

STATE OF TEXAS DEPARTMENT OF TRANSPORTATION

FUNCTIONAL CLASSIFICATION: URBAN PRINCIPAL ARTERIAL
 DESIGN SPEED = 45 MPH
 A.D.T. (2020) = 12,885 NB & 11,208 SB
 A.D.T. (2040) = 17,800 NB & 15,519 SB

STATE PROJECT NO.			
C 111-1-95			
CONT	SECT	JOB	HIGHWAY
0111	01	095	FM 521
DIST		COUNTY	SHEET NO.
HOU		HARRIS	1

PLANS OF PROPOSED STATE HIGHWAY IMPROVEMENT

STATE AID PROJECT NO. C 111-1-95

FM 521 HARRIS COUNTY


CSJ NO: 0111-01-095

NET LENGTH OF ROADWAY= 4547.74 FT. = 0.861 MI.

LIMITS: FROM 0.350 MI. N. OF IH 610 TO 0.106 MI. S. OF US 90A

FOR THE CONSTRUCTION OF MILLING, 1.5 IN HOT MIX ASPHALT OVERLAY, SEAL COAT, BASE REPAIR, TRAFFIC SIGNAL AND PAVEMENT MARKING


SEE SHEET 2 FOR INDEX OF SHEETS

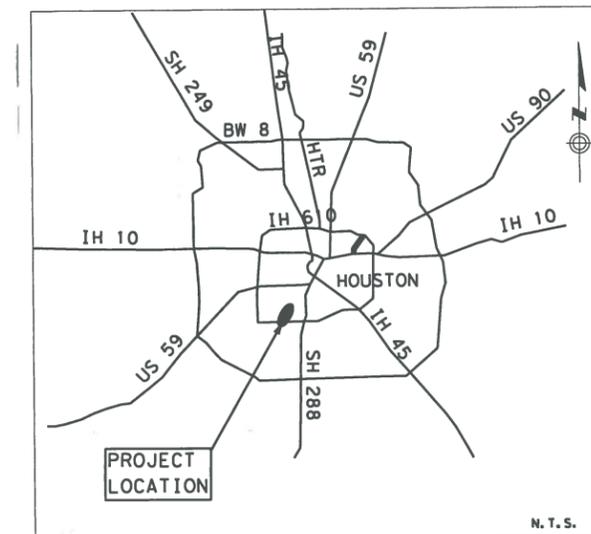

VICINITY MAP
SCALE: N.T.S

END PROJECT
 CSJ: 0111-01-095
 @ FM 521 STA: 171+06
 END RM: 734+0.228
 END MP: 13.238
 END D.F.O.: 98.130

BEGIN PROJECT
 CSJ: 0111-01-095
 @ FM 521 STA: 125+58.26
 BEGIN RM: 732+1.396
 BEGIN MP: 12.377
 BEGIN DFO: 97.269

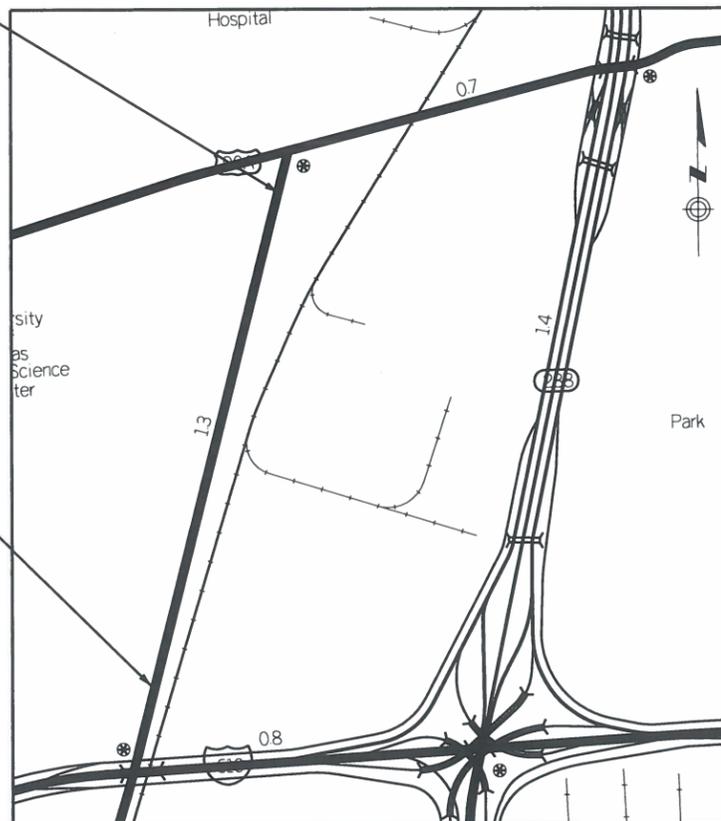

LOCATION MAP

 
SCALE: 1" = 1000'

EXCEPTIONS: NONE
 EQUATIONS: NONE
 RAILROAD CROSSINGS: NONE


SPECIFICATIONS ADOPTED BY THE TEXAS DEPARTMENT OF TRANSPORTATION NOV 1, 2014 AND THE SPECIFICATION ITEMS LISTED AND DATED AS FOLLOWS SHALL GOVERN ON THIS PROJECT: REQUIRED CONTRACT LABOR PROVISION FOR STATE PROJECTS SP000-008.


 Texas Department of Transportation
 © 2020 by Texas Department of Transportation
 all rights reserved

SUBMITTED FOR LETTING: 4/02/2020


 AREA ENGINEER

 RECOMMENDED FOR LETTING: 11/18/2020

DocuSigned by:

 LARRY W. BLACKBURN, P.E.
 FOR DISTRICT ENGINEER

INDEX OF SHEETS

GENERAL

1	TITLE SHEET
2	INDEX OF SHEETS
3	TYPICAL SECTIONS
4	IRI DATA
5, 5A--5H	GENERAL NOTES
6-6A	ESTIMATE & QUANTITY
7	SUMMARY OF WORKZONE, ROADWAY AND SWP3 QUANTITIES
8	SUMMARY OF PAVEMENT MARKING QUANTITIES
9	SUMMARY OF TRAFFIC SIGNAL QUANTITIES
10	SUMMARY OF SMALL SIGNS

TRAFFIC CONTROL PLAN

11	CONSTRUCTION NARRATIVE
11A	TRAFFIC CONTROL PLAN TYPICAL SECTIONS

TRAFFIC CONTROL PLAN STANDARDS

##	12-23	BC (1)-14 THRU BC (12)-14
##	24	TCP (1-4)-18 (MOD)
##	25	TCP (2-1)-18
##	26	TCP (2-4)-18 (MOD)
##	27	TCP (3-2)-13
##	28	TCP (3-3)-14
##	29	TCP(7-1)-13
##	30	WZ(BRK)-13
##	31	WZ(STPM)-13
##	32	WZ(UL)-13
##	33	WZ(BTS-1)-13
##	34	WZ(BTS-2)-13

ROADWAY DETAILS

35	HORIZONTAL ALIGNMENT DATA
36-40	ROADWAY LAYOUT
41	HOT MIX ASPHALT OVERLAY DETAILS (SHEET 1 OF 3)
42	HOT MIX ASPHALT OVERLAY DETAILS (SHEET 2 OF 3)
43	HOT MIX ASPHALT OVERLAY DETAILS (SHEET 3 OF 3)
44	FLEXIBLE PAVEMENT REPAIR DETAIL (NB SIDE)
45	MANHOLE ADJUSTMENT AND CAP DETAILS
46	TREATMENT FOR VARIOUS EDGE CONDITIONS

ROADWAY STANDARDS

##	47-48	CRCP(1)-20
##	49-50	CRCP(2)-20
##	51-52	REPCP-14
##	53-54	CRCP-HS (HOU DIST)
##	55	JS-14
##	56	CCCG-12

PAVEMENT MARKINGS

57-61	PAVEMENT MARKING LAYOUT
-------	-------------------------

PAVEMENT MARKINGS STANDARDS

##	62	PM(1)-20
##	63	PM(2)-20
##	64	PM(3)-20
##	65	PM(WAS)-07 (HOU DIST)
##	66	PM(DOT)-11 (HOU DIST)

SIGNING STANDARDS

##	67	SMD(GEN)-08
##	68	SMD (TWT)-08
##	69	TSR(4)-13

TRAFFIC SIGNAL

70	NOTES FOR PROPOSED LAYOUT AT HOLLY HALL INTERSECTION
71	EXISTING LAYOUT AT HOLLY HALL INTERSECTION
72	PROPOSED LAYOUT AT HOLLY HALL INTERSECTION(SHEET 1 OF 2)
73	PROPOSED LAYOUT AT HOLLY HALL INTERSECTION(SHEET 1 OF 2)

TRAFFIC SIGNAL STANDARD


##	74	LDD (HOU DIST)
##	75	LDDP (HOU DIST)
##	76	ED(1)-14
##	77	ED(3)-14
##	78	ED(4)-14

ENVIRONMENTAL

79-83	SWP3 LAYOUT
84	TXDOT STORMWATER POLLUTION PREVENTION PLAN SWP3 (HOU DIST)
85	ENVIRONMENTAL PERMITS, ISSUES AND COMMITMENTS EPIC

ENVIRONMENTAL ISSUES STANDARDS

##	86	ECL-12 (HOU DIST)
----	----	-------------------

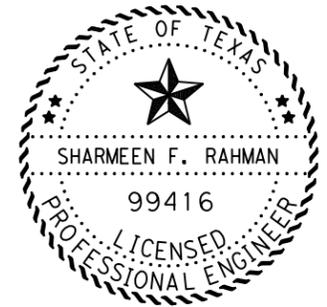

Sharmeen Rahman, P.E.

SHARMEEN F. RAHMAN, P.E. DATE

10/15/2020

THE STANDARD SHEETS SPECIFICALLY IDENTIFIED ABOVE (##) HAVE BEEN SELECTED BY ME, OR UNDER MY RESPONSIBLE SUPERVISION AS BEING APPLICABLE TO THIS PROJECT




FM 521

INDEX OF SHEETS



FED. RD. DIV. NO.	PROJECT NO.		SHEET NO.
6			2
STATE	DIST	COUNTY	
TEXAS	HOU	HARRIS	
CONT	SECT	JOB	HIGHWAY
0111	01	095	FM 521

10/6/2020 9:53:35 AM T:\HUM-AO\Des.ign\Roadway\FM 521\0111-01-095.DGN\GENERAL\002 INDEX OF SHEETS.dgn

10/7/2020 10:48:54 PM
 T:\HUM-AO\Desi.gn\Roadway\FM 521\0111-01-095.DGN\GENERAL\003 TYPICAL SECTION.dgn

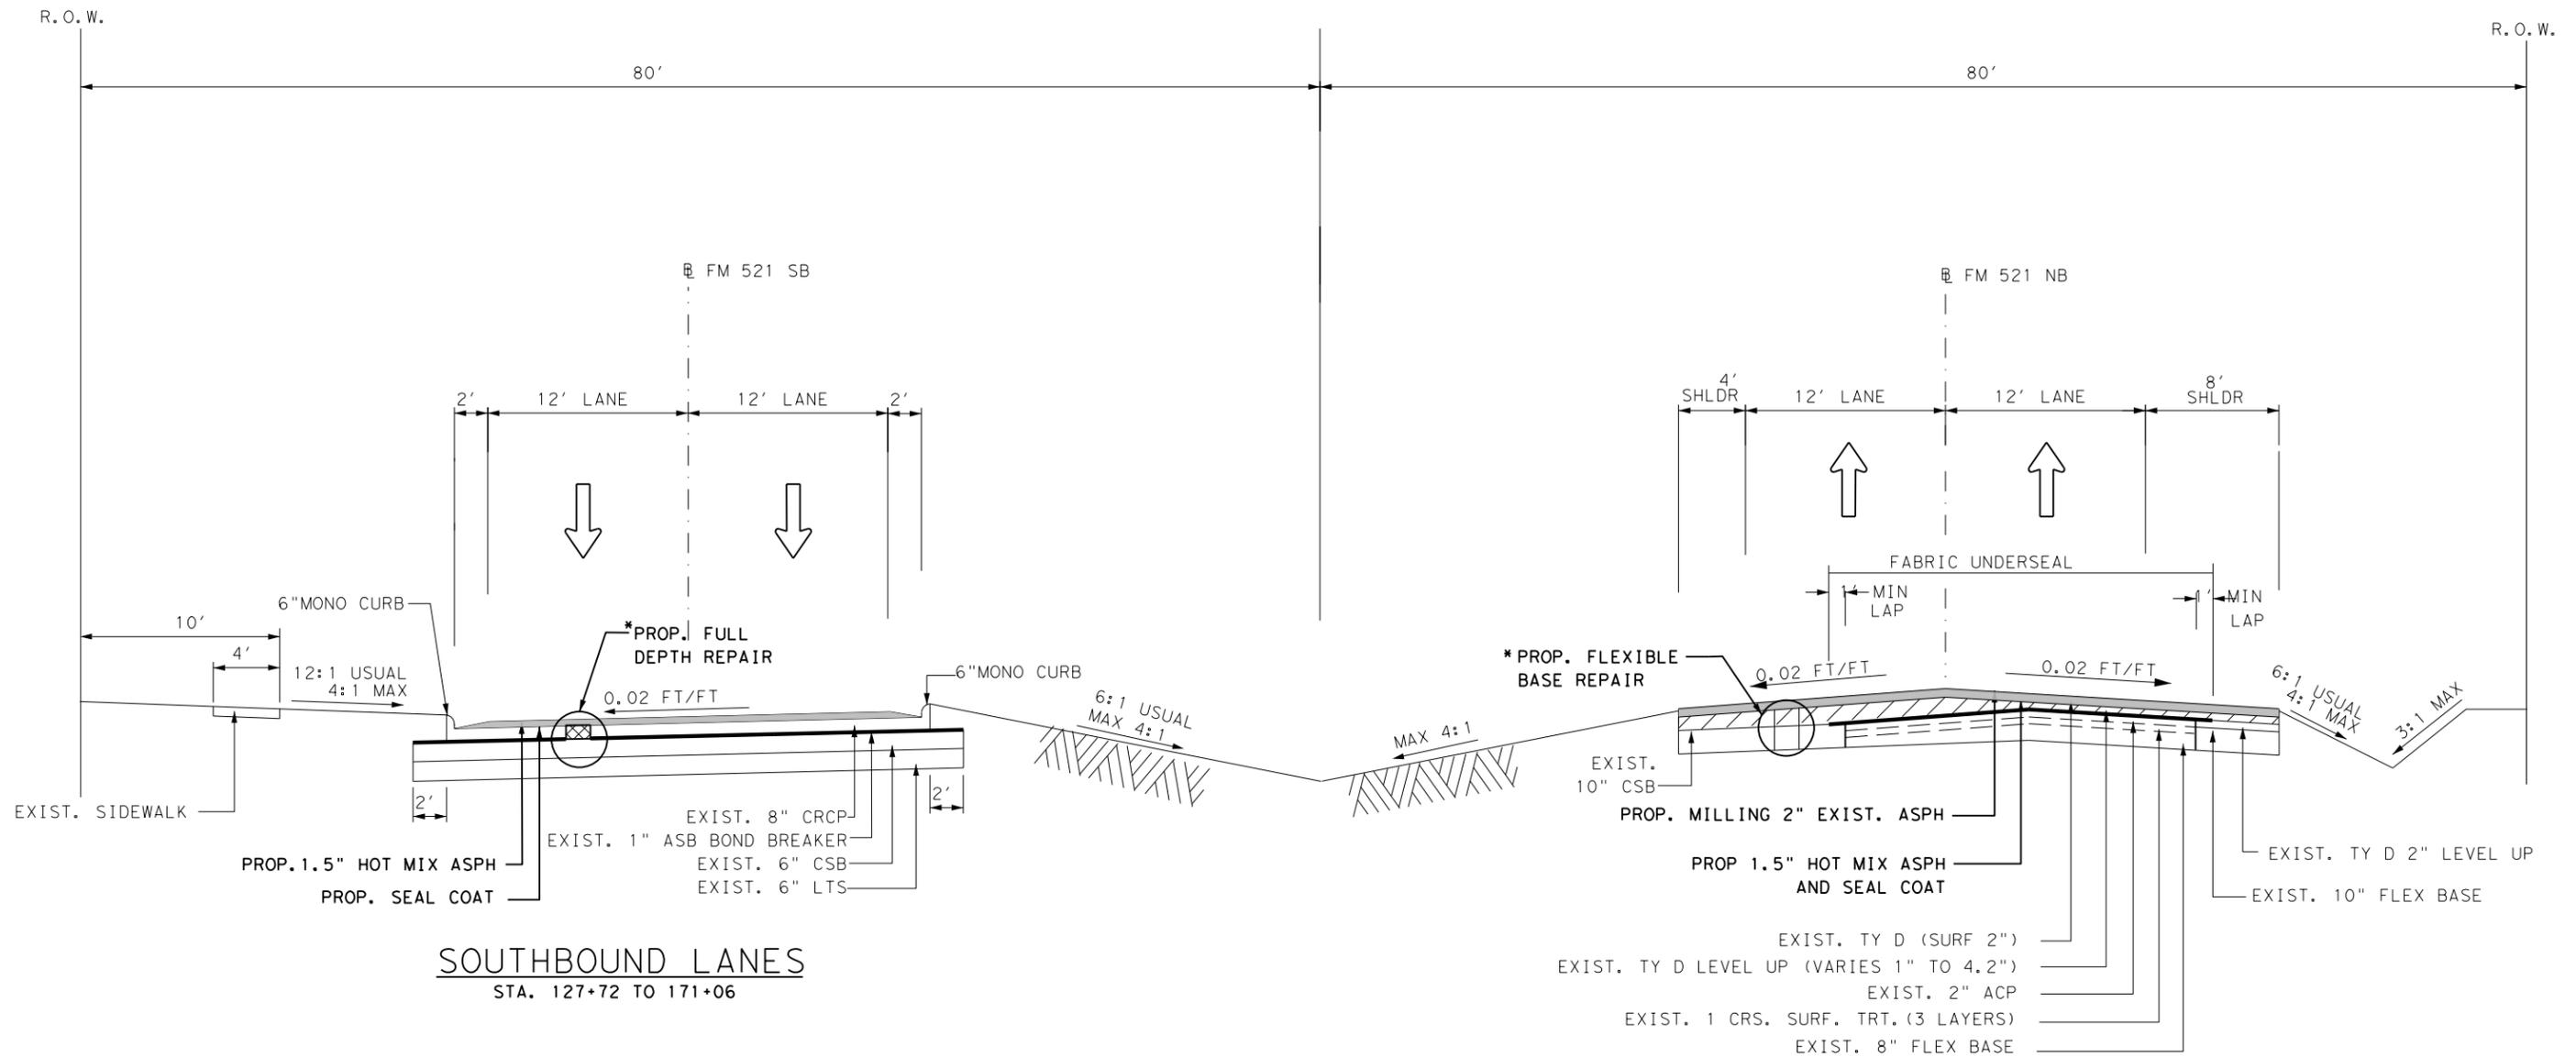

* THE LOCATION OF FULL DEPTH REPAIR AND FLEXIBLE BASE REPAIR WILL BE MARKED AND VERIFIED IN THE FIELD BY THE ENGINEER.

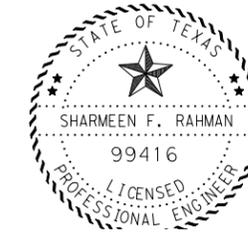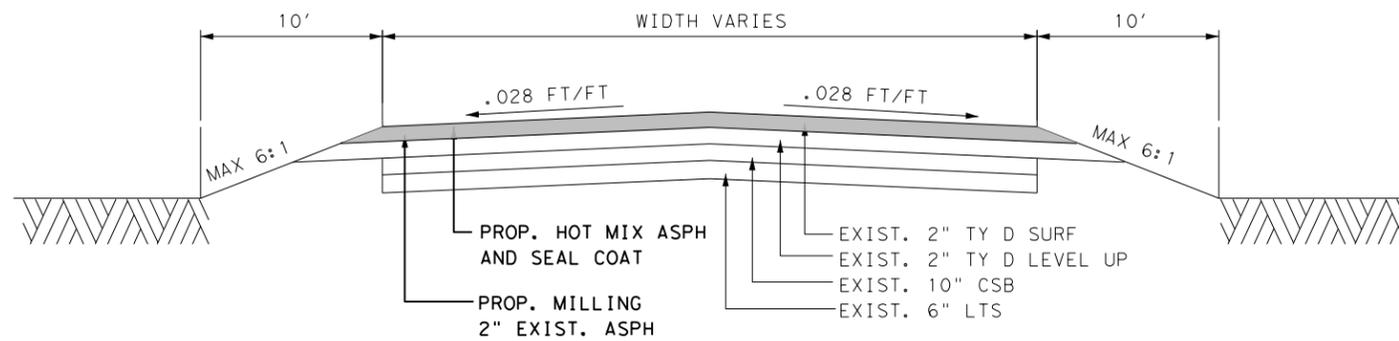

Sharmeen Rahman, P.E.

10/07/2020




FM 521
 TYPICAL SECTIONS

NOT TO SCALE

FED. RD. DIV. NO.	PROJECT NO.		SHEET NO.
6			3
STATE	DIST	COUNTY	
TEXAS	HOU	HARRIS	
CONT	SECT	JOB	HIGHWAY
0111	01	095	FM 521

9/22/2020 2:44:30 PM T:\HUM-AO\Des\ign\Roadway\FM 521\0111-01-095.DGN\GENERAL\004 IRI DATA.DGN

FY	MSEC	HIGHWAY	RDBD	REFERENCE MARKERS						IRI(N/MD)			COMMENTS			
				BEGIN		END		LEN	PType	MM/DD/YYYY	LEFT	RIGHT		SI		
2020	09	FM0521	L	0732	+	1.464	0732	+	1.564	0.1	05	10/7/2019	190	207	2.3	
2020	09	FM0521	L	0732	+	1.564	0732	+	1.664	0.1	05	10/7/2019	187	181	2.4	
2020	09	FM0521	L	0732	+	1.664	0732	+	1.764	0.1	05	10/7/2019	157	184	2.6	
2020	09	FM0521	L	0732	+	1.764	0732	+	1.864	0.1	05	10/7/2019	105	152	3.2	
2020	09	FM0521	L	0732	+	1.864	0732	+	1.964	0.1	05	10/7/2019	105	110	3.5	
2020	09	FM0521	L	0732	+	1.964	0734	+	0.034	0.1	05	10/7/2019	165	165	2.7	
2020	09	FM0521	L	0734	+	0.034	0734	+	0.134	0.1	05	10/7/2019	135	132	3.1	
2020	09	FM0521	L	0734	+	0.134	0734	+	0.234	0.1	05	10/7/2019	117	116	3.4	
2020	09	FM0521	L	0734	+	0.234	0734	+	0.334	0.1	05	10/7/2019	221	219	2.0	
2020	09	FM0521	R	0732	+	1.147	0732	+	1.247	0.1	05	10/8/2019	93	99	3.7	
2020	09	FM0521	R	0732	+	1.247	0732	+	1.347	0.1	05	10/8/2019	72	97	4.0	
2020	09	FM0521	R	0732	+	1.347	0732	+	1.447	0.1	05	10/8/2019	151	225	2.4	
2020	09	FM0521	R	0732	+	1.447	0732	+	1.547	0.1	05	10/8/2019	69	86	4.1	
2020	09	FM0521	R	0732	+	1.547	0732	+	1.647	0.1	05	10/8/2019	80	111	3.7	
2020	09	FM0521	R	0732	+	1.647	0732	+	1.747	0.1	05	10/8/2019	71	84	4.1	
2020	09	FM0521	R	0732	+	1.747	0732	+	1.847	0.1	05	10/8/2019	77	103	3.8	
2020	09	FM0521	R	0732	+	1.847	0732	+	1.947	0.1	05	10/8/2019	83	115	3.7	
2020	09	FM0521	R	0732	+	1.947	0734	+	0.017	0.1	05	10/8/2019	84	106	3.8	
2020	09	FM0521	R	0734	+	0.017	0734	+	0.117	0.1	05	10/8/2019	101	116	3.5	
2020	09	FM0521	R	0734	+	0.117	0734	+	0.217	0.1	05	10/8/2019	81	94	3.9	
2020	09	FM0521	R	0734	+	0.217	0734	+	0.317	0.1	05	10/8/2019	200	239	2.0	
2020	09	FM0521	R	0734	+	0.317	0734	+	0.334	0.1	05	10/8/2019	8	33	5.0	
2020	09	FM0521	R	0734	+	0.334	0734	+	0.344	0.1	05	10/8/2019	260	438	0.8	

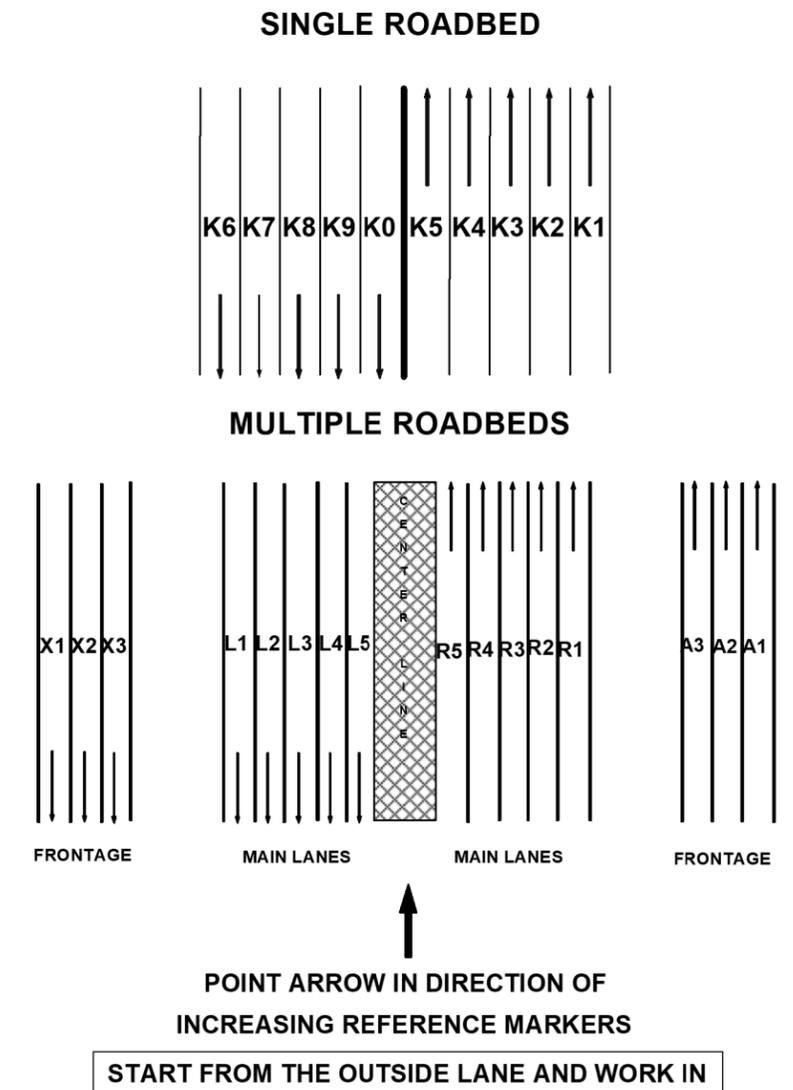

Pavement Types

Code	Description
01	Continuously Reinforced Concrete Pavement
02	Jointed Reinforced Concrete Pavement
03	Jointed Plain Concrete Pavement
04	Thick Asphaltic Concrete Pavement (greater than 5-1/2")
05	Intermediate Thickness Asphaltic Concrete Pavement (2-1/2" to 5-1/2")
06	Thin Surfaced Flexible Base Pavement (less than 2-1/2")
07	Asphalt Surfacing with Heavily Stabilized Base
08	Overlaid and/or Widened Old Concrete Pavement
09	Overlaid and/or Widened Old Flexible Pavement
10	Thin Surfaced Flexible Base Pavement (Surfaced Treatment-Seal Coat Combination)

FM 521

IRI DATA

FED. RD. DIV. NO.	PROJECT NO.	SHEET NO.	
6		4	
STATE	DIST	COUNTY	
TEXAS	HOU	HARRIS	
CONT	SECT	JOB	HIGHWAY
0111	01	095	FM 521

FOR CONTRACTOR'S INFORMATION ONLY

County: HARRIS

Highway: FM 521

General Notes:

General:

Contractor questions on this project are to be addressed to the following individual(s):

(John Elam email: John.Elam@Txdot.gov)

(Phillip Garlin email: Phillip.Garlin@Txdot.gov)

Contractor questions will be accepted through email, phone, and in person by the above individuals. Contractor questions will be reviewed by the Area Engineer or Assistant Area Engineer. Once a response is developed, it will be posted to TxDOT's Public FTP at the following address:

<https://ftp.dot.state.tx.us/pub/txdot-info/Pre-Letting%20Responses/>

Questions submitted that generate a response will be posted through this site. The site is organized by District, Project Type (Construction or Maintenance), Letting Date, and CCSJ/Project Name.

If fixed features require, the governing slopes shown may vary between the limits shown and to the extent determined by the Engineer.

Notify the Engineer immediately if discrepancies are discovered in the horizontal control or the benchmark data.

The following standard detail Sheets are modified:

Modified Standards

TCP(1-4)-18 TCP (1-4)-18 (MOD)

TCP (2-4)-18 TCP (2-4)-18 (MOD)

References to manufacturer's trade name or catalog numbers are for the purpose of identification only. Similar materials from other manufacturers are permitted if they are of equal quality, comply with the specifications for this project, and are approved, except for roadway illumination, electrical, and traffic signal items.

The cost for materials, labor, and incidentals to provide for traffic across the roadway and for ingress and egress to private property in accordance with Section 7.2.4 of the standard specifications is subsidiary to the various bid items. Restore access roadways to their original condition upon completing construction.

If a foundation is to be placed where a riprap surface or an asphalt concrete surface presently exists, use caution in breaking out the existing surface for placement. Break out no greater area than is required to place the foundation. After placing the foundation, wrap the periphery with

County: HARRIS

Highway: FM 521

Sheet 5

Control: 0111-01-095

0.5 in. pre-molded mastic expansion joint. Then replace the remaining portion of the broken out surface with Class A or Class C concrete or cold mix asphalt concrete to the exact slope, pattern, and thickness of the existing riprap or asphalt. Payment for breaking out the existing surface, wrapping the foundation, and replacing the surface is subsidiary to the various bid items.

Furnish aluminum Type A signs instead of plywood signs for signs shown on the Summary of Small Signs sheet.

Existing drainage flow lines and patterns should be maintained after pavement and repair work on roadways and intersections.

Procure permits and licenses, which are to be issued by the City, County, or Municipal Utility District.

General: Site Management

Mark stations every 100 ft. and maintain the markings for the project duration. Remove the station markings at the completion of the project. This work is subsidiary to the various bid items.

Do not mix or store materials, or store or repair equipment, on top of concrete pavement or bridge decks unless authorized by the Engineer. Permission will be granted to store materials on surfaces if no damage or discoloration will result.

Personal vehicles of employees are not permitted to park within the right of way, including sections closed to public traffic. Employees may park on the right of way at the Contractor's office, equipment, and materials storage yard sites.

Assume ownership of debris and dispose of at an approved location. Do not dispose of debris on private property unless approved in writing by the District Engineer.

Control the dust caused by construction operations. For sweeping the base material in preparation for laying asphalt and for sweeping the finished concrete pavement, use one of the following types of sweepers or approved equal:

Tricycle Type

Wayne Series 900
Elgin White Wing
Elgin Pelican

Truck Type - 4 Wheel

M-B Cruiser II
Wayne Model 945
Mobile TE-3
Mobile TE-4
Murphy 4042

General: Traffic Control and Construction

Perform Full depth concrete repair (Item 361) and Flexible pavement structure repair in advance of the asphalt overlay.

County: HARRIS

Highway: FM 521

Schedule construction operations such that preparing individual items of work follows in close sequence to constructing storm drains in order to provide as little inconvenience as practical to the businesses and residents along the project.

When design details are not shown on the plans, provide signs and arrows conforming to the latest "Standard Highway Sign Designs for Texas" manual.

In case of an emergency, the Engineer may allow traffic on the roadway before the asphalt overlay is in place. In that case, clean the roadway surface by removing loose matter resulting from the construction operations.

Verify that conditions under Item 502 are met before beginning work every day that work occurs.

General: Utilities

Consider the locations of underground utilities depicted in the plans as approximate and employ responsible care to avoid damaging utility facilities. Depending upon scope and magnitude of planned construction activities, advanced field confirmation by the utility owner or operator may be prudent. Where possible, protect and preserve permanent signs, markers, and designations of underground facilities.

If the Contractor damages or causes damage (breaks, leaks, nicks, dents, gouges, etc.) to the utility, contact the utility facility owner or operator immediately and it is at the contractor's own expense to repair any damages to the utility.

Be aware that an operational Computerized Transportation Management System (CTMS) exists within the limits of this project and that the system must remain operational throughout construction. If the Contractor damages or cause damage to this system, repair such damage within 8 hours of occurrence at no cost to the Department. In the event of system damage, notify the Director of Traffic Management Systems at 713-881-3063 within one hour of occurrence. Failure of the Contractor to repair damage to the main fiber optic cable and CCTV cable trunk lines, which convey all corridor information to TranStar, will result in the Contractor being billed for the full cost of emergency repairs.

At least 72 hours before starting work, make arrangements for locating existing Department-owned above ground and underground fiber optic, communications, power, illumination, and traffic signal cabling and conduit. Do this by calling the Department's Houston District Traffic Signal Operations Office at 713-802-5662 to schedule marking of underground lines on the ground. Use caution if working in these areas to avoid damaging or interfering with existing facilities.

Notify the Engineer at least 48 hours before constructing junction boxes at storm drain and utility intersections.

County: HARRIS

Highway: FM 521

Sheet 5A

Control: 0111-01-095

If overhead or underground power lines need to be de-energized, contact the electrical service provider to perform this work. Costs associated with de-energizing the power lines or other protective measures required are at no expense to the Department.

If working near power lines, comply with the appropriate sections of Texas State Law and Federal Regulations relating to the type of work involved.

Perform electrical work in conformance with the National Electrical Code (NEC) and Department's standard sheets.

Before beginning any underground work, notify the City of Houston's Chief Inspector, Public Works and Engineering, to establish the locations of any existing electrical systems for lighting facilities within the limits of this project.

Item 5: Control of Work

Submit shop drawings electronically for the fabrication of items as documented in Table 1 below. Information and requirements for electronic submittals can be viewed in the "Guide to Electronic Shop Drawing Submittal" which can be accessed through the following web link, ftp://ftp.dot.state.tx.us/pub/txdot-info/library/pubs/bus/bridge/e_submit_guide.pdf. References to 11 in. x 17 in. sheets in individual specifications for structural items imply electronic CAD sheets.

Table 1
2014 Construction Specification Required Shop/Working Drawing Submittals - TxDOT Generated Plans

Spec Item No.'s	Product	Submittal Required	Approval Required (Y/N)	Contractor/Fabricator P.E. Seal Required	Reviewing Party	Shop or Working Drawing (Note 1)
7.16.1&.2	Construction Load Analyses	Y	Y	Y	B	WD
400	Excavation and Backfill for Structures (cofferdams)	Y	N	Y	A	WD
403	Temporary Special Shoring	Y	N	Y	C	WD
420	Formwork/Falsework	Y	N	Y	A	WD
423	Retaining Walls, (calcs req'd.)	Y	Y	Y	C	SD
425	Optional Design Calculations (Prstrs Bms)	Y	Y	Y	B	SD
425	Prestr Concr Sheet Piling	Y	Y	N	B	SD
425	Prestr Concr Beams	Y	Y	N	B	SD
425	Prestr Concr Bent	Y	Y	N	B	SD
426	Post Tension Details	Y	Y	N	B	SD
434	Elastomeric Bearing Pads (All)	Y	Y	N	B	SD
441	Bridge Protective Assembly	Y	Y	N	B	SD
441	Misc Steel (various steel assemblies)	Y	Y	N	B	SD
441	Steel Pedestals (bridge raising)	Y	Y	N	B	SD
441	Steel Bearings	Y	Y	N	B	SD
441	Steel Bent	Y	Y	N	B	SD
441	Steel Diaphragms	Y	Y	N	B	SD
441	Steel Finger Joint	Y	Y	N	B	SD
441	Steel Plate Girder	Y	Y	N	B	SD

441	Steel Tub-Girders	Y	Y	N	B	SD
441	Erection Plans, including Falsework	Y	N	Y	A	WD
449	Sign Structure Anchor Bolts	Y	Y	N	T	SD
450	Railing	Y	Y	N	A	SD
462	Concrete Box Culvert	Y	Y	N	C	SD
462	Concrete Box Culvert (Alternate Designs Only, calcs req'd.)	Y	Y	Y	B	SD
464	Reinforced Concrete Pipe (Jack and Bore only; ONLY when requested)	Y	Y	Y	A	SD
465	Pre-cast Junction Boxes, Grates, and Inlets	Y	Y	N	A	SD
465	Pre-cast Junction Boxes, Grates, and Inlets (Alternate Designs Only, calcs req'd.)	Y	Y	Y	B	SD
466	Pre-cast Headwalls and Wingwalls	Y	Y	N	A	SD
467	Pre-cast Safety End Treatments	Y	Y	N	A	SD
495	Raising Existing Structure (calcs req'd.)	Y	Y	Y	B	SD
610	Roadway Illumination Supports (Non-Standard only, calcs req'd.)	Y	Y	Y	BRG	SD
613	High Mast Illumination Poles (Non-standard only, calcs req'd.)	Y	Y	Y	BRG	SD
627	Treated Timber Poles	Y	Y	N	T	SD
644	Special Non-Standard Supports (Bridge Mounts, Barrier Mounts, Etc.)	Y	Y	Y	T	SD
647	Large Roadside Sign Supports	Y	Y	Y	T	SD
650	Cantilever Sign Structure Supports - Alternate Design Calcs.	Y	Y	Y	T	SD
650	Sign Structures	Y	Y	N	T	SD
680	Installation of Highway Traffic Signals	Y	Y	N	T	SD
682	Vehicle and Pedestrian Signal Heads	Y	Y	N	T	SD
684	Traffic Signal Cables	Y	Y	N	T	SD
685	Roadside Flashing Beacon Assemblies	Y	Y	N	T	SD
686	Traffic Signal Pole Assemblies (Steel) (Non-Standard only)	Y	Y	Y	T	SD
687	Pedestal Pole Assemblies	Y	Y	N	T	SD
688	Detectors	Y	Y	N	A	SD
784	Repairing Steel Bridge Members	Y	Y	Y	B	WD
SS	Prestr Concr Crown Span	Y	Y	N	B	SD
SS	Sound Barrier Walls	Y	Y	Y	A	SD
SS	Camera Poles	Y	Y	Y	TMS	SD
SS	Pedestrian Bridge (Calcs req'd.)	Y	Y	Y	B	SD
SS	Screw-In Type Anchor Foundations	Y	Y	N	T	SD
SS	Fiber Optic/Communication Cable	Y	Y	N	TMS	SD
SS	Spread Spectrum Radios for Signals	Y	Y	N	T	SD
SS	VVDS System for Signals	Y	Y	N	T	SD
SS	CTMS Equipment	Y	Y	N	TMS	SD

Notes:

1. Document flow for Working Drawings differs from Shop Drawings in that Working Drawings must be submitted to the Engineer rather than the Engineer of Record and they are for the information of the Engineer only; an approval stamp and distribution to all project offices is not required.

Key to Reviewing Party

A - Area Office	
Area Office	Email Address
North Harris Area Office	HOU-NHAShpDrwgs@txdot.gov
Traffic Systems Construction Office	HOU-TSCShpDrwgs@txdot.gov
West/Central Harris Area Office	HOU-WWCHAOShpDrwgs@txdot.gov
B - Houston Bridge Engineer	
Bridge Design (Houston TxDOT)	HOU-BrgShpDrwgs@txdot.gov
BRG - Austin Bridge Division	
Bridge Design (Austin TxDOT)	BRG_ShopPlanReview@txdot.gov
C - Construction Office	
Construction	HOU-ConstrShpDrwgs@txdot.gov
Laboratory	HOU-LabShpDrwgs@txdot.gov
T - Traffic Engineer	
Traffic Operations	HOU-TrfShpDrwgs@txdot.gov
TMS - Traffic Management System	
Computerized Traffic Management Systems (CTMS)	HOU-CTMSShpDrwgs@txdot.gov

Item 7: Legal Relations and Responsibilities

This project does not require a U.S. Army Corps of Engineers (USACE) Section 404 Permit before letting, but if a permit is needed during construction, assume responsibility for preparing the permit application. Submit the permit application to the Department's District Environmental Section for approval. Once the permit application is approved, the Department will submit it to the USACE. Assume responsibility for the requested revisions, in coordination with the Department's District Environmental Section.

No significant traffic generator events have been identified.

Item 8: Prosecution and Progress

The Department will not adjust the number of days for the project and milestones, if any, due to differences in opinion regarding any assumptions made in the preparation of the schedule or for errors, omissions, or discrepancies found in the time determination schedule.

Working days will be computed and charged as shown below in accordance with Section 8.3.1.6.

- Monday 9:00 PM – Tuesday 5:00 AM
- Tuesday 9:00 PM – Wednesday 5:00 AM
- Wednesday 9:00 PM – Thursday 5:00 AM
- Thursday 9:00 PM – Friday 5:00 AM
- Friday 9:00 PM – Saturday 5:00 AM
- Saturday 5:00 AM - Sunday 5:00 AM
- Sunday 5:00 AM – Monday 5:00 AM

County: HARRIS

Highway: FM 521

A working day will be charged Monday through Friday, if weather or other conditions permit the performance of the principal unit of work underway, as determined by the Engineer, for a continuous period of at least 7 hours between 9 pm. to 5 am excluding national holidays or state holidays. For each 24-hour time period (Saturday and Sunday) only one day will be charged.

Nighttime work that extends past midnight will be assigned to the following day. Work on national holidays will not be permitted without written permission of the Engineer. If work requiring an inspector to be present is performed on a national or state holiday, and weather and other conditions permit the performance of work for 7 hours, a working day will be charged.

The Lane Closure Assessment Fee is \$300.00 for NB and SB lanes. This fee applies to the Contractor for closures or obstructions that overlap into restricted hour traffic for each hour or portion thereof, per lane, regardless of the length of lane closure or obstruction. For Restricted Hours subject to Lane Assessment Fee refer to the Item, "Barricades, Signs, and Traffic Handling."

Item 104: Removing Concrete

Removing concrete curb is paid as a separate bid item if the existing pavement on which it rests is not removed at the same time.

Item 204: Sprinkling

Perform subsidiary sprinkling as required under various other items in accordance with the Item, "Sprinkling."

Sprinkling for dust control is subsidiary to the various bid items.

Item 210: Rolling

Use a medium pneumatic roller meeting the requirements of Item 210 as directed. This work is subsidiary to the various bid items. On every asphalt shot, use a minimum of 3 pneumatic rollers or as directed. Use approved rolling patterns. Successive asphalt shots will not be allowed until acceptable rolling has been accomplished on the preceding asphalt shot.

Item 292: Asphalt Treatment (Plant-Mixed)

If using the iron ore topsoil as the primary aggregate, meaning 80 percent or more by weight of the total mixture, the requirements for the water susceptibility test are waived.

Mixtures containing the iron ore topsoil are exempted from test methods TEX-217-F (Part I, separation of deleterious material and Part II, decantation test for coarse aggregate) and TEX-203-F (Sand Equivalent Test).

Assume responsibility for proportioning the materials entering the asphalt mixture, regardless of the type of plant used.

Furnish the mix designs for approval.

County: HARRIS

Highway: FM 521

Sheet 5C

Control: 0111-01-095

Item 316: Seal Coat

The asphalt application rate shown on the "Basis of Estimate" is an average rate for calculating asphalt quantities. Vary the rate based on the pavement conditions and other factors such as the type and grade of aggregate used, weather, and traffic.

Item 351: Flexible Pavement Structure Repair

Use asphalt stabilized base for the base material.

For base repair, place the asphalt stabilized base in compacted lifts of 4 in. maximum, unless otherwise directed.

Item 361: Repair of Concrete Pavement

For full depth repair, remove only the quantity of pavement replaceable during the daily allowable work schedule.

Remove loose sub-base material and replace it with concrete. Use a bondbreaker, such as a polyethylene sheet, at the interface between the replaced sub-base material and the new concrete pavement.

Supply polyethylene fabric on the job site sufficient to cover the area of repair.

Do not place concrete placement if impending weather may result in rainfall or low temperatures that may impair the quality of the finished work.

Repair portions of the concrete pavement surfaces that are damaged while in a plastic state before those areas receive permanent pavement markings and open to traffic. Perform repairs that are structurally equivalent to and cosmetically uniform with adjacent undamaged areas. Do not repair by grouting onto the surface.

Ready mix concrete will be permitted if the equipment and construction methods can produce the desired results. Hand finishing will be permitted.

Perform saw cutting as shown on the plans in accordance with Section 360.4.10, "Sawing Joints." This saw cutting is subsidiary to this bid Item.

Items 420 and 421: All Concrete Items

For the Department's concrete cylinder split samples, transport the test cylinders to the Houston District Laboratory located at 7600 Washington Avenue in Houston, or to the appropriate Area Laboratory, when applicable. Transporting the test cylinders is subsidiary to the various bid items.

Item 479: Adjusting Manholes and Inlets

Manholes must be adjusted within three (3) days of ACP overlay.

Use prefabricated metal extension rings for this project.

County: HARRIS

Highway: FM 521

Locate all manholes and determine the size and height of each manhole riser ring in order to provide a matching height for the new pavement surface.

Removal and disposal of any existing rings is subsidiary to this item.

Item 502: Barricades, Signs, and Traffic Handling

Use a traffic control plan for handling traffic through the various phases of construction. Follow the phasing sequence unless otherwise agreed upon by the Area Engineer and the Project Manager. Ensure this plan conforms to the latest "Texas Manual on Uniform Traffic Control Devices" and the latest Barricade and Construction (BC) Standard Sheets.

Submit changes to the traffic control plan to the Area Engineer. Provide a layout showing the construction phasing, signs, striping, and signalizations for changes to the original traffic control plan.

Furnish and maintain the barricades and warning signs, including the necessary temporary and portable traffic control devices, during the various phases of construction. Place and construct these barricades and warning signs in accordance with the latest "Texas Manual on Uniform Traffic Control Devices" for typical construction layouts.

Cover work zone signs when work related to the signs is not in progress, or when any hazard related to the signs no longer exists.

Keep the delineation devices, signs, and pavement markings clean. This work is subsidiary to the Item, "Barricades, Signs, and Traffic Handling."

Erect temporary signs when exit ramps are closed or moved to new locations during construction.

Cover or remove the permanent signs and construction signs that are incorrect or that do not apply to the current situation for a particular phase.

Replace the overhead signs, informational signs, and exit signs to be removed, with temporary signs providing the correct information to the traveling public. Size the replacement signs and include them in the traffic control plan.

Do not mount signs on drums or barricades, except those listed in the latest Barricades and Construction standard sheets.

Use traffic cones for daytime work only. Replace the cones with plastic drums during nighttime hours.

County: HARRIS

Highway: FM 521

Sheet 5D

Control: 0111-01-095

Do not reduce the existing number of lanes open to traffic except as shown on the following time schedule:

One Lane Closures (FM 521, *Intersecting Streets)

Day	Daytime Closure Hours	Nighttime Closure Hours	Restricted Hours Subject to Lane Assessment Fee
Mondays to Fridays	N/A	9:00 PM - 11:59 PM 12:00 AM - 5:00 AM	5:00 AM TO 9:00 PM
Saturday	5:00 AM - 5:00 PM	5:00 PM - 5:00 AM	N/A
Sunday	5:00 AM - 5:00 PM	5:00 PM - 5:00 AM	N/A

*One lane closure times listed are for intersecting streets that have two or more lanes in one direction open to traffic prior to closure.

The above times are approved for the traffic control conditions listed. The Area Engineer may approve other closure times if traffic counts warrant. The Area Engineer may reduce the above times for special events.

Law enforcement assistance will be required for this project and is expected to be required for major traffic control changes and lane closures. Coordinate with local law enforcement and arrange for law enforcement as directed or agreed by the Engineer. Before payment will be made, complete the "Daily Report on Law Enforcement Force Account Work" (Form 318), provided by the Department and submit daily invoices that agree with this form for any day during the month in which approved services were provided.

Provide full-time, off-duty, uniformed, certified peace officers, as part of traffic control operations. The peace officers must be able to show proof of certification by the Texas Commission on Law Enforcement Officers Standards. The cost of the officers is paid for on a force account basis.

A minimum of 7 days in advance of any total closure, notify the Houston District Public Information Office of which roadways, ramps, intersections, or lanes will be closed, the dates they will remain closed, and when they will be opened again to traffic.

A minimum of 7 days in advance of any total closure, place a portable changeable message (PCM) sign at the location of each total closure which informs the traveling public of the details of the closure. Alternately, if the Traffic Control Plan provides a positive barrier at the location, a non-trailer mounted static message board sign behind the positive barrier may be used in place of a PCM.

Before closing any City of Houston sidewalk, one or more city street lanes, or entire city streets during construction, obtain a permit to do so from the City. Obtain the required permit in person at the City of Houston Permit Office, or apply online at <http://www.gims.houstontx.gov>.

County: HARRIS

Highway: FM 521

The Contractor Force Account "Safety Contingency" that has been established for this project is intended to be utilized for work zone enhancements, to improve the effectiveness of the Traffic Control Plan, that could not be foreseen in the project planning and design stage. These enhancements will be mutually agreed upon by the Engineer and the Contractor's Responsible Person based on weekly or more frequent traffic management reviews on the project. The Engineer may choose to use existing bid items if it does not slow the implementation of enhancement.

Item 506: Temporary Erosion, Sedimentation and Environmental Controls

The use of hay bales is not permitted as Storm Water Pollution Prevention Plan (SWP3) measures.

The Storm Water Pollution Prevention Plan (SWP3) consists of temporary erosion control measures needed and provided for under this Item. The disturbed area is less than one acre and use of erosion control measures is not anticipated. If physical conditions encountered at the job site require necessary controls, BMP installation, maintenance, and removal will be paid as extra work on a force account basis per Articles 4.4 and 9.7. Since the disturbed area is less than 5 acres, a "Notice of Intent" (NOI) is not required.

Use appropriate measures to prevent, minimize, and control the spill of hazardous materials in the construction staging area. Remove and dispose of materials in compliance with State and Federal laws.

Before starting construction, review with the Engineer the SWP3 used for temporary erosion control as outlined on the plans. Before construction, place the temporary erosion and sedimentation control features as shown on the SWP3.

Implement temporary and permanent erosion control measures to comply with the National Pollution Discharge Elimination System (NPDES) general permit under the Clean Water Act.

Before starting grading operations and during the project duration, place the temporary or permanent erosion control measures to prevent sediment from leaving the right of way.

Item 529: Concrete Curb, Gutter, and Combined Curb and Gutter

An air-entraining admixture is not required.

For concrete curbs, use Grade 7 aggregate conforming to Section 421.2.6 of the Item, "Hydraulic Cement Concrete."

Item 585: Ride Quality for Pavement Surfaces

To eliminate the need for corrective action due to excessive deviations in the final surface layers, exercise caution to ensure satisfactory profile results in the intermediate paving layers (mixture).

Milling will not be allowed as a corrective action for excessive deviations in the final surface layer of hot-mix asphalt.

County: HARRIS

Highway: FM 521

Sheet 5E

Control: 0111-01-095

Use Surface Test Type B and Pay Adjustment Schedule 2 for FM 521 northbound and Schedule 3 for FM 521 southbound.

Item 618: Conduit

When backfilling bore pits, ensure that the conduit is not damaged during installation or due to settling backfill material. Compact select backfill in 3 equal lifts to the bottom of the conduit; or if using sand, place it 2 in. above the conduit. Ensure backfill density is equal to that of the existing soil. Prevent material from entering the conduit.

Construct bore pits a minimum of 5 ft. from the edge of the base or pavement. Close the bore pit holes overnight.

Unless otherwise shown on the plans, install underground conduit a minimum of 24 in. deep. Install the conduit in accordance with the latest National Electrical Code (NEC) and applicable Department standard sheets. Place conduit under driveways or roadways a minimum of 24 in. below the pavement surface.

If using casing to place bored conduit, the casing is subsidiary to the conduit.

Where PVC, duct cable, and HDPE conduit 1 in. and larger is allowed and installed per Department standards, provide a PVC elbow in place of the galvanized rigid metal elbow required by the Electrical Details standards. Ensure the PVC elbow is of the same schedule rating as the conduit to which it is connected. Use only a flat, high tensile strength polyester fiber pull tape to pull conductors through the PVC conduit system.

Remove conductor and conduit to be abandoned to 1 ft. below the ground level. This work is subsidiary to the various bid items.

Do not use cast iron junction boxes in concrete traffic barriers and single slope traffic barriers. Use polymer concrete junction boxes in place of the cast iron junction boxes shown on standard sheets CTBI (3), CTBI (4), and SSCB (4). Mount the junction boxes flush (+ 0 in., - 1/2 in.) with the concrete surface of the concrete barrier.

Use materials from pre-qualified producers as shown on the Department's Construction Division (CST) material producers list. Check the latest links on the TxDOT website for the list. The category is "Roadway Illumination and Electrical Supplies." The polymer concrete barrier box is subsidiary to Item 618, "Conduit."

Item 620: Electrical Conductors

Test each wire of each cable or conductor after installation. Incomplete circuits or damage to the wire or the cable are cause for immediate rejection of the entire cable being tested. Remove and replace the entire cable at no expense to the Department. Also test the replacement cable after installation.

County: HARRIS

Highway: FM 521

When pulling cables or conductors through the conduit, do not exceed the manufacturer's recommended pulling tensions. Lubricate the cables or conductors with a lubricant recommended by the cable manufacturer.

When pulling cables or conductors through the conduit, do not exceed the manufacturer's recommended pulling tensions. Lubricate the cables or conductors with a lubricant recommended by the cable manufacturer.

Ensure that circuits test clear of faults, grounds, and open circuits.

Split bolt connectors are allowed only for splices on the grounding conductors.

For electrical licensing and electrical certification requirements for this project, see Item 7 of the Standard Specifications and any applicable special provisions to Item 7.

Item 624: Ground Boxes

The ground box locations are approximate. Alternate ground box locations may be used as directed, to avoid placing in sidewalks or driveways.

Ground metal ground box covers. Bond the ground box cover and ground conductors to a ground rod located in the ground box and to the system ground.

Ground the existing metal ground box covers as shown on the latest standard sheet ED (4)-14.

During construction and until project completion, provide personnel and equipment necessary to remove ground box lids for inspection. Provide this assistance within 24 hours of notification.

Construct concrete aprons in accordance with the latest standard sheet ED (4)-14. Make the depth of the concrete apron the same as the depth of the ground box, except for Type 1 and Type 2 ground boxes. For Type 1 or Type 2 ground boxes, construct the concrete apron in accordance with details shown on the "Ground Box Details Installations" standard.

Item 644: Small Roadside Sign Assemblies

Sign locations shown on the plans are approximate. Before placing them, obtain approval of and then stake the exact locations for these signs.

Use the Texas Universal Triangular Slip Base with the concrete foundation for small ground mounted signs, unless otherwise shown in the plans.

Remove existing street name signs from existing stop signs and re-install them above the new stop signs. Removing and re-installing existing street name signs is subsidiary to the Item, "Small Roadside Sign Assemblies."

When design details are not shown on the plans, provide signs and arrows conforming to the latest "Standard Highway Sign Designs for Texas" manual.

County: HARRIS

Highway: FM 521

Assume ownership of the removed existing signs.

Replace existing signs that become damaged during relocation at no expense to the Department.

Item 662: Work Zone Pavement Markings

At the end of each workday, mark roadways that remain open to traffic during construction operations with standard pavement markings, in accordance with the latest "Texas Manual on Uniform Traffic Control Devices."

Using raised markers for removable work zone pavement markings on final concrete surfaces is optional.

Do not use raised pavement markers as optional work zone pavement markings on final asphalt surfaces.

For transition lane lines and detour lane lines, use raised pavement markers as shown for solid lines on the latest Barricade and Construction standard sheet for "Work Zone Pavement Marking Details."

Item 662: Work Zone Pavement Markings

Item 666: Reflectorized Pavement Markings

Item 6038: Multipolymer Pavement Markings (MPM)

Use Type III glass beads for thermoplastic and multipolymer pavement markings.

Use a 0.100 in. (100 mil) thickness for thermoplastic pavement markings, measured to the top of the thermoplastic, not including the exposed glass beads.

Use a 0.022 in. (22 mil) thickness for multipolymer pavement markings, measured to the top of the multipolymer, not including the exposed glass beads.

For roadways with asphalt surfaces to be striped with work zone or permanent thermoplastic markings, the Contractor has the option to apply paint and beads markings for a maximum 30-day period until placing the thermoplastic markings, or until starting the succeeding phase of work on the striped area. Maintain the paint and beads markings, at no expense to the Department until placing the thermoplastic markings or starting the succeeding phase of work on the striped area. The work zone markings, whether paint and beads or thermoplastic, are paid under the Item, "Work Zone Pavement Markings" and the markings are paid for only once for the given phase of construction.

If using paint and bead markings as described above, purchase the traffic paint from the open market.

If the Type II markings become dirty and require cleaning by washing, brushing, compressed air, or other approved methods before applying the Type I thermoplastic markings, this additional cleaning is subsidiary to the Item, "Reflectorized Pavement Markings."

Establish the alignment and layout for work zone striping and permanent striping.

Sheet 5F

Control: 0111-01-095

County: HARRIS

Highway: FM 521

Stripe all roadways before opening them to traffic.

Place pavement markings under these items in accordance with details shown on the plans, the latest "Texas Manual on Uniform Traffic Control Devices," or as directed.

When design details are not shown on the plans, provide pavement markings for arrows, words, and symbols conforming to the latest "Standard Highway Sign Designs for Texas" manual.

Place the pedestrian crosswalk pavement markings only after the pedestrian signals and push buttons are installed and operating.

Item 672: Raised Pavement Markers

If other operations are complete on the project and if the curing time period is not yet elapsed, the contract time will be suspended until the curing is done.

Before placing the raised pavement markers on concrete pavement, blast clean the surface using an abrasive-blasting medium. This work is subsidiary to the Item, "Raised Pavement Markers."

Provide epoxy adhesive that is machine-mixed or nozzle-mixed and dispensed. Equip the machine or nozzle with a mechanism to ensure positive mix measurement control.

Item 677: Eliminating Existing Pavement Markings and Markers

Remove existing pavement markings on concrete or asphalt surfaces by flail milling or as directed.

Item 678: Pavement Surface Preparation for Markings

Do not blast clean asphalt concrete pavement. Clean asphalt concrete pavement as required under the applicable specifications or as directed.

On new concrete pavement or on existing concrete pavement when placing a new stripe on a new location, remove the curing compounds and contamination from the pavement surface by flail milling or as directed. In addition, air-blast the surface with compressed air just before placing the new stripe.

On existing concrete pavement when placing a new stripe on an existing location, after removing the existing stripe under the Item, "Eliminating Existing Pavement Markings and Markers," air-blast the surface with compressed air just before placing the new stripe.

Do not clean concrete pavement by grinding.

Item 688: Pedestrian Detectors and Vehicle Loop Detectors

Provide a black tube loop detector wire as specified in the "International Municipal Signal Association, Inc." (IMSA) Specification No. 51-7, 1997.

County: HARRIS

Highway: FM 521

Sheet 5G

Control: 0111-01-095

If the loop sealant supplied by the Contractor is not on the Department's pre-qualified product list, before applying the sealant provide a 5-gal. container of loop sealant for testing.

Item 3076: Dense-Graded Hot Mix Asphalt

Taper the asphalt concrete pavement at the beginning and ending points.

Use a maximum 6H:1V slope for the asphalt concrete pavement edge.

Where the 6H:1V ACP edge taper extends over onto the unsurfaced shoulders, blade off the loose existing shoulder material to provide a solid base for the outside taper edge. After placing the ACP overlay, blade this material back against the edge taper. This work is subsidiary to the various bid items.

The stockpile will be the point of sampling of coarse aggregate for test method TEX-217-F (Part II, decantation).

Place the asphalt concrete pavement in courses as shown on the typical sections.

Do not use petroleum-based solvents in the beds of hot mix asphalt delivery vehicles.

Dilution of tack coat is not allowed.

Do not use Surface Aggregate Classification (SAC) C for this project.

For determining the Asphalt Content, only ignition ovens will be allowed.

Item 6185: Truck Mounted Attenuator (TMA) and Trailer Attenuator (TA)

A shadow vehicle with Truck Mounted Attenuators (TMAs) or Trailer Attenuators (TAs) is required as shown on the appropriate Traffic Control Plan (TCP) sheets. TMAs/TAs must meet the requirements of the Compliant Work Zone Traffic Control Device List.

Level 3 Compliant TMAs/TAs are required for this project.

A total of one (1) shadow vehicle with a TMA/TA is required for the work with the exception of Pavement Marking Operations. The Contractor is responsible for determining if one or more of these operations will be ongoing at the same time to determine the total number of TMAs/TAs needed on the project.

A total of three (3) shadow vehicles with a TMA/TA are required for Pavement Marking Operations. The Contractor is responsible for determining if one or more of these operations will be ongoing at the same time to determine the total number of TMAs/TAs needed on the project.

County: HARRIS

Highway: FM 521

Shett 5H

Control: 0111-01-095

Basis of Estimate

Item	Description	Limit and Rate	Unit
316	Seal Coat <ul style="list-style-type: none">AsphaltAggregate (GR 4)	0.32 Gal / Sq.Yd. 1/130 Cu.Yd./Sq.Yd	GAL CY
292	Asphalt Treatment (Plant-Mixed) <ul style="list-style-type: none">AsphaltAggregate	110 Lb. / Sq. Yd.-In. 5 % by weight 95 % by weight	TON
3076	<ul style="list-style-type: none">Dense-Graded Hot Mix Asphalt (Small Quantity)AsphaltAggregate	110 Lb. / Sq. Yd.-In. 6 % by weight 94 % by weight	TON



CONTROLLING PROJECT ID 0111-01-095

DISTRICT Houston
HIGHWAY FM 521

COUNTY Harris

QUANTITY SHEET

CONTROL SECTION JOB				0111-01-095		TOTAL EST.	TOTAL FINAL
PROJECT ID				A00123562			
COUNTY				Harris			
HIGHWAY				FM 521			
ALT	BID CODE	DESCRIPTION	UNIT	EST.	FINAL		
	316-6017	ASPH (AC-20-5TR)	GAL	11,108.000		11,108.000	
	316-6434	AGGR (TY-PB GR-4 OR TY-PL GR-4 (SAC-B)	CY	260.000		260.000	
	351-6049	FLEX PAVEMNT STRUCTURE REPAIR (10"-16")	SY	100.000		100.000	
	354-6021	PLANE ASPH CONC PAV(0" TO 2")	SY	1,954.000		1,954.000	
	354-6035	PLANE CONC PAV(0" TO 1")	SY	1,210.000		1,210.000	
	354-6045	PLANE ASPH CONC PAV (2")	SY	17,986.000		17,986.000	
	361-6002	FULL - DEPTH REPAIR CRCP (8")	SY	2,322.000		2,322.000	
	479-6001	ADJUSTING MANHOLES	EA	3.000		3.000	
	500-6001	MOBILIZATION	LS	100.00%		100.00%	
	502-6001	BARRICADES, SIGNS AND TRAFFIC HANDLING	MO	4.000		4.000	
	506-6040	BIODEG EROSN CONT LOGS (IN STL) (8")	LF	177.000		177.000	
	506-6043	BIODEG EROSN CONT LOGS (REMOVE)	LF	177.000		177.000	
	529-6005	CONC CURB (MONO) (TY II)	LF	60.000		60.000	
	618-6046	CONDT (PVC) (SCH 80) (2")	LF	850.000		850.000	
	618-6047	CONDT (PVC) (SCH 80) (2") (BORE)	LF	345.000		345.000	
	618-6053	CONDT (PVC) (SCH 80) (3")	LF	70.000		70.000	
	618-6054	CONDT (PVC) (SCH 80) (3") (BORE)	LF	145.000		145.000	
	620-6009	ELEC CONDR (NO.6) BARE	LF	1,400.000		1,400.000	
	624-6010	GROUND BOX TY D (162922)W/APRON	EA	16.000		16.000	
	644-6001	IN SM RD SN SUP&AM TY10BWG(1)SA(P)	EA	1.000		1.000	
	662-6001	WK ZN PAV MRK NON-REMOV (W)4"(BRK)	LF	3,342.000		3,342.000	
	662-6004	WK ZN PAV MRK NON-REMOV (W)4"(SLD)	LF	8,618.000		8,618.000	
	662-6012	WK ZN PAV MRK NON-REMOV (W)8"(SLD)	LF	160.000		160.000	
	662-6014	WK ZN PAV MRK NON-REMOV (W)12"(SLD)	LF	162.000		162.000	
	662-6016	WK ZN PAV MRK NON-REMOV (W)24"(SLD)	LF	530.000		530.000	
	662-6017	WK ZN PAV MRK NON-REMOV (W)(ARROW)	EA	2.000		2.000	
	662-6029	WK ZN PAV MRK NON-REMOV(W)(WORD)	EA	2.000		2.000	
	662-6034	WK ZN PAV MRK NON-REMOV (Y)4"(SLD)	LF	8,138.000		8,138.000	
	662-6048	WK ZN PAV MRK REMOV (REFL) TY I-C	EA	8.000		8.000	
	662-6052	WK ZN PAV MRK REMOV (REFL) TY II-C-R	EA	169.000		169.000	
	666-6036	REFL PAV MRK TY I (W)8"(SLD)(100MIL)	LF	80.000		80.000	
	666-6042	REFL PAV MRK TY I (W)12"(SLD)(100MIL)	LF	81.000		81.000	
	666-6048	REFL PAV MRK TY I (W)24"(SLD)(100MIL)	LF	265.000		265.000	
	666-6054	REFL PAV MRK TY I (W)(ARROW)(100MIL)	EA	2.000		2.000	
	666-6078	REFL PAV MRK TY I (W)(WORD)(100MIL)	EA	2.000		2.000	
	666-6225	PAVEMENT SEALER 6"	LF	70.000		70.000	
	666-6226	PAVEMENT SEALER 8"	LF	150.000		150.000	



DISTRICT	COUNTY	CCSJ	SHEET
Houston	Harris	0111-01-095	6



CONTROLLING PROJECT ID 0111-01-095

DISTRICT Houston
HIGHWAY FM 521

COUNTY Harris

QUANTITY SHEET

CONTROL SECTION JOB				0111-01-095		TOTAL EST.	TOTAL FINAL
PROJECT ID				A00123562			
COUNTY				Harris			
HIGHWAY				FM 521			
ALT	BID CODE	DESCRIPTION	UNIT	EST.	FINAL		
	666-6228	PAVEMENT SEALER 12"	LF	95.000		95.000	
	666-6230	PAVEMENT SEALER 24"	LF	42.000		42.000	
	666-6231	PAVEMENT SEALER (ARROW)	EA	2.000		2.000	
	666-6232	PAVEMENT SEALER (WORD)	EA	2.000		2.000	
	666-6306	RE PM W/RET REQ TY I (W)6"(BRK)(100MIL)	LF	2,227.000		2,227.000	
	666-6309	RE PM W/RET REQ TY I (W)6"(SLD)(100MIL)	LF	4,309.000		4,309.000	
	666-6321	RE PM W/RET REQ TY I (Y)6"(SLD)(100MIL)	LF	4,069.000		4,069.000	
	668-6077	PREFAB PAV MRK TY C (W) (ARROW)	EA	2.000		2.000	
	668-6085	PREFAB PAV MRK TY C (W) (WORD)	EA	2.000		2.000	
	672-6007	REFL PAV MRKR TY I-C	EA	12.000		12.000	
	672-6010	REFL PAV MRKR TY II-C-R	EA	113.000		113.000	
	677-6002	ELIM EXT PAV MRK & MRKS (6")	LF	1,182.000		1,182.000	
	677-6003	ELIM EXT PAV MRK & MRKS (8")	LF	150.000		150.000	
	677-6005	ELIM EXT PAV MRK & MRKS (12")	LF	95.000		95.000	
	677-6007	ELIM EXT PAV MRK & MRKS (24")	LF	42.000		42.000	
	677-6008	ELIM EXT PAV MRK & MRKS (ARROW)	EA	3.000		3.000	
	677-6012	ELIM EXT PAV MRK & MRKS (WORD)	EA	3.000		3.000	
	678-6002	PAV SURF PREP FOR MRK (6")	LF	70.000		70.000	
	678-6004	PAV SURF PREP FOR MRK (8")	LF	150.000		150.000	
	678-6006	PAV SURF PREP FOR MRK (12")	LF	95.000		95.000	
	678-6008	PAV SURF PREP FOR MRK (24")	LF	42.000		42.000	
	678-6009	PAV SURF PREP FOR MRK (ARROW)	EA	3.000		3.000	
	678-6016	PAV SURF PREP FOR MRK (WORD)	EA	3.000		3.000	
	684-6080	TRF SIG CBL (TY C)(14 AWG)(2 CONDR)	LF	7,045.000		7,045.000	
	688-6004	VEH LP DETECT (SAWCUT)	LF	1,450.000		1,450.000	
	3076-6041	D-GR HMA TY-D SAC-A PG70-22	TON	2,864.000		2,864.000	
	6001-6001	PORTABLE CHANGEABLE MESSAGE SIGN	DAY	108.000		108.000	
	6038-6004	MULTIPOLYMER PAV MRK (W)(6")(SLD)	LF	40.000		40.000	
	6038-6005	MULTIPOLYMER PAV MRK (W)(6")(BRK)	LF	30.000		30.000	
	6038-6007	MULTIPOLYMER PAV MRK (W)(8")(SLD)	LF	150.000		150.000	
	6038-6011	MULTIPOLYMER PAV MRK (W)(12")(SLD)	LF	95.000		95.000	
	6038-6013	MULTIPOLYMER PAV MRK (W)(24")(SLD)	LF	42.000		42.000	
	6185-6002	TMA (STATIONARY)	DAY	41.000		41.000	
	6185-6003	TMA (MOBILE OPERATION)	HR	72.000		72.000	
08		LAW ENFORCEMENT	LS	1.000		1.000	
		EROSION CONTROL MAINTENANCE (NON-PART)	LS	1.000		1.000	
		SAFETY CONTINGENCY (NON-PART)	LS	1.000		1.000	



DISTRICT	COUNTY	CCSJ	SHEET
Houston	Harris	0111-01-095	6A

SUMMARY OF WORK ZONE QUANTITIES


500 6001	502 6001	6001 6001	6185 6002	6185 6003
MOBILIZATION	BARRICADES, SIGNS AND TRAFFIC HANDLING	PORTABLE CHANGEABLE MESSAGE SIGN	TMA (STATIONARY)	TMA (MOBILE OPERATION)
LS	MO	DAY	DAY	HR
1	4	108	41	72
1	4	108	41	72

SUMMARY OF ROADWAY ITEMS

LOCATION	316 6017	316 6434	351 6049	354 6021	354 6035	354 6045	361 6002	479 6001	529 6005	644 6001	3076 6041
	ASPH (AC-20-5TR)	AGGR (TY-PB GR-4 OR TY-PL GR-4 (SAC-B)	FLEX PAVEMNT STRUCTURE REPAIR (10"-16")	PLANE ASPH CONC PAY(0" TO 2")	PLANE CONC PAV(0" TO 1")	PLANE ASPH CONC PAV (2")	FULL - DEPTH REPAIR CRCP (8")	ADJUSTING MANHOLES	CONC CURB (MONO) (TY 11)	IN SM RD SN SUP&AM TY10BWG(1) SA(P)	D-GR HMA TY-D SAC-A PG70-22
	GAL	CY	SY	SY		SY	SY	EA	LF	EA	TON
SHEET 1 OF 5	820	20	25		585	1730					211
SHEET 2 OF 5	3076	74	52	848		4893	2019	1			793
SHEET 3 OF 5	2801	67		315		4596	303	2	60		722
SHEET 4 OF 5	2865	69	23	509		4745					739
SHEET 5 OF 5	1546	30		282	625	2022				1	399
PROJECT TOTALS	11108	260	100	1954	1210	17986	2322	3	60	1	2864

SUMMARY OF SWP3 QUANTITIES

LOCATION	506 6040	506 6043
	BIODEG EROSN CONT LOGS (INSTL) (8")	BIODEG EROSN CONT LOGS (REMOVE)
	LF	LF
SHEET 1 OF 5	15.5	15.5
SHEET 2 OF 5	31	31
SHEET 3 OF 5	46.5	46.5
SHEET 4 OF 5	46.5	46.5
SHEET 5 OF 5	37	37
PROJECT TOTALS	177	177

 

FM 521
SUMMARY OF WORK ZONE,
ROADWAY AND
SWP3 QUANTITIES

FED. RD. DIV. NO.	PROJECT NO.		SHEET NO.
6			7
STATE	DIST	COUNTY	
TEXAS	HOU	HARRIS	
CONT	SECT	JOB	HIGHWAY
0111	01	095	FM 521

9/21/2020 12:11:27 PM T:\HUM-AO\Design\Roadway\FM 521\0111-01-095\ESTIMATE\007 SUMMARY OF WORK ZONE AND ROADWAY QUANTITIES.dgn

9/21/2020 10:44:25 AM T:\HUM-AO\Design\Roadway\FM 521\0111-01-095\ESTIMATE\008 SUMMARY OF PAVEMENT MARKING QUANTITIES.dgn

LOCATION	662 6001	662 6004	662 6012	662 6014	662 6016	662 6017	662 6029	662 6034	662 6048	662 6052	666 6036	666 6042	666 6048	666 6054	666 6078
	WK ZN PAV MRK NON-REMOV (W)4"(BRK)	WK ZN PAV MRK NON-REMOV (W)4"(SLD)	WK ZN PAV MRK NON-REMOV (W)8"(SLD)	WK ZN PAV MRK NON-REMOV (W)12"(SLD)	WK ZN PAV MRK NON-REMOV (W)24"(SLD)	WK ZN PAV MRK NON-REMOV (W)(ARROW)	WK ZN PAV MRK NON-REMOV(W) (WORD)	WK ZN PAV MRK NON-REMOV (Y)4"(SLD)	WK ZN PAV MRK REMOV (REFL) TY I-C	WK ZN PAV MRK REMOV (REFL) TY II-C-R	REFL PAV MRK TY I (W)8"(SLD)(100MI L)	REFL PAV MRK TY I (W)12"(SLD)(100M IL)	REFL PAV MRK TY I (W)24"(SLD)(100M IL)	REFL PAV MRK TY I (W)(ARROW)(100 MIL)	REFL PAV MRK TY I (W)(WORD)(100MI L)
	LF	LF	LF	LF	LF	EA	EA	LF	EA	EA	LF	LF	LF	EA	EA
SHEET 1 OF 5	237	700		162	0			720		14		81			
SHEET 2 OF 5	900	2400	160		224	2	2	2044	8	45	80		112	1	1
SHEET 3 OF 5	900	2246			80			2268		45			40		
SHEET 4 OF 5	900	2286			136			2182		45			68		
SHEET 5 OF 5	405	986			90			924		20			45	1	1
PROJECT TOTALS	3342	8618	160	162	530	2	2	8138	8	169	80	81	265	2	2

LOCATION	666 6225	666 6226	666 6228	666 6230	666 6231	666 6232	666 6306	666 6309	666 6321	668 6077	668 6085	672 6007	672 6010	677 6002	677 6003
	PAVEMENT SEALER 6"	PAVEMENT SEALER 8"	PAVEMENT SEALER 12"	PAVEMENT SEALER 24"	PAVEMENT SEALER (ARROW)	PAVEMENT SEALER (WORD)	RE PM W/RET REQ TY I (W)6"(BRK)(100MI L)	RE PM W/RET REQ TY I (W)6"(SLD)(100MI L)	RE PM W/RET REQ TY I (Y)6"(SLD)(100MI L)	PREFAB PAV MRK TY C (W) (ARROW)	PREFAB PAV MRK TY C (W) (WORD)	REFL PAV MRKR TY I-C	REFL PAV MRKR TY II-C-R	ELIM EXT PAV MRK & MRKS (6")	ELIM EXT PAV MRK & MRKS (8")
	LF	LF	LF	LF	EA	EA	LF	LF	LF	EA	EA	EA	EA	LF	LF
SHEET 1 OF 5	70	150	95	42	2	2	147	350	360	2	2	8	9	127	150
SHEET 2 OF 5							600	1200	1022			4	30	300	
SHEET 3 OF 5							600	1123	1134				30	300	
SHEET 4 OF 5							600	1143	1091				30	300	
SHEET 5 OF 5							280	493	462				14	155	
PROJECT TOTALS	70	150	95	42	2	2	2227	4309	4069	2	2	12	113	1182	150

LOCATION	677 6005	677 6007	677 6008	677 6012	678 6002	678 6004	678 6006	678 6008	678 6009	678 6016	6038 6004	6038 6005	6038 6007	6038 6011	6038 6013
	ELIM EXT PAV MRK & MRKS (12")	ELIM EXT PAV MRK & MRKS (24")	ELIM EXT PAV MRK & MRKS (ARROW)	ELIM EXT PAV MRK & MRKS (WORD)	PAV SURF PREP FOR MRK (6")	PAV SURF PREP FOR MRK (8")	PAV SURF PREP FOR MRK (12")	PAV SURF PREP FOR MRK (24")	PAV SURF PREP FOR MRK (ARROW)	PAV SURF PREP FOR MRK (WORD)	MULTIPOLYMER PAV MRK (W)(6")(SLD)	MULTIPOLYMER PAV MRK (W)(6")(BRK)	MULTIPOLYMER PAV MRK (W)(8")(SLD)	MULTIPOLYMER PAV MRK (W)(12")(SLD)	MULTIPOLYMER PAV MRK (W)(24")(SLD)
	LF	LF	EA	EA	LF	LF	LF	LF	EA	EA	LF	LF	LF	LF	LF
SHEET 1 OF 5	95	42	2	2	70	150	95	42	2	2	40	30	150	95	42
SHEET 2 OF 5															
SHEET 3 OF 5															
SHEET 4 OF 5															
SHEET 5 OF 5			1	1					1	1			150	95	42
PROJECT TOTALS	95	42	3	3	70	150	95	42	3	3	40	30	150	95	42



FM 521

SUMMARY OF PAVEMENT
MARKING QUANTITIES

FED. RD. DIV. NO.	PROJECT NO.		SHEET NO.
6			8
STATE	DIST	COUNTY	
TEXAS	HOU	HARRIS	
CONT	SECT	JOB	HIGHWAY
0111	01	095	FM 521

MATERIALS FOR HIGHWAY TRAFFIC SIGNAL					
ITEM	DESC CODE	DESCRIPTION	UNIT	QUANTITY	FINAL
0618	6046	CONDT (PVC) (SCH 80) (2")	LF	850	
0618	6047	CONDT (PVC) (SCH 80) (2") (BORE)	LF	345	
0618	6053	CONDT (PVC) (SCH 80) (3")	LF	70	
0618	6054	CONDT (PVC) (SCH 80) (3") (BORE)	LF	145	
0620	6009	ELEC CONDR (NO.6) BARE	LF	1400	
0624	6010	GROUND BOX TY D (162922)W/APRON	EA	16	
0684	6080	TRF SIG CBL (TY C) (14 AWG) (2 CONDR)	LF	7045	
0688	6004	VEH LP DETECT (SAWCUT)	LF	1450	
0688	****	CONDT (PVC) (SCH 80) (1 1/4")	LF	360	
0688	****	ELEC CONDR (NO.14) INSULATED	LF	3885	

**** MATERIALS SUBSIDIARY TO PERTINENT ITEM



FM 521
SUMMARY OF
TRAFFIC SIGNAL
QUANTITIES

FED. RD. DIV. NO.	PROJECT NO.		SHEET NO.
6			9
STATE	DIST	COUNTY	
TEXAS	HOU	HARRIS	
CONT	SECT	JOB	HIGHWAY
0111	01	095	FM 521

10/7/2020 11:01:07 PM
T:\HUM-AO\Des\ign\Roadway\FM 521\0111-01-095\DGN\TCP\011 CONSTRUCTION NARRATIVE.dgn

PHASE 1: SB SIDE CURB, FULL DEPTH CONCRETE REPAIR, SEAL COAT AND HOT MIX OVERLAY

STEP IA: PLACE WORK ZONE BARRICADES & SIGNS AND SWP3 BMPS AS NOTED OR DIRECTED.

STEP IB: FULL DEPTH CONCRETE PAVEMENT REPAIR

- SET UP TCP IN ACCORDANCE WITH STANDARD TCP (2-4a)-18 MOD FOR ONE LANE CLOSURE.
- PERFORM FULL DEPTH CONCRETE REPAIR AND CURB REPAIR AT LOCATIONS MARKED BY THE ENGINEER.

STEP IIA- IIB: SEAL COAT AND OVERLAY

- SET UP TCP IN ACCORDANCE WITH STANDARD TCP (1-4a)-18 MOD FOR ONE LANE CLOSURE.
- CLEAN SURFACE AND PLACE SEAL COAT AND HOT MIX ASPHALT OVERLAY.
- PLACE TEMPORARY NON REMOVABLE WORK ZONE PAVEMENT MARKINGS ON OVERLAID SURFACES BEFORE OPENING TO TRAFFIC AT END OF WORK DAY.

PHASE 2: NB SIDE - FLEXIBLE PAVEMENT REPAIR, SEAL COAT AND HOT MIX OVERLAY

STEP I : PLACE WORK ZONE BARRICADES & SIGNS AND SWP3 BMPS AS NOTED OR DIRECTED.

STEP IIA- IIB: MILLING AND FLEXIBLE BASE REPAIR

- SET UP TCP IN ACCORDANCE WITH STANDARD TCP (1-4a)-18 MOD FOR ONE LANE CLOSURE AND "WZ(UL)-13".
- PLANE 2" ACP PROJECT WIDE STARTING WITH THE OUTERMOST LANE AND WORKING INWARD. PLANE CROSSOVER 2"-0".
- AFTER PLANING, PERFORM FLEXIBLE PAVEMENT REPAIR AT LOCATIONS MARKED BY THE ENGINEER.
- PLACE TEMPORARY ASPHALT TRANSITIONS AT ALL UNEVEN SURFACES ACCORDING TO TEMPORARY ASPHALT DETAIL" (SHEET 41) AFTER EACH PLANING OPERATION.
- PLACE TEMPORARY NON REMOVABLE WORK ZONE PAVEMENT MARKINGS ON PLANED SURFACES BEFORE OPENING TO TRAFFIC AT END OF WORK DAY.

STEP IIIA- IIIB: SEAL COAT AND OVERLAY

- SET UP TCP IN ACCORDANCE WITH STANDARD TCP (1-4a)-18 MOD FOR ONE LANE CLOSURE.
- REMOVE TEMPORARY ASPHALT, CLEAN SURFACE AND PLACE SEAL COAT AND HOT MIX ASPHALT OVERLAY.
- PLACE TEMPORARY NON-REMOVABLE WORK ZONE PAVEMENT MARKINGS ON OVERLAID SURFACES BEFORE OPENING TO TRAFFIC AT END OF WORK DAY.

PHASE 3: FINAL WORK AND STRIPING

- PLACE FINAL PAVEMENT MARKINGS.
- REMOVE BARRICADES, WORK ZONE SIGNS AND SWP3 BMPS. OPEN ROADWAY TO TRAFFIC.

NOTES:

THIS IS A SUGGESTED TRAFFIC CONTROL PLAN SUBMITTED FOR THE CONTRACTOR'S CONSIDERATION. THE CONTRACTOR MAY SUBMIT AN ALTERNATE TRAFFIC CONTROL PLAN TO THE ENGINEER FOR APPROVAL. NO PHASE OF CONSTRUCTION SHALL START UNTIL COMPLETION OF THE PREVIOUS PHASE, UNLESS OTHERWISE APPROVED BY THE ENGINEER.

ALL WORK AND MATERIALS REQUIRED FOR TRAFFIC HANDLING SHALL NOT BE PAID FOR DIRECTLY BUT SHALL BE CONSIDERED INCIDENTAL TO ITEM 502 "BARRICADES, SIGNS AND TRAFFIC HANDLING."



Sharmeen Rahman, P.E.

10/09/2020




FM 521


CONSTRUCTION NARRATIVE

FED. RD. DIV. NO.	PROJECT NO.		SHEET NO.
6			11
STATE	DIST	COUNTY	
TEXAS	HOU	HARRIS	
CONT	SECT	JOB	HIGHWAY
0111	01	095	FM 521


10/15/2020 4:30:27 PM T:\HUM-AO\Des\ign\Roadway\FM 521\0111-01-095\DGN\TCP\011 CONSTRUCTION NARRATIVE.dgn

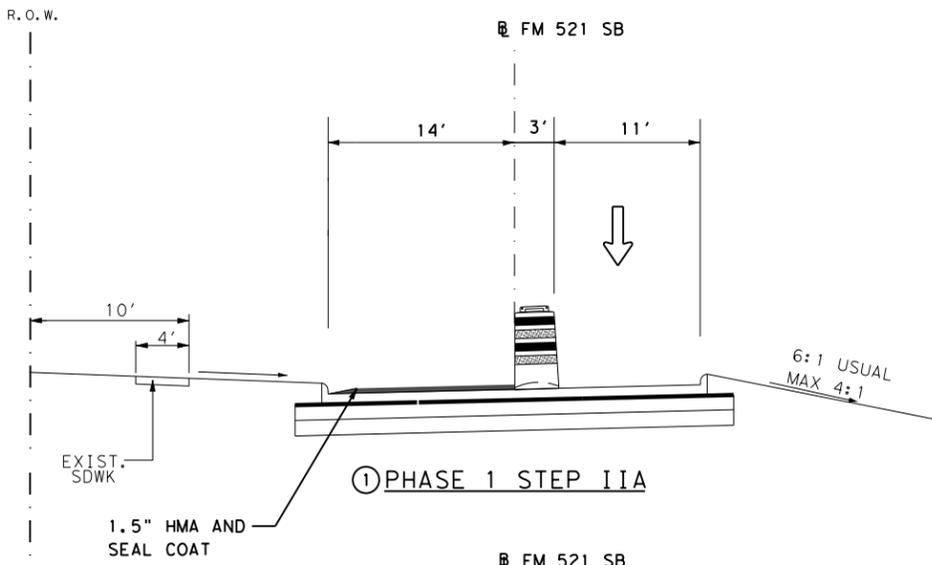

① PHASE 1 STEP IIA

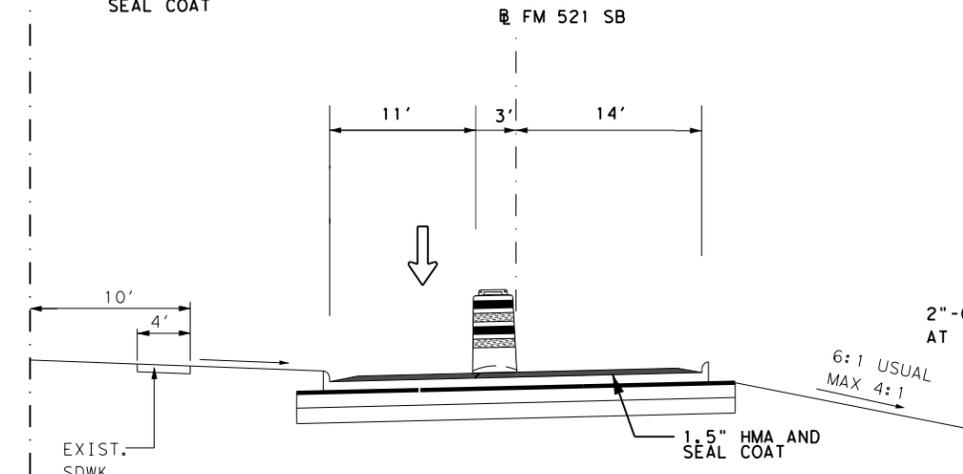


② PHASE 1 STEP IIB

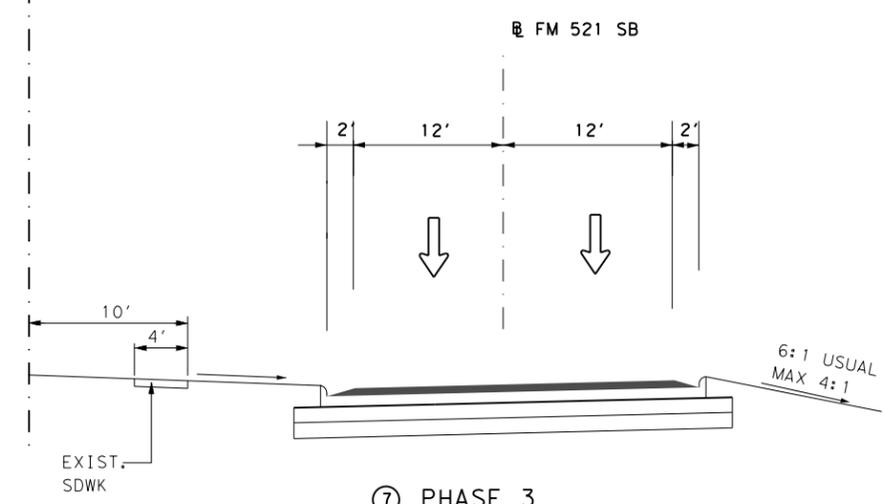


⑦ PHASE 3


SOUTHBOUND

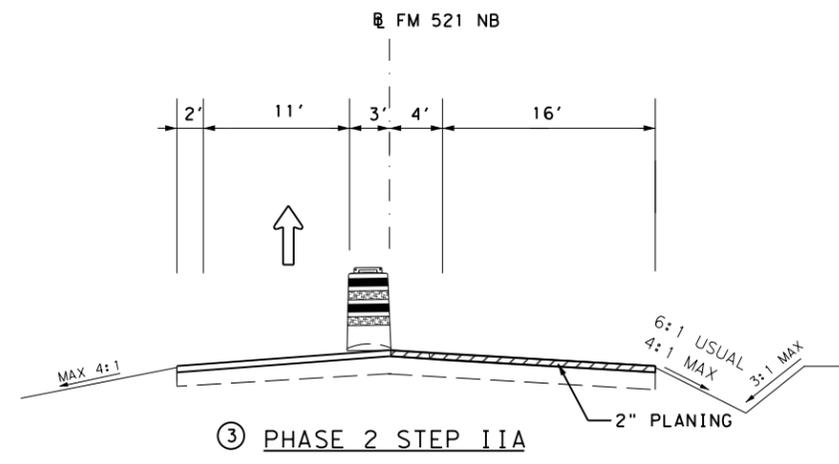

③ PHASE 2 STEP IIA

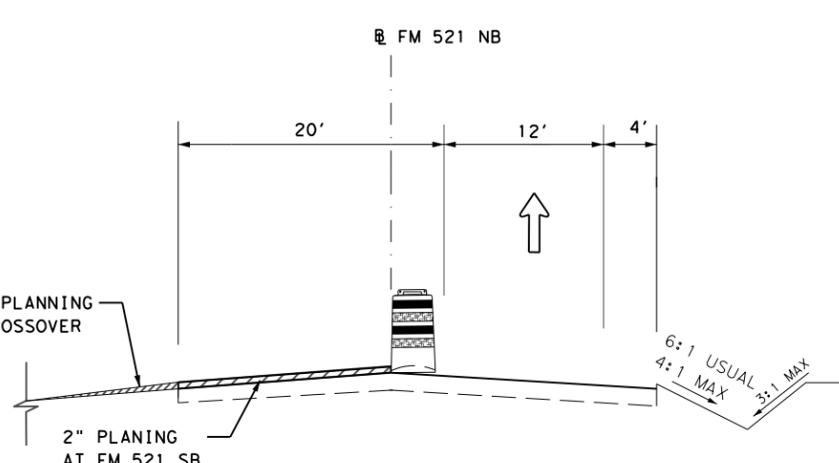


④ PHASE 2 STEP IIB

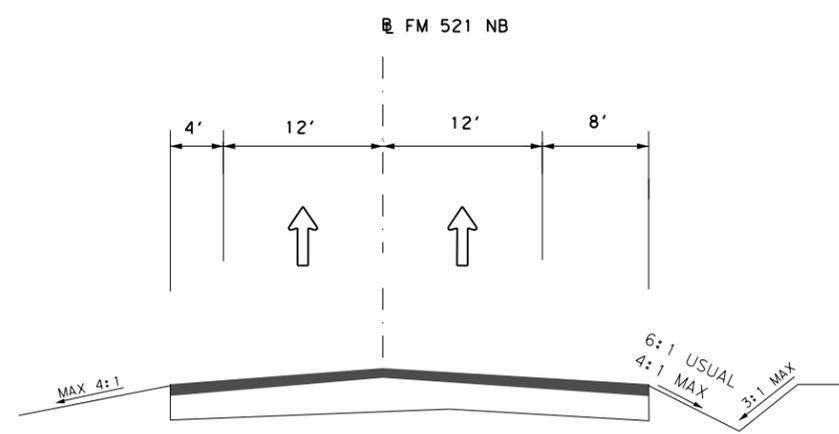


⑧ PHASE 3

NOTHRBOUND

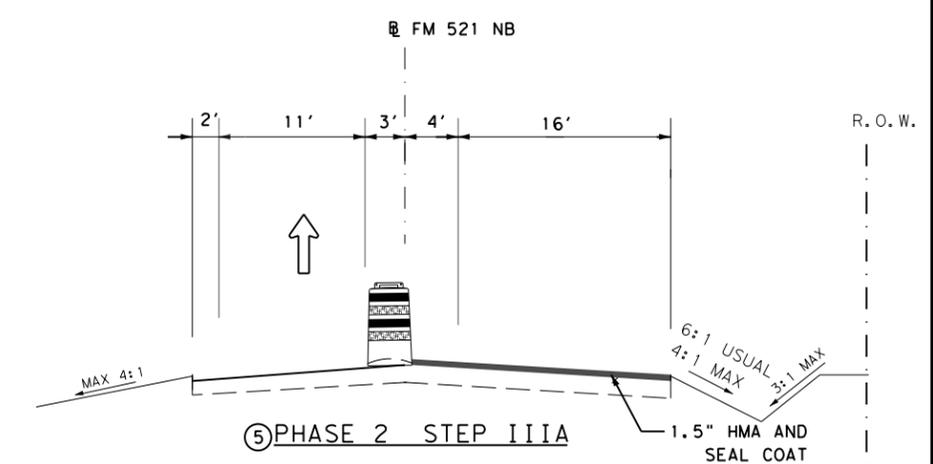


⑤ PHASE 2 STEP IIIA

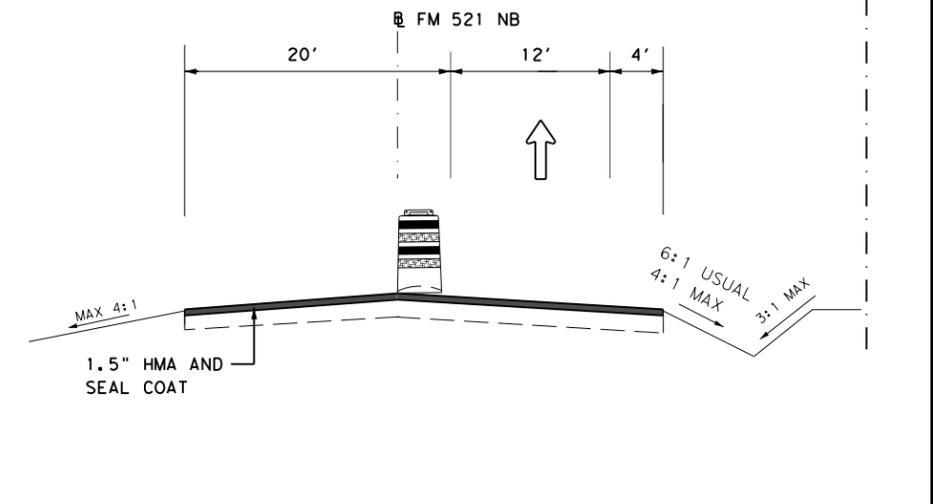

⑥ PHASE 2 STEP IIIB

NORTHBOUND LANES

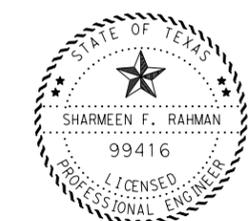

Sharmeen Rahman, P.E.
10/15/2020



FM 521
TRAFFIC CONTROL PLAN
TYPICAL SECTIONS

SCALE: N. T. S.		PROJECT NO.		SHEET NO.
6				11A
STATE	DIST	COUNTY		
TEXAS	HOU	HARRIS		
CONT	SECT	JOB	HIGHWAY	
0111	01	095	FM 521	

DISCLAIMER: The use of this standard is governed by the "Texas Engineering Practice Act". No warranty of any kind is made by TxDOT for any purpose whatsoever. TxDOT assumes no responsibility for the conversion of this standard to other formats or for incorrect results or damages resulting from its use.


DATE: 9/18/2020 12:08:41 AM
 FILE: I:\HUM-AO\Design\Roadway\FM 521\0111-01-095\DGN\TC\12-23 BC(1)-14.dgn

BARRICADE AND CONSTRUCTION (BC) STANDARD SHEETS GENERAL NOTES:

- The Barricade and Construction Standard Sheets (BC sheets) are intended to show typical examples for placement of temporary traffic control devices, construction pavement markings, and typical work zone signs. The information contained in these sheets meet or exceed the requirements shown in the "Texas Manual on Uniform Traffic Control Devices" (TMUTCD).
- The development and design of the Traffic Control Plan (TCP) is the responsibility of the Engineer.
- The Contractor may propose changes to the TCP that are signed and sealed by a licensed professional engineer for approval. The Engineer may develop, sign and seal Contractor proposed changes.
- The Contractor is responsible for installing and maintaining the traffic control devices as shown in the plans. The Contractor may not move or change the approximate location of any device without the approval of the Engineer.
- Geometric design of lane shifts and detours should, when possible, meet the applicable design criteria contained in manuals such as the American Association of State Highway and Transportation Officials (AASHTO), "A Policy on Geometric Design of Highways and Streets," the TxDOT "Roadway Design Manual" or engineering judgment.
- When projects abut, the Engineer(s) may omit the END ROAD WORK, TRAFFIC FINES DOUBLE, and other advance warning signs if the signing would be redundant and the work areas appear continuous to the motorists. If the adjacent project is completed first, the Contractor shall erect the necessary warning signs as shown on these sheets, the TCP sheets or as directed by the Engineer. The BEGIN ROAD WORK NEXT X MILES sign shall be revised to show appropriate work zone distance.
- The Engineer may require duplicate warning signs on the median side of divided highways where median width will permit and traffic volumes justify the signing.
- All signs shall be constructed in accordance with the details found in the "Standard Highway Sign Designs for Texas," latest edition. Sign details not shown in this manual shall be shown in the plans or the Engineer shall provide a detail to the Contractor before the sign is manufactured.
- The temporary traffic control devices shown in the illustrations of the BC sheets are examples. As necessary, the Engineer will determine the most appropriate traffic control devices to be used.
- As shown on BC(2), the OBEY WARNING SIGNS STATE LAW sign, STAY ALERT TALK OR TEXT LATER (see Sign Detail G20-10T) and the WORK ZONE TRAFFIC FINES DOUBLE sign with plaque shall be erected in advance of the CSJ limits. However, the TRAFFIC FINES DOUBLE sign will not be required on projects consisting solely of mobile operation work, such as striping or milling edgeline rumble strips. The BEGIN ROAD WORK NEXT X MILES, CONTRACTOR and END ROAD WORK signs shall be erected at or near the CSJ limits.
- Except for devices required by Note 10, traffic control devices should be in place only while work is actually in progress or a definite need exists.
- The Engineer has the final decision on the location of all traffic control devices.
- Inactive equipment and work vehicles, including workers' private vehicles must be parked away from travel lanes. They should be as close to the right-of-way line as possible, or located behind a barrier or guardrail, or as approved by the Engineer.

WORKER SAFETY APPAREL NOTES:

- Workers on foot who are exposed to traffic or to construction equipment within the right-of-way shall wear high-visibility safety apparel meeting the requirements of ISEA "American National Standard for High-Visibility Apparel," or equivalent revisions, and labeled as ANSI 107-2004 standard performance for Class 2 or 3 risk exposure. Class 3 garments should be considered for high traffic volume work areas or night time work.

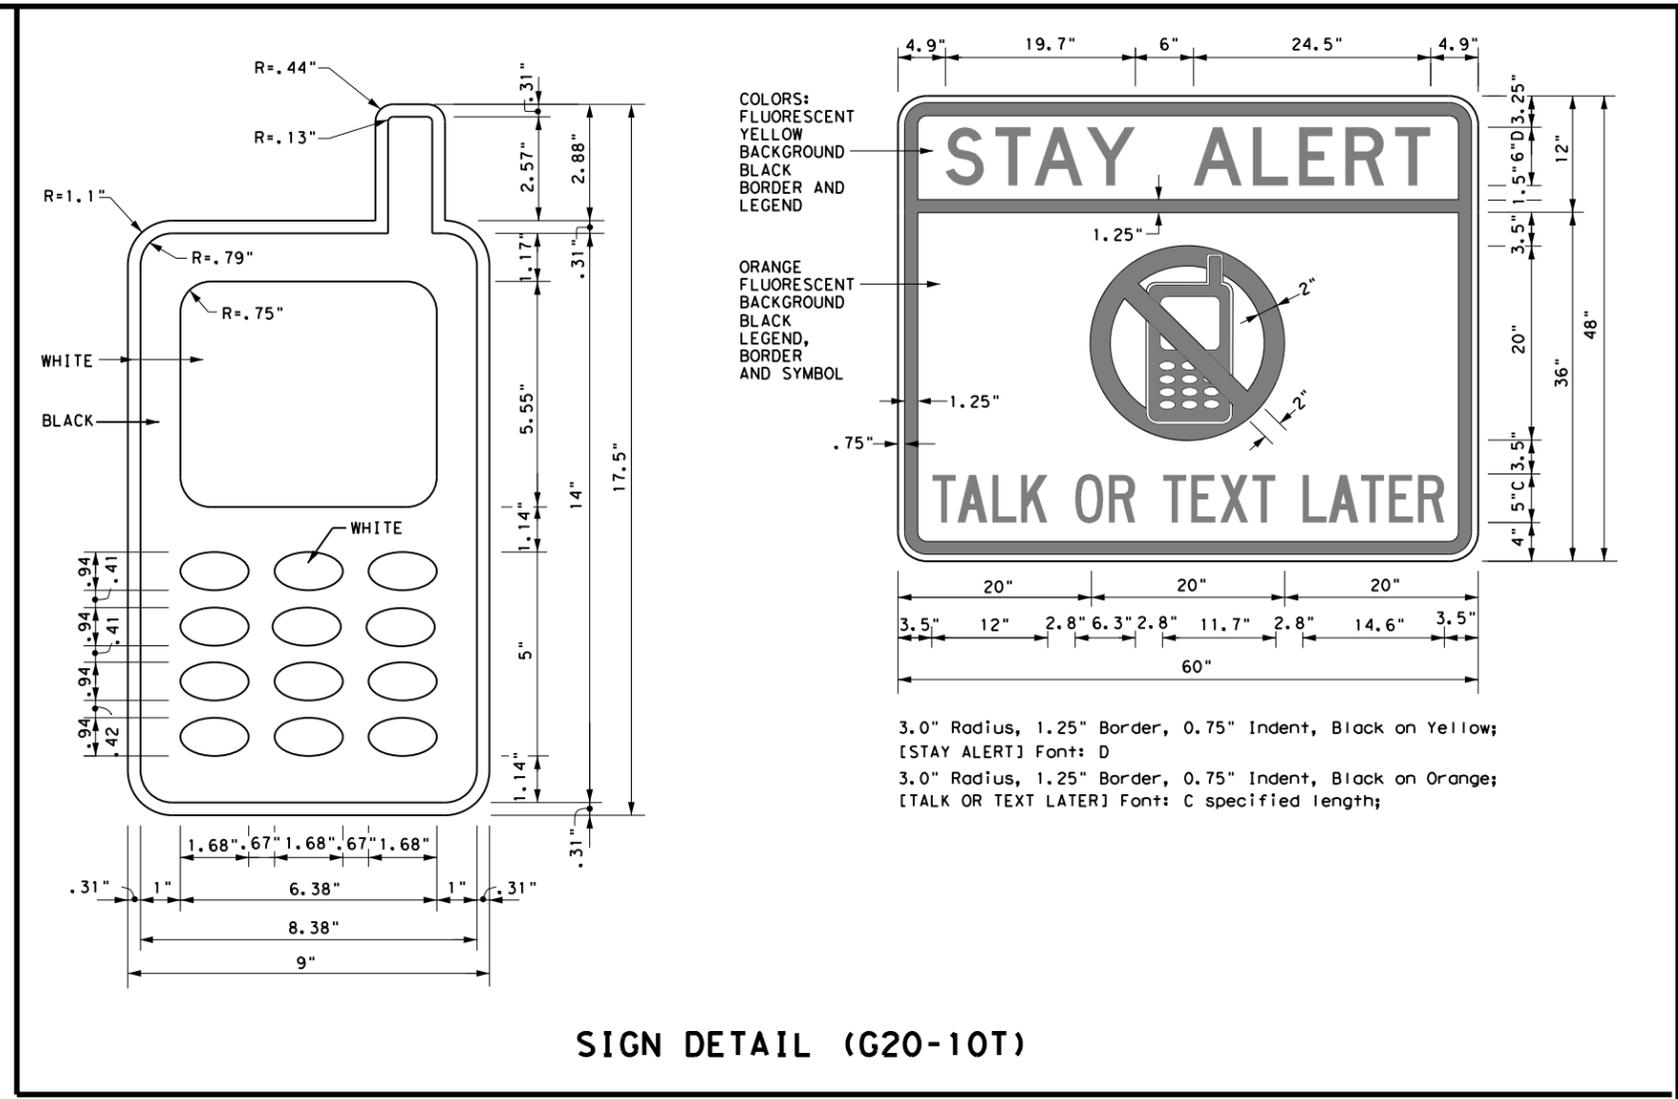

Only pre-qualified products shall be used. The "Compliant Work Zone Traffic Control Devices List" (CWZTCD) describes pre-qualified products and their sources and may be found on-line at the web address given below or by contacting:

Texas Department of Transportation
 Traffic Operations Division - TE
 Phone (512) 416-3118


THE DOCUMENTS BELOW CAN BE FOUND ON-LINE AT http://www.txdot.gov	
COMPLIANT WORK ZONE TRAFFIC CONTROL DEVICES LIST (CWZTCD)	
DEPARTMENTAL MATERIAL SPECIFICATIONS (DMS)	
MATERIAL PRODUCER LIST (MPL)	
ROADWAY DESIGN MANUAL - SEE "MANUALS (ONLINE MANUALS)"	
STANDARD HIGHWAY SIGN DESIGNS FOR TEXAS (SHSD)	
TEXAS MANUAL ON UNIFORM TRAFFIC CONTROL DEVICES (TMUTCD)	
TRAFFIC ENGINEERING STANDARD SHEETS	

SHEET 1 OF 12

		<i>Traffic Operations Division Standard</i>
BARRICADE AND CONSTRUCTION GENERAL NOTES AND REQUIREMENTS		
BC(1)-14		
FILE: bc-14.dgn	DW: TxDOT	CK: TxDOT
© TxDOT November 2002	CONT: 0111	SECT: 01
REVISIONS	JOB: 095	HIGHWAY: FM 521
4-03 5-10 8-14	DIST: HOU	COUNTY: HARRIS
9-07 7-13	SHEET NO. 12	


DATE: 9/18/2020 12:09:27 AM
 FILE: T:\HUM-AOV\Design\Roadway\FM_521\0111-01-095\VDGN\TC\12-23_BC(1)-14.dgn
 The use of this standard is governed by the "Texas Engineering Practice Act". No warranty of any kind is made by TxDOT for any purpose whatsoever. TxDOT assumes no responsibility for the conversion of this standard to other formats or for incorrect results or damages resulting from its use.

TYPICAL LOCATION OF CROSSROAD SIGNS

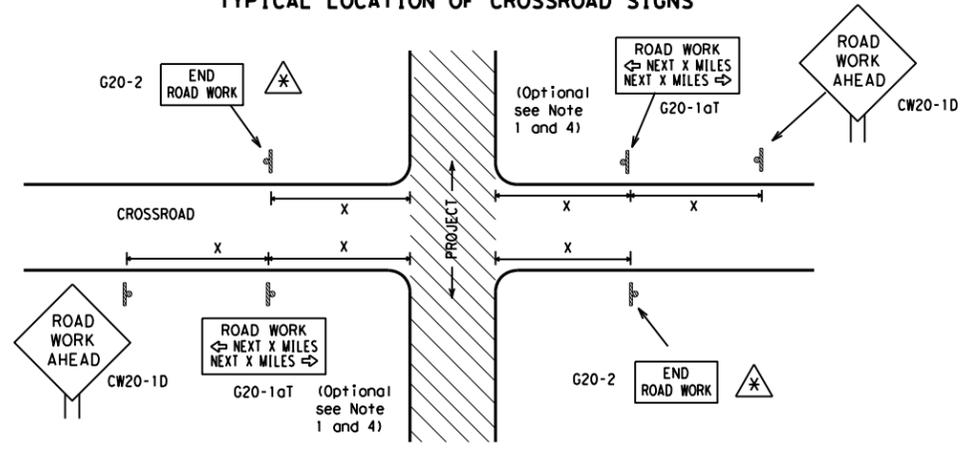

- ⚠ May be mounted on back of "ROAD WORK AHEAD" (CW20-1D) sign with approval of Engineer. (See note 2 below)
- The typical minimum signing on a crossroad approach should be a "ROAD WORK AHEAD" (CW20-1D) sign and a (G20-2) "END ROAD WORK" sign, unless noted otherwise in plans.
 - The Engineer may use the reduced size 36" x 36" ROAD WORK AHEAD (CW20-1D) sign mounted back to back with the reduced size 36" x 18" "END ROAD WORK" (G20-2) sign on low volume crossroads (see Note 4 under "Typical Construction Warning Sign Size and Spacing"). See the "Standard Highway Sign Designs for Texas" manual for sign details. The Engineer may omit the advance warning signs on low volume crossroads. The Engineer will determine whether a road is low volume. This information shall be shown in the plans.
 - Based on existing field conditions, the Engineer/Inspector may require additional signs such as FLAGGER AHEAD, LOOSE GRAVEL, or other appropriate signs. When additional signs are required, these signs will be considered part of the minimum requirements. The Engineer/Inspector will determine the proper location and spacing of any sign not shown on the BC sheets, Traffic Control Plan sheets or the Work Zone Standard Sheets.
 - The "ROAD WORK NEXT X MILES" (G20-1aT) sign shall be required at high volume crossroads to advise motorists of the length of construction in either direction from the intersection. The Engineer will determine whether a roadway is considered high volume.
 - Additional traffic control devices may be shown elsewhere in the plans for higher volume crossroads.
 - When work occurs in the intersection area, appropriate traffic control devices, as shown elsewhere in the plans or as determined by the Engineer/Inspector, shall be in place.

T-INTERSECTION

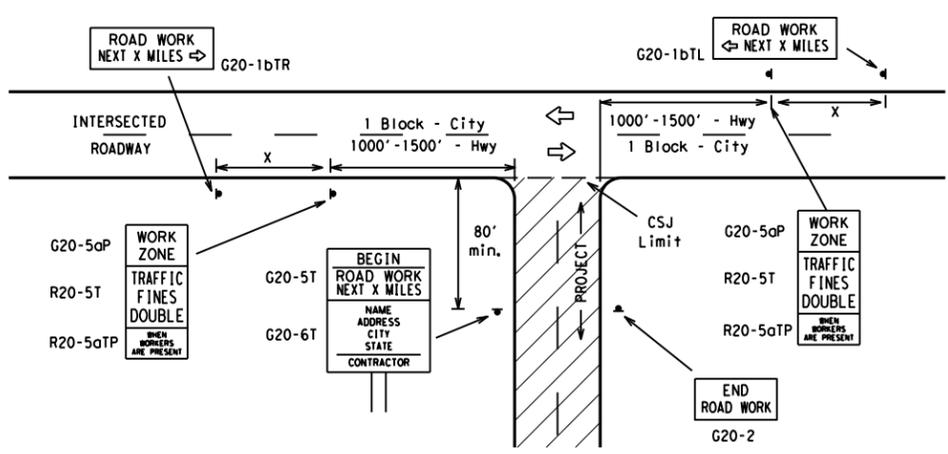

CSJ LIMITS AT T-INTERSECTION

- The Engineer will determine the types and location of any additional traffic control devices, such as a flagger and accompanying signs, or other signs, that should be used when work is being performed at or near an intersection.
- If construction closes the road at a T-intersection the Contractor shall place the "CONTRACTOR NAME" (G20-6T) sign behind the Type 3 Barricades for the road closure (see BC(10) also). The "ROAD WORK NEXT X MILES" left arrow (G20-1bTL) and "ROAD WORK NEXT X MILES" right arrow (G20-1bTR) signs shall be replaced by the detour signing called for in the plans.

TYPICAL CONSTRUCTION WARNING SIGN SIZE AND SPACING^{1,5,6}

Sign Number or Series	SIZE		SPACING	
	Conventional Road	Expressway/Freeway	Posted Speed MPH	Sign Spacing "X" Feet (Apprx.)
CW20 ⁴	48" x 48"	48" x 48"	30	120
CW21			35	160
CW22			40	240
CW23			45	320
CW25			50	400
CW1, CW2, CW7, CW8, CW9, CW11, CW14	36" x 36"	48" x 48"	55	500 ²
CW3, CW4, CW5, CW6, CW8-3, CW10, CW12	48" x 48"	48" x 48"	60	600 ²
			65	700 ²
			70	800 ²
			75	900 ²
			80	1000 ²
			*	* ³


* For typical sign spacings on divided highways, expressways and freeways, see Part 6 of the "Texas Manual on Uniform Traffic Control Devices" (TMUTCD) typical application diagrams or TCP Standard Sheets.

Δ Minimum distance from work area to first Advance Warning sign nearest the work area and/or distance between each additional sign.

GENERAL NOTES


- Special or larger size signs may be used as necessary.
- Distance between signs should be increased as required to have 1500 feet advance warning.
- Distance between signs should be increased as required to have 1/2 mile or more advance warning.
- 36" x 36" "ROAD WORK AHEAD" (CW20-1D) signs may be used on low volume crossroads at the discretion of the Engineer. See Note 2 under "Typical Location of Crossroad Signs".
- Only diamond shaped warning sign sizes are indicated.
- See sign size listing in "TMUTCD", Sign Appendix or the "Standard Highway Sign Designs for Texas" manual for complete list of available sign design sizes.

WORK AREAS IN MULTIPLE LOCATIONS WITHIN CSJ LIMITS

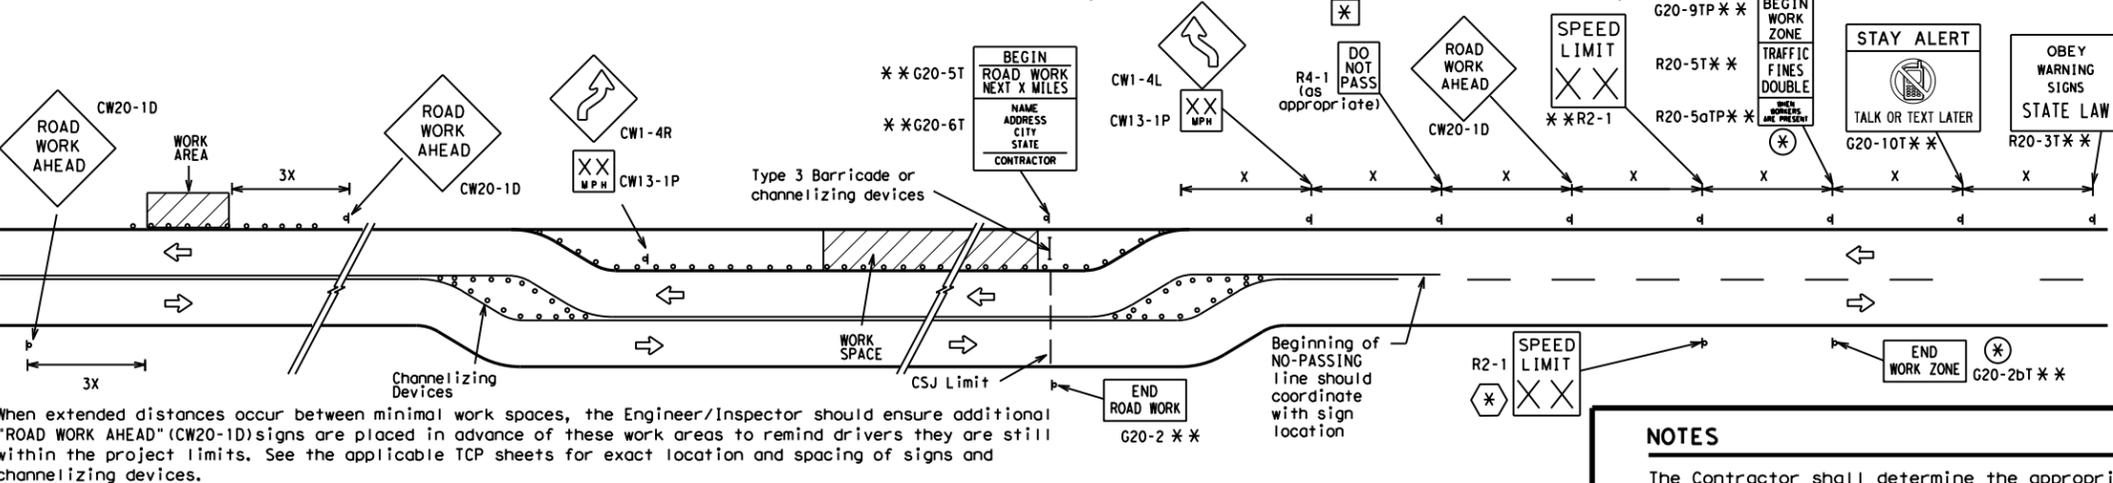


When extended distances occur between minimal work spaces, the Engineer/Inspector should ensure additional "ROAD WORK AHEAD" (CW20-1D) signs are placed in advance of these work areas to remind drivers they are still within the project limits. See the applicable TCP sheets for exact location and spacing of signs and channelizing devices.

SAMPLE LAYOUT OF SIGNING FOR WORK BEGINNING DOWNSTREAM OF THE CSJ LIMITS

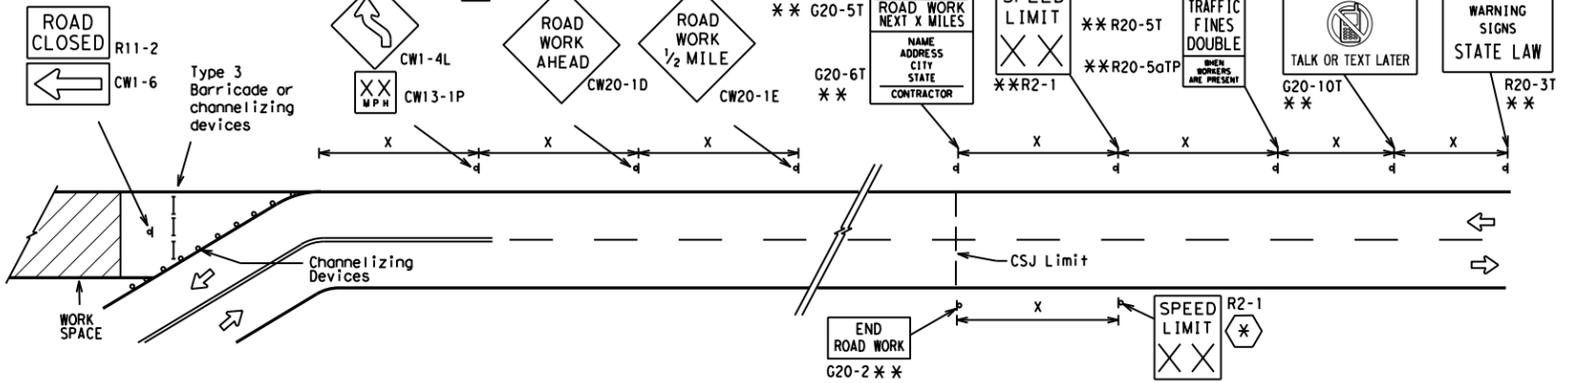

SAMPLE LAYOUT OF SIGNING FOR WORK BEGINNING AT THE CSJ LIMITS

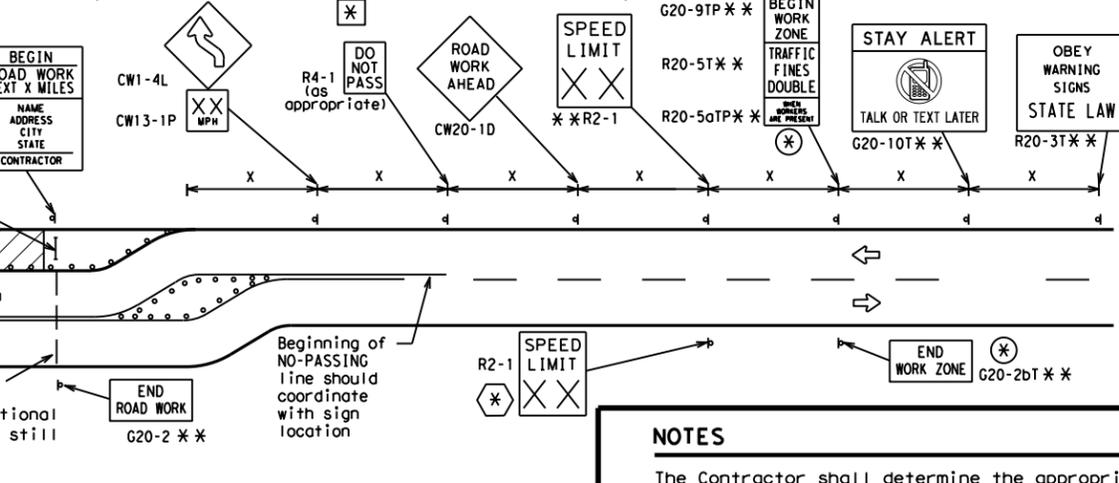

NOTES

- The Contractor shall determine the appropriate distance to be placed on the G20-1 series signs and "BEGIN ROAD WORK NEXT X MILES" (G20-5T) sign for each specific project. This distance shall replace the "X" and shall be rounded to the nearest whole mile with the approval of the Engineer. No decimals shall be used.
- ⊗ The "BEGIN WORK ZONE" (G20-9TP) and "END WORK ZONE" (G20-2bT) shall be used as shown on the sample layout when advance signs are required outside the CSJ Limits. They inform the motorist of entering or leaving a part of the work zone lying outside the CSJ Limits where traffic fines may double if workers are present.
- ** Required CSJ Limit signing. See Note 10 on BC(1). TRAFFIC FINES DOUBLE signs will not be required on projects consisting solely of mobile operations work.
- ⊗ Area for placement of "ROAD WORK AHEAD" (CW20-1D) sign and other signs or devices as called for on the Traffic Control Plan.
- ⊗ Contractor will install a regulatory speed limit sign at the end of the work zone.

LEGEND

—	Type 3 Barricade
○ ○ ○	Channelizing Devices
⊗	Sign
X	See Typical Construction Warning Sign Size and Spacing chart or the TMUTCD for sign spacing requirements.

SHEET 2 OF 12

Texas Department of Transportation
Traffic Operations Division Standard

BARRICADE AND CONSTRUCTION PROJECT LIMIT


BC(2)-14

FILE: bc-14.dgn	DN: TxDOT	CK: TxDOT	DW: TxDOT	CK: TxDOT
© TxDOT November 2002	CONT SECT	JOB	HIGHWAY	
REVISIONS	0111 01	095	FM 521	
9-07 8-14	DIST	COUNTY	SHEET NO.	
7-13	HOU	HARRIS	13	

TYPICAL APPLICATION OF WORK ZONE SPEED LIMIT SIGNS

Work zone speed limits shall be regulatory, established in accordance with the "Procedures for Establishing Speed Zones," and approved by the Texas Transportation Commission, or by City Ordinance when within Incorporated City Limits.

Reduced speeds should only be posted in the vicinity of work activity and not throughout the entire project. Regulatory work zone speed signs (R2-1) shall be removed or covered during periods when they are not needed.

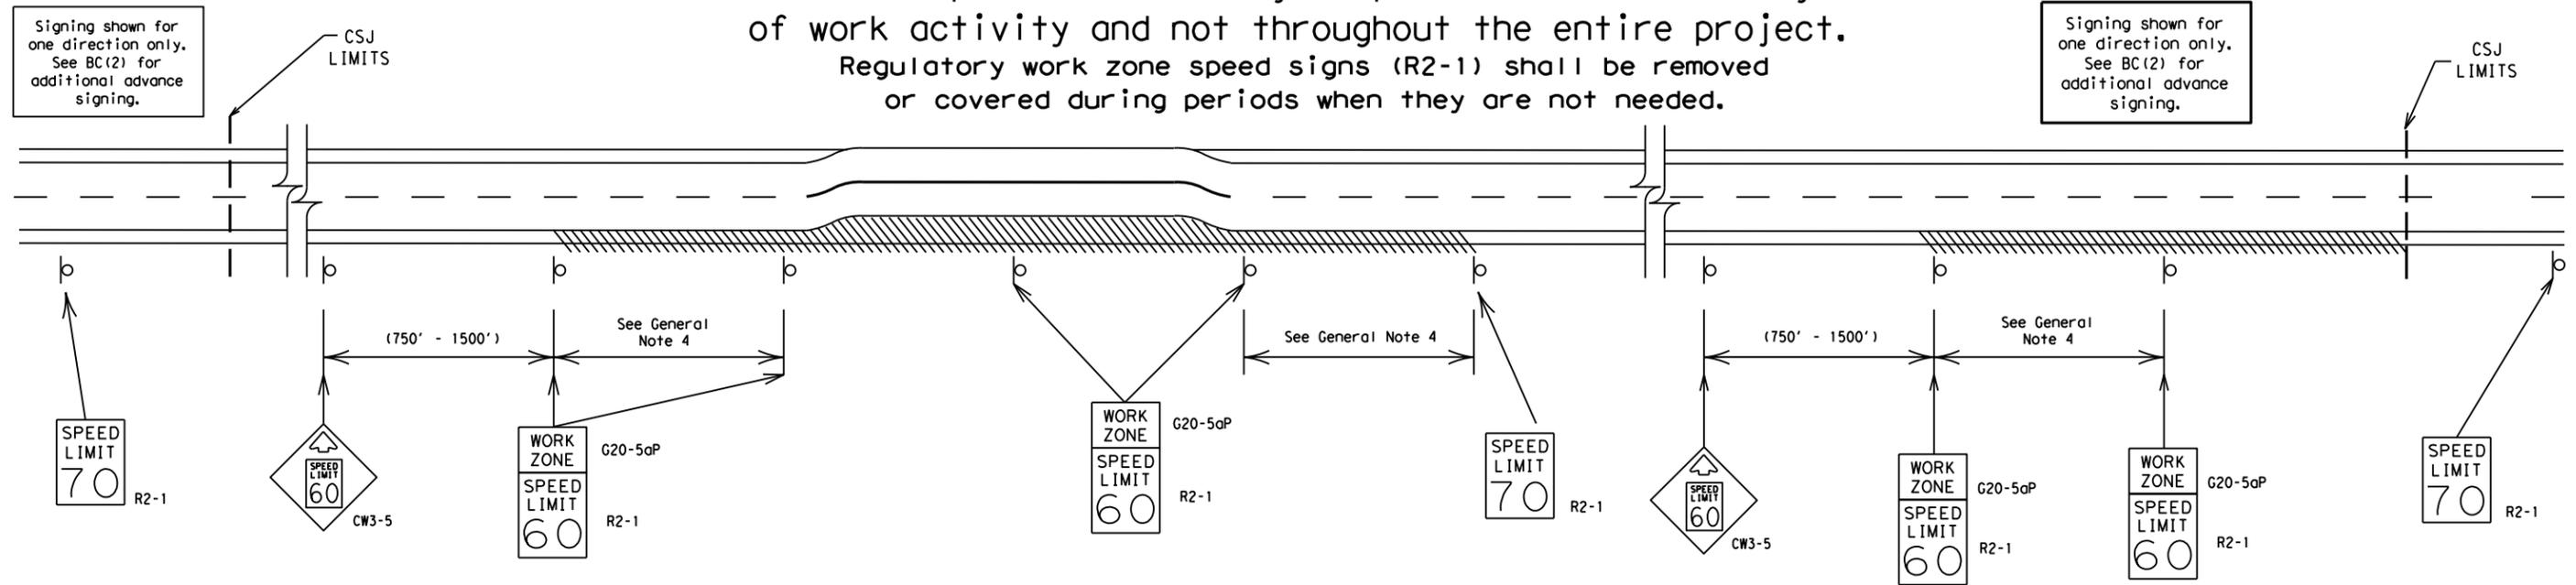

GUIDANCE FOR USE:

LONG/INTERMEDIATE TERM WORK ZONE SPEED LIMITS

This type of work zone speed limit should be included on the design of the traffic control plans when restricted geometrics with a lower design speed are present in the work zone and modification of the geometrics to a higher design speed is not feasible.

Long/Intermediate Term Work Zone Speed Limit signs, when approved as described above, should be posted and visible to the motorist when work activity is present. Work activity may also be defined as a change in the roadway that requires a reduced speed for motorists to safely negotiate the work area, including:

- rough road or damaged pavement surface
- substantial alteration of roadway geometrics (diversions)
- construction detours
- grade
- width
- other conditions readily apparent to the driver

As long as any of these conditions exist, the work zone speed limit signs should remain in place.

SHORT TERM WORK ZONE SPEED LIMITS

This type of work zone speed limit may be included on the design of the traffic control plans when workers or equipment are not behind concrete barrier, when work activity is within 10 feet of the traveled way or actually in the traveled way.

Short Term Work Zone Speed Limit signs should be posted and visible to the motorists only when work activity is present. When work activity is not present, signs shall be removed or covered. (See Removing or Covering on BC(4)).

GENERAL NOTES

- Regulatory work zone speed limits should be used only for sections of construction projects where speed control is of major importance.
- Regulatory work zone speed limit signs shall be placed on supports at a 7 foot minimum mounting height.
- Speed zone signs are illustrated for one direction of travel and are normally posted for each direction of travel.
- Frequency of work zone speed limit signs should be:

40 mph and greater	0.2 to 2 miles
35 mph and less	0.2 to 1 mile
- Regulatory speed limit signs shall have black legend and border on a white reflective background (See "Reflective Sheeting" on BC(4)).
- Fabrication, erection and maintenance of the "ADVANCE SPEED LIMIT" (CW3-5) sign, "WORK ZONE" (G20-5aP) plaque and the "SPEED LIMIT" (R2-1) signs shall not be paid for directly, but shall be considered subsidiary to Item 502.
- Turning signs from view, laying signs over or down will not be allowed, unless as otherwise noted under "REMOVING OR COVERING" on BC(4).
- Techniques that may help reduce traffic speeds include but are not limited to:
 - Law enforcement.
 - Flagger stationed next to sign.
 - Portable changeable message sign (PCMS).
 - Low-power (drone) radar transmitter.
 - Speed monitor trailers or signs.
- Speeds shown on details above are for illustration only. Work Zone Speed Limits should only be posted as approved for each project.
- For more specific guidance concerning the type of work, work zone conditions and factors impacting allowable regulatory construction speed zone reduction see TxDOT form #1204 in the TxDOT e-form system.


DISCLAIMER: The use of this standard is governed by the "Texas Engineering Practice Act". No warranty of any kind is made by TxDOT for any purpose whatsoever. TxDOT assumes no responsibility for the conversion of units or for the use of this standard in other formats or for incorrect results or damages resulting from its use.

DATE: 9/18/2020 12:09:49 AM
FILE: T:\HUM-AO\Design\Roadway\FM 521\0111-01-095\DGN\TCP\12-23 BC(1)-14.dgn

SHEET 3 OF 12

		Traffic Operations Division Standard	
<h2>BARRICADE AND CONSTRUCTION WORK ZONE SPEED LIMIT</h2>			
<h3>BC (3) - 14</h3>			
FILE:	bc-14.dgn	DW:	TxDOT
© TxDOT	November 2002	CONT:	0111
REVISIONS	01	SECT:	01
9-07	8-14	JOB:	095
7-13		HIGHWAY:	FM 521
		DIST:	HOU
		COUNTY:	HARRIS
		SHEET NO.:	14


TYPICAL MINIMUM CLEARANCES FOR LONG TERM AND INTERMEDIATE TERM SIGNS

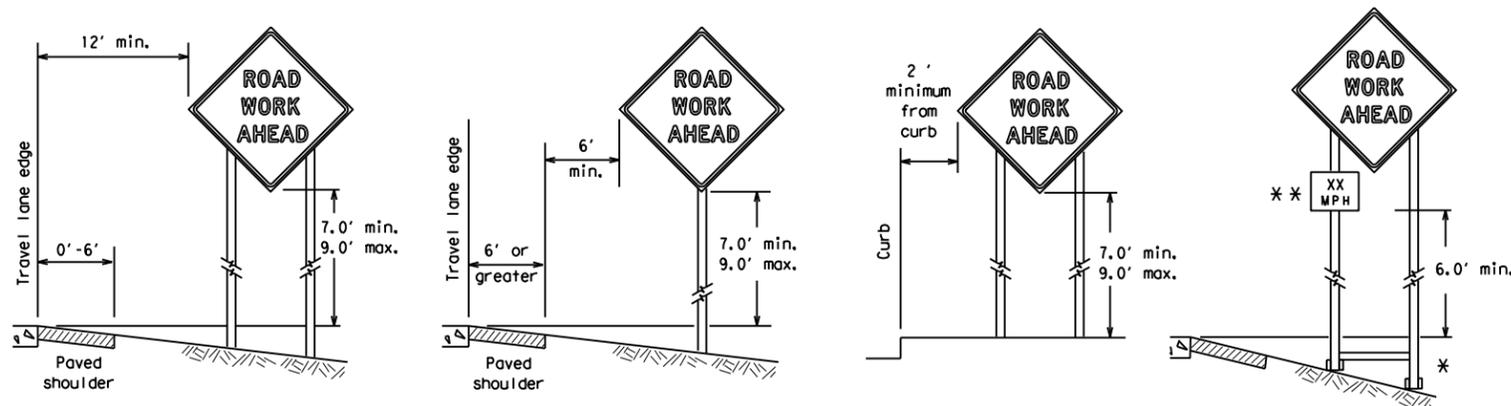

* When placing skid supports on unlevel ground, the leg post lengths must be adjusted so the sign appears straight and plumb. Objects shall NOT be placed under skids as a means of leveling.

** When plaques are placed on dual-leg supports, they should be attached to the upright nearest the travel lane. Supplemental plaques (advisory or distance) should not cover the surface of the parent sign.

ATTACHMENT FOR SIGN SUPPORTS

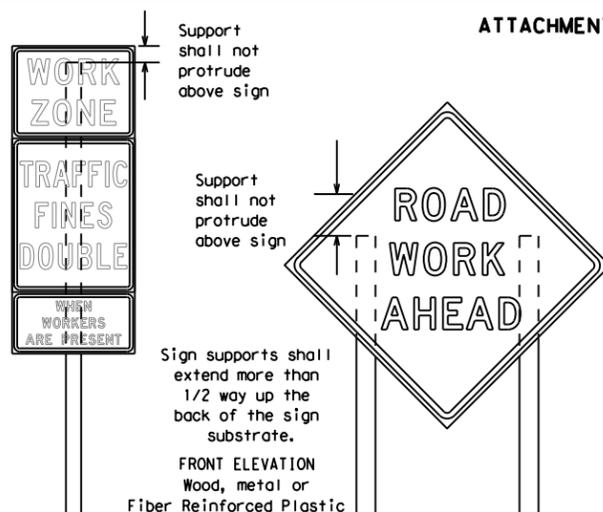


Support shall not protrude above sign

Support shall not protrude above sign

Sign supports shall extend more than 1/2 way up the back of the sign substrate.

FRONT ELEVATION
Wood, metal or
Fiber Reinforced Plastic

Attachment to wooden supports will be by bolts and nuts or screws. Use TxDOT's or manufacturer's recommended procedures for attaching sign substrates to other types of sign supports

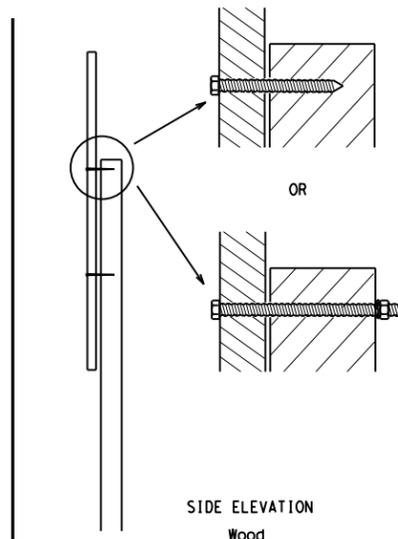


Nails shall NOT be allowed.
Each sign shall be attached directly to the sign support. Multiple signs shall not be joined or spliced by any means. Wood supports shall not be extended or repaired by splicing or other means.

Splicing embedded perforated square metal tubing in order to extend post height will only be allowed when the splice is made using four bolts, two above and two below the splice point. Splice must be located entirely behind the sign substrate, not near the base of the support. Splice insert lengths should be at least 5 times nominal post size, centered on the splice and of at least the same gauge material.

STOP/SLOW PADDLES

1. STOP/SLOW paddles are the primary method to control traffic by flaggers. The STOP/SLOW paddle size should be 24" x 24" as detailed below.
2. When used at night, the STOP/SLOW paddle shall be retroreflectORIZED.
3. STOP/SLOW paddles may be attached to a staff with a minimum length of 6' to the bottom of the sign.
4. Any lights incorporated into the STOP or SLOW paddle faces shall only be as specifically described in Section 6E.03 Hand Signaling Devices in the TMUTCD.

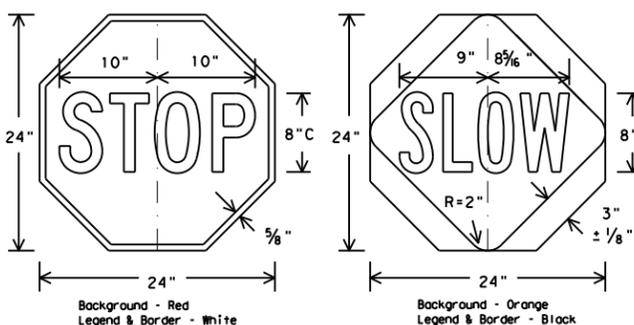

Background - Red
Legend & Border - White

Background - Orange
Legend & Border - Black

CONTRACTOR REQUIREMENTS FOR MAINTAINING PERMANENT SIGNS WITHIN THE PROJECT LIMITS

1. Permanent signs are used to give notice of traffic laws or regulations, call attention to conditions that are potentially hazardous to traffic operations, show route designations, destinations, directions, distances, services, points of interest, and other geographical, recreational, or cultural information. Drivers proceeding through a work zone need the same, if not better route guidance as normally installed on a roadway without construction.
2. When permanent regulatory or warning signs conflict with work zone conditions, remove or cover the permanent signs until the permanent sign message matches the roadway condition.
3. When existing permanent signs are moved and relocated due to construction purposes, they shall be visible to motorists at all times.
4. If existing signs are to be relocated on their original supports, they shall be installed on crashworthy bases as shown on the SMD Standard sheets. The signs shall meet the required mounting heights shown on the BC Sheets or the SMD Standards. This work should be paid for under the appropriate pay item for relocating existing signs.
5. If permanent signs are to be removed and relocated using temporary supports, the Contractor shall use crashworthy supports as shown on the BC sheets or the CWZTCD. The signs shall meet the required mounting heights shown on the BC Sheets or the SMD Standards during construction. This work should be paid for under the appropriate pay item for relocating existing signs.
6. Any sign or traffic control device that is struck or damaged by the Contractor or his/her construction equipment shall be replaced as soon as possible by the Contractor to ensure proper guidance for the motorists. This will be subsidiary to Item 502.

GENERAL NOTES FOR WORK ZONE SIGNS

1. Contractor shall install and maintain signs in a straight and plumb condition and/or as directed by the Engineer.
 2. Wooden sign posts shall be painted white.
 3. Barricades shall NOT be used as sign supports.
 4. All signs shall be installed in accordance with the plans or as directed by the Engineer. Signs shall be used to regulate, warn, and guide the traveling public safely through the work zone.
 5. The Contractor may furnish either the sign design shown in the plans or in the "Standard Highway Sign Designs for Texas" (SHSD). The Engineer/Inspector may require the Contractor to furnish other work zone signs that are shown in the TMUTCD but may have been omitted from the plans. Any variation in the plans shall be documented by written agreement between the Engineer and the Contractor's Responsible Person. All changes must be documented in writing before being implemented. This can include documenting the changes in the Inspector's TxDOT diary and having both the Inspector and Contractor initial and date the agreed upon changes.
 6. The Contractor shall furnish sign supports listed in the "Compliant Work Zone Traffic Control Device List" (CWZTCD). The Contractor shall install the sign support in accordance with the manufacturer's recommendations. If there is a question regarding installation procedures, the Contractor shall furnish the Engineer a copy of the manufacturer's installation recommendations so the Engineer can verify the correct procedures are being followed.
 7. The Contractor is responsible for installing signs on approved supports and replacing signs with damaged or cracked substrates and/or damaged or marred reflective sheeting as directed by the Engineer/Inspector.
 8. Identification markings may be shown only on the back of the sign substrate. The maximum height of letters and/or company logos used for identification shall be 1 inch.
 9. The Contractor shall replace damaged wood posts. New or damaged wood sign posts shall not be spliced.
- DURATION OF WORK (as defined by the "Texas Manual on Uniform Traffic Control Devices" Part 6)**
1. The types of sign supports, sign mounting height, the size of signs, and the type of sign substrates can vary based on the type of work being performed. The Engineer is responsible for selecting the appropriate size sign for the type of work being performed. The Contractor is responsible for ensuring the sign support, sign mounting height and substrate meets manufacturer's recommendations in regard to crashworthiness and duration of work requirements.
 - a. Long-term stationary - work that occupies a location more than 3 days.
 - b. Intermediate-term stationary - work that occupies a location more than one daylight period up to 3 days, or nighttime work lasting more than one hour.
 - c. Short-term stationary - daytime work that occupies a location for more than 1 hour in a single daylight period.
 - d. Short, duration - work that occupies a location up to 1 hour.
 - e. Mobile - work that moves continuously or intermittently (stopping for up to approximately 15 minutes.)

SIGN MOUNTING HEIGHT

1. The bottom of Long-term/Intermediate-term signs shall be at least 7 feet, but not more than 9 feet, above the paved surface, except as shown for supplemental plaques mounted below other signs.
2. The bottom of Short-term/Short Duration signs shall be a minimum of 1 foot above the pavement surface but no more than 2 feet above the ground.
3. Long-term/Intermediate-term Signs may be used in lieu of Short-term/Short Duration signing.
4. Short-term/Short Duration signs shall be used only during daylight and shall be removed at the end of the workday or raised to appropriate Long-term/Intermediate sign height.
5. Regulatory signs shall be mounted at least 7 feet, but not more than 9 feet, above the paved surface regardless of work duration.

SIZE OF SIGNS

1. The Contractor shall furnish the sign sizes shown on BC (2) unless otherwise shown in the plans or as directed by the Engineer.

SIGN SUBSTRATES

1. The Contractor shall ensure the sign substrate is installed in accordance with the manufacturer's recommendations for the type of sign support that is being used. The CWZTCD lists each substrate that can be used on the different types and models of sign supports.
2. "Mesh" type materials are NOT an approved sign substrate, regardless of the tightness of the weave.
3. All wooden individual sign panels fabricated from 2 or more pieces shall have one or more plywood cleat, 1/2" thick by 6" wide, fastened to the back of the sign and extending fully across the sign. The cleat shall be attached to the back of the sign using wood screws that do not penetrate the face of the sign panel. The screws shall be placed on both sides of the splice and spaced at 6" centers. The Engineer may approve other methods of splicing the sign face.

REFLECTIVE SHEETING

1. All signs shall be retroreflective and constructed of sheeting meeting the color and retro-reflectivity requirements of DMS-8300 for rigid signs or DMS-8310 for roll-up signs. The web address for DMS specifications is shown on BC(1).
2. White sheeting, meeting the requirements of DMS-8300 Type A, shall be used for signs with a white background.
3. Orange sheeting, meeting the requirements of DMS-8300 Type B_{FL} or Type C_{FL}, shall be used for rigid signs with orange backgrounds.

SIGN LETTERS

1. All sign letters and numbers shall be clear, and open rounded type uppercase alphabet letters as approved by the Federal Highway Administration (FHWA) and as published in the "Standard Highway Sign Design for Texas" manual. Signs, letters and numbers shall be of first class workmanship in accordance with Department Standards and Specifications.

REMOVING OR COVERING

1. When sign messages may be confusing or do not apply, the signs shall be removed or completely covered.
2. Long-term stationary or intermediate stationary signs installed on square metal tubing may be turned away from traffic 90 degrees when the sign message is not applicable. This technique may not be used for signs installed in the median of divided highways or near any intersections where the sign may be seen from approaching traffic.
3. Signs installed on wooden skids shall not be turned at 90 degree angles to the roadway. These signs should be removed or completely covered when not required.
4. When signs are covered, the material used shall be opaque, such as heavy mil black plastic, or other materials which will cover the entire sign face and maintain their opaque properties under automobile headlights at night, without damaging the sign sheeting.
5. Burlap shall NOT be used to cover signs.
6. Duct tape or other adhesive material shall NOT be affixed to a sign face.
7. Signs and anchor stubs shall be removed and holes backfilled upon completion of work.

SIGN SUPPORT WEIGHTS

1. Where sign supports require the use of weights to keep from turning over, the use of sandbags with dry, cohesionless sand should be used.
2. The sandbags will be tied shut to keep the sand from spilling and to maintain a constant weight.
3. Rock, concrete, iron, steel or other solid objects shall not be permitted for use as sign support weights.
4. Sandbags should weigh a minimum of 35 lbs and a maximum of 50 lbs.
5. Sandbags shall be made of a durable material that tears upon vehicular impact. Rubber (such as tire inner tubes) shall NOT be used.
6. Rubber ballasts designed for channelizing devices should not be used for ballast on portable sign supports. Sign supports designed and manufactured with rubber bases may be used when shown on the CWZTCD list.
7. Sandbags shall only be placed along or laid over the base supports of the traffic control device and shall not be suspended above ground level or hung with rope, wire, chains or other fasteners. Sandbags shall be placed along the length of the skids to weigh down the sign support.
8. Sandbags shall NOT be placed under the skid and shall not be used to level sign supports placed on slopes.

FLAGS ON SIGNS

1. Flags may be used to draw attention to warning signs. When used the flag shall be 16 inches square or larger and shall be orange or fluorescent red-orange in color. Flags shall not be allowed to cover any portion of the sign face.

SHEET 4 OF 12



BARRICADE AND CONSTRUCTION TEMPORARY SIGN NOTES

BC (4) - 14


FILE:	bc-14.dgn	DN:	TxDOT	CK:	TxDOT	DW:	TxDOT	CR:	TxDOT
© TxDOT	November 2002	CONT	SECT	JOB	HIGHWAY				
REVISIONS		0111	01	095	FM 521				
9-07	8-14	DIST	COUNTY	SHEET NO.					
7-13		HOU	HARRIS	15					

DISCLAIMER: The use of this standard is governed by the "Texas Engineering Practice Act". No warranty of any kind is made by TxDOT for any purpose whatsoever. TxDOT assumes no responsibility for the conversion of this standard to other formats or for incorrect results or damages resulting from its use.


DATE: 9/18/2020 12:10:08 AM
FILE: T:\HUM-AO\Design\Roadway\FM 521\0111-01--095\NGN\CP\12-23 BC(1)-14.dgn

DISCLAIMER: The use of this standard is governed by the "Texas Engineering Practice Act". No warranty of any kind is made by TxDOT for any purpose whatsoever. TxDOT assumes no responsibility for the conversion of this standard to other formats or for incorrect results or damages resulting from its use.

DATE: 9/18/2020 12:10:28 AM
 FILE: T:\HUM-AO\Design\Roadway\FM_521\0111-01-095\DGN\TYP\12-23_BC(1)-14.dgn

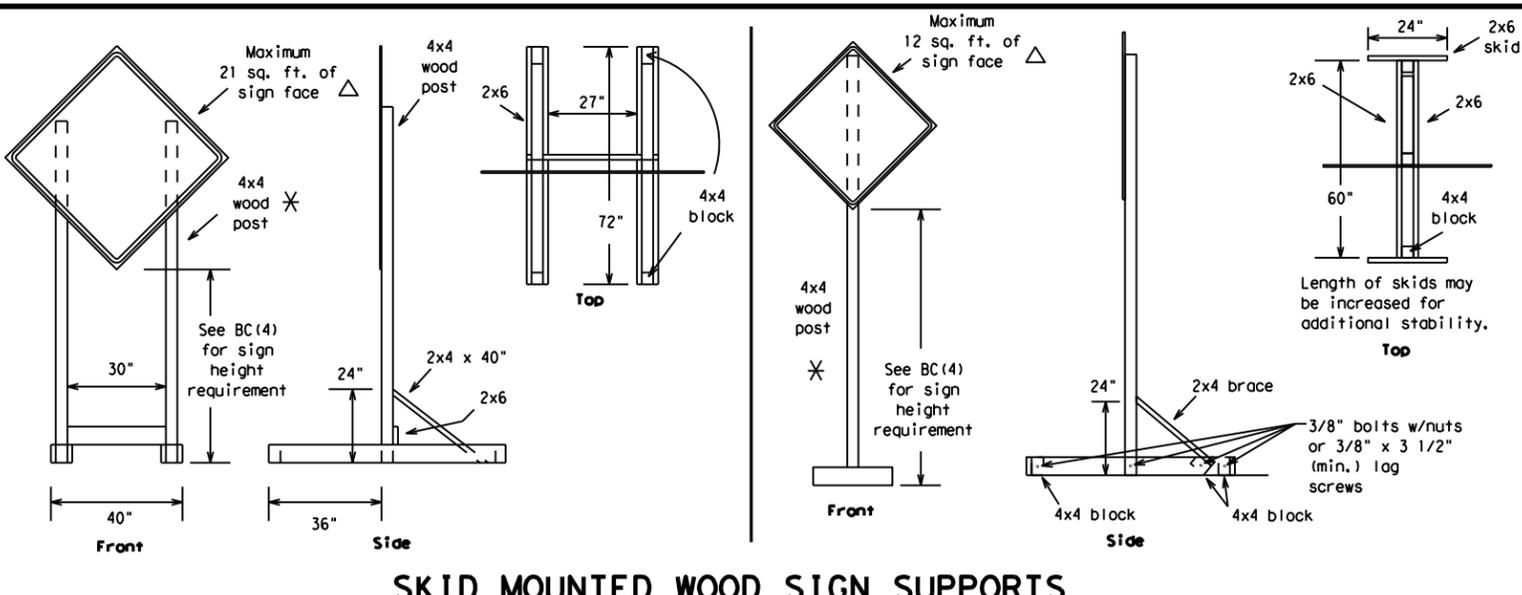


SKID MOUNTED WOOD SIGN SUPPORTS
 LONG/INTERMEDIATE TERM STATIONARY - PORTABLE SKID MOUNTED SIGN SUPPORTS □

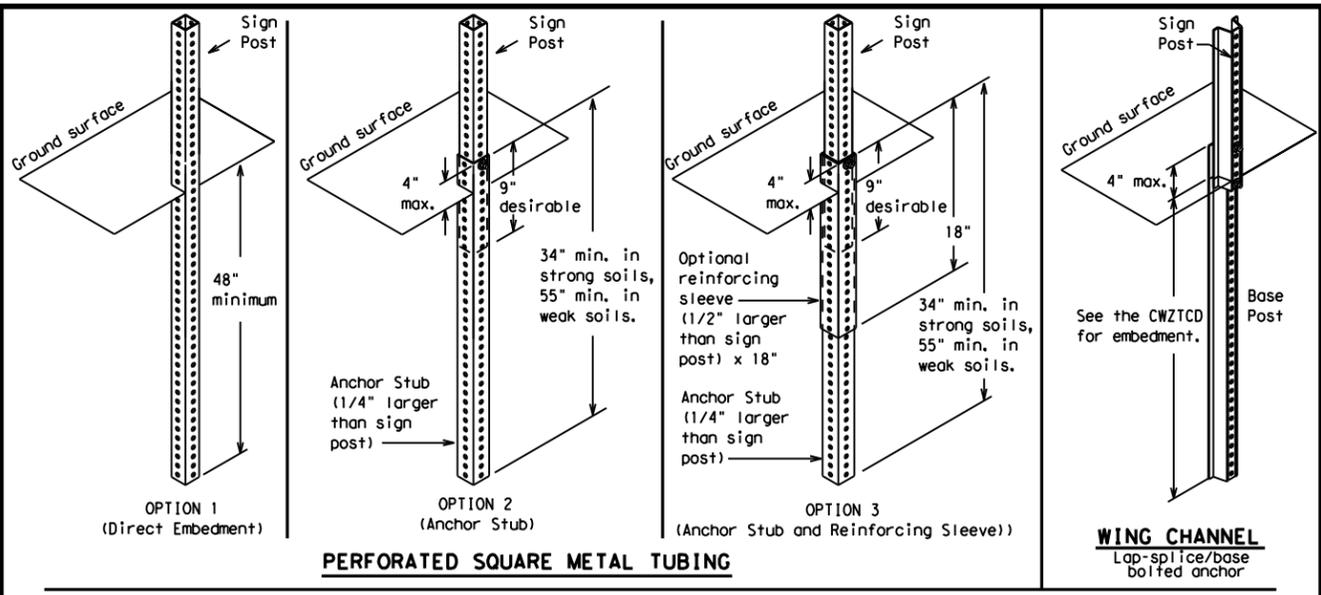


GROUND MOUNTED SIGN SUPPORTS

Refer to the CWZTCD and the manufacturer's installation procedure for each type sign support. The maximum sign square footage shall adhere to the manufacturer's recommendation. Two post installations can be used for larger signs.

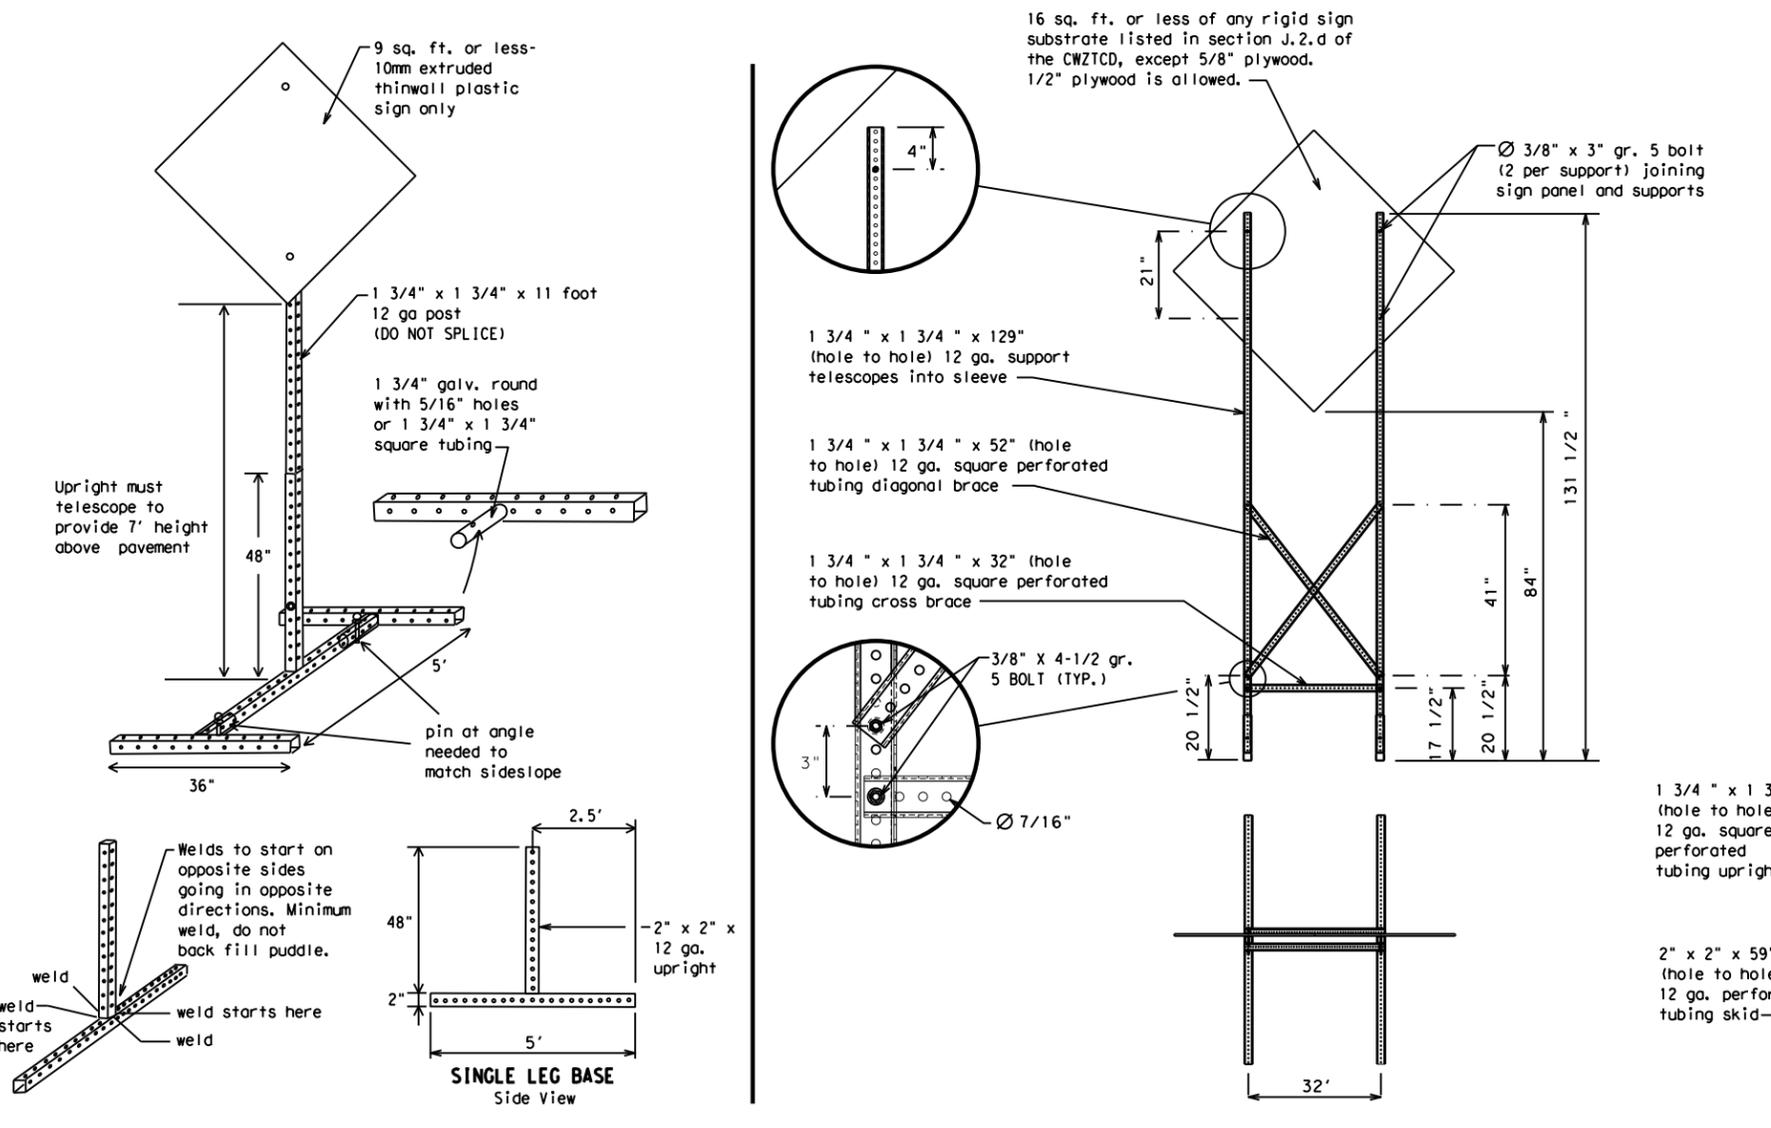

SKID MOUNTED PERFORATED SQUARE STEEL TUBING SIGN SUPPORTS

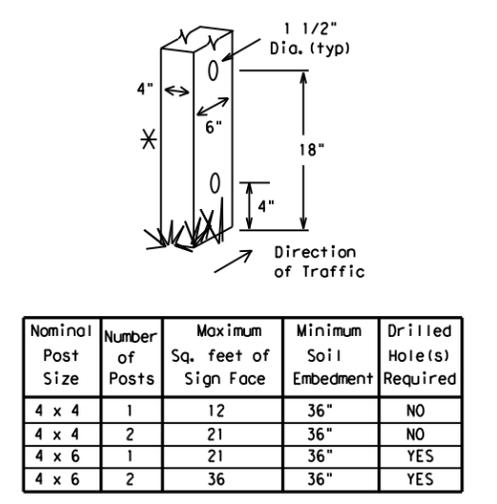

WOOD POST SYSTEM FOR GROUND MOUNTED SIGN SUPPORTS

Nominal Post Size	Number of Posts	Maximum Sq. feet of Sign Face	Minimum Soil Embedment	Drilled Hole(s) Required
4 x 4	1	12	36"	NO
4 x 4	2	21	36"	NO
4 x 6	1	21	36"	YES
4 x 6	2	36	36"	YES

WEDGE ANCHORS
 Both steel and plastic Wedge Anchor Systems as shown on the SMD Standard Sheets may be used as temporary sign supports for signs up to 10 square feet of sign face. They may be set in concrete or in sturdy soils if approved by the Engineer. (See web address for "Traffic Engineering Standard Sheets" on BC(1)).

OTHER DESIGNS
 MORE DETAILS OF APPROVED LONG/INTERMEDIATE AND SHORT TERM SUPPORTS CAN BE FOUND ON THE CWZTCD LIST. SEE BC(1) FOR WEBSITE LOCATION.

- GENERAL NOTES**
- Nails may be used in the assembly of wooden sign supports, but 3/8" bolts with nuts or 3/8" x 3 1/2" lag screws must be used on every joint for final connection.
 - No more than 2 sign posts shall be placed within a 7 ft. circle, except for specific materials noted on the CWZTCD List.
 - When project is completed, all sign supports and foundations shall be removed from the project site. This will be considered subsidiary to Item 502.

- See BC(4) for definition of "Work Duration."
- * Wood sign posts MUST be one piece. Splicing will NOT be allowed. Posts shall be painted white.
- △ See the CWZTCD for the type of sign substrate that can be used for each approved sign support.

BARRICADE AND CONSTRUCTION TYPICAL SIGN SUPPORT

BC(5) - 14

FILE: bc-14.dgn	DW: TxDOT	CK: TxDOT	DW: TxDOT	CK: TxDOT
© TxDOT November 2002	CONT	SECT	JOB	HIGHWAY
REVISIONS	0111	01	095	FM 521
9-07 8-14	DIST	COUNTY	SHEET NO.	
7-13	HOU	HARRIS	16	

WHEN NOT IN USE, REMOVE THE PCMS FROM THE RIGHT-OF-WAY OR PLACE THE PCMS BEHIND BARRIER OR GUARDRAIL WITH SIGN PANEL TURNED PARALLEL TO TRAFFIC

RECOMMENDED PHASES AND FORMATS FOR PCMS MESSAGES DURING ROADWORK ACTIVITIES

(The Engineer may approve other messages not specifically covered here.)

PORTABLE CHANGEABLE MESSAGE SIGNS

- The Engineer/Inspector shall approve all messages used on portable changeable message signs (PCMS).
- Messages on PCMS should contain no more than 8 words (about four to eight characters per word), not including simple words such as "TO," "FOR," "AT," etc.
- Messages should consist of a single phase, or two phases that alternate. Three-phase messages are not allowed. Each phase of the message should convey a single thought, and must be understood by itself.
- Use the word "EXIT" to refer to an exit ramp on a freeway; i.e., "EXIT CLOSED." Do not use the term "RAMP."
- Always use the route or interstate designation (IH, US, SH, FM) along with the number when referring to a roadway.
- When in use the bottom of a stationary PCMS message panel should be a minimum 7 feet above the roadway, where possible.
- The message term "WEEKEND" should be used only if the work is to start on Saturday morning and end by Sunday evening at midnight. Actual days and hours of work should be displayed on the PCMS if work is to begin on Friday evening and/or continue into Monday morning.
- The Engineer/Inspector may select one of two options which are available for displaying a two-phase message on a PCMS. Each phase may be displayed for either four seconds each or for three seconds each.
- Do not "flash" messages or words included in a message. The message should be steady burn or continuous while displayed.
- Do not present redundant information on a two-phase message; i.e., keeping two lines of the message the same and changing the third line.
- Do not use the word "Danger" in message.
- Do not display the message "LANES SHIFT LEFT" or "LANES SHIFT RIGHT" on a PCMS. Drivers do not understand the message.
- Do not display messages that scroll horizontally or vertically across the face of the sign.
- The following table lists abbreviated words and two-word phrases that are acceptable for use on a PCMS. Both words in a phrase must be displayed together. Words or phrases not on this list should not be abbreviated, unless shown in the TMUTCD.
- PCMS character height should be at least 18 inches for trailer mounted units. They should be visible from at least 1/2 (.5) mile and the text should be legible from at least 600 feet at night and 800 feet in daylight. Truck mounted units must have a character height of 10 inches and must be legible from at least 400 feet.
- Each line of text should be centered on the message board rather than left or right justified.
- If disabled, the PCMS should default to an illegible display that will not alarm motorists and will only be used to alert workers that the PCMS has malfunctioned. A pattern such as a series of horizontal solid bars is appropriate.

Phase 1: Condition Lists

Road/Lane/Ramp Closure List

FREEWAY CLOSED X MILE	FRONTAGE ROAD CLOSED
ROAD CLOSED AT SH XXX	SHOULDER CLOSED XXX FT
ROAD CLSD AT FM XXXX	RIGHT LN CLOSED XXX FT
RIGHT X LANES CLOSED	RIGHT X LANES OPEN
CENTER LANE CLOSED	DAYTIME LANE CLOSURES
NIGHT LANE CLOSURES	I-XX SOUTH EXIT CLOSED
VARIOUS LANES CLOSED	EXIT XXX CLOSED X MILE
EXIT CLOSED	RIGHT LN TO BE CLOSED
MALL DRIVEWAY CLOSED	X LANES CLOSED TUE - FRI
XXXXXXXX BLVD CLOSED	

Other Condition List

ROADWORK XXX FT	ROAD REPAIRS XXXX FT
FLAGGER XXXX FT	LANE NARROWS XXXX FT
RIGHT LN NARROWS XXXX FT	TWO-WAY TRAFFIC XX MILE
MERGING TRAFFIC XXXX FT	CONST TRAFFIC XXX FT
LOOSE GRAVEL XXXX FT	UNEVEN LANES XXXX FT
DETOUR X MILE	ROUGH ROAD XXXX FT
ROADWORK PAST SH XXXX	ROADWORK NEXT FRI-SUN
BUMP XXXX FT	US XXX EXIT X MILES
TRAFFIC SIGNAL XXXX FT	LANES SHIFT *

* LANES SHIFT in Phase 1 must be used with STAY IN LANE in Phase 2.

Phase 2: Possible Component Lists

Action to Take/Effect on Travel List

MERGE RIGHT	FORM X LINES RIGHT
DETOUR NEXT X EXITS	USE XXXXX RD EXIT
USE EXIT XXX	USE EXIT I-XX NORTH
STAY ON US XXX SOUTH	USE I-XX E TO I-XX N
TRUCKS USE US XXX N	WATCH FOR TRUCKS
WATCH FOR TRUCKS	EXPECT DELAYS
EXPECT DELAYS	PREPARE TO STOP
REDUCE SPEED XXX FT	END SHOULDER USE
USE OTHER ROUTES	WATCH FOR WORKERS
STAY IN LANE *	

Location List

AT FM XXXX
BEFORE RAILROAD CROSSING
NEXT X MILES
PAST US XXX EXIT
XXXXXXXX TO XXXXXX
US XXX TO FM XXXX

Warning List

SPEED LIMIT XX MPH
MAXIMUM SPEED XX MPH
MINIMUM SPEED XX MPH
ADVISORY SPEED XX MPH
RIGHT LANE EXIT
USE CAUTION
DRIVE SAFELY
DRIVE WITH CARE

** Advance Notice List

TUE-FRI XX AM-X PM
APR XX-XX X PM-X AM
BEGINS MONDAY
BEGINS MAY XX
MAY X-X XX PM - XX AM
NEXT FRI-SUN
XX AM TO XX PM
NEXT TUE AUG XX
TONIGHT XX PM-XX AM

** See Application Guidelines Note 6.

APPLICATION GUIDELINES

- Only 1 or 2 phases are to be used on a PCMS.
- The 1st phase (or both) should be selected from the "Road/Lane/Ramp Closure List" and the "Other Condition List".
- A 2nd phase can be selected from the "Action to Take/Effect on Travel, Location, General Warning, or Advance Notice Phase Lists".
- A Location Phase is necessary only if a distance or location is not included in the first phase selected.
- If two PCMS are used in sequence, they must be separated by a minimum of 1000 ft. Each PCMS shall be limited to two phases, and should be understandable by themselves.
- For advance notice, when the current date is within seven days of the actual work date, calendar days should be replaced with days of the week. Advance notification should typically be for no more than one week prior to the work.

WORDING ALTERNATIVES

- The words RIGHT, LEFT and ALL can be interchanged as appropriate.
- Roadway designations IH, US, SH, FM and LP can be interchanged as appropriate.
- EAST, WEST, NORTH and SOUTH (or abbreviations E, W, N and S) can be interchanged as appropriate.
- Highway names and numbers replaced as appropriate.
- ROAD, HIGHWAY and FREEWAY can be interchanged as needed.
- AHEAD may be used instead of distances if necessary.
- FT and MI, MILE and MILES interchanged as appropriate.
- AT, BEFORE and PAST interchanged as needed.
- Distances or AHEAD can be eliminated from the message if a location phase is used.

PCMS SIGNS WITHIN THE R.O.W. SHALL BE BEHIND GUARDRAIL OR CONCRETE BARRIER OR SHALL HAVE A MINIMUM OF FOUR (4) PLASTIC DRUMS PLACED PERPENDICULAR TO TRAFFIC ON THE UPSTREAM SIDE OF THE PCMS, WHEN EXPOSED TO ONE DIRECTION OF TRAFFIC. WHEN EXPOSED TO TWO WAY TRAFFIC, THE FOUR DRUMS SHOULD BE PLACED WITH ONE DRUM AT EACH OF THE FOUR CORNERS OF THE UNIT.

FULL MATRIX PCMS SIGNS

- When Full Matrix PCMS signs are used, the character height and legibility/visibility requirements shall be maintained as listed in Note 15 under "PORTABLE CHANGEABLE MESSAGE SIGNS" above.
- When symbol signs, such as the "Flagger Symbol" (CW20-7) are represented graphically on the Full Matrix PCMS sign and, with the approval of the Engineer, it shall maintain the legibility/visibility requirement listed above.
- When symbol signs are represented graphically on the Full Matrix PCMS, they shall only supplement the use of the static sign represented, and shall not substitute for, or replace that sign.
- A full matrix PCMS may be used to simulate a flashing arrow board provided it meets the visibility, flash rate and dimming requirements on BC(7), for the same size arrow.

DISCLAIMER: The use of this standard is governed by the "Texas Engineering Practice Act". No warranty of any kind is made by TxDOT for any purpose whatsoever. TxDOT assumes no responsibility for the conversion of this standard to other formats or for incorrect results or damages resulting from its use.

DATE: 9/18/2020 12:10:51 AM
FILE: T:\HUM-AO\Design\Roadway\FM 521\0111-01-095\DGN\CP\12-23 BC(1)-14.dgn

WORD OR PHRASE	ABBREVIATION	WORD OR PHRASE	ABBREVIATION
Access Road	ACCS RD	Major	MAJ
Alternate	ALT	Miles	MI
Avenue	AVE	Miles Per Hour	MPH
Best Route	BEST RTE	Minor	MNR
Boulevard	BLVD	Monday	MON
Bridge	BRDG	Normal	NORM
Canal	CANT	North	N
Center	CTR	Northbound	(route) N
Construction Ahead	CONST AHD	Parking	PKING
CROSSING	XING	Road	RD
Detour Route	DETOUR RTE	Right Lane	RT LN
Do Not	DONT	Saturday	SAT
East	E	Service Road	SERV RD
Eastbound	(route) E	Shoulder	SHLDR
Emergency	EMER	Slippery	SLIP
Emergency Vehicle	EMER VEH	South	S
Entrance, Enter	ENT	Southbound	(route) S
Express Lane	EXP LN	Speed	SPD
Expressway	EXPWY	Street	ST
XXXX Feet	XXXX FT	Sunday	SUN
Fog Ahead	FOG AHD	Telephone	PHONE
Freeway	FRWY, FWY	Temporary	TEMP
Freeway Blocked	FWY BLKD	Thursday	THURS
Friday	FRI	To Downtown	TO DWNTN
Hazardous Driving	HAZ DRIVING	Traffic	TRAF
Hazardous Material	HAZMAT	Travelers	TRVLR
High-Occupancy Vehicle	HOV	Tuesday	TUES
Highway	HWY	Time Minutes	TIME MIN
Hour(s)	HR, HRS	Upper Level	UPR LEVEL
Information	INFO	Vehicles (s)	VEH, VEHS
It Is	ITS	Warning	WARN
Junction	JCT	Wednesday	WED
Left	LFT	Weight Limit	WT LIMIT
Left Lane	LFT LN	West	W
Lane Closed	LN CLOSED	Westbound	(route) W
Lower Level	LWR LEVEL	Wet Pavement	WET PVMT
Maintenance	MAINT	Will Not	WONT


Roadway designation # IH-number, US-number, SH-number, FM-number

<h3>BARRICADE AND CONSTRUCTION PORTABLE CHANGEABLE MESSAGE SIGN (PCMS)</h3>			
<h2>BC (6) - 14</h2>			
FILE:	bc-14.dgn	DW:	TxDOT
CONT:	0111	SECT:	01
JOB:	095	REVISIONS:	FM 521
DATE:	9-07 8-14	DIST:	COUNTY
DATE:	7-13	HOU:	HARRIS
		SHEET NO.:	17


DISCLAIMER: The use of this standard is governed by the "Texas Engineering Practice Act". No warranty of any kind is made by TxDOT for any purpose whatsoever. TxDOT assumes no responsibility for the conversion of this standard to other formats or for incorrect results or damages resulting from its use.

DATE: 9/18/2020 12:11:12 AM
 FILE: T:\HUM-AO\Design\Roadway\FM_521\0111-01-095\06\GN\CP\12-23_BC(11)-14.dgn

- Barrier Reflectors shall be pre-qualified, and conform to the color and reflectivity requirements of DMS-8600. A list of prequalified Barrier Reflectors can be found at the Material Producer List web address shown on BC(1).
- Color of Barrier Reflectors shall be as specified in the TMUTCD. The cost of the reflectors shall be considered subsidiary to Item 512.

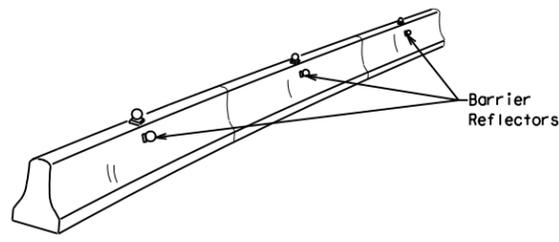


CONCRETE TRAFFIC BARRIER (CTB)

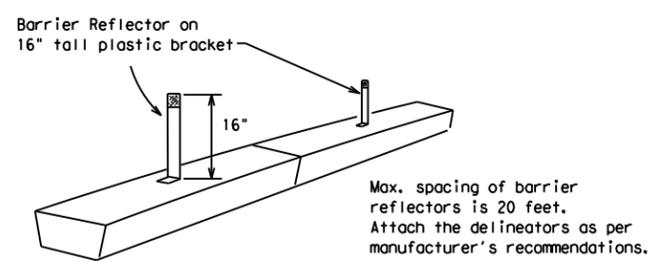

LOW PROFILE CONCRETE BARRIER (LPCB)

- Where traffic is on one side of the CTB, two (2) Barrier Reflectors shall be mounted in approximately the midsection of each section of CTB. An alternate mounting location is uniformly spaced at one end of each CTB. This will allow for attachment of a barrier grapple without damaging the reflector. The Barrier Reflector mounted on the side of the CTB shall be located directly below the reflector mounted on top of the barrier, as shown in the detail above.
- Where CTB separates two-way traffic, three barrier reflectors shall be mounted on each section of CTB. The reflector unit on top shall have two yellow reflective faces (Bi-Directional) while the reflectors on each side of the barrier shall have one yellow reflective face, as shown in the detail above.
- When CTB separates traffic traveling in the same direction, no barrier reflectors will be required on top of the CTB.
- Barrier Reflector units shall be yellow or white in color to match the edgeline being supplemented.
- Maximum spacing of Barrier Reflectors is forty (40) feet.
- Pavement markers or temporary flexible-reflective roadway marker tabs shall NOT be used as CTB delineation.
- Attachment of Barrier Reflectors to CTB shall be per manufacturer's recommendations.
- Missing or damaged Barrier Reflectors shall be replaced as directed by the Engineer.
- Single slope barriers shall be delineated as shown on the above detail.

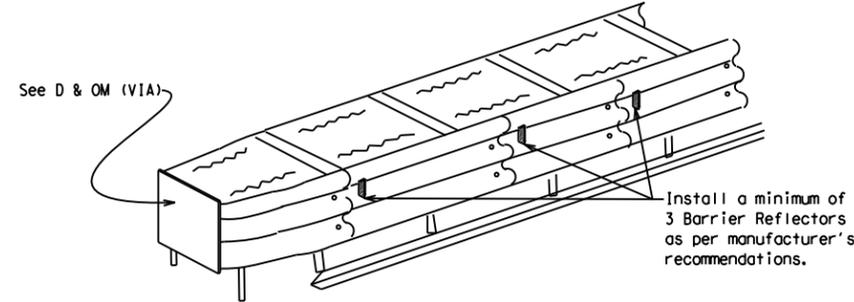

DELINEATION OF END TREATMENTS

END TREATMENTS FOR CTB'S USED IN WORK ZONES

End treatments used on CTB's in work zones shall meet crashworthy standards as defined in the National Cooperative Highway Research Report 350. Refer to the CWZTCD List for approved end treatments and manufacturers.

BARRIER REFLECTORS FOR CONCRETE TRAFFIC BARRIER AND ATTENUATORS

WARNING LIGHTS


- Warning lights shall meet the requirements of the TMUTCD.
- Warning lights shall NOT be installed on barricades.
- Type A-Low Intensity Flashing Warning Lights are commonly used with drums. They are intended to warn of or mark a potentially hazardous area. Their use shall be as indicated on this sheet and/or other sheets of the plans by the designation "FL". The Type A Warning Lights shall not be used with signs manufactured with Type B_{FL} or C_{FL} Sheeting meeting the requirements of Departmental Material Specification DMS-8300.
- Type-C and Type D 360 degree Steady Burn Lights are intended to be used in a series for delineation to supplement other traffic control devices. Their use shall be as indicated on this sheet and/or other sheets of the plans by the designation "SB".
- The Engineer/Inspector or the plans shall specify the location and type of warning lights to be installed on the traffic control devices.
- When required by the Engineer, the Contractor shall furnish a copy of the warning lights certification. The warning light manufacturer will certify the warning lights meet the requirements of the latest ITE Purchase Specifications for Flashing and Steady-Burn Warning Lights.
- When used to delineate curves, Type-C and Type D Steady Burn Lights should only be placed on the outside of the curve, not the inside.
- The location of warning lights and warning reflectors on drums shall be as shown elsewhere in the plans.

WARNING LIGHTS MOUNTED ON PLASTIC DRUMS


- Type A flashing warning lights are intended to warn drivers that they are approaching or are in a potentially hazardous area.
- Type A random flashing warning lights are not intended for delineation and shall not be used in a series.
- A series of sequential flashing warning lights placed on channelizing devices to form a merging taper may be used for delineation. If used, the successive flashing of the sequential warning lights should occur from the beginning of the taper to the end of the merging taper in order to identify the desired vehicle path. The rate of flashing for each light shall be 65 flashes per minute, plus or minus 10 flashes.
- Type C and D steady-burn warning lights are intended to be used in a series to delineate the edge of the travel lane on detours, on lane changes, and on lane closures, and on other similar conditions.
- Type A, Type C and Type D warning lights shall be installed at locations as detailed on other sheets in the plans.
- Warning lights shall not be installed on a drum that has a sign, chevron or vertical panel.
- The maximum spacing for warning lights on drums should be identical to the channelizing device spacing.

WARNING REFLECTORS MOUNTED ON PLASTIC DRUMS AS A SUBSTITUTE FOR TYPE C (STEADY BURN) WARNING LIGHTS

- A warning reflector or approved substitute may be mounted on a plastic drum as a substitute for a Type C, steady burn warning light at the discretion of the Contractor unless otherwise noted in the plans.
- The warning reflector shall be yellow in color and shall be manufactured using a sign substrate approved for use with plastic drums listed on the CWZTCD.
- The warning reflector shall have a minimum retroreflective surface area (one-side) of 30 square inches.
- Round reflectors shall be fully reflectorized, including the area where attached to the drum.
- Square substrates must have a minimum of 30 square inches of reflectorized sheeting. They do not have to be reflectorized where it attaches to the drum.
- The side of the warning reflector facing approaching traffic shall have sheeting meeting the color and retroreflectivity requirements for DMS 8300-Type B or Type C.
- When used near two-way traffic, both sides of the warning reflector shall be reflectorized.
- The warning reflector should be mounted on the side of the handle nearest approaching traffic.
- The maximum spacing for warning reflectors should be identical to the channelizing device spacing requirements.

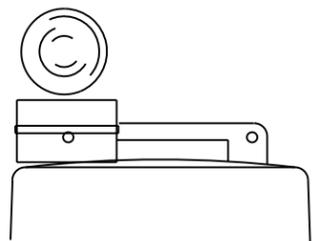


Type C Warning Light or approved substitute mounted on a drum adjacent to the travel way.

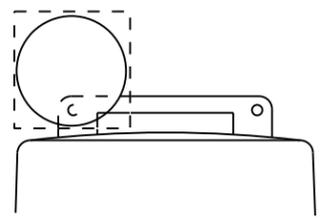

Warning reflector may be round or square. Must have a yellow reflective surface area of at least 30 square inches

Arrow Boards may be located behind channelizing devices in place for a shoulder taper or merging taper, otherwise they shall be delineated with four (4) channelizing devices placed perpendicular to traffic on the upstream side of traffic.

- The Flashing Arrow Board should be used for all lane closures on multi-lane roadways, or slow moving maintenance or construction activities on the travel lanes.
- Flashing Arrow Boards should not be used on two-lane, two-way roadways, detours, diversions or work on shoulders unless the "CAUTION" display (see detail below) is used.
- The Engineer/Inspector shall choose all appropriate signs, barricades and/or other traffic control devices that should be used in conjunction with the Flashing Arrow Board.
- The Flashing Arrow Board should be able to display the following symbols:

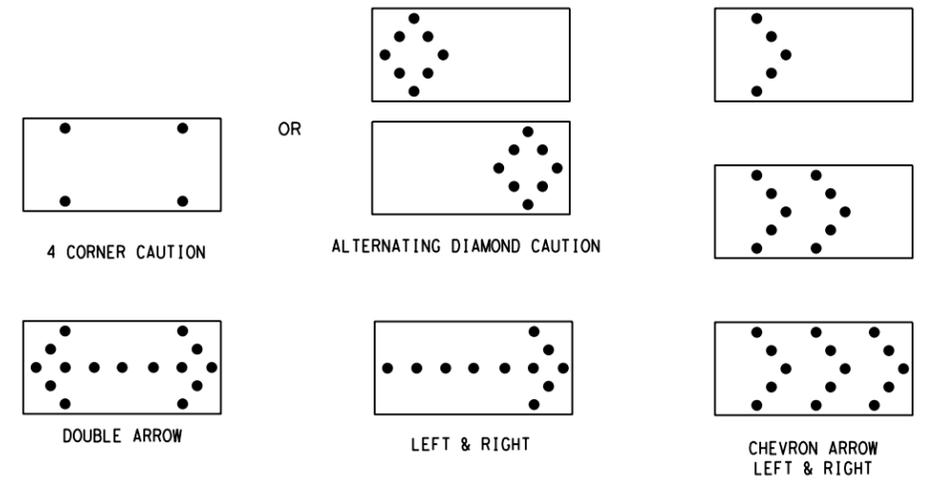

- The "CAUTION" display consists of four corner lamps flashing simultaneously, or the Alternating Diamond Caution mode as shown.
- The straight line caution display is NOT ALLOWED.
- The Flashing Arrow Board shall be capable of minimum 50 percent dimming from rated lamp voltage. The flashing rate of the lamps shall not be less than 25 nor more than 40 flashes per minute.
- Minimum lamp "on time" shall be approximately 50 percent for the flashing arrow and equal intervals of 25 percent for each sequential phase of the flashing chevron.
- The sequential arrow display is NOT ALLOWED.
- The flashing arrow display is the TxDOT standard; however, the sequential Chevron display may be used during daylight operations.
- The Flashing Arrow Board shall be mounted on a vehicle, trailer or other suitable support.
- A Flashing Arrow Board SHALL NOT BE USED to laterally shift traffic.
- A full matrix PCMS may be used to simulate a Flashing Arrow Board provided it meets visibility, flash rate and dimming requirements on this sheet for the same size arrow.
- Minimum mounting height of trailer mounted Arrow Boards should be 7 feet from roadway to bottom of panel.

REQUIREMENTS			
TYPE	MINIMUM SIZE	MINIMUM NUMBER OF PANEL LAMPS	MINIMUM VISIBILITY DISTANCE
B	30 x 60	13	3/4 mile
C	48 x 96	15	1 mile

ATTENTION

Flashing Arrow Boards shall be equipped with automatic dimming devices.

WHEN NOT IN USE, REMOVE THE ARROW BOARD FROM THE RIGHT-OF-WAY OR PLACE THE ARROW BOARD BEHIND CONCRETE TRAFFIC BARRIER OR GUARDRAIL.

FLASHING ARROW BOARDS

SHEET 7 OF 12

TRUCK-MOUNTED ATTENUATORS

- Truck-mounted attenuators (TMA) used on TxDOT facilities must meet the requirements outlined in the National Cooperative Highway Research Report No. 350 (NCHRP 350) or the Manual for Assessing Safety Hardware (MASH).
- Refer to the CWZTCD for the requirements of Level 2 or Level 3 TMAs.
- Refer to the CWZTCD for a list of approved TMAs.
- TMAs are required on freeways unless otherwise noted in the plans.
- A TMA should be used anytime that it can be positioned 30 to 100 feet in advance of the area of crew exposure without adversely affecting the work performance.
- The only reason a TMA should not be required is when a work area is spread down the roadway and the work crew is an extended distance from the TMA.



BARRICADE AND CONSTRUCTION ARROW PANEL, REFLECTORS, WARNING LIGHTS & ATTENUATOR

BC (7) - 14

FILE:	bc-14.dgn	DN:	TxDOT	CR:	TxDOT	OW:	TxDOT	CK:	TxDOT
© TxDOT	November 2002	CONT	SECT	JOB	HIGHWAY				
REVISIONS		0111	01	095	FM 521				
9-07	8-14	DIST	COUNTY	SHEET NO.					
7-13		HOU	HARRIS	18					

DISCLAIMER: The use of this standard is governed by the "Texas Engineering Practice Act". No warranty of any kind is made by TxDOT for any purpose whatsoever. TxDOT assumes no responsibility for the conversion of this standard to other formats or for incorrect results or damages resulting from its use.

DATE: 9/18/2020 12:11:30 AM
 FILE: T:\HUM-AO\Design\Roadway\FM_521\0111-01--095\DGN\TCP\12-23 BC(11)-14 TO BC(12)-14.dgn

GENERAL NOTES

- For long term stationary work zones on freeways, drums shall be used as the primary channelizing device.
- For intermediate term stationary work zones on freeways, drums should be used as the primary channelizing device but may be replaced in tangent sections by vertical panels, or 42" two-piece cones. In tangent sections one-piece cones may be used with the approval of the Engineer but only if personnel are present on the project at all times to maintain the cones in proper position and location.
- For short term stationary work zones on freeways, drums are the preferred channelizing device but may be replaced in tapers, transitions and tangent sections by vertical panels, two-piece cones or one-piece cones as approved by the Engineer.
- Drums and all related items shall comply with the requirements of the current version of the "Texas Manual on Uniform Traffic Control Devices" (TMUTCD) and the "Compliant Work Zone Traffic Control Devices List" (CWZTCD).
- Drums, bases, and related materials shall exhibit good workmanship and shall be free from objectionable marks or defects that would adversely affect their appearance or serviceability.
- The Contractor shall have a maximum of 24 hours to replace any plastic drums identified for replacement by the Engineer/Inspector. The replacement device must be an approved device.

GENERAL DESIGN REQUIREMENTS



- Pre-qualified plastic drums shall meet the following requirements:
- Plastic drums shall be a two-piece design; the "body" of the drum shall be the top portion and the "base" shall be the bottom.
 - The body and base shall lock together in such a manner that the body separates from the base when impacted by a vehicle traveling at a speed of 20 MPH or greater but prevents accidental separation due to normal handling and/or air turbulence created by passing vehicles.
 - Plastic drums shall be constructed of lightweight flexible, and deformable materials. The Contractor shall NOT use metal drums or single piece plastic drums as channelization devices or sign supports.
 - Drums shall present a profile that is a minimum of 18 inches in width at the 36 inch height when viewed from any direction. The height of drum unit (body installed on base) shall be a minimum of 36 inches and a maximum of 42 inches.
 - The top of the drum shall have a built-in handle for easy pickup and shall be designed to drain water and not collect debris. The handle shall have a minimum of two widely spaced 9/16 inch diameter holes to allow attachment of a warning light, warning reflector unit or approved compliant sign.
 - The exterior of the drum body shall have a minimum of four alternating orange and white retroreflective circumferential stripes not less than 4 inches nor greater than 8 inches in width. Any non-reflectORIZED space between any two adjacent stripes shall not exceed 2 inches in width.
 - Bases shall have a maximum width of 36 inches, a maximum height of 4 inches, and a minimum of two footholds of sufficient size to allow base to be held down while separating the drum body from the base.
 - Plastic drums shall be constructed of ultra-violet stabilized, orange, high-density polyethylene (HDPE) or other approved material.
 - Drum body shall have a maximum unballasted weight of 11 lbs.
 - Drum and base shall be marked with manufacturer's name and model number.

RETROREFLECTIVE SHEETING

- The stripes used on drums shall be constructed of sheeting meeting the color and retroreflectivity requirements of Departmental Materials Specification DMS-8300, "Sign Face Materials." Type A reflective sheeting shall be supplied unless otherwise specified in the plans.
- The sheeting shall be suitable for use on and shall adhere to the drum surface such that, upon vehicular impact, the sheeting shall remain adhered in-place and exhibit no delaminating, cracking, or loss of retroreflectivity other than that loss due to abrasion of the sheeting surface.


BALLAST

- Unballasted bases shall be large enough to hold up to 50 lbs. of sand. This base, when filled with the ballast material, should weigh between 35 lbs (minimum) and 50 lbs (maximum). The ballast may be sand in one to three sandbags separate from the base, sand in a sand-filled plastic base, or other ballasting devices as approved by the Engineer. Stacking of sandbags will be allowed, however height of sandbags above pavement surface may not exceed 12 inches.
- Bases with built-in ballast shall weigh between 40 lbs. and 50 lbs. Built-in ballast can be constructed of an integral crumb rubber base or a solid rubber base.
- Recycled truck tire sidewalls may be used for ballast on drums approved for this type of ballast on the CWZTCD list.
- The ballast shall not be heavy objects, water, or any material that would become hazardous to motorists, pedestrians, or workers when the drum is struck by a vehicle.
- When used in regions susceptible to freezing, drums shall have drainage holes in the bottoms so that water will not collect and freeze becoming a hazard when struck by a vehicle.
- Ballast shall not be placed on top of drums.
- Adhesives may be used to secure base of drums to pavement.

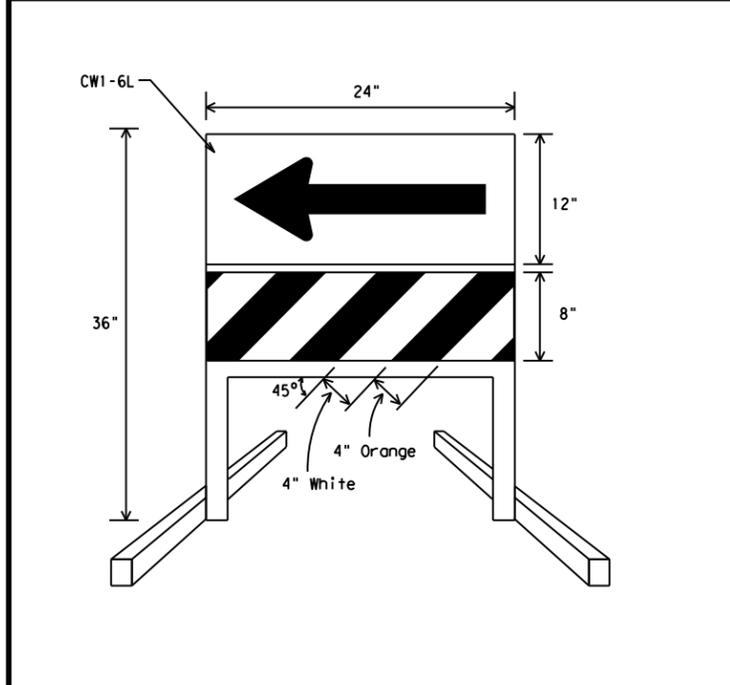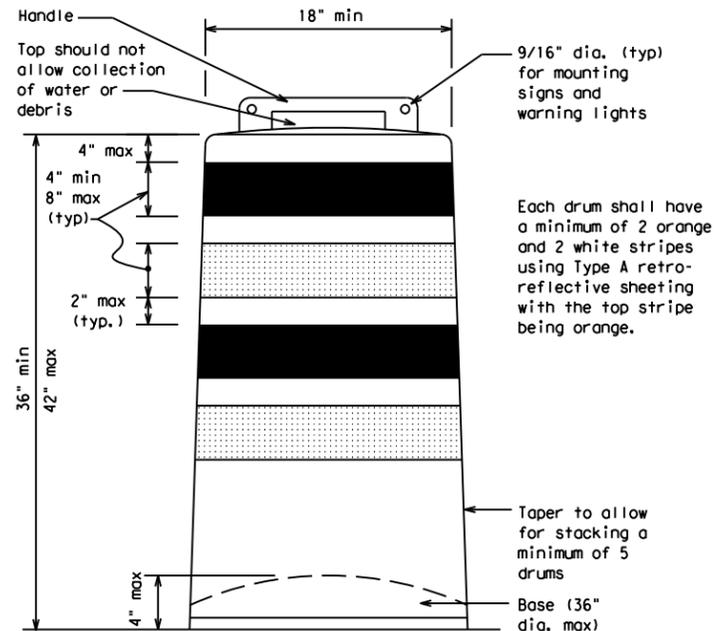


DIRECTION INDICATOR BARRICADE

- The Direction Indicator Barricade may be used in tapers, transitions, and other areas where specific directional guidance to drivers is necessary.
- If used, the Direction Indicator Barricade should be used in series to direct the driver through the transition and into the intended travel lane.
- The Direction Indicator Barricade shall consist of One-Direction Large Arrow (CWI-6) sign in the size shown with a black arrow on a background of Type B_{FL} or Type C_{FL} Orange retroreflective sheeting above a rail with Type A retroreflective sheeting in alternating 4" white and orange stripes sloping downward at an angle of 45 degrees in the direction road users are to pass. Sheeting types shall be as per DMS 8300.
- Double arrows on the Direction Indicator Barricade will not be allowed.
- Approved manufacturers are shown on the CWZTCD List. Ballast shall be as approved by the manufacturer's instructions.

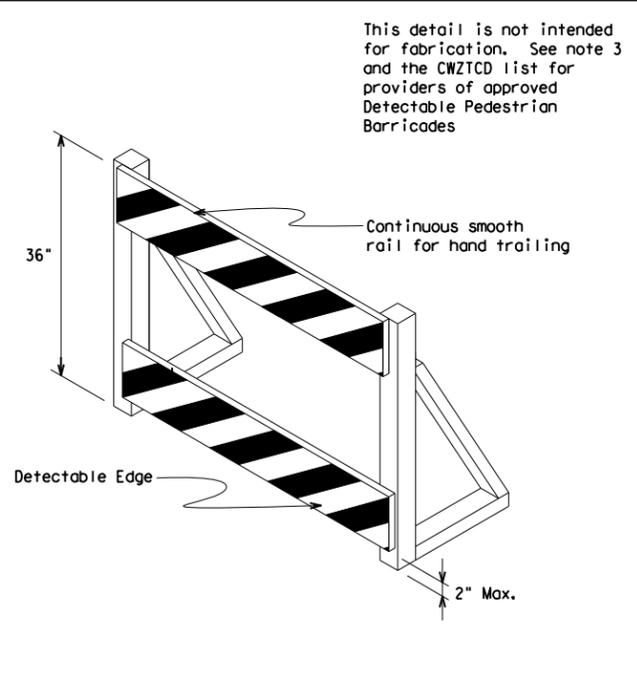

DETECTABLE PEDESTRIAN BARRICADES

- When existing pedestrian facilities are disrupted, closed, or relocated in a TTC zone, the temporary facilities shall be detectable and include accessibility features consistent with the features present in the existing pedestrian facility.
- Where pedestrians with visual disabilities normally use the closed sidewalk, a device that is detectable by a person with a visual disability traveling with the aid of a long cane shall be placed across the full width of the closed sidewalk.
- Detectable pedestrian barricades similar to the one pictured above, longitudinal channelizing devices, some concrete barriers, and wood or chain link fencing with a continuous detectable edging can satisfactorily delineate a pedestrian path.
- Tape, rope, or plastic chain strung between devices are not detectable, do not comply with the design standards in the "Americans with Disabilities Act Accessibility Guidelines for Buildings and Facilities (ADAAG)" and should not be used as a control for pedestrian movements.
- Warning lights shall not be attached to detectable pedestrian barricades.
- Detectable pedestrian barricades may use 8" nominal barricade rails as shown on BC(10) provided that the top rail provides a smooth continuous rail suitable for hand trailing with no splinters, burrs, or sharp edges.

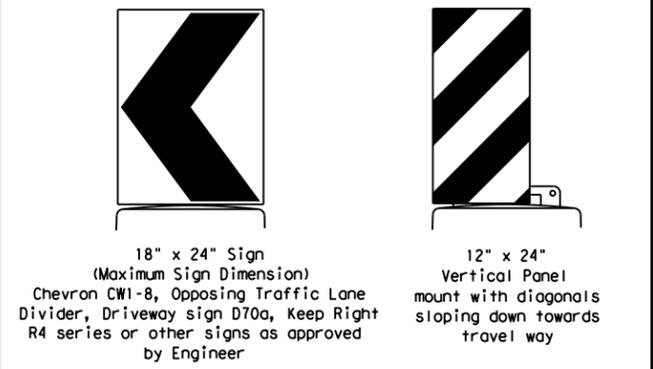

Plywood, Aluminum or Metal sign substrates shall NOT be used on plastic drums

SIGNS, CHEVRONS, AND VERTICAL PANELS MOUNTED ON PLASTIC DRUMS


- Signs used on plastic drums shall be manufactured using substrates listed on the CWZTCD.
- Chevrons and other work zone signs with an orange background shall be manufactured with Type B_{FL} or Type C_{FL} Orange sheeting meeting the color and retroreflectivity requirements of DMS-8300, "Sign Face Material," unless otherwise specified in the plans.
- Vertical Panels shall be manufactured with orange and white sheeting meeting the requirements of DMS-8300 Type A Diagonal stripes on Vertical Panels shall slope down toward the intended traveled lane.
- Other sign messages (text or symbolic) may be used as approved by the Engineer. Sign dimensions shall not exceed 18 inches in width or 24 inches in height, except for the R9 series signs discussed in note 8 below.
- Signs shall be installed using a 1/2 inch bolt (nominal) and nut, two washers, and one locking washer for each connection.
- Mounting bolts and nuts shall be fully engaged and adequately torqued. Bolts should not extend more than 1/2 inch beyond nuts.
- Chevrons may be placed on drums on the outside of curves, on merging tapers or on shifting tapers. When used in these locations they may be placed on every drum or spaced not more than on every third drum. A minimum of three (3) should be used at each location called for in the plans.
- R9-9, R9-10, R9-11 and R9-11a Sidewalk Closed signs which are 24 inches wide may be mounted on plastic drums, with approval of the Engineer.

SHEET 8 OF 12

		Traffic Operations Division Standard	
BARRICADE AND CONSTRUCTION CHANNELIZING DEVICES			
BC (8) - 14			
FILE: bc-14.dgn	DW: TxDOT	CR: TxDOT	DW: TxDOT
© TxDOT November 2002	CONT	SECT	JOB
REVISIONS	0111	01	095 FM 521
4-03 7-13	DIST	COUNTY	SHEET NO.
9-07 8-14	HOU	HARRIS	19


DISCLAIMER: The use of this standard is governed by the "Texas Engineering Practice Act". No warranty of any kind is made by TxDOT for any purpose whatsoever. TxDOT assumes no responsibility for the conversion of this standard to other formats or for incorrect results or damages resulting from its use.

DATE: 9/18/2020 12:11:54 AM
 FILE: T:\HUM-AO\Design\Roadway\FM_521\0111-01-095\DGN\TC\12-23_BC(11)-14.dgn

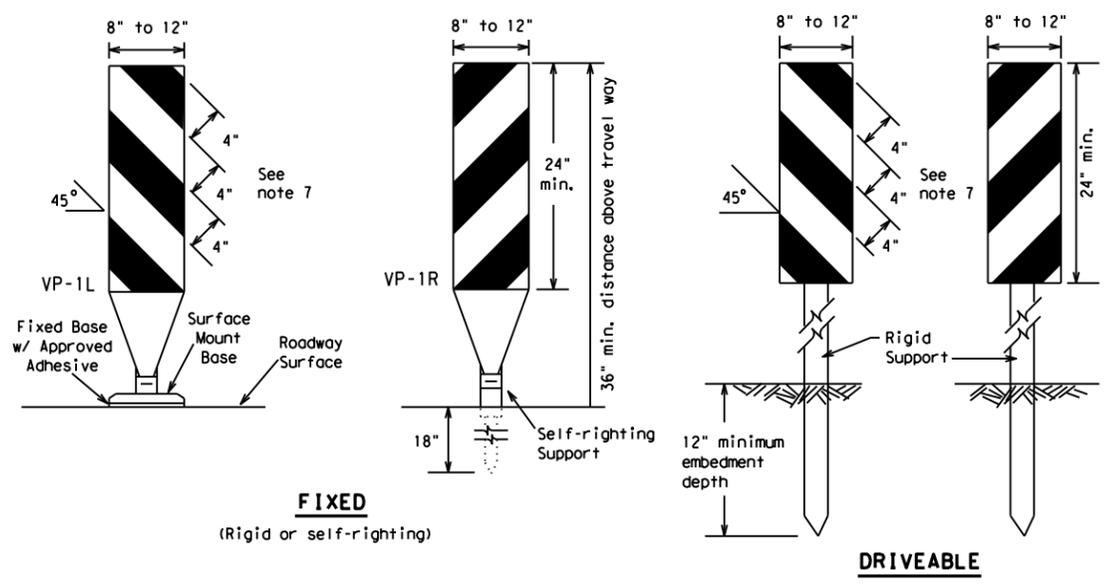

FIXED
(Rigid or self-righting)

DRIVEABLE

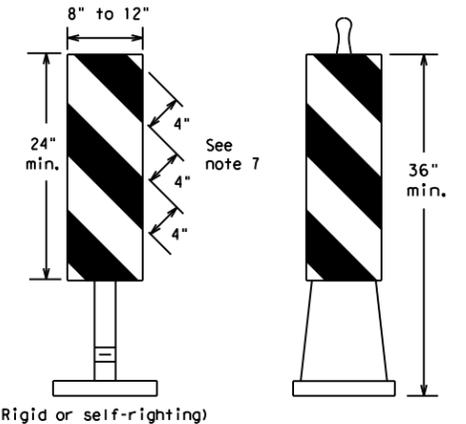


(Rigid or self-righting)

PORTABLE


VERTICAL PANELS (VPs)

- Vertical Panels (VP's) are normally used to channelize traffic or divide opposing lanes of traffic.
- VP's may be used in daytime or nighttime situations. They may be used at the edge of shoulder drop-offs and other areas such as lane transitions where positive daytime and nighttime delineation is required. The Engineer/Inspector shall refer to the Roadway Design Manual Appendix B "Treatment of Pavement Drop-offs in Work Zones" for additional guidelines on the use of VP's for drop-offs.
- VP's should be mounted back to back if used at the edge of cuts adjacent to two-way two lane roadways. Stripes are to be reflective orange and reflective white and should always slope downward toward the travel lane.
- VP's used on expressways and freeways or other high speed roadways, may have more than 270 square inches of retroreflective area facing traffic.
- Self-righting supports are available with portable base. See "Compliant Work Zone Traffic Control Devices List" (CWZTCD).
- Sheeting for the VP's shall be retroreflective Type A conforming to Departmental Material Specification DMS-8300, unless noted otherwise.
- Where the height of reflective material on the vertical panel is 36 inches or greater, a panel stripe of 6 inches shall be used.

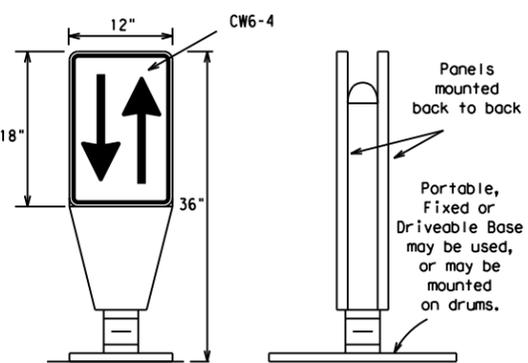


OPPOSING TRAFFIC LANE DIVIDERS (OTLD)

- Opposing Traffic Lane Dividers (OTLD) are delineation devices designed to convert a normal one-way roadway section to two-way operation. OTLD's are used on temporary centerlines. The upward and downward arrows on the sign's face indicate the direction of traffic on either side of the divider. The base is secured to the pavement with an adhesive or rubber weight to minimize movement caused by a vehicle impact or wind gust.
- The OTLD may be used in combination with 42" cones or VPs.
- Spacing between the OTLD shall not exceed 500 feet. 42" cones or VPs placed between the OTLD's should not exceed 100 foot spacing.
- The OTLD shall be orange with a black non-reflective legend. Sheeting for the OTLD shall be retroreflective Type B_{FL} or Type C_{FL} conforming to Departmental Material Specification DMS-8300, unless noted otherwise. The legend shall meet the requirements of DMS-8300.

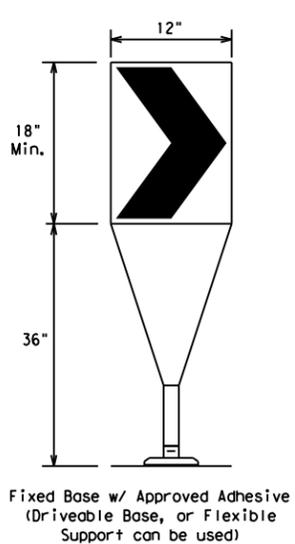

- The chevron shall be a vertical rectangle with a minimum size of 12 by 18 inches.
- Chevrons are intended to give notice of a sharp change of alignment with the direction of travel and provide additional emphasis and guidance for vehicle operators with regard to changes in horizontal alignment of the roadway.
- Chevrons, when used, shall be erected on the outside of a sharp curve or turn, or on the far side of an intersection. They shall be in line with and at right angles to approaching traffic. Spacing should be such that the motorist always has three in view, until the change in alignment eliminates its need.
- To be effective, the chevron should be visible for at least 500 feet.
- Chevrons shall be orange with a black nonreflective legend. Sheeting for the chevron shall be retroreflective Type B_{FL} or Type C_{FL} conforming to Departmental Material Specification DMS-8300, unless noted otherwise. The legend shall meet the requirements of DMS-8300.
- For Long Term Stationary use on tapers or transitions on freeways and divided highways self-righting chevrons may be used to supplement plastic drums but not to replace plastic drums.

CHEVRONS

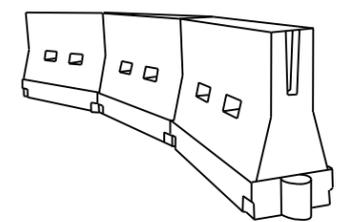

LONGITUDINAL CHANNELIZING DEVICES (LCD)

- LCDs are crashworthy, lightweight, deformable devices that are highly visible, have good target value and can be connected together. They are not designed to contain or redirect a vehicle on impact.
- LCDs may be used instead of a line of cones or drums.
- LCDs shall be placed in accordance to application and installation requirements specific to the device, and used only when shown on the CWZTCD list.
- LCDs should not be used to provide positive protection for obstacles, pedestrians or workers.
- LCDs shall be supplemented with retroreflective delineation as required for temporary barriers on BC(7) when placed roughly parallel to the travel lanes.
- LCDs used as barricades placed perpendicular to traffic should have at least one row of reflective sheeting meeting the requirements for barricade rails as shown on BC(10) placed near the top of the LCD along the full length of the device.

WATER BALLASTED SYSTEMS USED AS BARRIERS

- Water ballasted systems used as barriers shall not be used solely to channelize road users, but also to protect the work space per the appropriate NCHRP 350 crashworthiness requirements based on roadway speed and barrier application.
- Water ballasted systems used to channelize vehicular traffic shall be supplemented with retroreflective delineation or channelizing devices to improve daytime/nighttime visibility. They may also be supplemented with pavement markings.
- Water ballasted systems used as barriers shall be placed in accordance to application and installation requirements specific to the device, and used only when shown on the CWZTCD list.
- Water ballasted systems used as barriers should not be used for a merging taper except in low speed (less than 45 MPH) urban areas. When used on a taper in a low speed urban area, the taper shall be delineated and the taper length should be designed to optimize road user operations considering the available geometric conditions.
- When water ballasted systems used as barriers have blunt ends exposed to traffic, they should be attenuated as per manufacturer recommendations or flared to a point outside the clear zone.

If used to channelize pedestrians, longitudinal channelizing devices or water ballasted systems must have a continuous detectable bottom for users of long canes and the top of the unit shall not be less than 32 inches in height.

HOLLOW OR WATER BALLASTED SYSTEMS USED AS LONGITUDINAL CHANNELIZING DEVICES OR BARRIERS

GENERAL NOTES

- Work Zone channelizing devices illustrated on this sheet may be installed in close proximity to traffic and are suitable for use on high or low speed roadways. The Engineer/Inspector shall ensure that spacing and placement is uniform and in accordance with the "Texas Manual on Uniform Traffic Control Devices" (TMUTCD).
- Channelizing devices shown on this sheet may have a driveable, fixed or portable base. The requirement for self-righting channelizing devices must be specified in the General Notes or other plan sheets.
- Channelizing devices on self-righting supports should be used in work zone areas where channelizing devices are frequently impacted by errant vehicles or vehicle related wind gusts making alignment of the channelizing devices difficult to maintain. Locations of these devices shall be detailed elsewhere in the plans. These devices shall conform to the TMUTCD and the "Compliant Work Zone Traffic Control Devices List" (CWZTCD).
- The Contractor shall maintain devices in a clean condition and replace damaged, nonreflective, faded, or broken devices and bases as required by the Engineer/Inspector. The Contractor shall be required to maintain proper device spacing and alignment.
- Portable bases shall be fabricated from virgin and/or recycled rubber. The portable bases shall weigh a minimum of 30 lbs.
- Pavement surfaces shall be prepared in a manner that ensures proper bonding between the adhesives, the fixed mount bases and the pavement surface. Adhesives shall be prepared and applied according to the manufacturer's recommendations.
- The installation and removal of channelizing devices shall not cause detrimental effects to the final pavement surfaces, including pavement surface discoloration or surface integrity. Driveable bases shall not be permitted on final pavement surfaces. The Engineer/Inspector shall approve all application and removal procedures of fixed bases.

Posted Speed * S	Formula L = WS ² / 60	Minimum Desirable Taper Lengths **			Suggested Maximum Spacing of Channelizing Devices	
		10' Offset	11' Offset	12' Offset	On a Taper	On a Tangent
30	L = WS ² / 60	150'	165'	180'	30'	60'
35		205'	225'	245'	35'	70'
40	L = WS	265'	295'	320'	40'	80'
45		450'	495'	540'	45'	90'
50	L = WS	500'	550'	600'	50'	100'
55		600'	660'	720'	60'	120'
60	L = WS	650'	715'	780'	65'	130'
65		700'	770'	840'	70'	140'
70	L = WS	750'	825'	900'	75'	150'
75		800'	880'	960'	80'	160'
80	L = WS					
80						

**Taper lengths have been rounded off.
 L=Length of Taper (FT.) W=Width of Offset (FT.)
 S=Posted Speed (MPH)

SUGGESTED MAXIMUM SPACING OF CHANNELIZING DEVICES AND MINIMUM DESIRABLE TAPER LENGTHS

SHEET 9 OF 12



BARRICADE AND CONSTRUCTION CHANNELIZING DEVICES

BC (9) - 14


FILE: bc-14.dgn	DW: TxDOT	CK: TxDOT	DW: TxDOT	CK: TxDOT
© TxDOT November 2002	CONT	SECT	JOB	HIGHWAY
REVISIONS	0111	01	095	FM 521
9-07 8-14	DIST	COUNTY	SHEET NO.	
7-13	HOU	HARRIS	20	

DISCLAIMER: The use of this standard is governed by the "Texas Engineering Practice Act". No warranty of any kind is made by TxDOT for any purpose whatsoever. TxDOT assumes no responsibility for the conversion of this standard to other formats or for incorrect results or damages resulting from its use.


TYPE 3 BARRICADES

1. Refer to the Compliant Work Zone Traffic Control Devices List (CWZTCD) for details of the Type 3 Barricades and a list of all materials used in the construction of Type 3 Barricades.
2. Type 3 Barricades shall be used at each end of construction projects closed to all traffic.
3. Barricades extending across a roadway should have stripes that slope downward in the direction toward which traffic must turn in detouring. When both right and left turns are provided, the chevron striping may slope downward in both directions from the center of the barricade. Where no turns are provided at a closed road striping should slope downward in both directions toward the center of roadway.
4. Striping of rails, for the right side of the roadway, should slope downward to the left. For the left side of the roadway, striping should slope downward to the right.
5. Identification markings may be shown only on the back of the barricade rails. The maximum height of letters and/or company logos used for identification shall be 1".
6. Barricades shall not be placed parallel to traffic unless an adequate clear zone is provided.
7. Warning lights shall NOT be installed on barricades.
8. Where barricades require the use of weights to keep from turning over, the use of sandbags with dry, cohesionless sand is recommended. The sandbags will be tied shut to keep the sand from spilling and to maintain a constant weight. Sand bags shall not be stacked in a manner that covers any portion of a barricade rails reflective sheeting. Rock, concrete, iron, steel or other solid objects will NOT be permitted. Sandbags should weigh a minimum of 35 lbs and a maximum of 50 lbs. Sandbags shall be made of a durable material that tears upon vehicular impact. Rubber (such as tire inner tubes) shall not be used for sandbags. Sandbags shall only be placed along or upon the base supports of the device and shall not be suspended above ground level or hung with rope, wire, chains or other fasteners.
9. Sheeting for barricades shall be retroreflective Type A conforming to Departmental Material Specification DMS-8300 unless otherwise noted.

 Barricades shall NOT be used as a sign support.




TYPICAL STRIPING DETAIL FOR BARRICADE RAIL

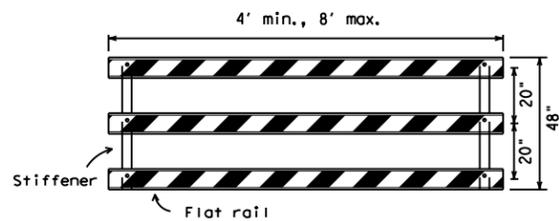


Stiffener may be inside or outside of support, but no more than 2 stiffeners shall be allowed on one barricade.

TYPICAL PANEL DETAIL FOR SKID OR POST TYPE BARRICADES

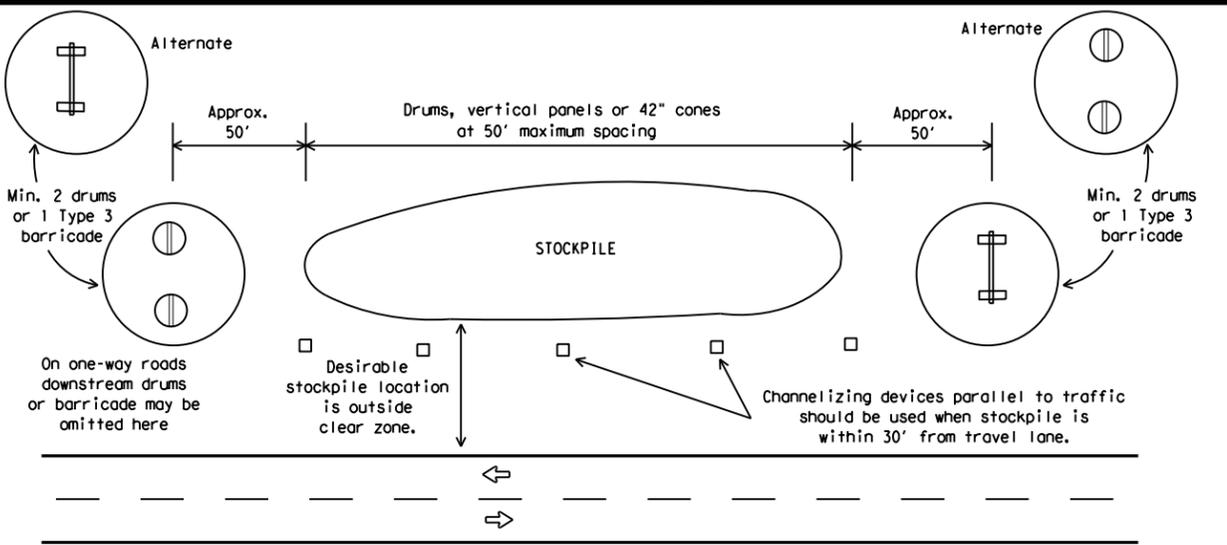


TRAFFIC CONTROL FOR MATERIAL STOCKPILES

Each roadway of a divided highway shall be barricaded in the same manner.

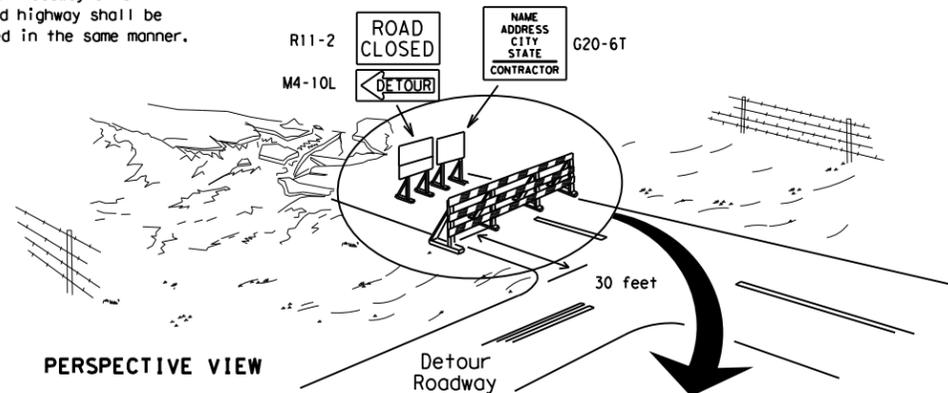

PERSPECTIVE VIEW


The three rails on Type 3 barricades shall be reflectorized orange and reflective white stripes on one side facing one-way traffic and both sides for two-way traffic. Barricade striping should slant downward in the direction of detour.

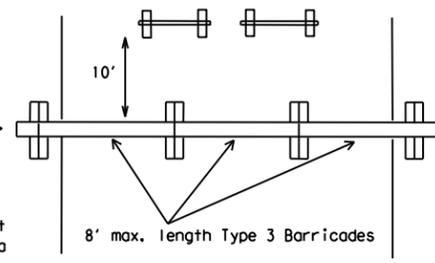

PLAN VIEW


1. Signs should be mounted on independent supports at a 7 foot mounting height in center of roadway. The signs should be a minimum of 10 feet behind Type 3 Barricades.
2. Advance signing shall be as specified elsewhere in the plans.

TYPE 3 BARRICADE (POST AND SKID) TYPICAL APPLICATION

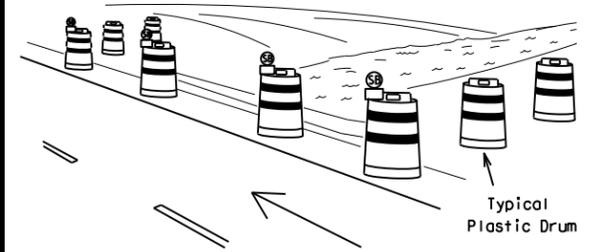

PERSPECTIVE VIEW

These drums are not required on one-way roadway

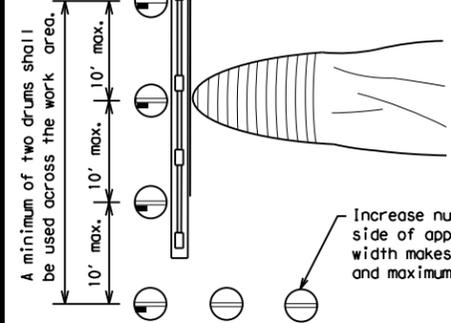


PLAN VIEW

Increase number of plastic drums on the side of approaching traffic if the crown width makes it necessary. (minimum of 2 and maximum of 4 drums)

LEGEND	
	Plastic drum
	Plastic drum with steady burn light or yellow warning reflector
	Steady burn warning light or yellow warning reflector


CULVERT WIDENING OR OTHER ISOLATED WORK WITHIN THE PROJECT LIMITS

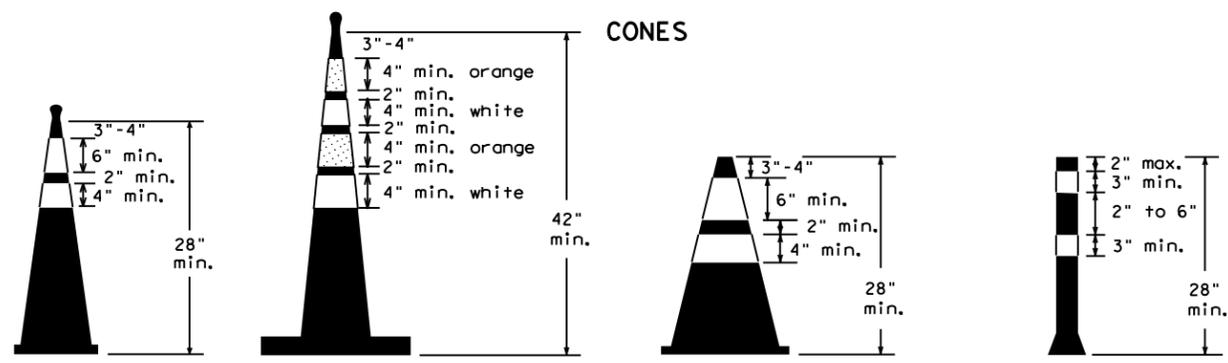

28" Cones shall have a minimum weight of 9 1/2 lbs.
 42" 2-piece cones shall have a minimum weight of 30 lbs. including base.

1. Traffic cones and tubular markers shall be predominantly orange, and meet the height and weight requirements shown above.
2. One-piece cones have the body and base of the cone molded in one consolidated unit. Two-piece cones have a cone shaped body and a separate rubber base, or ballast, that is added to keep the device upright and in place.
3. Two-piece cones may have a handle or loop extending up to 8" above the minimum height shown, in order to aid in retrieving the device.
4. Cones or tubular markers used at night shall have white or white and orange reflective bands as shown above. The reflective bands shall have a smooth, sealed outer surface and meet the requirements of Departmental Material Specification DMS-8300 Type A.
5. 28" cones and tubular markers are generally suitable for short duration and short-term stationary work as defined on BC(4). These should not be used for intermediate-term or long-term stationary work unless personnel is on-site to maintain them in their proper upright position.
6. 42" two-piece cones, vertical panels or drums are suitable for all work zone durations.
7. Cones or tubular markers used on each project should be of the same size and shape.

THIS DEVICE SHALL NOT BE USED ON PROJECTS LET AFTER MARCH 2014.

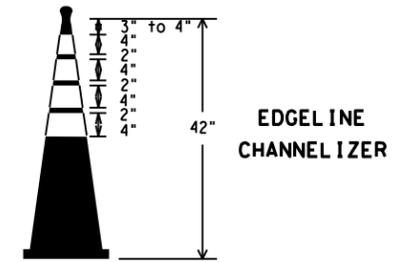

EDGE LINE CHANNELIZER

1. This device is intended only for use in place of a vertical panel to channelize traffic by indicating the edge of the travel lane. It is not intended to be used in transitions or tapers.
2. This device shall not be used to separate lanes of traffic (opposing or otherwise) or warn of objects.
3. This device is based on a 42 inch, two-piece cone with an alternate striping pattern: four 4 inch retroreflective bands, with an approximate 2 inch gap between bands. The color of the band should correspond to the color of the edgeline (yellow for left edgeline, white for right edgeline) for which the device is substituted or for which it supplements. The reflectorized bands shall be retroreflective Type A conforming to Departmental Material Specification DMS-8300, unless otherwise noted.
4. The base must weigh a minimum of 30 lbs.

BARRICADE AND CONSTRUCTION CHANNELIZING DEVICES

BC (10) - 14

FILE: bc-14.dgn	DN: TxDOT	CK: TxDOT	DW: TxDOT	CR: TxDOT
© TxDOT November 2002	CONT	SECT	JOB	HIGHWAY
REVISIONS	0111	01	095	FM 521
9-07 8-14	DIST	COUNTY	SHEET NO.	
7-13	HOU	HARRIS	21	

WORK ZONE PAVEMENT MARKINGS

GENERAL

- The Contractor shall be responsible for maintaining work zone and existing pavement markings, in accordance with the standard specifications and special provisions, on all roadways open to traffic within the CSJ limits unless otherwise stated in the plans.
- Color, patterns and dimensions shall be in conformance with the "Texas Manual on Uniform Traffic Control Devices" (TMUTCD).
- Additional supplemental pavement marking details may be found in the plans or specifications.
- Pavement markings shall be installed in accordance with the TMUTCD and as shown on the plans.
- When short term markings are required on the plans, short term markings shall conform with the TMUTCD, the plans and details as shown on the Standard Plan Sheet WZ(STPM).
- When standard pavement markings are not in place and the roadway is opened to traffic, DO NOT PASS signs shall be erected to mark the beginning of the sections where passing is prohibited and PASS WITH CARE signs at the beginning of sections where passing is permitted.
- All work zone pavement markings shall be installed in accordance with Item 662, "Work Zone Pavement Markings."

RAISED PAVEMENT MARKERS

- Raised pavement markers are to be placed according to the patterns on BC(12).
- All raised pavement markers used for work zone markings shall meet the requirements of Item 672, "RAISED PAVEMENT MARKERS" and Departmental Material Specification DMS-4200 or DMS-4300.

PREFABRICATED PAVEMENT MARKINGS

- Removable prefabricated pavement markings shall meet the requirements of DMS-8241.
- Non-removable prefabricated pavement markings (foil back) shall meet the requirements of DMS-8240.


MAINTAINING WORK ZONE PAVEMENT MARKINGS

- The Contractor will be responsible for maintaining work zone pavement markings within the work limits.
- Work zone pavement markings shall be inspected in accordance with the frequency and reporting requirements of work zone traffic control device inspections as required by Form 599.
- The markings should provide a visible reference for a minimum distance of 300 feet during normal daylight hours and 160 feet when illuminated by automobile low-beam headlights at night, unless sight distance is restricted by roadway geometrics.
- Markings failing to meet this criteria within the first 30 days after placement shall be replaced at the expense of the Contractor as per Specification Item 662.

REMOVAL OF PAVEMENT MARKINGS

- Pavement markings that are no longer applicable, could create confusion or direct a motorist toward or into the closed portion of the roadway shall be removed or obliterated before the roadway is opened to traffic.
- The above shall not apply to detours in place for less than three days, where flaggers and/or sufficient channelizing devices are used in lieu of markings to outline the detour route.
- Pavement markings shall be removed to the fullest extent possible, so as not to leave a discernable marking. This shall be by any method approved by TxDOT Specification Item 677 for "Eliminating Existing Pavement Markings and Markers".
- The removal of pavement markings may require resurfacing or seal coating portions of the roadway as described in Item 677.
- Subject to the approval of the Engineer, any method that proves to be successful on a particular type pavement may be used.
- Blast cleaning may be used but will not be required unless specifically shown in the plans.
- Over-painting of the markings SHALL NOT BE permitted.
- Removal of raised pavement markers shall be as directed by the Engineer.
- Removal of existing pavement markings and markers will be paid for directly in accordance with Item 677, "ELIMINATING EXISTING PAVEMENT MARKINGS AND MARKERS," unless otherwise stated in the plans.
- Black-out marking tape may be used to cover conflicting existing markings for periods less than two weeks when approved by the Engineer.

Temporary Flexible-Reflective Roadway Marker Tabs

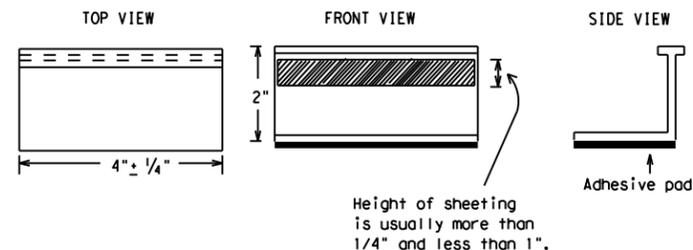

**STAPLES OR NAILS SHALL NOT BE USED TO SECURE
TEMPORARY FLEXIBLE-REFLECTIVE ROADWAY MARKER
TABS TO THE PAVEMENT SURFACE**

- Temporary flexible-reflective roadway marker tabs used as guidemarks shall meet the requirements of DMS-8242.
- Tabs detailed on this sheet are to be inspected and accepted by the Engineer or designated representative. Sampling and testing is not normally required, however at the option of the Engineer, either "A" or "B" below may be imposed to assure quality before placement on the roadway.
 - Select five (5) or more tabs at random from each lot or shipment and submit to the Construction Division, Materials and Pavement Section to determine specification compliance.
 - Select five (5) tabs and perform the following test. Affix five (5) tabs at 24 inch intervals on an asphaltic pavement in a straight line. Using a medium size passenger vehicle or pickup, run over the markers with the front and rear tires at a speed of 35 to 40 miles per hour, four (4) times in each direction. No more than one (1) out of the five (5) reflective surfaces shall be lost or displaced as a result of this test.
- Small design variances may be noted between tab manufacturers.
- See Standard Sheet WZ(STPM) for tab placement on new pavements. See Standard Sheet TCP(7-1) for tab placement on seal coat work.

RAISED PAVEMENT MARKERS USED AS GUIDEMARKS

- Raised pavement markers used as guidemarks shall be from the approved product list, and meet the requirements of DMS-4200.
- All temporary construction raised pavement markers provided on a project shall be of the same manufacturer.
- Adhesive for guidemarks shall be bituminous material hot applied or butyl rubber pad for all surfaces, or thermoplastic for concrete surfaces.

Guidemarks shall be designated as:
 YELLOW - (two amber reflective surfaces with yellow body).
 WHITE - (one silver reflective surface with white body).

DEPARTMENTAL MATERIAL SPECIFICATIONS	
PAVEMENT MARKERS (REFLECTORIZED)	DMS-4200
TRAFFIC BUTTONS	DMS-4300
EPOXY AND ADHESIVES	DMS-6100
BITUMINOUS ADHESIVE FOR PAVEMENT MARKERS	DMS-6130
PERMANENT PREFABRICATED PAVEMENT MARKINGS	DMS-8240
TEMPORARY REMOVABLE, PREFABRICATED PAVEMENT MARKINGS	DMS-8241
TEMPORARY FLEXIBLE, REFLECTIVE ROADWAY MARKER TABS	DMS-8242

A list of prequalified reflective raised pavement markers, non-reflective traffic buttons, roadway marker tabs and other pavement markings can be found at the Material Producer List web address shown on BC(1).

SHEET 11 OF 12



BARRICADE AND CONSTRUCTION PAVEMENT MARKINGS


BC(11) - 14

FILE: bc-14.dgn	DN: TxDOT	CR: TxDOT	OW: TxDOT	CK: TxDOT
© TxDOT February 1998	CONT	SECT	JOB	HIGHWAY
	0111	01	095	FM 521
REVISIONS				
2-98 9-07				
1-02 7-13	DIST	COUNTY	SHEET NO.	
11-02 8-14	HOU	HARRIS	22	


DISCLAIMER: The use of this standard is governed by the "Texas Engineering Practice Act". No warranty of any kind is made by TxDOT for any purpose whatsoever. TxDOT assumes no responsibility for the conversion of this standard to other formats or for incorrect results or damages resulting from its use.

DATE: 9/18/2020 12:12:27 AM
 FILE: T:\HUM-AO\Design\Roadway\FM_521\0111-01-095\DGN\TCP\12-23_BC(11)-14.dgn

 
PAVEMENT MARKING PATTERNS



 
REFLECTORIZED PAVEMENT MARKINGS - PATTERN A



 REFLECTORIZED PAVEMENT MARKINGS - PATTERN B




RAISED PAVEMENT MARKERS - PATTERN A

 

RAISED PAVEMENT MARKERS - PATTERN B


Pattern A is the TXDOT Standard, however Pattern B may be used if approved by the Engineer. Prefabricated markings may be substituted for reflectorized pavement markings.

CENTER LINE & NO-PASSING ZONE BARRIER LINES FOR TWO-LANE, TWO-WAY HIGHWAYS

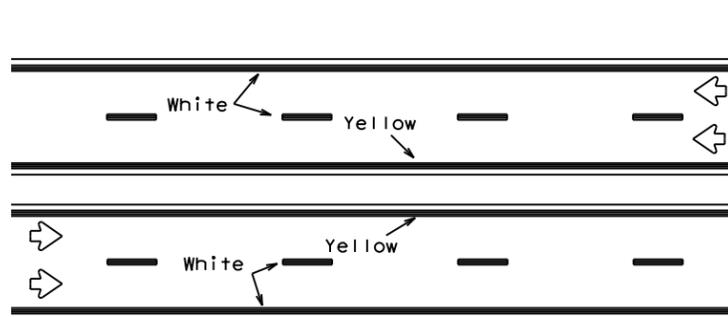


REFLECTORIZED PAVEMENT MARKINGS

Prefabricated markings may be substituted for reflectorized pavement markings.

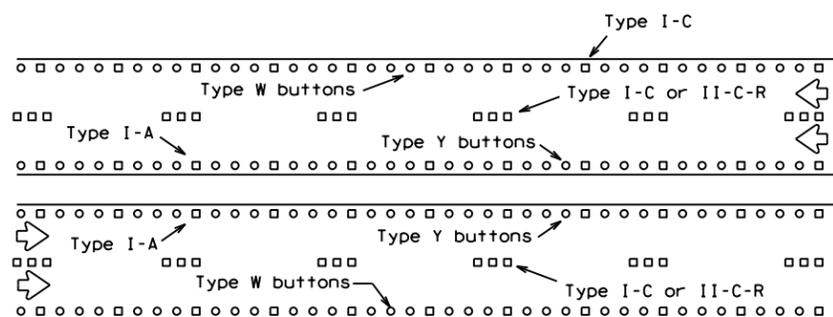


RAISED PAVEMENT MARKERS

EDGE & LANE LINES FOR DIVIDED HIGHWAY

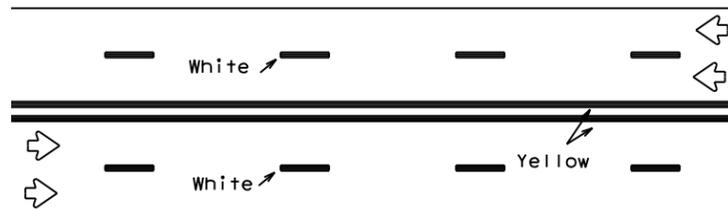


REFLECTORIZED PAVEMENT MARKINGS

Prefabricated markings may be substituted for reflectorized pavement markings.

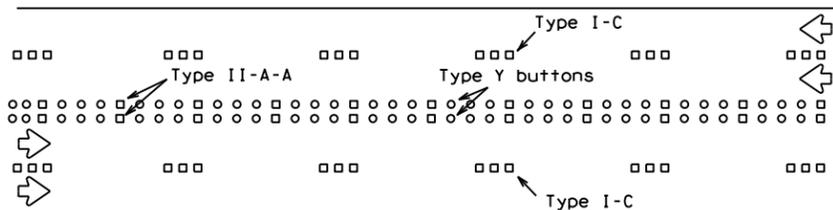


RAISED PAVEMENT MARKERS

LANE & CENTER LINES FOR MULTILANE UNDIVIDED HIGHWAYS

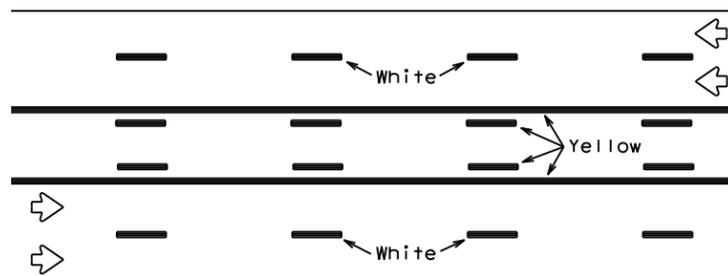

REFLECTORIZED PAVEMENT MARKINGS


Prefabricated markings may be substituted for reflectorized pavement markings.

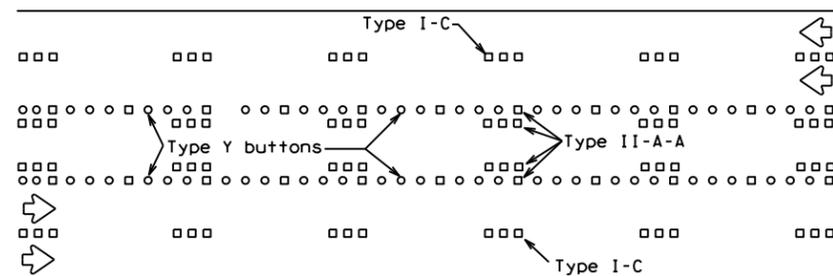



RAISED PAVEMENT MARKERS

TWO-WAY LEFT TURN LANE


STANDARD WORK ZONE PAVEMENT MARKINGS DETAILS

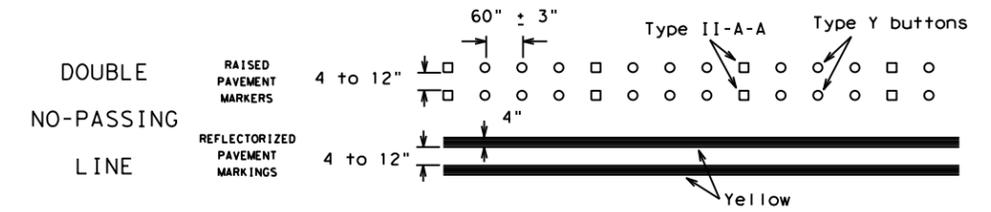


SOLID LINES

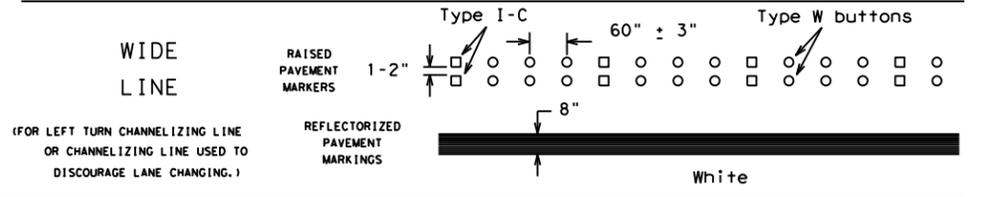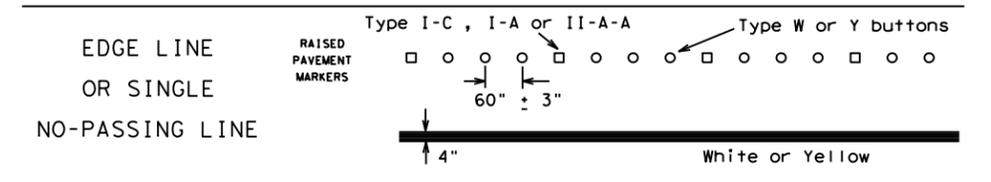

CENTER LINE OR LANE LINE

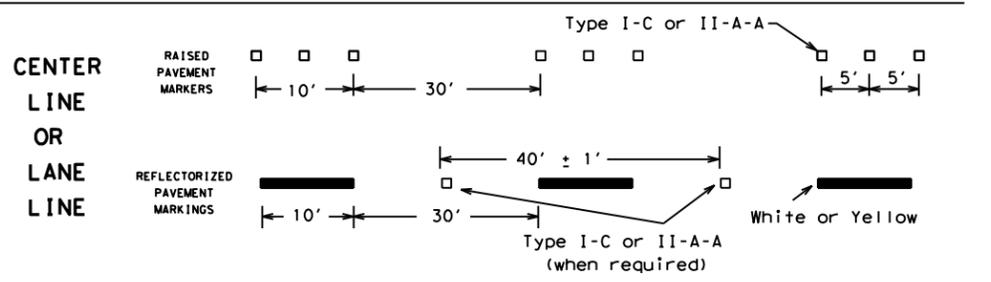


BROKEN LINES

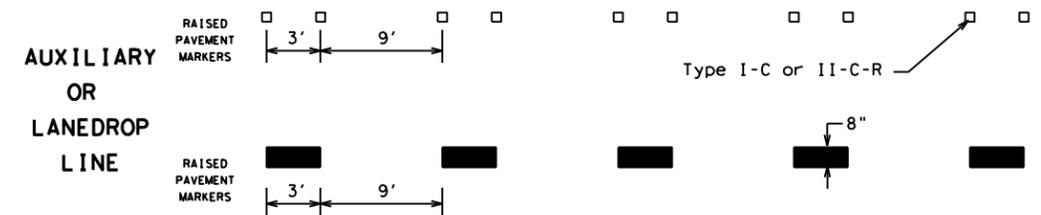

REMOVABLE MARKINGS WITH RAISED PAVEMENT MARKERS

If raised pavement markers are used to supplement REMOVABLE markings, the markers shall be applied to the top of the tape at the approximate mid length of tape used for broken lines or at 20 foot spacing for solid lines. This allows an easier removal of raised pavement markers and tape.

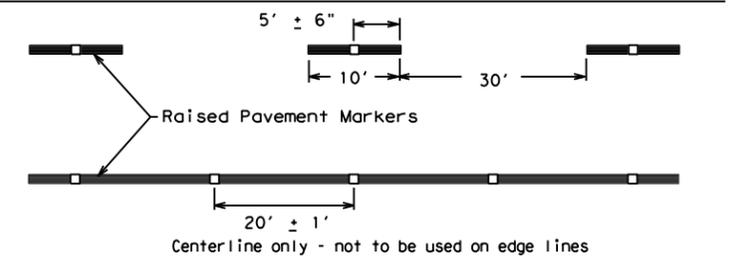

SHEET 12 OF 12

DISCLAIMER: The use of this standard is governed by the "Texas Engineering Practice Act". No warranty of any kind is made by TXDOT for any purpose whatsoever. TXDOT assumes no responsibility for the conversion of this standard to other formats or for incorrect results or damages resulting from its use.

DATE: 9/18/2020 12:12:44 AM
FILE: T:\HUM-AO\Design\Roadway\FM 521\0111-01-095\06\NCP\12-23 BC(11)-14) TO BC(12)-14.dgn



BARRICADE AND CONSTRUCTION PAVEMENT MARKING PATTERNS



BC(12)-14

FILE: bc-14.dgn	DN: TxDOT	CK: TxDOT	DW: TxDOT	CR: TxDOT
©TxDOT February 1998	CONT	SECT	JOB	HIGHWAY
REVISIONS	0111	01	095	FM 521
1-97 9-07	DIST	COUNTY	SHEET NO.	
2-98 7-13	HOU	HARRIS	23	
11-02 8-14				

Raised pavement markers used as standard pavement markings shall be from the approved products list and meet the requirements of Item 672 "RAISED PAVEMENT MARKERS."

DISCLAIMER: The use of this standard is governed by the "Texas Engineering Practice Act". No warranty of any kind is made by TxDOT for any purpose whatsoever. TxDOT assumes no responsibility for the conversion of this standard to other formats or for incorrect results or damages resulting from its use.

DATE: FILE:

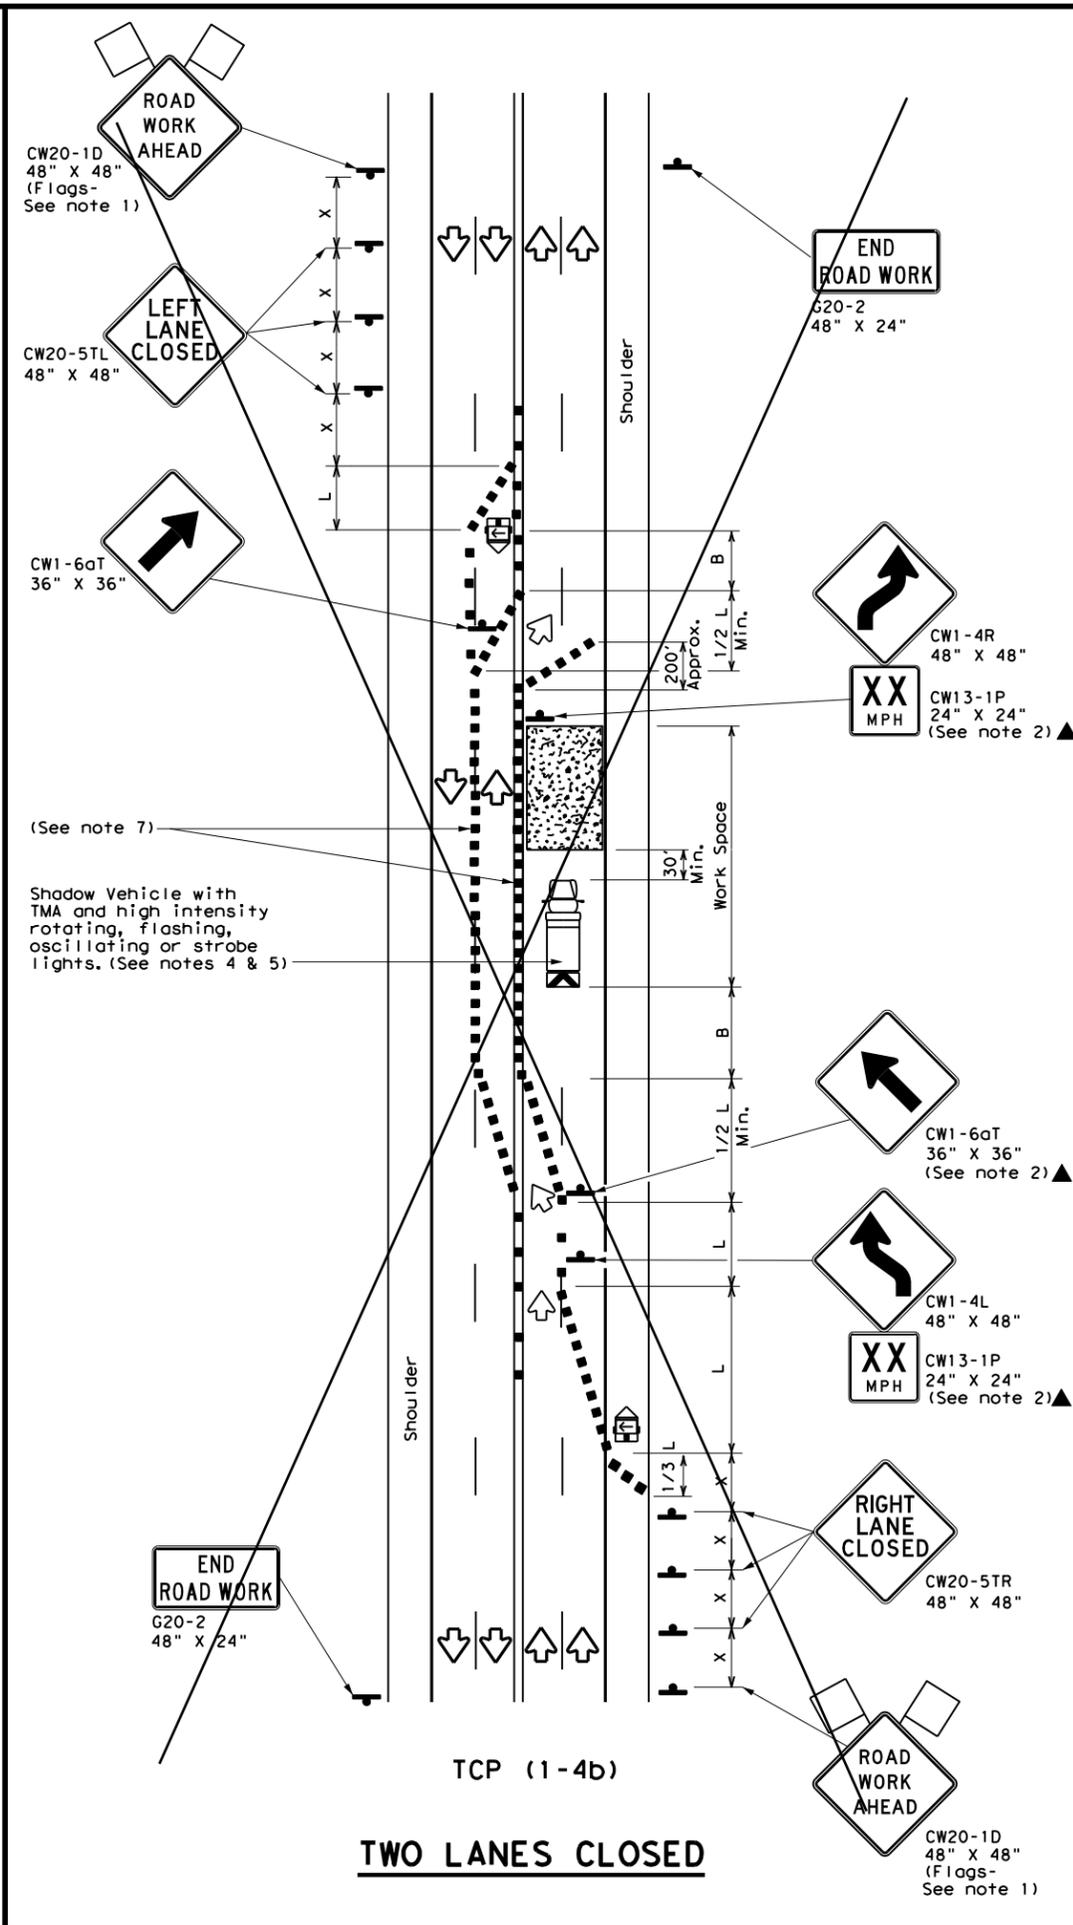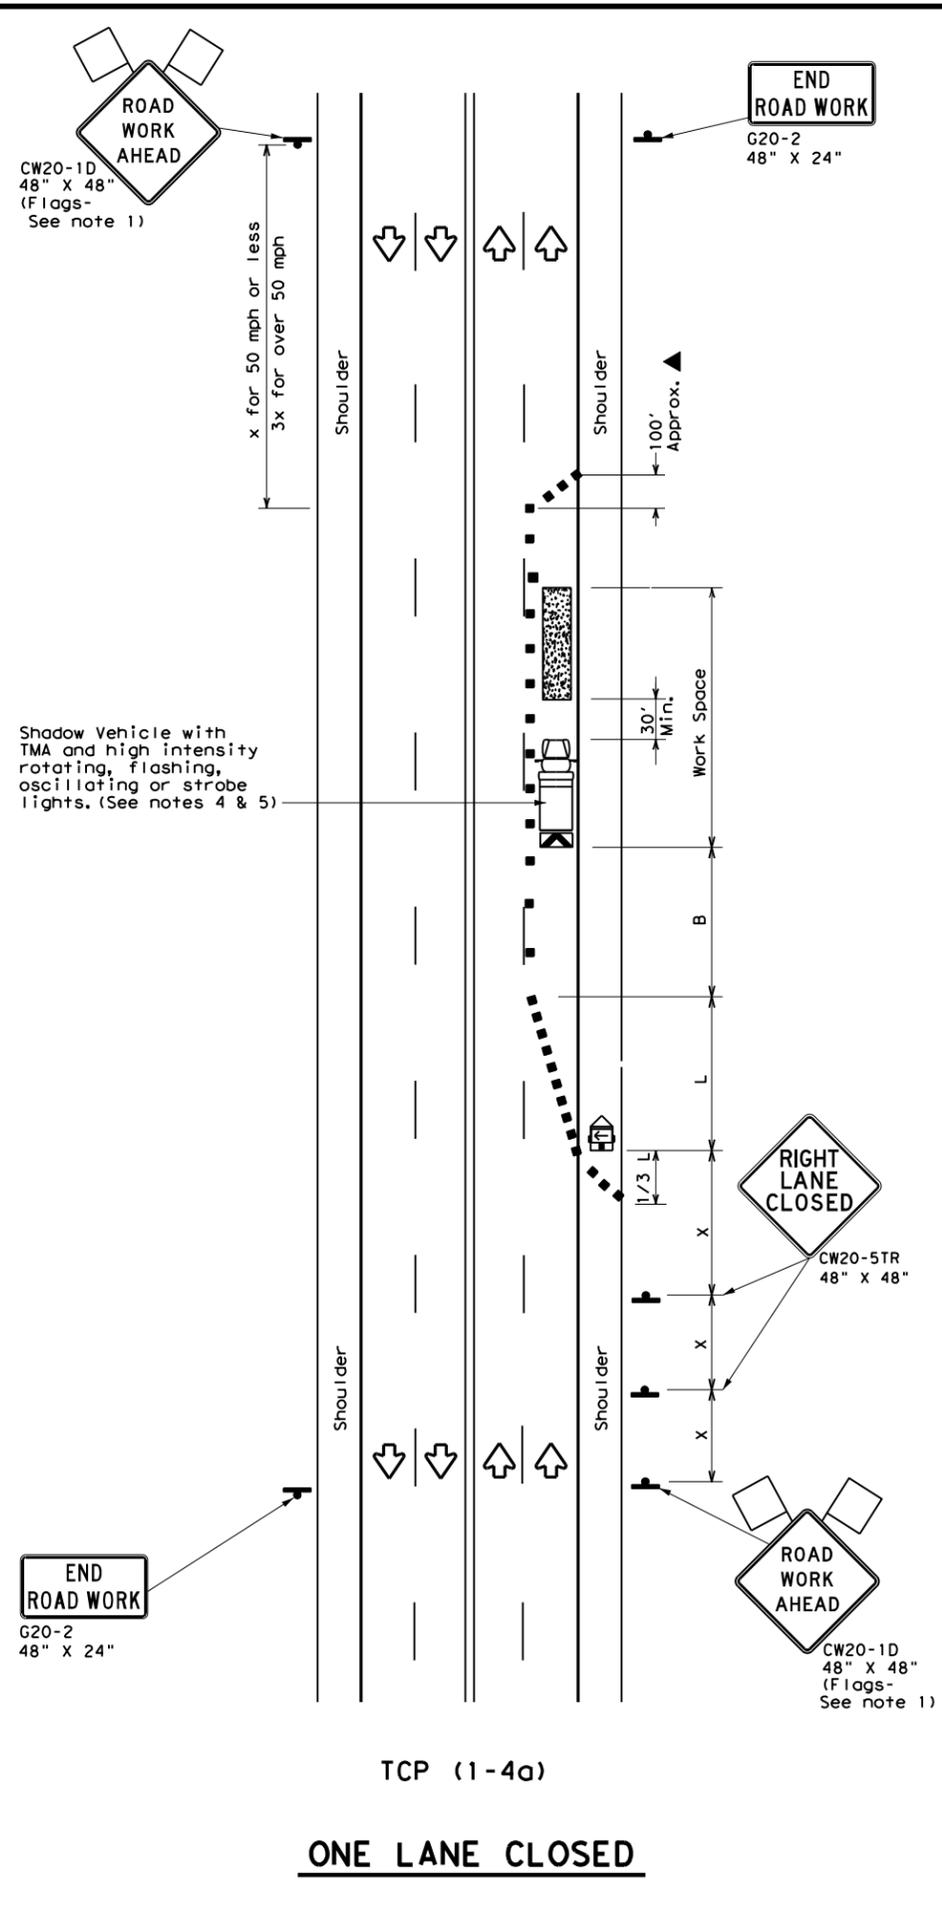

LEGEND			
	Type 3 Barricade		Channelizing Devices
	Heavy Work Vehicle		Truck Mounted Attenuator (TMA)
	Trailer Mounted Flashing Arrow Board		Portable Changeable Message Sign (PCMS)
	Sign		Traffic Flow
	Flag		Flagger

Posted Speed *	Formula	Minimum Desirable Taper Lengths **			Suggested Maximum Spacing of Channelizing Devices		Minimum Sign Spacing "x" Distance	Suggested Longitudinal Buffer Space "B"
		10' Offset	11' Offset	12' Offset	On a Taper	On a Tangent		
30	$L = \frac{WS^2}{60}$	150'	165'	180'	30'	60'	120'	90'
35		205'	225'	245'	35'	70'	160'	120'
40		265'	295'	320'	40'	80'	240'	155'
45	$L = WS$	450'	495'	540'	45'	90'	320'	195'
50		500'	550'	600'	50'	100'	400'	240'
55		550'	605'	660'	55'	110'	500'	295'
60		600'	660'	720'	60'	120'	600'	350'
65		650'	715'	780'	65'	130'	700'	410'
70		700'	770'	840'	70'	140'	800'	475'
75		750'	825'	900'	75'	150'	900'	540'

* Conventional Roads Only
** Taper lengths have been rounded off.
L=Length of Taper (FT) W=Width of Offset (FT) S=Posted Speed (MPH)

TYPICAL USAGE				
MOBILE	SHORT DURATION	SHORT TERM STATIONARY	INTERMEDIATE TERM STATIONARY	LONG TERM STATIONARY
	✓	✓		

- GENERAL NOTES**
- Flags attached to signs where shown are REQUIRED.
 - All traffic control devices illustrated are REQUIRED, except those denoted with the triangle symbol may be omitted when stated elsewhere in the plans, or for routine maintenance work, when approved by the Engineer.
 - The CW20-1D "ROAD WORK AHEAD" sign may be repeated if the visibility of the work zone is less than 1500 feet.
 - A Shadow Vehicle with a TMA should be used anytime it can be positioned 30 to 100 feet in advance of the area of crew exposure without adversely affecting the performance or quality of the work. If workers are no longer present but road or work conditions require the traffic control to remain in place, Type 3 Barricades or other channelizing devices may be substituted for the Shadow Vehicle and TMA.
 - Additional Shadow Vehicles with TMAs may be positioned off the paved surface, next to those shown in order to protect wider work spaces.

TCP (1-4a)

- If this TCP is used for a left lane closure, CW20-5TL "LEFT LANE CLOSED" signs shall be used and channelizing devices shall be placed on the centerline where needed to protect the work space from opposing traffic with the arrow panel placed in the closed lane near the end of the merging taper.

TCP (1-4b)

- Where traffic is directed over a yellow centerline, channelizing devices which separate two-way traffic should be spaced on tapers at 20' or 15' if posted speeds are 35 mph or slower, and for tangent sections, at 1/2S where S is the speed in mph. This tighter device spacing is intended for the areas of conflicting markings, not the entire work zone.

STATE OF TEXAS
SHARMEEN F. RAHMAN
99416
LICENSED PROFESSIONAL ENGINEER
Sharmeen Rahaman, PE
11.30.2020

Texas Department of Transportation
Traffic Operations Division Standard


**TRAFFIC CONTROL PLAN
LANE CLOSURES ON MULTILANE
CONVENTIONAL ROADS**

TCP (1-4) - 18 (MOD)

FILE: tcp1-4-18.dgn	DN:	CK:	DW:	CK:
© TxDOT December 1985	CONT	SECT	JOB	HIGHWAY
REVISIONS	0111	01	095	FM 521
2-94 4-98	DIST	COUNTY	SHEET NO.	
8-95 2-12	HOU	HARRIS	24	
1-97 2-18				


DISCLAIMER: The use of this standard is governed by the "Texas Engineering Practice Act". No warranty of any kind is made by TxDOT for any purpose whatsoever. TxDOT assumes no responsibility for the conversion of this standard to other formats or for incorrect results or damages resulting from its use.

DATE: FILE:

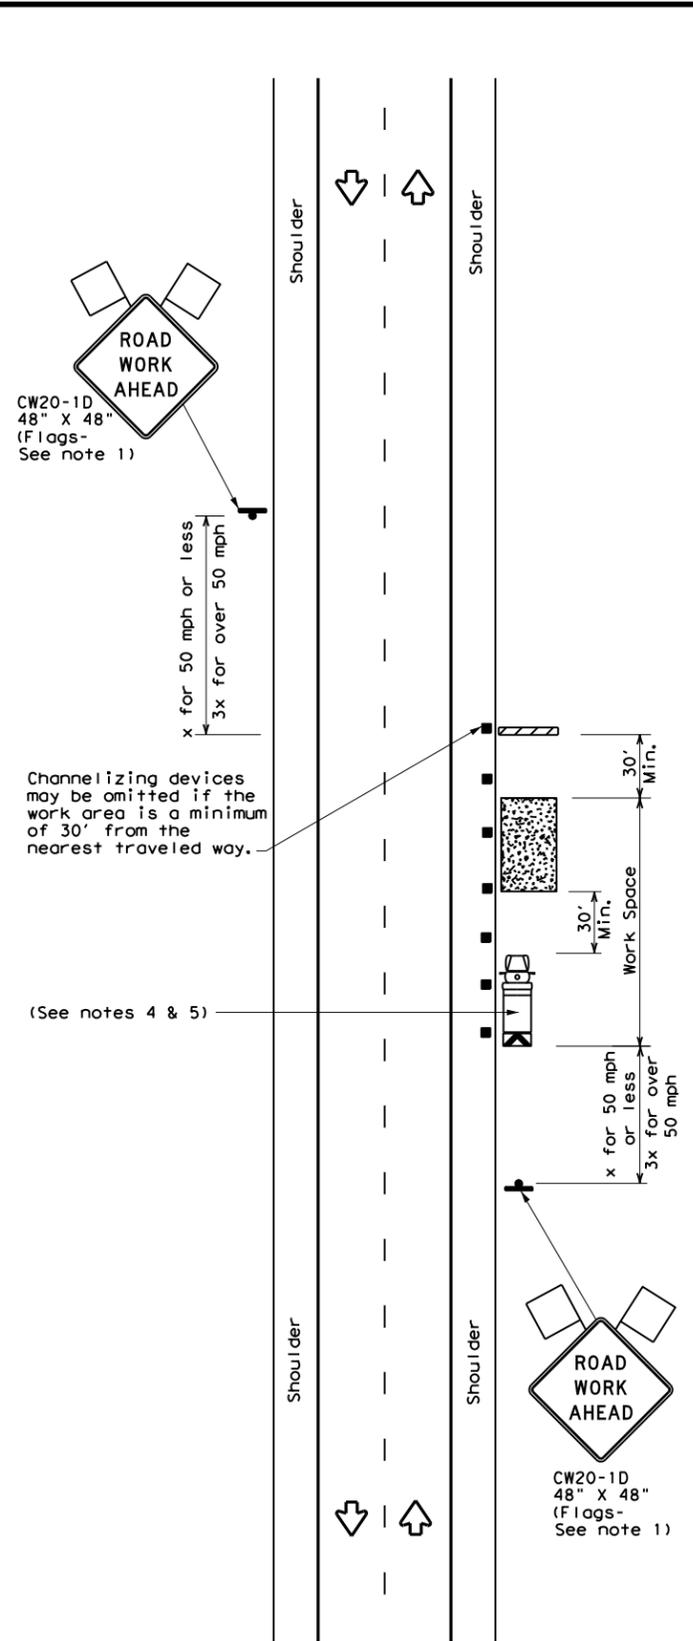


TCP (2-1a)

WORK SPACE NEAR SHOULDER
Conventional Roads

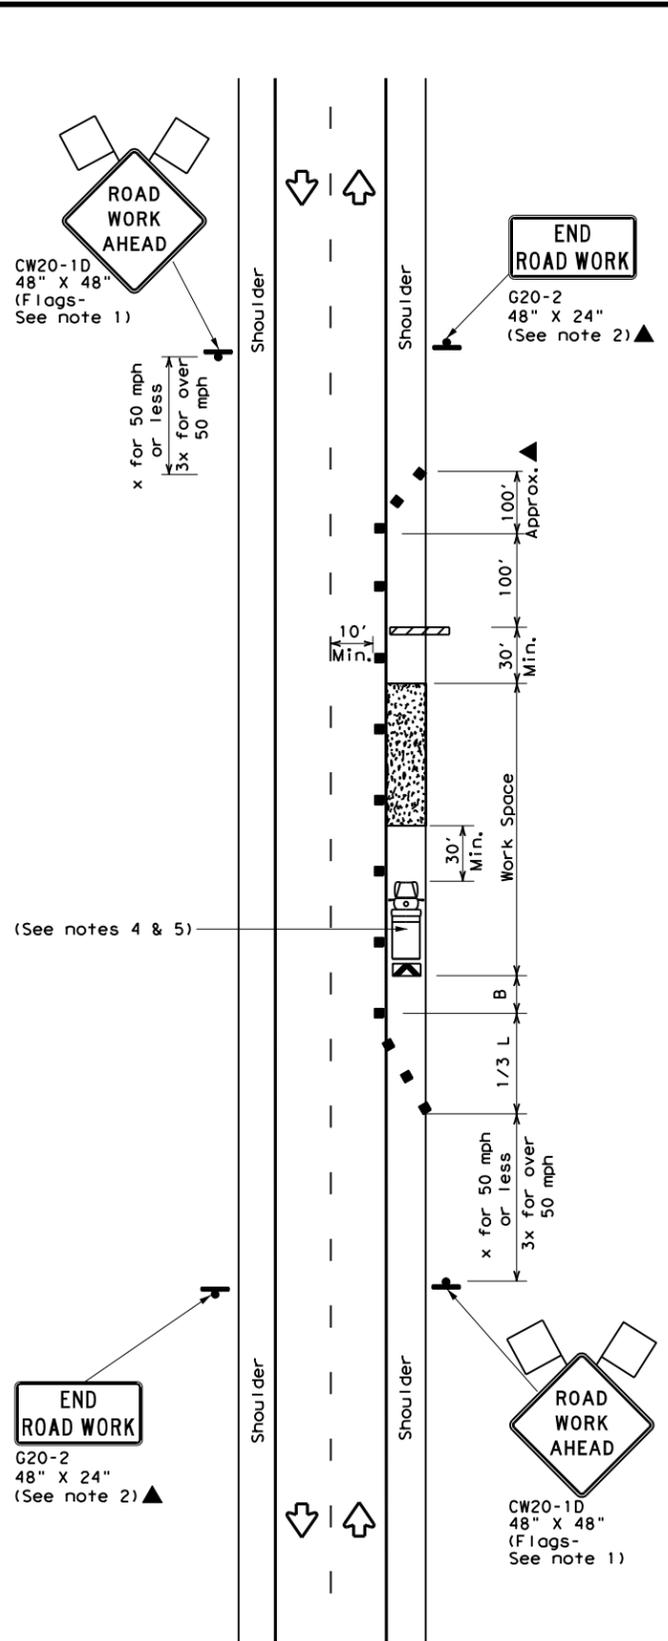

TCP (2-1b)

WORK SPACE ON SHOULDER
Conventional Roads

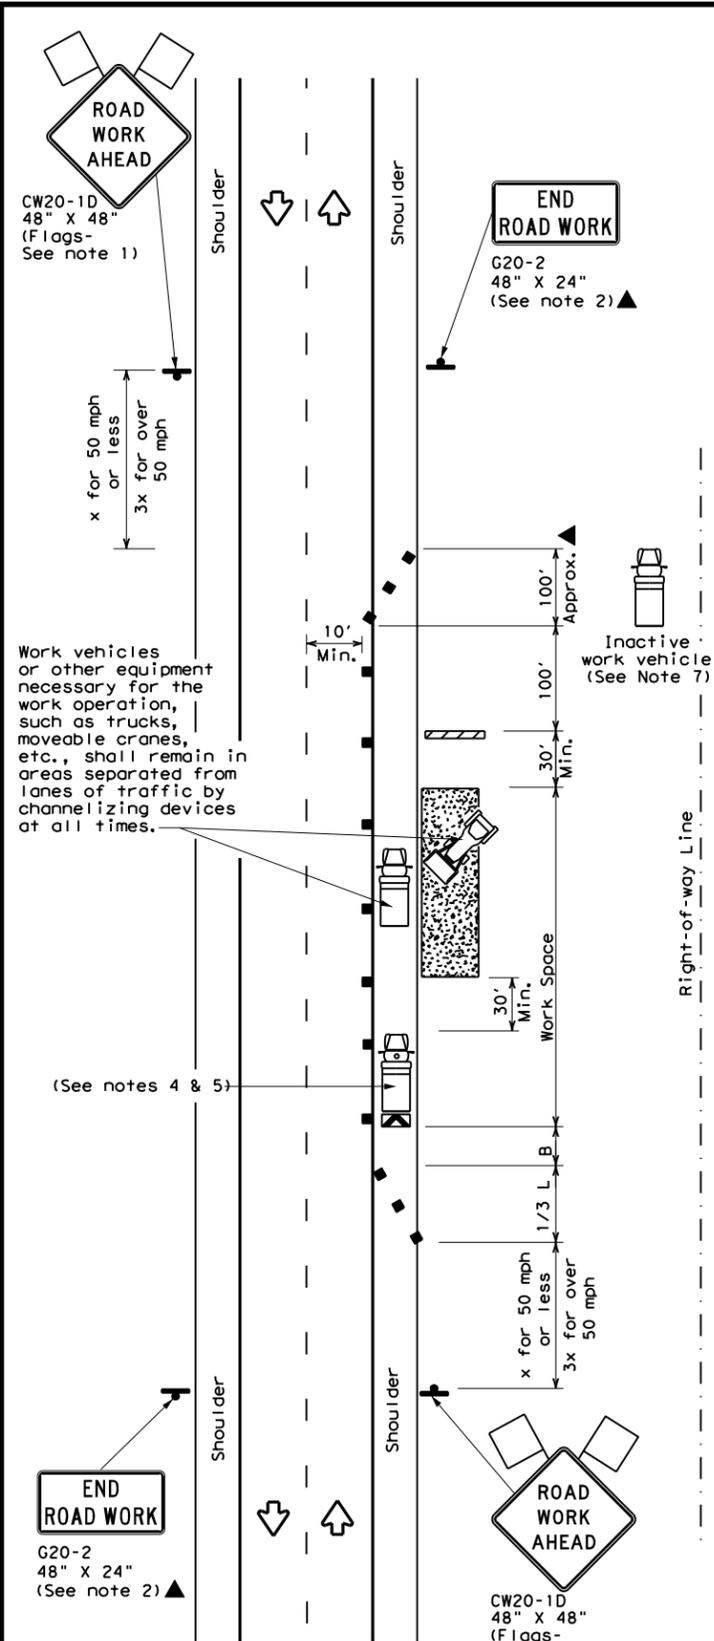

TCP (2-1c)

WORK VEHICLES ON SHOULDER
Conventional Roads

LEGEND			
	Type 3 Barricade		Channelizing Devices
	Heavy Work Vehicle		Truck Mounted Attenuator (TMA)
	Trailer Mounted Flashing Arrow Board		Portable Changeable Message Sign (PCMS)
	Sign		Traffic Flow
	Flag		Flagger

Posted Speed *	Formula	Minimum Desirable Taper Lengths **			Suggested Maximum Spacing of Channelizing Devices		Minimum Sign Spacing "X" Distance	Suggested Longitudinal Buffer Space "B"
		10' Offset	11' Offset	12' Offset	On a Taper	On a Tangent		
30	$L = \frac{WS^2}{60}$	150'	165'	180'	30'	60'	120'	90'
35		205'	225'	245'	35'	70'	160'	120'
40		265'	295'	320'	40'	80'	240'	155'
45	L = WS	450'	495'	540'	45'	90'	320'	195'
50		500'	550'	600'	50'	100'	400'	240'
55		550'	605'	660'	55'	110'	500'	295'
60		600'	660'	720'	60'	120'	600'	350'
65		650'	715'	780'	65'	130'	700'	410'
70	700'	770'	840'	70'	140'	800'	475'	
75	750'	825'	900'	75'	150'	900'	540'	

* Conventional Roads Only
** Taper lengths have been rounded off.
L=Length of Taper (FT) W=Width of Offset (FT) S=Posted Speed (MPH)

TYPICAL USAGE				
MOBILE	SHORT DURATION	SHORT TERM STATIONARY	INTERMEDIATE TERM STATIONARY	LONG TERM STATIONARY
	✓	✓	✓	✓

GENERAL NOTES

- Flags attached to signs where shown, are REQUIRED.
- All traffic control devices illustrated are REQUIRED, except those denoted with the triangle symbol may be omitted when stated in the plans, or for routine maintenance work, when approved by the Engineer.
- Stockpiled material should be placed a minimum of 30 feet from nearest traveled way.
- Shadow Vehicle with TMA and high intensity rotating, flashing, oscillating or strobe lights. A Shadow Vehicle with a TMA should be used anytime it can be positioned 30 to 100 feet in advance of the area of crew exposure without adversely affecting the performance or quality of the work. If workers are no longer present but road or work conditions require the traffic control to remain in place, Type 3 Barricades or other channelizing devices may be substituted for the Shadow Vehicle and TMA.
- Additional Shadow Vehicles with TMAs may be positioned off the paved surface, next to those shown in order to protect a wider work space.
- See TCP(5-1) for shoulder work on divided highways, expressways and freeways.
- Inactive work vehicles or other equipment should be parked near the right-of-way line and not parked on the paved shoulder.
- CW21-5 "SHOULDER WORK" signs may be used in place of CW20-1D "ROAD WORK AHEAD" signs for shoulder work on conventional roadways.




TRAFFIC CONTROL PLAN
CONVENTIONAL ROAD
SHOULDER WORK

TCP (2-1) - 18


FILE: tcp2-1-18.dgn	DN:	CK:	DW:	CK:
© TxDOT December 1985	CONT	SECT	JOB	HIGHWAY
REVISIONS	0111	01	095	FM 521
2-94 4-98	DIST	COUNTY	SHEET NO.	
8-95 2-12	HOU	HARRIS	25	
1-97 2-18				

DISCLAIMER: The use of this standard is governed by the "Texas Engineering Practice Act". No warranty of any kind is made by TxDOT for any purpose whatsoever. TxDOT assumes no responsibility for the conversion of this standard to other formats or for incorrect results or damages resulting from its use.

DATE: 9/18/2020 10:40:53 AM
 FILE: T:\HUM-AO\Design\Roadway\FM_521\0111-01-095\DGN\TCP\026 TCP(2-4)-18.dgn

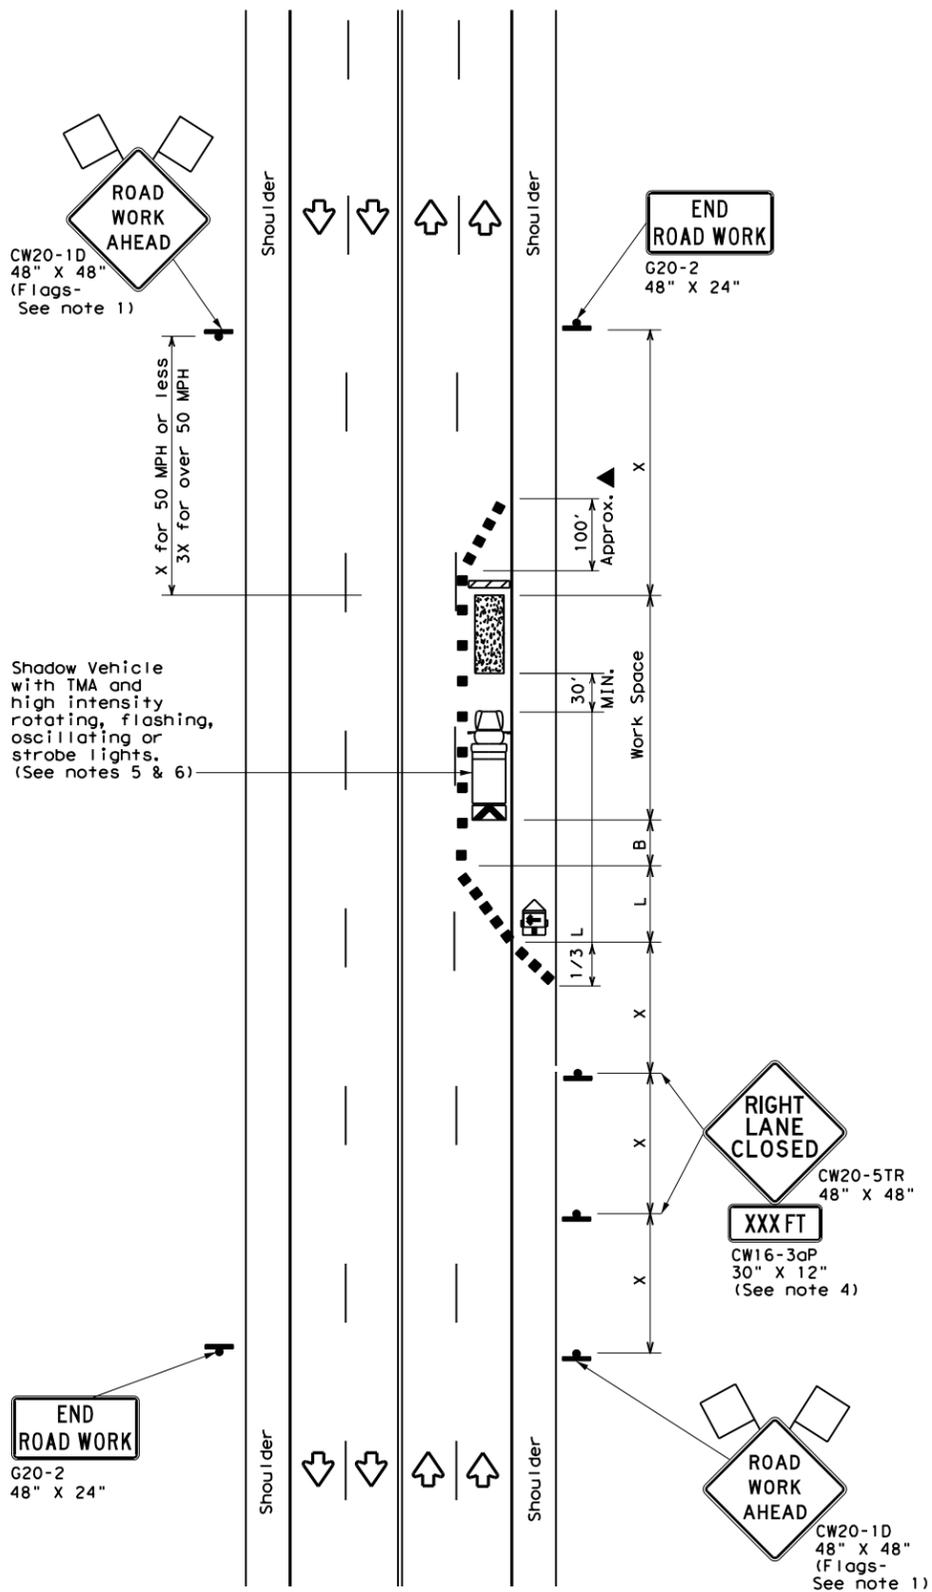

TCP (2-4a)
ONE LANE CLOSED

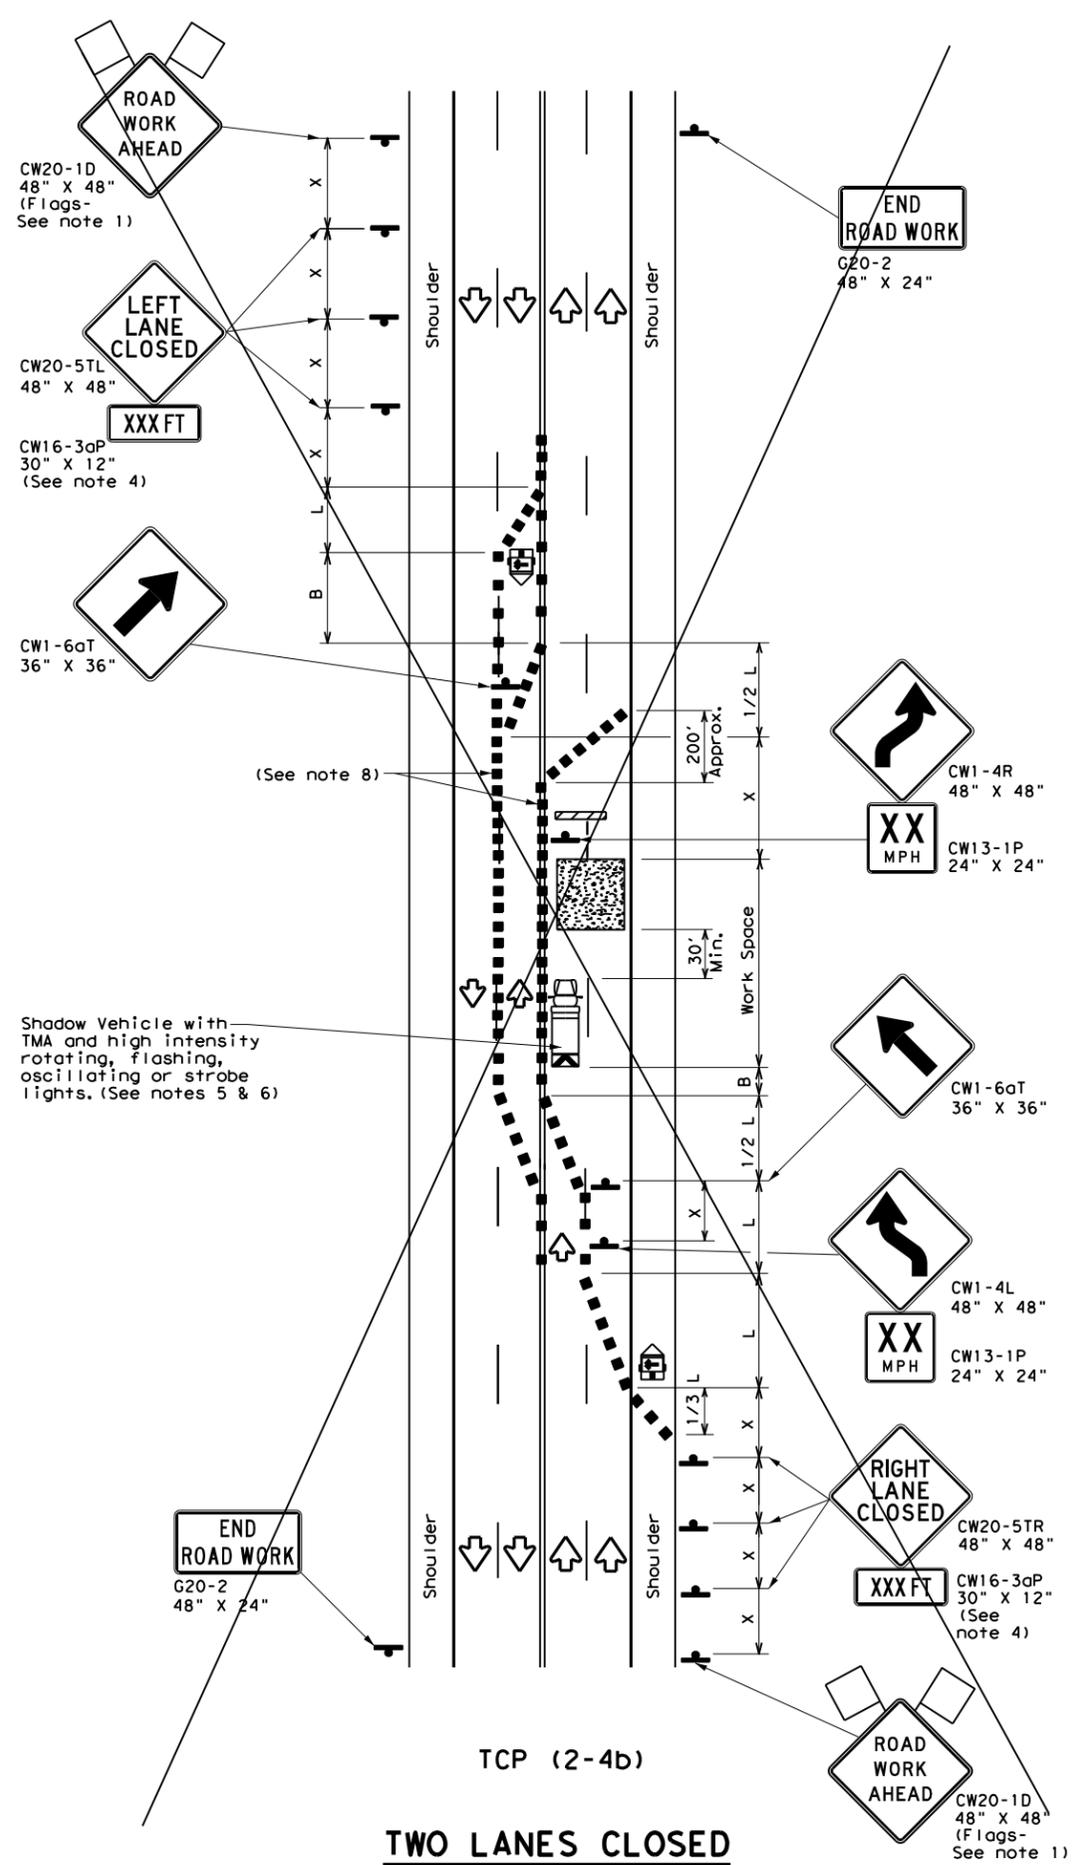

TCP (2-4b)
TWO LANES CLOSED

LEGEND			
	Type 3 Barricade		Channelizing Devices
	Heavy Work Vehicle		Truck Mounted Attenuator (TMA)
	Trailer Mounted Flashing Arrow Board		Portable Changeable Message Sign (PCMS)
	Sign		Traffic Flow
	Flag		Flagger

Posted Speed *	Formula	Minimum Desirable Taper Lengths **			Suggested Maximum Spacing of Channelizing Devices		Minimum Sign Spacing "x" Distance	Suggested Longitudinal Buffer Space "B"
		10' Offset	11' Offset	12' Offset	On a Taper	On a Tangent		
30	L = WS ² / 60	150'	165'	180'	30'	60'	120'	90'
35		205'	225'	245'	35'	70'	160'	120'
40		265'	295'	320'	40'	80'	240'	155'
45	L = WS	450'	495'	540'	45'	90'	320'	195'
50		500'	550'	600'	50'	100'	400'	240'
55		550'	605'	660'	55'	110'	500'	295'
60		600'	660'	720'	60'	120'	600'	350'
65		650'	715'	780'	65'	130'	700'	410'
70		700'	770'	840'	70'	140'	800'	475'
75		750'	825'	900'	75'	150'	900'	540'

* Conventional Roads Only
 ** Taper lengths have been rounded off.
 L=Length of Taper (FT) W=Width of Offset (FT) S=Posted Speed (MPH)

TYPICAL USAGE				
MOBILE	SHORT DURATION	SHORT TERM STATIONARY	INTERMEDIATE TERM STATIONARY	LONG TERM STATIONARY
		✓	✓	

GENERAL NOTES


- Flags attached to signs where shown, are REQUIRED.
- All traffic control devices illustrated are REQUIRED, except those denoted with the triangle symbol may be omitted when stated elsewhere in the plans, or for routine maintenance work, when approved by the Engineer.
- The downstream taper is optional. When used, it should be 100 feet minimum length per lane.
- For short term applications, when post mounted signs are not used, the distance legend may be shown on the sign face rather than on a CW16-3aP supplemental plaque.
- A Shadow Vehicle with a TMA should be used anytime it can be positioned 30 to 100 feet in advance of the area of crew exposure without adversely affecting the performance or quality of the work. If workers are no longer present but road or work conditions require the traffic control to remain in place, Type 3 Barricades or other channelizing devices may be substituted for the Shadow Vehicle and TMA.
- Additional Shadow Vehicles with TMAs may be positioned in each closed lane, on the shoulder or off the paved surface, next to those shown in order to protect a wider work space.

TCP (2-4a)

- If this TCP is used for a left lane closure, CW20-5TL "LEFT LANE CLOSED" signs shall be used and channelizing devices shall be placed on the centerline to protect the work space from opposing traffic with the arrow board placed in the closed lane near the end of the merging taper.

TCP (2-4b)



- For shorter durations where traffic is directed over a yellow centerline, channelizing devices which separate two-way traffic should be spaced on tapers at 20' or 15' if posted speeds are 35 mph or slower, and for tangent sections, at 1/2(S) where S is the speed in mph. This tighter devices spacing is intended for the area of conflicting markings, not the entire work zone.

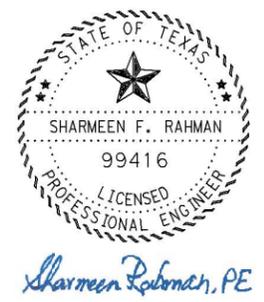



Sharmeen Rahman, PE
 11.30.2020

Texas Department of Transportation		Traffic Operations Division Standard	
TRAFFIC CONTROL PLAN LANE CLOSURES ON MULTILANE CONVENTIONAL ROADS			
TCP (2-4) - 18 (MOD)			
FILE: tcp2-4-18.dgn	DN:	CK:	DW: CK:
© TxDOT December 1985	CONT	SECT	JOB HIGHWAY
REVISIONS	0111	01	095 FM 521
8-95 3-03	DIST	COUNTY	SHEET NO.
1-97 2-12	HOU	HARRIS	26
4-98 2-18			

DATE: 9/28/2020 11:15:02 AM
 FILE: T:\HUM-AO\Design\Roadway\FM_521\0111-01-095\DGN\TCP\027 TCP(3-2)-13.dgn
 DISCLAIMER: The use of this standard is governed by the "Texas Engineering Practice Act". No warranty of any kind is made by TxDOT for any purpose whatsoever. TxDOT assumes no responsibility for the conversion of this standard to other formats or for incorrect results or damages resulting from its use.

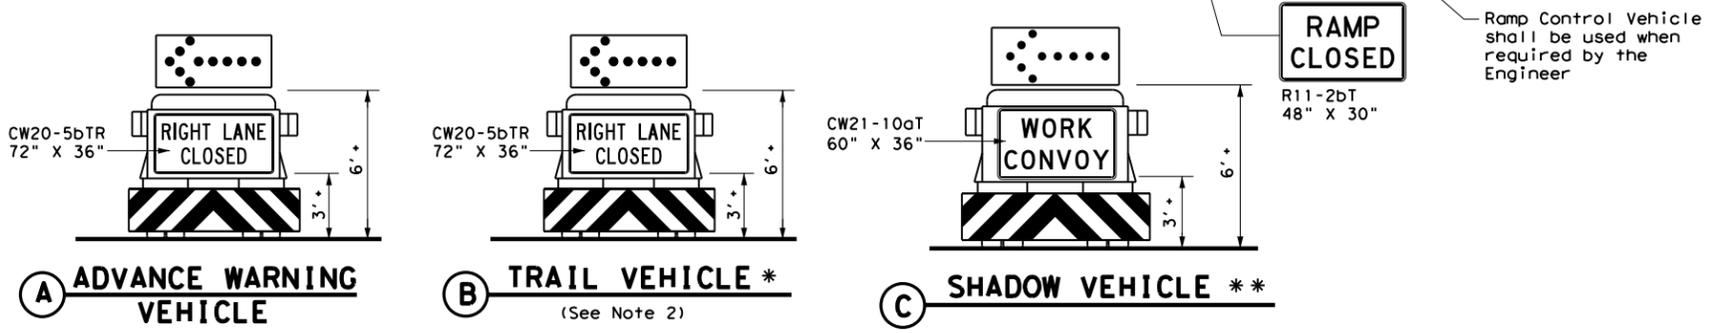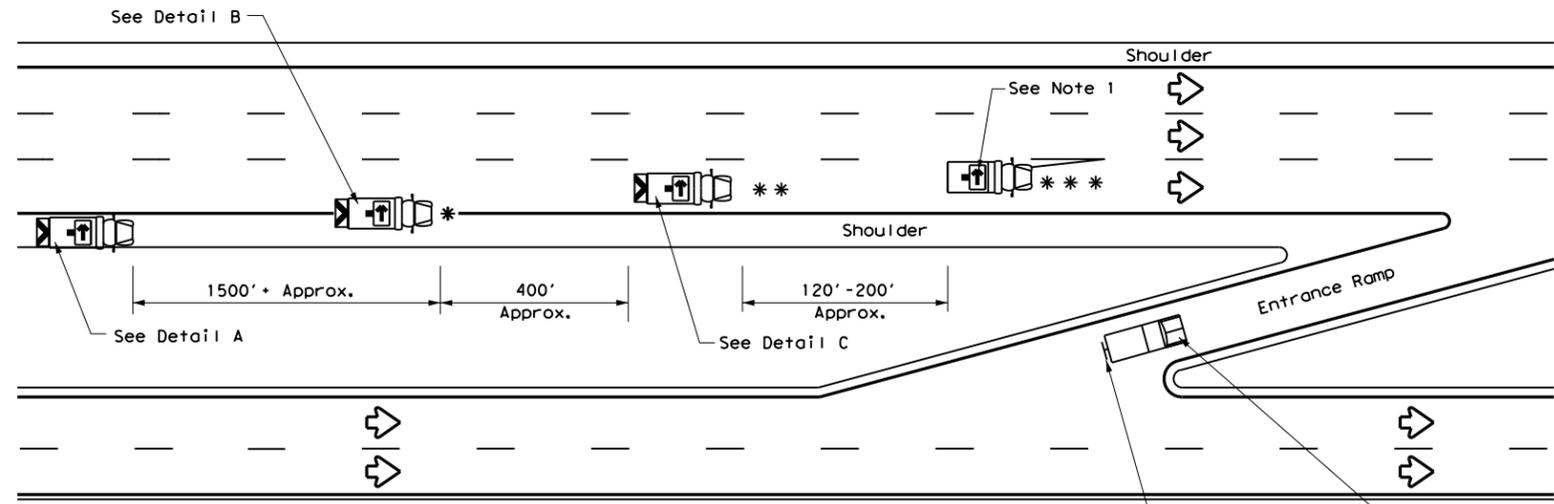

RIGHT LANE CLOSURE ON DIVIDED HIGHWAY - TCP(3-2a)

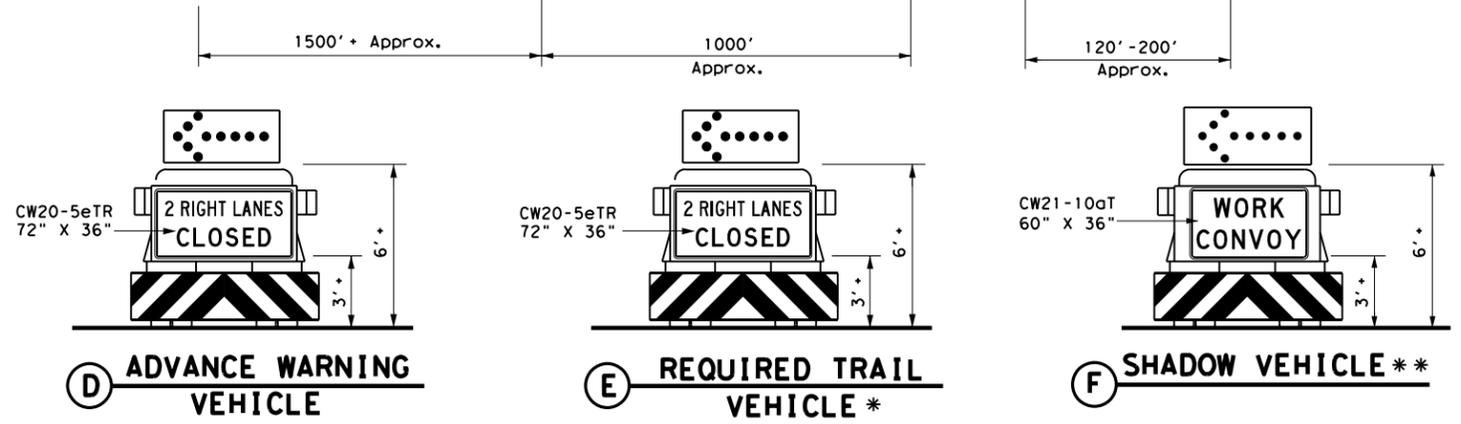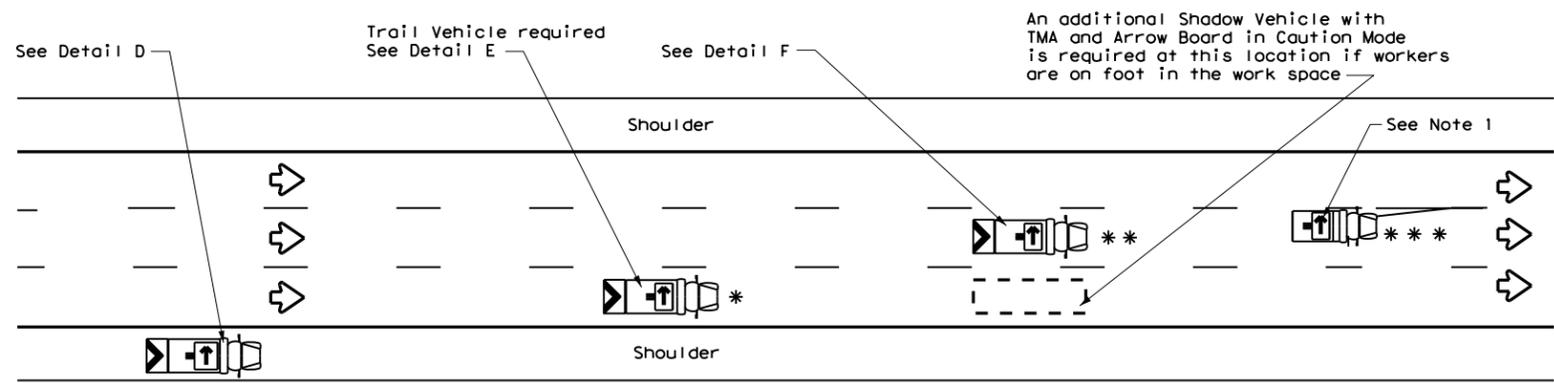


INTERIOR LANE CLOSURE ON MULTI-LANE DIVIDED HIGHWAY - TCP(3-2b)

LEGEND			
*	Trail Vehicle	ARROW BOARD DISPLAY	
**	Shadow Vehicle		
***	Work Vehicle		RIGHT Directional
	Heavy Work Vehicle		LEFT Directional
	Truck Mounted Attenuator (TMA)		Double Arrow
	Traffic Flow		CAUTION (Alternating Diamond or 4 Corner Flash)

TYPICAL USAGE				
MOBILE	SHORT DURATION	SHORT TERM STATIONARY	INTERMEDIATE TERM STATIONARY	LONG TERM STATIONARY
<input checked="" type="checkbox"/>	<input type="checkbox"/>	<input type="checkbox"/>	<input type="checkbox"/>	<input type="checkbox"/>

GENERAL NOTES









- ADVANCE WARNING, TRAIL and SHADOW vehicles shall be equipped with Type B or Type C flashing arrow boards as per the Barricade and Construction (BC) standards. Arrow boards on WORK vehicles will be optional based on the type of work being performed. The arrow boards shall be operated from inside the vehicle.
- For TCP(3-2a) the Engineer will determine if the TRAIL VEHICLE is required based on prevailing roadway conditions, traffic volume, and sight distance restrictions. All other vehicles shown for both TCP(3-2a) and TCP(3-2b) are required.
- The use of amber high intensity rotating, flashing, oscillating, or strobe lights on vehicles are required. Blue high intensity rotating, flashing, oscillating or strobe lights when mounted on the driver's side of the vehicle may be operated simultaneously with the amber beacons or strobe lights.
- The use of truck mounted attenuators (TMA) on the ADVANCE WARNING, SHADOW, and TRAIL vehicles are required.
- Reflective sheeting on the rear of the TMA shall meet or exceed the reflectivity and color requirements of DMS 8300, Type A.
- Each vehicle shall have two-way radio communication capability.
- When work convoys must change lanes, the TRAIL VEHICLE should change lanes first to shadow the other convoy vehicles.
- Vehicle spacing between the TRAIL VEHICLE and the SHADOW VEHICLE will vary depending on sight distance restrictions. Motorists approaching the work convoy should be able to see the TRAIL VEHICLE in time to slow down and/or change lanes as they approach the TRAIL VEHICLE. Vehicle spacing between the WORK VEHICLE and SHADOW VEHICLE may vary according to terrain, work activity and other factors.
- Standard 48" X 48" diamond shaped warning signs with the same message as those shown may be used where adequate mounting space exists.
- The signs shown should be used on the Advance Warning Vehicle. As an option, a portable changeable message sign (PCMS) or a truck mounted changeable message sign (TMCMS) with a minimum character height of 12", and displaying the same legend may be substituted for these signs. An appropriate directional arrow display, simulating the size and legibility of the flashing arrow board, must be used in the second phase of the PCMS/TMCMS message. When this is done, the arrow board will not be required on the Advance Warning Vehicle.
- Standard diamond shape versions of the CW20-5 series signs may be used as an option if the rectangular signs shown are not available.
- The principles on this sheet may be used to close lanes from the left side of the roadway considering the number of lanes, shoulder width, sight distance, and ramp frequency.
- Signs and flashing arrow board modes shall be appropriately altered when implementing left lane closures or interior closures which close the left lanes.
- The Advance Warning Vehicle may straddle the edgeline when shoulder width makes it necessary.

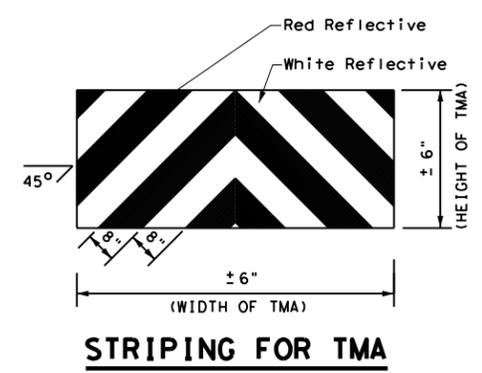

STRIPING FOR TMA

		Traffic Operations Division Standard	
TRAFFIC CONTROL PLAN MOBILE OPERATIONS DIVIDED HIGHWAYS			
TCP(3-2)-13			
FILE: tcp3-2.dgn	DN: TxDOT	CK: TxDOT	DW: TxDOT
© TxDOT December 1985	CONT SECT	JOB	HIGHWAY
REVISIONS	0111 01	095	FM 521
2-94 4-98			
8-95 7-13			
1-97			
	DIST	COUNTY	SHEET NO.
	HOU	HARRIS	27

DATE: 9/18/2020 10:58:56 AM
 FILE: T:\HUM-AOV\Design\Roadway\FM_521\01111-01-095\DGN\TCP\028 TCP (3-3) -14.dgn
 The use of this standard is governed by the "Texas Engineering Practice Act". No warranty of any kind is made by TxDOT for any purpose whatsoever. TxDOT assumes no responsibility for the conversion of this standard to other formats or for incorrect results or damages resulting from its use.

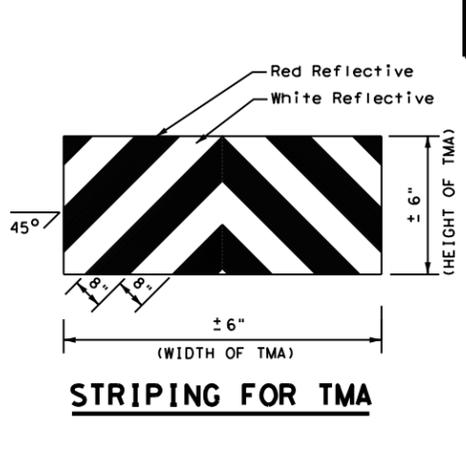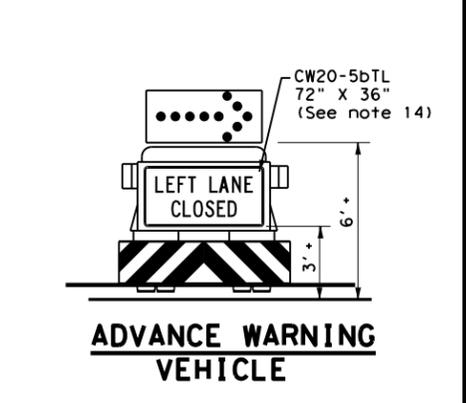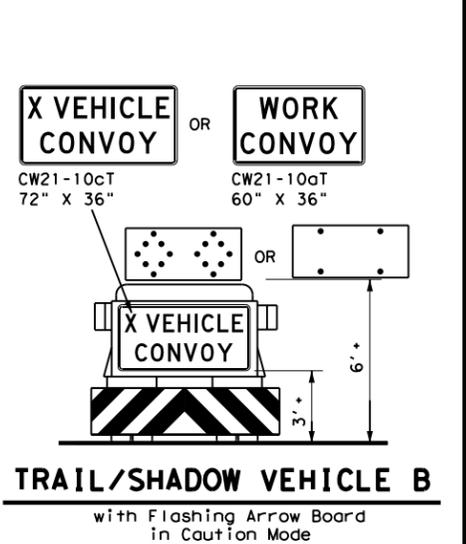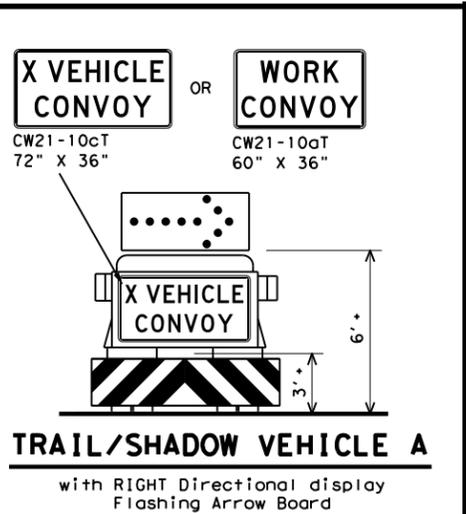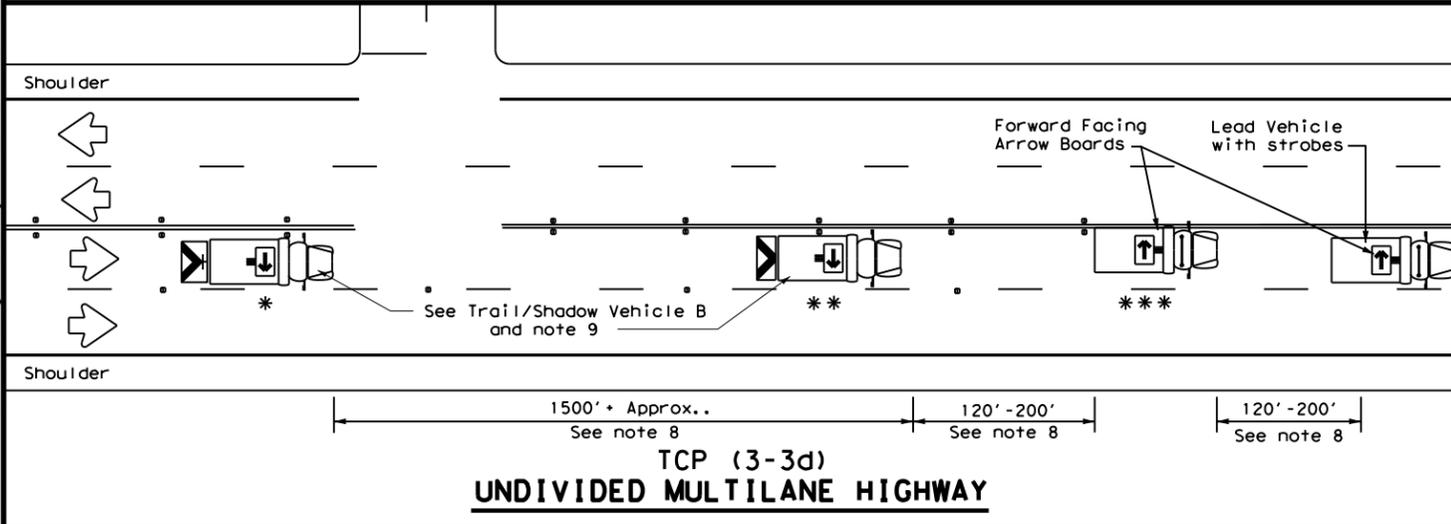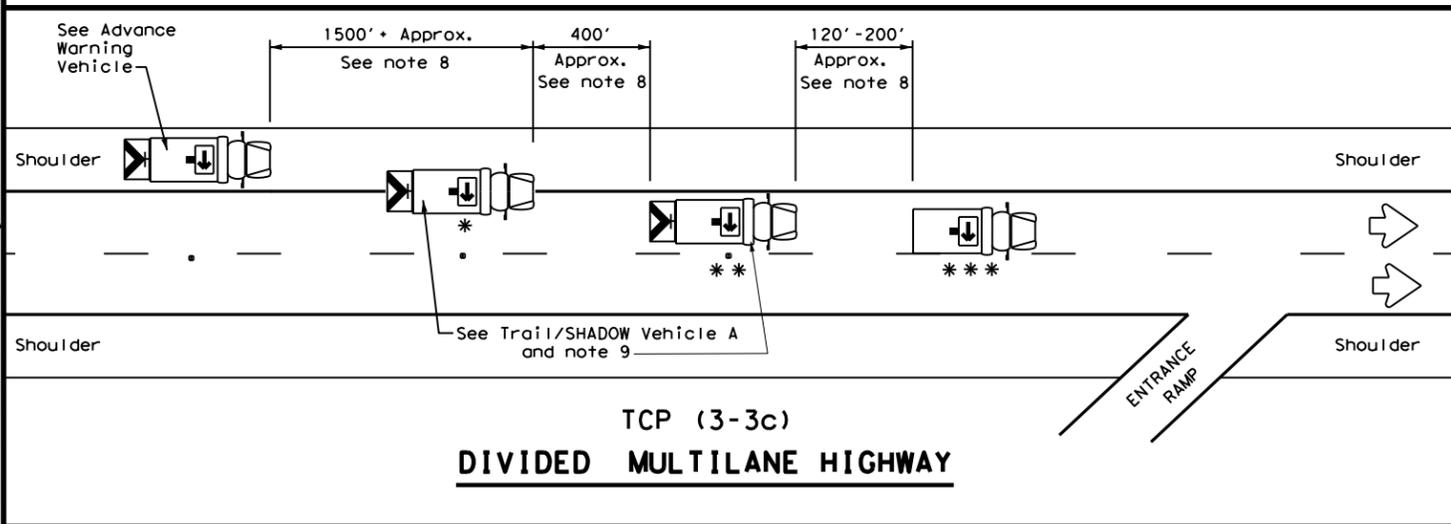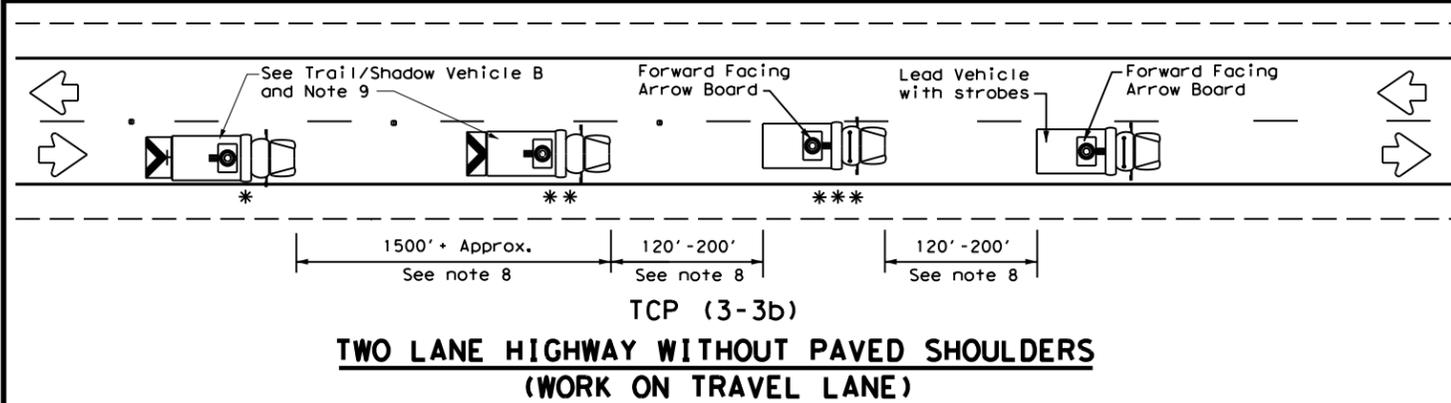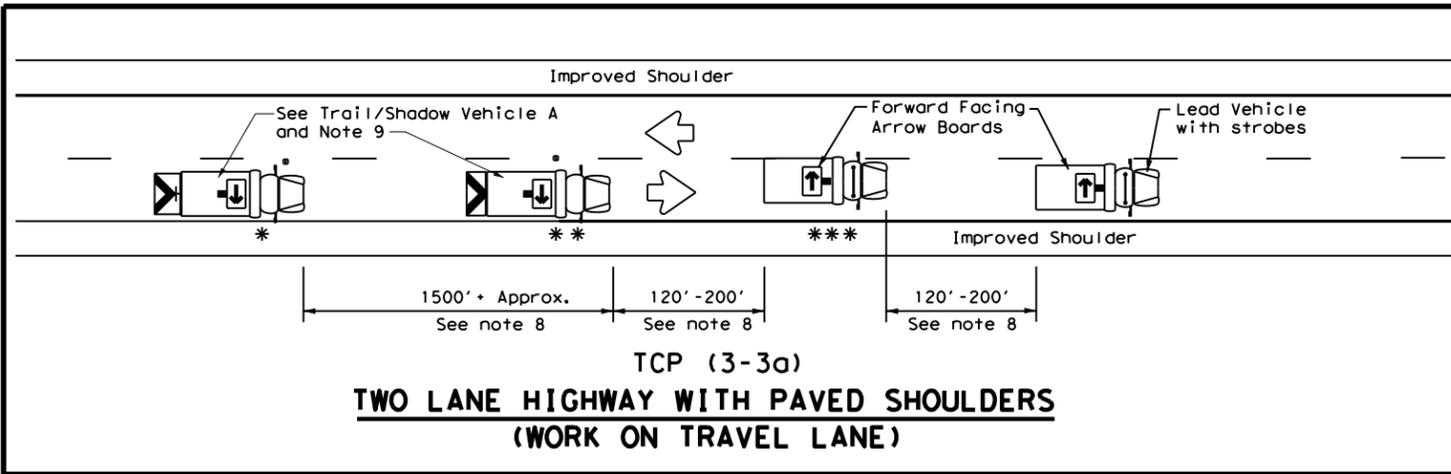

LEGEND		
* Trail Vehicle	ARROW BOARD DISPLAY	
** Shadow Vehicle		
*** Work Vehicle		RIGHT Directional
Heavy Work Vehicle		LEFT Directional
Truck Mounted Attenuator (TMA)		Double Arrow
Traffic Flow		CAUTION (Alternating Diamond or 4 Corner Flash)

TYPICAL USAGE				
MOBILE	SHORT DURATION	SHORT TERM STATIONARY	INTERMEDIATE TERM STATIONARY	LONG TERM STATIONARY
✓				

GENERAL NOTES

- TRAIL, SHADOW, and LEAD vehicles shall be equipped with arrow boards as illustrated. When a LEAD vehicle is not used on two way roads the WORK vehicle must have an arrow board. For divided roadways, the arrow board on the WORK vehicle is optional based on the type of work being performed. The Engineer will determine if the LEAD vehicle and/or TRAIL vehicle are required based on prevailing roadway conditions, traffic volume, and sight distance restrictions.
- The use of amber high intensity rotating, flashing, oscillating, or strobe lights on vehicles are required. Blue high intensity rotating, flashing, oscillating, or strobe lights when mounted on the driver's side of the vehicle may be operated simultaneously with the amber beacons or strobe lights.
- The use of truck mounted attenuators (TMA) on the SHADOW VEHICLE, ADVANCE WARNING and TRAIL VEHICLE are required.
- Reflective sheeting on the rear of the TMA shall meet or exceed the reflectivity and color requirements of DEPARTMENTAL MATERIAL SPECIFICATION DMS 8300, Type A.
- Flashing arrow boards shall be Type B or Type C as per the Barricade and Construction (BC) standards. The board shall be controlled from inside the vehicle.
- Each vehicle shall have two-way radio communication capability.
- When work convoys must change lanes, the TRAIL VEHICLE should change lanes first to shadow the other convoy vehicles.
- Vehicle spacing between the TRAIL VEHICLE and the SHADOW VEHICLE will vary depending on sight distance restrictions. Motorists approaching the convoy should be able to see the TRAIL VEHICLE in time to slow down and/or change lanes as they approach the TRAIL VEHICLE. Vehicle spacing between the WORK VEHICLE and SHADOW VEHICLE and vehicle spacing between WORK VEHICLE and LEAD VEHICLE may vary according to terrain, work activity and other factors.
- X VEHICLE CONVOY (CW21-10cT) or WORK CONVOY (CW21-10aT) signs shall be used on TRAIL VEHICLES and SHADOW VEHICLES as shown. As an option 48" x 48" diamond shaped WORK CONVOY (CW21-10T) or X VEHICLE CONVOY (CW21-10bT) signs may be used where adequate mounting space exists. When used, the X VEHICLE CONVOY sign shall have the number of the convoy vehicles displayed on the sign in the number designation "X" location. The X VEHICLE CONVOY sign shall not be used on the SHADOW VEHICLE if a TRAIL VEHICLE is used.
- For divided highways with two or three lanes in one direction, the appropriate LEFT LANE CLOSED (CW20-5bTL), RIGHT LANE CLOSED (CW20-5bTR), or CENTER LANE CLOSED (CW20-5dT) sign should be used on the Advance Warning Vehicle. As an option, a portable changeable message sign (PCMS) or truck mounted changeable message sign (TMCMS) with a minimum character height of 12", and displaying the same legend may be substituted for these signs. An appropriate directional arrow display, simulating the size and legibility of the flashing arrow board may be used in the second phase of the PCMS/TMCMS message. When this is done, the arrow board will not be required on the Advance Warning Vehicle.
- A double arrow shall not be displayed on the arrow board on the Advance Warning Vehicle.
- For divided highways with three or four lanes in each direction, use TCP(3-2).
- Standard diamond shape versions of the CW20-5 series signs may be used as an option if the rectangular signs shown are not available.
- The Advance Warning Vehicle may straddle the edgeline when Shoulder width makes it necessary.
- On two-lane two-way roadways, the work and protection vehicles should pull over periodically to allow motor vehicle traffic to pass. If motorists are not allowed to pass the work convoy, a DO NOT PASS (R4-1) sign should be placed on the back of the rearmost protection vehicle.


Texas Department of Transportation
 Traffic Operations Division Standard

TRAFFIC CONTROL PLAN
MOBILE OPERATIONS
RAISED PAVEMENT
MARKER INSTALLATION/
REMOVAL
TCP (3-3) - 14

FILE: tcp3-3.dgn	DW: TxDOT	CK: TxDOT	DW: TxDOT	CK: TxDOT
© TxDOT September 1987	CONT	SECT	JOB	HIGHWAY
REVISIONS	0111	01	095	FM 521
2-94 4-98	DIST	COUNTY	SHEET NO.	
8-95 7-13	HOU	HARRIS	28	
1-97 7-14				


DISCLAIMER: The use of this standard is governed by the "Texas Engineering Practice Act". No warranty of any kind is made by TxDOT for any purpose whatsoever. TxDOT assumes no responsibility for the conversion of this standard to other formats or for incorrect results or damages resulting from its use.

DATE: 9/18/2020 11:12:22 AM
 FILE: T:\HUM-AO\Design\Roadway\FM_521\0111-01-095\DGN\TCP\029 TCP(7-1)-13.dgn

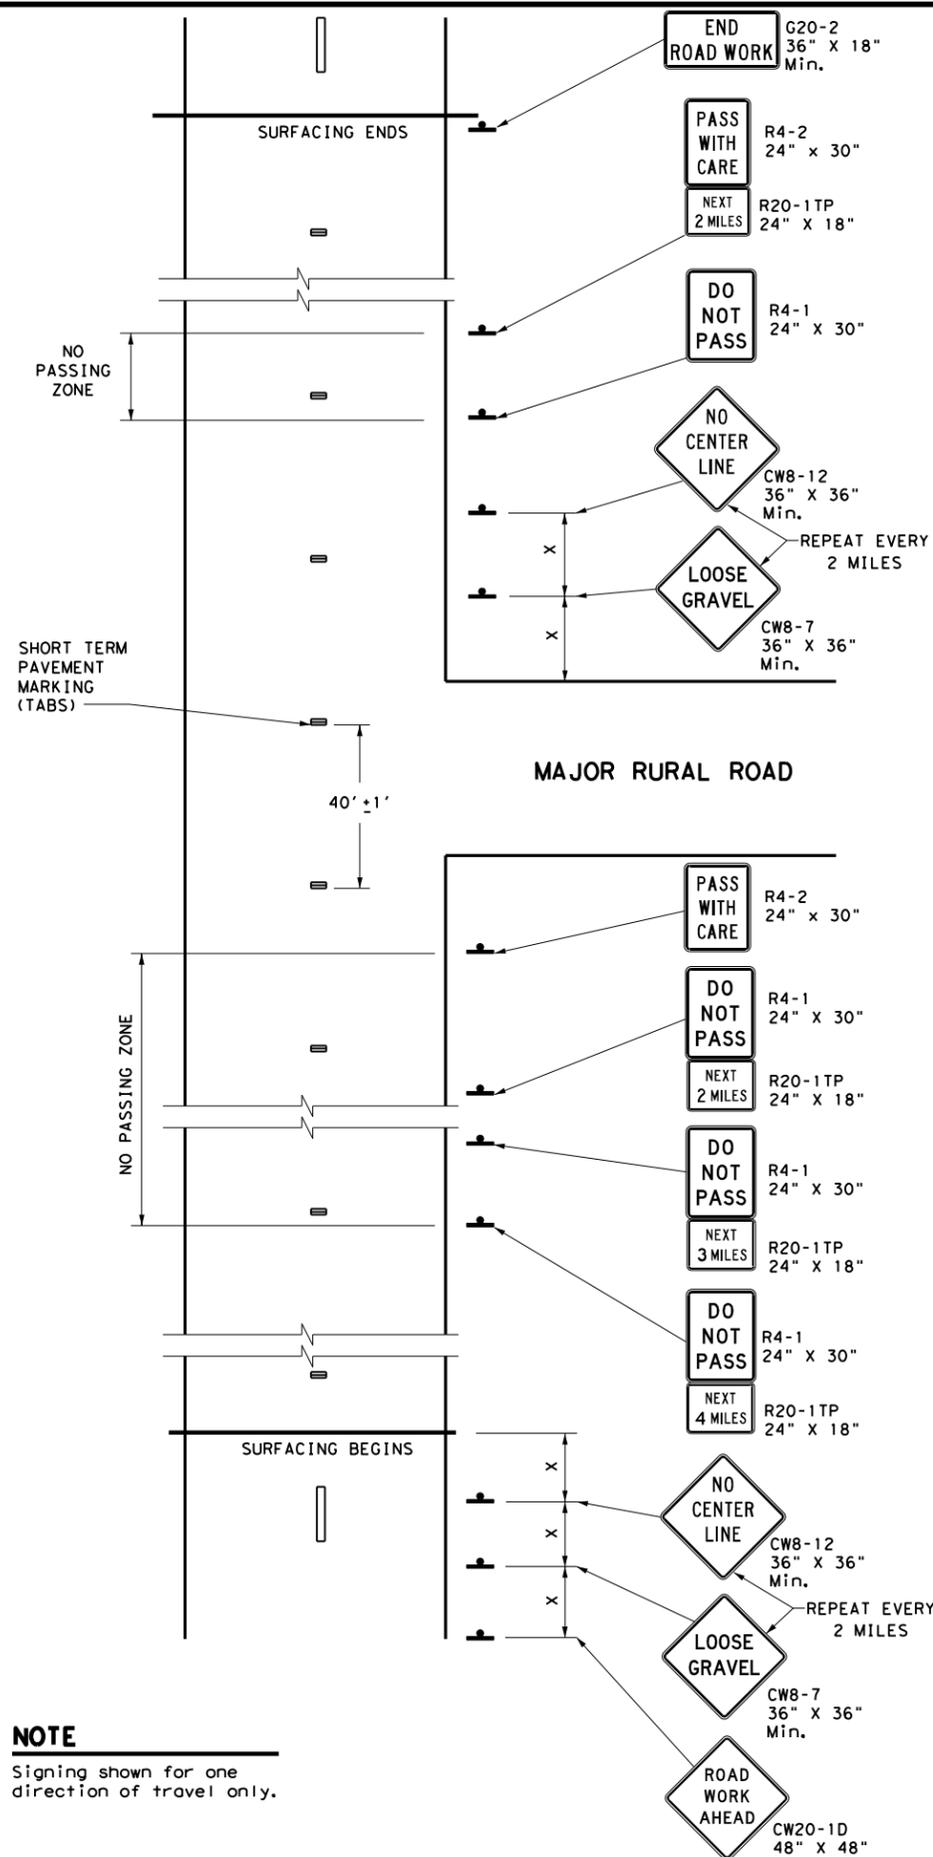

NOTE
 Signing shown for one direction of travel only.

NO PASSING ZONES ON TWO-LANE TWO-WAY ROADS

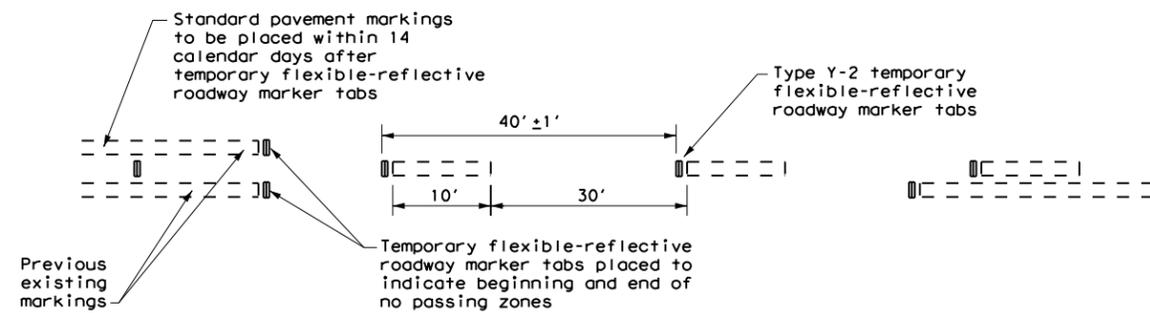

TABS ON CENTERLINES OF TWO-LANE TWO-WAY ROADS
 For seal coat, micro-surface or similar operations

"DO NOT PASS" SIGN (R4-1) and NO-PASSING ZONES

- A. Prior to the beginning of construction, all currently striped no-passing zones shall be signed with the DO NOT PASS (R4-1) signs and PASS WITH CARE (R4-2) signs placed at the beginning and end of each zone for each direction of travel except as otherwise provided herein. Signs marking these individual no-passing zones need not be covered prior to construction if the signs supplement the existing pavement markings.
- B. At the discretion of the Engineer, in areas of numerous no-passing zones, several zones may be combined as a single zone. If passing is to be prohibited over one or more lengthy sections, a DO NOT PASS sign and a NEXT XX MILES (R20-1TP) plaque may be used at the beginning of such zones. The DO NOT PASS sign and the NEXT XX MILES plaque should be repeated every mile to the end of the no-passing zone. In areas where there is considerable distance between no-passing zones, the end of the no-passing zone may be signed with a PASS WITH CARE sign and a NEXT XX MILES plaque.
- C. Depending on traffic volumes and length of sections, it may be desirable to prohibit passing throughout the project to prevent damage to windshield and lights. The DO NOT PASS sign and NEXT XX MILES plaque should be used and repeated as often as necessary for this purpose. Where several existing zones are to be combined into one individual no-passing zone, the sign at the beginning of the zone should be covered until the surfacing operation has passed this location so as not to have the DO NOT PASS sign conflict with the existing pavement markings. Also, unless one days operation completes the entire length of such combined zones, appropriate DO NOT PASS and PASS WITH CARE signs should be placed at the beginning and end of the no-passing zones where the surfacing operation has stopped for the day.
- D. R4-1 and R4-2 are to remain in place until standard pavement markings are installed.

"NO CENTER LINE" SIGN (CW8-12)

- A. Center line markings are yellow pavement markings that delineate the separation of travel lanes that have opposite directions of travel on a roadway. Divided highways do not typically have center line markings.
- B. At the time construction activity obliterates the existing center line markings (low volume roads may not have an existing centerline), a NO CENTER LINE (CW8-12) sign should be erected at the beginning of the work area, at approximately 2 mile intervals within the work area, beyond major intersections and other locations deemed necessary by the Engineer.
- C. The NO CENTER LINE signs are to remain in place until standard pavement markings are installed.

"LOOSE GRAVEL" SIGN (CW8-7)

- A. When construction begins, a LOOSE GRAVEL (CW8-7) sign should be erected at each end of the work area and repeated at intervals of approximately 2 miles in rural areas and closer in urban areas.
- B. The LOOSE GRAVEL signs are to remain in place until the condition no longer exists.

PAVEMENT MARKINGS

- A. Temporary markings for surfacing projects shall be Temporary Flexible-reflective Roadway Marker Tabs unless otherwise approved by the Engineer. Tabs are to be installed to provide true alignment for striping crews or as directed by the Engineer. Tabs will be placed at the spacing indicated. Tabs should be applied to the pavement no more than two (2) days before the surfacing is applied. After the surfacing is rolled and swept, the cover over the reflective strip shall be removed.
- B. Tabs shall not be used to simulate edge lines.
- C. Tab placement for overlay/inlay operations shall be as shown on the WZ(STPM) standard sheet.

COORDINATION OF SIGN LOCATIONS

- A. The location of warning signs at the beginning and end of a work area are to be coordinated with other signing typically shown on the Barricade and Construction Standards for project limits to ensure adequate sign spacing.
- B. Where possible the ROAD WORK AHEAD (CW20-1D), LOOSE GRAVEL (CW8-7), and NO CENTER LINE (CW8-12) signs should be placed in the sequence shown following the OBEY WARNING SIGNS STATE LAW (R20-3T) and the TRAFFIC FINES DOUBLE (R20-5T) sign, and one "X" sign spacing prior to the CONTRACTOR (G20-6T) sign typically located at or near the limits of surfacing. LOOSE GRAVEL and NO CENTER LINE signs will then be repeated as described above.

Posted Speed *	Minimum Sign Spacing "X" Distance
30	120'
35	160'
40	240'
45	320'
50	400'
55	500'
60	600'
65	700'
70	800'
75	900'

* Conventional Roads Only

TYPICAL USAGE				
MOBILE	SHORT DURATION	SHORT TERM STATIONARY	INTERMEDIATE TERM STATIONARY	LONG TERM STATIONARY
			✓	✓

GENERAL NOTES

1. The traffic control devices detailed on this sheet will be furnished and erected as directed by the Engineer on sections of roadway where tabs must be placed prior to the surfacing operation which will cover or obliterate the existing pavement markings.
2. The devices shown on this sheet are to be used to supplement those required by the BC Standards or others required elsewhere in the plans.
3. Signs shall be erected as detailed on the BC Standards or the Compliant Work Zone Traffic Control Devices List (CWZTCD) on supports approved for Long-Term / Intermediate-Term Work Zone Sign Supports.
4. When surfacing operations take place on divided highways, freeways or expressways, the size of diamond shaped construction warning signs shall be 48" x 48".
5. Signs on divided highways, freeways and expressways will be placed on both right and left sides of the roadway based on roadway conditions as directed by the Engineer.




TRAFFIC CONTROL DETAILS FOR SURFACING OPERATIONS

TCP (7-1) - 13

FILE:	tcp7-1.dgn	DW:	TxDOT	CK:	TxDOT	DW:	TxDOT	CK:	TxDOT
© TxDOT	March 1991	CONT:	0111	SECT:	01	JOB:	095	HIGHWAY:	FM 521
REVISIONS:	4-92 4-98	DIST:	HOU	COUNTY:	HARRIS	SHEET NO.:	29		

DISCLAIMER: The use of this standard is governed by the "Texas Engineering Practice Act". No warranty of any kind is made by TxDOT for any purpose whatsoever. TxDOT assumes no responsibility for the conversion of this standard to other formats or for incorrect results or damages resulting from its use.

DATE: 9/18/2020 11:04:38 AM
 FILE: T:\HUM-AO\Design\Roadway\FM 521\0111-01-095\DGN\TCP\030_WZ(BRK)-13.dgn

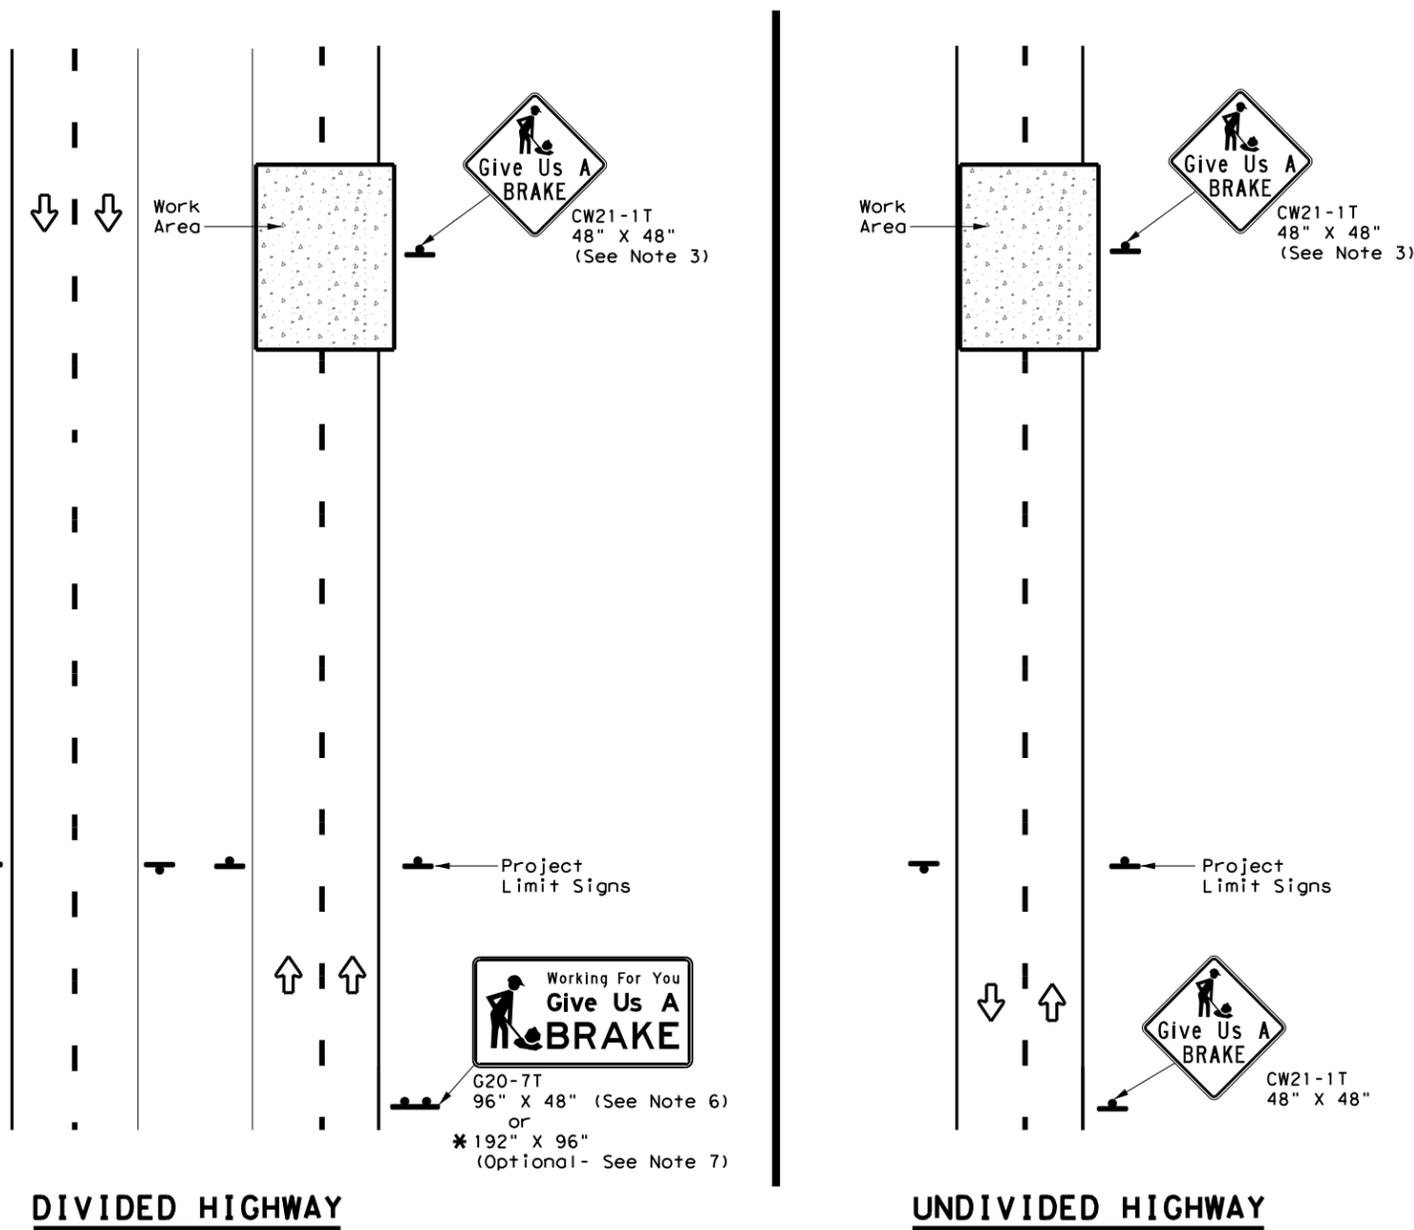

DIVIDED HIGHWAY

UNDIVIDED HIGHWAY

SIGNS ARE SHOWN FOR ONE DIRECTION OF TRAVEL

* When the optional larger WORKING FOR YOU GIVE US A BRAKE (G20-7T) 192" x 96" sign is required, the locations shall be noted elsewhere in the plans.

SUMMARY OF LARGE SIGNS

BACKGROUND COLOR	SIGN DESIGNATION	SIGN	SIGN DIMENSIONS	REFLECTIVE SHEETING	SQ FT	GALVANIZED STRUCTURAL STEEL		DRILLED SHAFT
						Size	(LF)	
							① ②	24" DIA. (LF)
Orange	G20-7T		96" X 48"	Type B _{FL} or C _{FL}	32	▲	▲ ▲	▲
Orange	G20-7T		192" X 96"	Type B _{FL} or C _{FL}	128	W8x18	16 17	12

▲ See Note 6 Below

LEGEND

	Sign
	Large Sign
	Traffic Flow

DEPARTMENTAL MATERIAL SPECIFICATIONS

PLYWOOD SIGN BLANKS	DMS-7100
ALUMINUM SIGN BLANKS	DMS-7110
SIGN FACE MATERIALS	DMS-8300

COLOR	USAGE	SHEETING MATERIAL
ORANGE	BACKGROUND	TYPE B _{FL} OR TYPE C _{FL}
BLACK	LEGEND & BORDERS	NON-REFLECTIVE ACRYLIC FILM

GENERAL NOTES

- See BC and SMD sheets for additional sign support details.
- Sign locations shall be approved by the Engineer.
- For projects more than two miles in length, Give Us a BRAKE signs should be repeated halfway through the project. The Give Us a Brake (CW21-1T) may be used for this purpose.
- Work zone speed limits are sometimes used in conjunction with GIVE US A BRAKE signing. See BC(3) for location and spacing of construction speed zone signing when required.
- Give Us a Brake (CW21-1T) signs and supports shall be considered subsidiary to Item 502, "Barricades, Signs and Traffic Handling."
- The 96" X 48" Working For You Give Us A BRAKE (G20-7T) may use a 1/2" or 5/8" plywood substrate or 0.125" aluminum sheeting substrate and may be supported by two 4" x 6" wood posts with drilled holes for breakaway as per BC(5) and will be subsidiary to Item 502.
- The Working For You Give Us A BRAKE (G20-7T) 192" X 96" sign shall be paid for under the following specification items:
 Item 636 - Aluminum Signs
 Item 647 - Large Roadside Sign Supports and Assemblies.
 Item 416 - Drilled Shaft Foundations
- All signs shall be constructed in accordance with the details found in the "Standard Highway Sign Designs for Texas," latest edition. Sign details not shown in this manual shall be shown in the plans or the Engineer shall provide a detail to the Contractor before the sign is manufactured.

Texas Department of Transportation Traffic Operations Division Standard

WORK ZONE "GIVE US A BRAKE" SIGNS


WZ (BRK) - 13

FILE: wzbrk-13.dgn	DN: TxDOT	CK: TxDOT	DW: TxDOT	CR: TxDOT
© TxDOT August 1995	CONT	SECT	JOB	HIGHWAY
REVISIONS	0111	01	095	FM 521
6-96 5-98 7-13	DIST	COUNTY	SHEET NO.	
8-96 3-03	HOU	HARRIS	30	

DISCLAIMER: The use of this standard is governed by the "Texas Engineering Practice Act". No warranty of any kind is made by TxDOT for any purpose whatsoever. TxDOT assumes no responsibility for the conversion of this standard to other formats or for incorrect results or damages resulting from its use.

DATE: 9/18/2020 11:06:13 AM
 FILE: T:\HUM-AO\Design\Roadway\FM_521\0111-01-095\DGN\TCP\031_WZ(STPM)-13.dgn

WORK ZONE SHORT TERM PAVEMENT MARKINGS DETAILS

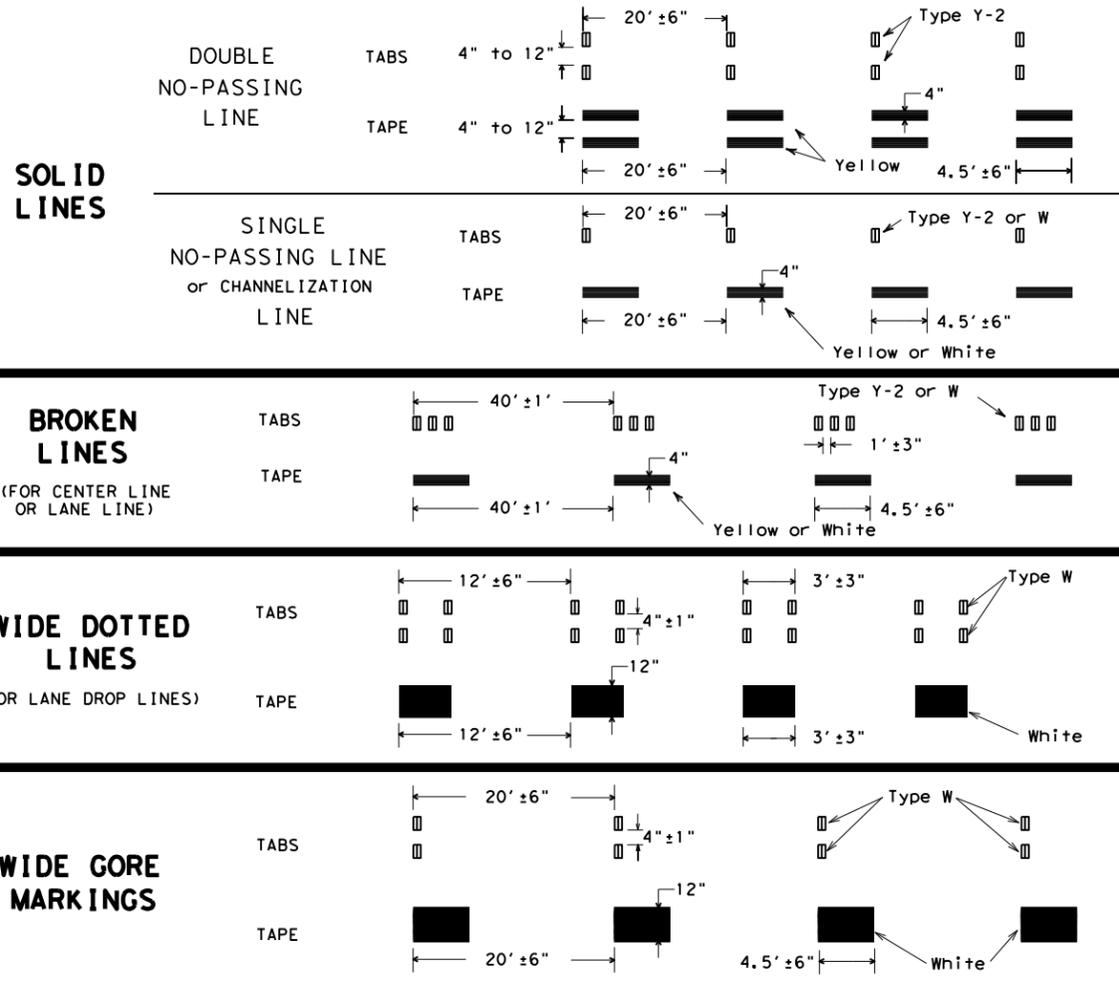


NOTES:

- Short term pavement markings may be prefabricated markings (stick down tape) or temporary flexible-reflective roadway marker tabs unless otherwise specified elsewhere in plans.
- Short term pavement markings shall NOT be used to simulate edge lines.
- Dimensions indicated on this sheet are typical and approximate. Variations in size and height may occur between markers or devices made by manufacturers, by as much as 1/4 inch, unless otherwise noted.
- Temporary flexible-reflective roadway marker tabs will require normal maintenance replacement when used on roadways with an ADT per lane of up to 7500 vehicles with no more than 10% truck mix. When roadways exceed these values, additional maintenance replacement of devices should be planned.
- No segment of roadway open to traffic shall remain without permanent pavement markings for a period greater than 14 calendar days. The Contractor will be responsible for maintaining short term pavement markings until permanent pavement markings are in place. When the Contractor is responsible for placement of permanent pavement markings, no segment of roadway shall remain without permanent pavement markings for a period greater than 14 calendar days unless weather conditions prohibit placement. Permanent pavement markings shall be placed as soon as weather permits.
- For two lane, two-way roadways, DO NOT PASS signs shall be erected to mark the beginning of sections where passing is prohibited and PASS WITH CARE signs shall be erected to mark the beginning of sections where passing is permitted. Signs shall be in accordance with the "Texas Manual on Uniform Traffic Control Devices" (TMUTCD) and may be used to indicate the limits of no-passing zones for up to 14 calendar days. Permanent pavement markings should then be placed.
- For low volume two lane, two-way roadways of 4000 ADT or less, no-passing lines may be omitted when approved by the Engineer. DO NOT PASS and PASS WITH CARE signs shall be erected (see note 6).
- For exit gores where a lane is being dropped place wide gore markings or retroreflective channelizing devices to guide motorist through the exit. If channelizing devices are to be used it should be noted elsewhere in the plans. One piece cones are not allowed for this purpose.

TEMPORARY FLEXIBLE, REFLECTIVE ROADWAY MARKER TABS (TABS)

- Temporary flexible-reflective roadway marker tabs detailed on this sheet will be designated Type Y-2 (two amber reflective surfaces with yellow body); Type Y (one amber reflective surface with yellow body); and Type W (one white or silver reflective surface with white body). Additional details may be found on BC(11).
- Tabs shall meet requirements of Departmental Material Specification DMS-8242.
- When dry, tabs shall be visible for a minimum distance of 200 feet during normal daylight hours and when illuminated by automobile low-beam head light at night, unless sight distance is restricted by roadway geometrics.
- No two consecutive tabs nor four tabs per 1000 feet of line shall be missing or fail to meet the visual performance requirements of Note 3.

WORK ZONE SHORT TERM PAVEMENT MARKINGS PATTERNS

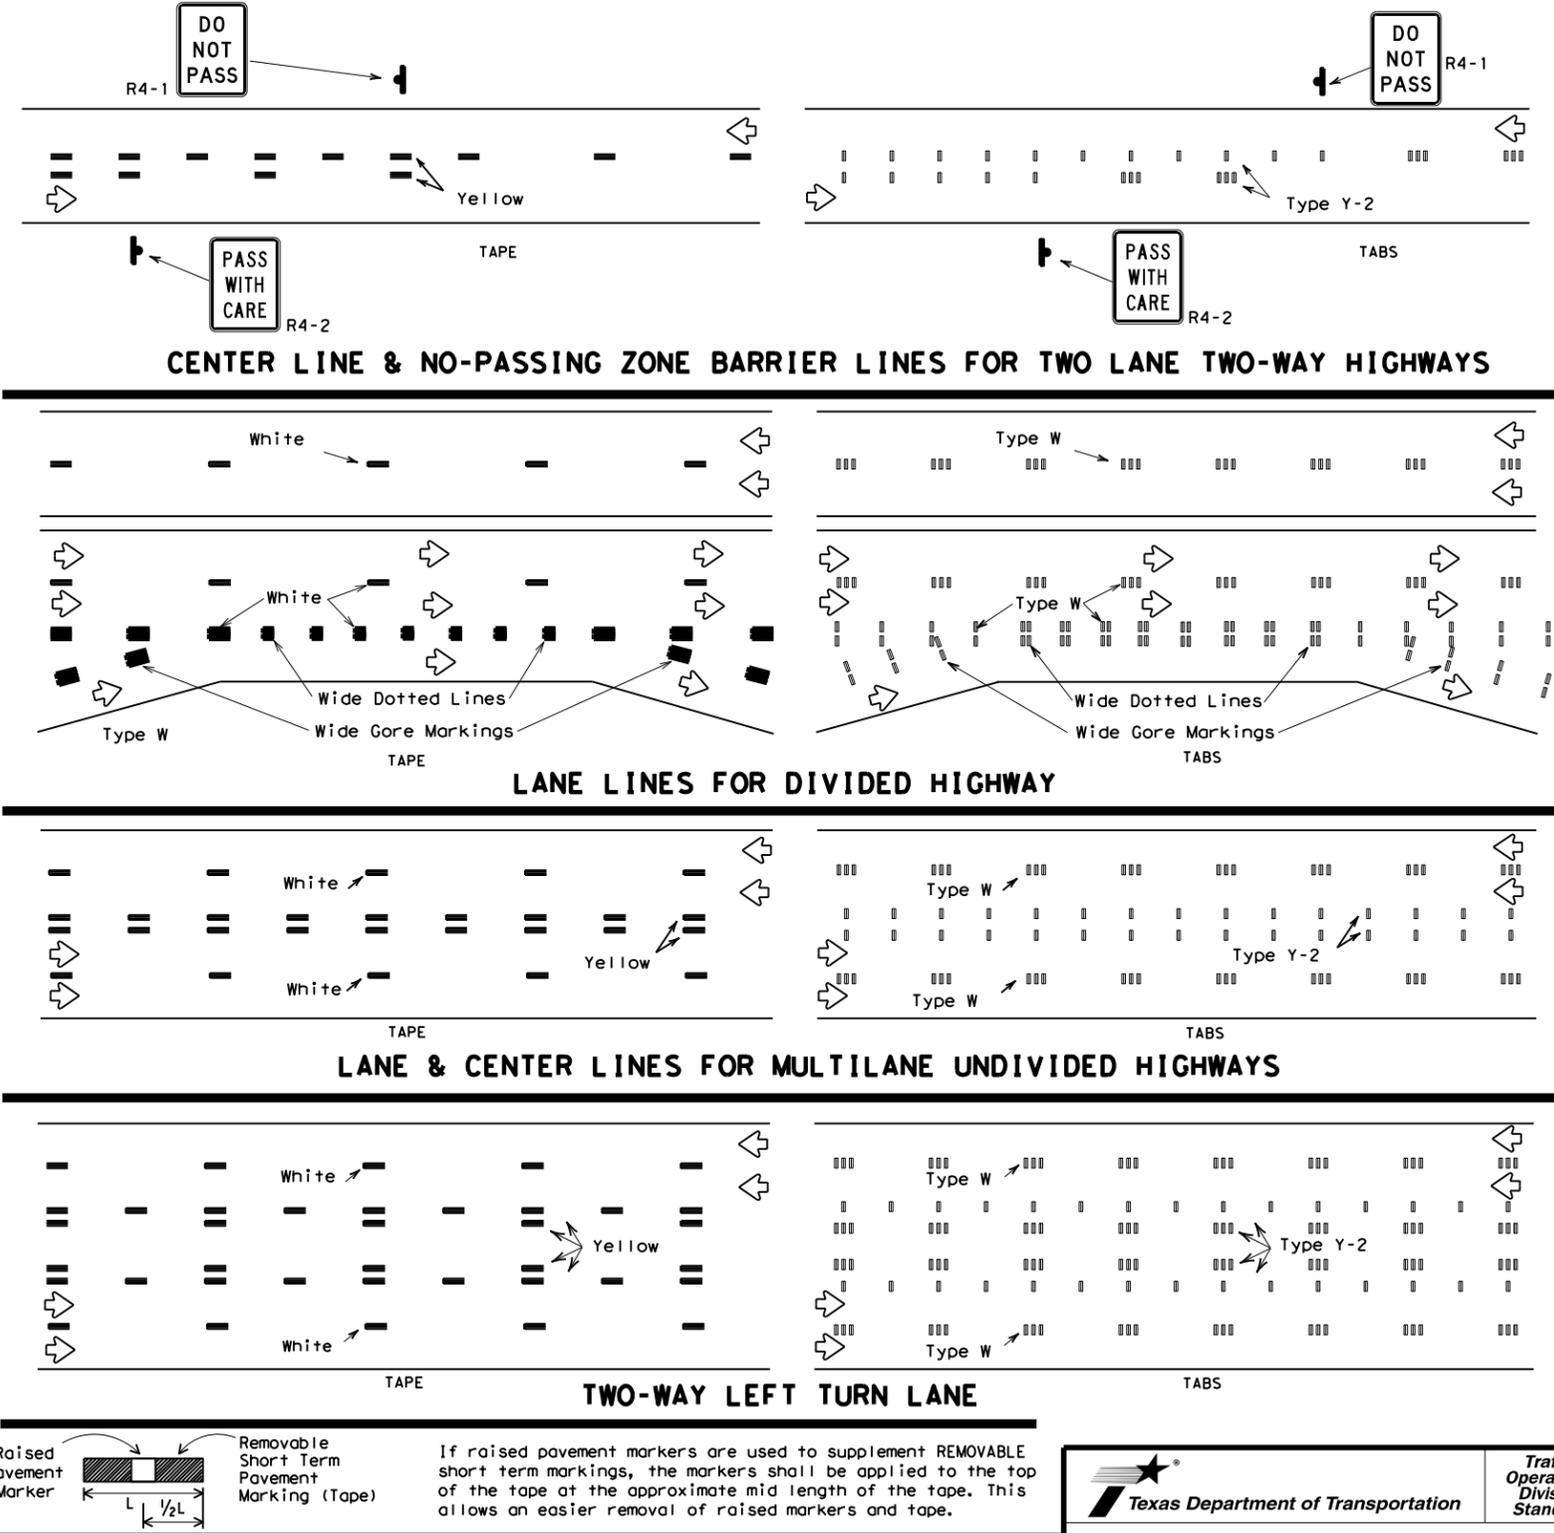

PREFABRICATED PAVEMENT MARKINGS

- Temporary Removable Prefabricated Pavement Markings shall meet the requirements of DMS-8241.
- Non-removable Prefabricated Pavement Markings shall meet the requirements of either DMS-8240 "Permanent Prefabricated Pavement Markings" or DMS-8243 "Temporary Construction-Grade Prefabricated Pavement Markings."

RAISED PAVEMENT MARKERS

- All raised pavement markers used for work zone markings shall meet the requirements of Item 672, "RAISED PAVEMENT MARKERS" and DMS-4200.

DEPARTMENTAL MATERIAL SPECIFICATIONS (DMS) & MATERIAL PRODUCER LISTS (MPL)

- DMSs referenced above can be found along with embedded links to their respective MPLs at the following website:
http://www.txdot.gov/business/contractors_consultants/material_specifications/default.htm







WORK ZONE SHORT TERM PAVEMENT MARKINGS

WZ (STPM) - 13

FILE:	wzstpm-13.dgn	DN:	TxDOT	CK:	TxDOT	DW:	TxDOT	CK:	TxDOT
© TxDOT	April 1992	CONT:	0111	SECT:	01	JOB:	095	FM:	521
REVISIONS		DIST:		COUNTY:		SHEET NO.:			
1-97		HOU:		HARRIS					
3-03									
7-13									

DISCLAIMER: The use of this standard is governed by the "Texas Engineering Practice Act". No warranty of any kind is made by TxDOT for any purpose whatsoever. TxDOT assumes no responsibility for the conversion of this standard to other formats or for incorrect results or damages resulting from its use.

DATE: 9/18/2020 11:08:01 AM
 FILE: T:\HUM-AO\Design\Roadway\FM_521\0111-01-095\06\N\CP\032_WZ(UL)-13.dgn

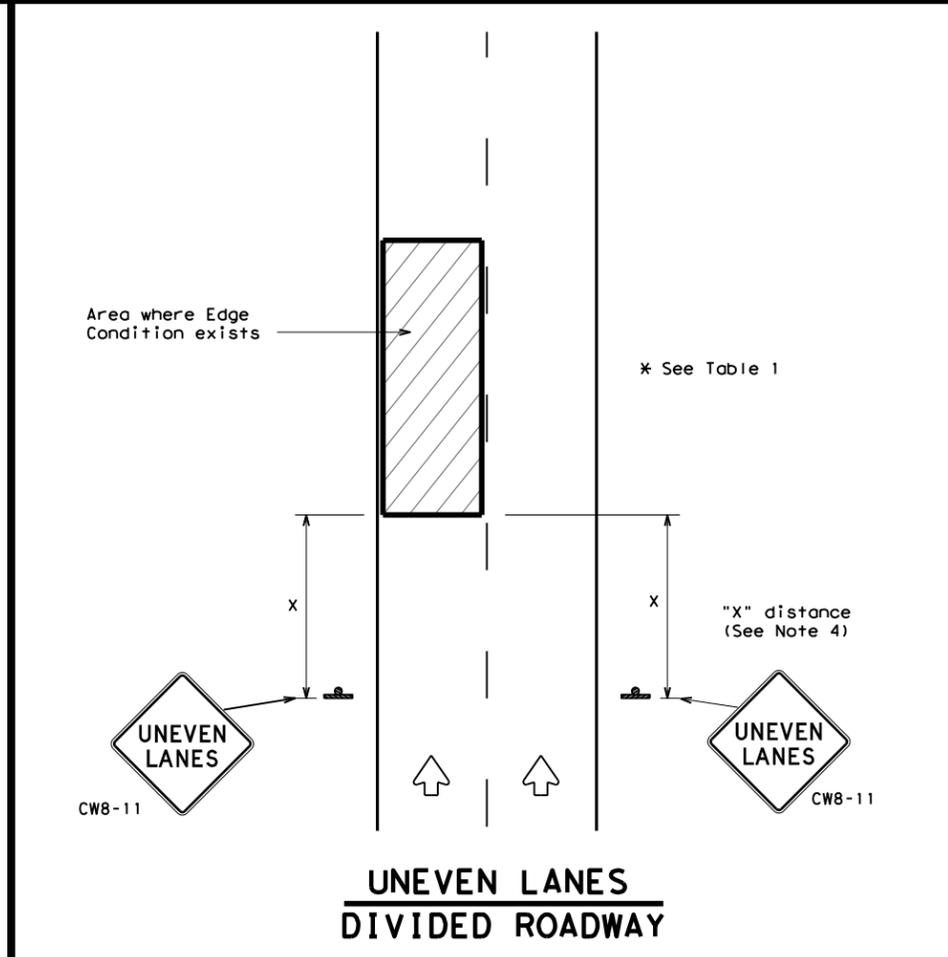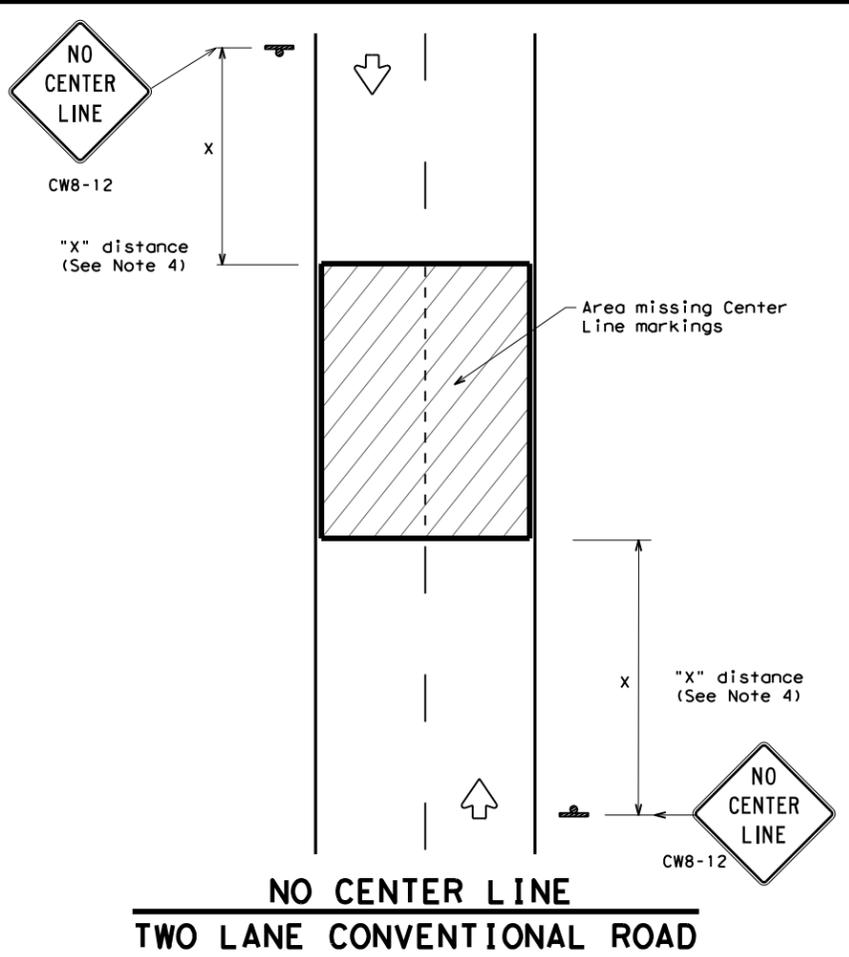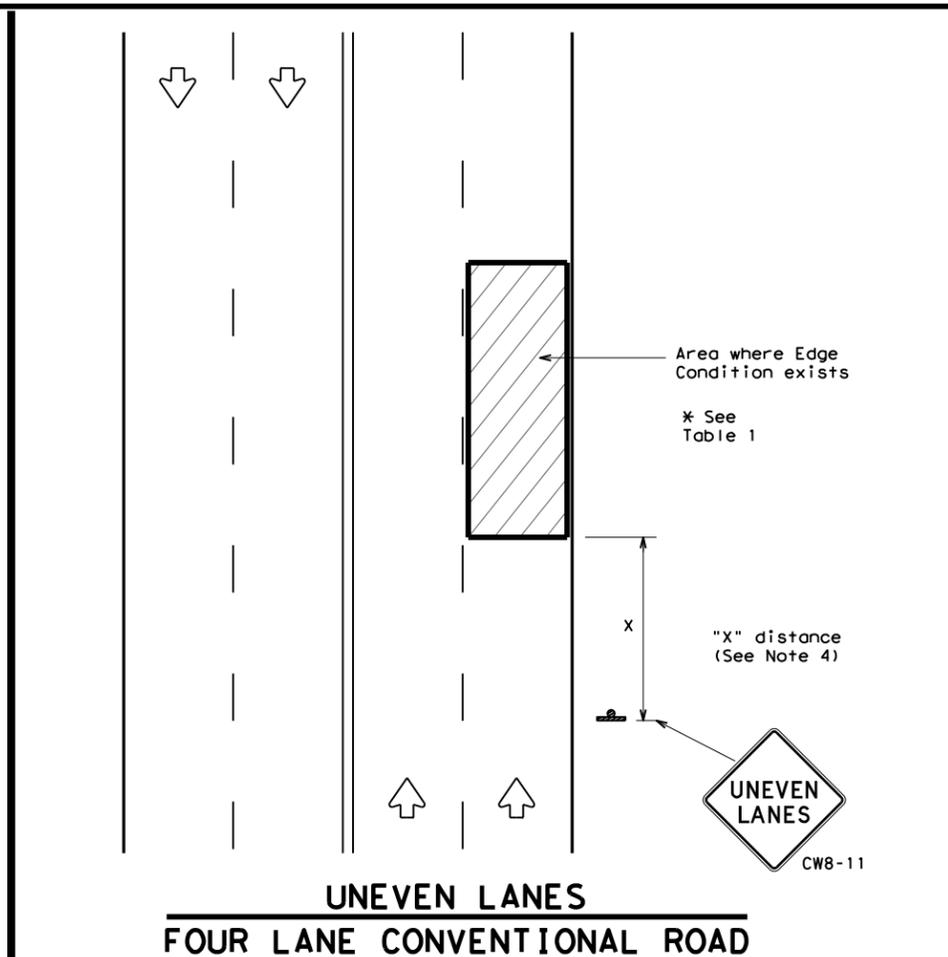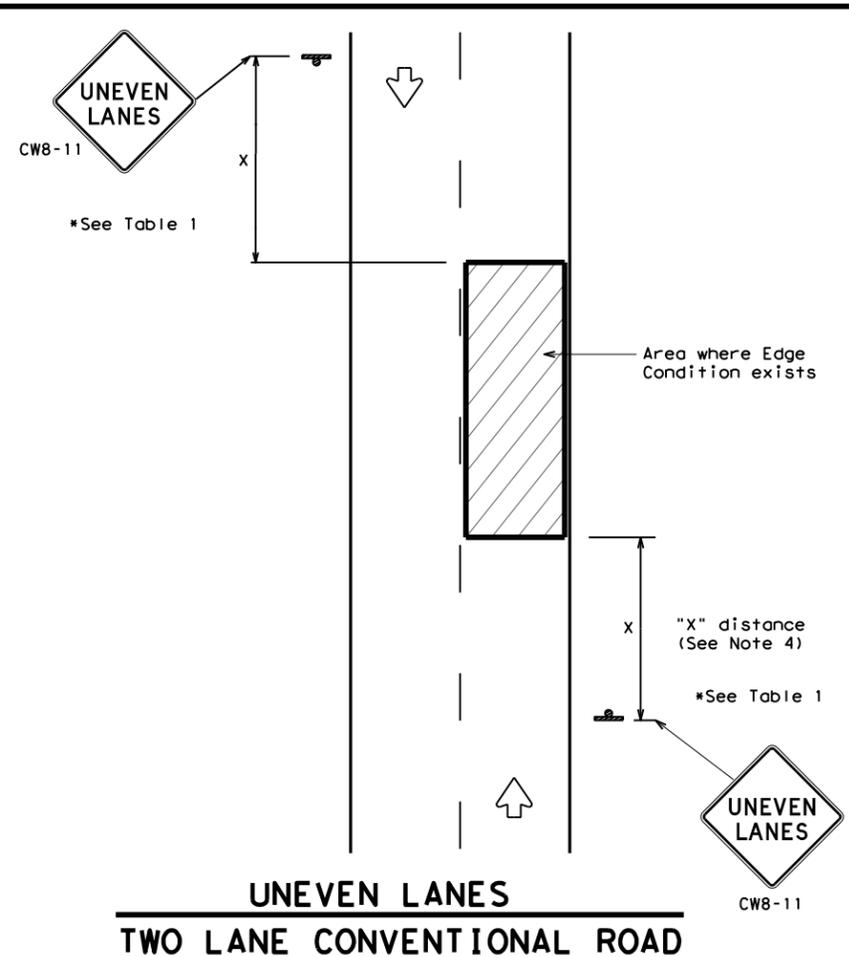

DEPARTMENTAL MATERIAL SPECIFICATIONS	
PERMANENT PREFABRICATED PAVEMENT MARKINGS	DMS-8240
TEMPORARY (REMOVABLE) PREFABRICATED PAVEMENT MARKINGS	DMS-8241
SIGN FACE MATERIALS	DMS-8300

COLOR	USAGE	SHEETING MATERIAL
ORANGE	BACKGROUND	TYPE B _{FL} OR TYPE C _{FL} SHEETING
BLACK	LEGEND & BORDERS	ACRYLIC NON-REFLECTIVE SHEETING

GENERAL NOTES

1. If spalling or holes occur, ROUGH ROAD (CW8-8) signs should be placed in advance of the condition and be repeated every two miles where the condition persists.
2. UNEVEN LANES (CW8-11) signs shall be installed in advance of the condition and repeated every mile. Signs installed along the uneven lane condition may be supplemented with the NEXT XX MILES (CW7-3aP) plaque or Advisory Speed (CW13-1P) plaque.
3. NO CENTER LINE (CW8-12) signs and temporary pavement markings as per the WZ(STPM) standard shall be installed if yellow centerlines separating two way traffic are obscured or obliterated. Repeat NO CENTER LINE signs every two miles where the center line markings are not in place. The signs and markings shall remain in place until permanent pavement markings are installed.
4. Signs shall be spaced at the distances recommended as per BC standards.
5. Additional signs may be required as directed by the Engineer. Signs shall remain in place until final surface is applied. Signs shall be considered subsidiary to Item 502 "BARRICADES, SIGNS AND TRAFFIC HANDLING."
6. Signs shall be fabricated and mounted on supports as shown on the BC standards and/or listed on the "Compliant Work Zone Traffic Control Devices" list.
7. Short term markings shall not be used to simulate edge lines.
8. All signs shall be constructed in accordance with the details found in the "Standard Highway Sign Designs for Texas," latest edition.

Edge Condition	Edge Height (D)	* Warning Devices
①	Less than or equal to: 1/4" (maximum-planing) 1/2" (typical-overlay)	Sign: CW8-11
②	Less than or equal to 3"	Sign: CW8-11
③	Distance "D" may be a maximum of 3" if uneven lanes with edge condition 2 or 3 are open to traffic after work operations cease. Uneven lanes should not be open to traffic when "D" is greater than 3".	

TRAFFIC CONTROL DURING PLANING, OVERLAY AND LEVELING OPERATIONS ARE SHOWN ELSEWHERE IN THE PLANS.

MINIMUM WARNING SIGN SIZE	
Conventional roads	36" x 36"
Freeways/expressways, divided roadways	48" x 48"




SIGNING FOR UNEVEN LANES

WZ(UL) - 13


FILE: WZUL-13.dgn	DN: TxDOT	CK: TxDOT	DW: TxDOT	CR: TxDOT
© TxDOT	APRIL 1992	CONT	SECT	JOB
REVISIONS	0111	01	095	FM 521
8-95 2-98 7-13	DIST	COUNTY	SHEET NO.	
1-97 3-03	HOU	HARRIS	32	

DISCLAIMER: The use of this standard is governed by the "Texas Engineering Practice Act". No warranty of any kind is made by TxDOT for any purpose whatsoever. TxDOT assumes no responsibility for the conversion of this standard to other formats or for incorrect results or damages resulting from its use.


DATE: FILE:

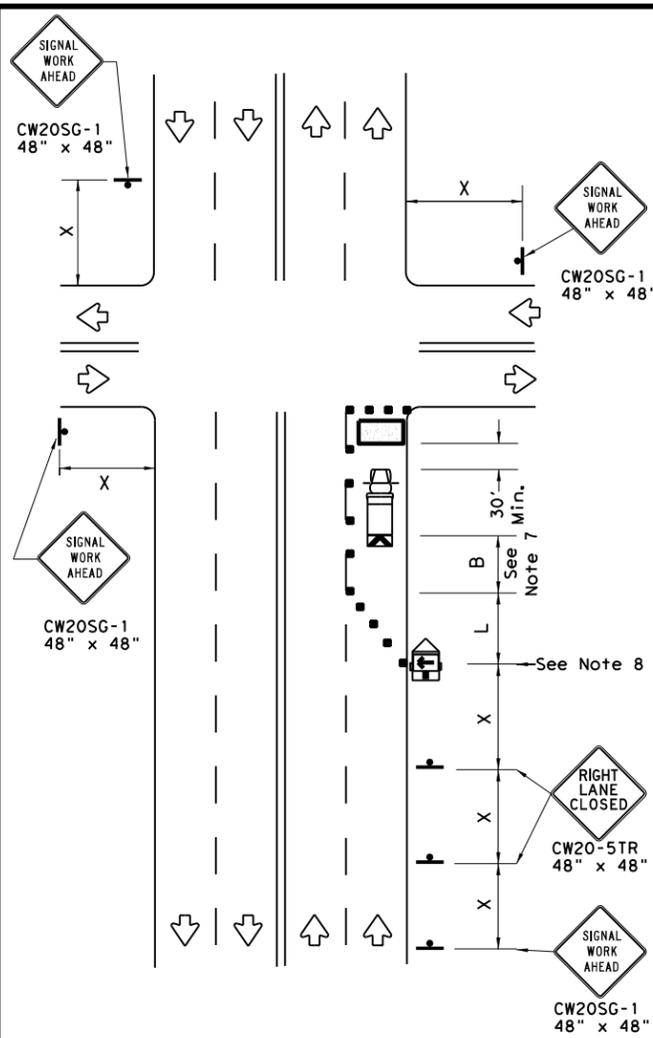

NEAR SIDE LANE CLOSURE
SHORT DURATION OR SHORT TERM STATIONARY

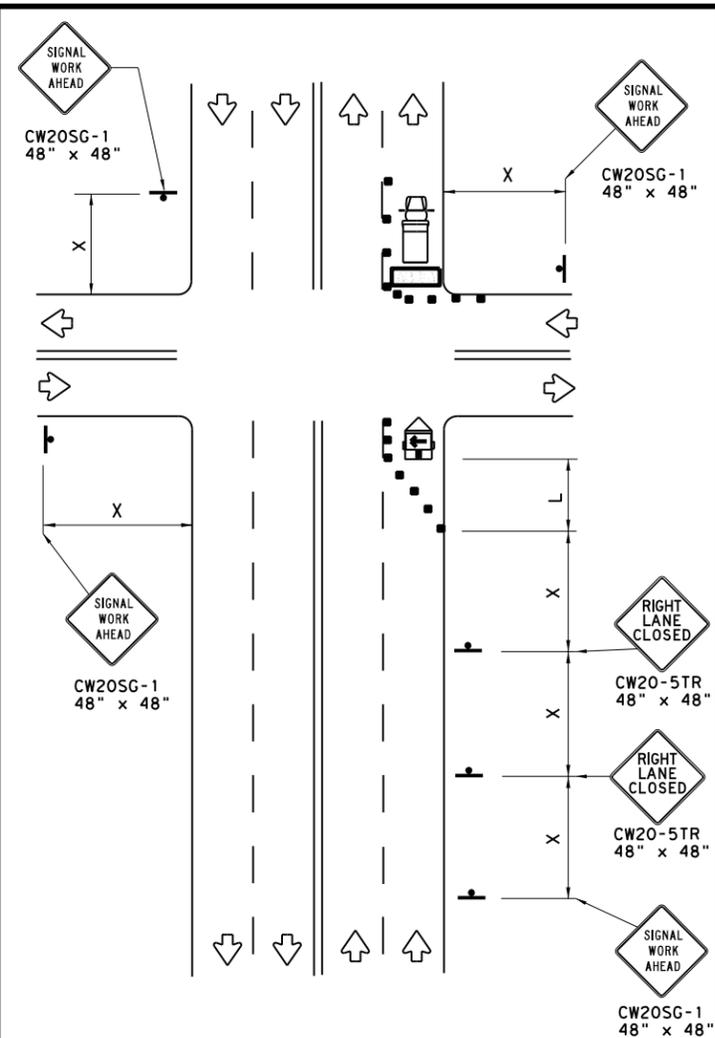

FAR SIDE RIGHT LANE CLOSURE
SHORT DURATION OR SHORT TERM STATIONARY

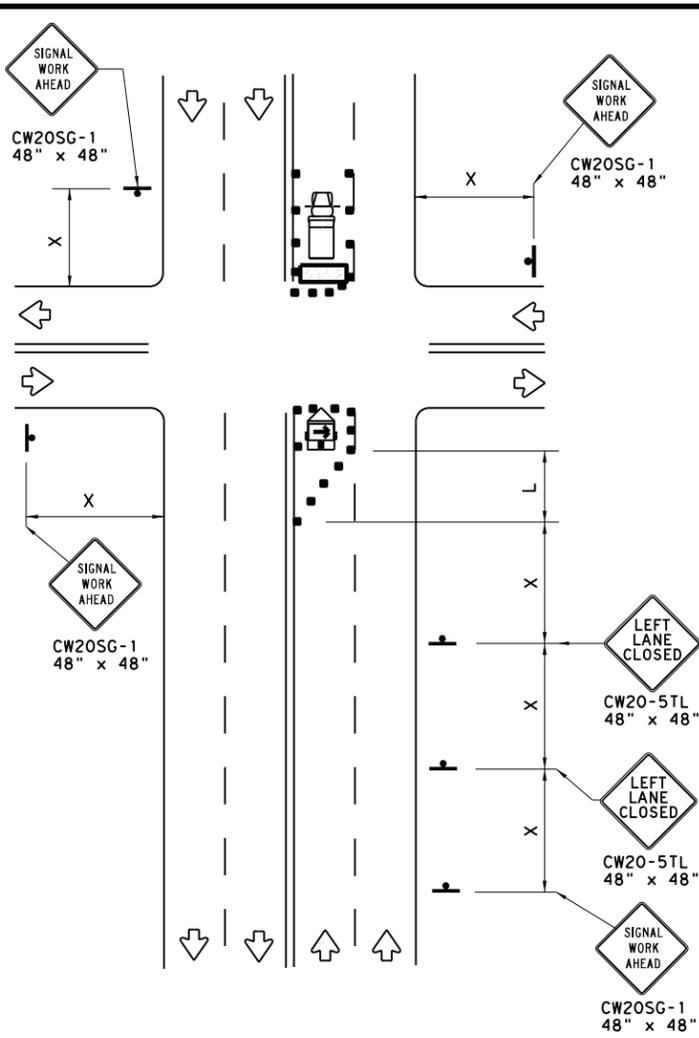


FAR SIDE LEFT LANE CLOSURE
SHORT DURATION OR SHORT TERM STATIONARY

LEGEND			
	Type 3 Barricade		Channelizing Devices
	Heavy Work Vehicle		Truck Mounted Attenuator (TMA)
	Trailer Mounted Flashing Arrow Board		Portable Changeable Message Sign (PCMS)
	Sign		Traffic Flow
	Flag		Flagger


Posted Speed *	Formula	Minimum Desirable Taper Lengths **			Suggested Maximum Spacing of Channelizing Devices		Minimum Sign Spacing "x" Distance	Suggested Longitudinal Buffer Space "B"
		10' Offset	11' Offset	12' Offset	On a Taper	On a Tangent		
30	$L = \frac{WS^2}{60}$	150'	165'	180'	30'	60'	120'	90'
35		205'	225'	245'	35'	70'	160'	120'
40		265'	295'	320'	40'	80'	240'	155'
45	L = WS	450'	495'	540'	45'	90'	320'	195'
50		500'	550'	600'	50'	100'	400'	240'
55		550'	605'	660'	55'	110'	500'	295'
60		600'	660'	720'	60'	120'	600'	350'
65		650'	715'	780'	65'	130'	700'	410'
70		700'	770'	840'	70'	140'	800'	475'
75		750'	825'	900'	75'	150'	900'	540'

* Conventional Roads Only
 ** Taper lengths have been rounded off.
 L=Length of Taper (FT) W=Width of Offset (FT) S=Posted Speed (MPH)

WORKERS IN BUCKET TRUCKS SHALL NOT WORK ABOVE OPEN LANES OF TRAFFIC.

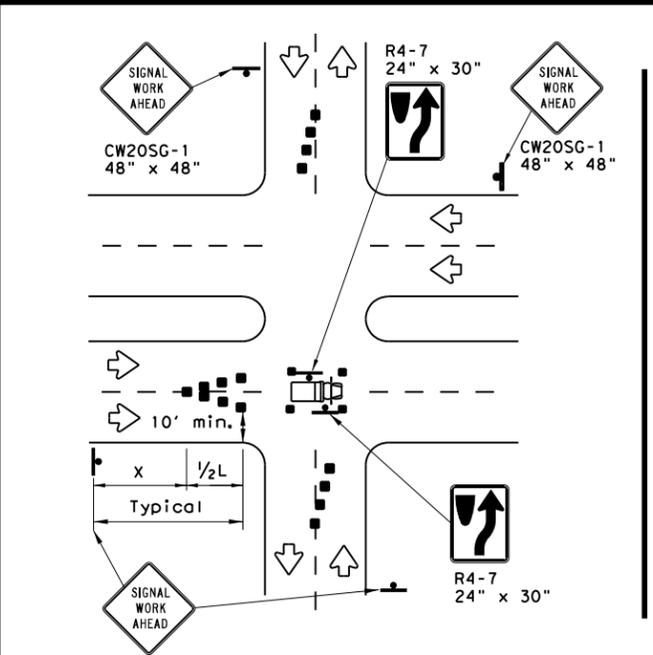

OPERATIONS IN THE INTERSECTION
SHORT DURATION

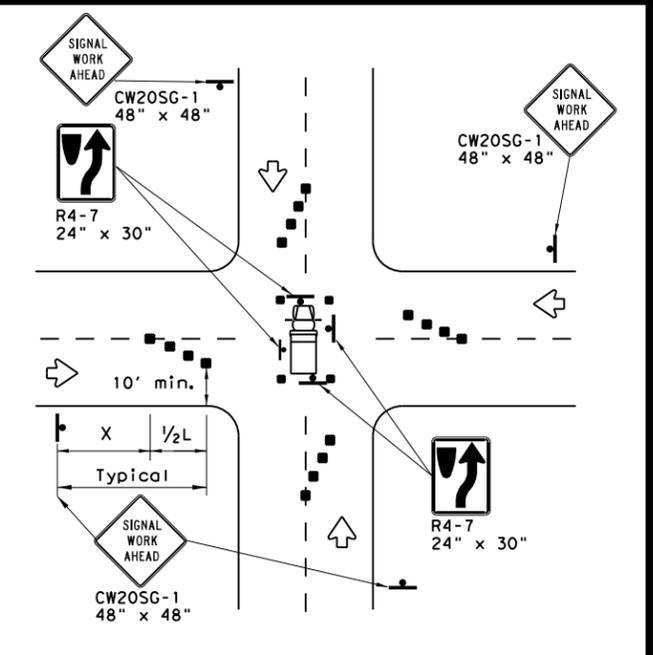

GENERAL NOTES

- The minimum size channelizing device is the 28" cone. 42" Two-piece cones, drums, vertical panels or barricades will be required when the device must be left unattended at night.
- Obstructions or hazards at the work area shall be clearly marked and delineated at all times.
- Flaggers and Flagger Symbol (CW20-7) signs may be required according to field conditions.
- Vehicles parked in roadway shall be equipped with at least two high intensity rotating, flashing, oscillating or strobe type lights.
- High level warning devices (flag trees) may be used at corners of the vehicle.
- When work operations are performed on existing signals, the signals may be placed in flashing red mode when approved by the engineer. If existing signals do not have power, All-Way Stop (R1-1 and R1-3P) signs may be implemented when approved by the engineer.
- For Short-Term Stationary work the buffer space "B" from the above table should be used if field conditions permit. For Short Duration (less than 1 hour) any buffer space provided will enhance the safety of the setup.
- The arrow board at this location may be omitted for Short Duration work if the work vehicle has an arrow board in operation. As an option, the arrow board may be placed at the end of the taper in the closed lane if space is not available at the beginning of the taper.
- Signs and devices for the NEAR SIDE LANE CLOSURE may be altered for a left lane closure by using a LEFT LANE CLOSED (CW20-5TL) and adding channelizing devices on the centerline to protect the work space from opposing traffic.




TRAFFIC SIGNAL WORK TYPICAL DETAILS

WZ(BTS-1)-13

FILE: wzbts-13.dgn	DN: TxDOT	CR: TxDOT	DW: TxDOT	CK: TxDOT
© TxDOT April 1992	CONT	SECT	JOB	HIGHWAY
REVISIONS	0111	01	095	FM 521
2-98 10-99 7-13	DIST	COUNTY	SHEET NO.	
4-98 3-03	HOU	HARRIS	33	

DISCLAIMER: The use of this standard is governed by the "Texas Engineering Practice Act". No warranty of any kind is made by TxDOT for any purpose whatsoever. TxDOT assumes no responsibility for the conversion of this standard to other formats or for incorrect use or damages resulting from its use.

DATE: FILE:

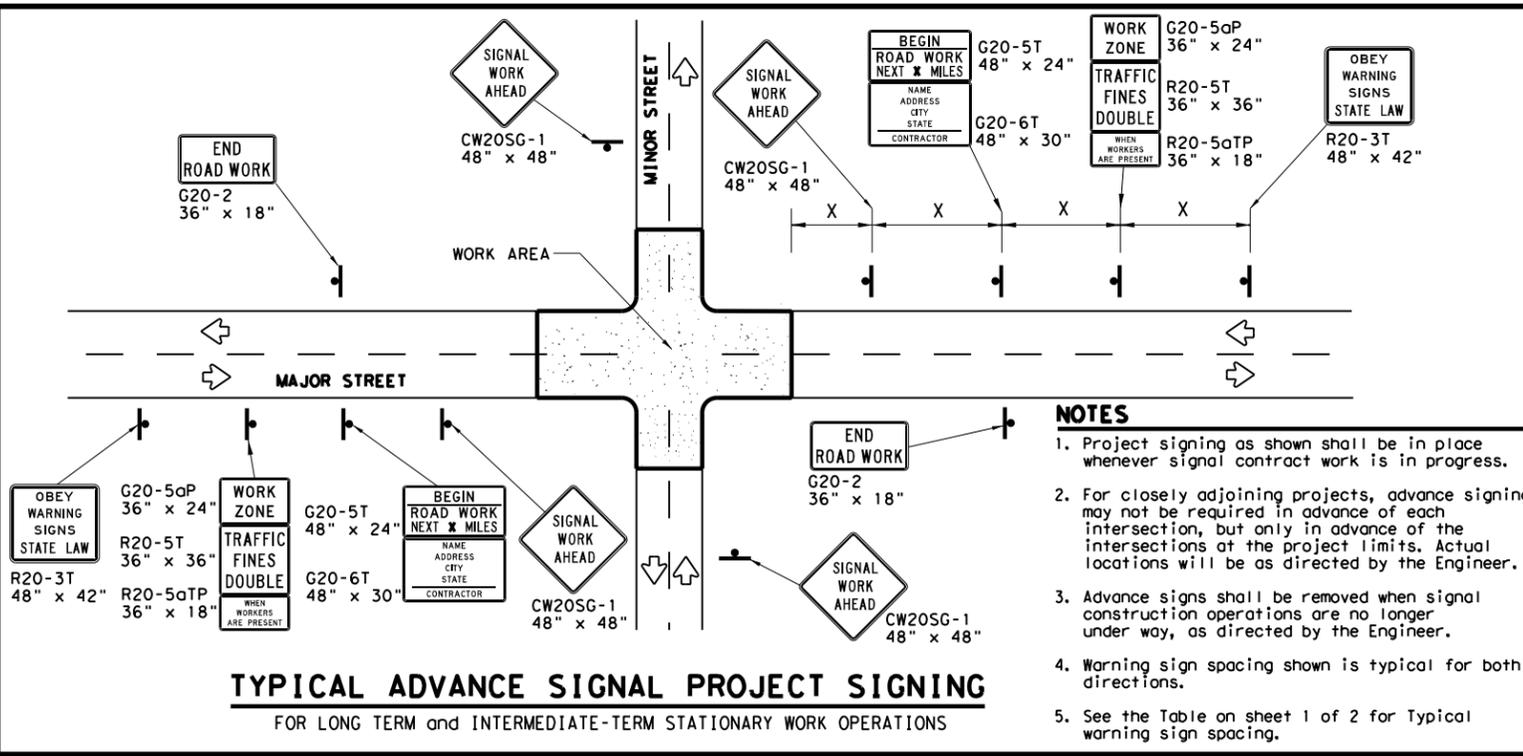

- NOTES**
1. Project signing as shown shall be in place whenever signal contract work is in progress.
 2. For closely adjoining projects, advance signing may not be required in advance of each intersection, but only in advance of the intersections at the project limits. Actual locations will be as directed by the Engineer.
 3. Advance signs shall be removed when signal construction operations are no longer under way, as directed by the Engineer.
 4. Warning sign spacing shown is typical for both directions.
 5. See the Table on sheet 1 of 2 for Typical warning sign spacing.

GENERAL NOTES FOR WORK ZONE SIGNS

1. Signs shall be installed and maintained in a straight and plumb condition.
2. Wooden sign posts shall be painted white.
3. Barricades shall NOT be used as sign supports.
4. Nails shall NOT be used to attach signs to any support.
5. All signs shall be installed in accordance with the plans or as directed by the Engineer.
6. The Contractor shall furnish the sign design shown in the plans or in the "Standard Highway Sign Designs for Texas" (SHSD).
7. The Contractor shall furnish sign supports and substrates listed in the "Compliant Work Zone Traffic Control Device List" (CWZTCD), installed as per the manufacturer's recommendations.
8. Temporary signs that have damaged or cracked substrates and/or damaged or marred reflective sheeting shall be replaced as directed by the Engineer.
9. Identification markings may be shown only on the back of the sign substrate. The maximum height of letters and/or company logos used for identification shall be 1".
10. Damaged wood posts shall be replaced. Splicing wood posts will not be allowed.

DURATION OF WORK

1. Work zone durations are defined in Part 6, Section 60.02 of the Texas Manual on Uniform Traffic Control Devices (TMUTCD).

SIGN MOUNTING HEIGHT

1. Sign height of Long-term/Intermediate-term warning signs shall be as shown on Figure 6F-1 of the TMUTCD.
2. Sign height of Short-term/Short Duration warning signs shall be as shown on Figure 6F-2 of the TMUTCD.
3. Regulatory signs shall be mounted at least 7 feet, but not more than 9 feet, above the paved surface regardless of work duration.

REMOVING OR COVERING

1. When sign messages may be confusing or do not apply, the signs shall be removed or completely covered, unless otherwise approved by the Engineer.
2. When signs are covered, the material used shall be opaque, such as heavy mil black plastic, or other materials which will cover the entire sign face and maintain their opaque properties under automobile headlights at night without damaging the sign sheeting. Burlap, or heavy materials such as plywood or aluminum shall not be used to cover signs.
3. Duct tape or other adhesive material shall NOT be affixed to a sign face.
4. Signs and anchor stubs shall be removed and holes back filled upon completion of the work.

REFLECTIVE SHEETING

1. All signs shall be retroreflective and constructed of sheeting meeting the requirements of the DMS and color usage table shown on this sheet.

SIGN SUPPORT WEIGHTS

1. Weights used to keep signs from turning over should be sandbags filled with dry, cohesionless material.
2. The sandbags will be tied shut to keep the sand from spilling and to maintain a constant weight.
3. Rock, concrete, iron, steel or other solid objects will not be permitted for use as sign support weights.
4. Sandbags should weigh a minimum of 35 lbs and a maximum of 50 lbs.
5. Sandbags shall be made of a durable material that tears upon vehicular impact. Rubber, such as tire inner tubes, shall not be used.
6. Rubber ballasts designed for channelizing devices should not be used for ballast on portable sign supports. Sign supports designed and manufactured with rubber bases may be used when shown on the CWZTCD list.
7. Sandbags shall only be placed along or laid over the base supports of the traffic control device and shall not be suspended above ground level or hung with rope, wire, chains or other fasteners. Sandbags shall be placed along the length of the skids to weigh down the sign support.
8. Sandbags shall NOT be placed under the skid and shall not be used to level sign supports placed on slopes.

LEGEND




	Sign
	Channelizing Devices
	Type 3 Barricade

DEPARTMENTAL MATERIAL SPECIFICATIONS

SIGN FACE MATERIALS	DMS-8300
FLEXIBLE ROLL-UP REFLECTIVE SIGNS	DMS-8310

COLOR	USAGE	SHEETING MATERIAL
ORANGE	BACKGROUND	TYPE B _{FL} OR TYPE C _{FL} SHEETING
WHITE	BACKGROUND	TYPE A SHEETING
BLACK	LEGEND & BORDERS	ACRYLIC NON-REFLECTIVE SHEETING

Only pre-qualified products shall be used. A copy of the "Compliant Work Zone Traffic Control Devices List" (CWZTCD) describes pre-qualified products and their sources and may be found at the following web address:
http://www.txdot.gov/txdot_library/publications/construction.htm

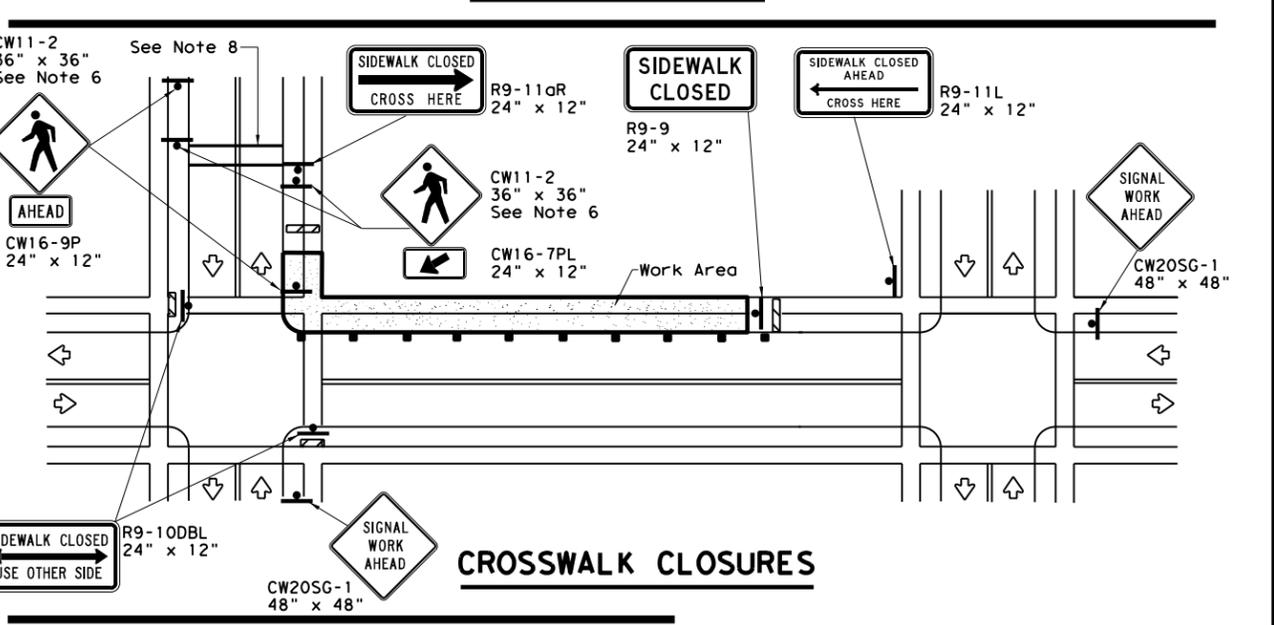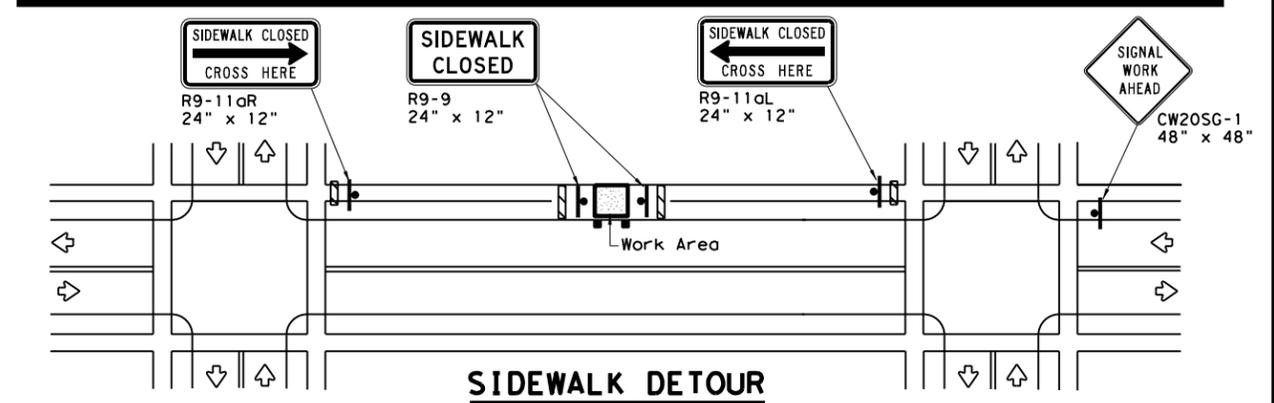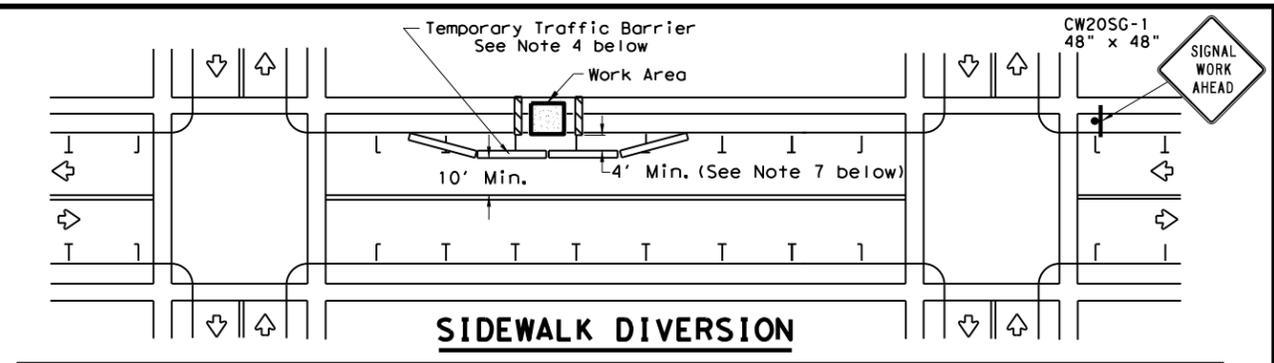

PEDESTRIAN CONTROL

1. Holes, trenches or other hazards shall be adequately protected by covering, delineating or surrounding the hazard with orange plastic pedestrian fencing or longitudinal channelizing devices, or as directed by the Engineer.
2. "CROSSWALK CLOSURES" as detailed above will require the Engineer's approval prior to installation.
3. R9 series signs shown may be placed on supports detailed on the BC standards or CWZTCD list, or when fabricated from approved lightweight plastic substrates, they may be mounted on top of a plastic drum at or near the location shown.
4. For speeds less than 45 mph longitudinal channelizing devices may be used instead of traffic barriers when approved by the Engineer. Attenuation of blunt ends and installation of water filled devices shall be as per BC(9) and manufacturer's recommendations.
5. Location of devices are for general guidance. Actual device spacing and location must be field adjusted to meet actual conditions.
6. Where pedestrians with visual disabilities normally use the closed sidewalk Detectable Pedestrian Barricades should be used instead of the Type 3 Barricades shown.
7. The width of existing sidewalk should be maintained if practical.
8. Pavement markings for mid-block crosswalks shall be paid for under the appropriate bid items.
9. When crosswalks or other pedestrian facilities are closed or relocated, temporary facilities shall be detectable and shall include accessibility features consistent with the features present in the existing pedestrian facility.

SHEET 2 OF 2

Traffic Operations Division Standard

TRAFFIC SIGNAL WORK
 BARRICADES AND SIGNS

WZ(BTS-2)-13

FILE: wzbt5-13.dgn	DN: TxDOT	CR: TxDOT	OW: TxDOT	CK: TxDOT
© TxDOT April 1992	CONT	SECT	JOB	HIGHWAY
REVISIONS	0111	01	095	FM 521
2-98 10-99 7-13	DIST	COUNTY	SHEET NO.	
4-98 3-03	HOU	HARRIS	34	

8/27/2020 1:36:17 AM
T:\HUM-AO\Des\ign\Roadway\FM 521\0111-01-095.DGN\ROADWAY\035 HORIZONTAL ALIGNMENT DATA.dgn

<* 1 DESCRIBE CHAIN FM521

Chain FM521 contains:
10 20


Beginning chain FM521 description

=====
Point 10 N 13,814,689.3784 E 3,114,055.7799 Sta 110+00.00

Course from 10 to 20 N 14° 49' 51.80" E Dist 6,796.2190


Point 20 N 13,821,259.1799 E 3,115,795.4065 Sta 177+96.22

=====
Ending chain FM521 description

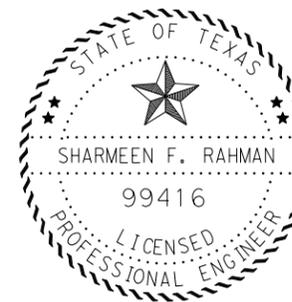



— *Sharmeen Rahman* —, P.E.

 10/09/2020



FM 521
HORIZONTAL ALIGNMENT
DATA

FED. RD. DIV. NO.		PROJECT NO.		SHEET NO.
6				35
STATE	DIST	COUNTY		
TEXAS	HOU	HARRIS		
CONT	SECT	JOB	HIGHWAY	
0111	01	095	FM 521	

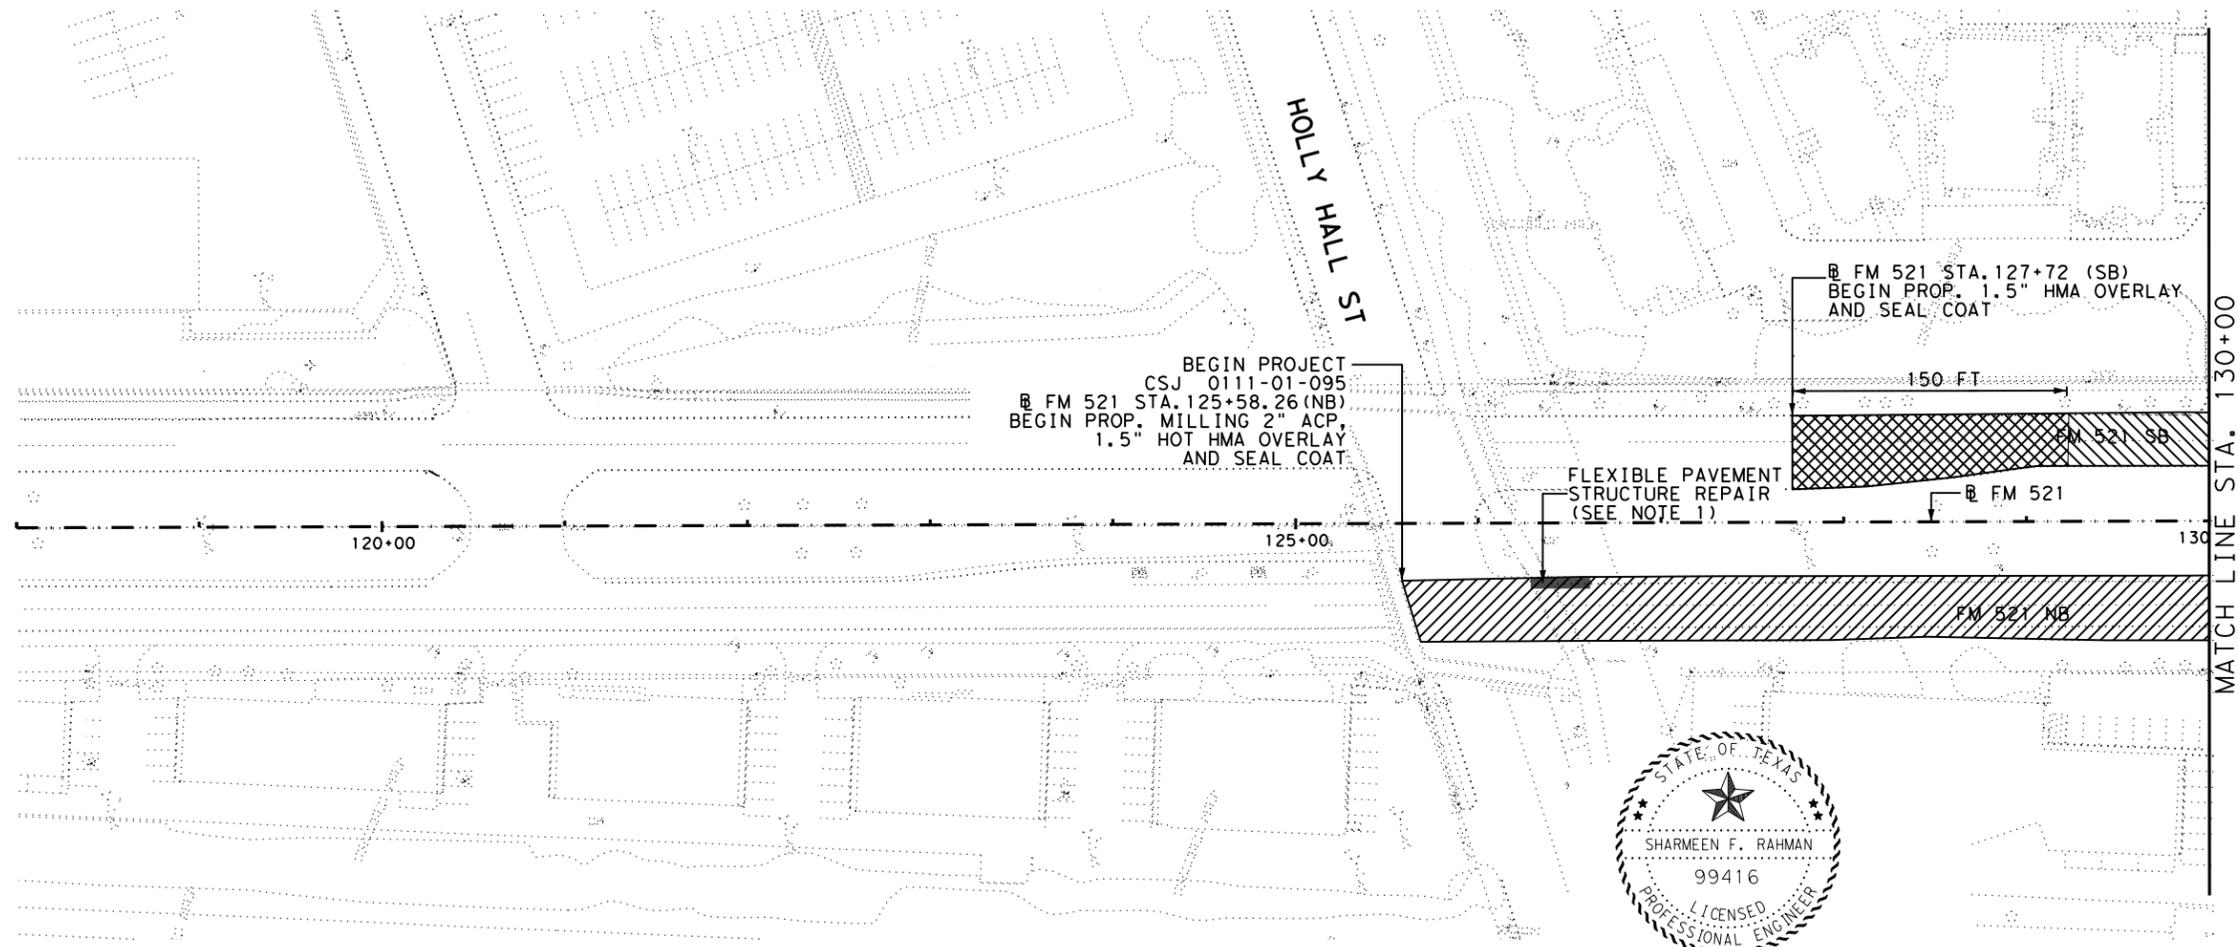 


10/9/2020 3:49:13 PM T:\HUM-AO\Des\ign\Roadway\FM 521\0111-01-095\DCN\ROADWAY\036 ROADWAY LAYOUT.dgn

NOTES:

1. AFTER MILLING (NB SIDE) LOCATION OF FLEXIBLE BASE REPAIR WILL BE DETERMINED BY THE ENGINEER. NO FLEXIBLE BASE REPAIR WILL BE MADE PRIOR TO MILLING.
2. THE LOCATION OF CURB AND FULL DEPTH CONCRETE REPAIR (SB SIDE) WILL BE VERIFIED AND MARKED BY THE ENGINEER IN THE FIELD.
3. FLEXIBLE BASE REPAIR AND FULL DEPTH CONCRETE REPAIR WILL BE PERFORMED IN ADVANCE OF ASPHALT OVERLAY.
4. FOR HOT MIX ASPHALT OVERLAY DETAILS, SEE SHEET 41-43.
5. FOR PAVEMENT MARKING LAYOUTS, SEE SHEET 57-61.
6. ADJUST MANHOLES TO MATCH PROPOSED PAVEMENT SURFACE. THE CONTRACTOR WILL VERIFY THE SIZE AND TYPE OF ALL MANHOLES NEEDED TO BE ADJUSTED.

LEGEND:



- PROPOSED 2" MILLING (NB) AND PROPOSED 1.5" HMA & SEAL COAT
- PROPOSED 0"-2" MILLING (CROSSOVER) AND PROPOSED 1.5" HMA & SEAL COAT
- PROPOSED 1.5" HMA AND SEAL COAT (SB SIDE)
- PROPOSED 0-1" MILLING AT BEGINNING AND END OF OVERLAY (SB SIDE) TO BE FILLED WITH HOT MIX ASPHALT AND SEAL COAT TO MATCH EXISTING CONCRETE PAVEMENT.

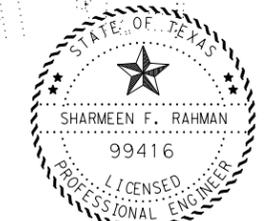

Sharmeen Rahman P.E.
10/12/2020



FM 521			
ROADWAY LAYOUT			
SCALE: 1" = 100'		SHEET 1 OF 5	
FED. RD. DIV. NO.	PROJECT NO.		SHEET NO.
6			36
STATE	DIST	COUNTY	
TEXAS	HOU	HARRIS	
CONT	SECT	JOB	HIGHWAY
0111	01	095	FM 521

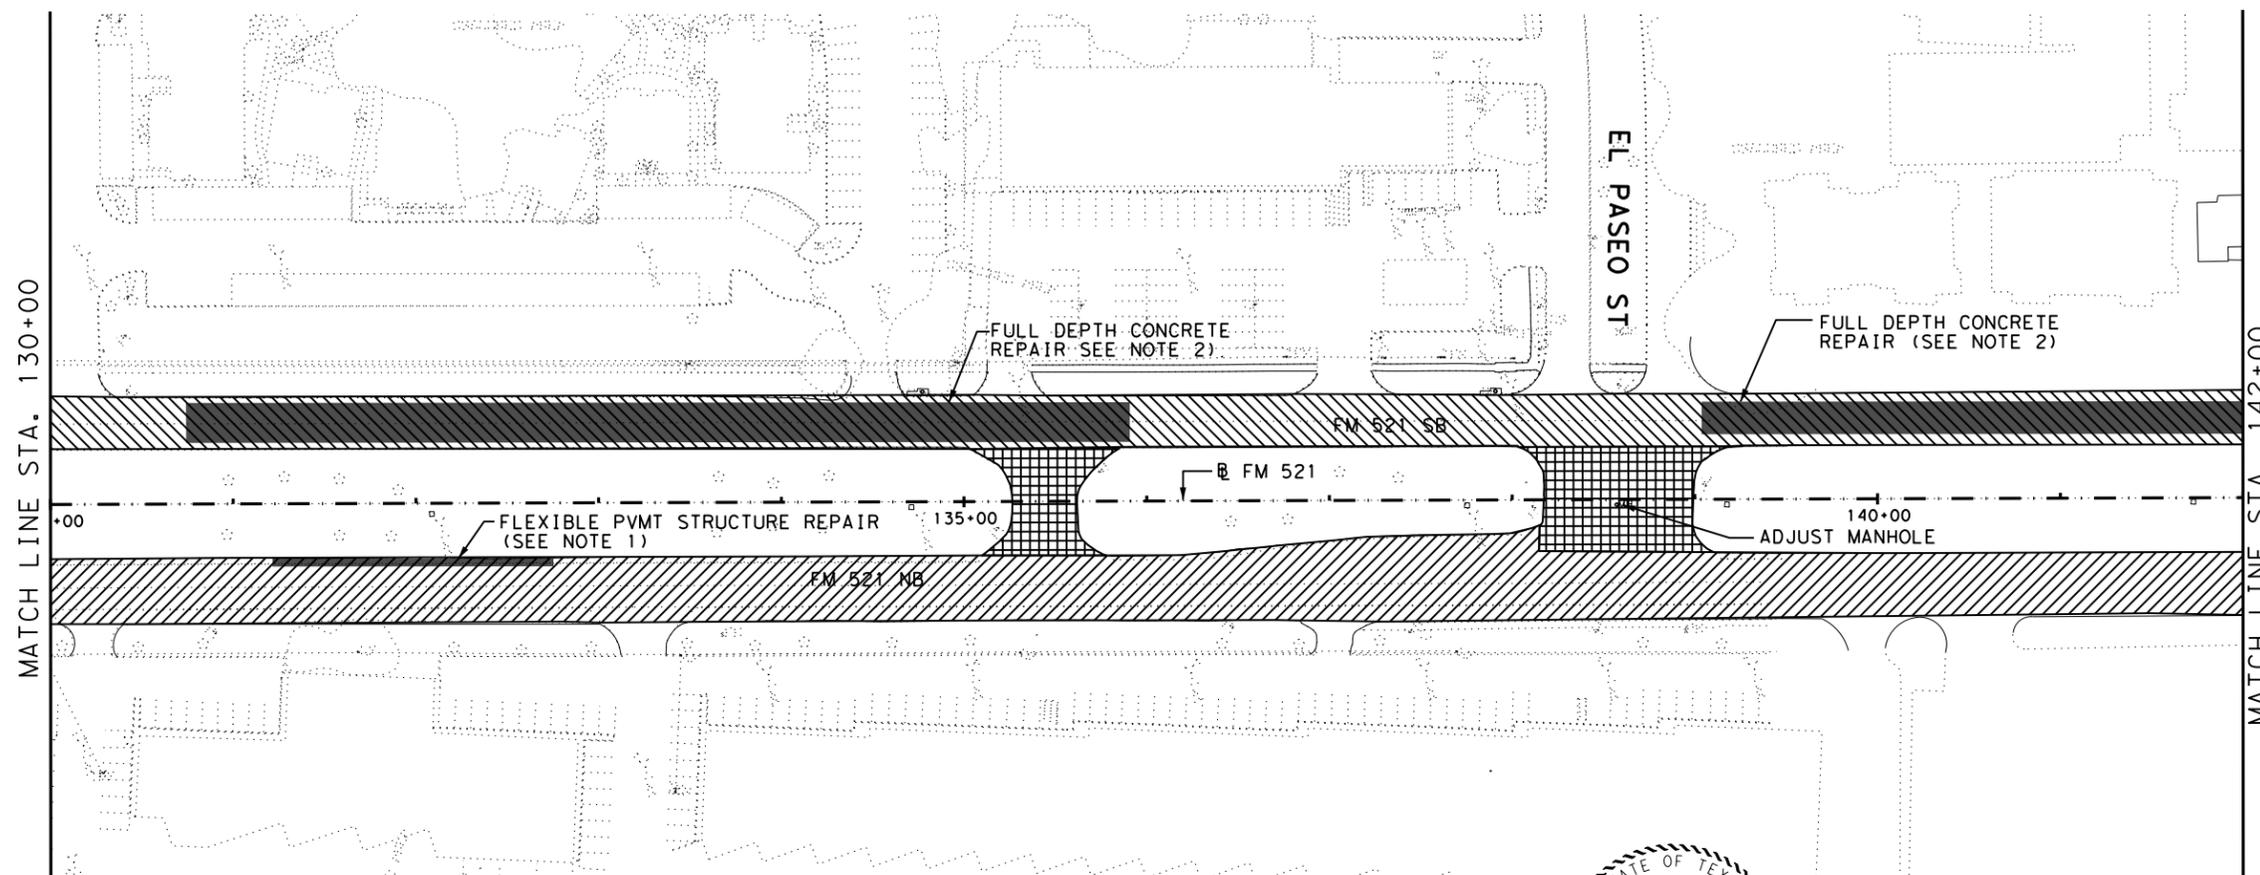 


10/9/2020 3:57:35 PM T:\HUM-AO\Des\ign\Roadway\FM 521\0111-01-095.DGN\ROADWAY\037 ROADWAY LAYOUT (2).dgn

NOTES:

1. AFTER MILLING (NB SIDE) LOCATION OF FLEXIBLE BASE REPAIR WILL BE DETERMINED BY THE ENGINEER. NO FLEXIBLE BASE REPAIR WILL BE MADE PRIOR TO MILLING.
2. THE LOCATION OF CURB AND FULL DEPTH CONCRETE REPAIR (SB SIDE) WILL BE VERIFIED AND MARKED BY THE ENGINEER IN THE FIELD.
3. FLEXIBLE BASE REPAIR AND FULL DEPTH CONCRETE REPAIR WILL BE PERFORMED IN ADVANCE OF ASPHALT OVERLAY.
4. FOR HOT MIX ASPHALT OVERLAY DETAILS, SEE SHEET 41-43.
5. FOR PAVEMENT MARKING LAYOUTS, SEE SHEET 57-61.
6. ADJUST MANHOLES TO MATCH PROPOSED PAVEMENT SURFACE. THE CONTRACTOR WILL VERIFY THE SIZE AND TYPE OF ALL MANHOLES NEEDED TO BE ADJUSTED.

LEGEND:



- PROPOSED 2" MILLING (NB) AND PROPOSED 1.5" HMA & SEAL COAT
- PROPOSED 0"-2" MILLING (CROSSOVER) AND PROPOSED 1.5" HMA & SEAL COAT
- PROPOSED 1.5" HMA AND SEAL COAT (SB SIDE)
- PROPOSED 0-1" MILLING AT BEGINNING AND END OF OVERLAY (SB SIDE) TO BE FILLED WITH HOT MIX ASPHALT AND SEAL COAT TO MATCH EXISTING CONCRETE PAVEMENT.

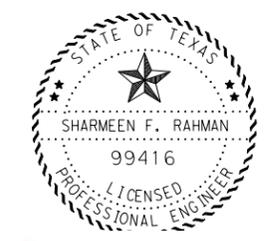

Sharmeen Rahman, P.E.
10/12/2020



FM 521			
ROADWAY LAYOUT			
SCALE: 1" = 100'		SHEET 2 OF 5	
FED. RD. DIV. NO.	PROJECT NO.		SHEET NO.
6			37
STATE	DIST	COUNTY	
TEXAS	HOU	HARRIS	
CONT	SECT	JOB	HIGHWAY
0111	01	095	FM 521

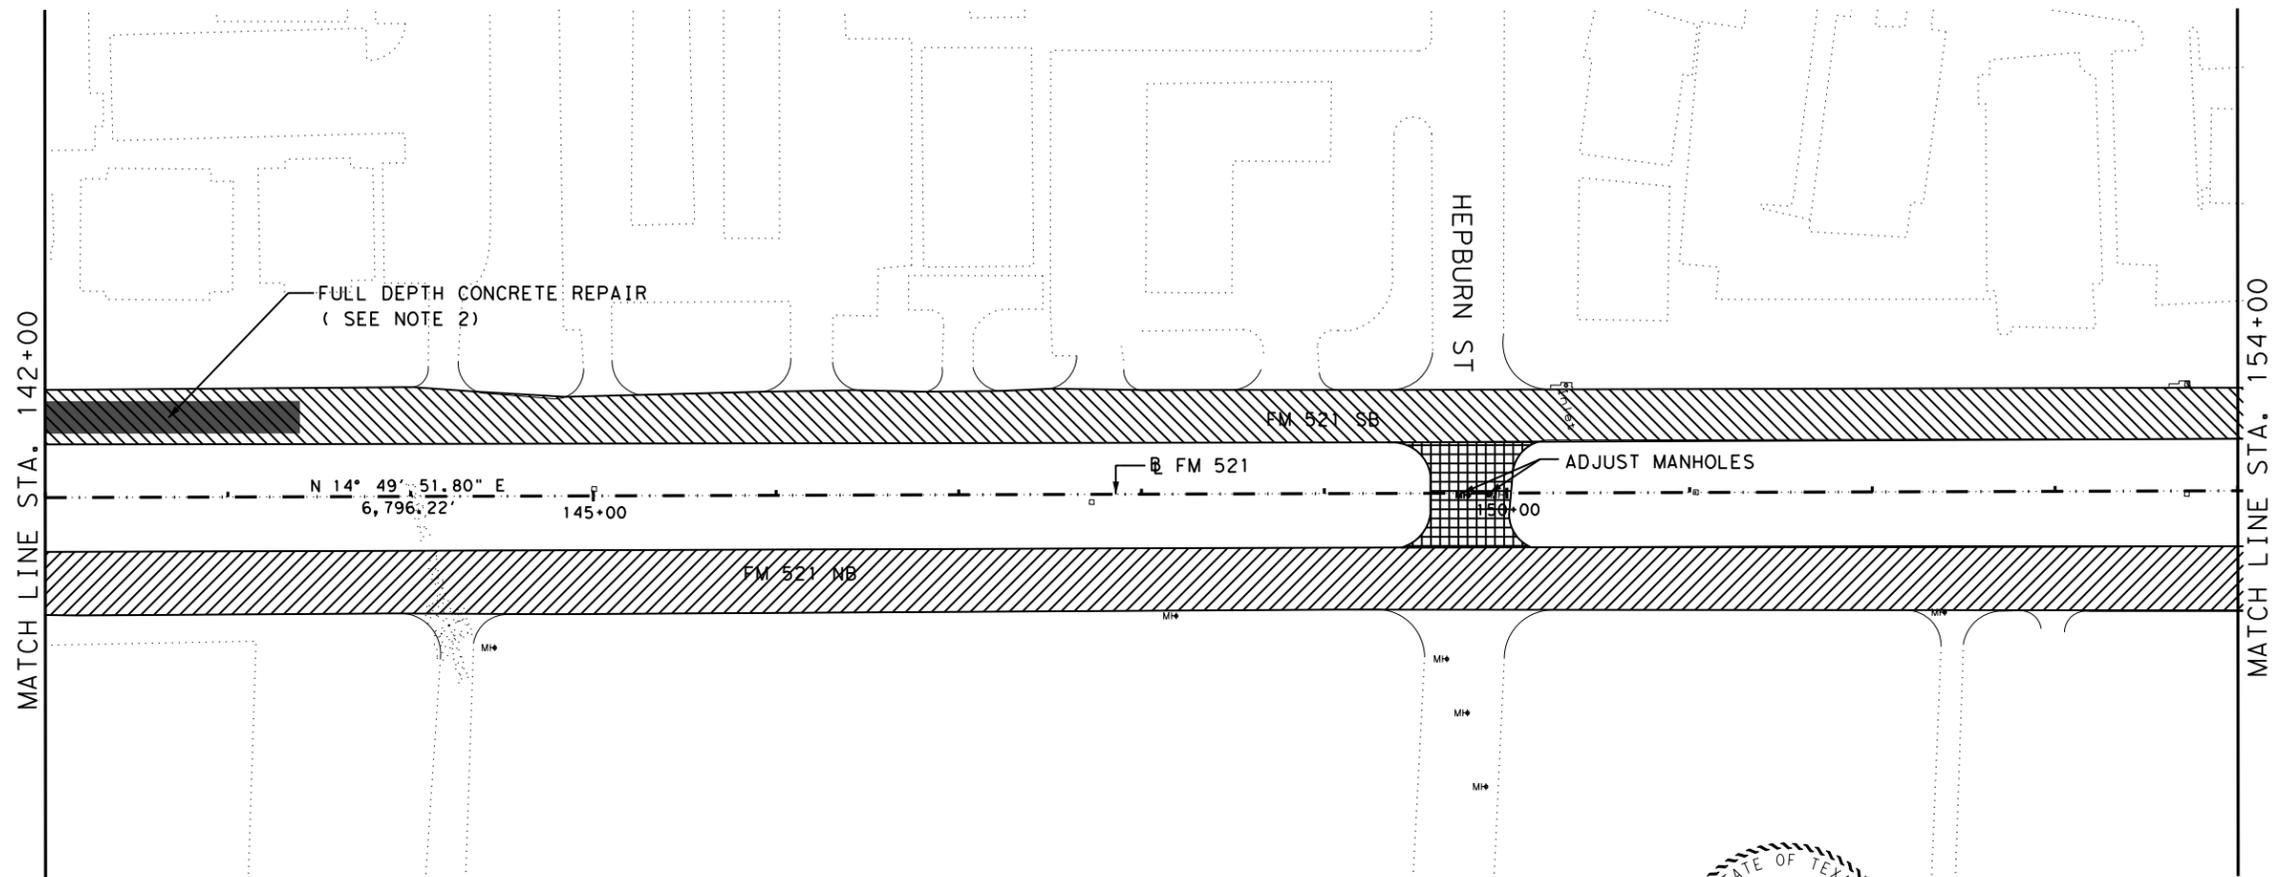 


10/9/2020 3:56:41 PM T:\HUM-AO\Des\ign\Roadway\FM 521\0111-01-095.DGN\ROADWAY\038 ROADWAY LAYOUT.dgn

NOTES:

1. AFTER MILLING (NB SIDE) LOCATION OF FLEXIBLE BASE REPAIR WILL BE DETERMINED BY THE ENGINEER. NO FLEXIBLE BASE REPAIR WILL BE MADE PRIOR TO MILLING.
2. THE LOCATION OF CURB AND FULL DEPTH CONCRETE REPAIR (SB SIDE) WILL BE VERIFIED AND MARKED BY THE ENGINEER IN THE FIELD.
3. FLEXIBLE BASE REPAIR AND FULL DEPTH CONCRETE REPAIR WILL BE PERFORMED IN ADVANCE OF ASPHALT OVERLAY.
4. FOR HOT MIX ASPHALT OVERLAY DETAILS, SEE SHEET 41-43.
5. FOR PAVEMENT MARKING LAYOUTS, SEE SHEET 57-61.
6. ADJUST MANHOLES TO MATCH PROPOSED PAVEMENT SURFACE. THE CONTRACTOR WILL VERIFY THE SIZE AND TYPE OF ALL MANHOLES NEEDED TO BE ADJUSTED.

LEGEND:

- PROPOSED 2" MILLING (NB) AND PROPOSED 1.5" HMA & SEAL COAT
- PROPOSED 0"-2" MILLING (CROSSOVER) AND PROPOSED 1.5" HMA & SEAL COAT
- PROPOSED 1.5" HMA AND SEAL COAT (SB SIDE)
- PROPOSED 0-1" MILLING AT BEGINNING AND END OF OVERLAY (SB SIDE) TO BE FILLED WITH HOT MIX ASPHALT AND SEAL COAT TO MATCH EXISTING CONCRETE PAVEMENT.


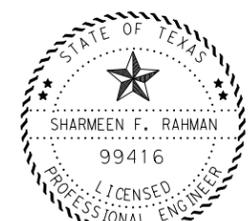


Sharmeen Rahman, P.E.
10/12/2020



FM 521
ROADWAY LAYOUT

SCALE: 1" = 100'		SHEET 3 OF 5	
FED. RD. DIV. NO. 6	PROJECT NO.		SHEET NO. 38
STATE TEXAS	DIST HOU	COUNTY HARRIS	
CONT 0111	SECT 01	JOB 095	HIGHWAY FM 521

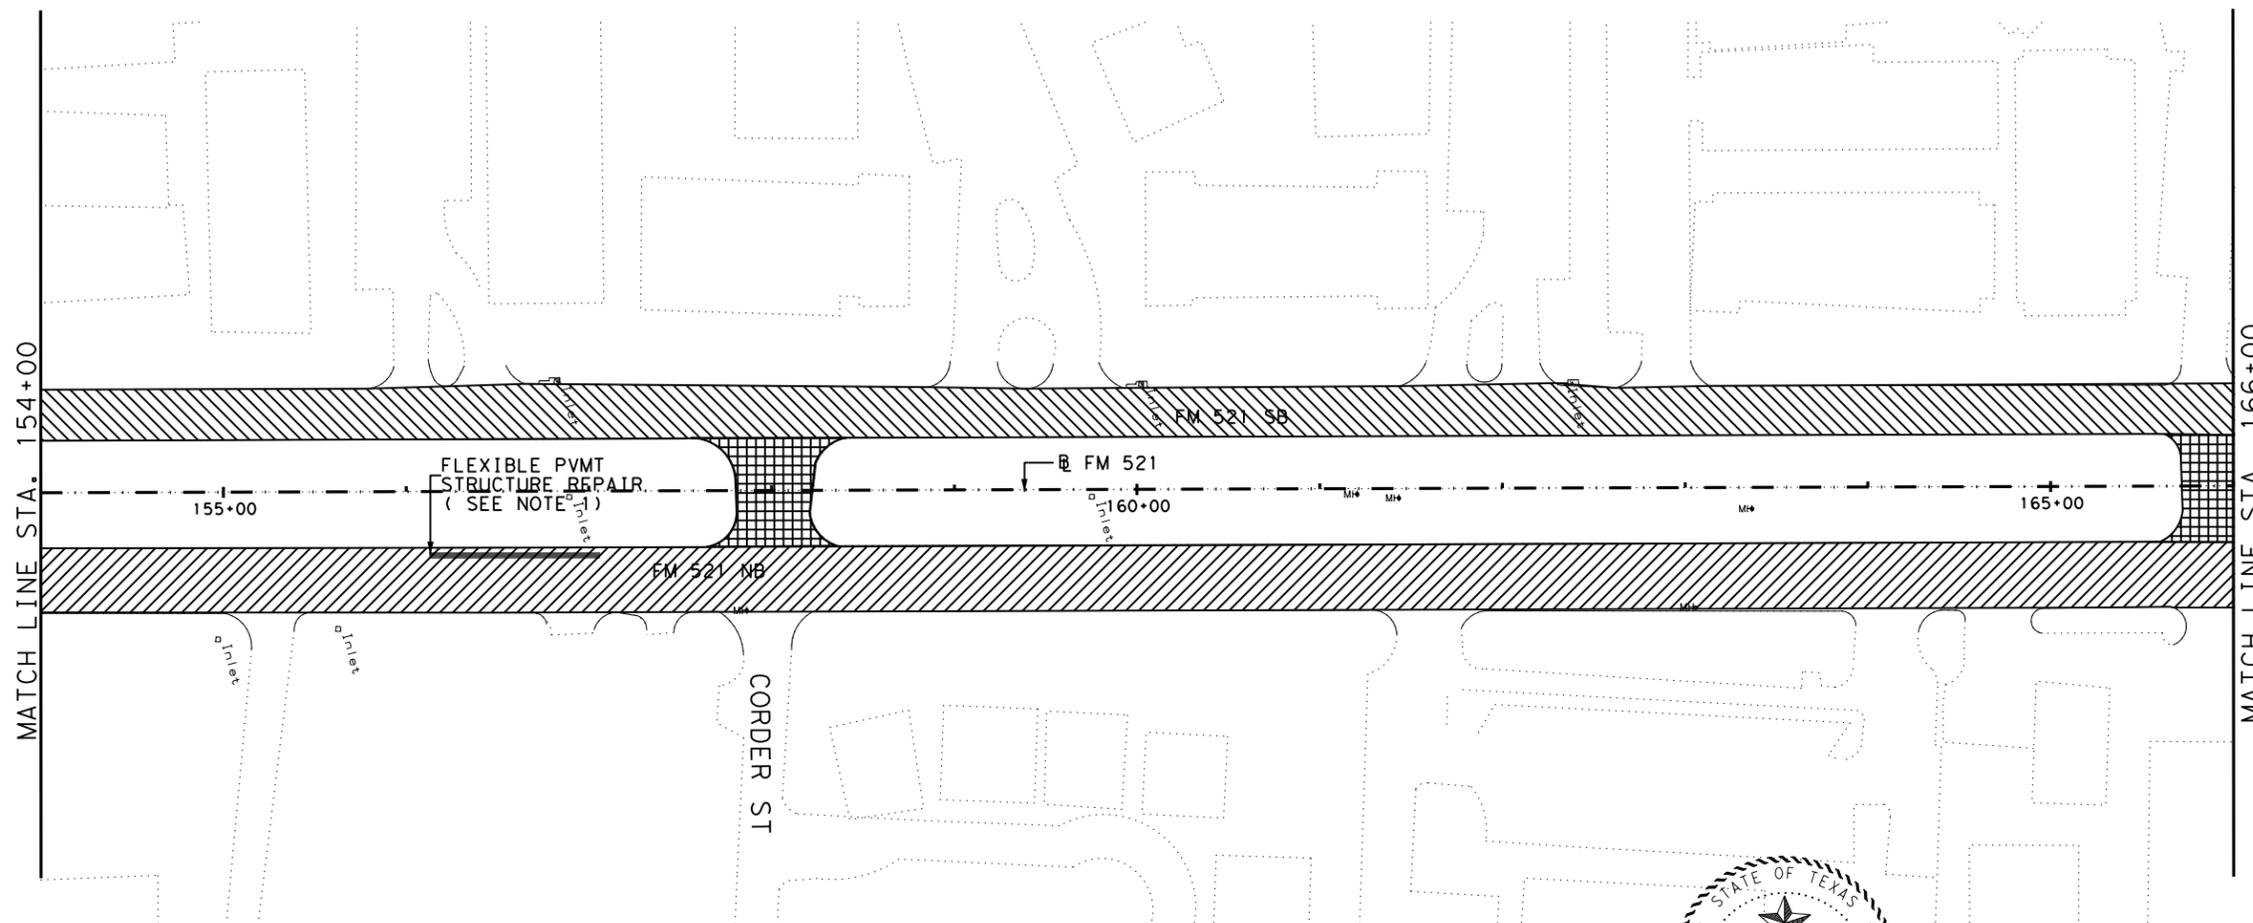 


10/9/2020 3:55:51 PM T:\HUM-AO\Des\ign\Roadway\FM 521\0111-01-095.DGN\ROADWAY\039 ROADWAY LAYOUT.dgn

NOTES:

1. AFTER MILLING (NB SIDE) LOCATION OF FLEXIBLE BASE REPAIR WILL BE DETERMINED BY THE ENGINEER. NO FLEXIBLE BASE REPAIR WILL BE MADE PRIOR TO MILLING.
2. THE LOCATION OF CURB AND FULL DEPTH CONCRETE REPAIR (SB SIDE) WILL BE VERIFIED AND MARKED BY THE ENGINEER IN THE FIELD.
3. FLEXIBLE BASE REPAIR AND FULL DEPTH CONCRETE REPAIR WILL BE PERFORMED IN ADVANCE OF ASPHALT OVERLAY.
4. FOR HOT MIX ASPHALT OVERLAY DETAILS, SEE SHEET 41-43.
5. FOR PAVEMENT MARKING LAYOUTS, SEE SHEET 57-61.
6. ADJUST MANHOLES TO MATCH PROPOSED PAVEMENT SURFACE. THE CONTRACTOR WILL VERIFY THE SIZE AND TYPE OF ALL MANHOLES NEEDED TO BE ADJUSTED.

LEGEND:

- PROPOSED 2" MILLING (NB) AND PROPOSED 1.5" HMA & SEAL COAT
- PROPOSED 0"-2" MILLING (CROSSOVER) AND PROPOSED 1.5" HMA & SEAL COAT
- PROPOSED 1.5" HMA AND SEAL COAT (SB SIDE)
- PROPOSED 0-1" MILLING AT BEGINNING AND END OF OVERLAY (SB SIDE) TO BE FILLED WITH HOT MIX ASPHALT AND SEAL COAT TO MATCH EXISTING CONCRETE PAVEMENT.

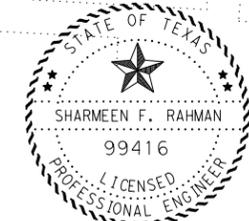


Sharmeen Rahman, P.E.
10/12/2020



FM 521
ROADWAY LAYOUT

SCALE: 1" = 100'		SHEET 4 OF 5	
FED. RD. DIV. NO. 6	PROJECT NO.	SHEET NO. 39	
STATE TEXAS	DIST HOU	COUNTY HARRIS	
CONT 0111	SECT 01	JOB 095	HIGHWAY FM 521

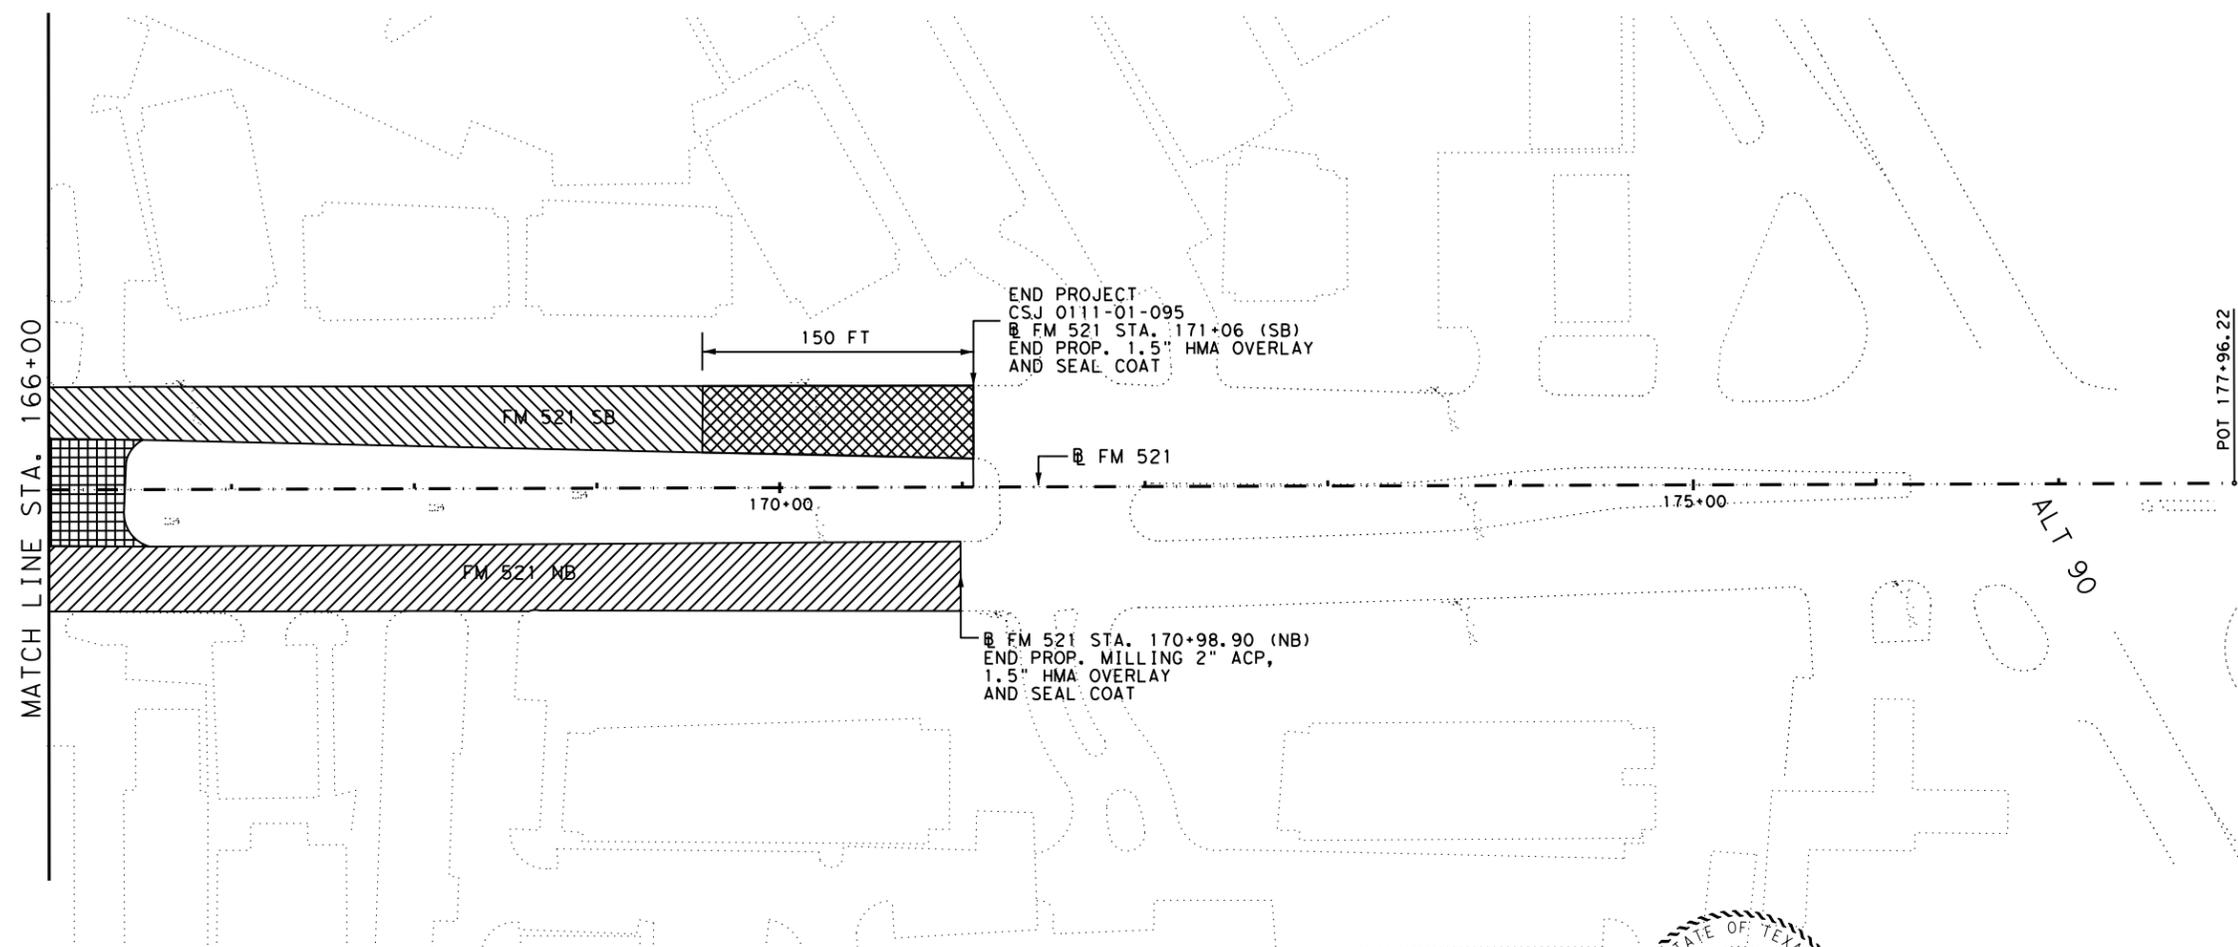

END PROJECT
CSJ 0111-01-095
@ FM 521 STA. 171+06 (SB)
END PROP. 1.5" HMA OVERLAY
AND SEAL COAT

@ FM 521 STA. 170+98.90 (NB)
END PROP. MILLING 2" ACP,
1.5" HMA OVERLAY
AND SEAL COAT

MATCH LINE STA. 166+00

POT 177+96.22

ALT 90


10/9/2020 3:54:52 PM T:\HUM-AO\Des\ign\Roadway\FM 521\0111-01-095.DGN\ROADWAY\040 ROADWAY LAYOUT.dgn

NOTES:


1. AFTER MILLING (NB SIDE) LOCATION OF FLEXIBLE BASE REPAIR WILL BE DETERMINED BY THE ENGINEER. NO FLEXIBLE BASE REPAIR WILL BE MADE PRIOR TO MILLING.
2. THE LOCATION OF CURB AND FULL DEPTH CONCRETE REPAIR (SB SIDE) WILL BE VERIFIED AND MARKED BY THE ENGINEER IN THE FIELD.
3. FLEXIBLE BASE REPAIR AND FULL DEPTH CONCRETE REPAIR WILL BE PERFORMED IN ADVANCE OF ASPHALT OVERLAY.
4. FOR HOT MIX ASPHALT OVERLAY DETAILS, SEE SHEET 41-43.
5. FOR PAVEMENT MARKING LAYOUTS, SEE SHEET 57-61.
6. ADJUST MANHOLES TO MATCH PROPOSED PAVEMENT SURFACE. THE CONTRACTOR WILL VERIFY THE SIZE AND TYPE OF ALL MANHOLES NEEDED TO BE ADJUSTED.

LEGEND:

- PROPOSED 2" MILLING (NB) AND PROPOSED 1.5" HMA & SEAL COAT
- PROPOSED 0"-2" MILLING (CROSSOVER) AND PROPOSED 1.5" HMA & SEAL COAT
- PROPOSED 1.5" HMA AND SEAL COAT (SB SIDE)
- PROPOSED 0-1" MILLING AT BEGINNING AND END OF OVERLAY (SB SIDE) TO BE FILLED WITH HOT MIX ASPHALT AND SEAL COAT TO MATCH EXISTING CONCRETE PAVEMENT.

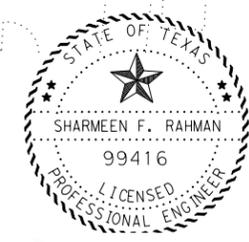


Sharmeen Rahman, P.E.
10/12/2020

 

FM 521
ROADWAY LAYOUT

SCALE: 1" = 100'		SHEET 5 OF 5	
FED. RD. DIV. NO. 6	PROJECT NO.	SHEET NO. 40	
STATE TEXAS	DIST HOU	COUNTY HARRIS	
CONT 0111	SECT 01	JOB 095	HIGHWAY FM 521


9/25/2020 2:02:27 PM
 T:\HUM-AO\Des.ign\Roadway\FM 521\0111-01-095.DGN\ROADWAY\ACP OVERLAY DETAILS.dgn

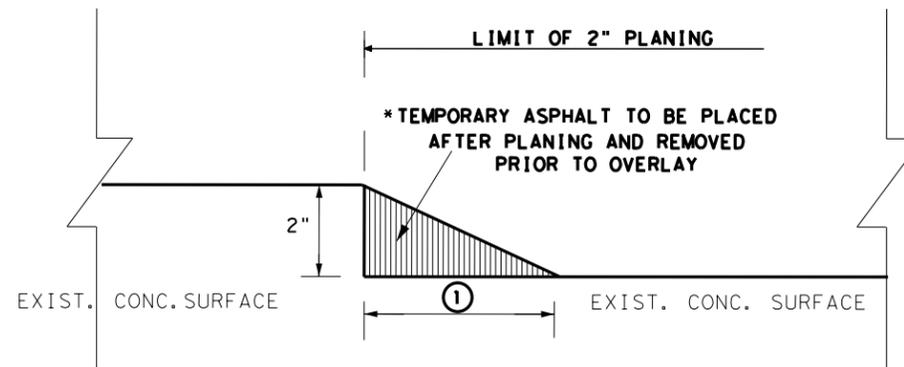

TEMPORARY ASPHALT DETAIL (NB SIDE)

① FOR APPROACH AND DEPARTURE TRAFFIC USE 10:1 TAPER RATIO (10 FEET PER INCH)
 FOR PARALLEL TRAFFIC USE 1 FT TAPER WITH 1" DROP OFF


* THIS WORK WILL NOT BE PAID FOR DIRECTLY
 AND WILL BE SUBSIDIARY TO THE PLANING
 BID ITEMS.

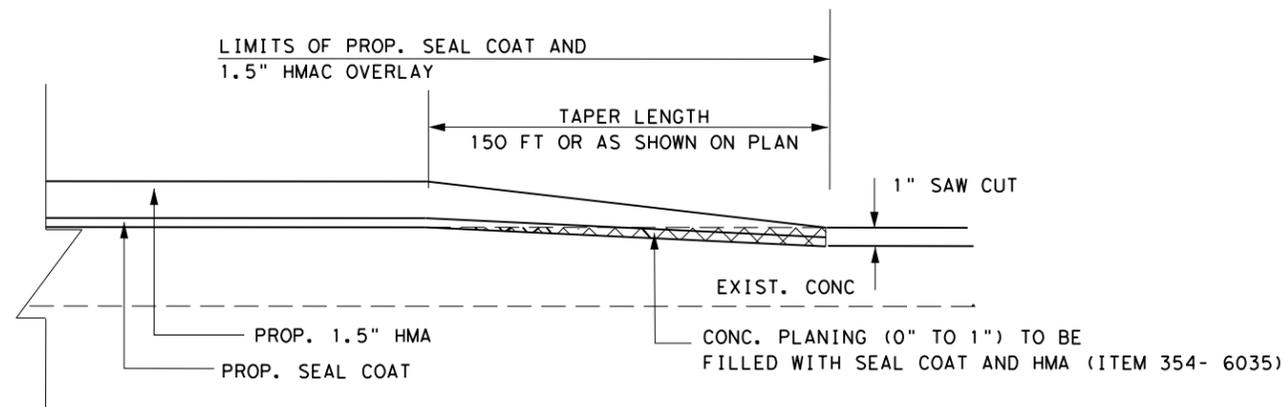

BEGINING/END HMA SURFACE TAPER (SB SIDE)

NOTE:

3. SAW CUT IS SUBSIDIARY TO THE VARIOUS BID ITEMS.

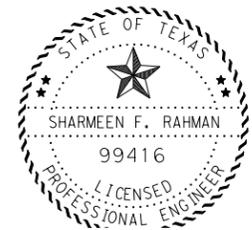

Sharmeen Rahman, P.E.

10/07/2020





FM 521

HOT MIX ASPHALT
 OVERLAY DETAIL

SCALE: N. T. S.		SHEET 1 OF 3	
FED. RD. DIV. NO. 6	PROJECT NO.	SHEET NO. 41	
STATE TEXAS	DIST HOU	COUNTY HARRIS	
CONT 0111	SECT 01	JOB 095	HIGHWAY FM 521


DETAIL "A"

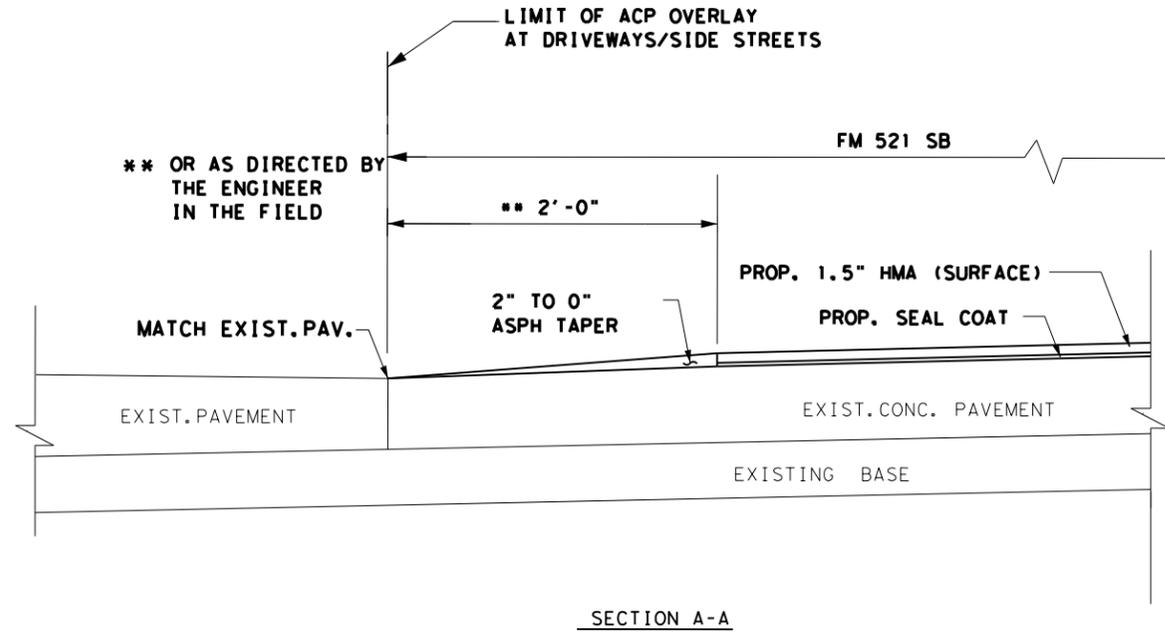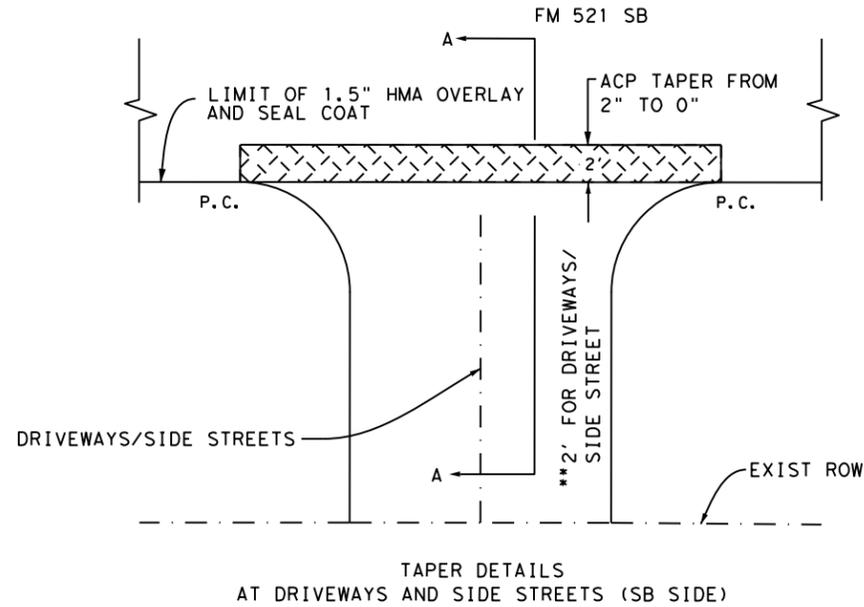



NOTE:

1. DETAIL "A", 'B' AND 'C' IS ONLY APPLICABLE TO SB SIDE.
2. HAND FINISH OVERLAY AROUND INLET OPENING. MAINTAIN EXISTING DRAINAGE.
3. SAW CUT IS SUBSIDIARY TO THE VARIOUS BID ITEMS.

DETAIL "B"

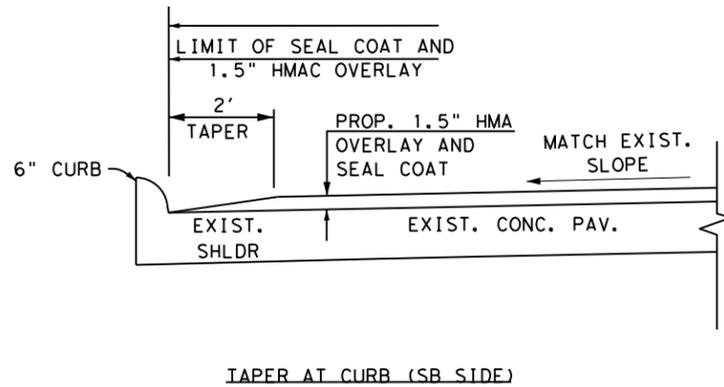

DETAIL "C"

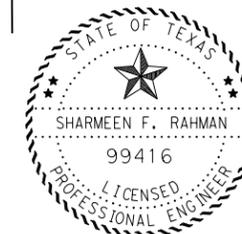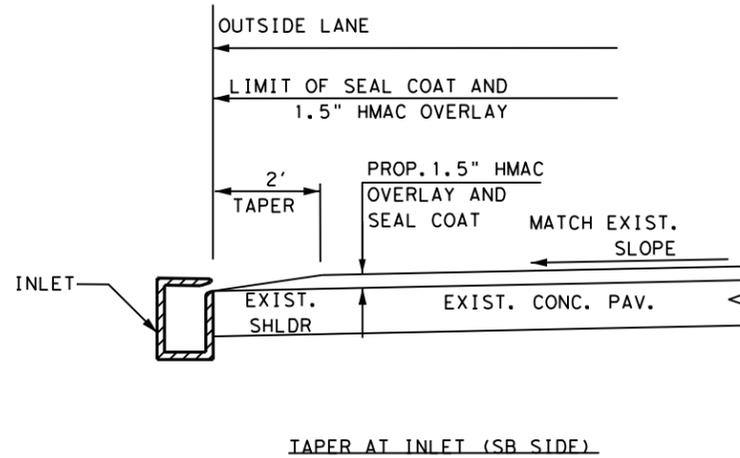

Sharmeen Rahman, P.E.
10/19/2020





FM 521

HOT MIX ASPHALT OVERLAY DETAIL

SCALE: N. T. S.		SHEET 2 OF 3	
FED. RD. DIV. NO.	PROJECT NO.	SHEET NO.	42
6			
STATE	DIST	COUNTY	
TEXAS	HOU	HARRIS	
CONT	SECT	JOB	HIGHWAY
0111	01	095	FM 521

10/19/2020 4:19:14 PM T:\HUM-AO\Design\Roadway\FM 521\0111-01-095.DGN\ROADWAY\ACP OVERLAY DETAILS.dgn

9/28/2020 11:03:43 AM
 T:\HUM-AO\Design\Roadway\FM 521\0111-01-095.DGN\ROADWAY\ACP OVERLAY DETAILS.dgn

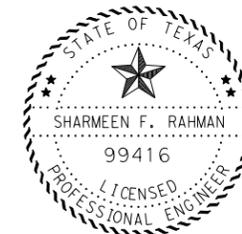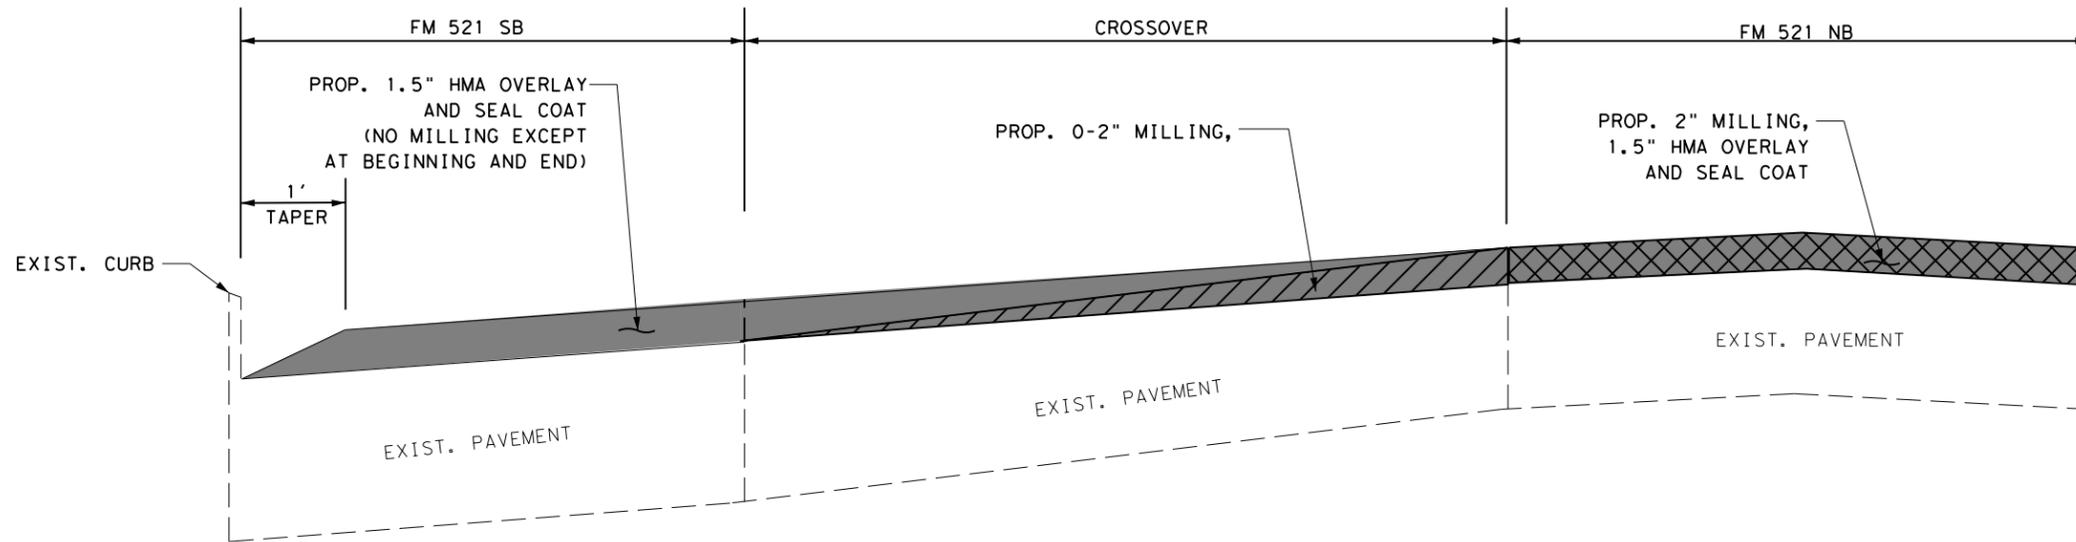

Sharmeen Rahman, P.E.

10/07/2020

 PROPOSED 1.5" HMA (ITEM 3076-6041) AND SEAL COAT (ITEM 316-6017 AND 316-6434)

 PROPOSED 0-2" MILLING AT CROSSOVER (ITEM 354-6021)

 PROPOSED 2" MILLING NB SIDE ONLY (ITEM 354-6045)




FM 521

HOT MIX ASPHALT
OVERLAY DETAIL

SCALE: N. T. S.		SHEET 3 OF 3	
FED. RD. DIV. NO. 6	PROJECT NO.		SHEET NO. 43
STATE TEXAS	DIST HOU	COUNTY HARRIS	
CONT 0111	SECT 01	JOB 095	HIGHWAY FM 521


10/9/2020 3:42:06 PM T:\HUM-AO\Desi\gn\Roadway\FM 521\0111-01-095\DGN\ROADWAY\044 FLEXIBLE PAVEMENT REPAIR DETAIL (NB SIDE).dgn

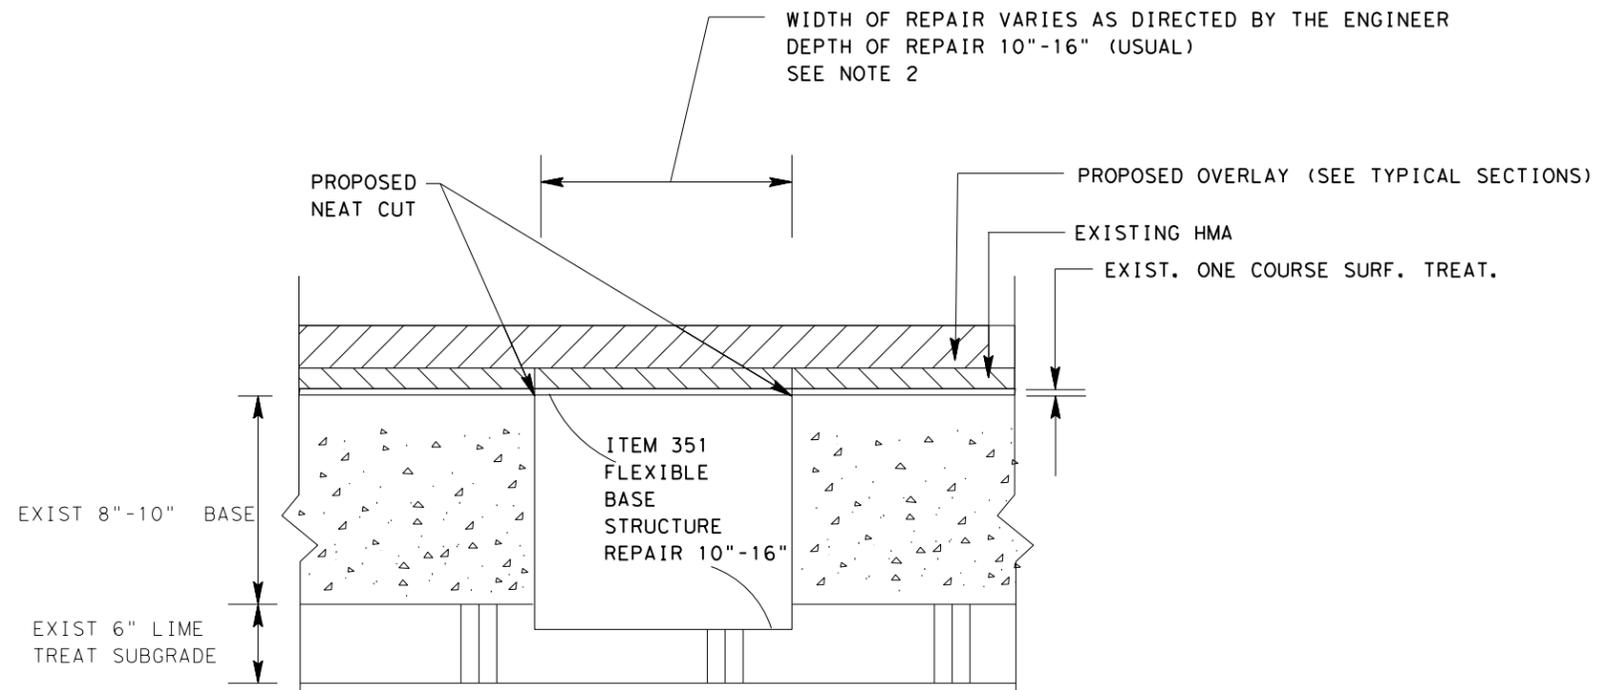

FLEXIBLE PAVEMENT REPAIR DETAIL


NOTES:

1. THE LOCATION OF ALL REPAIRS SHOWN VARIES THROUGHOUT THE TRAVEL LANES. THE ENGINEER SHALL MARK AND VERIFY ALL AREAS TO BE REPAIRED PRIOR TO COMMENCEMENT OF WORK.
2. QUANTITIES SHOWN IN THE PLANS ARE FOR BASIS OF ESTIMATE ONLY AND WILL VARY AS DETERMINED BY THE ENGINEER.
3. ALL FLEXIBLE PAVEMENT STRUCTURE REPAIR SHALL BE PERFORMED IN ACCORDANCE WITH ITEM 351.
4. THE MATERIAL FOR BASE REPAIR SHALL BE ASPHALT STABILIZED BASE CONFORMING TO ITEM 292. USE GRADE 2, PG=64.
5. NEAT CUTS SHALL BE SUBSIDIARY TO ITEM 351.
6. ON ALL BASE REPAIR LOCATIONS, THE SIDES SHALL BE CUT VERTICAL, THEN CLEANED OF ALL LOOSE MATERIAL AND TACK COATED PRIOR TO ANY PLACEMENT OF ASPHALT STABILIZED BASE

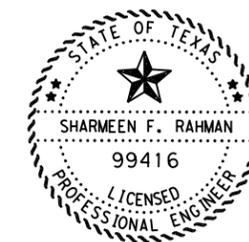


Sharmeen Rahman

 10/09/2020



FLEXIBLE PAVEMENT REPAIR DETAIL (NB SIDE)


SCALE: N. T. S.		SHEET 1 OF 1	
FED. RD. DIV. NO. 6	PROJECT NO.		SHEET NO. 44
STATE TEXAS	DIST HOU	COUNTY HARRIS	
CONT 0111	SECT 01	JOB 095	HIGHWAY FM 521

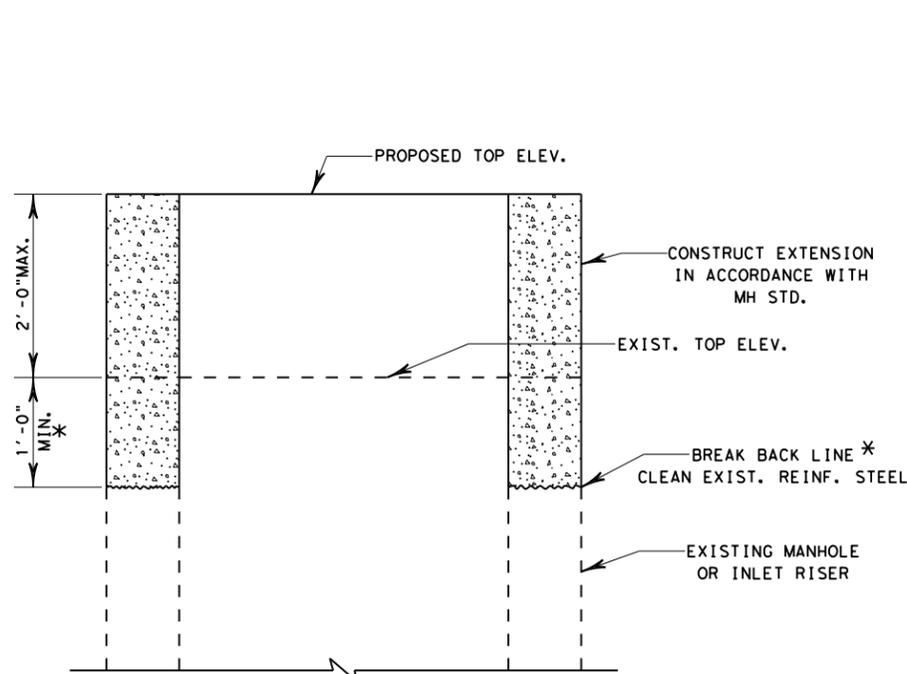

* BREAK BACK 1'-0" MIN. OR AS REQUIRED TO PROVIDE 10" MIN. LAP IN VERTICAL REINFORCING

EXISTING FRAME & GRATE OR RING & COVER MAY BE RE-USED, IF APPROVED.


VERTICAL EXTENSIONS
 $< 2'-0"$

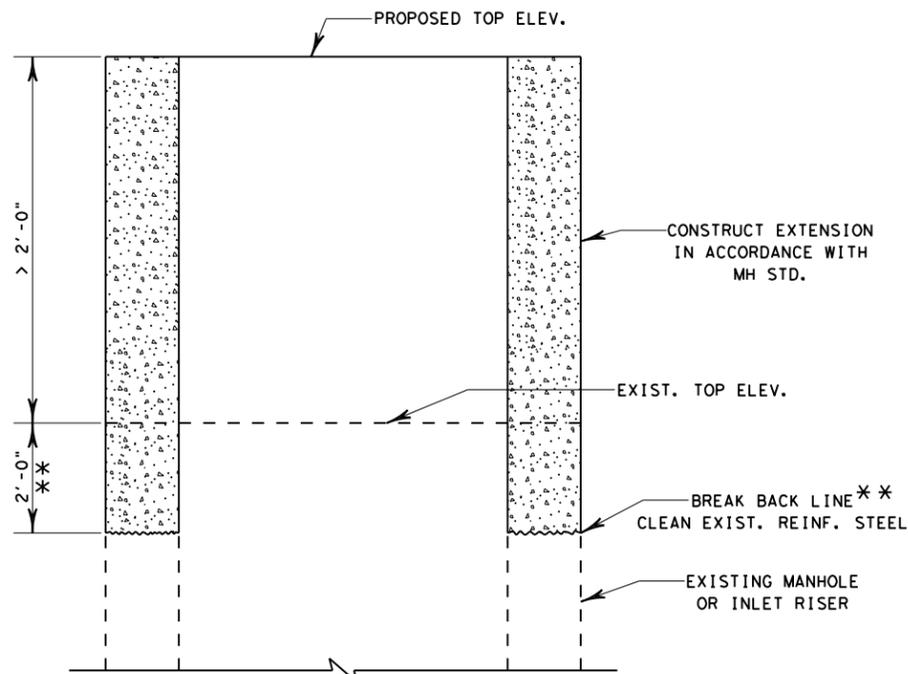

** BREAK BACK 2'-0" MIN. OR AS REQUIRED TO PROVIDE 1'-9" MIN. LAP IN VERTICAL REINFORCING

EXISTING FRAME & GRATE OR RING & COVER MAY BE RE-USED, IF APPROVED.


VERTICAL EXTENSIONS
 $> 2'-0"$

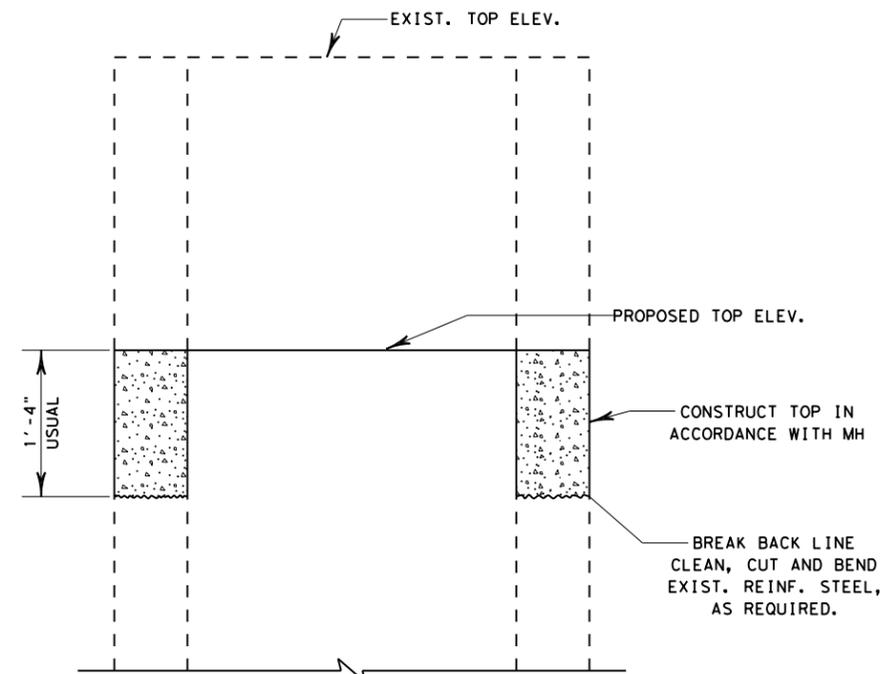

EXISTING FRAME & GRATE OR RING & COVER MAY BE RE-USED, IF APPROVED.

VERTICAL REDUCTION


MANHOLE AND INLET ADJUSTMENT DETAILS

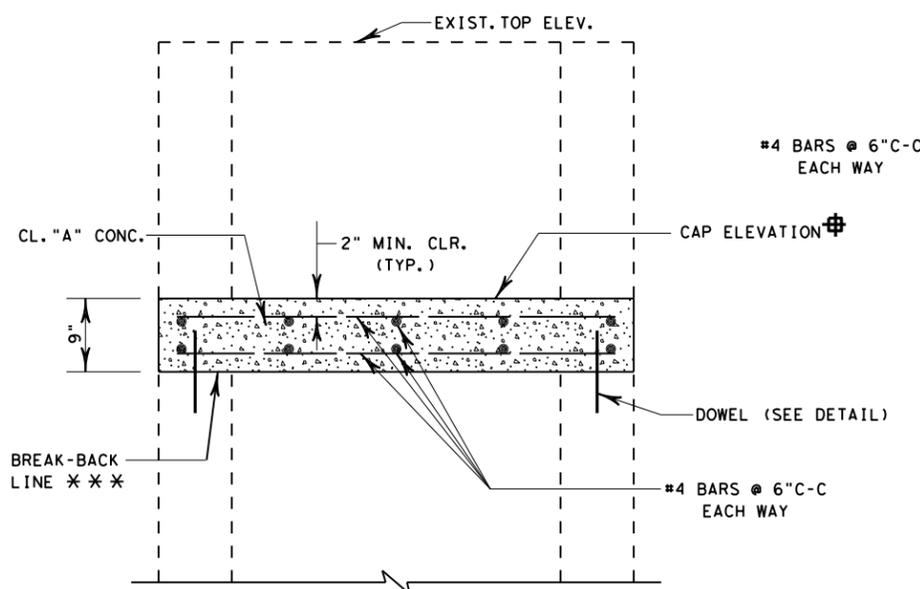

*** CUT STEEL FLUSH WITH CONCRETE & LEVEL WITH GROUT.

MANHOLE OR INLET CAP


MINIMUM 1' BELOW FINISHED GRADE OR SUBGRADE, UNLESS OTHERWISE APPROVED

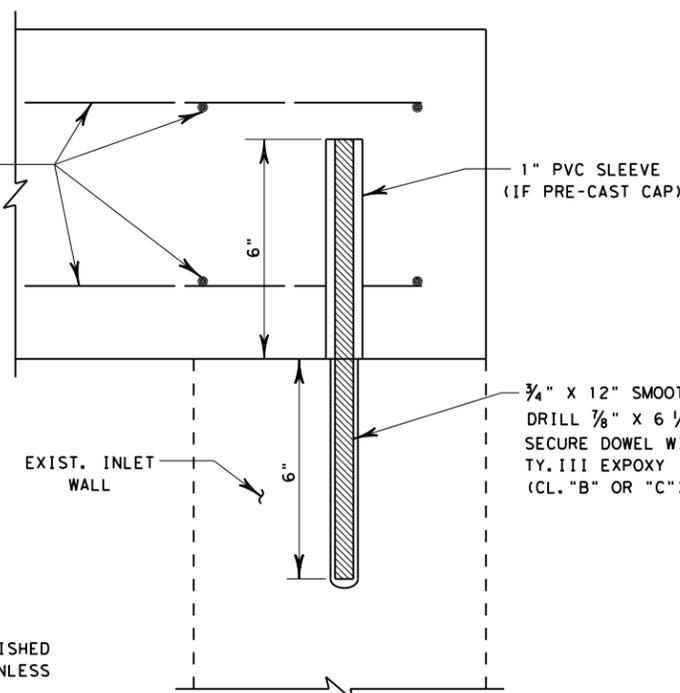

DOWEL DETAIL

MIN. - 4 EA. - PLACED AT CORNERS OF INLET OR MANHOLE FOR CURB INLETS, PLACE AT CORNERS AND AT 5'± C-C ALONG WALLS

MANHOLE AND INLET CAP DETAILS

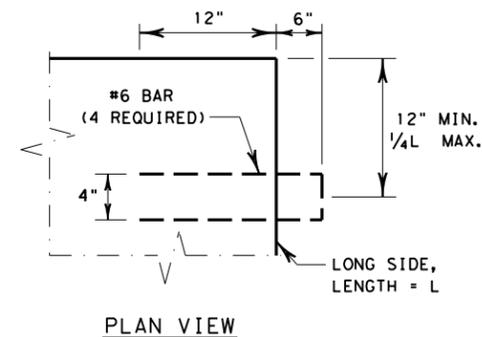

PLAN VIEW


SECTION VIEW

LIFTING LOOPS


USE WITH PRE-CAST CAP

GENERAL NOTES

ALL CONCRETE SHALL BE CLASS A.
 MANHOLE AND INLET CAPS MAY BE PRE-CAST OR CAST-IN-PLACE. IF CAST-IN-PLACE, PERMANENT METAL DECK FORMS (PMDF) MAY BE USED. THE METHOD OF SUPPORTING PMDF TO BE APPROVED IN WRITING

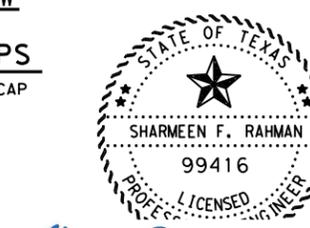

Sharmeen Rahman, P.E.
 10/09/2020

 

FM 521


MANHOLE ADJUSTMENT AND CAP DETAILS

FED. RD. DIV. NO.	PROJECT NO.		SHEET NO.
6			45
STATE	DIST	COUNTY	
TEXAS	HOU	HARRIS	
CONT	SECT	JOB	HIGHWAY
0111	01	095	FM 521



DISCLAIMER: The use of this standard is governed by the "Texas Engineering Practice Act". No warranty of any kind is made by TxDOT for any purpose whatsoever. TxDOT assumes no responsibility for the conversion of this standard to other formats or for incorrect results or damages resulting from its use.

DEFINITION OF TREATMENT ZONES FOR VARIOUS EDGE CONDITIONS


Edge Height (D) in Inches versus Lateral Clearance (Y) in Feet

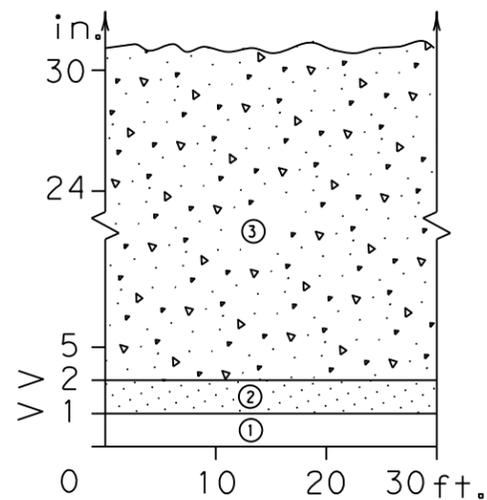



Edge Condition I
S = (3:1) (or flatter)

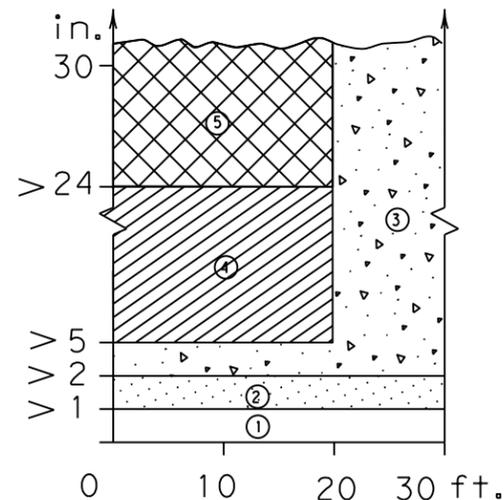 

Edge Condition II
S = ((2.99):1) to (1:1)

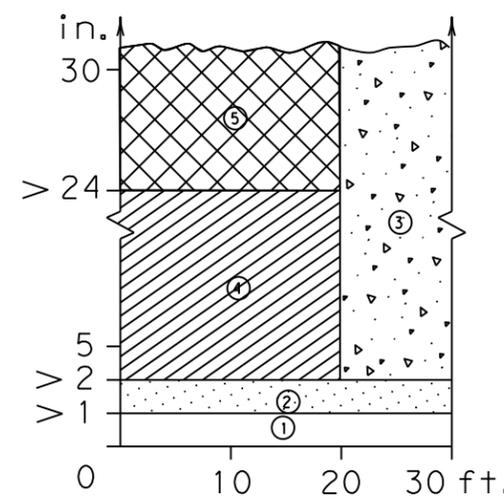

 Edge Condition III
S is steeper than (1:1)

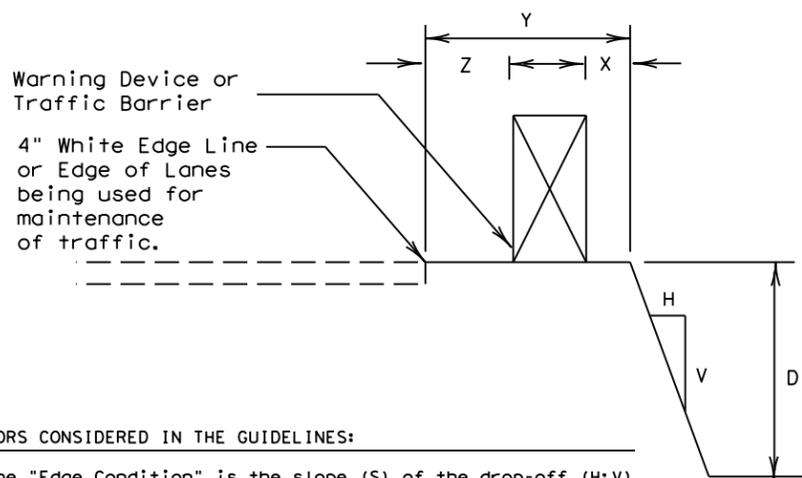


Zone	Treatment Types Guidelines:
①	No treatment.
②	CW 8-11 "Uneven Lanes" signs.
③	CW 8-9a "Shoulder Drop-Off" or CW 8-11 signs plus vertical panels.
④	CW 8-9a or CW 8-11, signs plus drums. Where restricted space precludes the use of drums, use vertical panels. An edge fill may be provided to change the edge slope to that of the preferable Edge Condition I.
⑤	Check indications (Figure-1) for positive barrier. Where positive barrier is not indicated, the treatment shown above for Zone- 4 may be used after consideration of other applicable factors.

Edge Condition Notes:

- Edge Condition I: Most vehicles are able to traverse an edge condition with a slope rate of (3 to 1) or flatter. The slope must be constructed with a compacted material capable of supporting vehicles.
- Edge Condition II: Most vehicles are able to traverse an edge condition with a slope between (2.99 to 1) and (1 to 1) so long as "D" does not exceed 5 inches. Under-carriage drag on most automobiles will occur when "D" exceeds 6 inches. As "D" exceeds 24 inches, the possibility for rollover is greater in most vehicles.
- Edge Condition III: When slopes are greater than (1 to 1) and where "D" is greater than 2 inches, a more difficult control factor may exist for some vehicles, if not properly treated. For example, where "D" is greater than 2 inches and up to 24 inches different types of vehicles may experience different steering control at different edge heights. Automobiles might experience more steering control differential when "D" is greater than 2 inches and up to 5 inches. Trucks, particularly those with high loads, have more steering control differential when "D" is greater than 5 inches and up to 24 inches. When "D" exceeds 24 inches, the possibility of rollover is greater for most vehicles.
- Milling or overlay operations that result in Edge Condition III should not be in place without appropriate warning treatments, and these conditions should not be left in place for extended periods of time.

FIGURE-1: CONDITIONS INDICATING USE OF POSITIVE BARRIER FOR ZONE 5 ([Cross-hatched symbol])

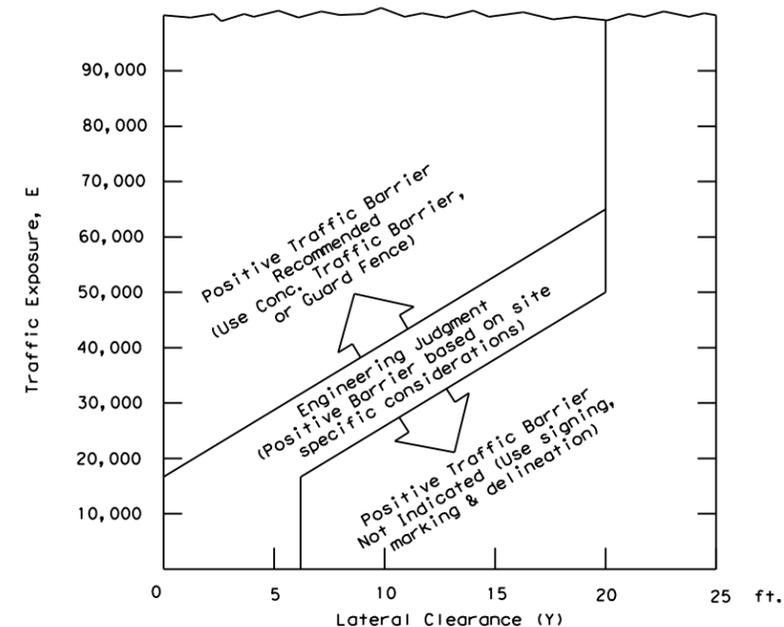

- $E = ADT \times T$
Where ADT is that portion of the average daily traffic volume traveling within 20 feet (generally two adjacent lanes) of the edge dropoff condition; and, T is the duration time in years of the dropoff condition.
- Figure-1 provides a practical approach to the use of positive barriers for the protection of vehicles from pavement drop-offs. Other factors, such as the presence of heavy machinery, construction workers, or the mix and volume of traffic may make the use of positive barriers appropriate, even when the edge condition alone may not justify the use of a barrier.
- An approved end treatment should be provided for any positive barrier end located within a lateral offset of 20 feet from the edge of the travel lane.

These guidelines apply to temporary traffic control areas or work zones where continuous pavement edges or drop-offs exists parallel and adjacent to a lane used by traffic. The edge conditions may be present between shoulders and travel lanes, between adjacent or opposing travel lanes, or at intermediate points across the width of the paved surface. Due to the variability in construction operations, tolerances in the variables may be allowed by the engineer. These guidelines do not apply to short term operations. These guidelines do not constitute a rigid standard or policy; rather, they are guidance to be used in conjunction with engineering judgement. These guidelines may be updated on the Design Division's on-line manuals.

FACTORS CONSIDERED IN THE GUIDELINES:

- The "Edge Condition" is the slope (S) of the drop-off (H:V). The "Edge Height" is the depth of the drop-off "D".
- Distance "X" is to be the maximum practical under job conditions. Two feet minimum for high speed conditions. Distance "Y" is the lateral clearance from edge of travel lane to edge of dropoff. Distance "Z" does not have a minimum.
- In addition to the factors considered in the guidelines, each construction zone drop-off situation should be analyzed individually, taking into account other variables, such as: traffic mix, posted speed in the construction zone, horizontal curvature, and the practicality of the treatment options.
- The conditions for indicating the use of positive or protective barriers are given by Zone-5 and Figure-1. Traffic barriers are primarily applicable for high speed conditions. Urban areas with speeds of 30 mph or less may have a lesser need for signing, delineation, and barriers. Right-angled edges, however, with "D" greater than 2 inches and located within a lateral offset of 6 feet, may indicate a higher level of treatment.
- If the distance "Y" must be less than 3 feet, the use of a positive barrier may not be feasible. In such a case, consider either: 1) narrowing the lanes to a desired 11 to 12 feet or 10 foot minimum (see CW20-8 sign), or 2) provide an edge slope such as Edge Condition I.

DATE:
FILE:

Engineer's Seal

Date: 10/15/2020

Texas Department of Transportation
Traffic Operations Division

TREATMENT FOR VARIOUS EDGE CONDITIONS

© TxDOT August 2000		DN: TxDOT	CK: TxDOT	DW: TxDOT	CK: TxDOT
REVISIONS					
CONT	SECT	JOB		HIGHWAY	
0111	01	095		FM 521	
DIST	COUNTY		SHEET NO.		
HOU	HARRIS		46		

DISCLAIMER: The use of this standard is governed by the "Texas Engineering Practice Act". No warranty of any kind is made by TxDOT for any purpose whatsoever. TxDOT assumes no responsibility for the conversion of this standard to other formats or for incorrect results or damages resulting from its use.





DATE: FILE:

GENERAL NOTES

1. DETAILS FOR PAVEMENT WIDTH, PAVEMENT THICKNESS AND THE CROWN CROSS-SLOPE SHALL BE SHOWN ELSEWHERE IN THE PLANS. PAVEMENTS WIDER THAN 100 FT. WITHOUT A FREE LONGITUDINAL JOINT ARE NOT COVERED BY THIS STANDARD.
2. USE COARSE AGGREGATES WITH A RATED COEFFICIENT OF THERMAL EXPANSION (COTE) OF NOT MORE THAN 5.5×10^{-6} IN/IN/°F AS LISTED IN THE CONCRETE RATED SOURCE QUALITY CATALOG (CRSQC).
3. ALL THE REINFORCING STEEL AND TIE BARS SHALL BE DEFORMED STEEL BARS CONFORMING TO ASTM A 615 (GRADE 60) OR ASTM A 996 (GRADE 60) OR ABOVE. STEEL BAR SIZES AND SPACINGS SHALL CONFORM TO TABLE NO.1 AND TABLE NO.2.
4. STEEL BAR PLACEMENT TOLERANCE SHALL BE +/- 1 IN. HORIZONTALLY AND +/- 0.5 IN. VERTICALLY. CALCULATED AVERAGE BAR SPACING (CONCRETE PLACEMENT WIDTH / NUMBER OF LONGITUDINAL BARS) SHALL CONFORM TO TABLE NO.1
5. PAVEMENT WIDTHS OF MORE THAN 15 FT. SHALL HAVE A LONGITUDINAL JOINT (SECTION Z-Z OR SECTION Y-Y). THESE JOINTS SHALL BE LOCATED WITHIN 6 IN. OF THE LANE LINE UNLESS THE JOINT LOCATION IS SHOWN ELSEWHERE ON THE PLANS.
6. THE SAW CUT DEPTH FOR THE LONGITUDINAL CONTRACTION JOINT (SECTION Z-Z) SHALL BE ONE THIRD OF THE SLAB THICKNESS (T/3).
7. WHEN TYING CONCRETE GUTTER AT A LONGITUDINAL JOINT, THE TIE BAR LENGTH OR POSITION MAY BE ADJUSTED. PROVIDE 3 IN. OF CONCRETE COVER FROM THE BACK OF GUTTER TO THE END OF TIE BAR.
8. REPLACE MISSING OR DAMAGED TIE BARS WITHOUT ADDITIONAL COMPENSATION BY DRILLING MIN. 10 IN. DEEP AND GROUTING TIE BARS WITH TYPE III, CLASS C EPOXY. MEET THE PULL-OUT TEST REQUIREMENTS IN ITEM 361.
9. OMIT TIE BARS LOCATED WITHIN 18-IN. OF THE TRANSVERSE CONSTRUCTION JOINTS (SECTION X-X). USE HAND-OPERATED IMMERSION VIBRATORS TO CONSOLIDATE THE CONCRETE ADJACENT TO ALL FORMED JOINTS.
10. LONGITUDINAL REINFORCING STEEL SPLICES SHALL BE A MINIMUM OF 25 IN. STAGGER THE LAP LOCATIONS SO THAT NO MORE THAN 1/3 OF THE LONGITUDINAL STEEL IS SPLICED IN ANY GIVEN 12-FT. WIDTH AND 2-FT. LENGTH OF THE PAVEMENT.
11. THE DETAIL FOR THE JOINT SEALANT AND RESERVOIR IS SHOWN ON STANDARD SHEET "CONCRETE PAVING DETAILS, JOINT SEALS."

SLAB THICKNESS AND BAR SIZE		REGULAR STEEL BARS	FIRST SPACING AT EDGE OR JOINT	ADDITIONAL STEEL BARS AT TRANSVERSE CONSTRUCTION JOINT (SECTION X-X)	
T (IN.)	BAR SIZE	SPACING C (IN.)	SPACING a (IN.)	SPACING 2 x C (IN.)	LENGTH L (IN.)
7.0	#5	6.5	3 TO 4	13	50
7.5	#5	6.0	3 TO 4	12	50
8.0	#6	9.0	3 TO 4	18	50
8.5	#6	8.5	3 TO 4	17	50
9.0	#6	8.0	3 TO 4	16	50
9.5	#6	7.5	3 TO 4	15	50
10.0	#6	7.0	3 TO 4	14	50
10.5	#6	6.75	3 TO 4	13.5	50
11.0	#6	6.5	3 TO 4	13	50
11.5	#6	6.25	3 TO 4	12.5	50
12.0	#6	6.0	3 TO 4	12	50
12.5	#6	5.75	3 TO 4	11.5	50
13.0	#6	5.5	3 TO 4	11	50

SLAB THICKNESS (IN.)	TRANSVERSE STEEL		TIE BARS AT LONGITUDINAL CONTRACTION JOINT (SECTION Z-Z)		TIE BARS AT LONGITUDINAL CONTRACTION JOINT (SECTION Y-Y)	
	BAR SIZE	SPACING (IN.)	BAR SIZE	SPACING (IN.)	BAR SIZE	SPACING (IN.)
7.0 - 7.5	#5	48	#5	48	#5	24
8.0 - 13.0	#5	48	#6	48	#6	24

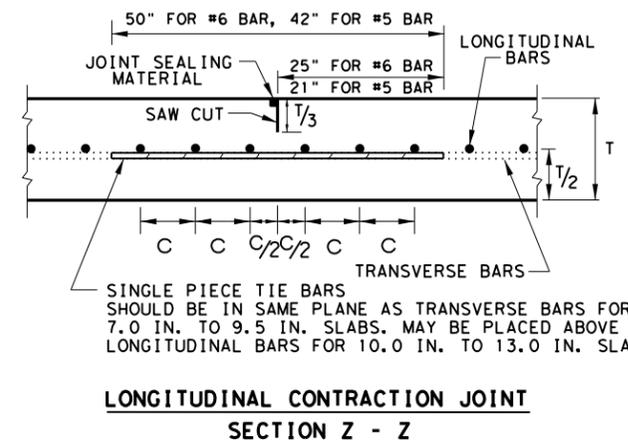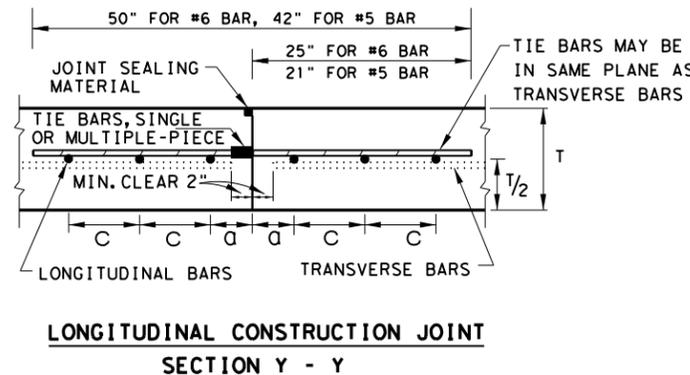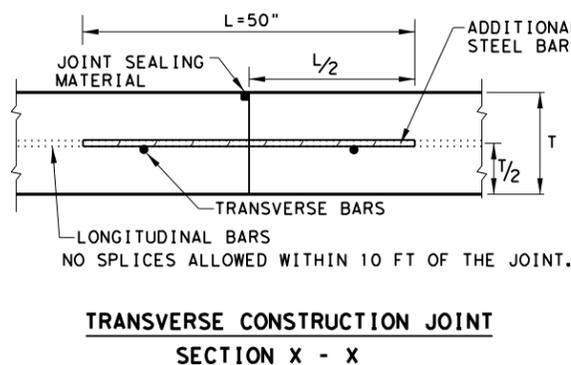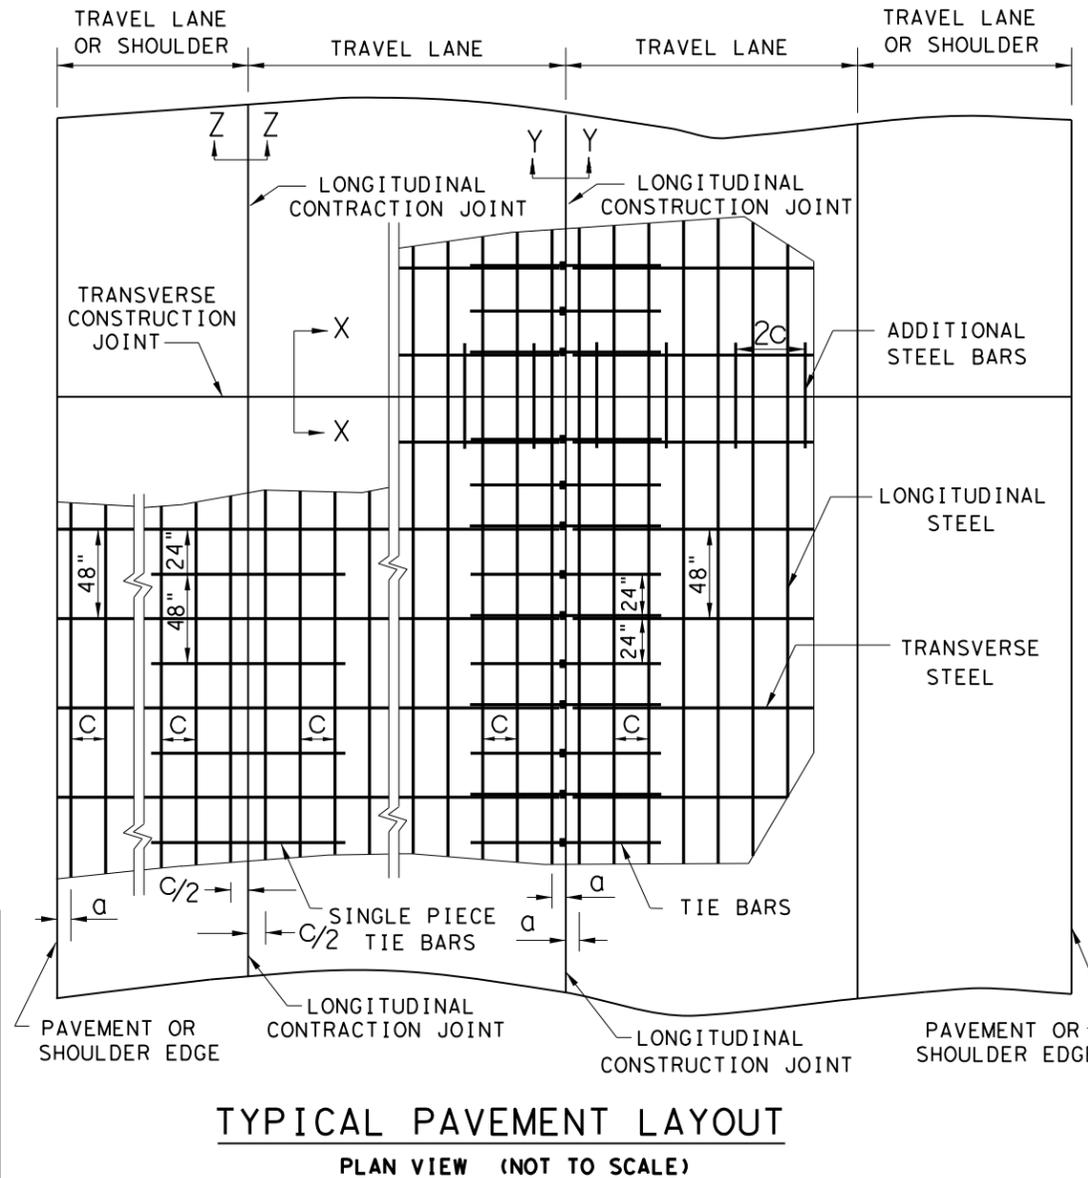


SHEET 1 OF 2


		Design Division Standard	
CONTINUOUSLY REINFORCED CONCRETE PAVEMENT ONE LAYER STEEL BAR PLACEMENT T - 7 to 13 INCHES CRCP (1) - 20			
FILE: crcp120.dgn	DN: TxDOT	CK: KM	DW: AN
© TxDOT: APRIL 2020	CONT	SECT	JOB
10/10/2011 ADD ON #12	0111	01	095
04/09/2013 REMOVE 6" AND 6.5" ADD CTE REQUIREMENTS	DIST	COUNTY	HIGHWAY
05/05/2017 COTE AS RATED 4.3	HOU	HARRIS	521
			SHEET NO. 47

DISCLAIMER: The use of this standard is governed by the "Texas Engineering Practice Act". No warranty of any kind is made by TxDOT for any purpose whatsoever. TxDOT assumes no responsibility for the conversion of this standard to other formats or for incorrect results or damages resulting from its use.


DATE:
FILE:

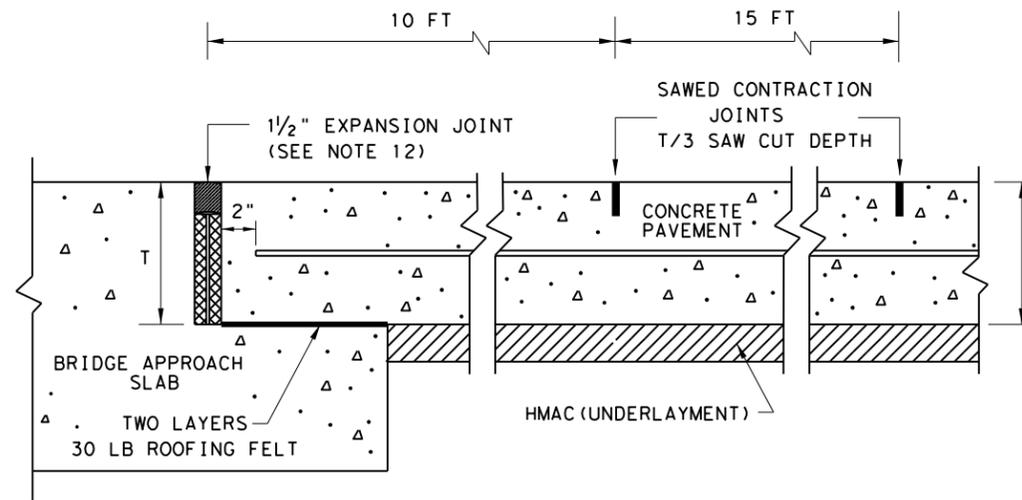

**TRANSVERSE EXPANSION JOINT DETAIL
AT BRIDGE APPROACH**

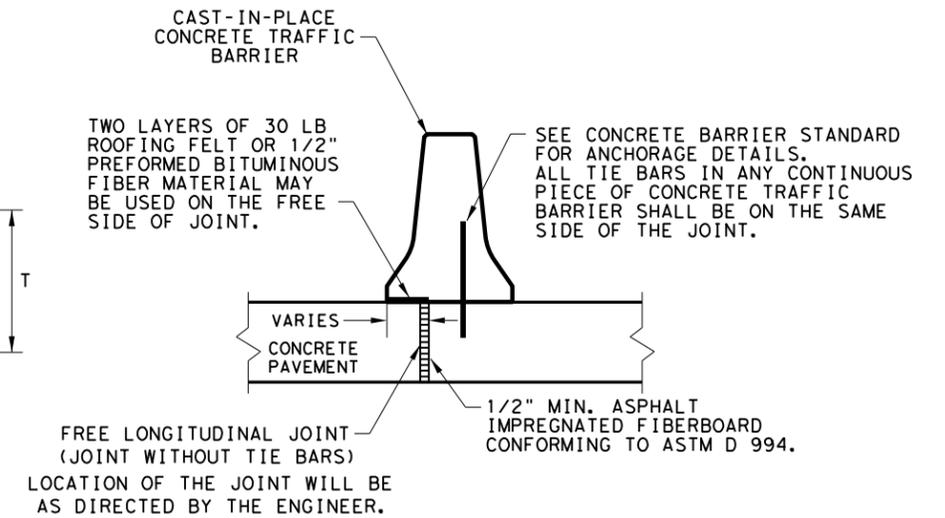


FREE LONGITUDINAL JOINT DETAIL

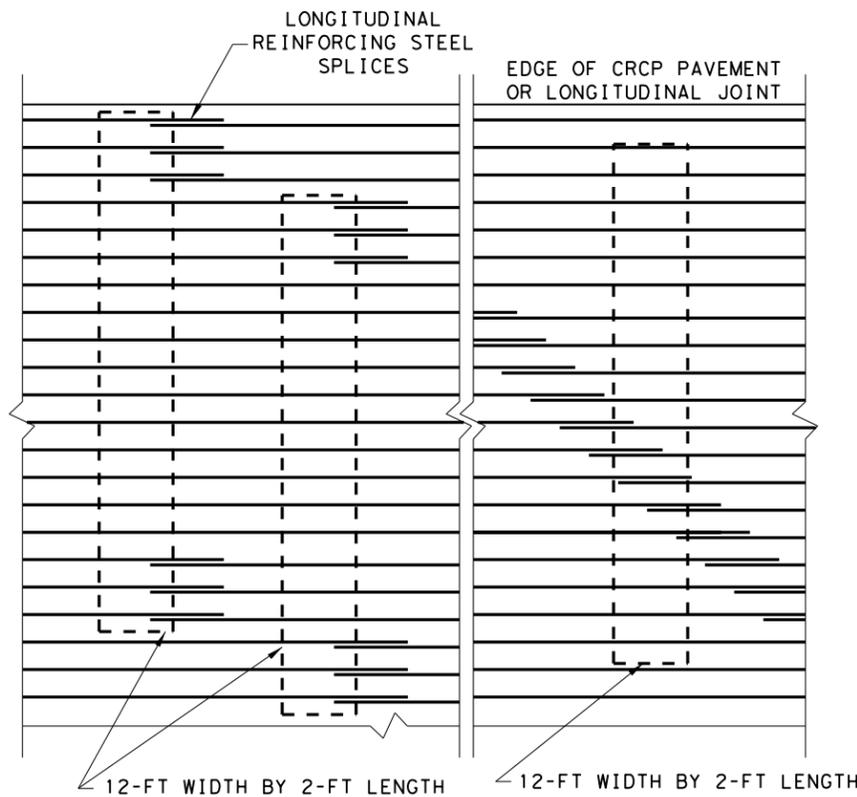


STAGGER THE LAP LOCATIONS SO THAT NO MORE THAN 1/3 OF THE LONGITUDINAL STEEL IS SPLICED IN ANY GIVEN 12-FT. WIDTH AND 2-FT. LENGTH OF THE PAVEMENT. ANY OTHER LAP CONFIGURATION MEETING THIS REQUIREMENT WILL BE ALLOWED.


**EXAMPLES OF LAP CONFIGURATION
PLAN VIEW (NOT TO SCALE)**

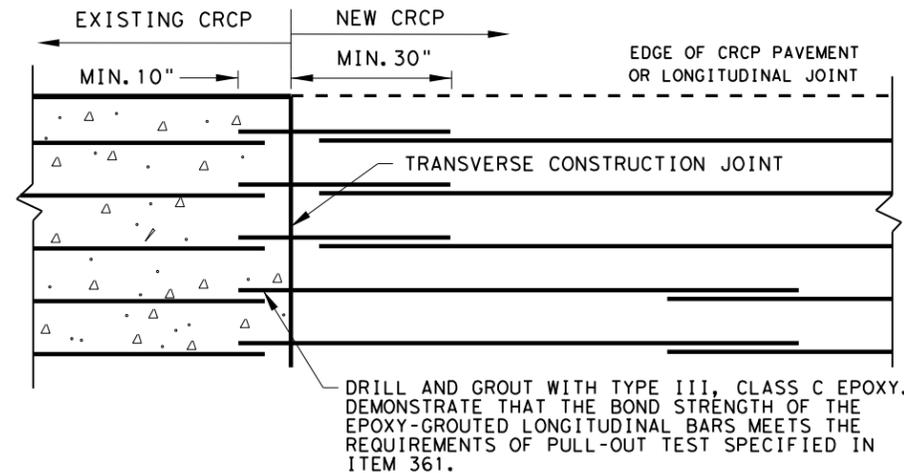

**OPTION A: DRILL AND EPOXY
PLAN VIEW (NOT TO SCALE)**

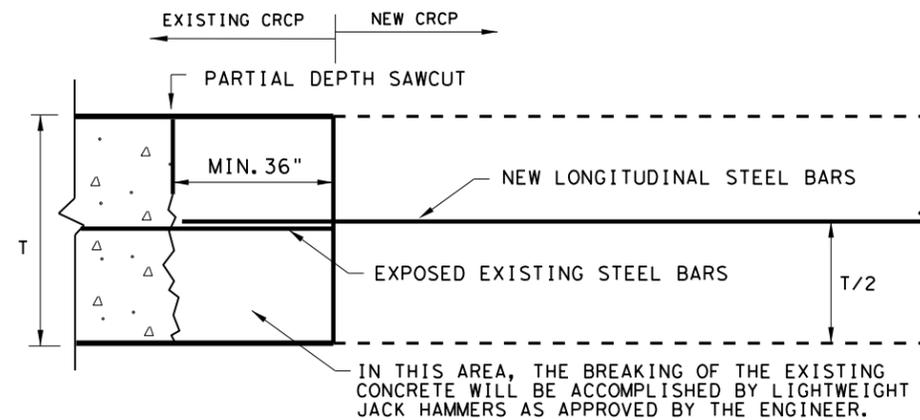

**OPTION B: BREAKBACK AND LAP
TRANSVERSE TIE JOINT DETAIL
EXISTING CRCP TO NEW CRCP**

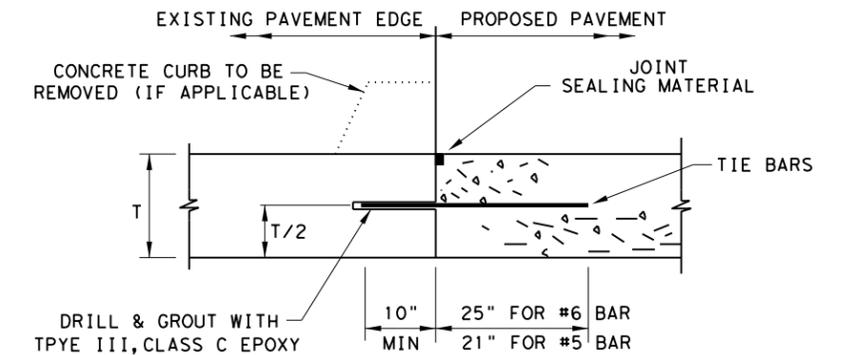

- BEFORE WIDENING WORK, DEMONSTRATE THAT THE BOND STRENGTH OF THE EPOXY-GROUTED TIE BARS MEETS THE REQUIREMENTS OF PULL-OUT TEST SPECIFIED IN ITEM 361.
- SPACE TIE BARS AT 24" SPACING. USE #6 TIE BARS FOR 8" AND THICKER SLABS, USE #5 TIE BARS FOR LESS THAN 8" THICK SLABS.

LONGITUDINAL WIDENING JOINT DETAIL

SHEET 2 OF 2


		<i>Design Division Standard</i>	
CONTINUOUSLY REINFORCED CONCRETE PAVEMENT			
ONE LAYER STEEL BAR PLACEMENT			
T - 7 to 13 INCHES			
CRCP (1) - 20			
FILE: crcp120.dgn	DN: TxDOT	CK: KM	DW: AN
© TxDOT: APRIL 2020	CONT	SECT	JOB
REVISIONS	0111	01	095
03/16/2020 REMOVED TABLE 1A	DIST	COUNTY	SHEET NO.
	HOU	HARRIS	48

DISCLAIMER: The use of this standard is governed by the "Texas Engineering Practice Act". No warranty of any kind is made by TxDOT for any purpose whatsoever. TxDOT assumes no responsibility for the conversion of this standard to other formats or for incorrect results or damages resulting from its use.

TABLE NO. 1 LONGITUDINAL STEEL					
SLAB THICKNESS AND BAR SIZE		FOR BOTH STEEL MATS		FOR TOP STEEL MAT ONLY	
		REGULAR STEEL BARS	FIRST SPACING AT EDGE OR JOINT	ADDITIONAL STEEL BARS AT TRANSVERSE CONSTRUCTION JOINT (SECTION X-X)	
T (IN.)	BAR SIZE	SPACING C (IN.)	SPACING a (IN.)	SPACING 2 x c (IN.)	LENGTH L (IN.)
14	#6	9.5	3 TO 4	19	50
15	#6	8.5	3 TO 4	17	50

TABLE NO. 2 TRANSVERSE STEEL AND TIE BARS						
SLAB THICKNESS T (IN.)	FOR BOTH STEEL MATS		FOR LOWER STEEL MAT ONLY		FOR BOTH STEEL MATS	
	TRANSVERSE STEEL		TIE BARS AT LONGITUDINAL CONSTRUCTION JOINT (SECTION Z-Z)		TIE BARS AT LONGITUDINAL CONSTRUCTION JOINT (SECTION Y-Y)	
	BAR SIZE	SPACING (IN.)	BAR SIZE	SPACING (IN.)	BAR SIZE	SPACING (IN.)
14 - 15	#5	48	#6	48	#6	24

TABLE NO. 3 TWO LAYER STEEL PLACEMENT HEIGHT OF STEEL MATS		
SLAB THICKNESS T (IN.)	LOWER STEEL MAT HEIGHT T1 (IN.)	TOP STEEL MAT HEIGHT T2 (IN.)
14	4.5	8.0
15	5.0	8.5

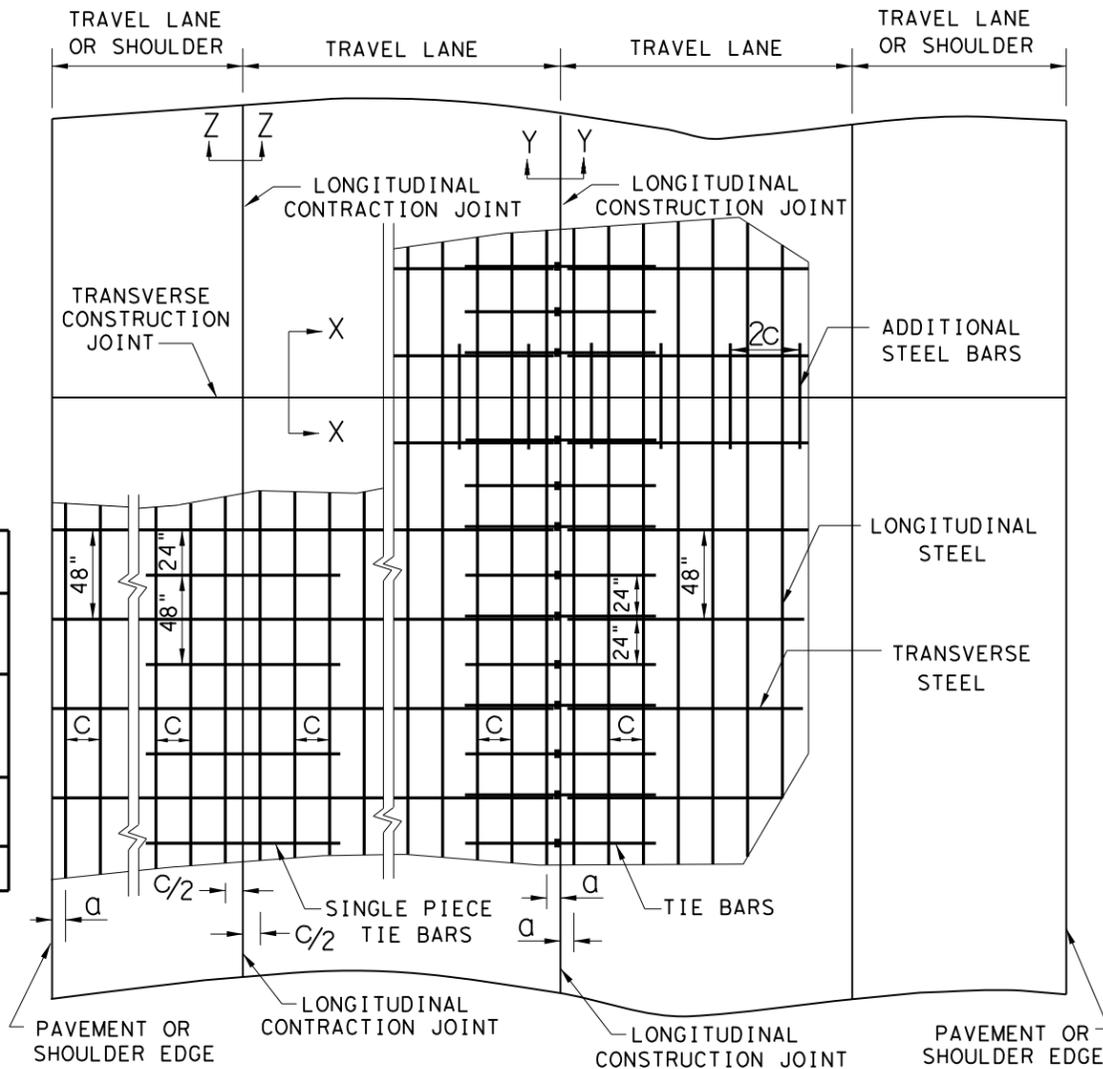


TYPICAL PAVEMENT LAYOUT


PLAN VIEW (NOT TO SCALE)

GENERAL NOTES


1. DETAILS FOR PAVEMENT WIDTH, PAVEMENT THICKNESS AND THE CROWN CROSS-SLOPE SHALL BE SHOWN ELSEWHERE IN THE PLANS. PAVEMENTS WIDER THAN 100 FT. WITHOUT A FREE LONGITUDINAL JOINT ARE NOT COVERED BY THIS STANDARD.
2. USE COARSE AGGREGATES WITH A RATED COEFFICIENT OF THERMAL EXPANSION (COTE) OF NOT MORE THAN 5.5×10^{-6} IN/IN/°F AS LISTED IN THE CONCRETE RATED SOURCE QUALITY CATALOG (CRSQC).
3. ALL THE REINFORCING STEEL AND TIE BARS SHALL BE DEFORMED STEEL BARS CONFORMING TO ASTM A 615 (GRADE 60) OR ASTM A 996 (GRADE 60) OR ABOVE. STEEL BAR SIZES AND SPACINGS SHALL CONFORM TO TABLE NO. 1, TABLE NO. 2 AND TABLE NO. 3.
4. STEEL BAR PLACEMENT TOLERANCE SHALL BE +/- 1 IN. HORIZONTALLY AND +/- 0.5 IN. VERTICALLY. CALCULATED AVERAGE BAR SPACING (CONCRETE PLACEMENT WIDTH / NUMBER OF LONGITUDINAL BARS) SHALL CONFORM TO TABLE NO. 1.
5. PAVEMENT WIDTHS OF MORE THAN 15 FT. SHALL HAVE A LONGITUDINAL JOINT (SECTION Z-Z OR SECTION Y-Y). THESE JOINTS SHALL BE LOCATED WITHIN 6 IN. OF THE LANE LINE UNLESS THE JOINT LOCATION IS SHOWN ELSEWHERE ON THE PLANS.
6. THE SAW CUT DEPTH FOR THE LONGITUDINAL CONTRACTION JOINT (SECTION Z-Z) SHALL BE ONE THIRD OF THE SLAB THICKNESS (T/3).
7. WHEN TYING CONCRETE GUTTER AT A LONGITUDINAL JOINT, THE TIE BAR LENGTH OR POSITION MAY BE ADJUSTED. PROVIDE 3 IN. OF CONCRETE COVER FROM THE BACK OF GUTTER TO THE END OF TIE BAR.
8. REPLACE MISSING OR DAMAGED TIE BARS WITHOUT ADDITIONAL COMPENSATION BY DRILLING MIN. 10 IN. DEEP AND GROUTING TIE BARS WITH TYPE III, CLASS C EPOXY. MEET THE PULL-OUT TEST REQUIREMENTS IN ITEM 361.
9. OMIT TIE BARS LOCATED WITHIN 18 IN. OF THE TRANSVERSE CONSTRUCTION JOINTS (SECTION X-X). USE HAND-OPERATED IMMERSION VIBRATORS TO CONSOLIDATE THE CONCRETE ADJACENT TO ALL FORMED JOINTS.
10. LONGITUDINAL REINFORCING STEEL SPLICES SHALL BE A MINIMUM OF 25 IN. STAGGER THE LAP LOCATIONS SO THAT NO MORE THAN 1/3 OF THE LONGITUDINAL STEEL IS SPLICED IN ANY GIVEN 12-FT. WIDTH AND 2-FT. LENGTH OF THE PAVEMENT.
11. THE DETAIL FOR THE JOINT SEALANT AND RESERVOIR IS SHOWN ON STANDARD SHEET "CONCRETE PAVING DETAILS, JOINT SEALS."

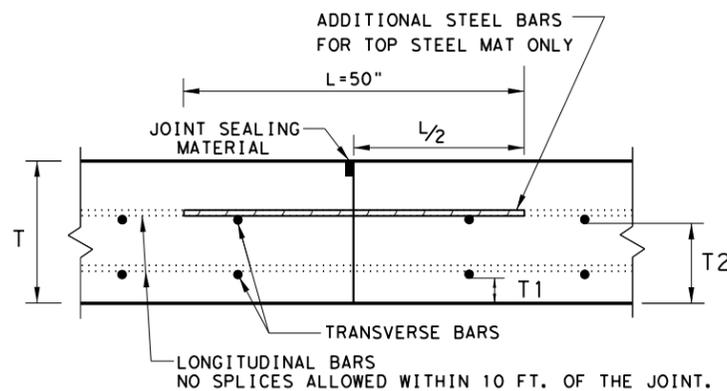

TRANSVERSE CONSTRUCTION JOINT
SECTION X - X

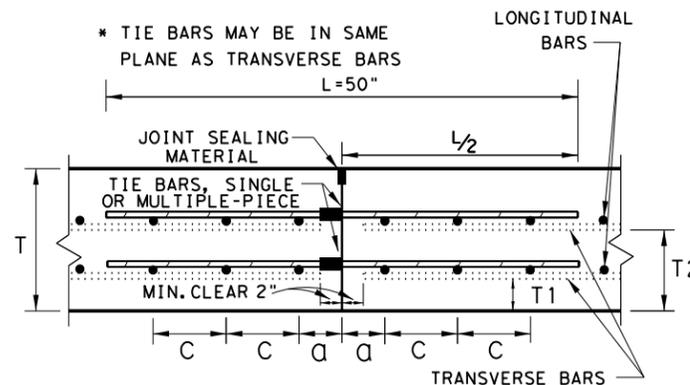

LONGITUDINAL CONSTRUCTION JOINT
SECTION Y - Y

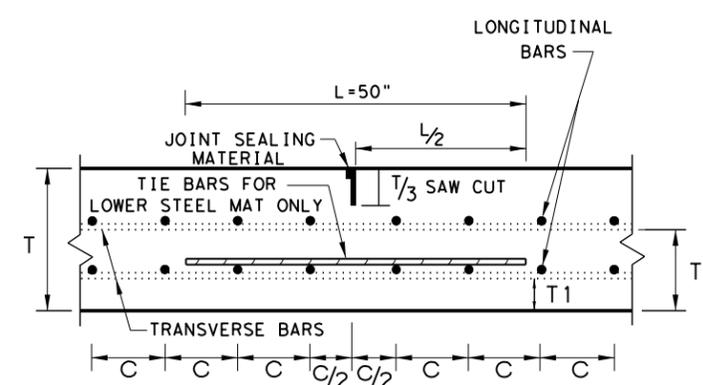

LONGITUDINAL CONTRACTION JOINT
SECTION Z - Z


SHEET 1 OF 2

		Design Division Standard	
CONTINUOUSLY REINFORCED CONCRETE PAVEMENT TWO LAYER STEEL BAR PLACEMENT T - 14 & 15 INCHES CRCP (2) - 20			
FILE: crcp220.dgn	DN: TxDOT	CK: KM	DW: AN
© TxDOT: APRIL 2020	CONT	SECT	JOB
10/10/2011 ADD CW #12	0111	01	095
04/09/2013 REMOVE 6" AND 6.5" ADD CTE REQUIREMENTS	DIST	COUNTY	HIGHWAY
04/19/2017 COTE AS RATED 4.3	HOU	HARRIS	FM 521
			SHEET NO.
			49


DATE: FILE:

DISCLAIMER: The use of this standard is governed by the "Texas Engineering Practice Act". No warranty of any kind is made by TxDOT for any purpose whatsoever. TxDOT assumes no responsibility for the conversion of this standard to other formats or for incorrect results or damages resulting from its use.


DATE:
FILE:

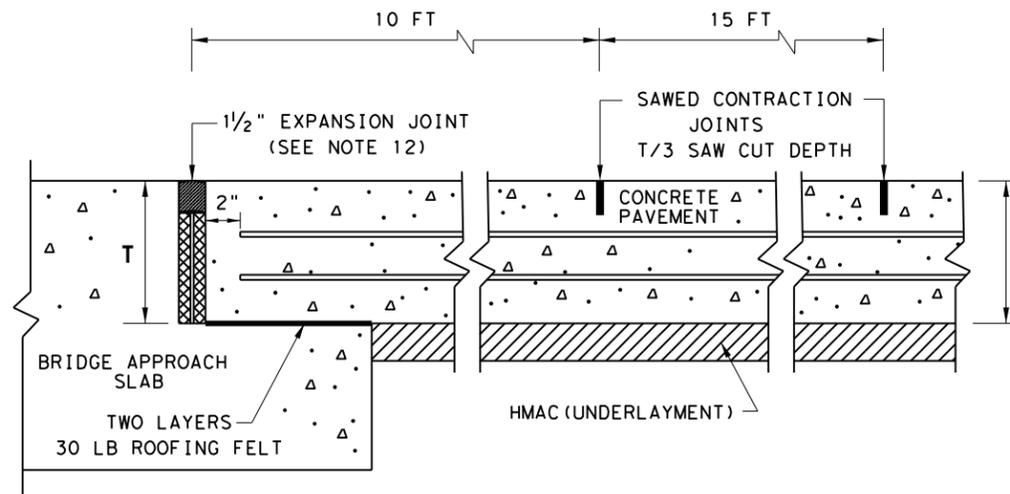

**TRANSVERSE EXPANSION JOINT DETAIL
AT BRIDGE APPROACH**

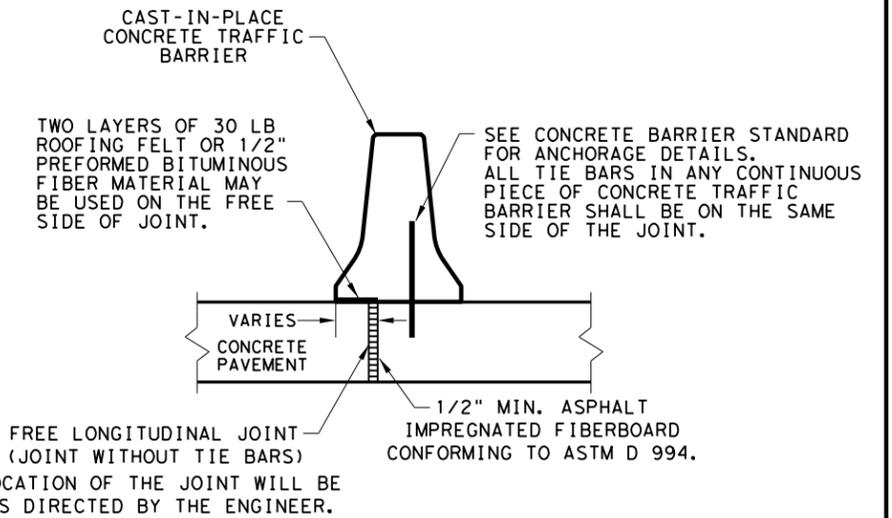


FREE LONGITUDINAL JOINT DETAIL

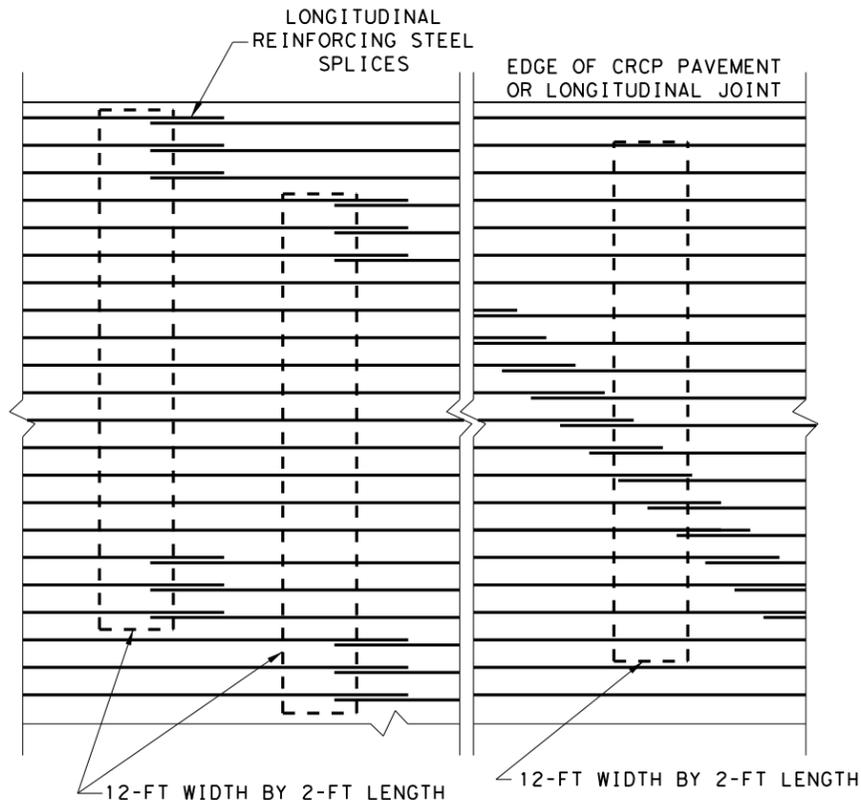


STAGGER THE LAP LOCATIONS SO THAT NO MORE THAN 1/3 OF THE LONGITUDINAL STEEL IS SPLICED IN ANY GIVEN 12-FT. WIDTH AND 2-FT. LENGTH OF THE PAVEMENT. ANY OTHER LAP CONFIGURATION MEETING THIS REQUIREMENT WILL BE ALLOWED.


**EXAMPLES OF LAP CONFIGURATION
PLAN VIEW (NOT TO SCALE)**

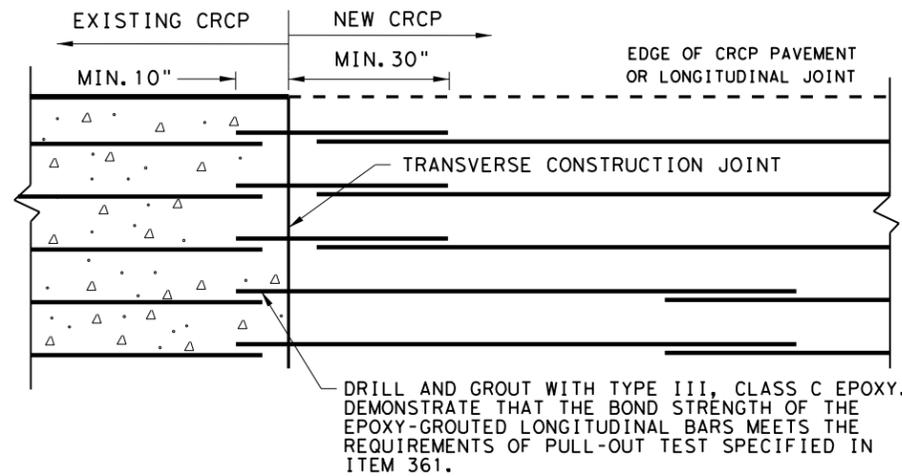

**OPTION A: DRILL AND EPOXY
PLAN VIEW (NOT TO SCALE)**

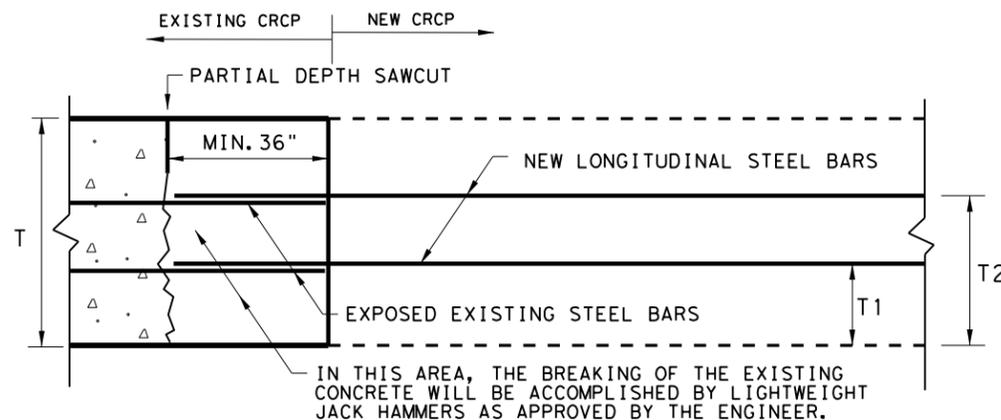

**OPTION B: BREAKBACK AND LAP
TRANSVERSE TIE JOINT DETAIL
EXISTING CRCP TO NEW CRCP**

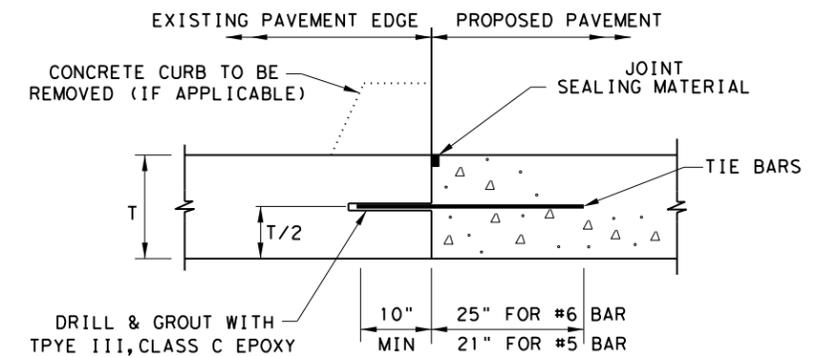

1. BEFORE WIDENING WORK, DEMONSTRATE THAT THE BOND STRENGTH OF THE EPOXY-GROUTED TIE BARS MEETS THE REQUIREMENTS OF PULL-OUT TEST SPECIFIED IN ITEM 361.
2. SPACE TIE BARS AT 24" SPACING. USE #6 TIE BARS FOR 8" AND THICKER SLABS, USE #5 TIE BARS FOR LESS THAN 8" THICK SLABS.

LONGITUDINAL WIDENING JOINT DETAIL

SHEET 2 OF 2



**CONTINUOUSLY REINFORCED
CONCRETE PAVEMENT
TWO LAYER STEEL BAR PLACEMENT
T - 14 & 15 INCHES
CRCP (2) - 20**


FILE: crcp220.dgn	DN: TxDOT	CK: KM	DW: AN	CK: VP
© TxDOT: APRIL 2020	CONT	SECT	JOB	HIGHWAY
REVISIONS	0111	01	095	FM 521
03/16/2020 REMOVED TABLE 1A	DIST	COUNTY	SHEET NO.	
	HOU	HARRIS	50	

DISCLAIMER: The use of this standard is governed by the "Texas Engineering Practice Act". No warranty of any kind is made by TxDOT for any purpose whatsoever. TxDOT assumes no responsibility for the conversion of this standard to other formats or for incorrect results or damages resulting from its use.

DATE: FILE:

TABLE NO.1 STEEL BAR SIZE AND SPACING						
TYPE PAVEMENT	SLAB THICKNESS AND BAR SIZE		LONGITUDINAL*		TRANSVERSE*	
			REGULAR BARS	TIEBARS	BARS	TIEBARS
	T (IN.)	BAR SIZE	SPACING (IN.)	SPACING (IN.)	SPACING (IN.)	SPACING (IN.)
CRCP	6.0	#5	7.5	7.5	24	24
	6.5		7.0	7.0		
	7.0		6.5	6.5		
	7.5		6.0	6.0		
	8.0	#6	9.0	9.0	24	24
	8.5		8.5	8.5		
	9.0		8.0	8.0		
	9.5		7.5	7.5		
	10.0		7.0	7.0		
	10.5		6.75	6.75		
	11.0		6.5	6.5		
11.5	6.25	6.25				
≥12.0	6.0	6.0				
JRCP	<8.0	#5	24.0	12.0	24	24
	≥8.0	#6	24.0	12.0	24	24
CPCD	<8.0	#5	NONE	12.0	NONE	24
	≥8.0	#6	NONE	12.0	NONE	24

* USE 12" SPACING AS FIRST AND LAST SPACING AT END OR SIDE FOR ALL BARS.

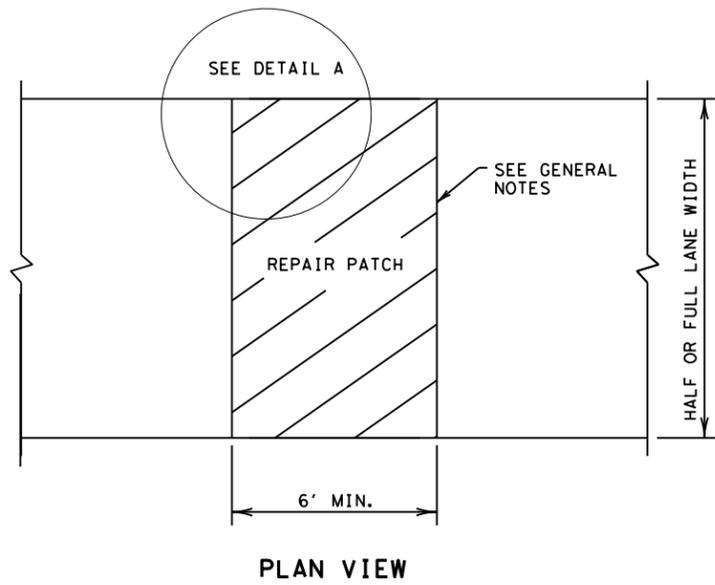


PLAN VIEW

FULL-DEPTH REPAIR OF CRCP, JRCP, AND CPCD

GENERAL NOTES


- ITEM 361, "REPAIR OF CONCRETE PAVEMENT" SHALL GOVERN FOR THIS WORK.
- MULTIPLE PIECE TIEBARS SHALL BE USED WHEN THE REPAIR AREA MUST BE PLACED IN TWO STAGES DUE TO SEQUENCE OF CONSTRUCTION.
- FULL DEPTH SAW CUTS SHALL BE MADE AROUND THE PERIMETER OF THE AREA TO BE REPAIRED. THE CUT SHALL BE MADE AT A RIGHT ANGLE TO THE PAVEMENT EDGE AND TO THE CENTER LINE OF THE PAVEMENT.
- AT LEAST ONE LONGITUDINAL FULL DEPTH SAW CUT SHALL BE AT AN EXISTING LONGITUDINAL JOINT.
- ADDITIONAL SAW CUTS MAY BE REQUIRED WITHIN THE AREA OF THE REPAIR TO FACILITATE REMOVAL OF THE CONCRETE OR TO ALLEVIATE BINDING OF THE FULL DEPTH SAW CUT AT THE REPAIR EDGE.
- THE SAW CUTS WHICH EXTEND OUTSIDE THE AREA OF THE REPAIR WILL BE CLEANED AND FILLED WITH A CEMENTITIOUS GROUT APPROVED BY THE ENGINEER.
- EXISTING LONGITUDINAL AND TRANSVERSE JOINTS REMOVED DUE TO REPAIR OPERATION SHOULD BE RESTORED IN ACCORDANCE WITH STANDARD SHEET "CONCRETE PAVING DETAILS, JOINT SEALS."

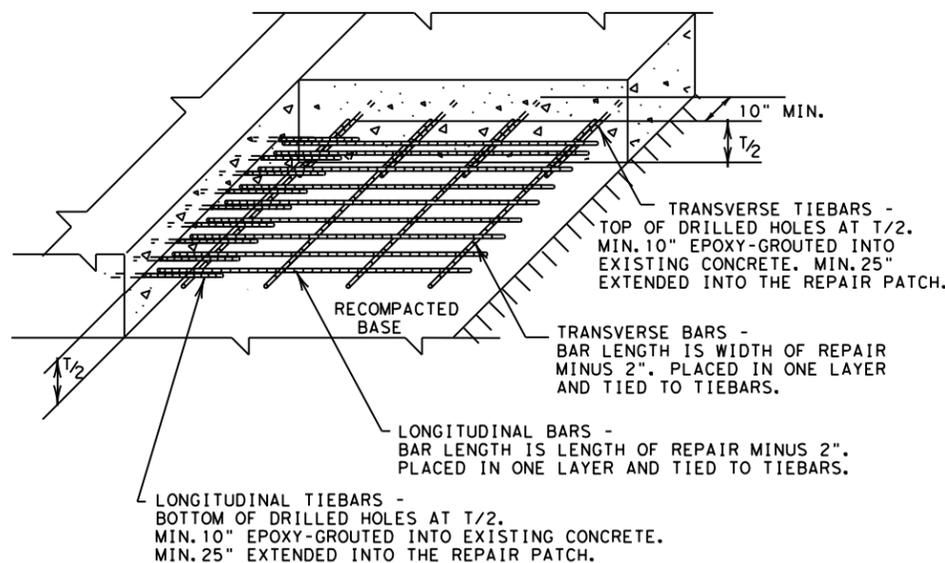


**DETAIL A
GROUTED TIEBARS & REINFORCEMENT**

GENERAL NOTES

- ITEM 361, "REPAIR OF CONCRETE PAVEMENT" SHALL GOVERN FOR THIS WORK.
- THE SAW CUTS WHICH EXTEND OUTSIDE THE AREA OF THE REPAIR WILL BE CLEANED AND FILLED WITH A CEMENTITIOUS GROUT APPROVED BY THE ENGINEER.
- EXISTING LONGITUDINAL AND TRANSVERSE JOINTS REMOVED DUE TO REPAIR OPERATION SHOULD BE RESTORED IN ACCORDANCE WITH STANDARD SHEET "CONCRETE PAVING DETAILS, JOINT SEALS."

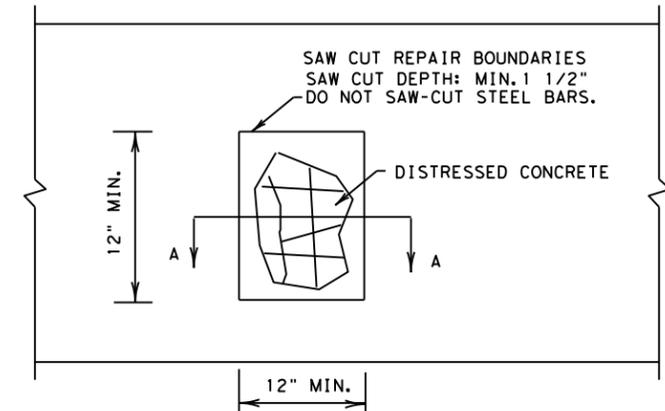

PLAN VIEW

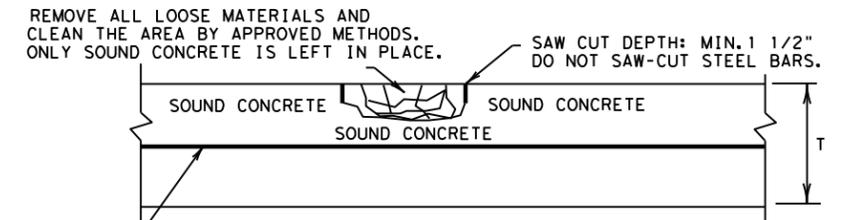

LONGITUDINAL STEEL BARS:

*REPAIR AREAS MAY BE ADJUSTED AFTER REMOVING DISTRESSED CONCRETE. SWITCH THE HALF-DEPTH REPAIR TO FULL-DEPTH REPAIR IF EXPOSED EXISTING LONGITUDINAL BARS ARE DEFICIENT, AS APPROVED. COMPENSATION WILL BE MADE FOR UNEXPECTED VOLUMES OF REPAIR AREAS OR CHANGES IN SCOPE OF WORK.

*INCREASE THE REPAIR AREA AND PERFORM A FULL-DEPTH REPAIR AS DIRECTED IF LONGITUDINAL STEEL BARS WERE DAMAGED BY THE REMOVAL OPERATIONS. NO ADDITIONAL COMPENSATION WILL BE MADE.



**SECTION A-A
HALF-DEPTH REPAIR**

SHEET 1 OF 2

		<i>Design Division Standard</i>	
REPAIR OF CONCRETE PAVEMENT			
REPCP-14			
FILE: repcp14.dgn	DN: TxDOT	DN: HC	CK: AN
© TxDOT: DECEMBER 2014	CONT: 0111	SECT: 01	JOB: 095
REVISIONS			HIGHWAY: FM 521
	DIST: HOU	COUNTY: HARRIS	SHEET NO.: 51

DISCLAIMER: The use of this standard is governed by the "Texas Engineering Practice Act". No warranty of any kind is made by TxDOT for any purpose whatsoever. TxDOT assumes no responsibility for the conversion of this standard to other formats or for incorrect results or damages resulting from its use.

DATE:
FILE:

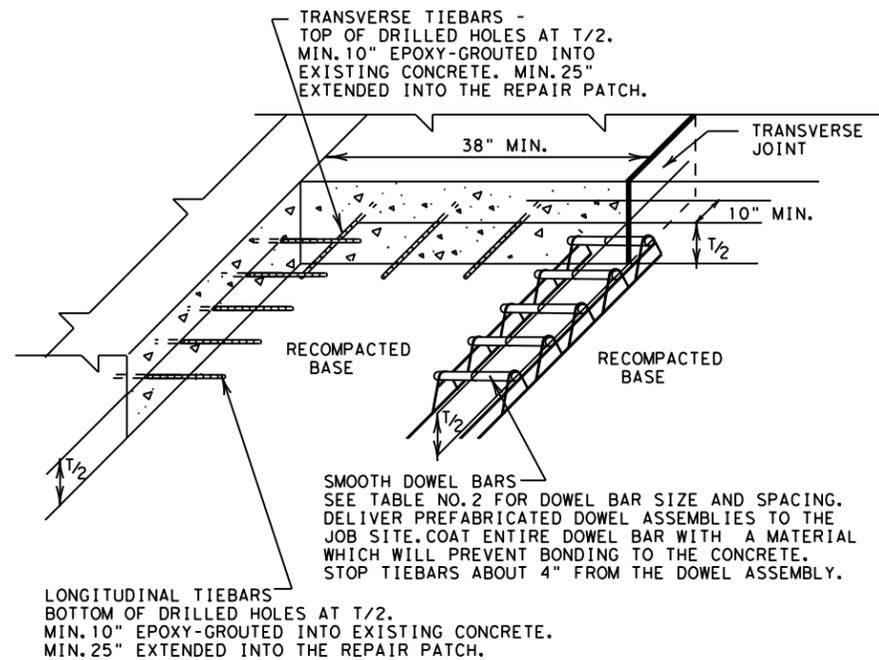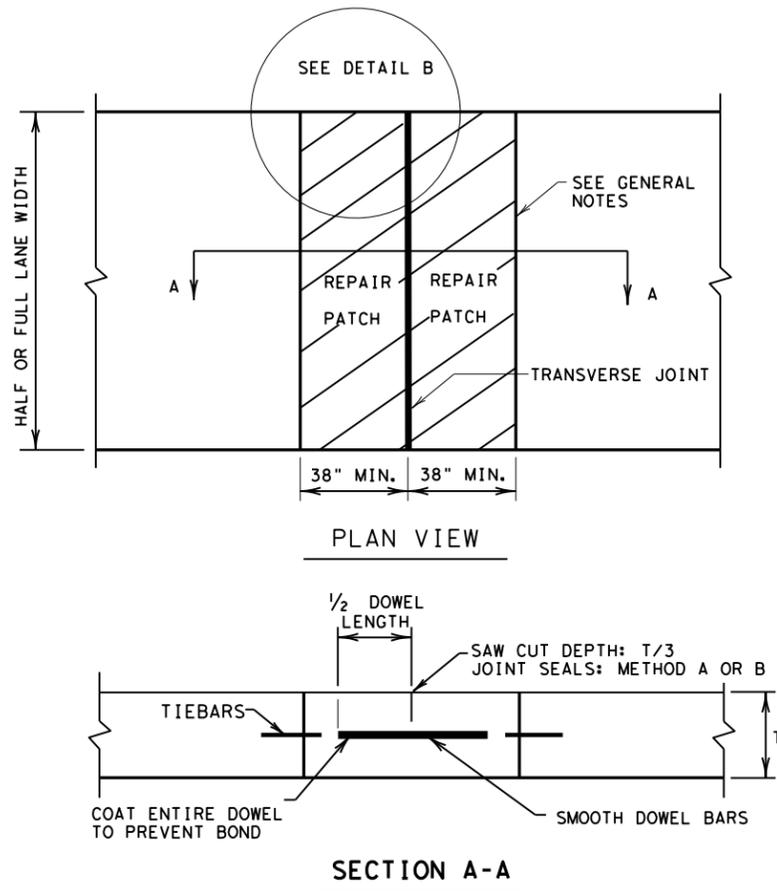



PAVEMENT THICKNESS (INCHES)	SIZE AND DIA.	LENGTH (IN.)	SPACING (IN.)
<10	#8 (1 IN.)	18.0	12.0
≥10	#10 (1 1/4 IN.)		

GENERAL NOTES

- ITEM 361, "REPAIR OF CONCRETE PAVEMENT" SHALL GOVERN FOR THIS WORK.
- MULTIPLE PIECE TIEBARS SHALL BE USED WHEN THE REPAIR AREA MUST BE PLACED IN TWO STAGES DUE TO SEQUENCE OF CONSTRUCTION.
- FULL DEPTH SAW CUTS SHALL BE MADE AROUND THE PERIMETER OF THE AREA TO BE REPAIRED. THE CUT SHALL BE MADE AT A RIGHT ANGLE TO THE PAVEMENT EDGE AND TO THE CENTER LINE OF THE PAVEMENT.
- AT LEAST ONE LONGITUDINAL FULL DEPTH SAW CUT SHALL BE AT AN EXISTING LONGITUDINAL JOINT.
- ADDITIONAL SAW CUTS MAY BE REQUIRED WITHIN THE AREA OF THE REPAIR TO FACILITATE REMOVAL OF THE CONCRETE OR TO ALLEVIATE BINDING OF THE FULL DEPTH SAW CUT AT THE REPAIR EDGE.
- THE SAW CUTS WHICH EXTEND OUTSIDE THE AREA OF THE REPAIR WILL BE CLEANED AND FILLED WITH A CEMENTITIOUS GROUT APPROVED BY THE ENGINEER.
- EXISTING LONGITUDINAL AND TRANSVERSE JOINTS REMOVED DUE TO REPAIR OPERATION SHOULD BE RESTORED IN ACCORDANCE WITH STANDARD SHEET "CONCRETE PAVING DETAILS, JOINT SEALS."
- DOWEL BAR PLACEMENT TOLERANCE SHALL BE +/- 1/4 IN. HORIZONTALLY AND VERTICALLY UNLESS OTHERWISE SPECIFIED. WHERE DOWEL BAR BASKETS ARE USED, REMOVE THE SHIPPING WIRES.

SHEET 2 OF 2

		<i>Design Division Standard</i>	
<p>REPAIR OF CONCRETE PAVEMENT</p> <p>REPCP-14</p>			
FILE: repcp14.dgn	DN: TxDOT	DN: HC	CK: AN
© TxDOT: DECEMBER 2014	CONT	SECT	HIGHWAY
REVISIONS	0111	01	095 FM 521
	DIST	COUNTY	SHEET NO.
	HOU	HARRIS	52



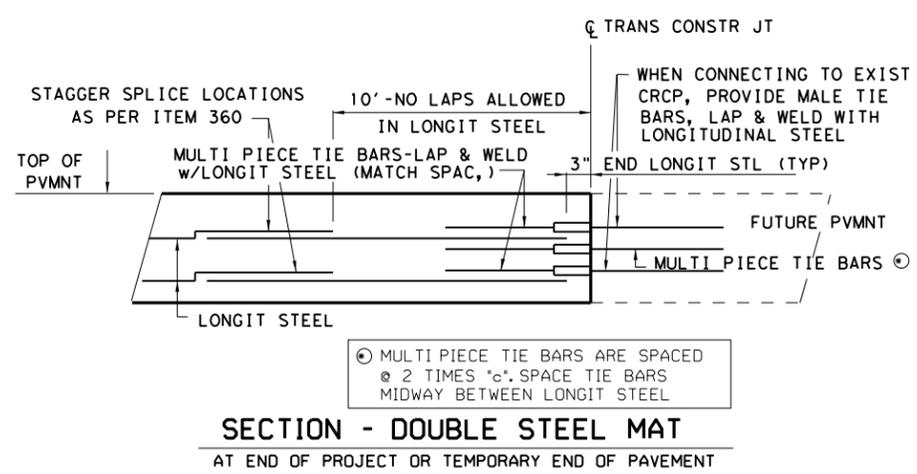
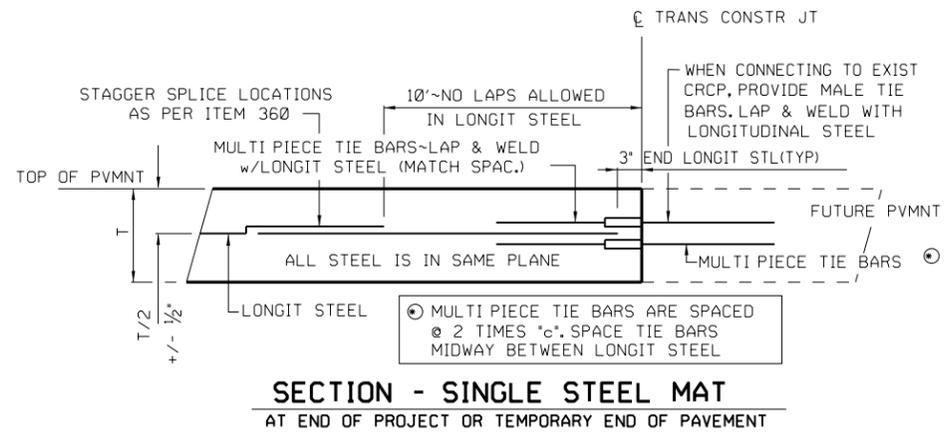


LONGITUDINAL DOWEL JOINT DETAILS

LOCATE WHERE SHOWN IN THE PLANS OR AS APPROVED. CONTRACTOR MAY USE EITHER METHOD

SINGLE STEEL MAT

DOUBLE STEEL MAT

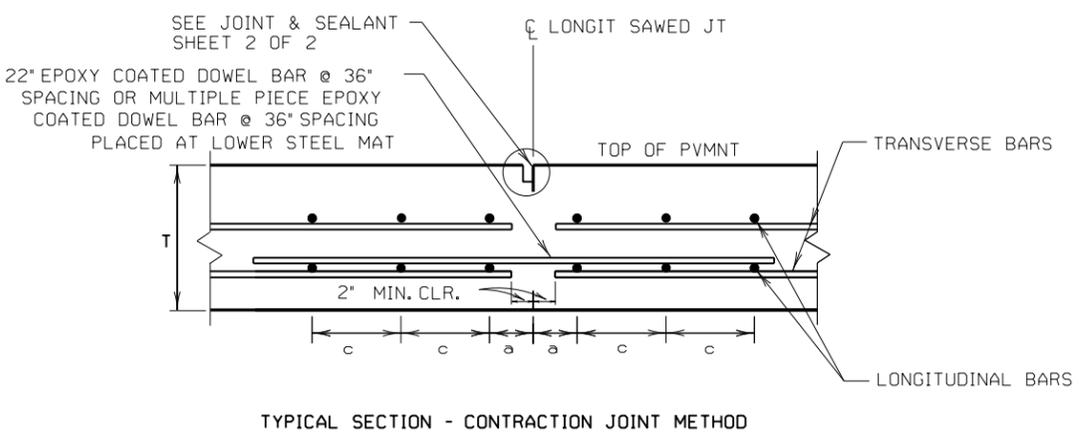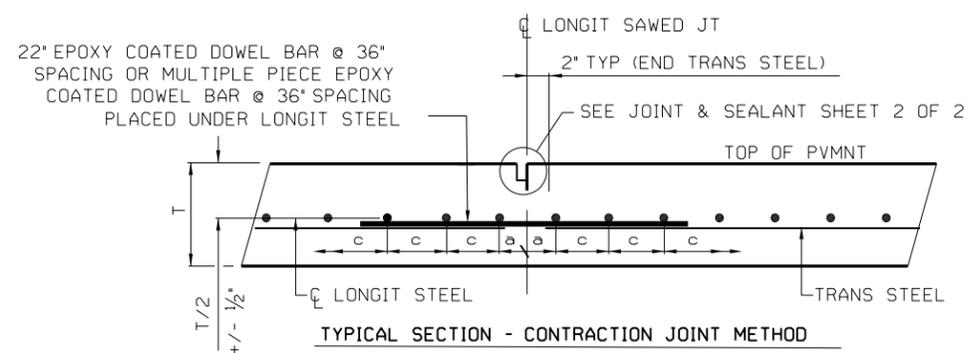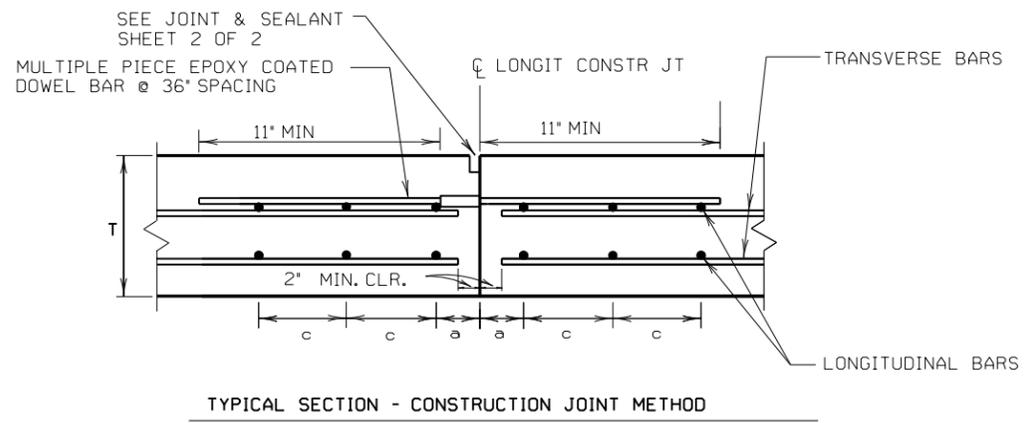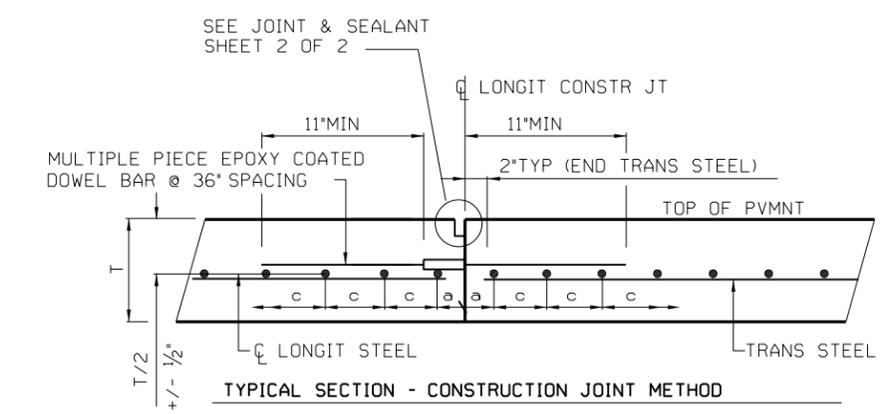




GENERAL NOTES

1. DETAILS FOR 7.0 IN. TO 13.0 IN. THICK CONCRETE PAVEMENT ARE SHOWN ON STANDARD CRCP(1)-20. DETAILS FOR 14 IN. TO 15 IN. THICK CONCRETE PAVEMENT ARE SHOWN ON STANDARD CRCP(2)-20.
2. DOWELS AND TIE BARS - DOWELS ARE ONE INCH MINIMUM DIAMETER. ENSURE DOWELS ARE FREE OF GREASE AND ARE EPOXY COATED. DO NOT SHEAR CUT DOWELS DURING FABRICATION. PROVIDE TIE BARS PER ITEM 360. FURNISH MULTI PIECE TIE BARS AND DOWELS WITH STOP COUPLINGS AND WITH THREADS ON THE BARS.
3. USE CHAIRS OF SUFFICIENT STRUCTURAL QUALITY AND NUMBER TO SUPPORT THE MAT TO THE VERTICAL TOLERANCES. CHAIRS WILL BE APPROVED BY THE ENGINEER AND DO NOT REQUIRE GALVANIZING.
4. MECHANICALLY PLACING REINFORCING STEEL IS NOT ALLOWED. NO BARS, DOWELS OR TIE BARS MAY BE VIBRATED INTO POSITION.
5. WHERE DIFFERENT THICKNESS PAVEMENTS MEET, TRANSITION THE THINNER SECTION TO THE THICKER SECTION OVER A DISTANCE OF 20 FT. PLACE REINFORCING STEEL WITHIN THE TRANSITION THE SAME AS IN THE THICKER PAVEMENT.
6. PERFORM WELDING PER ITEM 448. FURNISH WELDABLE REBAR PER ITEM 440.



Texas Department of Transportation
Houston District

**CONTINUOUSLY REINFORCED
CONCRETE PAVEMENT
HOUSTON SUPPLEMENT
CRCP-HS**

© TxDOT APR. 2012	Dist -	Ck -	Dist -	Ck -	PROJECT NO.	SHEET
REVISIONS 4/12 CHANGED CTE FROM 6.0 TO 5.0 8/14 UPDATE TO REFERENCE CRCP-13 STD. 2/15 REVISED GENERAL NOTES, MINOR CORRECTIONS. 4/17 REVISED NOTE #3 OF GENERAL NOTES, MINOR CORRECTIONS. 8/20 REVISED NOTE #1 OF GENERAL NOTES, MINOR CORRECTIONS.	DISTRICT HOU		COUNTY HARRIS		CONTROL SECTION JOB 0111 01 095	HIGHWAY FM 521

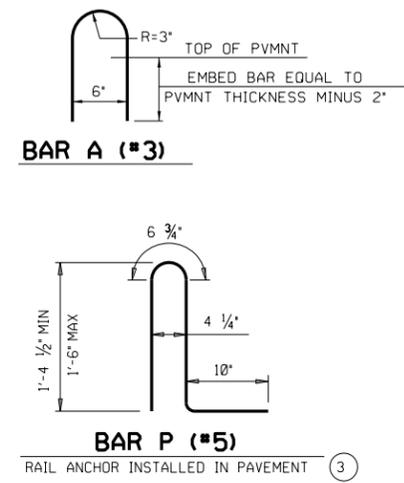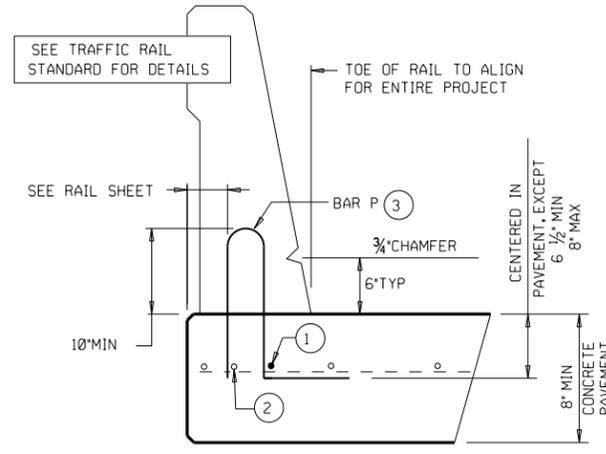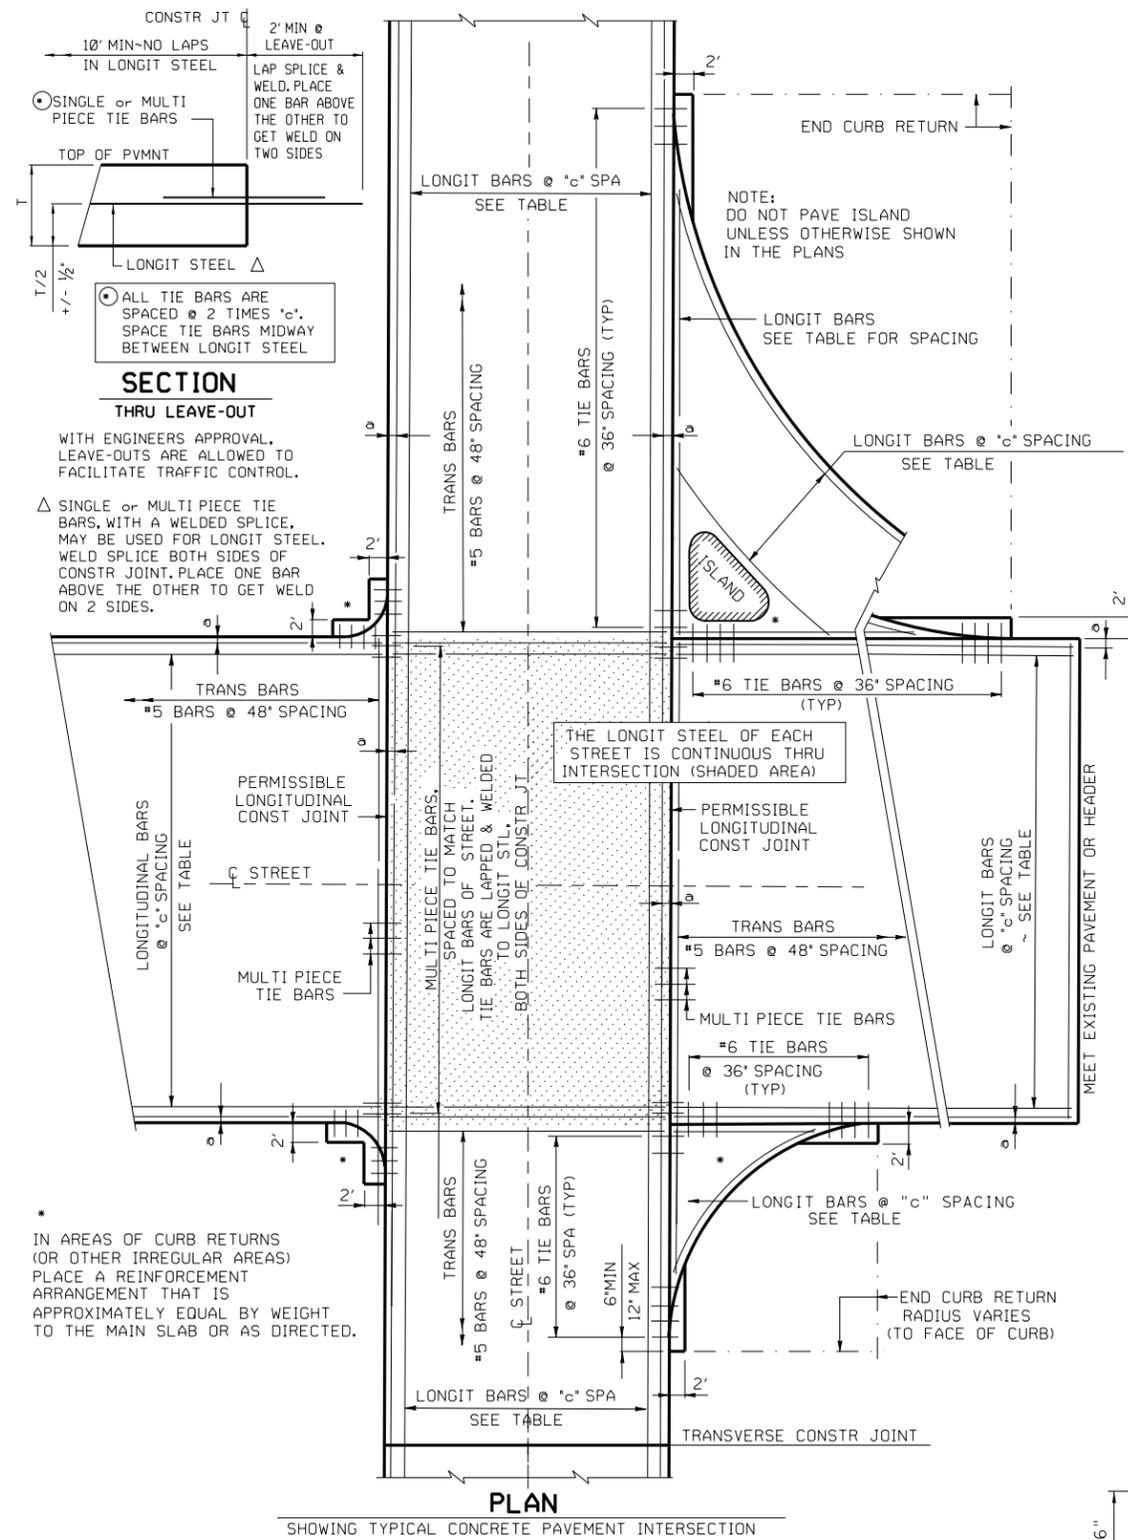

- AS AN AID IN SUPPORTING REINFORCEMENT, ADDITIONAL LONGITUDINAL BARS MAY BE USED IN THE SLAB WITH THE APPROVAL OF THE ENGINEER. FURNISH SUCH BARS AT NO EXPENSE TO THE DEPARTMENT.
- LONGITUDINAL SLAB BAR MAY BE ADJUSTED LATERALLY 3" +/- TO TIE REINFORCING.
- ANCHORAGE BAR SHOWN IS FOR AN SSTR OR T551 RAIL. SEE RAILING DETAIL SHEET FOR SPACING OF BAR P. FOR OTHER RAIL TYPES SEE RAILING DETAIL SHEET.

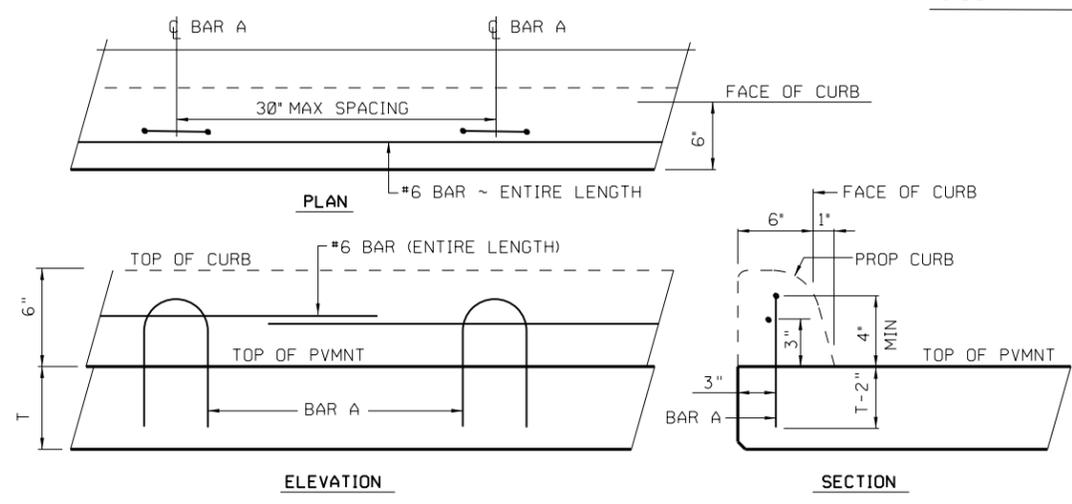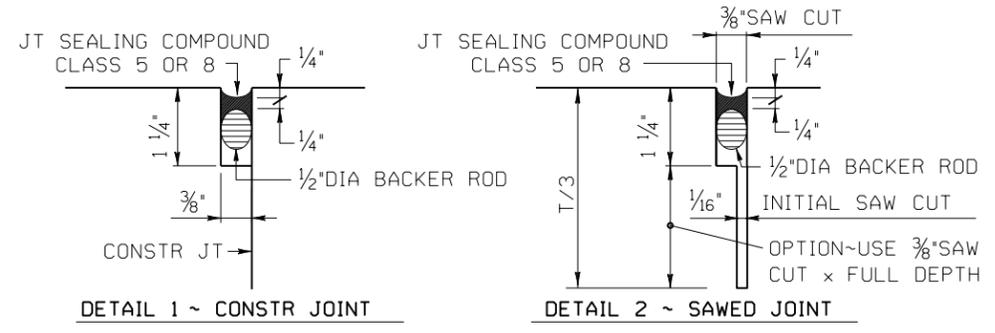

CURB DETAIL
SEE CC & DID STANDARD

JOINT AND SEALANT DETAILS


Texas Department of Transportation
Houston District

CONTINUOUSLY REINFORCED CONCRETE PAVEMENT HOUSTON SUPPLEMENT CRCP-HS


© TxDOT APR. 2012	DN-	CR-	DR-	CK-
REVISIONS 4/12 CHANGED CTE FROM 6.0 TO 5.0 (ON SHEET 1) 2/15 MINOR CORRECTIONS.	DISTRICT		PROJECT NO.	
	HOU		54	
	COUNTY	CONTROL	SECTION	JOB
	HARRIS	0111	01	095 FM 521

DISCLAIMER: The use of this standard is governed by the "Texas Engineering Practice Act". No warranty of any kind is made by TxDOT for any purpose whatsoever. TxDOT assumes no responsibility for the conversion of this standard to other formats or for incorrect results or damages resulting from its use.


METHOD B: JOINT SEALING COMPOUND

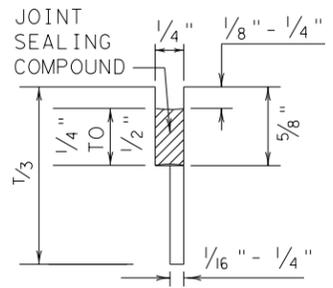


LONGITUDINAL SAWED CONTRACTION JOINT

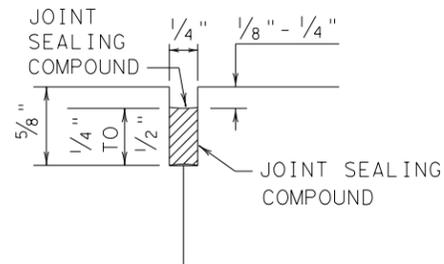


LONGITUDINAL OR TRANSVERSE CONSTRUCTION JOINT

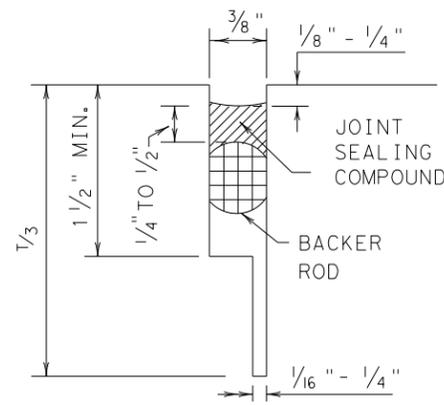

TRANSVERSE SAWED CONTRACTION JOINT

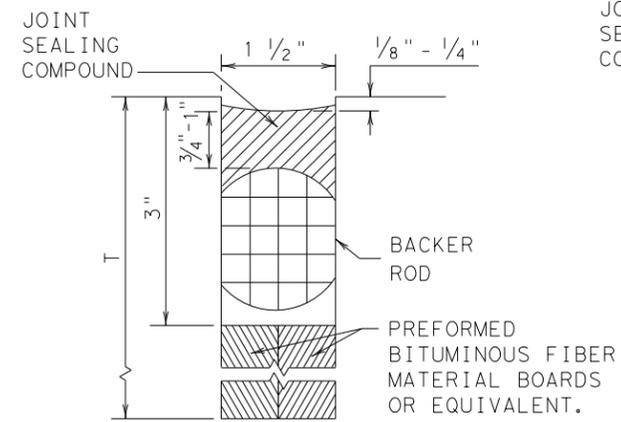


TRANSVERSE FORMED EXPANSION JOINT

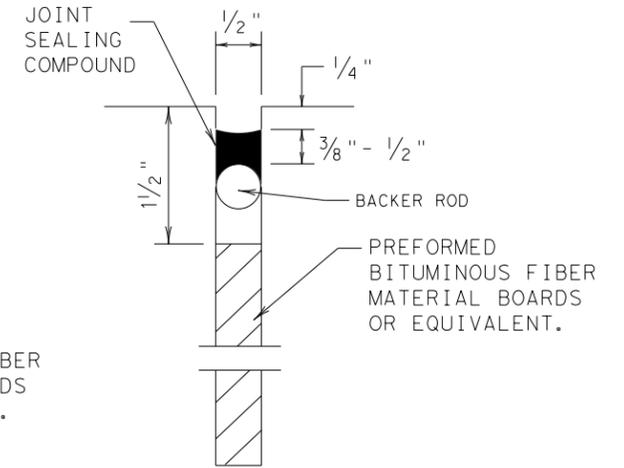


FORMED ISOLATION JOINT


METHOD A: PREFORMED COMPRESSION SEALS (PCS) (DMS-6310 CLASS 6)

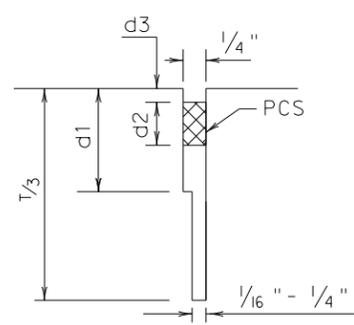


LONGITUDINAL SAWED CONTRACTION JOINT

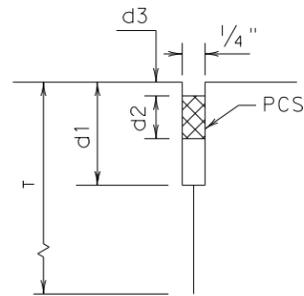

LONGITUDINAL CONSTRUCTION JOINT

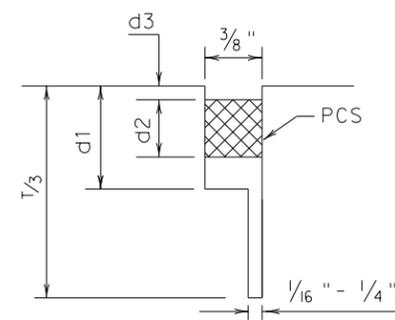

TRANSVERSE SAWED CONTRACTION JOINT

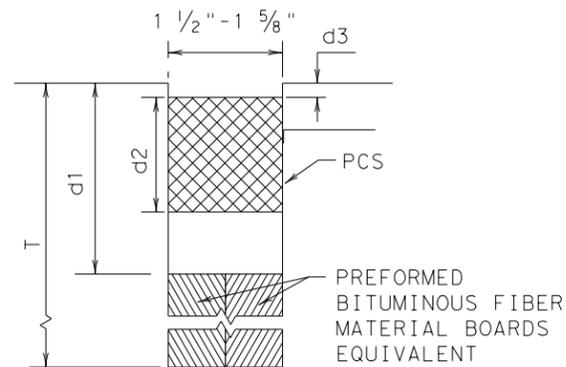

TRANSVERSE FORMED EXPANSION JOINT

GENERAL NOTES


- UNLESS OTHERWISE SHOWN IN THE PLANS, EITHER METHOD "A" OR METHOD "B" MAY BE USED.
- THE LOCATION OF JOINTS SHALL BE AS SHOWN ELSEWHERE IN THE PLANS.
- THE JOINT RESERVOIR FOR SEALANT OR PCS SHALL BE SAWED UNLESS OTHERWISE SHOWN ON THE PLANS FOR THE LONGITUDINAL AND TRANSVERSE CONSTRUCTION JOINTS AND THE SAWED JOINTS.
- DIMENSIONS d1, d2, AND d3 SHOWN IN METHOD A SHALL BE IN ACCORDANCE WITH THE PREFORMED COMPRESSION SEAL MANUFACTURER'S RECOMMENDATION.
- REFER TO DMS-6310 "JOINT SEALANTS AND FILLERS" FOR THE CLASSIFICATIONS.
- FOR SAWED LONGITUDINAL JOINT, LONGITUDINAL OR TRANSVERSE CONSTRUCTION JOINT, USE JOINT SEALANT CLASS 5 OR 8 UNLESS OTHERWISE SHOWN ON THE PLAN OR APPROVED.
- FOR TRANSVERSE SAWED CONTRACTION, TRANSVERSE FORMED EXPANSION JOINT, AND ISOLATION JOINT USE JOINT SEALANT CLASS 5 OR 8 AT NEW JOINTS. USE JOINT SEALANT CLASS 4, 5, 7, OR 8 FOR MAINTAINING EXISTING JOINTS.
- THE JOINTS SHALL BE CLEANED IN ACCORDANCE WITH THE ITEM 438 "CLEANING AND SEALING JOINTS" OR ITEM 713 "CLEANING AND SEALING JOINTS AND CRACKS (CONCRETE PAVEMENT)".
- ISOLATION JOINTS ACCOMMODATE HORIZONTAL AND VERTICAL MOVEMENTS THAT OCCUR BETWEEN A PAVEMENT AND A STRUCTURE. ISOLATION JOINTS MAY BE USED FOR BRIDGE ABUTMENTS, INTERSECTIONS, CURB AND GUTTER, OLD AND NEW PAVEMENTS, OR AROUND DRAINAGE INLETS, MANHOLES, FOOTINGS AND LIGHTING STRUCTURES.

DATE:
FILE:


				Design Division Standard	
CONCRETE PAVING DETAILS JOINT SEALS JS-14					
FILE: js14.dgn	DN: TxDOT	DN: HC	DW: HC	CK: AN	
© TxDOT: DECEMBER 2014	CONT	SECT	JOB	HIGHWAY	
REVISIONS	0111	01	095	FM 521	
	DIST	COUNTY		SHEET NO.	
	HOU	HARRIS		55	

DISCLAIMER: The use of this standard is governed by the "Texas Engineering Practice Act". No warranty of any kind is made by TxDOT for any purpose whatsoever. TxDOT assumes no responsibility for the conversion of this standard to other formats or for incorrect results or damages resulting from its use.


DATE:
FILE:

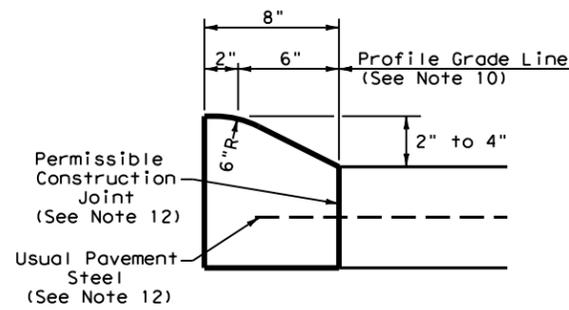


TYPE I CURB (MONOLITHIC)
2" - 4" HEIGHT

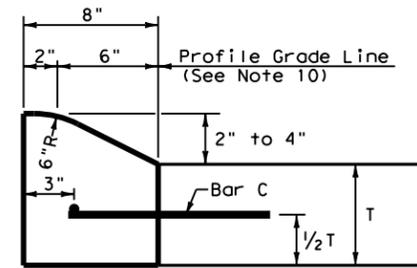


TYPE I CURB
2" - 4" HEIGHT

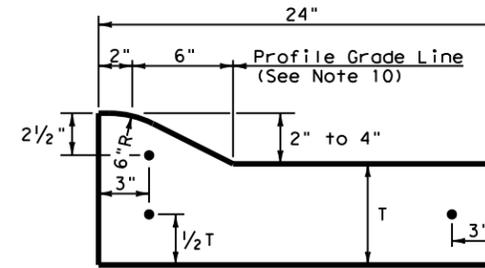


TYPE I CURB AND GUTTER
2" - 4" HEIGHT

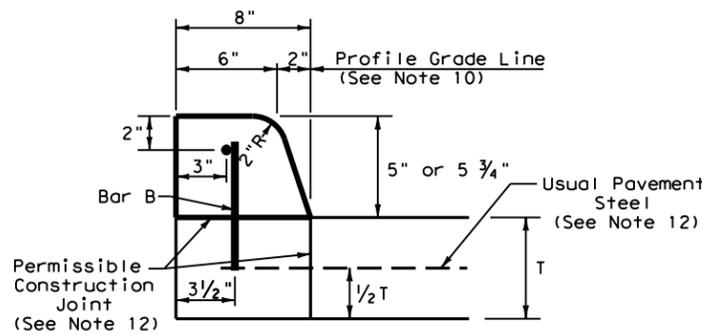


TYPE II CURB (MONOLITHIC)
5" - 5 3/4" HEIGHT

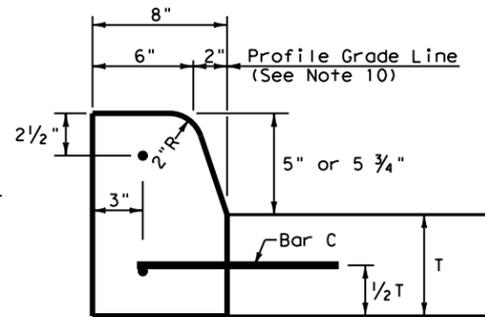


TYPE II CURB
5" - 5 3/4" HEIGHT

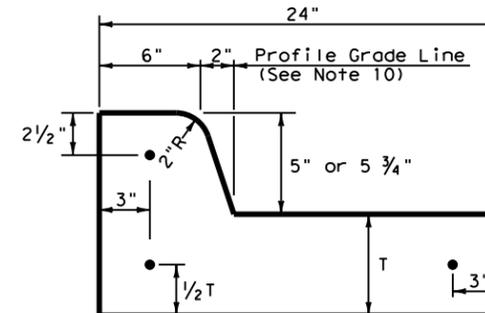


TYPE II CURB AND GUTTER
5" - 5 3/4" HEIGHT

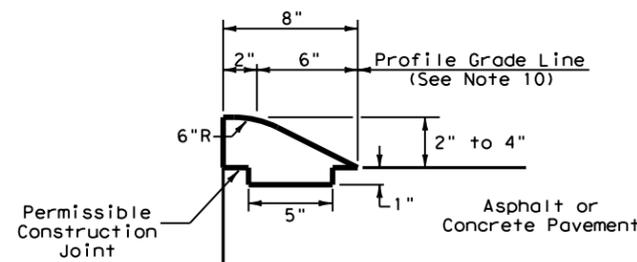


TYPE III CURB (KEYED)
2" - 4" HEIGHT

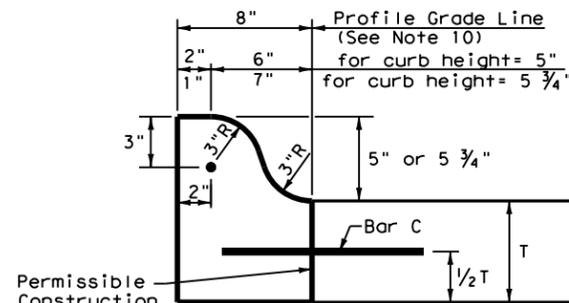


TYPE IIa CURB
5" - 5 3/4" HEIGHT

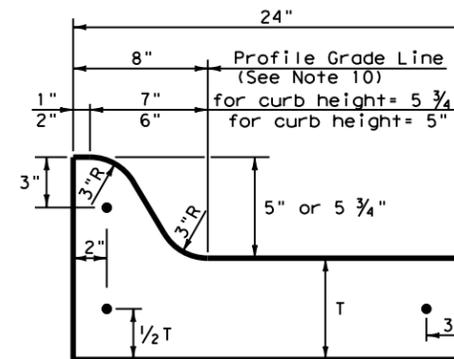


TYPE IIa CURB AND GUTTER
5" - 5 3/4" HEIGHT

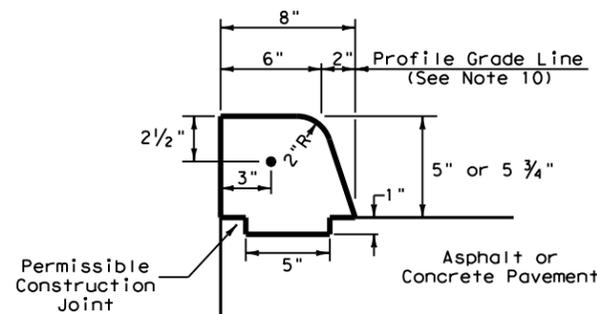

TYPE IV CURB (KEYED)
5" - 5 3/4" HEIGHT

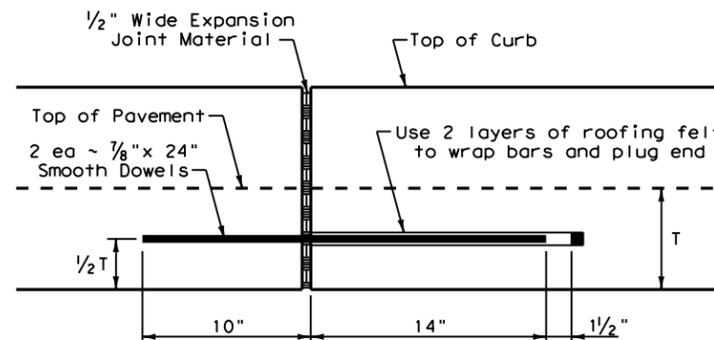

EXPANSION JOINT DETAIL

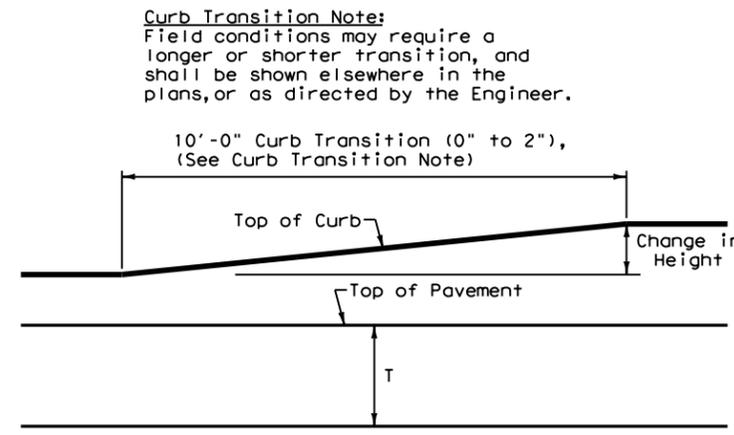


CURB TRANSITION

Note: To be paid for as Highest Curb



General Notes

- All materials and construction shall be in accordance with Item 529, "Concrete Curb, Gutter, and Combined Curb and Gutter."
- Concrete shall be Class A.
- When reinforcing bars are used, they shall be No.4 unless otherwise shown. The use of synthetic fiber in lieu of steel reinforcing is acceptable, provided the fiber producer is on the Department Producer List (MPL), maintained by TxDOT, Construction Division.
- Round exposed sharp edges with a rounding tool, to a minimum radius of 1/4 inch.
- All existing curbs and driveways to be removed shall be sawed or removed at existing joints.
- Where concrete curb is placed on existing concrete pavement, the pavement shall be drilled and the reinforcing bars grouted in place.
- Expansion and contraction joints shall be constructed to match pavement joints in all curbs and curb and gutter adjacent to jointed concrete pavement. Where placement of curb or curb and gutter is not adjacent to concrete pavement, expansion joints shall be provided at structures, curb returns at streets, and at locations directed by The Engineer.
- Vertical and horizontal dowel bars and transverse reinforcing bars shall be placed at four feet C-C.
- Dimension 'T' shown is the thickness of concrete pavement. When curb is installed adjacent to flexible pavement dimension 'T' is 8" maximum.
- Usual profile grade line. Refer to typical sections and plan-profile sheets for exact locations.
- One-half inch expansion joint material shall be provided where curb or curb and gutter is adjacent to sidewalk or riprap.
- When vertical permissible construction joints are used, resulting in a longitudinal construction joint in the pavement, the longitudinal pavement steel shall be placed in accordance with pavement details shown elsewhere in the plans for longitudinal construction joints. Reinforcing steel for curb section shall then conform to that required for concrete curb.

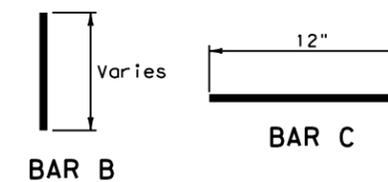

Curb Transition Note:
Field conditions may require a longer or shorter transition, and shall be shown elsewhere in the plans, or as directed by the Engineer.


				Design Division Standard	
CONCRETE CURB AND GUTTER CCCG-12					
FILE: ccog12.dgn	DN: TxDOT	CK: AM	DW: VP	CK: VP	
© TxDOT: 1995	CONT	SECT	JOB	HIGHWAY	
REVISIONS	0111	01	095	FM 521	
UPDATED 2012 - VP	DIST	COUNTY		SHEET NO.	
	HOU	HARRIS		56	

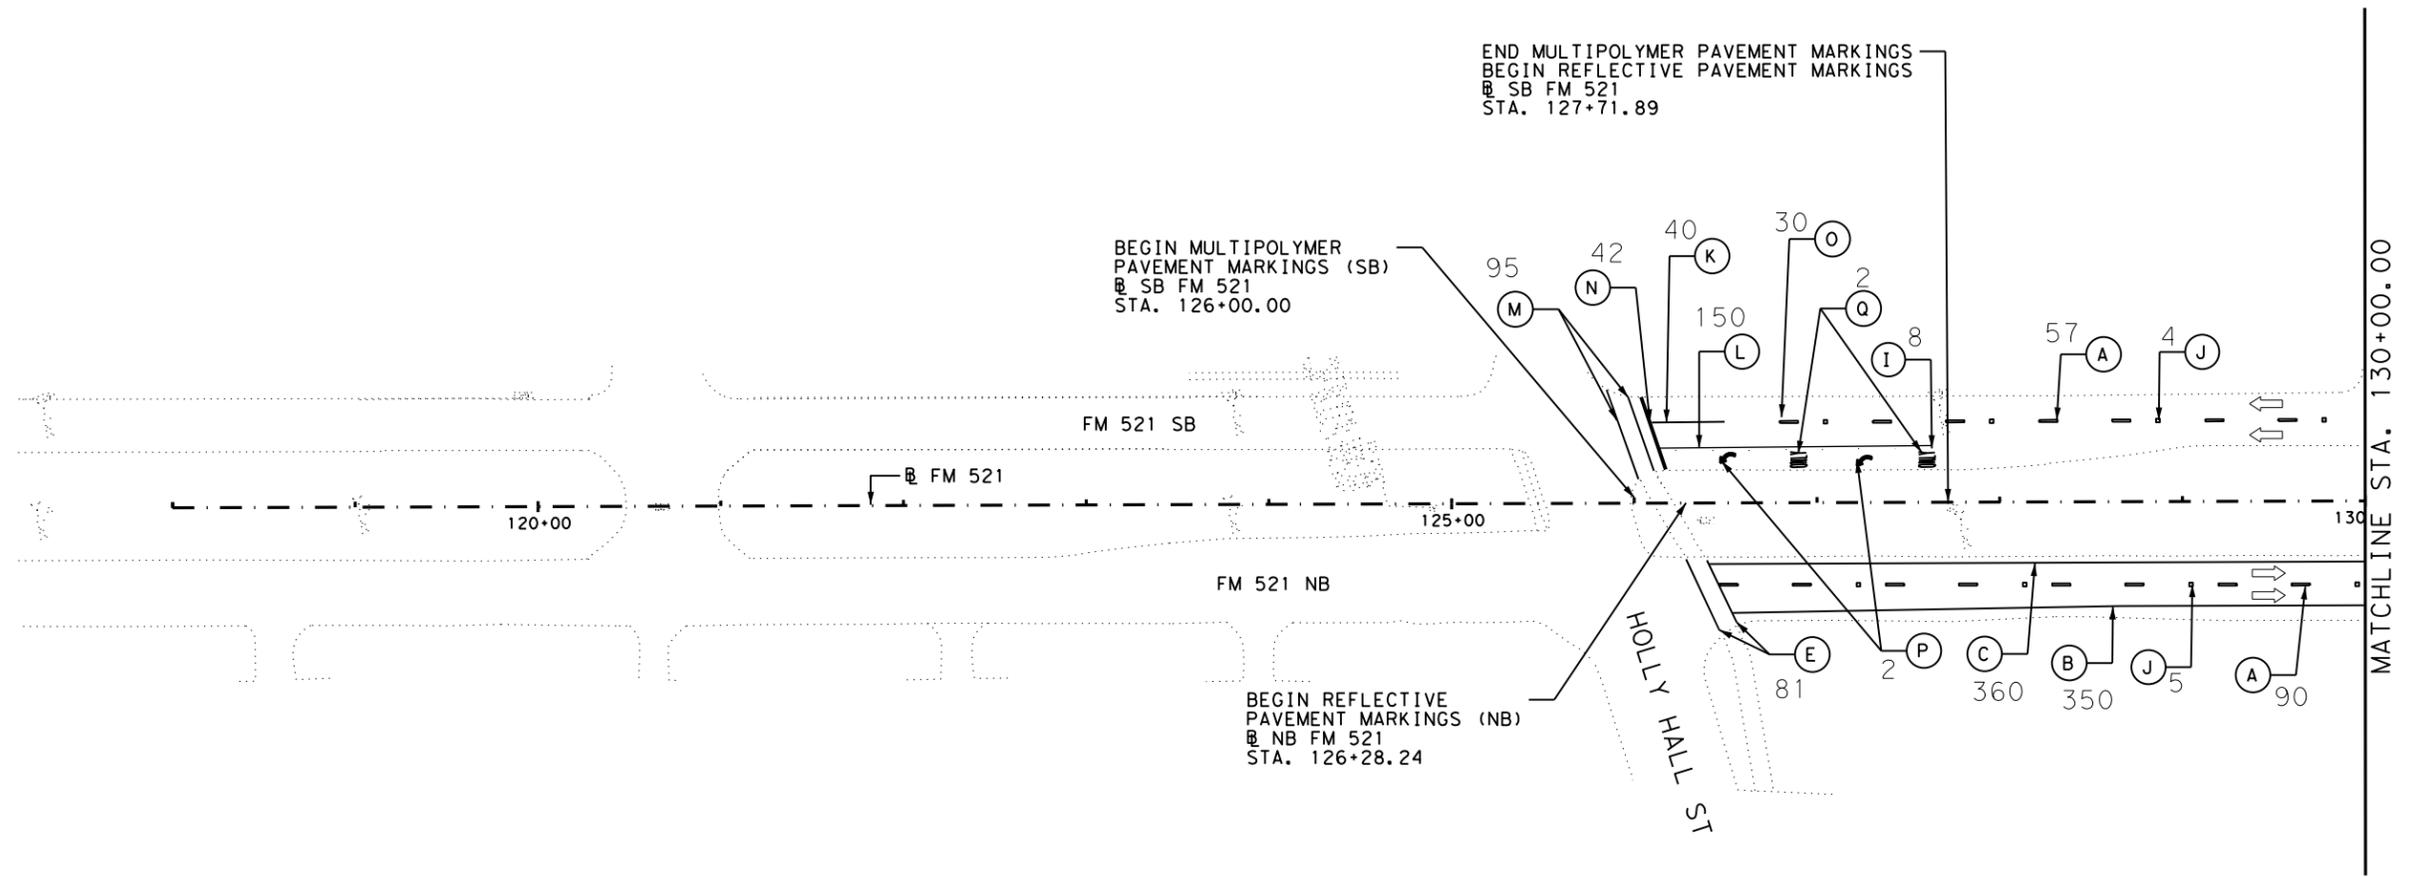 

9/22/2020 1:57:29 PM
 T:\HUM-AO\Des\ign\Roadway\FM 521\0111-01-095.DGN\PAVEMENT MARKINGS\057 PAVEMENT MARKING LAYOUT.dgn

LEGEND

- | | |
|---|--|
| (A) RE PM W/REQ TY I (W) 6" (BRK) (100 MIL) | (I) REFL PAV MRKR TY I-C |
| (B) RE PM W/REQ TY I (W) 6" (SLD) (100 MIL) | (J) REFL PAV MRKR TY II-C-R |
| (C) RE PM W/REQ TY I (Y) 6" (SLD) (100 MIL) | (K) MULTIPOLYMER PAV MRK (W) (6") (SLD) |
| (D) REFL PAV MRK TY I (W) 8" (SLD) (100 MIL) | (L) MULTIPOLYMER PAV MRK (W) (8") (SLD) |
| (E) REFL PAV MRK TY I (W) 12" (SLD) (100 MIL) | (M) MULTIPOLYMER PAV MRK (W) (12") (SLD) |
| (F) REFL PAV MRK TY I (W) 24" (SLD) (100 MIL) | (N) MULTIPOLYMER PAV MRK (W) (24") (SLD) |
| (G) REFL PAV MRK TY I (W) (ARROW) (100 MIL) | (O) MULTIPOLYMER PAV MRK (W) (6") (BRK) |
| (H) REFL PAV MRK TY I (W) (WORD) (100 MIL) | (P) PREFAB PAV MRK TY C (W) (ARROW) |
| | (Q) PREFAB PAV MRK TY C (W) (WORD) |

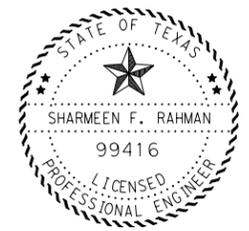



Sharmeen Rahman, P.E.
 10/07/2020



FM 521
 PAVEMENT MARKING
 LAYOUT


SCALE: 1" = 100'		SHEET 1 OF 5	
FED. RD. DIV. NO. 6	PROJECT NO. 095		SHEET NO. 57
STATE TEXAS	DIST HOU	COUNTY HARRIS	
CONT 0111	SECT 01	JOB 095	HIGHWAY FM 521

 9/22/2020 2:04:01 PM T:\HUM-AO\Des\ign\Roadway\FM 521\0111-01-095.DGN\PAVEMENT MARKINGS\058 PAVEMENT MARKING LAYOUT.dgn

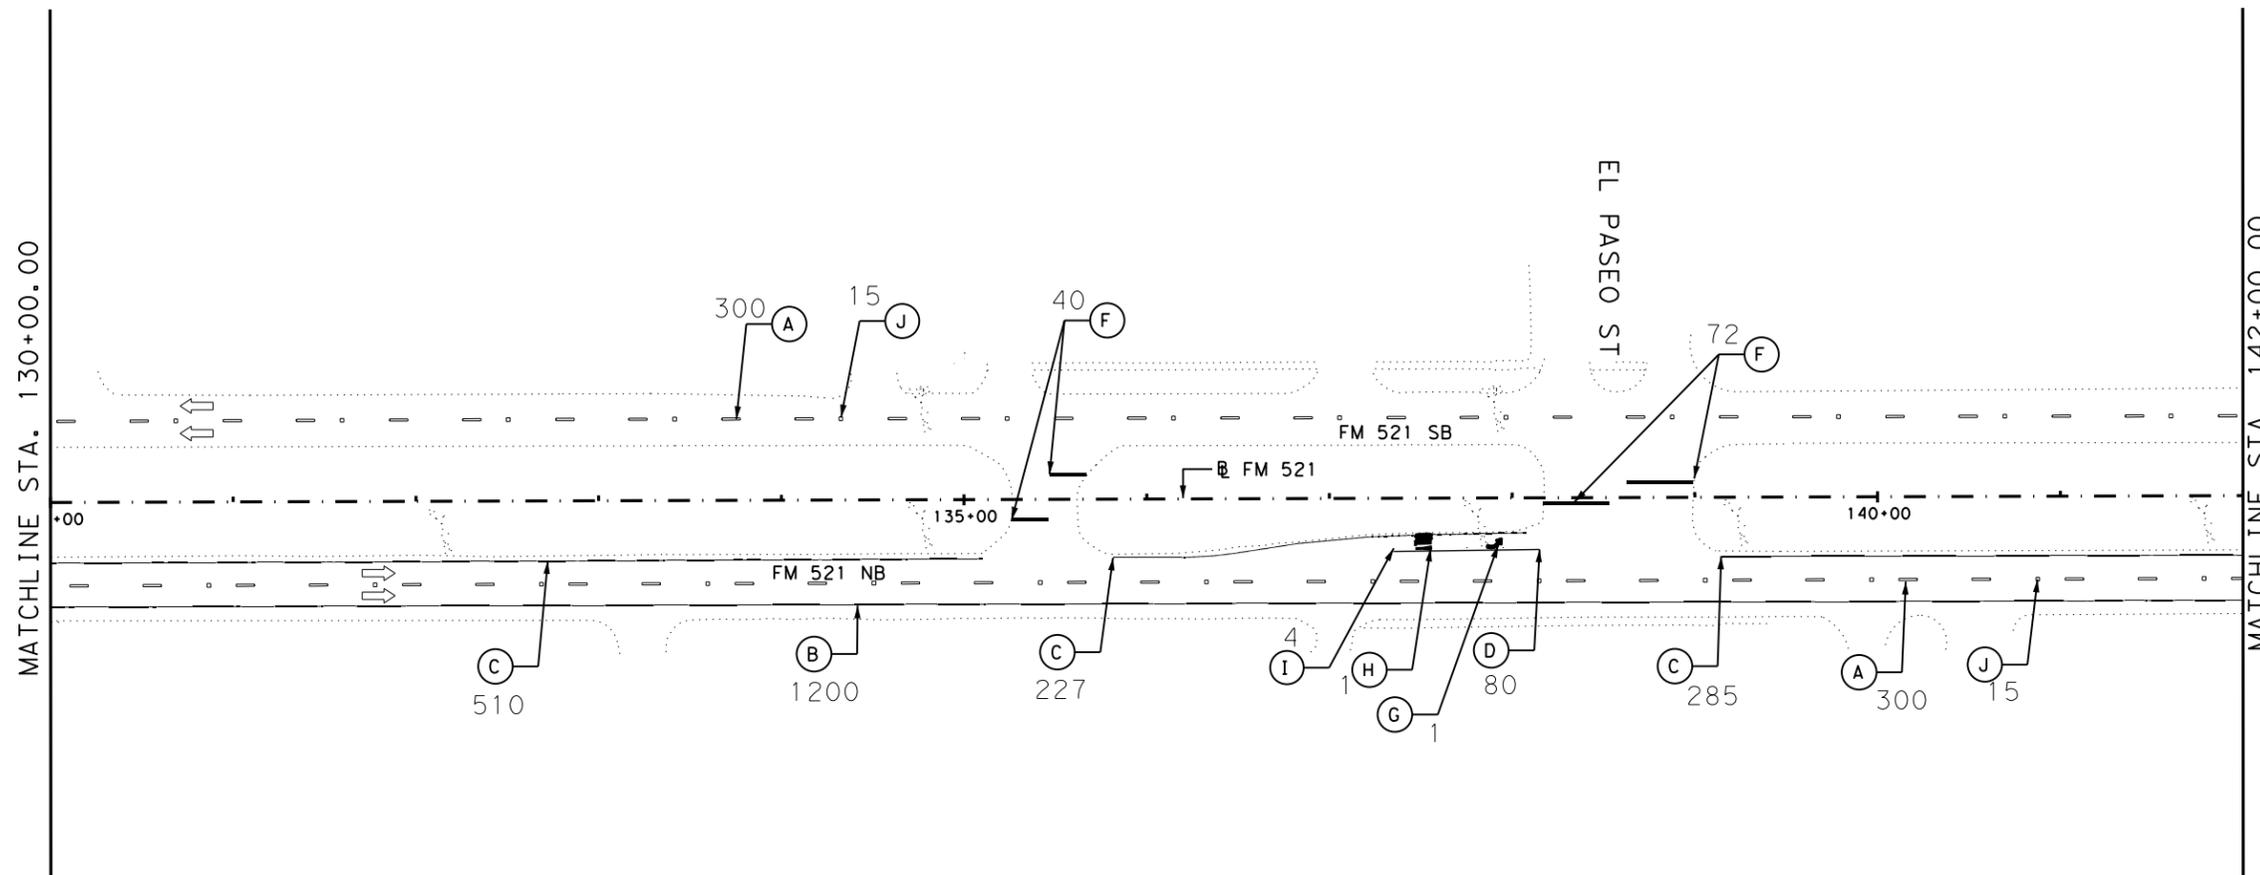

LEGEND

- | | |
|---|--|
| (A) RE PM W/REQ TY I (W) 6" (BRK) (100 MIL) | (I) REFL PAV MRKR TY I-C |
| (B) RE PM W/REQ TY I (W) 6" (SLD) (100 MIL) | (J) REFL PAV MRKR TY II-C-R |
| (C) RE PM W/REQ TY I (Y) 6" (SLD) (100 MIL) | (K) MULTIPOLYMER PAV MRK (W) (6") (SLD) |
| (D) REFL PAV MRK TY I (W) 8" (SLD) (100 MIL) | (L) MULTIPOLYMER PAV MRK (W) (8") (SLD) |
| (E) REFL PAV MRK TY I (W) 12" (SLD) (100 MIL) | (M) MULTIPOLYMER PAV MRK (W) (12") (SLD) |
| (F) REFL PAV MRK TY I (W) 24" (SLD) (100 MIL) | (N) MULTIPOLYMER PAV MRK (W) (24") (SLD) |
| (G) REFL PAV MRK TY I (W) (ARROW) (100 MIL) | (O) MULTIPOLYMER PAV MRK (W) (6") (BRK) |
| (H) REFL PAV MRK TY I (W) (WORD) (100 MIL) | (P) PREFAB PAV MRK TY C (W) (ARROW) |
| | (Q) PREFAB PAV MRK TY C (W) (WORD) |

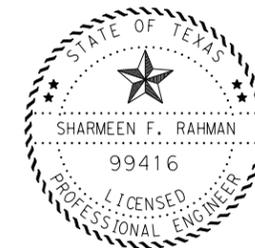


Sharmeen Rahman, P.E.
10/07/2020



FM 521
PAVEMENT MARKING
LAYOUT


SCALE: 1" = 100'		SHEET 2 OF 5	
FED. RD. DIV. NO. 6	PROJECT NO.	SHEET NO. 58	
STATE TEXAS	DIST HOU	COUNTY HARRIS	
CONT 0111	SECT 01	JOB 095	HIGHWAY FM 521

9/22/2020 2:05:26 PM T:\HUM-AO\Des\ign\Roadway\FM 521\0111-01-095.DGN\PAVEMENT MARKINGS\059 PAVEMENT MARKING LAYOUT.dgn

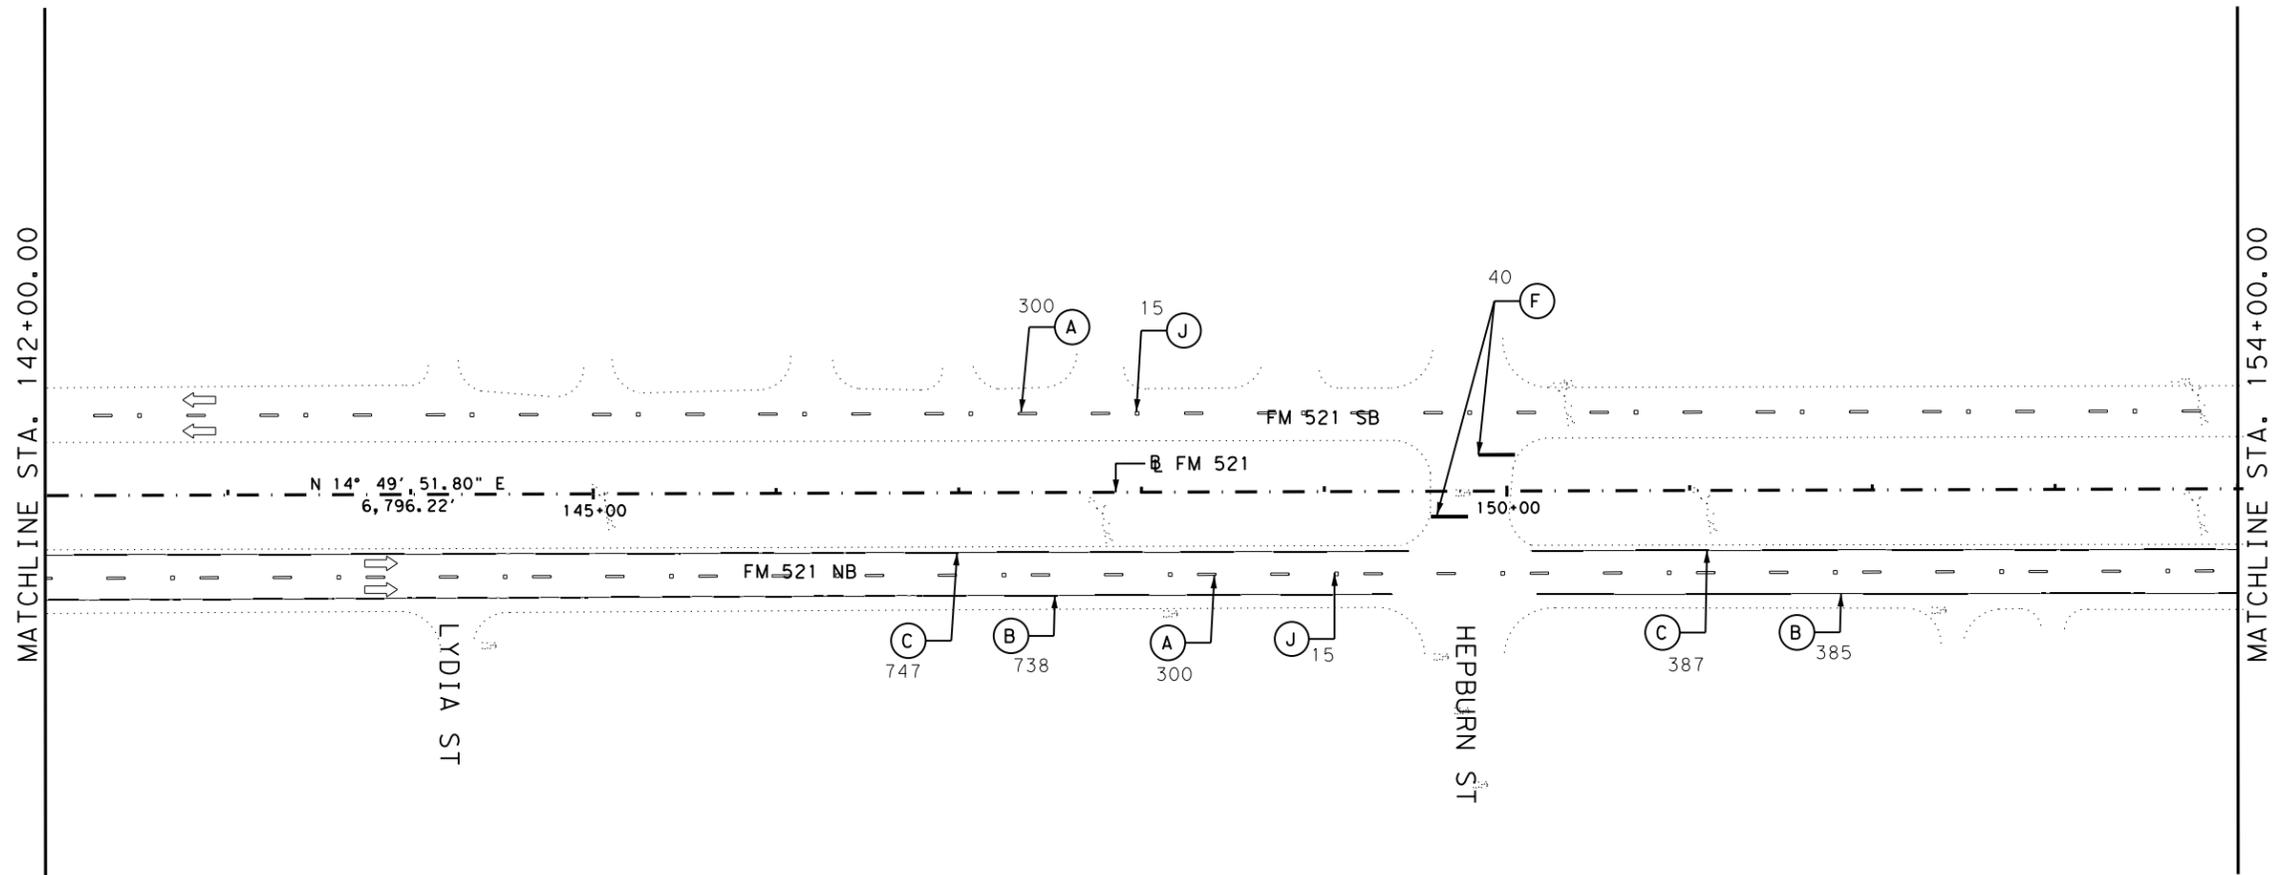

LEGEND

- (A) RE PM W/REQ TY I (W) 6" (BRK) (100 MIL)
- (B) RE PM W/REQ TY I (W) 6" (SLD) (100 MIL)
- (C) RE PM W/REQ TY I (Y) 6" (SLD) (100 MIL)
- (D) REFL PAV MRK TY I (W) 8" (SLD) (100 MIL)
- (E) REFL PAV MRK TY I (W) 12" (SLD) (100 MIL)
- (F) REFL PAV MRK TY I (W) 24" (SLD) (100 MIL)
- (G) REFL PAV MRK TY I (W) (ARROW) (100 MIL)
- (H) REFL PAV MRK TY I (W) (WORD) (100 MIL)
- (I) REFL PAV MRKR TY I-C
- (J) REFL PAV MRKR TY II-C-R
- (K) MULTIPOLYMER PAV MRK (W) (6") (SLD)
- (L) MULTIPOLYMER PAV MRK (W) (8") (SLD)
- (M) MULTIPOLYMER PAV MRK (W) (12") (SLD)
- (N) MULTIPOLYMER PAV MRK (W) (24") (SLD)
- (O) MULTIPOLYMER PAV MRK (W) (6") (BRK)
- (P) PREFAB PAV MRK TY C (W) (ARROW)
- (Q) PREFAB PAV MRK TY C (W) (WORD)

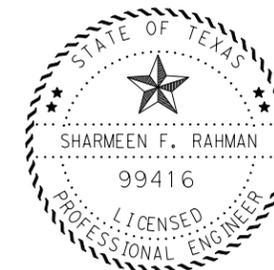



Sharmeen Rahman, P.E.
10/07/2020



FM 521
PAVEMENT MARKING
LAYOUT

SCALE: 1" = 100'		SHEET 3 OF 5	
FED. RD. DIV. NO. 6	PROJECT NO.	SHEET NO. 59	
STATE TEXAS	DIST HOU	COUNTY HARRIS	
CONT 0111	SECT 01	JOB 095	HIGHWAY FM 521

 9/22/2020 2:07:37 PM T:\HUM-AO\Des\ign\Roadway\FM 521\0111-01-095.DGN\PAVEMENT MARKINGS\060 PAVEMENT MARKING LAYOUT.dgn

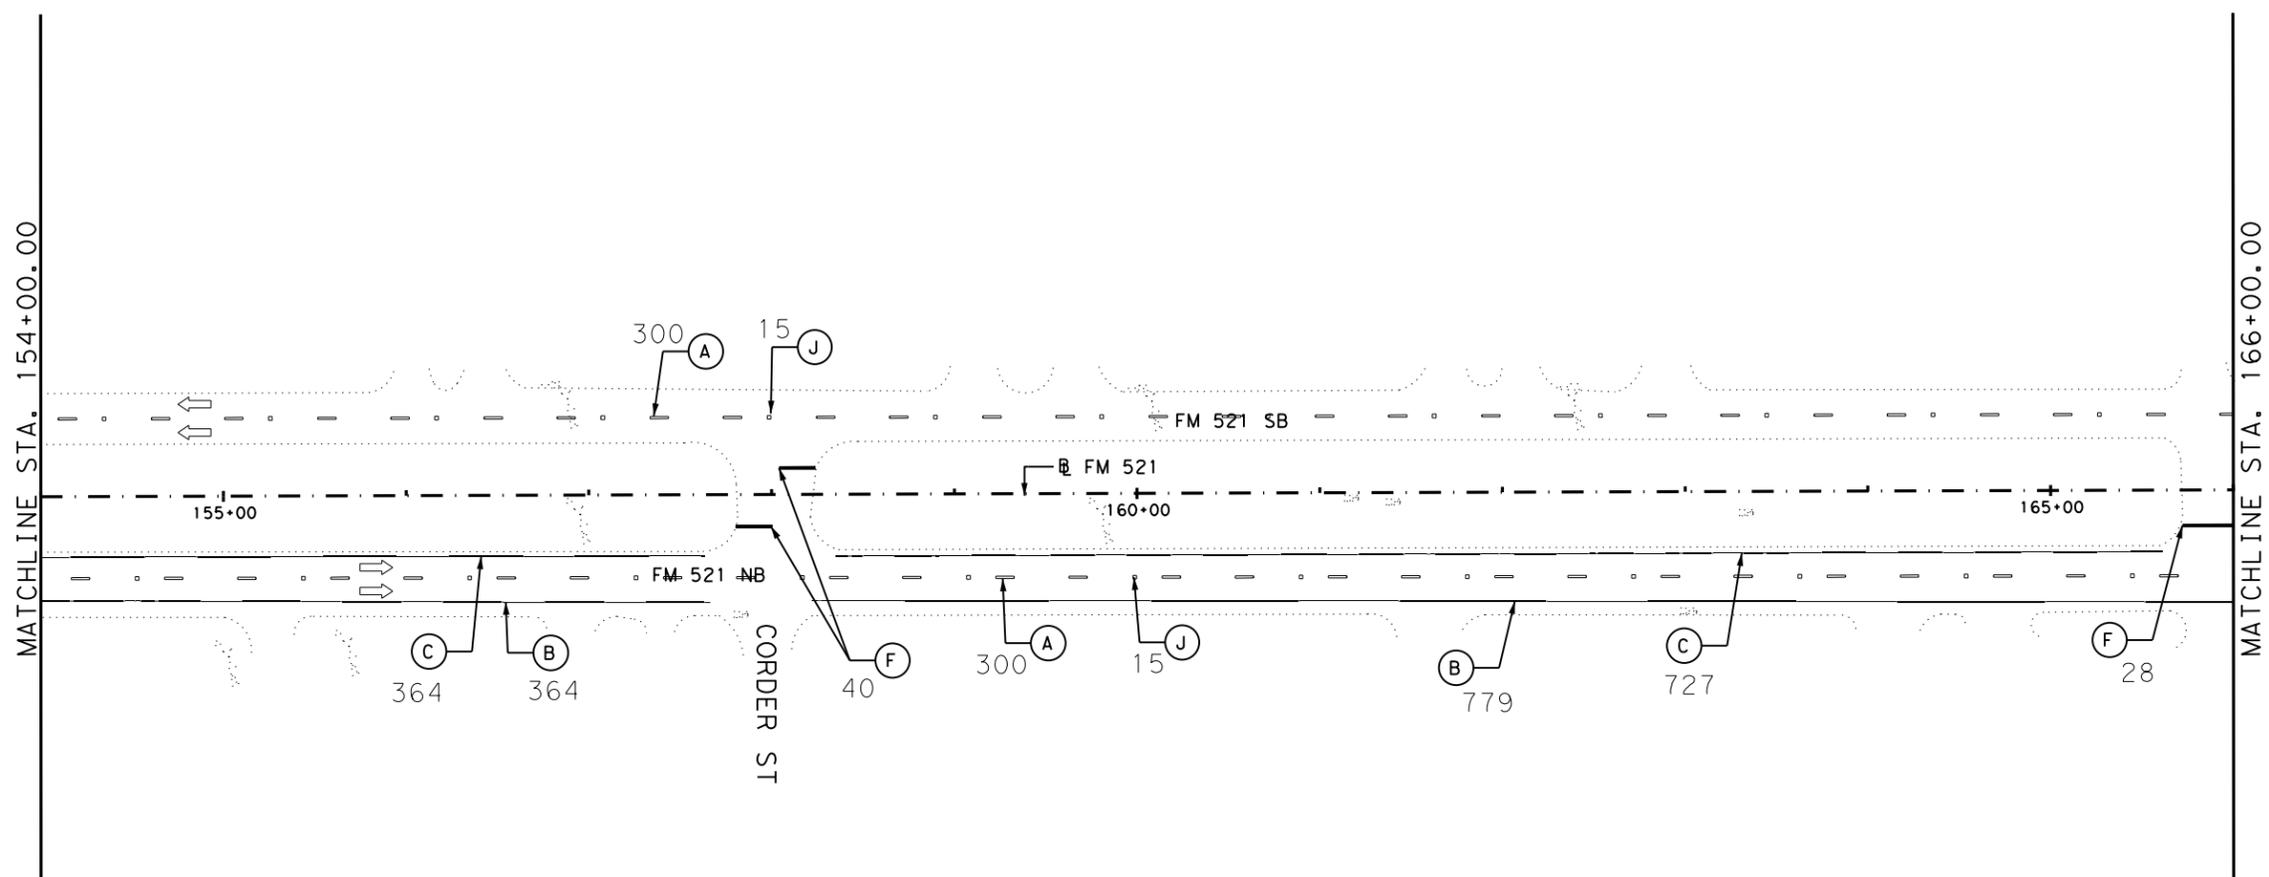

LEGEND

- (A) RE PM W/REQ TY I (W) 6" (BRK) (100 MIL)
- (B) RE PM W/REQ TY I (W) 6" (SLD) (100 MIL)
- (C) RE PM W/REQ TY I (Y) 6" (SLD) (100 MIL)
- (D) REFL PAV MRK TY I (W) 8" (SLD) (100 MIL)
- (E) REFL PAV MRK TY I (W) 12" (SLD) (100 MIL)
- (F) REFL PAV MRK TY I (W) 24" (SLD) (100 MIL)
- (G) REFL PAV MRK TY I (W) (ARROW) (100 MIL)
- (H) REFL PAV MRK TY I (W) (WORD) (100 MIL)
- (I) REFL PAV MRKR TY I-C
- (J) REFL PAV MRKR TY II-C-R
- (K) MULTIPOLYMER PAV MRK (W) (6") (SLD)
- (L) MULTIPOLYMER PAV MRK (W) (8") (SLD)
- (M) MULTIPOLYMER PAV MRK (W) (12") (SLD)
- (N) MULTIPOLYMER PAV MRK (W) (24") (SLD)
- (O) MULTIPOLYMER PAV MRK (W) (6") (BRK)
- (P) PREFAB PAV MRK TY C (W) (ARROW)
- (Q) PREFAB PAV MRK TY C (W) (WORD)




Sharmeen Rahman, P.E.
10/07/2020



FM 521
PAVEMENT MARKING
LAYOUT


SCALE: 1" = 100'		SHEET 4 OF 5	
FED. RD. DIV. NO. 6	PROJECT NO.		SHEET NO. 60
STATE TEXAS	DIST HOU	COUNTY HARRIS	
CONT 0111	SECT 01	JOB 095	HIGHWAY FM 521

9/22/2020 2:09:52 PM T:\HUM-AO\Des\ign\Roadway\FM 521\0111-01-095.DGN\PAVEMENT MARKINGS\061 PAVEMENT MARKING LAYOUT.dgn

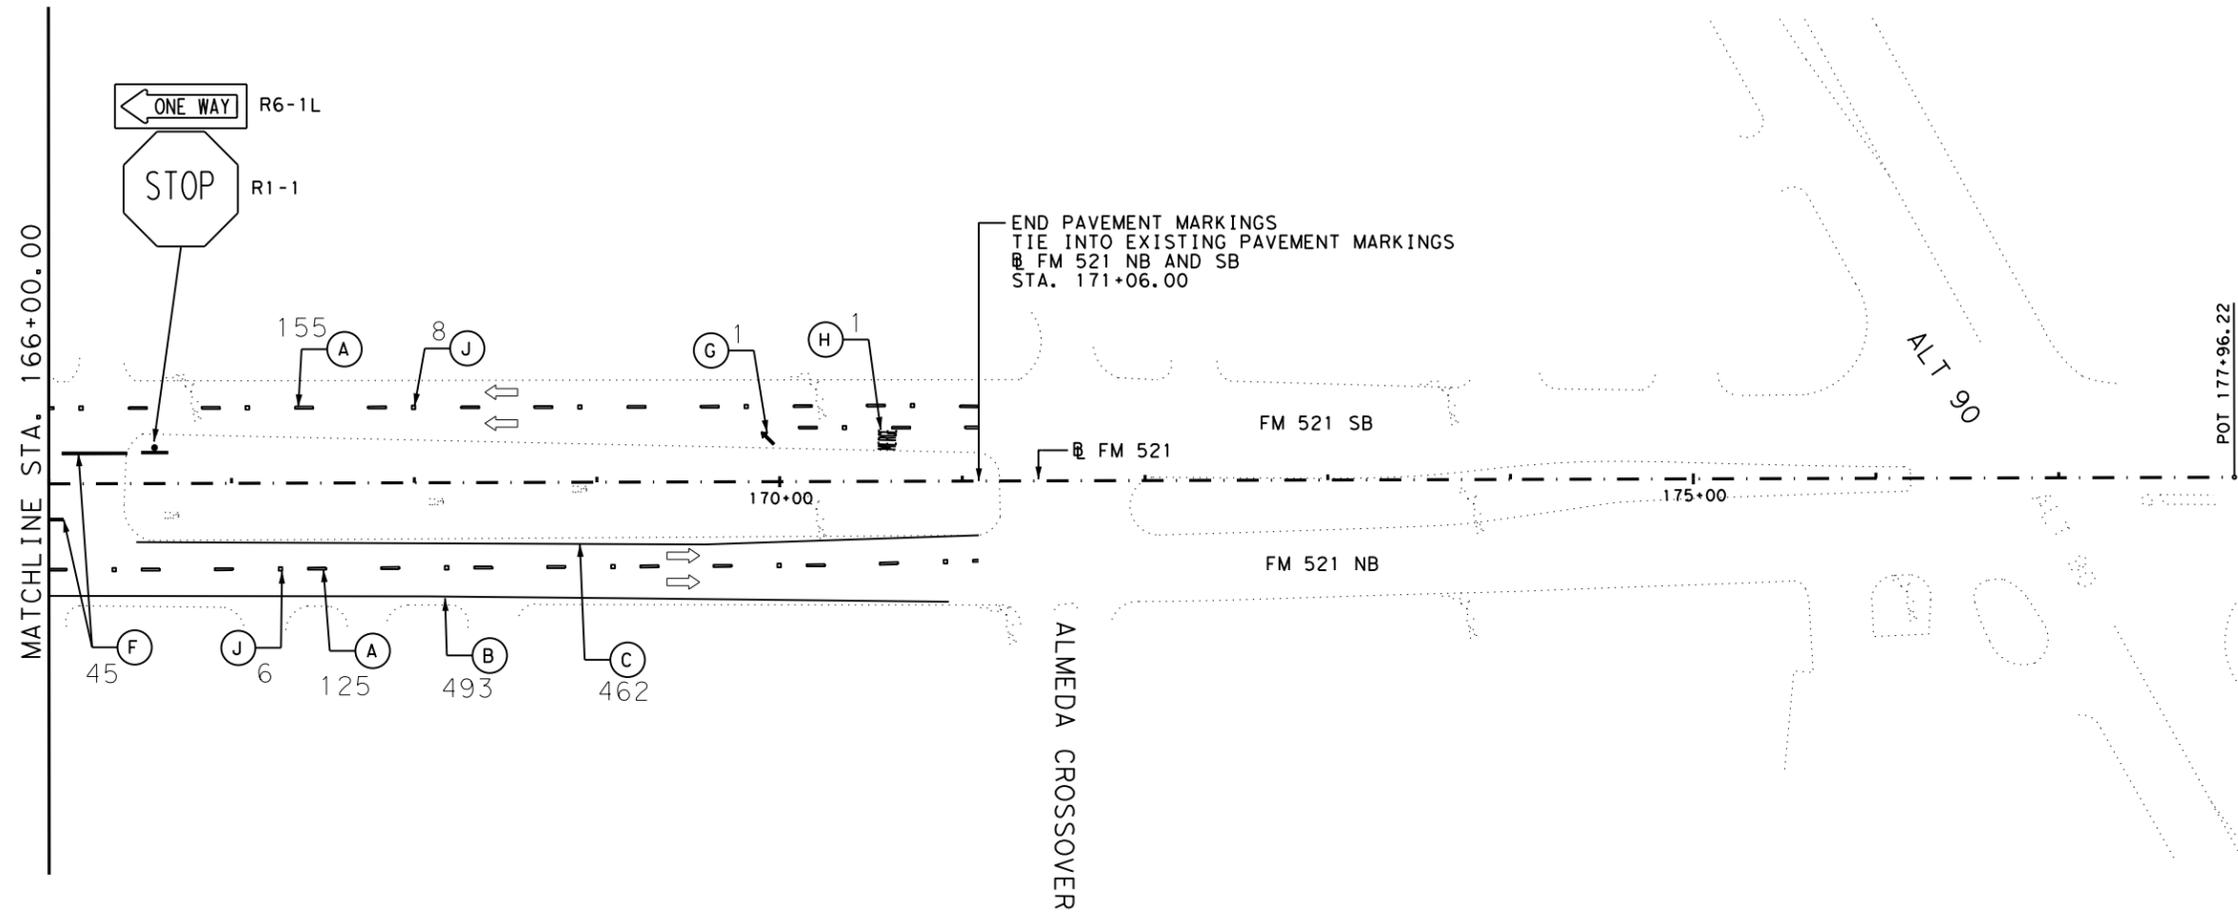

LEGEND

- | | |
|---|--|
| (A) RE PM W/REQ TY I (W) 6" (BRK) (100 MIL) | (I) REFL PAV MRKR TY I-C |
| (B) RE PM W/REQ TY I (W) 6" (SLD) (100 MIL) | (J) REFL PAV MRKR TY II-C-R |
| (C) RE PM W/REQ TY I (Y) 6" (SLD) (100 MIL) | (K) MULTIPOLYMER PAV MRK (W) (6") (SLD) |
| (D) REFL PAV MRK TY I (W) 8" (SLD) (100 MIL) | (L) MULTIPOLYMER PAV MRK (W) (8") (SLD) |
| (E) REFL PAV MRK TY I (W) 12" (SLD) (100 MIL) | (M) MULTIPOLYMER PAV MRK (W) (12") (SLD) |
| (F) REFL PAV MRK TY I (W) 24" (SLD) (100 MIL) | (N) MULTIPOLYMER PAV MRK (W) (24") (SLD) |
| (G) REFL PAV MRK TY I (W) (ARROW) (100 MIL) | (O) MULTIPOLYMER PAV MRK (W) (6") (BRK) |
| (H) REFL PAV MRK TY I (W) (WORD) (100 MIL) | (P) PREFAB PAV MRK TY C (W) (ARROW) |
| | (Q) PREFAB PAV MRK TY C (W) (WORD) |

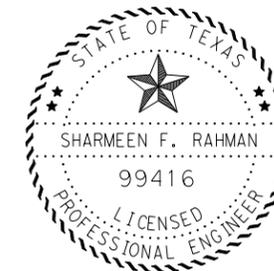


Sharmeen Rahman, P.E.
10/07/2020




FM 521
PAVEMENT MARKING
LAYOUT

SCALE: 1" = 100'		SHEET 5 OF 5	
FED. RD. DIV. NO. 6	PROJECT NO. 095		SHEET NO. 61
STATE TEXAS	DIST HOU	COUNTY HARRIS	
CONT 0111	SECT 01	JOB 095	HIGHWAY FM 521


DISCLAIMER: The use of this standard is governed by the "Texas Engineering Practice Act". No warranty of any kind is made by TxDOT for any purpose whatsoever. TxDOT assumes no responsibility for the conversion of this standard to other formats or for incorrect results or damages resulting from its use.

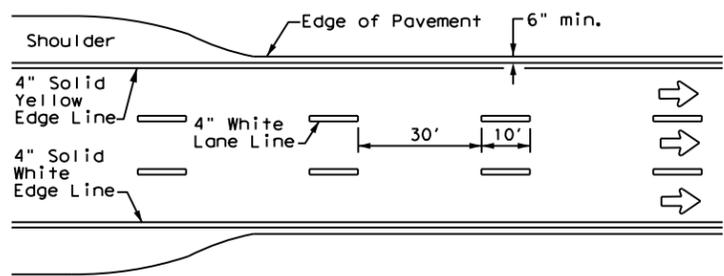


**EDGE LINE AND LANE LINES
ONE-WAY ROADWAY
WITH OR WITHOUT SHOULDERS**

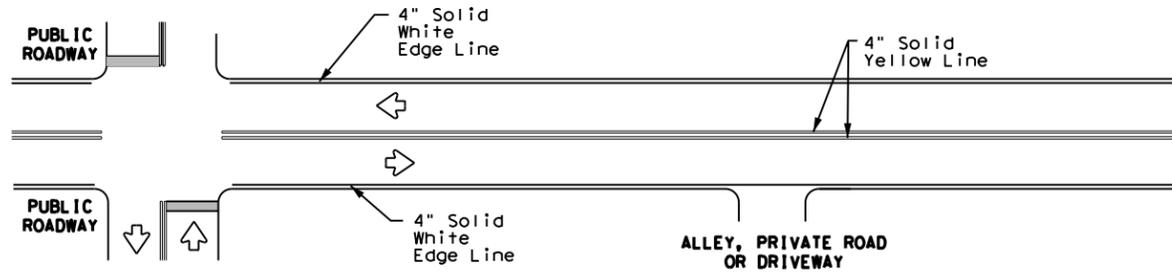


**TYPICAL TWO-LANE, TWO-WAY PAVEMENT
MARKINGS THROUGH INTERSECTIONS**

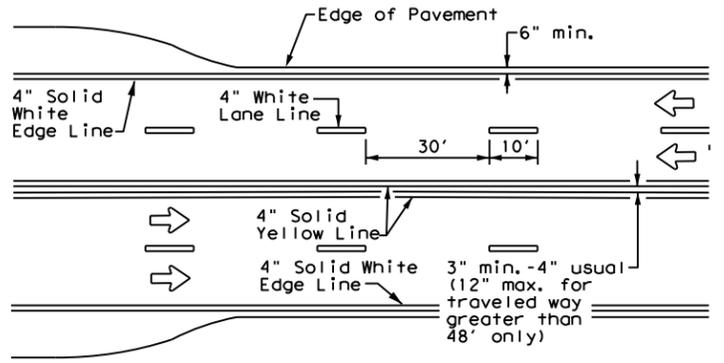


**CENTERLINE AND LANE LINES
FOUR LANE TWO-WAY ROADWAY
WITH OR WITHOUT SHOULDERS**

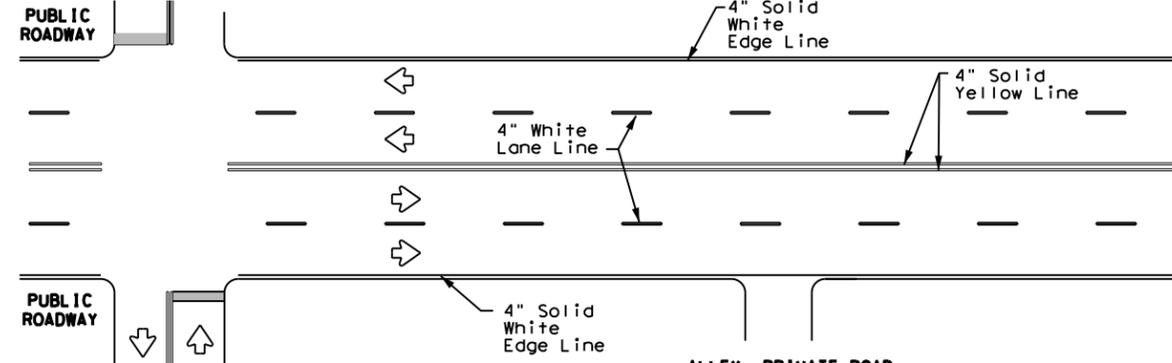


**TYPICAL MULTI-LANE, TWO-WAY PAVEMENT
MARKINGS THROUGH INTERSECTIONS**

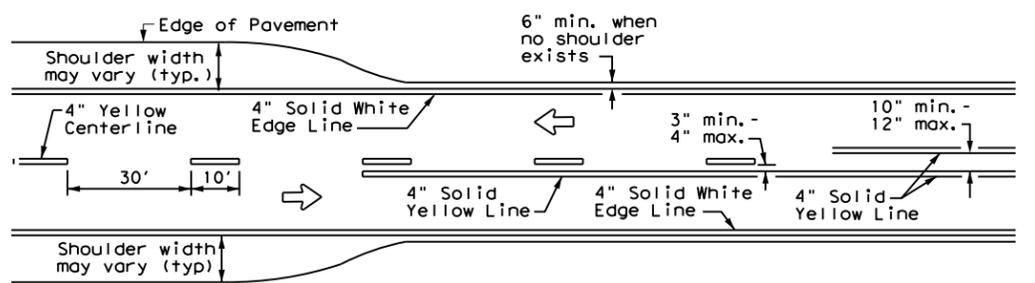

 **TWO LANE TWO-WAY ROADWAY
WITH OR WITHOUT SHOULDERS**



 For posted speed on road being marked equal to or less than 40 MPH.



For posted speed on road being marked equal to or greater than 45 MPH.


YIELD LINES

GENERAL NOTES

1. Edgeline striping shall be as shown in the plans or as directed by the Engineer. The edgeline should not be placed less than 6 inches from the edge of pavement. This distance may vary due to pavement raveling or other conditions. Edgelines are not required in curb and gutter sections of roadways.
2. The traveled way includes only that portion of the roadway used for vehicular travel. It does not include the parking lanes, sidewalks, berms and shoulders. The traveled ways shall be measured from the inside of edgeline to the inside of edgeline of a two lane roadway.

MATERIAL SPECIFICATIONS	
PAVEMENT MARKERS (REFLECTORIZED)	DMS-4200
EPOXY AND ADHESIVES	DMS-6100
BITUMINOUS ADHESIVE FOR PAVEMENT MARKERS	DMS-6130
TRAFFIC PAINT	DMS-8200
HOT APPLIED THERMOPLASTIC	DMS-8220
PERMANENT PREFABRICATED PAVEMENT MARKINGS	DMS-8240

All pavement marking materials shall meet the required Departmental Material Specifications as specified by the plans.

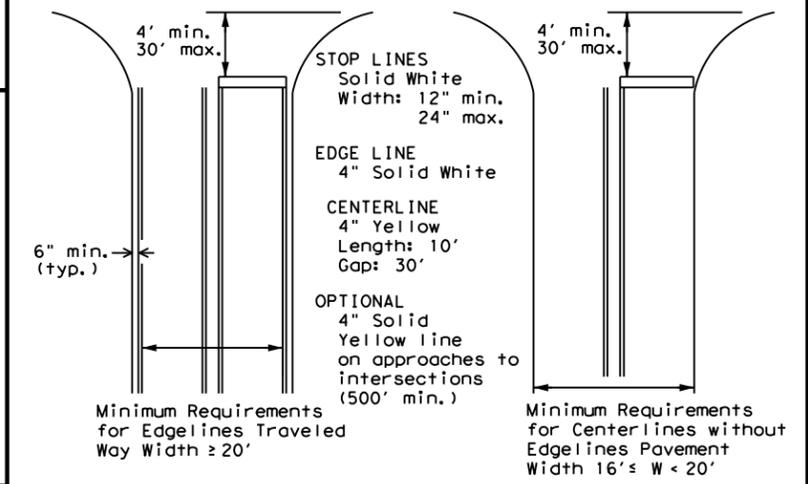

**GUIDE FOR PLACEMENT OF STOP LINES,
EDGE LINE & CENTERLINE**

Based on Traveled Way and Pavement Widths for Undivided Highways




**TYPICAL STANDARD
PAVEMENT MARKINGS**

PM(1) - 20

FILE: pm1-20.dgn	DWG:	CK:	DW:	CK:
© TxDOT November 1978	CONT	SECT	JOB	HIGHWAY
8-95 3-03 REVISIONS	0111	01	09B	FM 521
5-00 2-12	DIST	COUNTY		SHEET NO.
8-00 6-20	HOU	HARRIS		62

NOTES

1. Where divided highways are separated by median widths at the median opening itself of 30 feet or more, median openings shall be signed as two separate intersections. Each median opening has two width measurements, with one measurement for each approach. The narrow median width will be the controlling width to determine if signs are required. Yield signs are the typical intersection control. Stop signs are optional as determined by the Engineer.
2. Install median striping (double yellow centerlines and stop bars/yield triangles) when a 50' or greater median centerline can be placed. Stop bars shall only be used with stop signs. Yield triangles shall only be used with yield signs.
3. Length of turn bays, including taper, deceleration, and storage lengths shall be as shown on the plans or as directed by the Engineer.

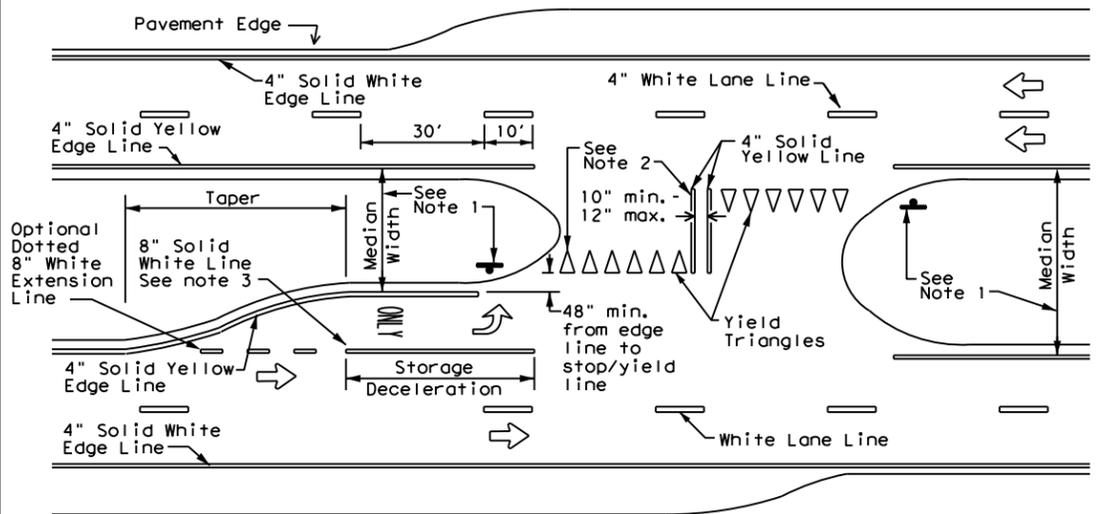


FOUR LANE DIVIDED ROADWAY CROSSOVERS


DATE:
FILE:

REFLECTIVE RAISED PAVEMENT MARKERS FOR VEHICLE POSITIONING GUIDANCE



DISCLAIMER: The use of this standard is governed by the "Texas Engineering Practice Act". No warranty of any kind is made by TxDOT for any purpose whatsoever. TxDOT assumes no responsibility for the conversion of this standard to other formats or for incorrect results or damages resulting from its use.

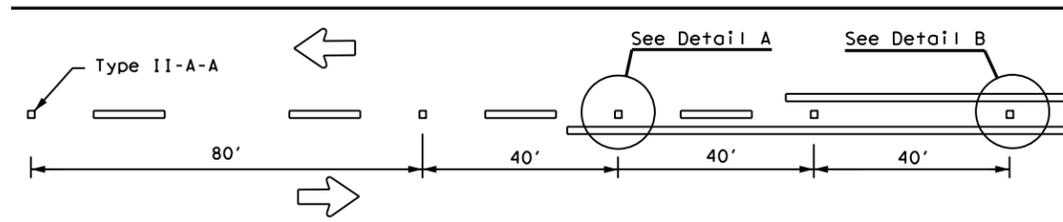


CENTERLINE FOR ALL TWO LANE ROADWAYS

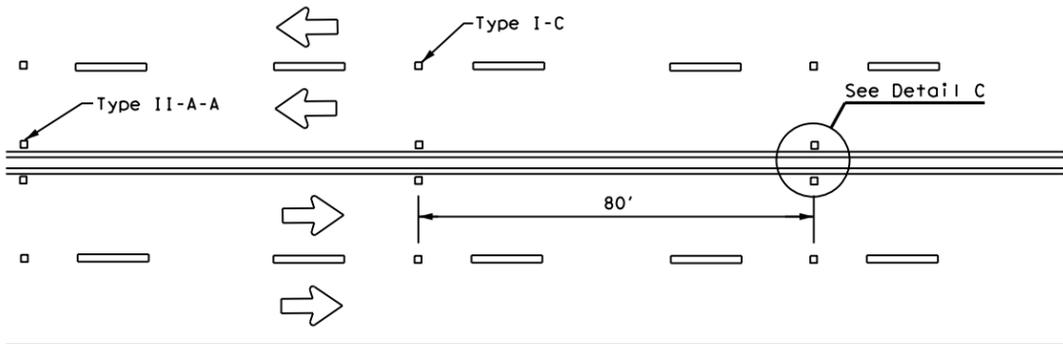

**CENTERLINE & LANE LINES
FOR FOUR LANE TWO-WAY HIGHWAYS**

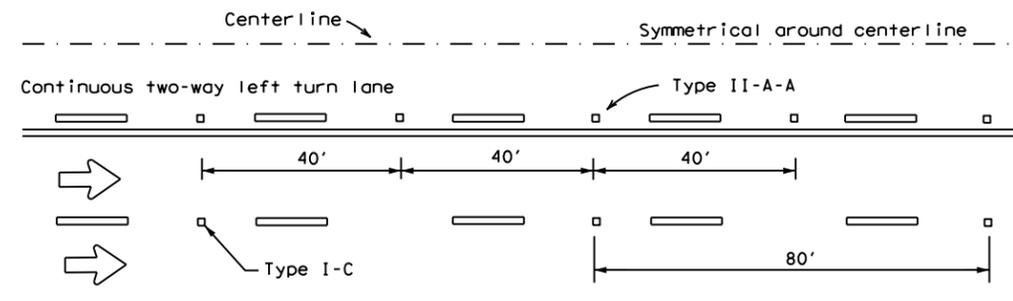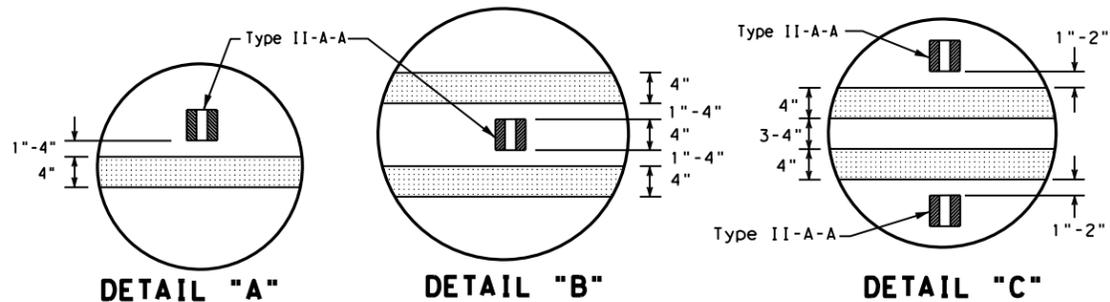

CENTERLINE AND LANE LINES FOR TWO-WAY LEFT TURN LANE

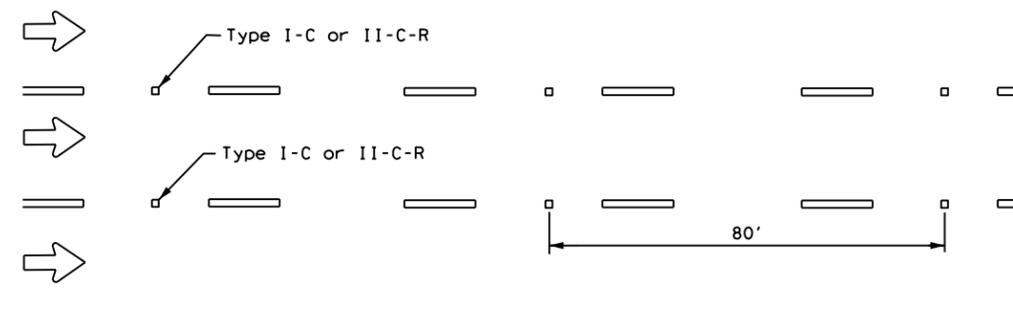


LANE LINES FOR ONE-WAY ROADWAY (NON-FREEWAY FACILITIES)


Raised pavement markers Type II-C-R shall have clear face toward normal traffic and red face toward wrong-way traffic.

MATERIAL SPECIFICATIONS	
PAVEMENT MARKERS (REFLECTORIZED)	DMS-4200
EPOXY AND ADHESIVES	DMS-6100
BITUMINOUS ADHESIVE FOR PAVEMENT MARKERS	DMS-6130
TRAFFIC PAINT	DMS-8200
HOT APPLIED THERMOPLASTIC	DMS-8220
PERMANENT PREFABRICATED PAVEMENT MARKINGS	DMS-8240


All pavement marking materials shall meet the required Departmental Material Specifications as specified by the plans.

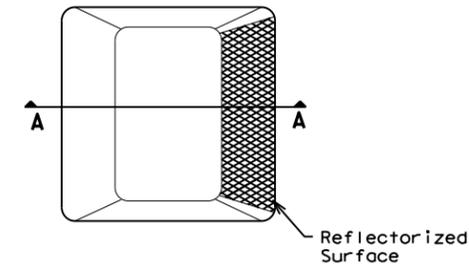

Type I (Top View)

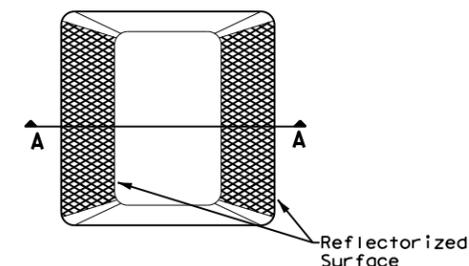

Type II (Top View)

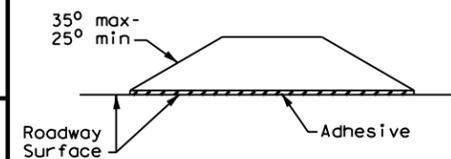


SECTION A

RAISED PAVEMENT MARKERS


GENERAL NOTES

- All raised pavement markers placed in broken lines shall be placed in line with and midway between the stripes.
- On concrete pavements the raised pavement markers should be placed to one side of the longitudinal joints.

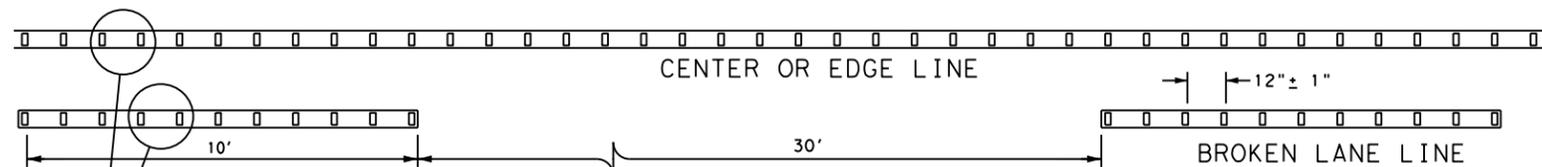

**REFLECTORIZED PROFILE
PATTERN DETAIL**

USING REFLECTIVE PROFILE PAVEMENT MARKINGS

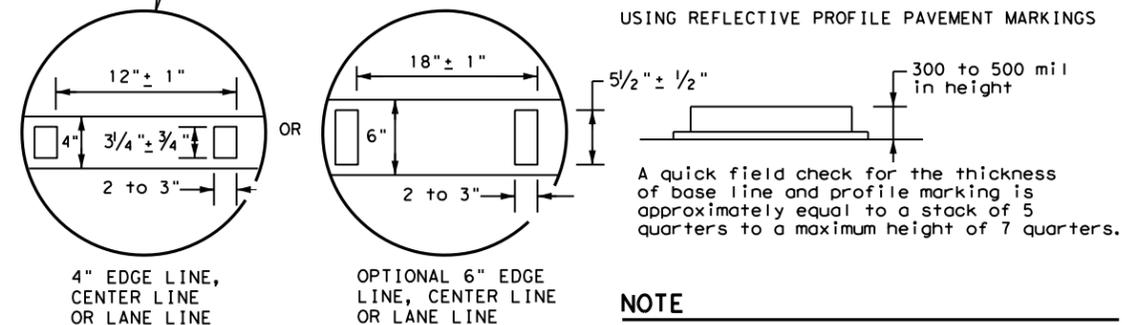

NOTE

Profile markings shall not be placed on roadways with a posted speed limit of 45 MPH or less.




**POSITION GUIDANCE USING
RAISED MARKERS
REFLECTORIZED PROFILE
MARKINGS
PM(2) - 20**

FILE: pm2-20.dgn	DN:	CK:	DW:	CK:
© TxDOT April 1977	CONT	SECT	JOB	HIGHWAY
4-92 2-10 REVISIONS	0111	01	095	FM 521
5-00 2-12	DIST	COUNTY		SHEET NO.
8-00 6-20	MOU	HARRIS		63

DATE:
FILE:

DISCLAIMER: The use of this standard is governed by the "Texas Engineering Practice Act". No warranty of any kind is made by TxDOT for any purpose whatsoever. TxDOT assumes no responsibility for the conversion of this standard to other formats or for incorrect results or damages resulting from its use.

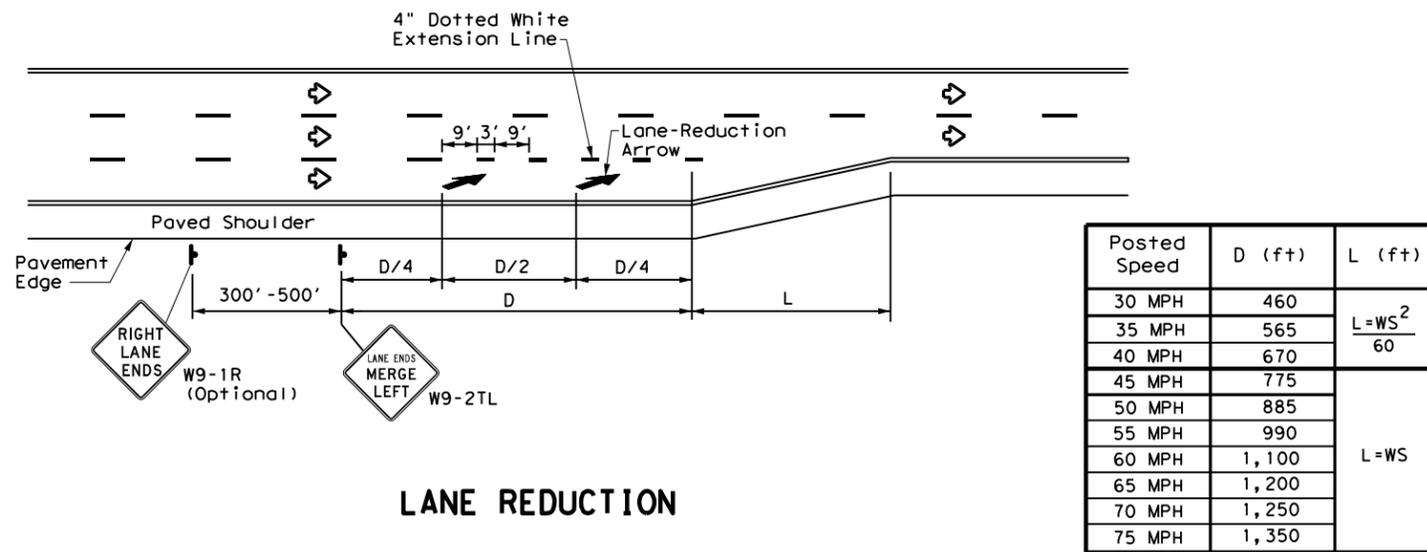

Posted Speed	D (ft)	L (ft)
30 MPH	460	$L = \frac{WS^2}{60}$
35 MPH	565	
40 MPH	670	L = WS
45 MPH	775	
50 MPH	885	
55 MPH	990	
60 MPH	1,100	
65 MPH	1,200	
70 MPH	1,250	
75 MPH	1,350	

LANE REDUCTION

NOTES


- Lane reduction pavement markings are used where the number of through lanes is reduced because of narrowing of the roadway or because of a section of on-street parking in what would otherwise be a through lane. For Texas Super 2 Passing Lanes, see TS2(PL) standard sheets.
- On divided highways, an additional W9-1R "RIGHT LANE ENDS" sign may be installed in the median aligned with the W9-1R sign on the right side of the highway.
- Lane reduction arrows are required for speeds of 45 mph or greater. An optional third lane reduction arrow may be added based on engineering judgement. If used, the optional third lane reduction arrow should be centered between the first and last lane reduction arrows.
- For lane reductions on Freeways and Expressways, signing shall conform to the TxDOT Freeway Signing Handbook.

GENERAL NOTES

- Lane use word and arrow markings shall be used where through lanes approaching an intersection become mandatory turn lanes. Lane use word and arrow markings should be used in auxiliary lanes of substantial length. Lane use arrow markings or word and arrow markings may be used in other lanes and turn bays for emphasis. Details for words and arrows are as shown in the Standard Highway Sign Designs for Texas.
- When lane-use words and arrow markings are used, two sets of arrows should be used if the length of the bay is greater than 180 feet. When a single lane use arrow or word and arrow marking is used for a short turn lane, it should be located at or near the upstream end of the full-width turn lane.
- Use raised pavement marker Type I-C with undivided highways, flush medians and two way left turn lanes. Use raised pavement marker Type II-C-R with divided highways and raised medians.
- Length of turn bays, including taper, deceleration, and storage lengths shall be as shown on the plans or as directed by the Engineer.


MATERIAL SPECIFICATIONS	
PAVEMENT MARKERS (REFLECTORIZED)	DMS-4200
EPOXY AND ADHESIVES	DMS-6100
BITUMINOUS ADHESIVE FOR PAVEMENT MARKERS	DMS-6130
TRAFFIC PAINT	DMS-8200
HOT APPLIED THERMOPLASTIC	DMS-8220
PERMANENT PREFABRICATED PAVEMENT MARKINGS	DMS-8240

All pavement marking materials shall meet the required Departmental Material Specifications as specified by the plans.

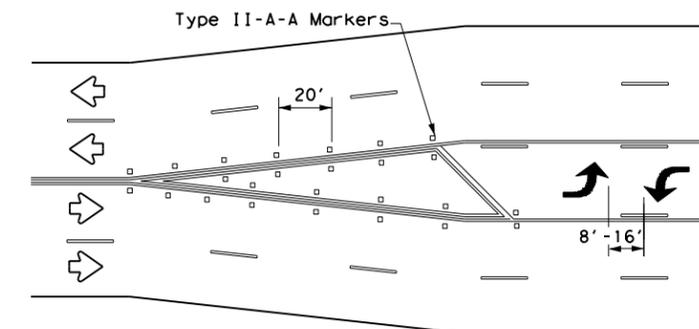


A two-way left-turn (TWLTL) lane-use arrow pavement marking should be used at or just downstream from the beginning of a two-way left-turn lane within a corridor. Repeating the marking after each intersection or dedicated turn bay is not required unless stated elsewhere in the plans.


TYPICAL TRANSITION FOR TWLTL AND DIVIDED HIGHWAY

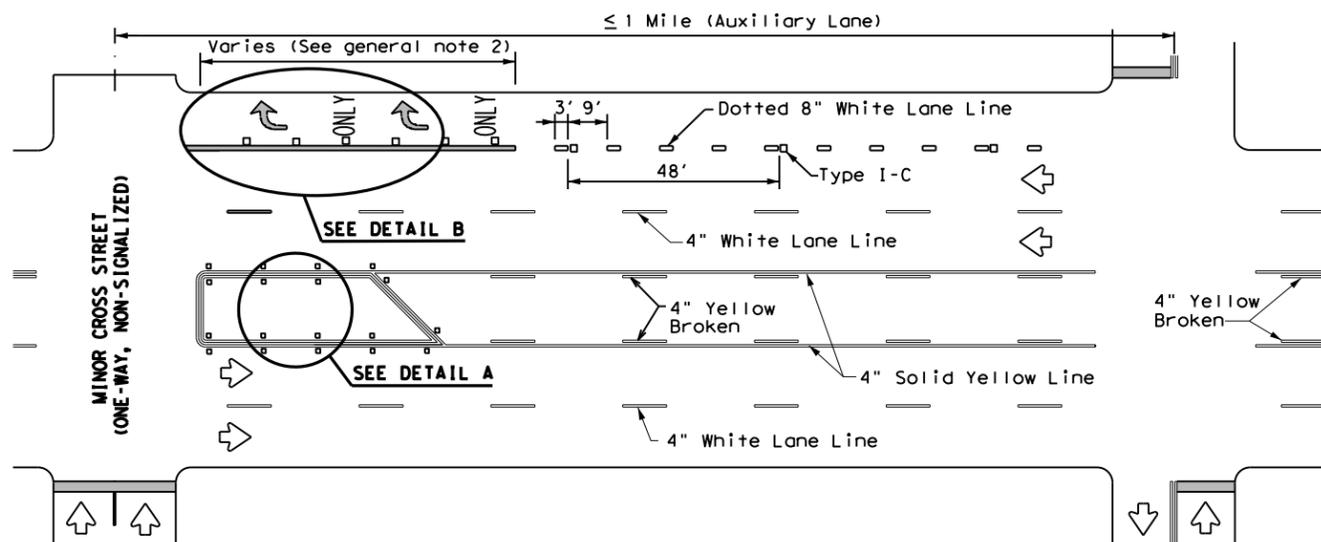


TYPICAL TWLTL AT ONE-WAY STREET AND RIGHT TURN AUXILIARY LANE

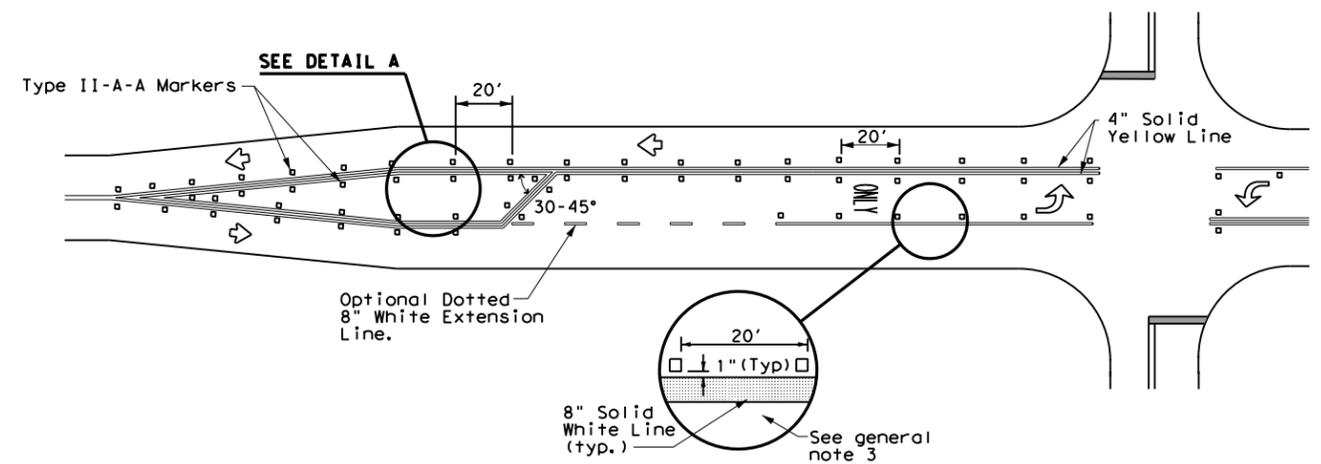

TYPICAL TWO-LANE HIGHWAY INTERSECTION WITH LEFT TURN BAYS

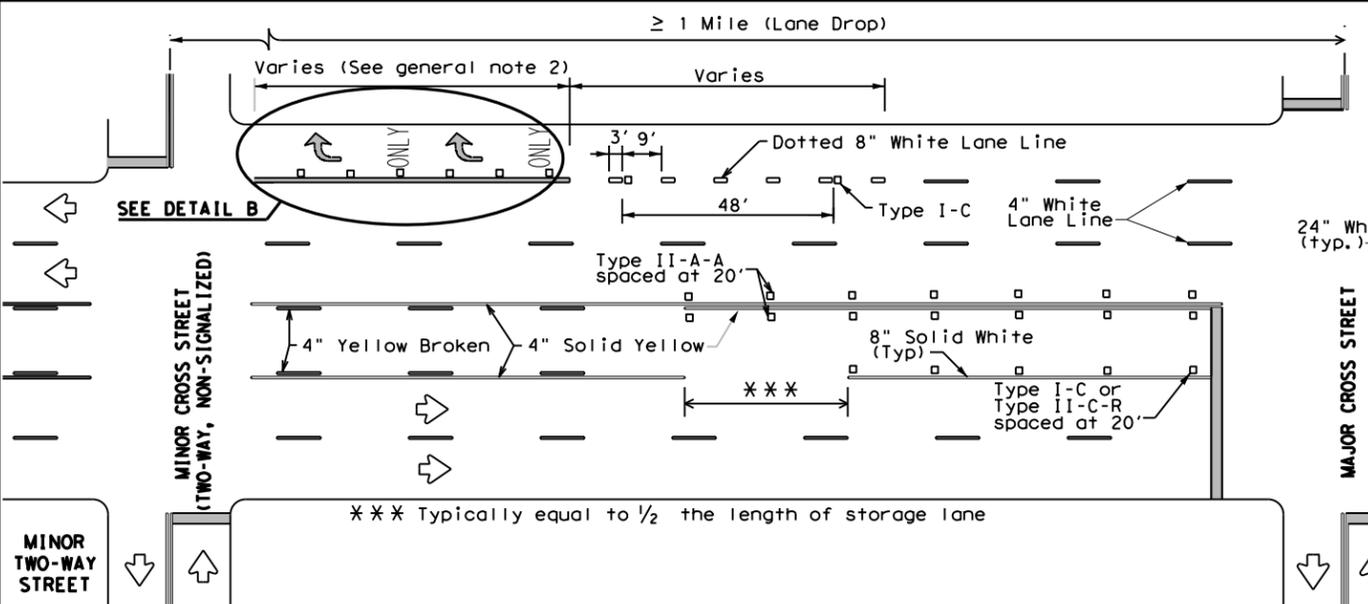

TYPICAL TWLTL AT TWO-WAY CROSS STREET AND RIGHT TURN LANE DROP

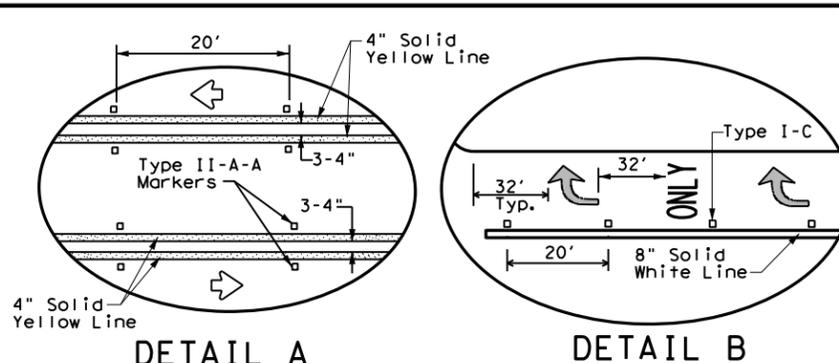

DETAIL A







DETAIL B

Texas Department of Transportation
Traffic Safety Division Standard


TWO-WAY LEFT TURN LANES, RURAL LEFT TURN BAYS, AND LANE REDUCTION PAVEMENT MARKINGS PM(3) - 20

FILE: pm3-20.dgn	DN:	CK:	DW:	CK:
© TxDOT April 1998	CONT	SECT	JOB	HIGHWAY
REVISIONS	0111	01	095	FM 521
5-00 2-10	DIST	COUNTY	SHEET NO.	
8-00 2-12	HOU	HARRIS	64	
3-03 6-20				


DATE:
FILE:

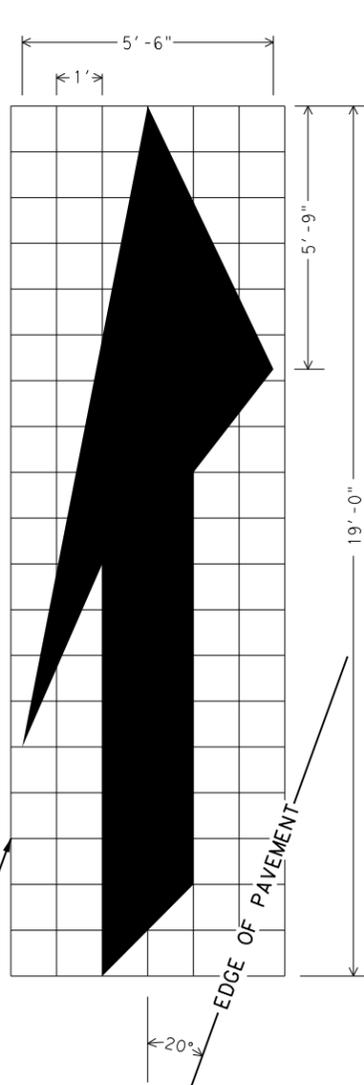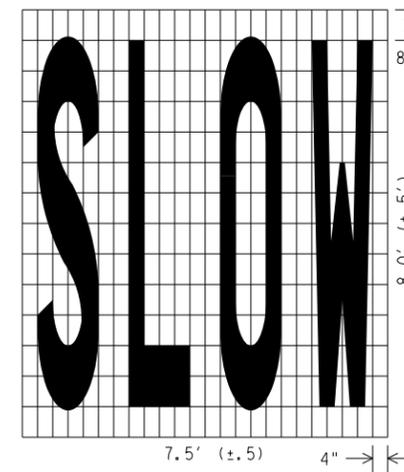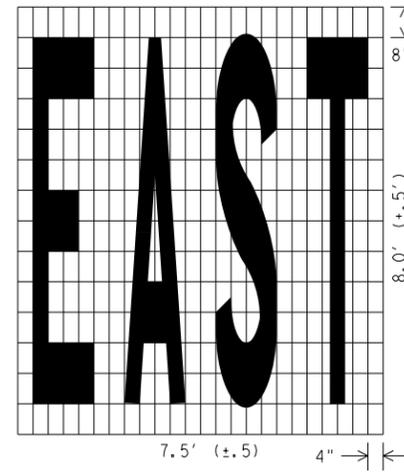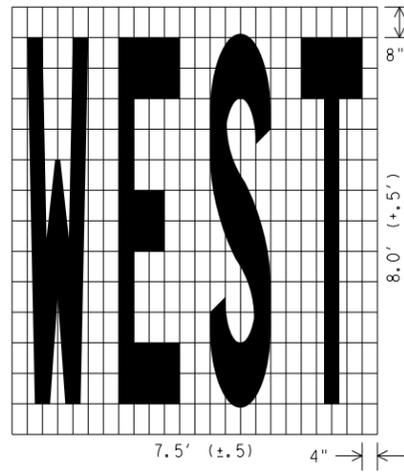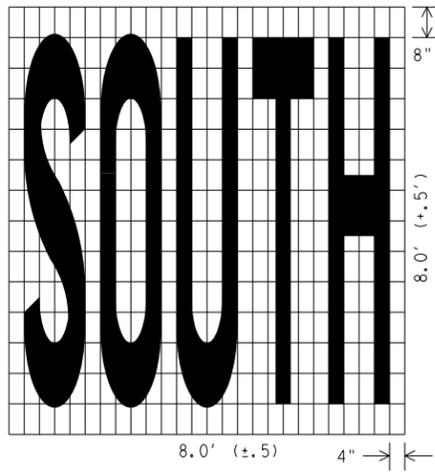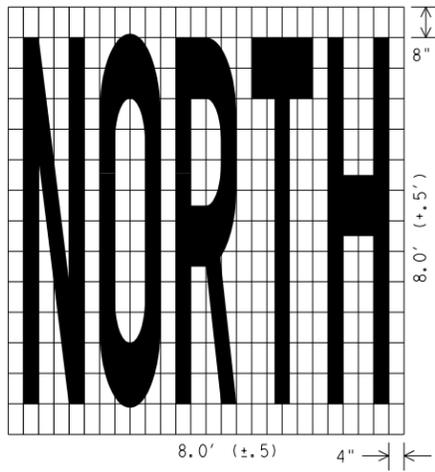


ISOMETRIC ARROW
 12 INCH GRID
 AREA = 42 SQ. FT.
 RIGHT LANE DROP ARROW
 (FOR LEFT LANE, USE MIRROR IMAGE)

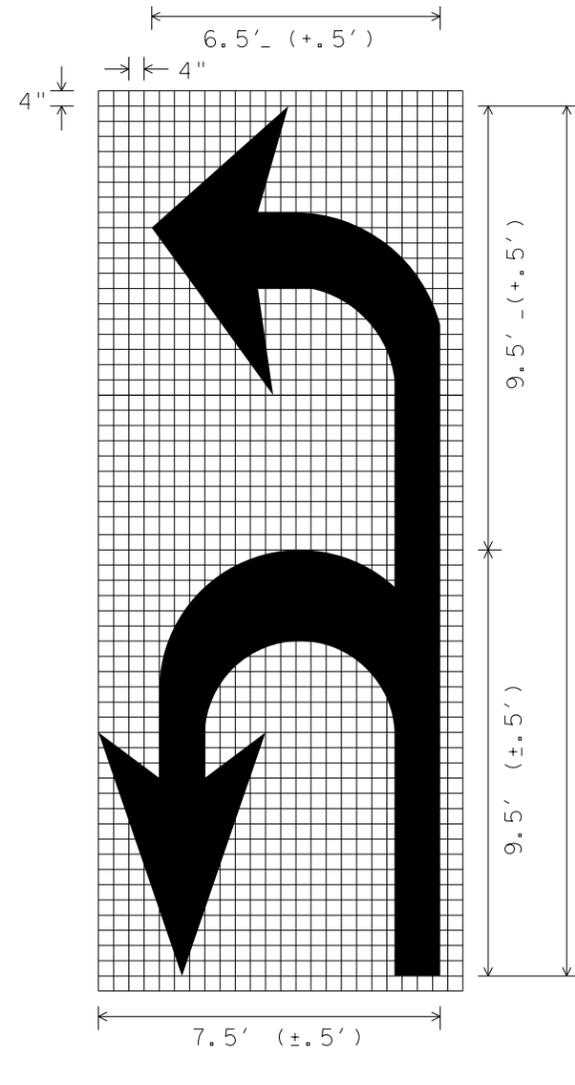

U-L ARROW

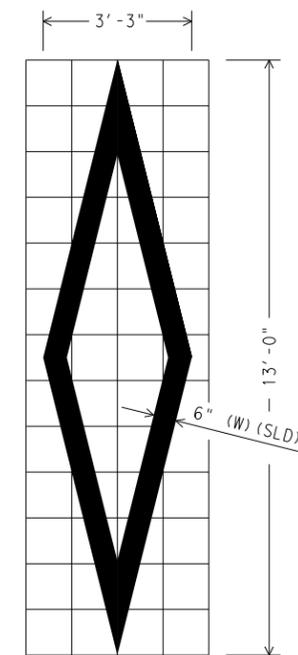

DIAMOND SYMBOL

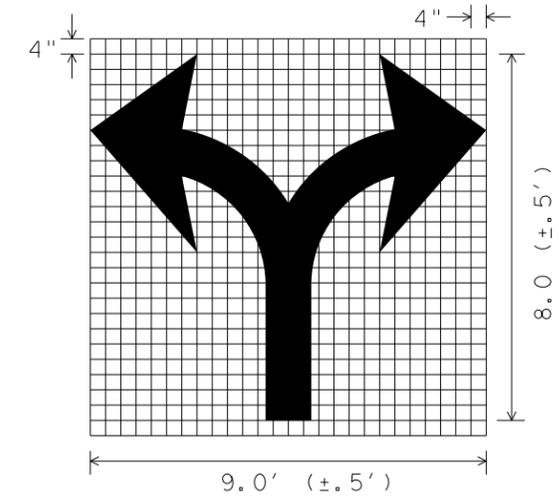


SCALE 1/4" = 1'

Texas Department of Transportation
Houston District


**PAVEMENT MARKINGS
 (WORDS, ARROWS & SYMBOLS)**

PM(WAS) -07

FILE:	DN:	CK:	DW:	CK:
© TxDOT 2007	DIST	FED REG	PROJECT NO.	SHEET
REVISIONS 03-19-07	HOU	6		65
	COUNTY	CONTROL	SECT	JOB
	HARRIS	0111	01	095
				HIGHWAY
				FM 521

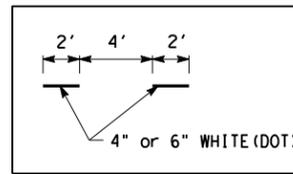

DETAIL "A"

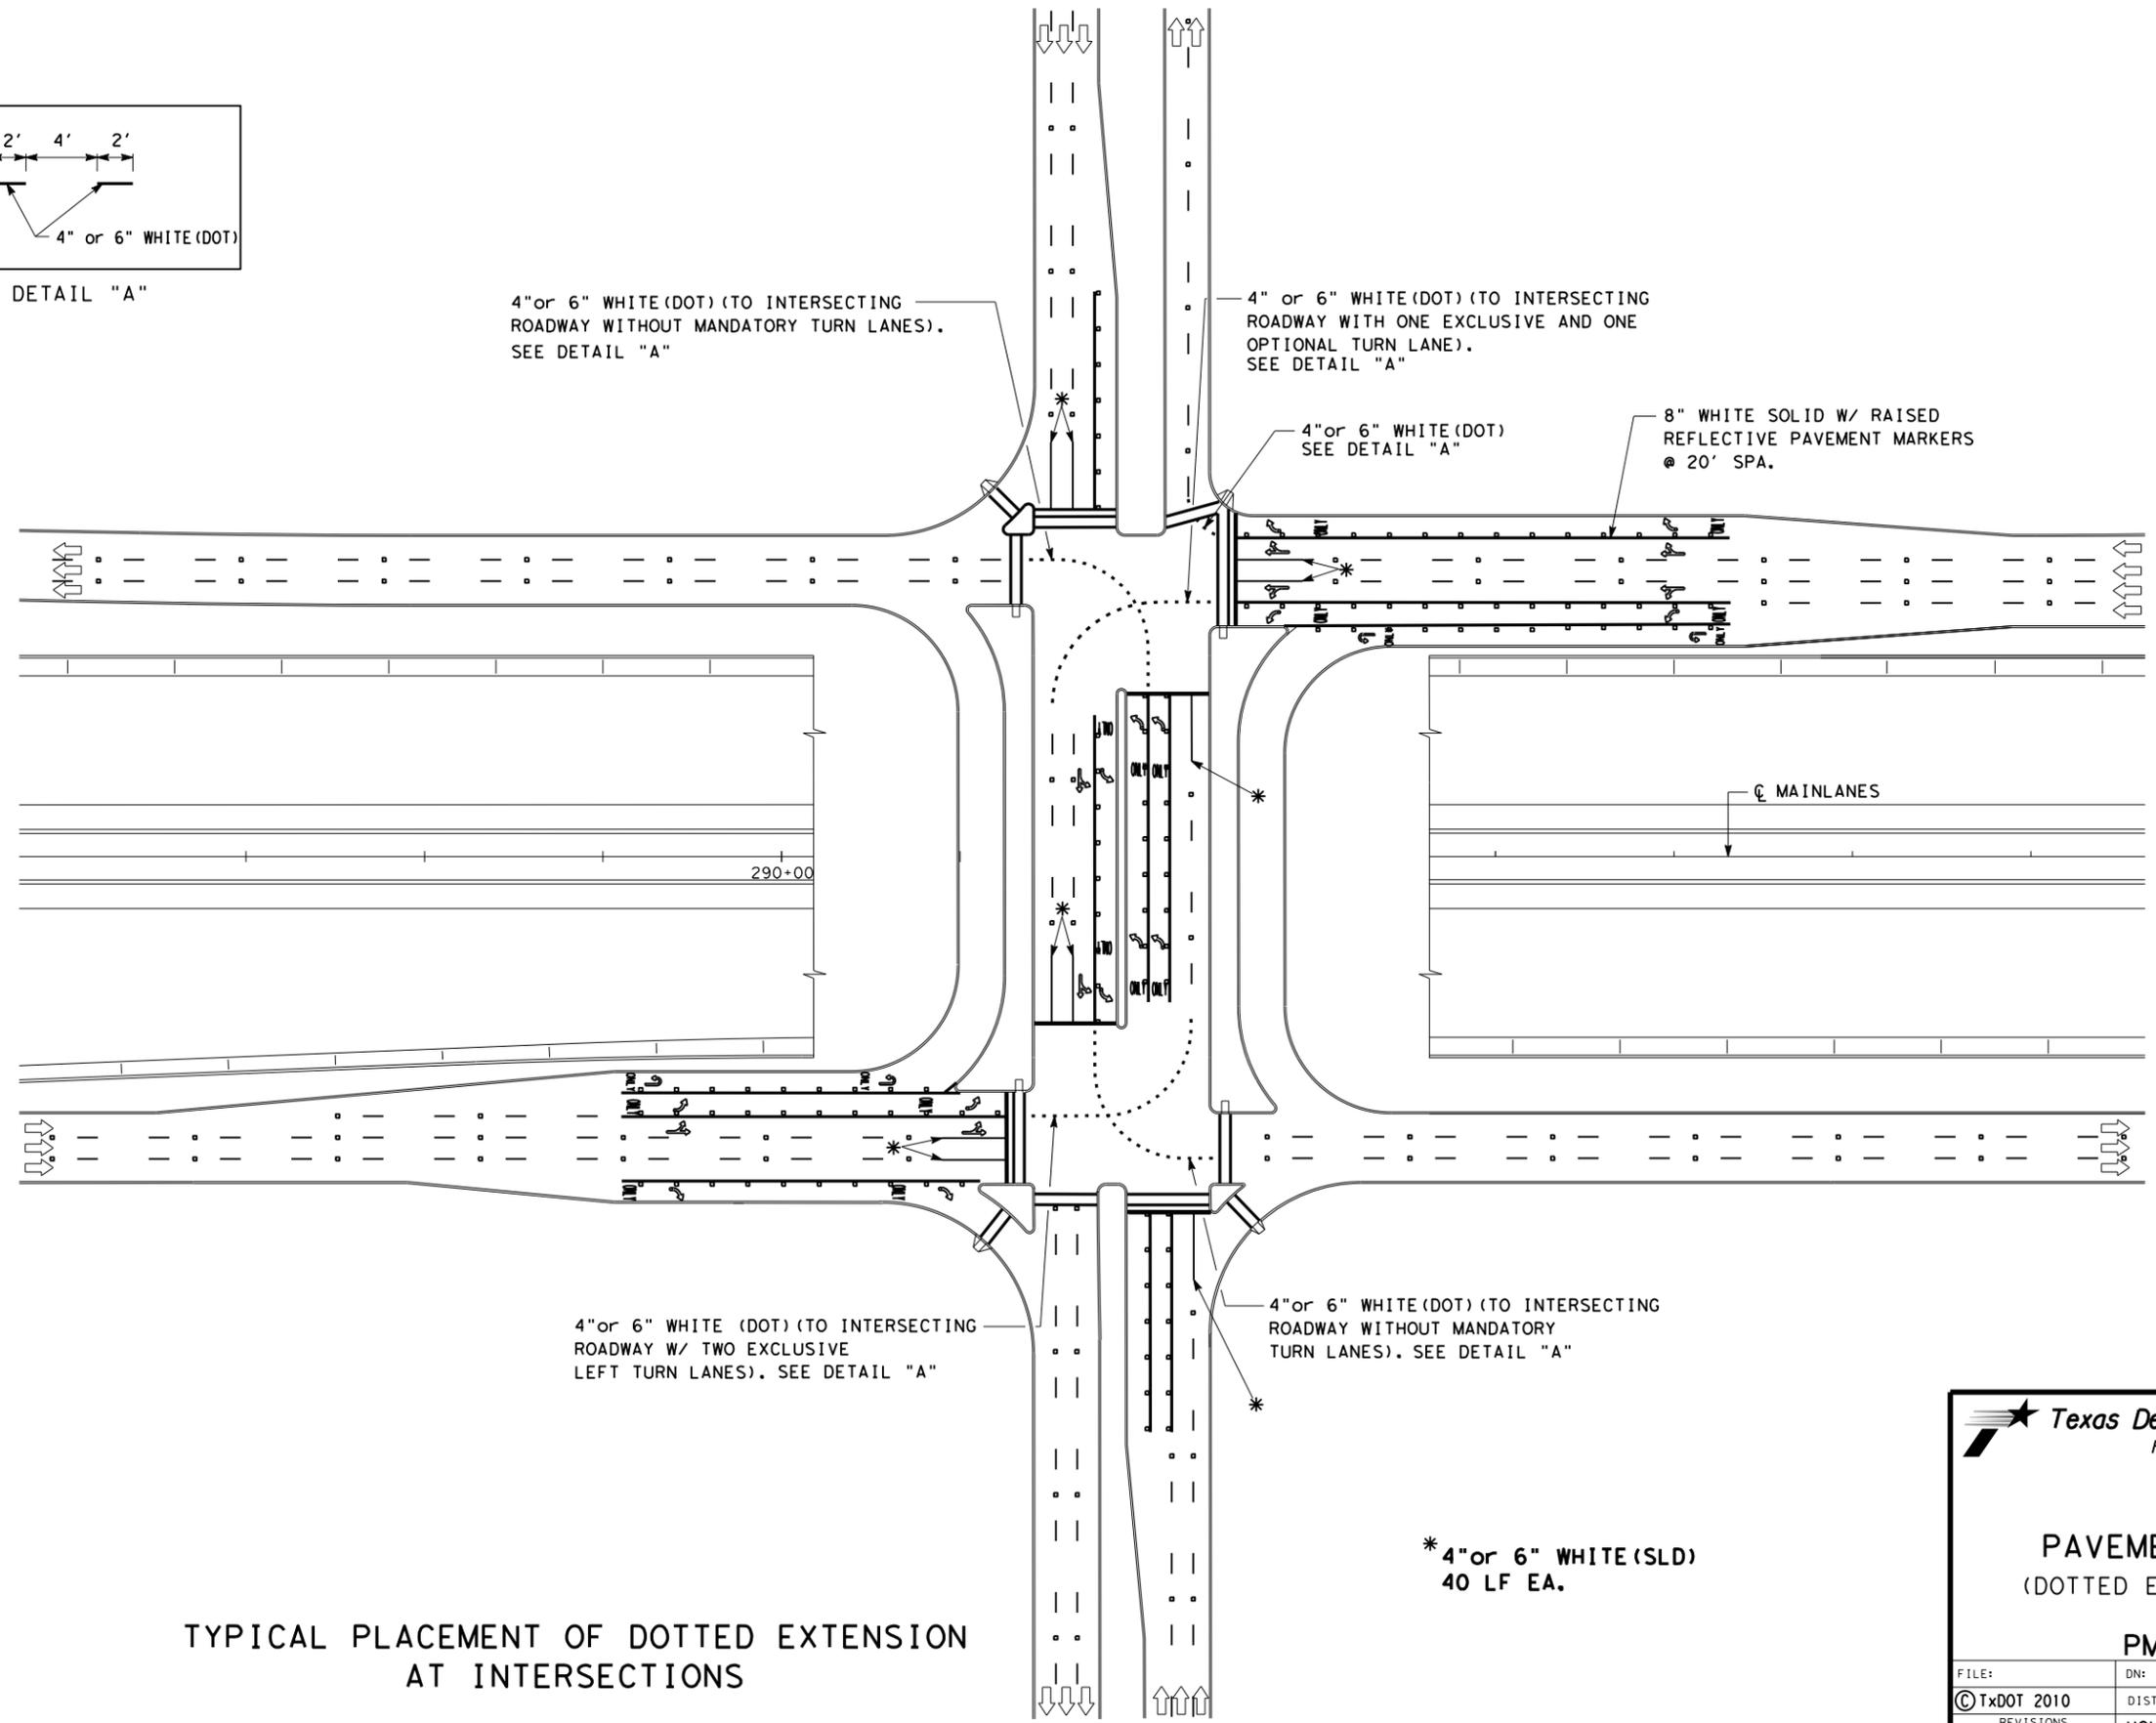

4" or 6" WHITE (DOT) (TO INTERSECTING ROADWAY WITHOUT MANDATORY TURN LANES). SEE DETAIL "A"

4" or 6" WHITE (DOT) (TO INTERSECTING ROADWAY WITH ONE EXCLUSIVE AND ONE OPTIONAL TURN LANE). SEE DETAIL "A"

4" or 6" WHITE (DOT) SEE DETAIL "A"

8" WHITE SOLID W/ RAISED REFLECTIVE PAVEMENT MARKERS @ 20' SPA.

☉ MAINLANES

290+00

4" or 6" WHITE (DOT) (TO INTERSECTING ROADWAY W/ TWO EXCLUSIVE LEFT TURN LANES). SEE DETAIL "A"

4" or 6" WHITE (DOT) (TO INTERSECTING ROADWAY WITHOUT MANDATORY TURN LANES). SEE DETAIL "A"

* 4" or 6" WHITE (SLD) 40 LF EA.

TYPICAL PLACEMENT OF DOTTED EXTENSION AT INTERSECTIONS



PAVEMENT MARKINGS (DOTTED EXTENSION DETAILS)

PM(DOT) - 11

FILE:	DN:	CK:	DW:	CK:
© TxDOT 2010	DIST	FED REG	PROJECT NO.	SHEET
REVISIONS	HOU	6		66
4/2010	COUNTY	CONTROL	SECT	JOB
4/2011	HARRIS	0111	01	095
				HIGHWAY
				FM 521

DISCLAIMER: The use of this standard is governed by the "Texas Engineering Practice Act". No warranty of any kind is made by TxDOT for any purpose whatsoever. TxDOT assumes no responsibility for the conversion of this standard to other formats or for incorrect results or damages resulting from its use.

SIGN SUPPORT DESCRIPTIVE CODES

(Descriptive Codes correspond to project estimate and quantities sheets)

SM RD SGN ASSM TY XXXXX(X)XX(X-XXXX)

Post Type

FRP = Fiberglass Reinforced Plastic Pipe (see SMD(FRP))
 TWT = Thin-Walled Tubing (see SMD(TWT))
 10BWG = 10 BWG Tubing (see SMD(SLIP-1) to (SLIP-3))
 S80 = Schedule 80 Pipe (see SMD(SLIP-1) to (SLIP-3))

Number of Posts (1 or 2)


Anchor Type

UA = Universal Anchor - Concreted (see SMD(FRP) and (TWT))
 UB = Universal Anchor - Bolted down (see SMD(FRP) and (TWT))
 WS = Wedge Anchor Steel - (see SMD(TWT))
 WP = Wedge Anchor Plastic (see SMD(TWT))
 SA = Slipbase - Concreted (see SMD(SLIP-1) to (SLIP-3))
 SB = Slipbase - Bolted Down (see SMD(SLIP-1) to (SLIP-3))

Sign Mounting Designation

P = Prefab. "Plain" (see SMD(SLIP-1) to (SLIP-3), (TWT), (FRP))
 T = Prefab. "T" (see SMD(SLIP-1) to (SLIP-3), (TWT))
 U = Prefab. "U" (see SMD(SLIP-1) to (SLIP-3))
 IF REQUIRED
 1EXT or 2EXT = Number of Extensions (see SMD(SLIP-1) to (SLIP-3), (TWT))
 BM = Extruded Wind Beam (see SMD(SLIP-1) to (SLIP-3))
 WC = 1.12 #/ft Wing Channel (see SMD(SLIP-1) to (SLIP-3))
 EXAL = Extruded Aluminum Sign Panels (see SMD(SLIP-3))


REQUIRED CLEARANCE FOR BREAKAWAY SUPPORT

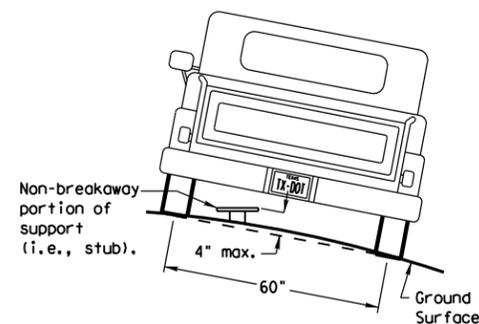

To avoid vehicle undercarriage snagging, any substantial remains of a breakaway support, when it is broken away, should not project more than 4 inches above a 60-inch chord (i.e., typical space between wheel paths).


SIGN LOCATION

PAVED SHOULDERS

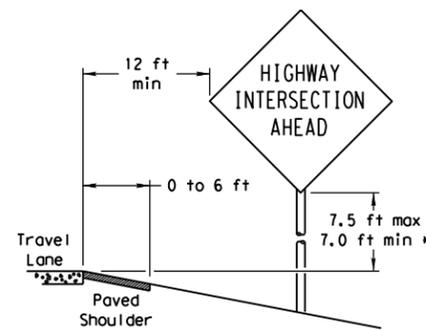

LESS THAN 6 FT. WIDE


When the shoulder is 6 ft. or less in width, the sign must be placed at least 12 ft. from the edge of the travel lane.

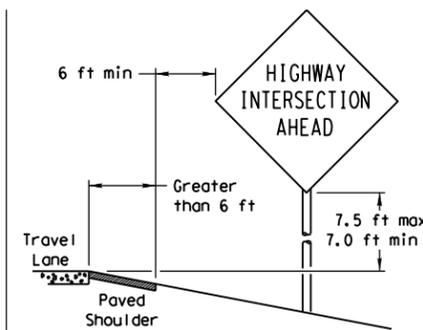

GREATER THAN 6 FT. WIDE


When the shoulder is greater than 6 ft in width, the sign must be placed at least 6 ft. from the edge of the shoulder.

T-INTERSECTION

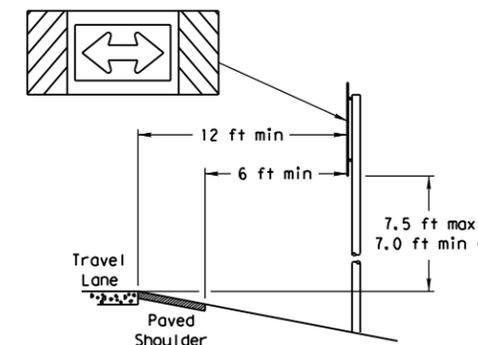


When this sign is needed at the end of a two-lane, two way roadway, the right edge of the sign should be in line with the centerline of the roadway. Place as close to ROW as practical.

No more than 2 sign posts should be located within a 7 ft. circle.

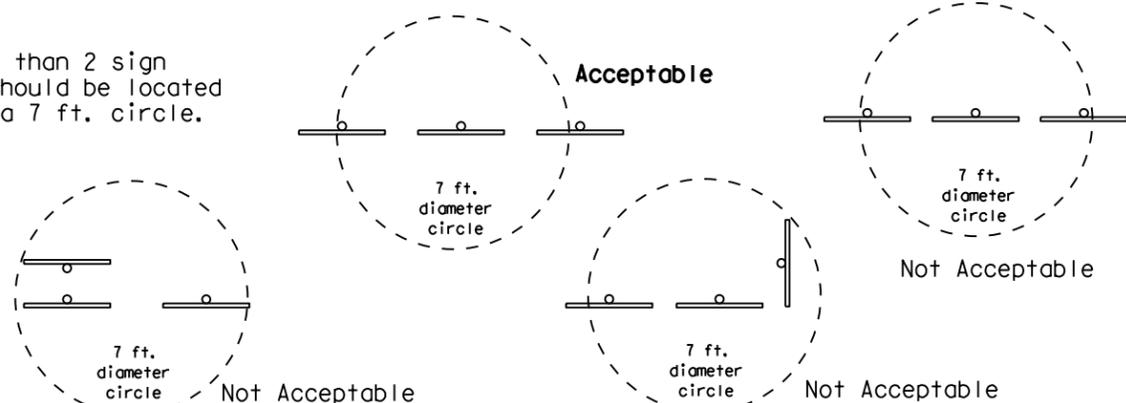


BEHIND BARRIER

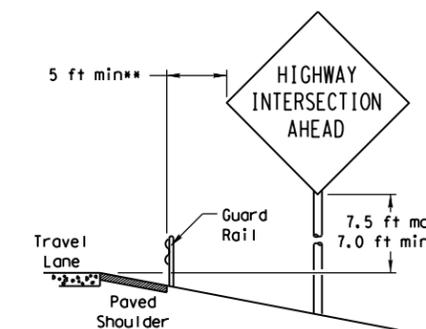


BEHIND GUARDRAIL

**Sign clearance based on distance required for proper guard rail or concrete barrier performance.

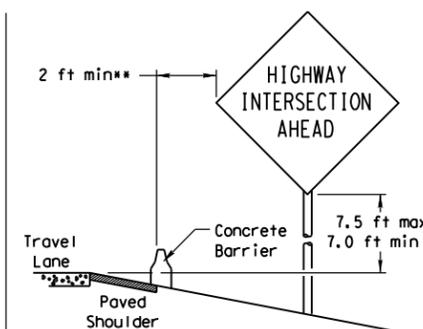

BEHIND CONCRETE BARRIER

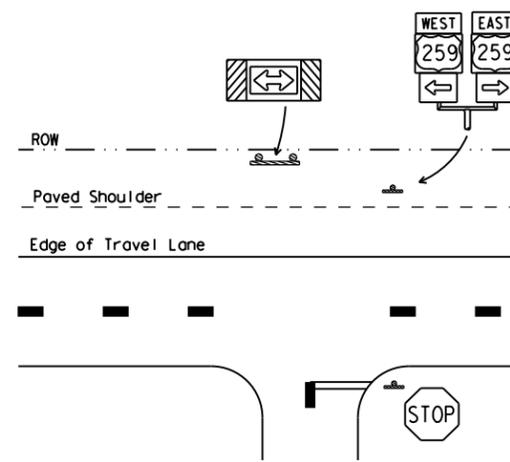

* Signs shall be mounted using the following condition that results in the greatest sign elevation:


- (1) a minimum of 7 to a maximum of 7.5 feet above the edge of the travel lane or
- (2) a minimum of 7 to a maximum of 7.5 feet above the grade at the base of the support when sign is installed on the backslope.

The maximum values may be increased when directed by the Engineer.

See the Traffic Operations Division website for detailed drawings of sign clamps, Triangular Slipbase System components and Wedge Anchor System components.

The website address is:
<http://www.txdot.gov/publications/traffic.htm>

TYPICAL SIGN ATTACHMENT DETAIL

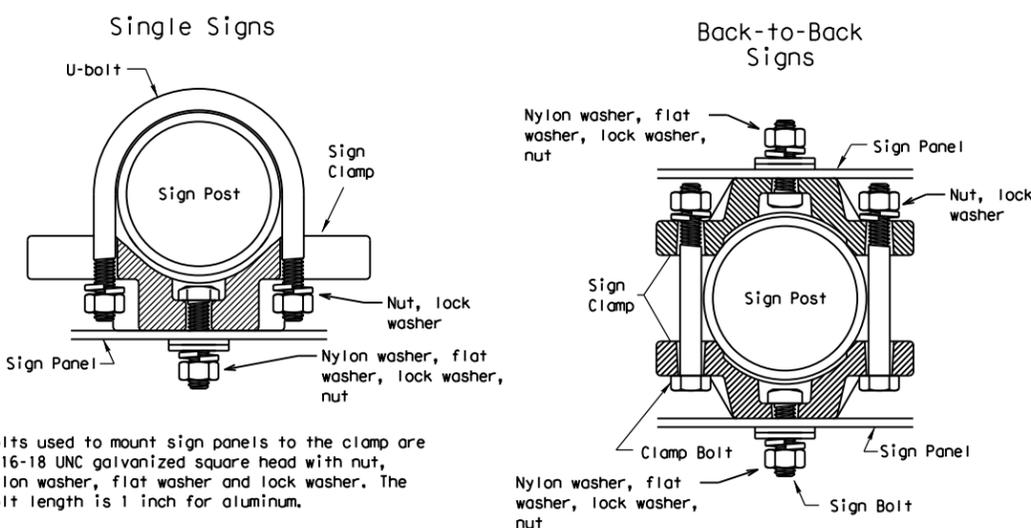


Bolts used to mount sign panels to the clamp are 5/16-18 UNC galvanized square head with nut, nylon washer, flat washer and lock washer. The bolt length is 1 inch for aluminum.

When two sign clamps are used to mount signs back-to-back, use a 5/16-18 UNC galvanized hex head per ASTM A307 with nut and helical-spring lock washer. The approximate bolt lengths for various post sizes and sign clamp types are given in the table at right. The bolt length may need to be adjusted depending upon field conditions.

Sign clamps may be either the specific size clamp or the universal clamp.


Pipe Diameter	Approximate Bolt Length	
	Specific Clamp	Universal Clamp
2" nominal	3"	3 or 3 1/2"
2 1/2" nominal	3 or 3 1/2"	3 1/2 or 4"
3" nominal	3 1/2 or 4"	4 1/2"

SIGNS WITH PLAQUES

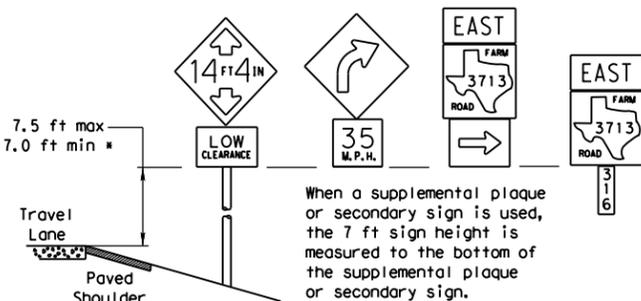


When a supplemental plaque or secondary sign is used, the 7 ft sign height is measured to the bottom of the supplemental plaque or secondary sign.

CURB & GUTTER OR RAISED ISLAND

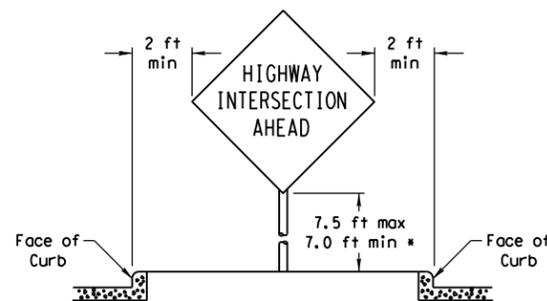

RESTRICTED RIGHT-OF-WAY (When 6 ft min. is not possible.)

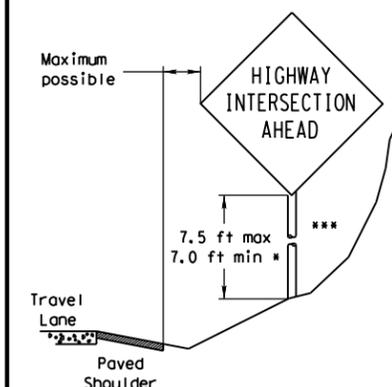

Right-of-way restrictions may be created by rocks, water, vegetation, forest, buildings, a narrow island, or other factors.

In situations where a lateral restriction prevents the minimum horizontal clearance from the edge of the travel lane, signs should be placed as far from the travel lane as practical.

*** Post may be shorter if protected by guardrail or if Engineer determines the post could not be hit due to extreme slope.

Texas Department of Transportation
 Traffic Operations Division


SIGN MOUNTING DETAILS SMALL ROADSIDE SIGNS GENERAL NOTES & DETAILS

SMD(GEN)-08


© TxDOT July 2002		DN: TxDOT	CK: TxDOT	DW: TxDOT	CK: TxDOT
9-08	REVISIONS	CONT	SECT	JOB	HIGHWAY
		0111	01	095	FM 521
		DIST	COUNTY		SHEET NO.
		HOU	HARRIS		67

DISCLAIMER: The use of this standard is governed by the "Texas Engineering Practice Act". No warranty of any kind is made by TxDOT for any purpose whatsoever. TxDOT assumes no responsibility for the conversion of this standard to other formats or for incorrect results or damages resulting from its use.



Wedge Anchor Steel System

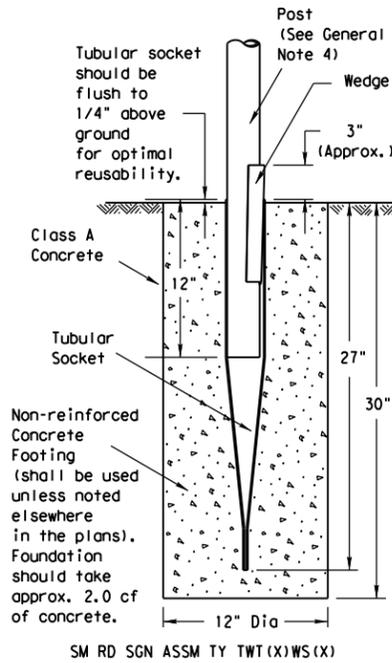


Wedge Anchor High Density Polyethylene (HDPE) System

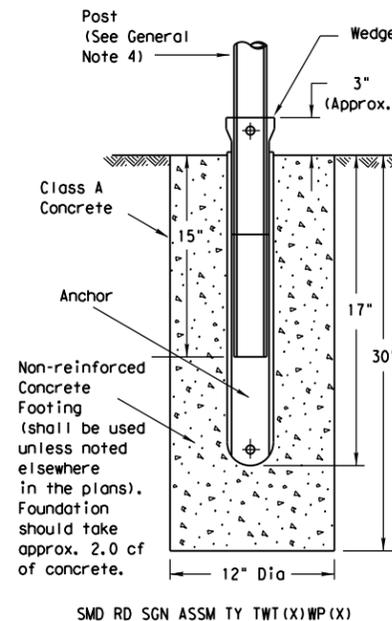


Universal Anchor System with Thin-Walled Tubing Post

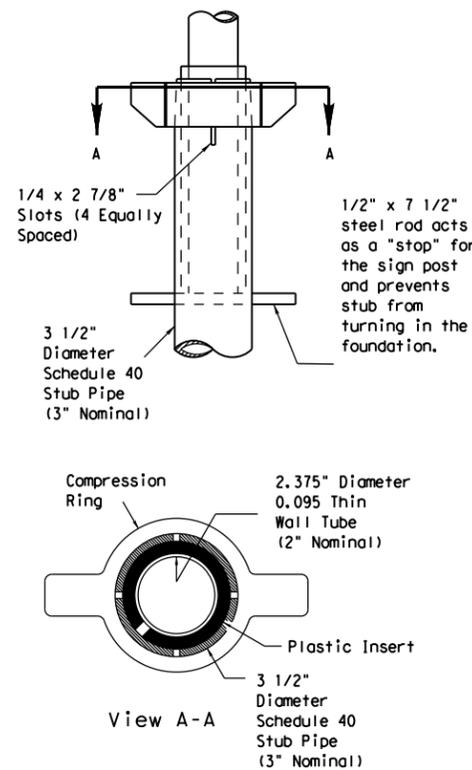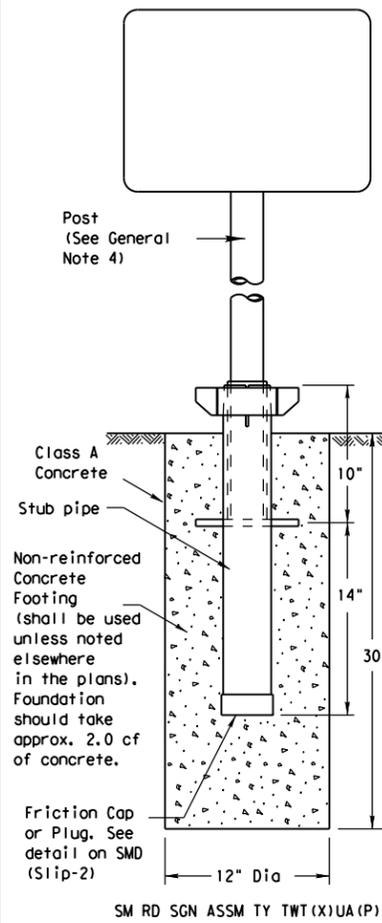



Plastic insert must be used when using the TWT with either the Universal Anchor System or the Bolt Down Universal Anchor System. The insert should be approx. 10" long and cover the tubing from just above the top of the stub pipe to the bottom of the sign post when using the Universal Anchor System. The insert should be cut to approx. 4 1/2" when used with the Bolt Down Universal Anchor System.

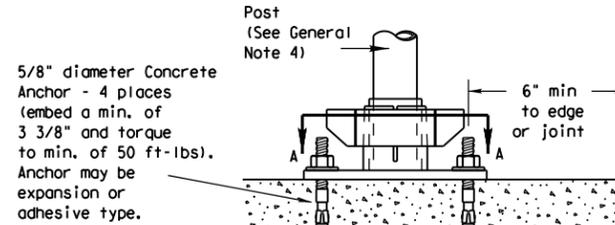

Concrete anchor consists of 5/8" diameter stud bolt with UNC series bolt threads on the upper end. A heavy hex nut per ASTM A563 and hardened washer per ASTM F436. The stud bolt shall have minimum yield and ultimate tensile strengths of 50 and 75 ksi, respectively. Nuts, bolts and washers shall be galvanized per Item 445, "Galvanizing." Top of bolt shall extend at least flush with top of nut when installed. The anchor, when installed in 4000 psi normal-weight concrete with a 3 3/8" minimum embedment, shall have a minimum allowable tension and shear of 2450 and 1525 psi, respectively. Adhesive type anchors shall have stud bolts installed with Type III epoxy per DMS-6100, "Epoxy and Adhesives." Adhesive anchors may be loaded after adequate epoxy cure time per the manufacturer's recommendations.

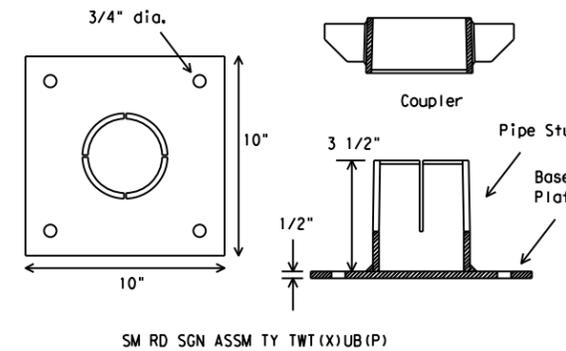

Sign Installation Using a Prefabricated T-Bracket for Thin-Wall Tubing Post

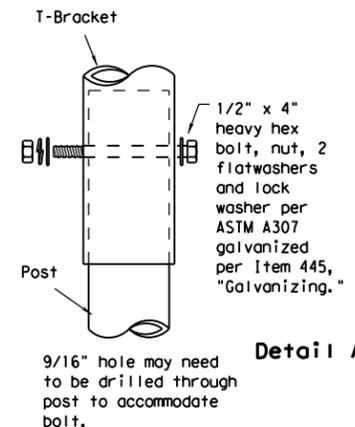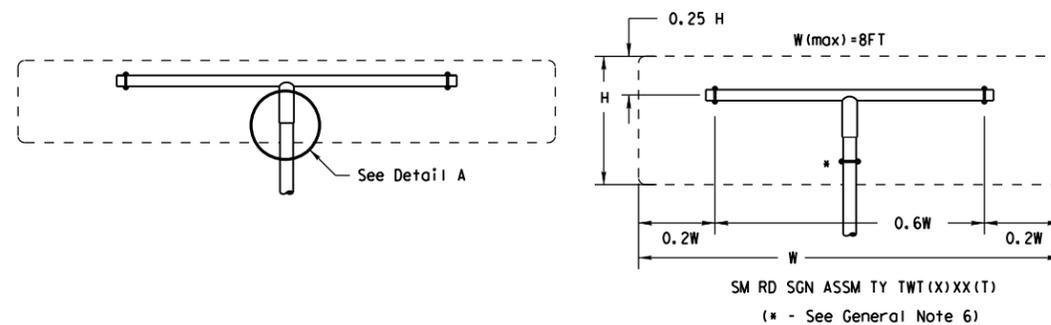

NOTE
The devices shall be installed per manufacturer's recommendations. Installation procedures shall be provided to the Engineer by Contractor.

- GENERAL NOTES:
- The Wedge Anchor System and the Universal Anchor System with thin wall tubing post may be used to support up to 10 square feet of sign area.
 - The tubular socket, wedge and prefabricated T-bracket shall be permanently marked to indicate manufacturer. Method, design, and location of marking are subject to the approval of the TxDOT Traffic Standards Engineer.
 - Except for posts (13 BWG Tubing), clamps, nuts and bolts, all components shall be prequalified. A list of prequalified vendors may be obtained from the Material Producer List web page. The website address is: http://www.txdot.gov/business/producer_list.htm
 - Material used as post with this system shall conform to the following specifications:
13 BWG Tubing (2.375" outside diameter) (TWT)
0.095" nominal wall thickness
Seamless or electric-resistance welded steel tubing
Steel shall be HSLA Gr 55 per ASTM A1011 or ASTM A1008
Other steels may be used if they meet the following:
55,000 PSI minimum yield strength
70,000 PSI minimum tensile strength
18% minimum elongation in 2"
Wall thickness (uncoated) shall be within the range of .083" to .099"
Outside diameter (uncoated) shall be within the range of 2.369" to 2.381"
Galvanization per ASTM 123 or ASTM A653 G210. For precoated steel tubing (ASTM A653), recoat tube outside diameter weld seam by metallizing with zinc wire per ASTM B833.
 - Sign blanks shall be the sizes and shapes shown on the plans.
 - Additional sign clamp required on the "T-bracket" post for 24" high signs. Place clamp at least 3" above bottom of sign when possible.
 - Sign supports shall not be spliced except where shown. Sign support posts shall not be spliced.
 - See the Traffic Operations Division website for detailed drawings of sign clamps and Wedge Anchor System components. The website address is: <http://www.txdot.gov/publications/traffic.htm>

- WEDGE ANCHOR SYSTEM INSTALLATION PROCEDURE
- Dig foundation hole. Where solid rock is encountered at ground level, the foundation shall be a minimum depth of 18". When solid rock is encountered below ground level, the foundation shall extend in the solid rock a minimum depth of 18" or provide a minimum foundation depth of 30". If solid rock is encountered, the socket/stub may be reduced in length as required to a minimum length of 18". Any material removed from the socket/stub shall be from the bottom and the clearance requirements given on SMD(GEN) must be followed. The inner surfaces of the socket/stub must remain free of concrete or other debris.
 - The Engineer may permit batches of concrete less than 2 cubic yards to be mixed with a portable, motor driven concrete mixer. For small placements less than 0.5 cubic yards, hand mixing in a suitable container may be allowed by Engineer. Place concrete into hole until it is approximately flush with the ground. Concrete shall be Class A.
 - Insert tubular socket into concrete until top of socket is approximately 1/4" above the concrete footing.
 - Plumb the socket. Allow a minimum 4 days for concrete to set, unless otherwise directed by Engineer.
 - Attach the sign to the sign post.
 - Insert the sign post into socket and align sign face with roadway.
 - Drive the wedge into the socket to secure post. This will leave approximately 3 inches of the wedge exposed.

- UNIVERSAL ANCHOR SYSTEM INSTALLATION PROCEDURE
- Dig foundation hole. Where solid rock is encountered at ground level, the foundation shall be a minimum depth of 18". When solid rock is encountered below ground level, the foundation shall extend in the solid rock a minimum depth of 18" or provide a minimum foundation depth of 30". If solid rock is encountered, the socket/stub may be reduced in length as required to a minimum length of 18". Any material removed from the socket/stub shall be from the bottom and the clearance requirements given on SMD(GEN) must be followed. The inner surfaces of the socket/stub must remain free of concrete or other debris.
 - Insert base post in hole to depths shown and backfill hole with concrete.
 - Level and plumb the base post using a torpedo level and allow concrete adequate time to set. The bottom of the slots provided in the stub pipe shall remain above the top of the concrete foundation.
 - Attach the sign to the sign post.
 - Install plastic insert around bottom of post.
 - Insert sign post into base post. Lower until the post comes to rest on steel rod.
 - Seat compression ring using a hammer. Typically, the top of compression ring will be approximately level with top of stub post when optimally installed.
 - Check sign post by hand to ensure it is unable to turn. If loose, increase the tightening of the compression ring.

Texas Department of Transportation
Traffic Operations Division

SIGN MOUNTING DETAILS SMALL ROADSIDE SIGNS WEDGE & UNIVERSAL ANCHOR WITH THIN WALL TUBING POST SMD (TWT) -08

© TxDOT July 2002	DN: TxDOT	CK: TxDOT	DW: TxDOT	CK: TxDOT
9-08	REVISIONS	CONT	SECT	JOB
		0111	01	095
		DIST	COUNTY	HIGHWAY
		HOU	HARRIS	FM 521
				SHEET NO.
				68


DATE:
FILE:

DISCLAIMER: The use of this standard is governed by the "Texas Engineering Practice Act". No warranty of any kind is made by TxDOT for any purpose whatsoever. TxDOT assumes no responsibility for the conversion of this standard to other formats or for incorrect results or damages resulting from its use.

DATE: FILE:

REQUIREMENTS FOR RED BACKGROUND REGULATORY SIGNS

(STOP, YIELD, DO NOT ENTER AND WRONG WAY SIGNS)

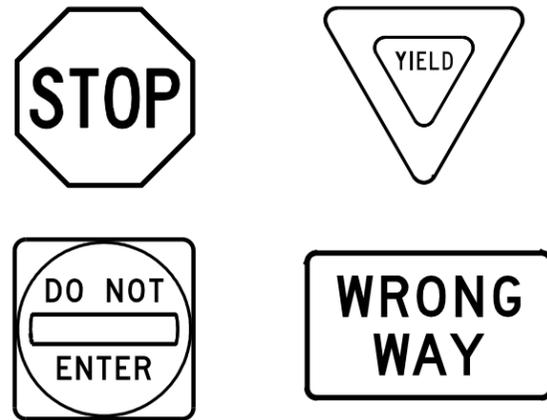

REQUIREMENTS FOR FOUR SPECIFIC SIGNS ONLY

SHEETING REQUIREMENTS		
USAGE	COLOR	SIGN FACE MATERIAL
BACKGROUND	RED	TYPE B OR C SHEETING
BACKGROUND	WHITE	TYPE B OR C SHEETING
LEGEND & BORDERS	WHITE	TYPE B OR C SHEETING
LEGEND	RED	TYPE B OR C SHEETING

REQUIREMENTS FOR WHITE BACKGROUND REGULATORY SIGNS


(EXCLUDING STOP, YIELD, DO NOT ENTER AND WRONG WAY SIGNS)



TYPICAL EXAMPLES

SHEETING REQUIREMENTS		
USAGE	COLOR	SIGN FACE MATERIAL
BACKGROUND	WHITE	TYPE A SHEETING
BACKGROUND	ALL OTHERS	TYPE B OR C SHEETING
LEGEND, BORDERS AND SYMBOLS	BLACK	ACRYLIC NON-REFLECTIVE FILM
LEGEND, BORDERS AND SYMBOLS	ALL OTHER	TYPE B OR C SHEETING

REQUIREMENTS FOR WARNING SIGNS

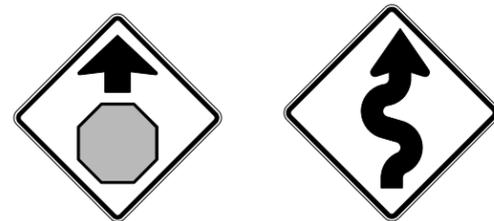

TYPICAL EXAMPLES

SHEETING REQUIREMENTS		
USAGE	COLOR	SIGN FACE MATERIAL
BACKGROUND	FLOURESCENT YELLOW	TYPE B _{FL} OR C _{FL} SHEETING
LEGEND & BORDERS	BLACK	ACRYLIC NON-REFLECTIVE FILM
LEGEND & SYMBOLS	ALL OTHER	TYPE B OR C SHEETING

REQUIREMENTS FOR SCHOOL SIGNS



TYPICAL EXAMPLES

SHEETING REQUIREMENTS		
USAGE	COLOR	SIGN FACE MATERIAL
BACKGROUND	WHITE	TYPE A SHEETING
BACKGROUND	FLOURESCENT YELLOW GREEN	TYPE B _{FL} OR C _{FL} SHEETING
LEGEND, BORDERS AND SYMBOLS	BLACK	ACRYLIC NON-REFLECTIVE FILM
SYMBOLS	RED	TYPE B OR C SHEETING

GENERAL NOTES

- Signs to be furnished shall be as detailed elsewhere in the plans and/or as shown on sign tabulation sheet. Standard sign designs and arrow dimensions can be found in the "Standard Highway Sign Designs for Texas" (SHSD).
- Sign legend shall use the Federal Highway Administration (FHWA) Standard Highway Alphabets (B, C, D, E, Emod or F).
- Lateral spacing between letters and numerals shall conform with the SHSD, and any approved changes thereto. Lateral spacing of legend shall provide a balanced appearance when spacing is not shown.
- Black legend and borders shall be applied by screening process or cut-out acrylic non-reflective black film to background sheeting, or combination thereof.
- White legend and borders shall be applied by screening process with transparent colored ink, transparent colored overlay film to white background sheeting or cut-out white sheeting to colored background sheeting, or combination thereof.
- Colored legend shall be applied by screening process with transparent colored ink, transparent colored overlay film or colored sheeting to background sheeting, or combination thereof.
- Sign substrate shall be any material that meets the Departmental Material Specification requirements of DMS-7110 or approved alternative.
- Mounting details for roadside mounted signs are shown in the "SMD series" Standard Plan Sheets.

ALUMINUM SIGN BLANKS THICKNESS

Square Feet	Minimum Thickness
Less than 7.5	0.080
7.5 to 15	0.100
Greater than 15	0.125

DEPARTMENTAL MATERIAL SPECIFICATIONS

ALUMINUM SIGN BLANKS	DMS-7110
SIGN FACE MATERIALS	DMS-8300

The Standard Highway Sign Designs for Texas (SHSD) can be found at the following website.

<http://www.txdot.gov/>



TYPICAL SIGN REQUIREMENTS

TSR(4) - 13

FILE:	tsr4-13.dgn	DN:	TxDOT	CK:	TxDOT	DW:	TxDOT	CR:	TxDOT
© TxDOT	October 2003	CONT	SECT	JOB	HIGHWAY				
REVISIONS		0111	01	095	FM 521				
12-03	7-13	DIST	COUNTY	SHEET NO.					
9-08		HOU	HARRIS	69					

NOTES:

1. LOCATE DETECTORS , ETC., AS APPROVED.
2. REPAIR OR REPLACE PAVEMENT AND SIDEWALKS DAMAGED BY THE CONTRACTOR'S FORCES DURING CONSTRUCTION AT NO COST TO THE DEPARTMENT.
3. FURNISH AND INSTALL URETHANE FOAM TO ENCLOSE THE ENDS OF EACH CONDUIT CONTAINING SIGNAL CABLE.
4. INSTALL EACH LOOP DETECTOR IN A SEPARATE SAW CUT FROM THE DETECTOR TO THE EDGE OF ROADWAY. INSTALL EACH LOOP DETECTOR RUN IN A SEPARATE CONDUIT (SIZE AS REQUIRED) FROM THE EDGE OF ROADWAY TO A GROUND BOX AS SHOWN ON THE PLAN LAYOUT.
5. PROVIDE CONTINUED OPERATION OF THE EXISTING SIGNAL(S) DURING CONSTRUCTION AND UNTIL THE PROPOSED OPERATION IS COMPLETED.
6. ONCE THE INTEGRITY AND/OR FUNCTION OF THE EXISTING TRAFFIC SIGNAL(S) IS ALTERED BY THE CONTRACTOR, MAINTAIN AND OPERATE THE EXISTING TRAFFIC SIGNAL(S) UNTIL THE TRAFFIC SIGNAL WORK IS ACCEPTED BY THE DEPARTMENT. DURING THE CONSTRUCTION OF THE PROPOSED TRAFFIC SIGNAL WORK, MAINTAIN THE EXISTING TRAFFIC SIGNAL(S) AND/OR TEMPORARY CONSTRUCTION TRAFFIC SIGNAL(S) IN CONFORMANCE WITH THE LATEST TEXAS MANUAL ON UNIFORM TRAFFIC CONTROL DEVICES.
7. DURING CONSTRUCTION OF THE PROPOSED SIGNAL WORK, IF THE EXISTING TRAFFIC SIGNAL EQUIPMENT REQUIRES REPLACEMENT DUE TO WEAR, DETERIORATION, OR ANY CIRCUMSTANCE OVER WHICH THE CONTRACTOR HAS NO CONTROL, THE EQUIPMENT WILL BE FURNISHED BY THE STATE OR CITY OF HOUSTON AT NO COST TO THE CONTRACTOR AND SHALL BE INSTALLED BY THE CONTRACTOR. NO EXTRA COMPENSATION WILL BE ALLOWED TO THE CONTRACTOR FOR THIS WORK.
8. MAINTAIN THE INTEGRITY AND FUNCTION OF EACH EXISTING SIGNALIZED INTERSECTION. ONCE THE INTEGRITY OR FUNCTION OF THE SIGNAL HAS BEEN ALTERED, PURSUE THE WORK AT THAT LOCATION WITHOUT DELAY OR INTERRUPTION TO RESTORE OPERATION TO ITS ORIGINAL OR FINAL OPERATIONAL DESIGN.
9. ONLY NEW CONDUIT AND CABLE SHALL BE INSTALLED.
10. CONDUIT INSTALLED UNDER EXISTING PAVED DRIVEWAYS, ROADWAYS OR SIDEWALKS, WHICH ARE NOT SCHEDULED TO BE RECONSTRUCTED AS PART OF THIS PROJECT, SHALL BE INSTALLED BY MEANS OF BORING. THE CONTRACTOR SHALL NOT CUT OPEN ANY STREET OR DRIVEWAY FOR CONDUIT INSTALLATION WITHOUT THE PRIOR APPROVAL OF THE ENGINEER AND/OR THE APPROVED CITY OF HOUSTON REPRESENTATIVE.
11. CONDUIT NOT PLACED UNDER PAVED DRIVEWAYS, ROADWAY PAVEMENT OR SIDEWALK MAY BE PLACED BY CUTTING A TRENCH, INSTALLING THE CONDUIT AND BACKFILLING. ANY TRENCHING FOR CONDUIT WIDER THAN THREE (3) INCHES SHALL BE RESODDED.
12. PULL BOXES SHALL NOT BE INSTALLED WITHIN CONCRETE CURB ACCESS RAMPS. IN ADDITION, ANY PULL BOXES INSTALLED BEHIND CURBS SHALL BE INSTALLED BETWEEN THE CURB AND THE PROPOSED/FUTURE SIDEWALK OR BEYOND THE PROPOSED/FUTURE SIDEWALK. AN EXCEPTION TO THIS NOTE WOULD BE PULL BOXES INSTALLED IN A MEDIAN. ANY PULL BOXES INSTALLED ALONG AN UNCURBED ROADWAY SHALL BE INSTALLED ADJACENT TO, BUT NOT WITHIN, THE SHOULDER.
13. ALL CONDUITS SHALL BE CLEANED BY COMPRESSED AIR AND A PROPERLY SIZED CONDUIT PISTON OR MANDREL SHALL BE PULLED THROUGH THE CONDUIT PRIOR TO CABLE INSTALLATION.
14. WHEN PULLING TRAFFIC SIGNAL SYSTEM CABLES THROUGH CONDUIT, THE CABLES SHALL BE LUBRICATED WITH A LUBRICANT NORMALLY USED FOR THIS PURPOSE. ANY ABRASION TO ANY CONDUCTOR INSULATION WHICH OCCURS WHILE PULLING CABLE FOR THE TRAFFIC SIGNAL SYSTEM WILL BE CAUSE FOR THE IMMEDIATE REJECTION OF THE CABLE. IF THIS OCCURS, THE CONTRACTOR SHALL REMOVE AND REPLACE THE ENTIRE CABLE RUN AT THEIR EXPENSE.

15. A MINIMUM OF THREE (3) FEET OF EACH WIRE AND CABLE MEASURED FROM THE TOP OF THE PULL BOX SHALL BE LEFT IN EACH PULL BOX AND AT EACH POLE BASE.
16. NO LOOP DETECTOR SHALL BE CUT IN PARALLEL EXPANSION JOINT. LOOPS CUT ACROSS EXPANSION JOINTS SHALL HAVE A SLACK IN THE CABLE FOR EXPANSION.
17. DETECTION LOOP SAW CUTS SHALL BE FLUSHED WITH WATER UNDER PRESSURE AND THEN DRIED WITH AIR UNDER PRESSURE.
18. THERE SHALL BE NO SPLICING IN CONDUCTORS EXCEPT FOR THE NECESSARY SPLICE BETWEEN ROADWAY LOOP WIRE AND DETECTOR LEAD-IN CABLE IN THE PULL BOX ADJACENT TO THE DETECTOR. THESE SPLICES SHALL BE WATERPROOF AND SHALL BE MADE BY THE CONTRACTOR. DO NOT GROUND THE CABLE SHIELD AT THE PULL BOX.
19. THE LOCATION OF EACH NEW PULL BOX SHALL BE MARKED IN THE FIELD AS SHOWN ON THE PLANS. THE EXACT LOCATION SHALL BE APPROVED BY THE ENGINEER AND/OR THE APPROVED CITY OF HOUSTON REPRESENTATIVE PRIOR TO BEGINNING INSTALLATION OF THE FOUNDATION.
20. THE HIGH VOLTAGE CABLES SHOULD BE SEPARATED FROM THE LOW VOLTAGE CABLES AS MUCH AS POSSIBLE.
21. ALL VEHICLE ROADWAY DETECTION LOOP CABLES SHALL BE #14 AWG IMSA 51-5-1985 CABLE. LEAD-IN CABLES SHALL BE #14 AWG IMSA 50-2-1984 CABLE. NO SPLICES SHALL BE ALLOWED IN THE ROADWAY DETECTION LOOP CABLE EXCEPT AT THE PULL BOX ADJACENT TO THE LOOP. THE DETECTOR LEAD-IN CABLE SHALL NOT BE SPLICED.
22. ALL ELECTRICAL WORK DONE SHALL BE IN CONFORMANCE WITH CURRENT EDITION OF THE NATIONAL ELECTRICAL CODE (NEC).
23. UNLESS OTHERWISE SHOWN ON THE PLANS, UNDERGROUND CONDUIT SHALL BE INSTALLED A MINIMUM OF 24 INCHES DEEP. INSTALLATION OF CONDUIT SHALL BE IN ACCORDANCE WITH THE CURRENT EDITION OF THE NATIONAL ELECTRICAL CODE (NEC). CONDUIT PLACED UNDER DRIVEWAYS AND/OR ROADWAYS SHALL BE PLACED A MINIMUM OF 24 INCHES BELOW PAVEMENT SURFACE.
24. THE CONTRACTOR SHALL PERMIT THE ELECTRICAL WORK TO BE INSPECTED BY THE STATE AND CITY FOR COMPLIANCE WITH THE PLANS AND SPECIFICATIONS.



09/17/2020





FM 521
NOTES FOR
PROPOSED LAYOUT
AT HOLLY HALL
INTERSECTION

FED. RD. DIV. NO.	PROJECT NO.		SHEET NO.
6			70
STATE	DIST	COUNTY	
TEXAS	HOU	HARRIS	
CONT	SECT	JOB	HIGHWAY
0111	01	095	FM 521

LEGEND:

-  DIRECTION OF TRAFFIC FLOW
-  EXIST. POWER POLE
-  EXIST. OVERHEAD LINE
-  EXIST. TRAFFIC SIGNAL CONTROLLER
-  EXIST. GROUND BOX
-  EXIST. MAST ARM TRAFFIC SIGNAL POLE
-  EXIST. TRAFFIC SIGNAL HEAD
-  EXIST. PEDESTRIAN SIGNAL POLE

EXISTING TRAFFIC SIGNAL HEADS:

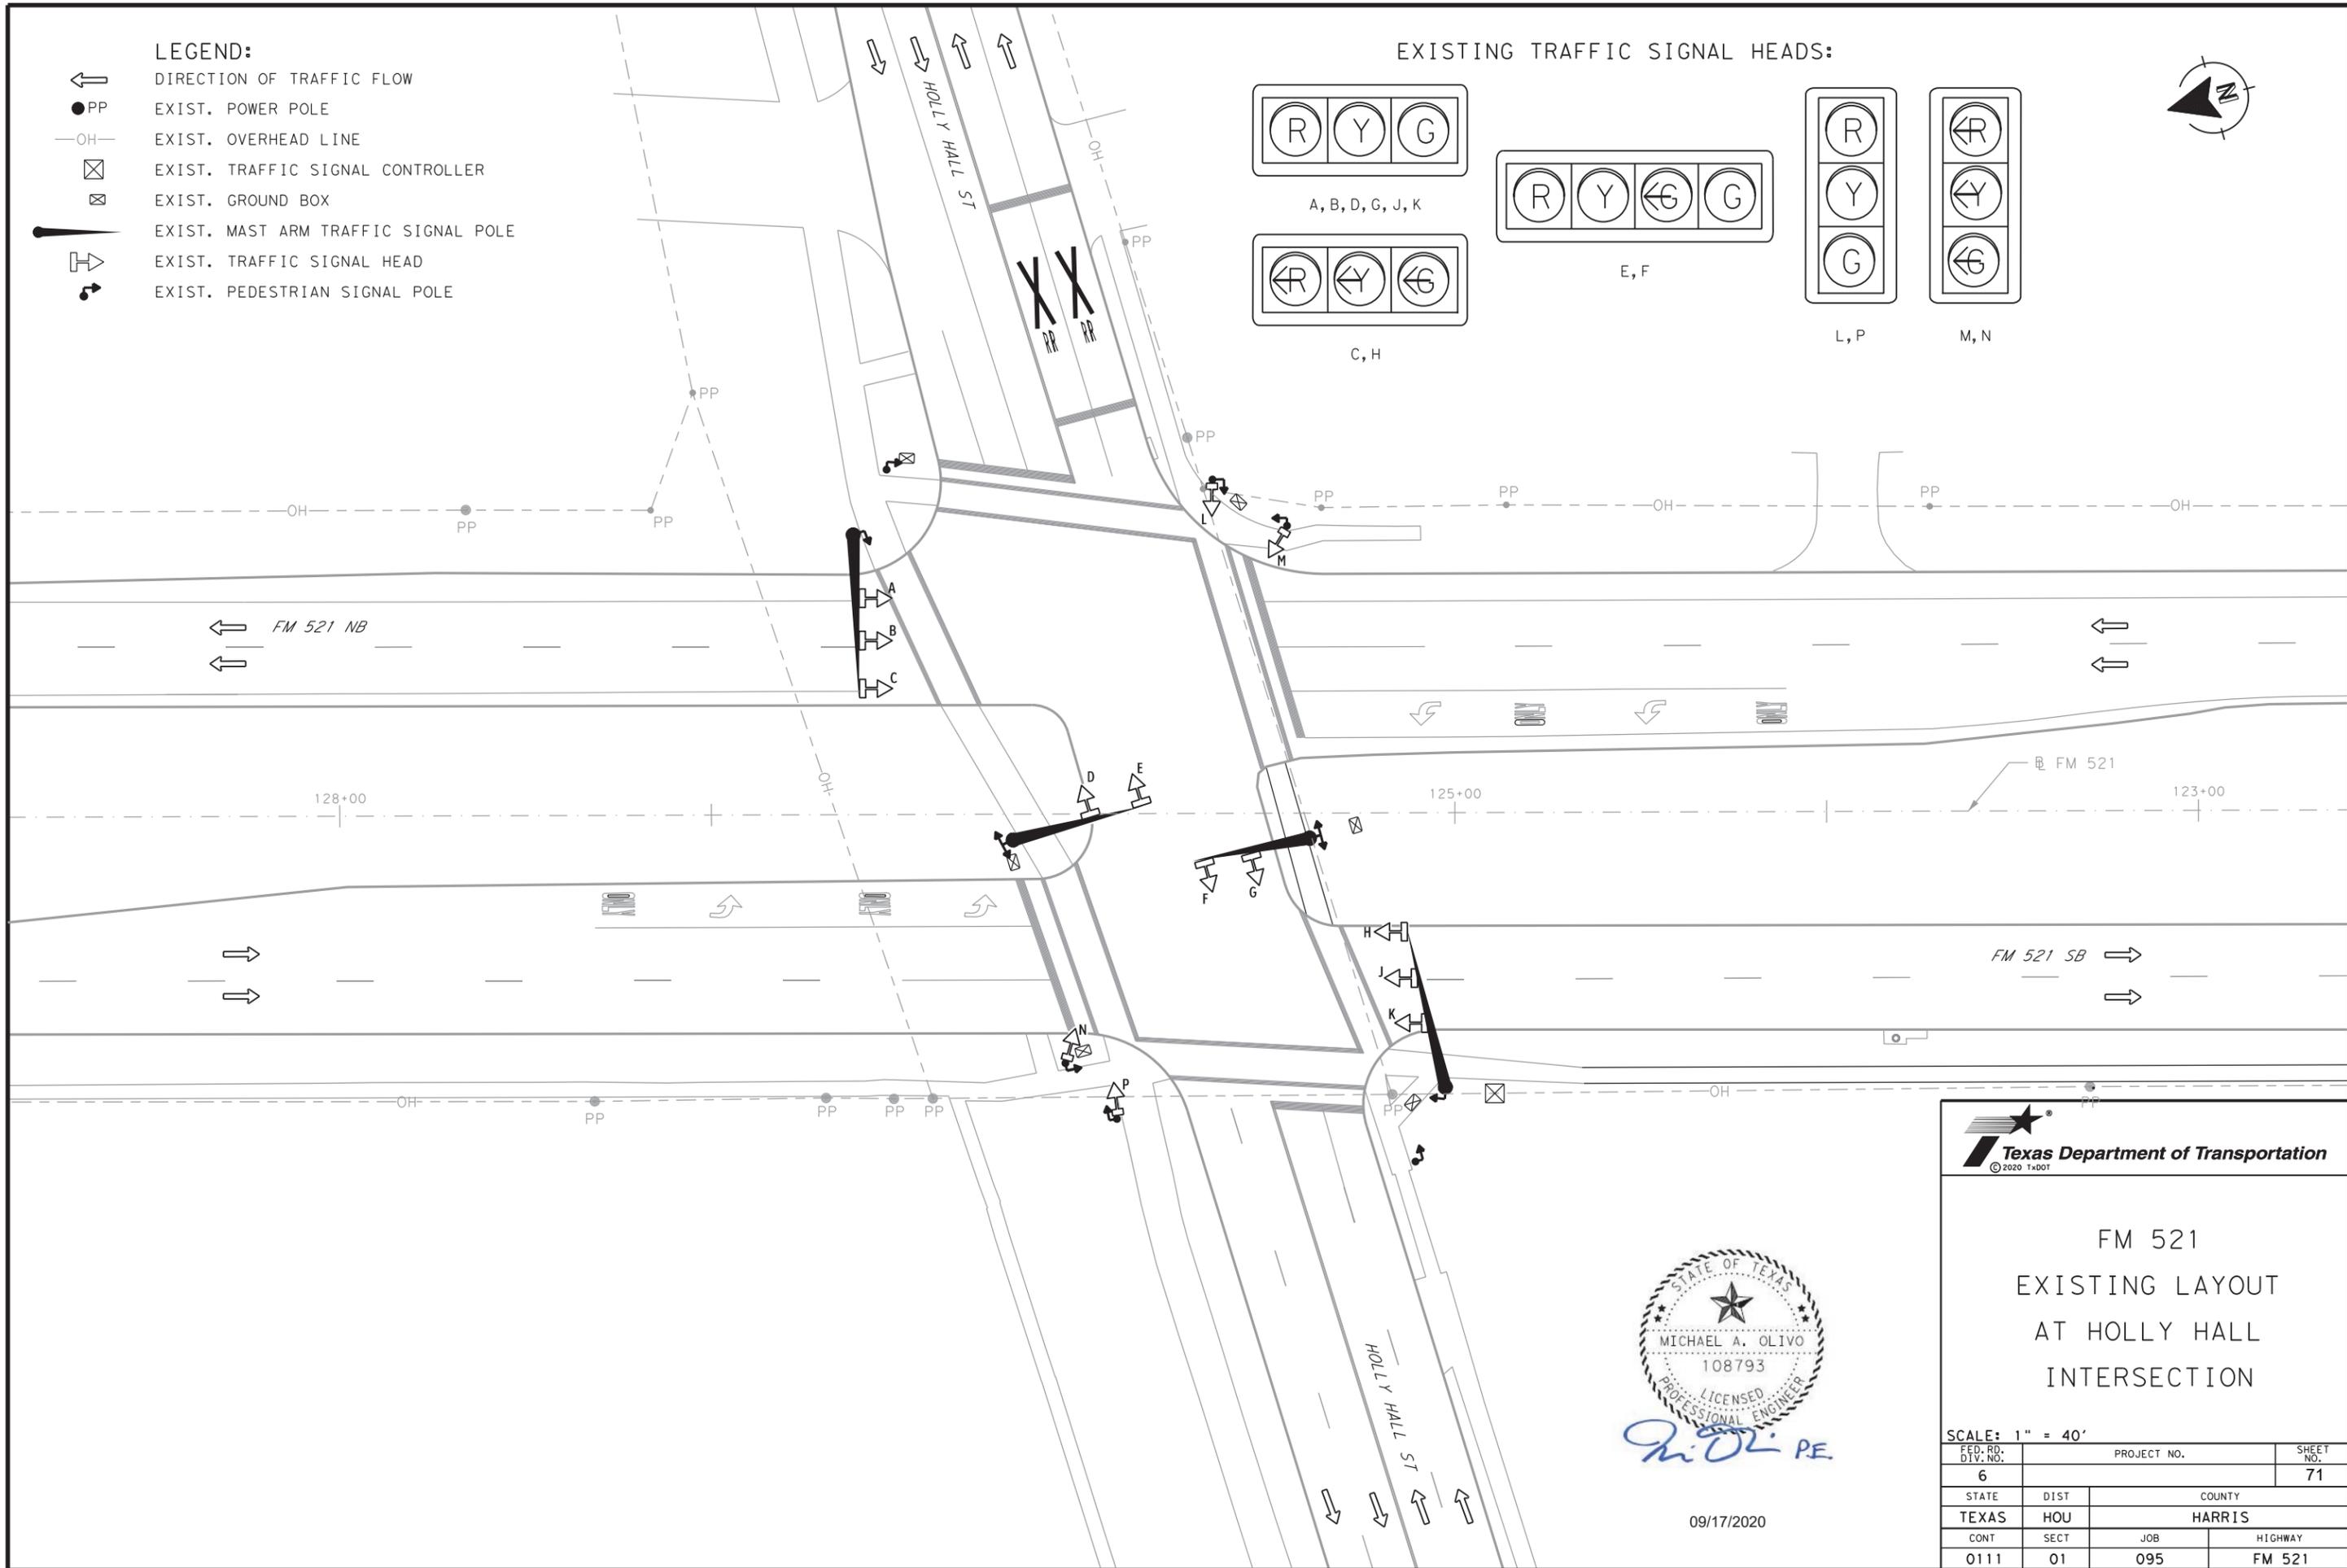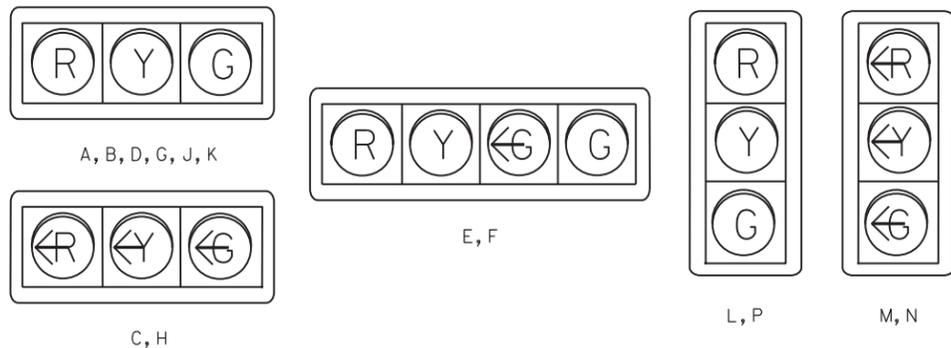

FM 521
EXISTING LAYOUT
AT HOLLY HALL
INTERSECTION




09/17/2020

SCALE: 1" = 40'

FED. RD. DIV. NO.	PROJECT NO.		SHEET NO.
6			71
STATE	DIST	COUNTY	
TEXAS	HOU	HARRIS	
CONT	SECT	JOB	HIGHWAY
0111	01	095	FM 521

LEGEND:

-  DIRECTION OF TRAFFIC FLOW
-  EXIST. POWER POLE
-  EXIST. OVERHEAD LINE
-  EXIST. TRAFFIC SIGNAL CONTROLLER
-  EXIST. GROUND BOX
-  EXIST. MAST ARM TRAFFIC SIGNAL POLE
-  EXIST. TRAFFIC SIGNAL HEAD
-  EXIST. PEDESTRIAN SIGNAL POLE
-  PROP. LOOP DETECTOR (6' x 30')
-  PROP. LOOP DETECTOR (6' x 10')
-  PROP. LOOP DETECTOR (6' x 6')
-  PROP. CONDUIT (BORE)
-  PROP. CONDUIT (TRENCH)
-  PROP. GROUND BOX TY D

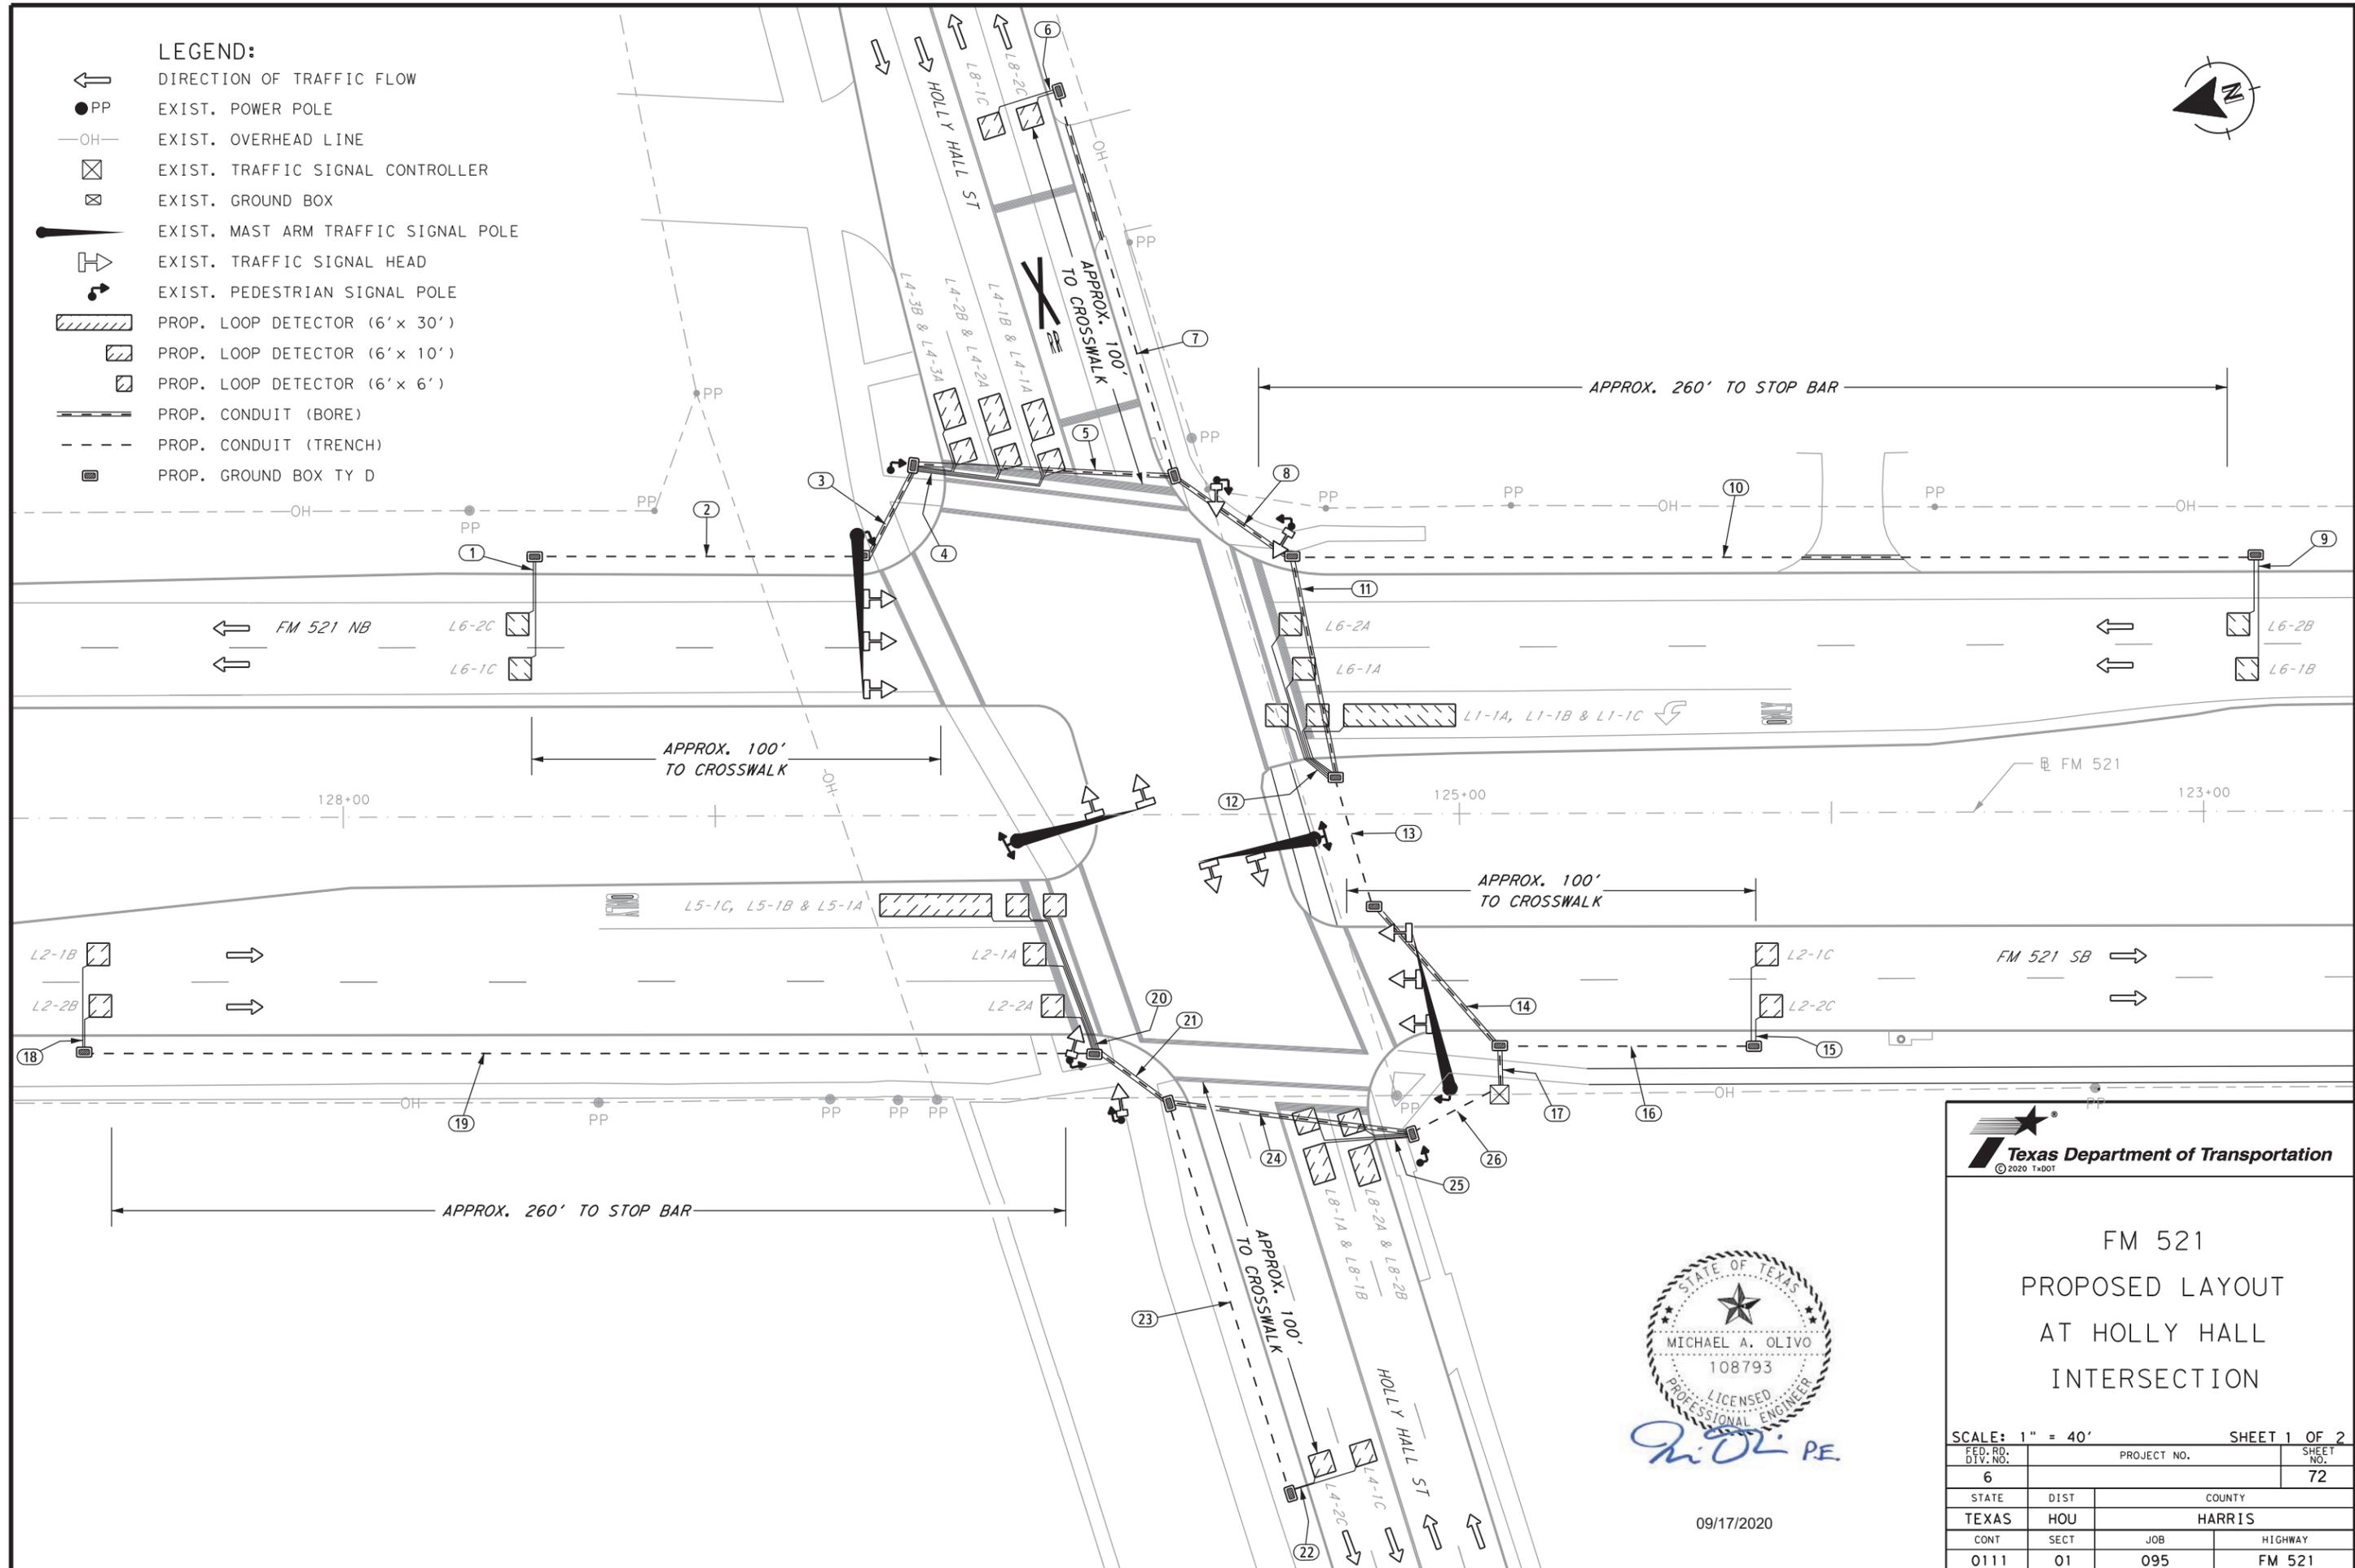

09/17/2020



FM 521
PROPOSED LAYOUT
AT HOLLY HALL
INTERSECTION

SCALE: 1" = 40'		SHEET 1 OF 2	
FED. RD. DIV. NO. 6	PROJECT NO.		SHEET NO. 72
STATE TEXAS	DIST HOU	COUNTY HARRIS	
CONT 0111	SECT 01	JOB 095	HIGHWAY FM 521

ELECTRICAL DATA CHART:

RUN NO.	CONDUIT (618)										CONDUCTORS (620)		LOOP (688)		LOOP (684)	
	PVC										GROUND		LOOP		LEAD-IN	
	1.25" (SCHD 80)		2" (SCHD 80)				3" (SCHD 80)				#6 BARE		#14 INSULATED		#14/2C	
	(Subsidiary)		(6046)		(6047)		(6053)		(6054)		(6009)		(Subsidiary)		(6080)	
	NO.	TRENCH	NO.	TRENCH	NO.	BORE	NO.	TRENCH	NO.	BORE	NO.	LENGTH	NO.	LENGTH	NO.	LENGTH
EA	LF	EA	LF	EA	LF	EA	LF	EA	LF	EA	LF	EA	LF	EA	LF	
1	2	10										1	200			
2			1	85							1	85		2	85	
3					1	30					1	30		2	30	
4	6	10										1	680			
5					1	75					1	75		8	75	
6	2	10										1	200			
7			1	70	1	40					1	110		2	110	
8					1	45					1	45		10	45	
9	2	10										1	200			
10			1	220	1	40					1	260		2	260	
11								1	60	1	60			12	60	
12	5	10										1	670			
13							1	35			1	35		17	35	
14								1	55	1	55			17	55	
15	2	10										1	200			
16			1	70						1	70			2	70	
17								1	20	1	20			19	20	
18	2	10										1	200			
19			1	260						1	260			2	260	
20	5	10										1	670			
21					1	25				1	25			7	25	
22	2	10										1	200			
23			1	100						1	100			2	100	
24					1	70				1	70			9	70	
25	4	15										1	480			
26							1	30		1	30			13	30	
TOTAL (LF)		340		805		325		65		135		1330		3700		6705
EST. TOTAL		360		850		345		70		145		1400		3885		7045




09/17/2020



FM 521
PROPOSED LAYOUT
AT HOLLY HALL
INTERSECTION


SHEET 2 OF 2

FED. RD. DIV. NO.	PROJECT NO.		SHEET NO.
6			73
STATE	DIST	COUNTY	
TEXAS	HOU	HARRIS	
CONT	SECT	JOB	HIGHWAY
0111	01	095	FM 521

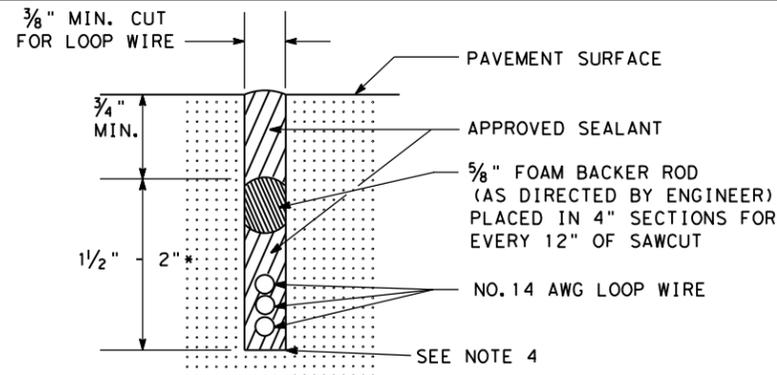


LOOP SAW CUT CROSS-SECTION

* SAWCUTS IN BRIDGE DECKS ARE TYPICALLY 1" DEPTH MAXIMUM
SAWCUTS IN BRIDGE DECKS AND ACROSS EXPANSION JOINTS SHALL BE AS APPROVED BY ENGINEER

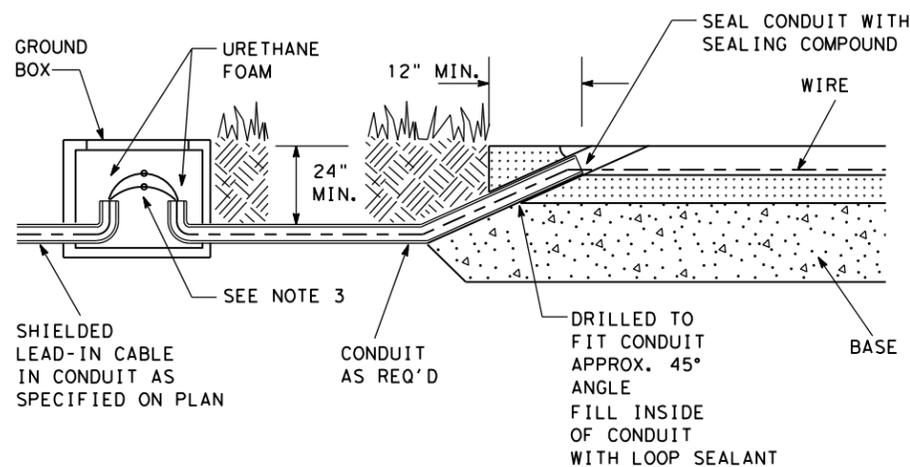


TYPICAL LEAD IN CONFIGURATION (WITHOUT CURBING)

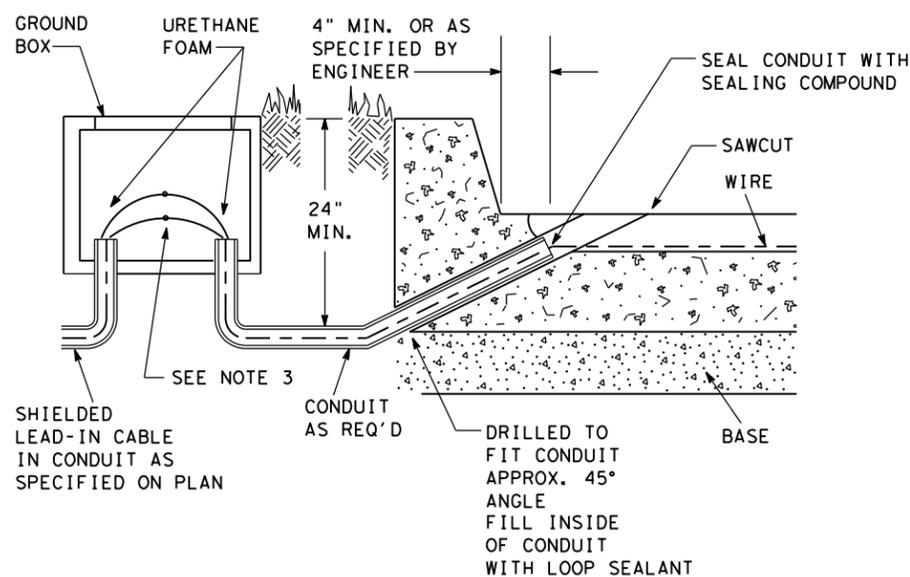


TYPICAL LEAD IN CONFIGURATION (WITH CURBING)


TYPE DET.	NUMBER OF LANES	LENGTH	WIDTH	TURNS OF WIRE
PULSE	1	6 FT.- 12 FT.	6 FT.	4
PULSE	2	13 FT.-26 FT.	6 FT.	3
PULSE	3	27 FT.-39 FT.	6 FT.	2
PULSE	4	40 FT.-46 FT.	6 FT.	1
PRES- ENCE	1	40 FT.	6 FT.	2

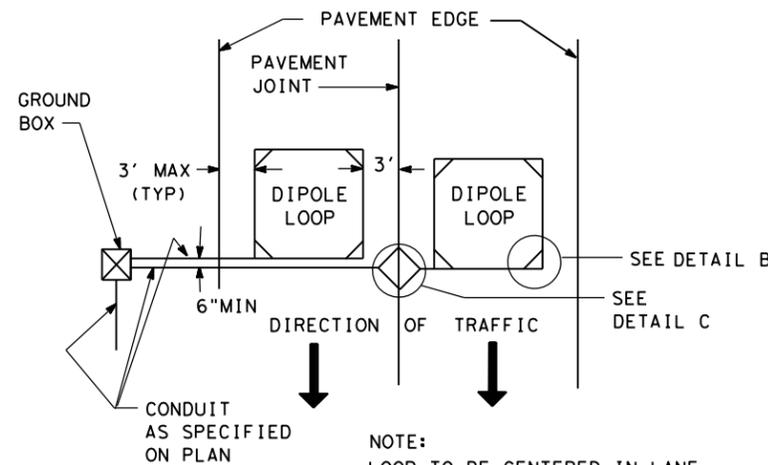


PAVEMENT JOINT DETAILS

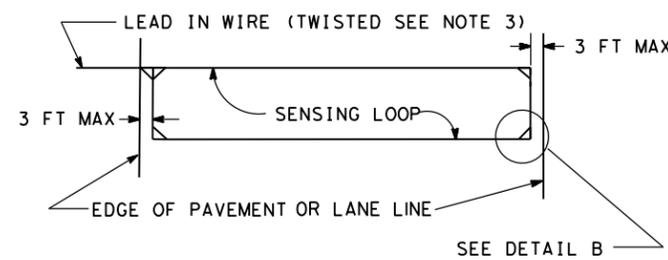

TYPICAL LAYOUT OF DIPOLE LOOP

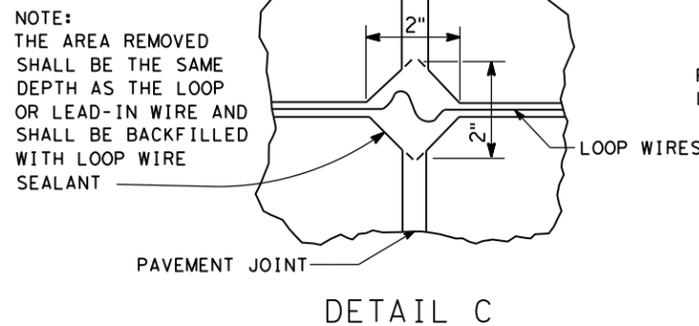

DETAIL C

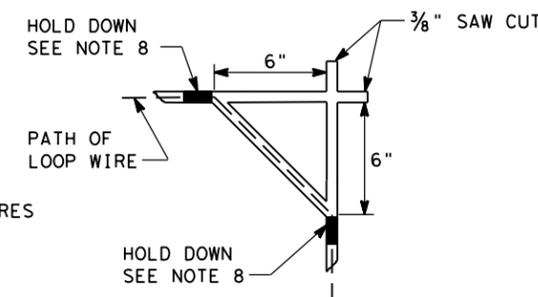

DETAIL B

TYPICAL ALL FOUR CORNERS (DIPOLE LOOPS)

NOTES:

- INSTALL THE LOOP WIRES IN THE SHORTEST TIME PRACTICAL, NOT TO EXCEED 4 HOURS MAXIMUM AND SCHEDULE THIS WORK DURING OFF- PEAK HOURS TO MINIMIZE DELAY TO VEHICLE TRAFFIC.
- CUT PAVEMENT WITH A CONCRETE SAW TO NEAT LINES AND REMOVE LOOSE MATERIAL. ENSURE A CLEAN AND DRY CUT WHEN PLACING THE SEALING COMPOUND.
- TWIST LEAD-IN WIRES A MINIMUM OF FIVE TURNS PER FOOT AND DO NOT DISTURB THEM AFTER THE LOOP HAS BEEN TUNED. DO NOT TWIST LOOP WIRES IN SAW CUT.
- SEAL WIRE PLACED IN THE SAW CUT BY FULLY ENCAPSULATING IT IN A SEALANT ACCEPTABLE TO THE ENGINEER. SEALING COMPOUND SHALL BE IN ACCORDANCE WITH DMS 6340.
- INSTALL TWO-CONDUCTOR #14 SHIELDED CABLE FROM THE BASE OF A STEEL POLE OR TOP OF A WOOD POLE TO THE CONTROLLER OR AS APPROVED BY THE ENGINEER.
- ENSURE CONNECTIONS ARE SOLDERED. SEAL SOLDER JOINT WITH SCOTCH CAST OR OTHER METHOD ACCEPTABLE TO THE ENGINEER.
- FURNISH #14 XHHW LOOP WIRE LOOSELY ENCASED IN A FLEXIBLE VINYL OR PLASTIC TUBE. APPLY A WATERPROOF SEAL TO THE ENDS OF THE VINYL OR PLASTIC TUBING ENCASING THE WIRE IMMEDIATELY AFTER PLACING THE WIRE TO PREVENT MOISTURE FROM ENTERING THE TUBE.
- SECURE THE LOOP WIRE IN PLACE EVERY 2 FT. WITH SHORT STRIPS OF RUBBER OR NEOPRENE FLEXIBLE TUBING OR POLYETHYLENE FOAM SEALANT APPROXIMATELY 1 IN. IN LENGTH. LEAVE STRIPS IN PLACE AND FILL THE SLOT WITH LOOP SEALER.
- INSTALL SAWCUT OF SUFFICIENT DEPTH TO PROVIDE FOR A MINIMUM OF 1 IN. DEPTH OF SEALER OVER THE WIRE.
- INSTALL EACH LOOP DETECTOR LEAD-IN IN A SEPARATE SAWCUT FROM THE DETECTOR TO THE EDGE OF ROADWAY. SEPARATE THE SAW CUTS AT A MINIMUM OF 6 IN. INSTALL EACH LOOP DETECTOR RUN IN A SEPARATE CONDUIT (SIZE AS REQUIRED) FROM THE EDGE OF ROADWAY TO A GROUND BOX AS SHOWN ON THE PLAN LAYOUT.
- PLACE LOOP WIRE IN A FLEXIBLE VINYL OR POLYETHYLENE TUBING OF 0.184 IN. MINIMUM I.D., 0.031 IN. MINIMUM WALL THICKNESS AND 0.26 IN. MAXIMUM O.D., HAVING A SMOOTH BORE. ENSURE THE TUBING DOES NOT ADHERE TO THE LOOP WIRE IN ANY WAY. ENSURE TUBING IS CAPABLE OF RESISTING DETERIORATION FROM OILS, SOLVENTS AND TEMPERATURES UP TO 212°F. ENSURE TUBING IS HIGHLY ABRASION RESISTANT AND REMAINS FLEXIBLE FROM -22°F TO 212°F.

**SIGNAL DETAILS/STANDARDS
LOOP DETECTOR DETAILS**

LDD

FILE:	DN:	CK:	DW:	CK:
© TxDOT 2015	DIST	FED REG	PROJECT NO.	SHEET
8/2004	HOU	6		74
7/2012 SPELLING	COUNTY	CONTROL	SECT	JOB
7/2015 *C TO *F	HARRIS	0111	01	095
				FM 521

TYPICAL LOOP DETECTOR

PLACEMENT LAYOUT FOR DIAMOND INTERCHANGE (Ø2 IS ALWAYS TO THE CONTROLLER'S LEFT)

- USE FOR LEFT TURN ONLY
- MAKE SURE TRAFFIC TURNING FROM FRONTAGE ROAD DOES NOT MISS DETECTORS FOR Ø1A AND Ø5A.
- LOOP PLACEMENT IS 5 FEET FROM STOP LINE





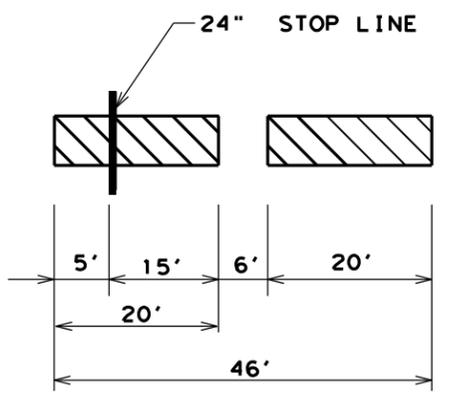


TABLE B

PRESENCE DETECTORS
PLACEMENT
(LEFT TURN LANE
AND
MINOR STREET ONLY)

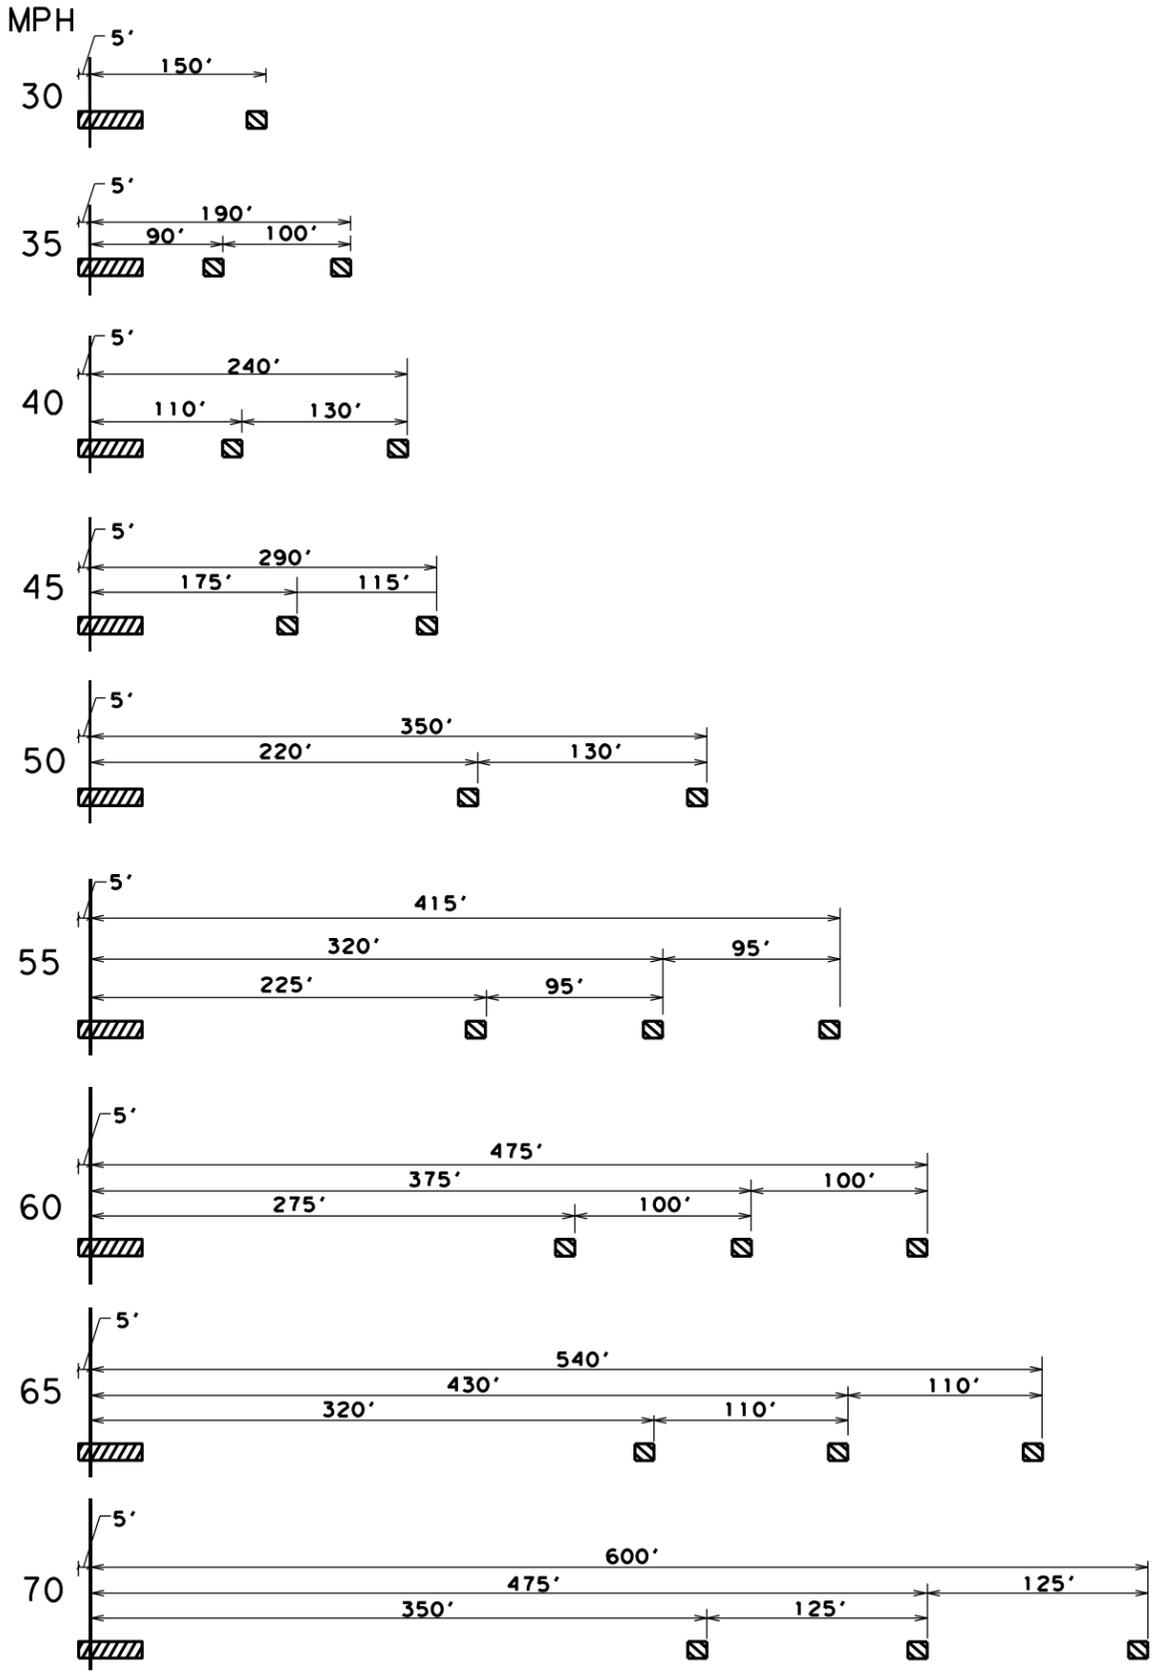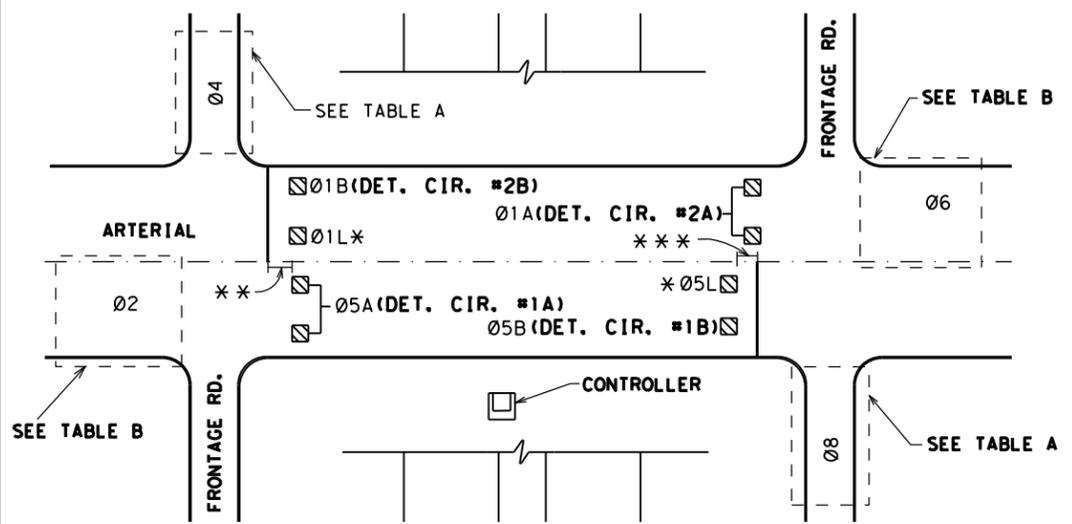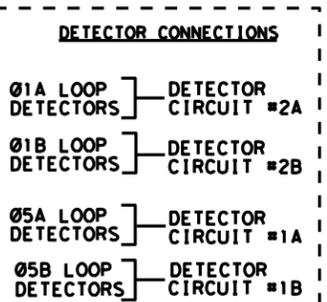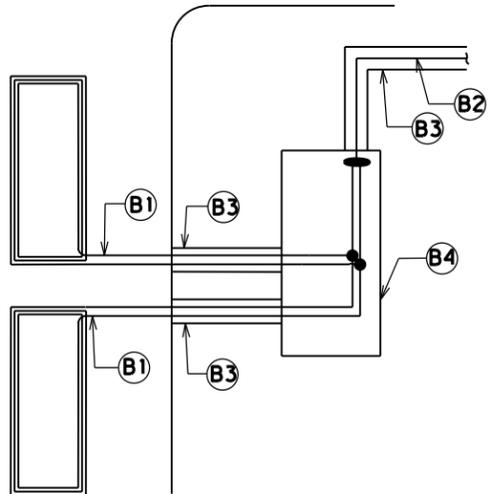

- (B1) LOOP WIRE
- (B2) LOOP LEAD-IN TO CONTROLLER
- (B3) CONDUIT AS REQUIRED
- (B4) GROUND BOX
- CONNECTION

**CONNECTION FOR
DETECTORS**

- ▨ (6' x 20')
- ◻ (6' x 6')
- 24" STOP LINE

TABLE A

LOOP DETECTORS PLACEMENT
ACCORDING TO APPROACH SPEED
(NOT TO SCALE)

TEXAS DEPARTMENT OF TRANSPORTATION
HOUSTON DISTRICT

© 2011 TxDOT

SIGNAL DETAILS/STANDARDS LOOP DETECTOR DETAILS PLACEMENT LDDP

SCALE	FED. RD. DIV. NO.	STATE	PROJECT NO.	HIGHWAY
N. T. S.	6	TEXAS		FM 521
REVISIONS	STATE DISTRICT	COUNTY	CONTROL SECTION	JOB SHEET NO.
	HOU	HARRIS	0111 01	095 75

STD-M18

DISCLAIMER: The use of this standard is governed by the "Texas Engineering Practice Act". No warranty of any kind is made by TxDOT for any purpose whatsoever. TxDOT assumes no responsibility for the conversion of this standard to other formats or for incorrect results or damages resulting from its use.

DATE: 8/25/2020 11:25:11 AM
 FILE: H:\TrfSignals\Haj Tran\0111-01-095\FM521atHollyHall.dgn

GENERAL NOTES FOR ALL ELECTRICAL WORK

- The location of all conduits, junction boxes, ground boxes, and electrical services is diagrammatic and may be shifted to accommodate field conditions.
- Provide new and unused materials. Ensure that all materials and installations comply with the applicable articles of the National Electrical Code (NEC), TxDOT standards and specifications, National Electrical Manufacturers Association (NEMA), and are listed by Underwriters Laboratories (UL) or a Nationally Recognized Testing Lab (NRTL). NRTLs such as Canadian Standard Association (CSA), Intertek Testing Services NA Inc., or FM Approvals LLC can be considered equivalent to UL. Where reference is made to NEMA listed devices, International Electrotechnical Commission (IEC) listed devices will not be considered an acceptable equal to a NEMA listed device. Acceptable devices may have both a NEMA and IEC listing. Faulty fabrication or poor workmanship in any material, equipment, or installation is justification for rejection. Replace or reinstall rejected material or equipment at no additional cost to the Department.
- Miscellaneous nuts, bolts and hardware, except for high strength bolts, may be stainless steel when plans specify galvanized, provided the bolt size is 1/2 in. or less in diameter.
- Provide the following test equipment as required by the Engineer to confirm compliance with the contract and the NEC: voltmeter, ammeter, megohm meter (1000 volt DC), ground resistance tester, torque wrenches, and torque screwdrivers. Ensure all equipment has been properly calibrated within the last year. Provide calibration certification to the Engineer upon request. Operate test equipment during inspection as requested by the Engineer.
- Install grounding as shown on the plans and in accordance with the NEC. Ensure all metallic conduits; metal poles; luminaires; and metal enclosures are bonded to the equipment grounding conductor. Provide stranded bare copper or green insulated grounding conductors. Ground rods, connectors, and bonding jumpers are subsidiary to the various bid items.
- When required by the Engineer, notify the Department in writing of materials from the Material Producers List (MPL) intended for use on each project. Prequalified materials are listed on the MPL on TxDOT's website under "Roadway Illumination and Electrical Supplies." No substitutions will be allowed for materials on this list.

CONDUIT

A. MATERIALS

- Provide conduit, junction boxes, fittings, and hardware as per TxDOT Departmental Material Specification (DMS) 11030 "Conduit" and Item 618 "Conduit" of TxDOT's "Standard Specifications For Construction And Maintenance Of Highways, Streets, And Bridges," latest edition. Provide conduits listed under Item 618 on the MPL under "Roadway Illumination and Electrical Supplies." Provide conduit types according to the descriptive code or as shown on the plans. Do not substitute other types of conduits for those shown. Provide liquidtight flexible metal conduit (LFMC) when flexible conduit is called for on galvanized steel rigid metallic conduit (RMC) systems. Provide liquidtight flexible nonmetallic conduit (LFNC) when flexible conduit is called for on polyvinyl chloride (PVC) systems.
- Provide galvanized steel RMC for all exposed conduits, unless otherwise shown on the plans. Properly bond all metal conduits.
- Unless otherwise shown on the plans, provide junction boxes with a minimum size as shown in the following table, which applies to the greatest number of conductors entering the box through one conduit with no more than four conduits per box. When a mixture of conductor sizes is present, count the conductors as if all are of the larger size. For situations not applicable to the table, size junction boxes in accordance with NEC.

AWG	3 CONDUCTORS	5 CONDUCTORS	7 CONDUCTORS
#1	10" x 10" x 4"	12" x 12" x 4"	16" x 16" x 4"
#2	8" x 8" x 4"	10" x 10" x 4"	12" x 12" x 4"
#4	8" x 8" x 4"	10" x 10" x 4"	10" x 10" x 4"
#6	8" x 8" x 4"	8" x 8" x 4"	10" x 10" x 4"
#8	8" x 8" x 4"	8" x 8" x 4"	8" x 8" x 4"

- Junction boxes with an internal volume of less than 100 cu. in. and supported by entering raceways must have threaded entries or hubs identified for the intended purpose and supported by connection of two or more rigid metal conduits. Secure conduit within 3 ft. of the enclosure or within 18 in. of the enclosure if all conduit entries are on the same side. Mechanically secure all junction boxes with an internal volume greater than 100 cu. inches.
- Provide hot dipped galvanized cast iron or sand cast aluminum outlet boxes for junction boxes containing only 10 AWG or 12 AWG conductors. Do not use die cast aluminum boxes. Size outlet boxes according to the NEC.
- Do not use intermediate metal conduit (IMC) or electrical metallic tubing (EMT) unless specifically required by the plan sheets. When EMT is called for, provide junction boxes made from galvanized steel sheeting, listed and approved for outdoor use, unless otherwise noted on the plans. Size all galvanized steel junction boxes in accordance with the NEC. Provide junction boxes for IMC conduit systems that meet the same requirements for junction boxes used with RMC systems.
- Provide PVC junction boxes intended for outdoor use on PVC conduit systems, unless otherwise noted on the plans.

- Provide PVC elbows in PVC conduit systems, unless otherwise shown on the plans. Use only a flat, high tensile strength polyester fiber pull tape for pulling conductors through the PVC conduit system. When galvanized steel RMC elbows are specifically called for in the plans and any portion of the RMC elbow is buried less than 18 in., ground the RMC elbow by means of a grounding bushing on a rigid metal extension. Grounding of the rigid metal elbow is not required if the entire RMC elbow is encased in a minimum of 2 in. of concrete. PVC extensions are allowed on these concrete encased rigid metal elbows. RMC or PVC elbows are subsidiary to various bid items.
- When required, provide High-Density Polyethylene (HDPE) conduit with factory installed internal conductors according to Item 622 "Duct Cable." At the Contractor's request and with approval by the Engineer, substitute HDPE conduit with no conductors for bored schedule 40 or schedule 80 PVC conduit bid under Item 618. Ensure bored HDPE substituted for PVC is schedule 40 and of the same size PVC called for in the plans. Ensure the substituted HDPE meets the requirements of Item 622, except that the conduit is supplied without factory-installed conductors. Make the transition of the HDPE conduit to PVC (or RMC elbow when required) at the bore pit. Provide conduit of the size and schedule as shown on the plans. Do not extend substituted conduit into ground boxes or foundations. Provide PVC or galvanized steel RMC elbows as called for at all ground boxes and foundations.
- Use two-hole straps when supporting 2 in. and larger conduits. On electrical service poles, properly sized stainless steel or hot dipped galvanized one-hole standoff straps are allowed on the service riser conduit.

B. CONSTRUCTION METHODS

- Provide and install expansion joint conduit fittings on all structure-mounted conduits at the structure's expansion joints to allow for movement of the conduit. In addition, provide and install expansion joint fittings on all continuous runs of galvanized steel RMC conduit externally exposed on structures such as bridges at maximum intervals of 150 ft. When requested by the project Engineer, supply manufacturer's specification sheet for expansion joint conduit fittings. Repair or replace expansion joint fittings that do not allow for movement at no additional cost to the Department. Provide the method of determining the amount of expansion to the Engineer upon request. Do not use LFMC or LFNC as a substitute for the required expansion conduit fittings.
- Space all conduit supports at maximum intervals of 5 ft. Install conduit spacers when attaching metal conduit to surface of concrete structures. See "Conduit Mounting Options" on ED(2). Install conduit support within 3 ft. of all enclosures and conduit terminations.
- Do not attach conduit supports directly to pre-stressed concrete beams except as shown specifically in the plans or as approved by the Engineer.
- Unless otherwise shown on the plans, jack or bore conduit placed beneath existing roadways, driveways, sidewalks, or after the base or surfacing operation has begun. Backfill and compact the bore pits below the conduit per Item 476 "Jacking, Boring, or Tunneling Pipe or Box" prior to installing conduit or duct cable to prevent bending of the connections.
- When placing conduit in the sub-grade of new roadways, backfill all trenches with excavated material unless otherwise noted on the plans. When placing conduit in the sub-base of new roadways, backfill all trenches with cement-stabilized base as per requirements of Items 110 "Excavation", 400 "Excavation and Backfill for Structures", 401 "Flowable Backfill", 402 "Trench Excavation Protection", and 403 "Temporary Special Shoring."
- Provide and place warning tape approximately 10 in. above all trenched conduit as per Item 618.
- During construction, temporarily cap or plug open ends of all conduit and raceways immediately after installation to prevent entry of dirt, debris and animals. Temporary caps constructed of durable duct tape are allowed. Tightly fix the tape to the conduit opening. Clean out the conduit and prove it clear in accordance with Item 618 prior to installing any conductors.
- Ensure conduit entry into the top of any enclosure is waterproof by installing conduit sealing hubs or using boxes with threaded bosses. This includes surface mounted safety switches, meter cans, service enclosures, auxiliary enclosures and junction boxes. Grounding bushings on water tight sealing hubs are not required.
- Fit the ends of all PVC conduit terminations with bushings or bell end fittings. Provide and install a grounding type bushing on all metal conduit terminations.
- Install a bonding jumper from each grounding bushing to the nearest ground rod, grounding lug, or equipment grounding conductor. Ensure all bonding jumpers are the same size as the equipment grounding conductor. Bonding of conduit used as a casing under roadways for duct cable is not required, if the duct extends the full length through the casing.
- At all electrical services, install a 6 AWG solid copper grounding electrode conductor.
- Place conduits entering ground boxes so that the conduit openings are between 3 in. and 6 in. from the bottom of the box. See the ground box detail on sheet ED(4).
- Seal ends of all conduits with duct seal, expandable foam, or by other methods approved by the Engineer. Seal conduit immediately after completion of conductor installation and pull tests. Do not use duct tape as a permanent conduit sealant. Do not use silicone caulk as a conduit sealant.
- File smooth the cut ends of all mounting strut and conduit. Before installing, paint the field cut ends of all mounting strut and RMC (threaded or non-threaded) with zinc rich paint (94% or more zinc content) to alleviate overspray. Use zinc rich paint to touch up galvanized material as allowed under Item 445 "Galvanizing." Do not paint non-galvanized material with a zinc rich paint as an alternative for materials required to be galvanized.

					
<p>ELECTRICAL DETAILS CONDUITS & NOTES</p> <p>ED(1) - 14</p>					
FILE:	ed1-14.dgn	DN:	CK:	DW:	CK:
© TxDOT	October 2014	CONT	SECT	JOB	HIGHWAY
REVISIONS		0111	01	095	FM 521
		DIST	COUNTY		SHEET NO.
		HOU	HARRIS		76

ELECTRICAL CONDUCTORS

A. MATERIAL INFORMATION

1. Provide Type XHHW insulated conductors in accordance with Departmental Material Specification (DMS) 11040 "Conductors" and Item 620 "Electrical Conductors." Provide conductors as listed on the Material Producers List (MPL) on the Department web site under "Roadway Illumination and Electrical Supplies" Item 620. Color code insulated conductors in conformance with the NEC. Identify grounded (neutral) conductors with white insulation. Identify grounding conductors (ground wires) with green insulation or bare conductors. Identify ungrounded (hot) conductors with any color insulation except green, white, or gray. Keep color scheme consistent throughout the wiring system. Identify conductors 6 American Wire Gauge (AWG) and smaller by continuous color jacket. Identify electrical conductors 4 AWG and larger by continuous color jacket or by colored tape. When identifying conductors with colored tape, mark at least 6 in. of the conductor's insulation with half laps of tape.
2. Provide a solid copper 6 AWG grounding electrode conductor to bond the electrical service equipment to the concrete encased grounding electrode or the ground rod at the service location. Connect the grounding electrode conductor to the ground rod with a UL listed connector in accordance with DMS 11040. Connect the grounding electrode conductor to the concrete encased grounding electrode as shown in the plans.
3. Where two or more circuits are present in one conduit or enclosure, permanently identify the conductors of each branch circuit by attaching a non-metallic tag around both circuit conductors at each accessible location. Provide tags with two straps, large enough to indicate circuit number, letter, or other identification as shown in the plans. Print circuit identification on the tag with a permanent marker.
4. Use listed compression or screw type pressure connectors, terminal blocks, or split bolt connectors for splicing as specified in DMS 11040. Use hot melt adhesive tape to fill the gap and seal the ends of heat shrink tubing. Provide UL listed gel-filled insulating splice covers. Splicing materials, insulating materials, breakaway disconnects, splice covers, and fuse holders are subsidiary to various bid items.

B. CONSTRUCTION METHODS

1. Use only a flat, high tensile strength polyester fiber pull tape for pulling conductors through the conduit system. After installing conductors in conduit, perform conductor pull test. If a conductor cannot be freely pulled, make any needed alterations or repairs at no additional cost to the department. Perform insulation resistance tests in accordance with Item 620. Coordinate with the Engineer to witness the tests.
2. Leave 2 ft. minimum, 3 ft. maximum length for each conductor up to the splice in ground boxes. Leave 3 ft. minimum, 4 ft. maximum length of conductor in ground boxes when pulled through with no splice. Leave 1 ft. minimum, 1.5 ft. maximum length of conductor at enclosures, weatherheads and pole bases.
3. Make splices only in junction boxes, ground boxes, pole bases, or electrical enclosures and use only listed compression or screw type pressure connectors, terminal blocks, or split bolt connectors. Insulate splices with heavy wall heat shrink tubing or gel-filled insulating splice covers to provide a watertight seal. Overlap conductor insulation with heat shrink tubing a minimum of 2 in. past both sides of the splice. Where heat shrink tubing may not shrink sufficiently to provide a watertight seal around the individual conductors, prior to heating the tubing, increase the diameter of the conductor insulation using hot melt adhesive tape to provide a watertight seal between the individual conductors and the heat shrink tubing. Ensure the tape extends past the heat shrink tubing. Use hot melt adhesive tape to fill the gap and seal the ends of heat shrink tubing. Heat shrink tubing that appears to have been burned, or overheated, is considered defective and must be replaced.
4. Size and install gel-filled insulating splice covers according to manufacturer's specifications when used in place of heat shrink tubing.
5. Wire nuts with factory applied waterproof sealant may be used for 8 AWG or smaller conductors in above ground junction boxes, but not in pole bases or ground boxes. Install wire nuts in an upright position to prevent the accumulation of water.
6. Support conductors in illumination poles with a J-hook at the top of the pole.
7. When terminating conductors, remove the insulation and jacketing material without nicking the individual strands of the conductor. Conductors with nicked individual conductor strands or removed strands will be considered damaged.
8. Replace conductors and cables that are damaged beyond repair or that fail an insulation resistance test at no additional cost to the department.
9. Do not repair damaged conductors with duct tape, electrical tape, or wire nuts. Use only approved splicing methods.
10. Do not terminate more than one conductor under a single connector, unless the connector is rated for multiple conductors. Do not exceed the pressure connector's listing for maximum number and size of conductors allowed.
11. Install breakaway connectors on conductors bid under Item 620 whenever those conductors pass through a breakaway support device. Follow manufacturer's instructions when terminating conductors to breakaway connectors. Properly torque threaded connections. Proper terminations are critical to the safe operation of breakaway devices. Trim waterproofing boots on breakaway connectors to fit snugly around the conductor to ensure waterproof connection. Only one conductor may enter a single opening in a boot. Provide waterproof boots with the correct number of openings. Leave unused openings factory sealed. Use prequalified breakaway connectors as shown on the MPL.

12. Provide and install a separate stranded equipment grounding conductor (EGC) in all conduits that contain circuit wiring of 50 volts or more. Unless shown elsewhere, size the EGC to be the same size as the largest current carrying conductor contained in the conduit. Ensure all EGCs are bonded together at every accessible location. For traffic signal installations, provide a minimum size 8 AWG EGC. The EGC is paid for under Item 620.

C. TEMPORARY WIRING

1. Install temporary conductors and electrical equipment in accordance with the NEC article "Temporary Installations" and Department standard sheets.
2. Provide a ground fault circuit interrupter (GFCI) for power outlets for portable electrical equipment, power tools, ice machines, ice storage bins and refrigerators located outdoors at grade. GFCI may be any one of the following: molded cord and plug set, receptacle, or circuit breaker type.
3. Use listed wire nuts with factory applied sealant for temporary wiring where approved.
4. Enclose conductor splices within a listed enclosure or ground box, or ensure the splices are more than 10 ft. above grade vertically and more than 5 ft. horizontally from any metal structure. Where installing temporary conductors in areas subject to vehicle traffic or mobile construction equipment, ensure the vertical clearance to ground is at least 18 ft. when measured at the lowest point. Ground messenger wires that support power conductors in conformance with the NEC.
5. Protect and when necessary repair any existing electrical conduits uncovered during the construction process in a timely manner and in conformance with the NEC.


GROUND RODS & GROUNDING ELECTRODES

A. MATERIAL INFORMATION


1. Provide and install a grounding electrode at electrical services. Provide ground rods according to DMS 11040 and the plans. Larger diameter or longer length rods may be called for in some specific locations, see the individual plans sheets. Concrete encased grounding electrodes may be called for in specific locations including electrical service, see individual plan sheets.

B. CONSTRUCTION METHODS


1. Furnish auxiliary ground rods for lightning protection and install in soil, concrete, or both, as called for in the plans. For ground rods installed in concrete, ensure the connection of the conductor to the ground rod is readily accessible for inspection or repairs. For ground rods installed in soil, ensure that the upper end is between 2 to 4 in. below finished grade.
2. Do not place ground rods in the same drilled hole as a timber pole.
3. Install ground rods so the imprinted part number is at the upper end of the rod.
4. Remove all non-conductive coatings such as concrete splatter from the rod at the clamp location.
5. Route all conductors as short and straight as possible for connection to lightning protection ground rods. When a bend is required, ensure a minimum radius bend of four inches for these conductors.
6. Unless otherwise called for in the plans, protect grounding electrode conductors with non-metallic conduit. When protecting grounding electrode conductors with metal conduit, provide and install a grounding type bushing and properly sized bonding jumper on each end of the metal conduit.
7. Written authorization is required before installing a ground rod in a horizontal trench for rocky soil or a solid rock bottom.

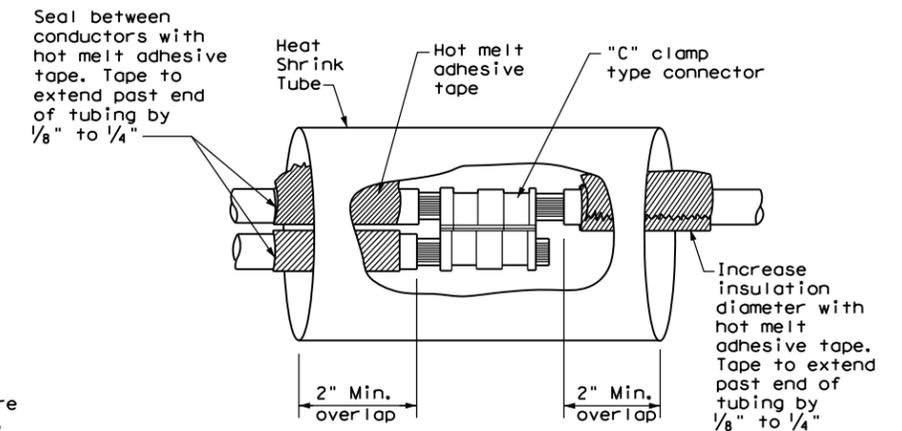

**SPLICE OPTION 1
Compression Type**

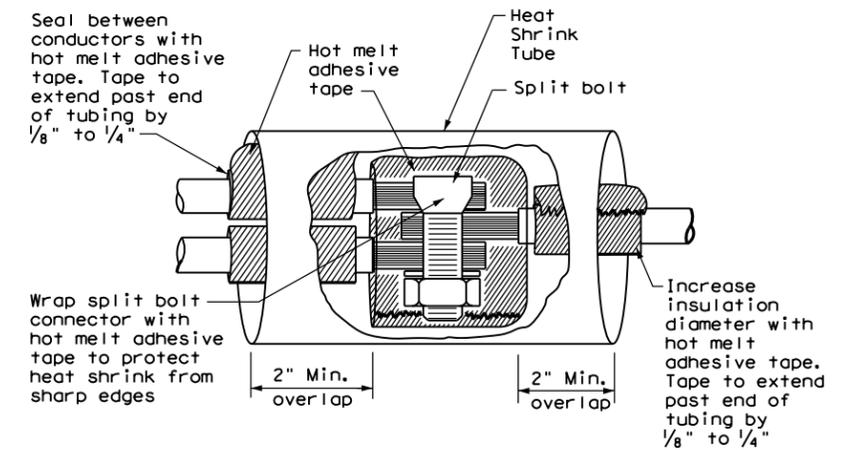

**SPLICE OPTION 2
Split Bolt Type**

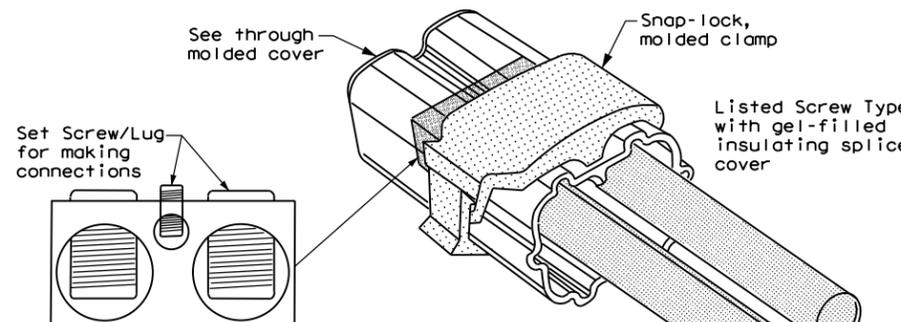

**SPLICE OPTION 3
Listed Screw Type**


DISCLAIMER: The use of this standard is governed by the "Texas Engineering Practice Act". No warranty of any kind is made by TxDOT for any purpose whatsoever. TxDOT assumes no responsibility for the conversion of this standard to other formats or for incorrect results or damages resulting from its use.

DATE: 8/25/2020 11:25:19 AM
 FILE: H:\TrSignal\Hoi Tran\0111-01-095\FM521atHollyHall.dgn

		Traffic Operations Division Standard	
<h1>ELECTRICAL DETAILS CONDUCTORS</h1>			
<h2>ED(3) - 14</h2>			
FILE: ed3-14.dgn	DN: TxDOT	CK: TxDOT	DW: TxDOT
© TxDOT October 2014	CONT	SECT	JOB
REVISIONS	0111	01	095
	DIST	COUNTY	SHEET NO.
	HOU	HARRIS	77

DISCLAIMER: The use of this standard is governed by the "Texas Engineering Practice Act". No warranty of any kind is made by TxDOT for any purpose whatsoever. TxDOT assumes no responsibility for the conversion of this standard to other formats or for incorrect results or damages resulting from its use.

DATE: 8/25/2020 11:25:27 AM
 FILE: H:\TrfSignals\Hoi_Tran\0111-01-095\FM521atHo11yHall.dgn

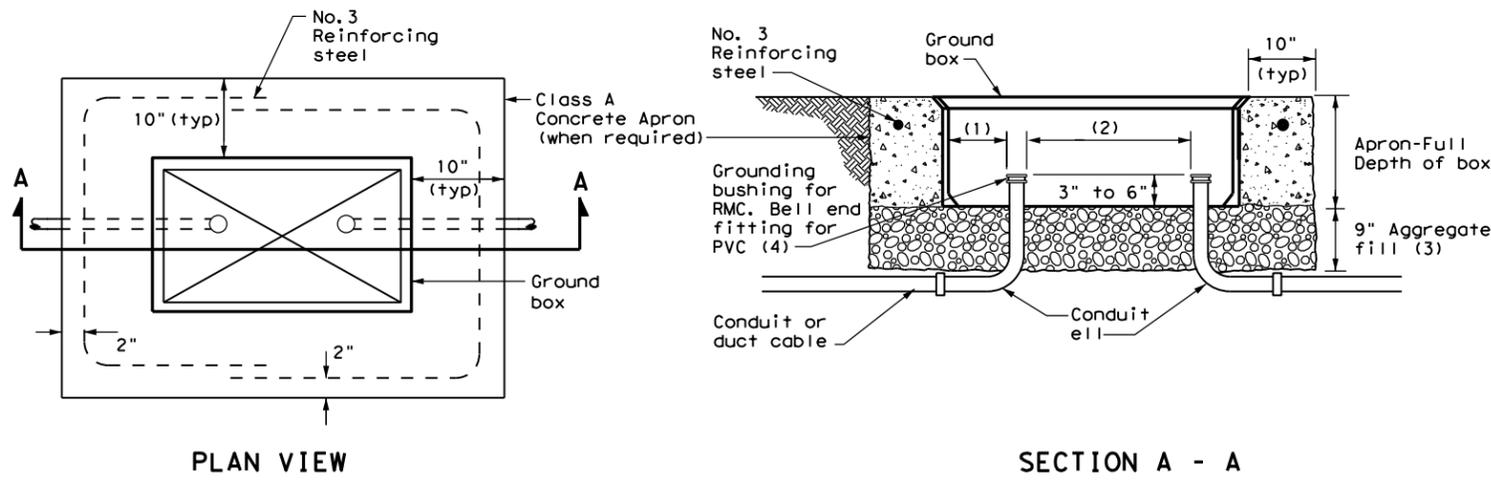


APRON FOR GROUND BOX

- (1) Uniformly space ends of conduits within the ground box. Position ends of conduits so that ground box walls do not interfere with the installation of grounding bushings or bell end fittings.
- (2) Maintain sufficient space between conduits to allow for proper installation of bushing.
- (3) Place aggregate under the box, not in the box. Aggregate should not encroach on the interior volume of the box.
- (4) Install a grounding bushing on the upper end of all RMC terminating in a ground box. Ground RMC elbows when any part of the elbow is less than 18 in. below the bottom of the ground box. Install a PVC bushing or bell end fitting on the upper end of all PVC conduits terminating in a ground box.

GROUND BOX DIMENSIONS	
TYPE	OUTSIDE DIMENSIONS (INCHES) (Width x Length X Depth)
A	12 X 23 X 11
B	12 X 23 X 22
C	16 X 29 X 11
D	16 X 29 X 22
E	12 X 23 X 17

GROUND BOX COVER DIMENSIONS								
TYPE	DIMENSIONS (INCHES)							
	H	I	J	K	L	M	N	P
A, B & E	23 1/4	23	13 3/4	13 1/2	9 7/8	5 1/8	1 3/8	2
C & D	30 1/2	30 1/4	17 1/2	17 1/4	13 1/4	6 3/4	1 3/8	2

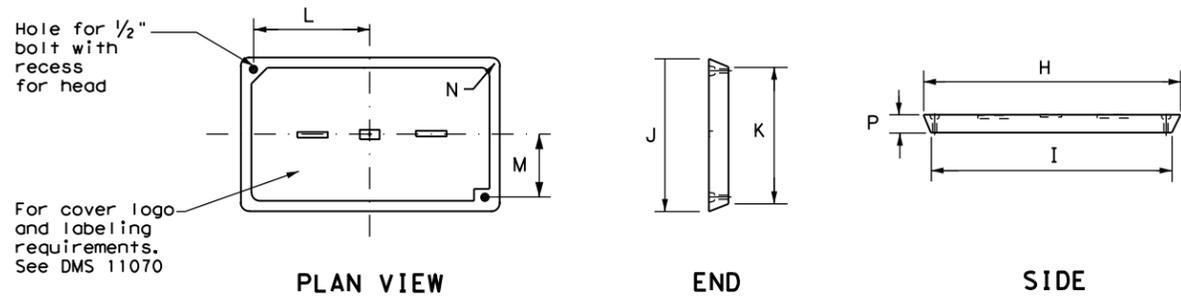

GROUND BOX COVER

GROUND BOXES


A. MATERIALS

1. Provide polymer concrete ground boxes measuring 16x30x24 in. (WxLxD) or smaller in accordance with Departmental Material Specification (DMS) 11070 "Ground Boxes" and Item 624 "Ground Boxes."
2. Provide Type A, B, C, D, and E ground boxes as shown in the plans, and as listed on the Material Producers List (MPL) on the Department web site under "Roadway Illumination and Electrical Supplies," Item 624.
3. Ensure ground box cover is correctly labeled in accordance with DMS 11070.
4. Provide larger ground boxes in accordance with Item 624 and as shown in the plans.

B. CONSTRUCTION METHODS


1. Remove all gravel and dirt from conduit. Cap all conduits prior to placing aggregate and setting ground box. Provide Grade 3 or 4 coarse aggregate as shown on Table 2 of Item 302 "Aggregates for Surface Treatments." Ensure aggregate bed is in place and at least 9 inches deep, prior to setting the ground box. Install ground box on top of aggregate.
2. Cast ground box aprons in place. Reinforcing steel may be field bent. Ensure the depth of concrete for the apron extends from finished grade to the top of the aggregate bed under the box. Ground box aprons, including concrete and reinforcing steel, are subsidiary to ground boxes when called for by descriptive code.
3. Keep bolt holes in the box clear of dirt. Bolt covers down when not working in ground boxes.
4. Install all conduits and ells in a neat and workmanlike manner. Uniformly space conduits so grounding bushings and bell end fittings can easily be installed.
5. Temporarily seal all conduits in the ground box until conductors are installed.
6. Permanently seal conduits immediately after the completion of conductor installation and pull tests. Permanently seal the ends of all conduits with duct seal, expandable foam, or other method as approved. Do not use duct tape as a permanent conduit sealant. Do not use silicone caulk as a sealant.
7. When a ground rod is present in a ground box, bond all equipment grounding conductors together and to the ground rod with listed connectors.
8. When a type B or D ground box is stacked to meet volume requirements, it is allowable to cut an appropriately sized hole for conduit entry in the side wall at least 18 inches below grade.
9. If an existing ground box in the contract has a metal cover, bond the cover to the equipment grounding conductor with a 3 ft. long stranded bonding jumper the same size as the grounding conductor. The bonding jumper is subsidiary to various bid items. Verify existing ground boxes with metal covers are shown on the plans, with notes fully describing the work required.
10. If other ground boxes with metal covers are within the project limits but are not part of the contract, the Engineer may direct the Contractor to bond the metal covers, identifying the specific boxes in writing. This work will be paid for separately.
11. Bond metal ground box covers to the grounding conductor with a tank ground type lug.

				Traffic Operations Division Standard	
<h2>ELECTRICAL DETAILS GROUND BOXES</h2> <h3>ED(4) - 14</h3>					
FILE:	ed4-14.dgn	DN:	TxDOT	CK:	TxDOT
© TxDOT	October 2014	CONT	SECT	JOB	HIGHWAY
REVISIONS		0111	01	095	FM 521
		DIST	COUNTY		SHEET NO.
		HOU	HARRIS		78

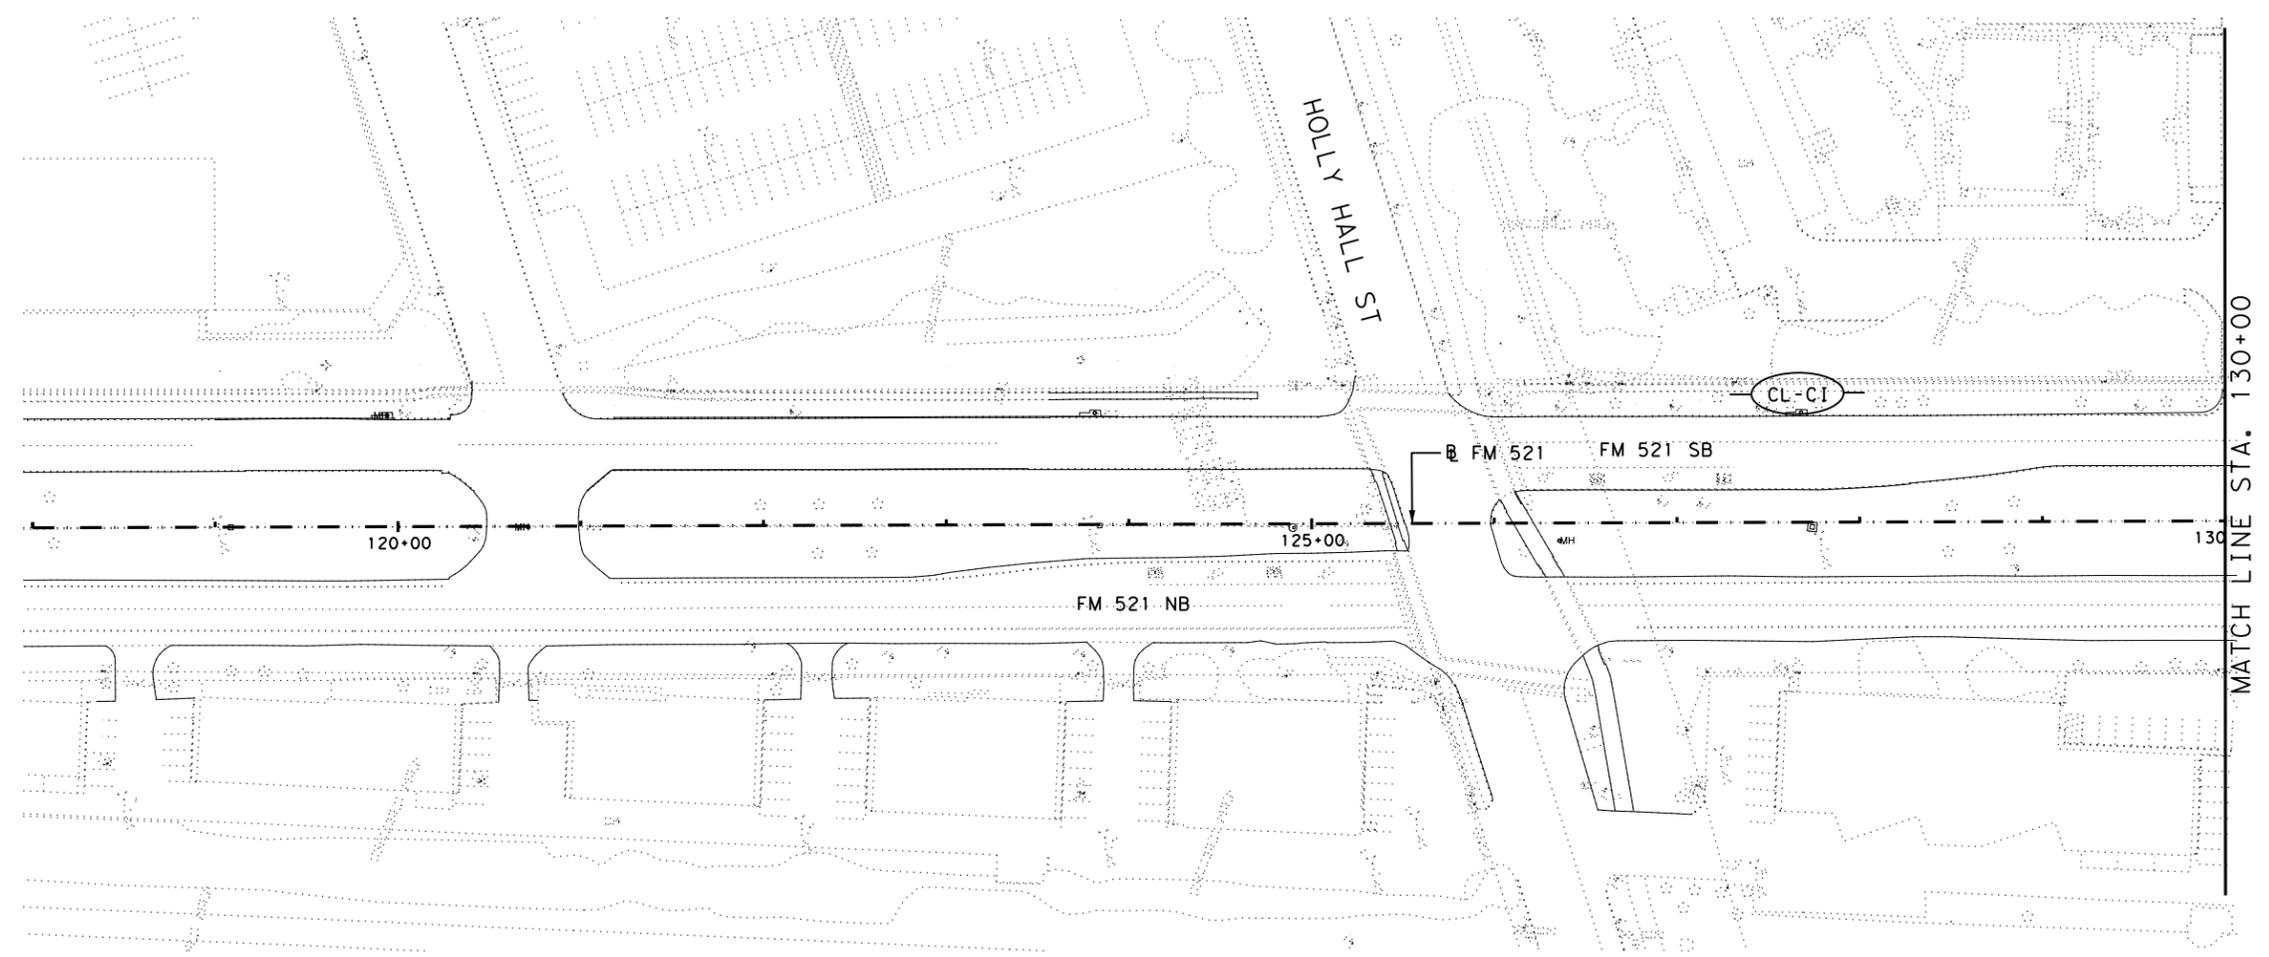


—(CL-CI)— EROSION CONTROL LOG AT CURB INLET

9/22/2020 2:18:03 PM T:\HUM-AO\Des\ign\Roadway\FM 521\0111-01-095.DGN\SWP3\79 SWP3 LAYOUT.dgn

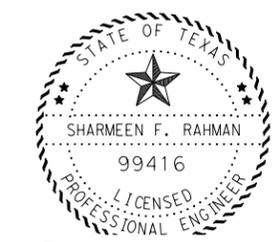



Sharmeen Rahman, P.E.
10/07/2020

 


FM 521
SWP3 LAYOUT

SCALE: 1" = 100'		SHEET 1 OF 5	
FED. RD. DIV. NO. 6	PROJECT NO. 095		SHEET NO. 79
STATE TEXAS	DIST HOU	COUNTY HARRIS	
CONT 0111	SECT 01	JOB 095	HIGHWAY FM 521

 9/22/2020 2:19:36 PM
 T:\HUM-AO\Des\ign\Roadway\FM 521\0111-01-095.DGN\SWP3\80 SWP3 LAYOUT.dgn

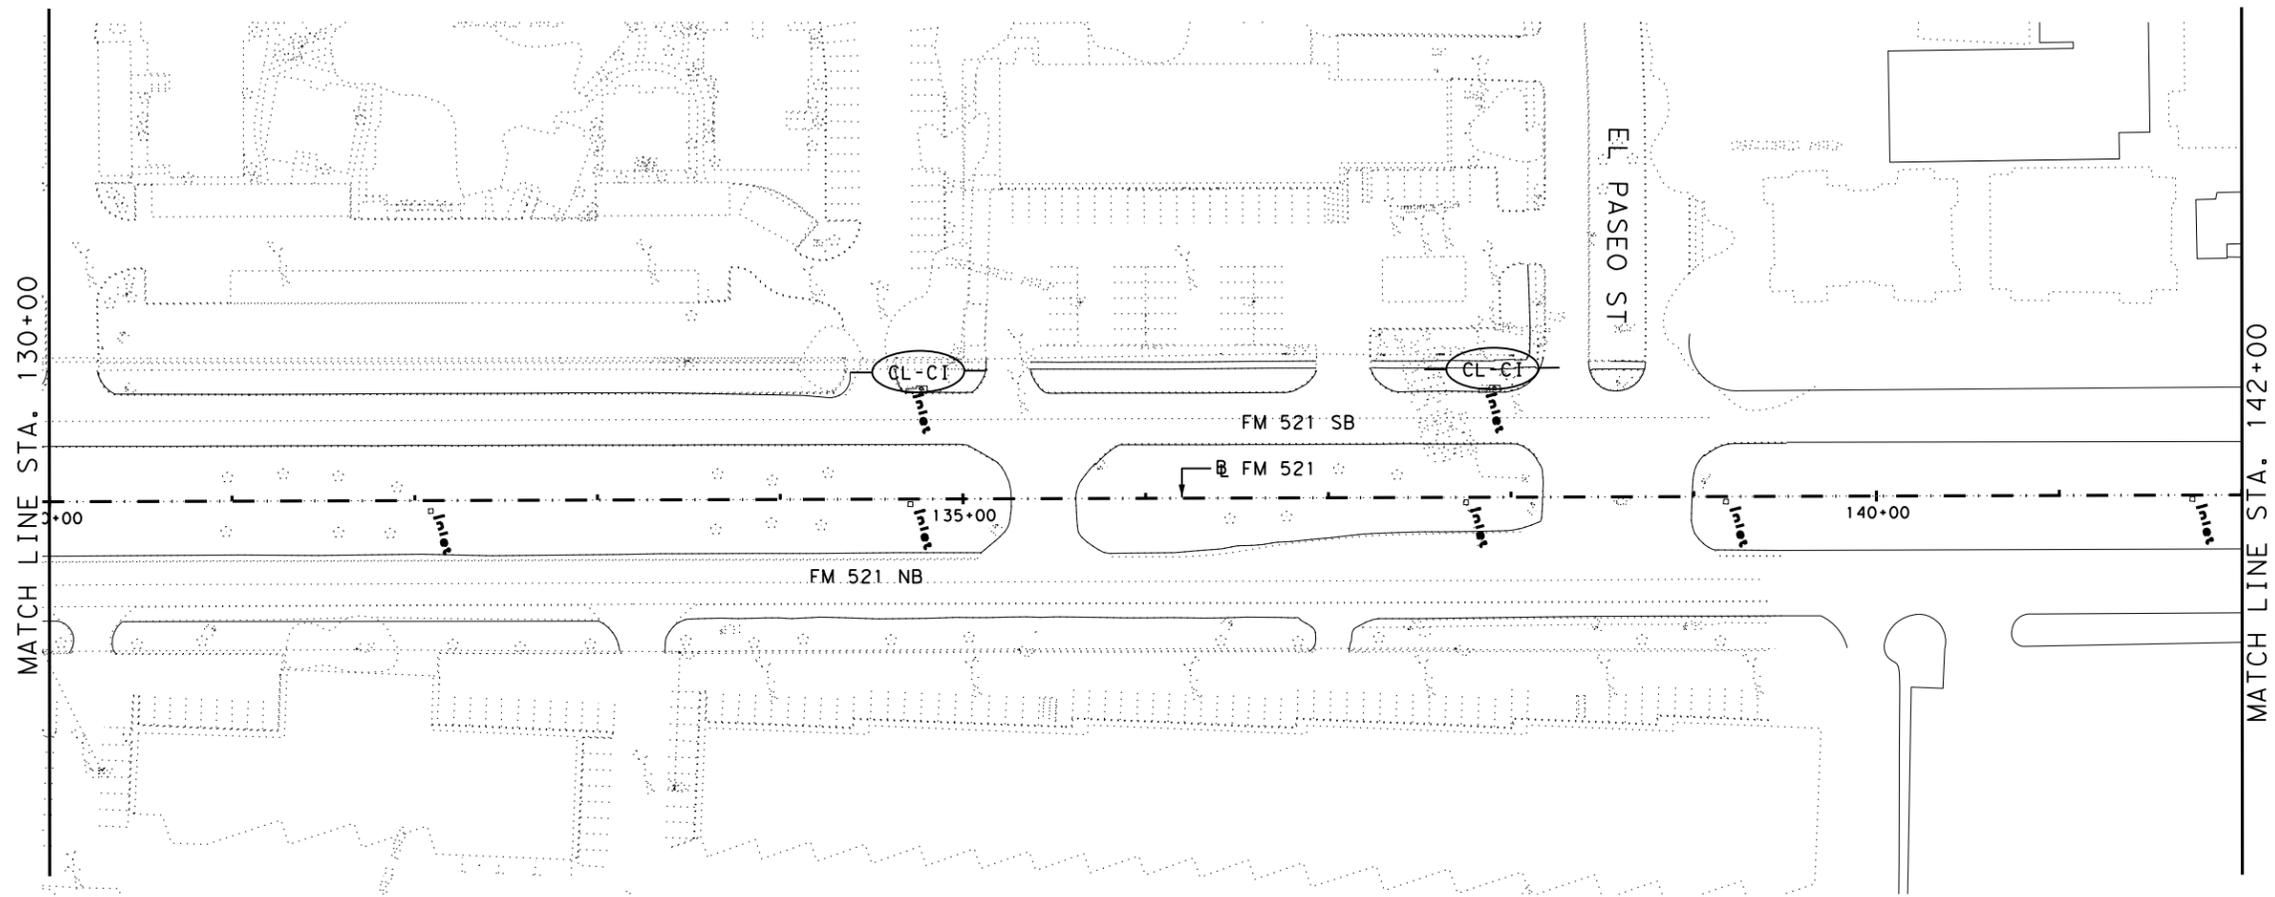


—(CL-CI)— EROSION CONTROL LOG AT CURB INLET

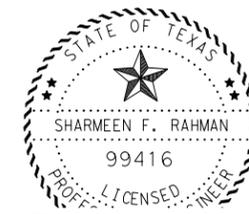


Sharmeen Rahman, P.E.

 10/07/2020



FM 521
 SWP3 LAYOUT

SCALE: 1" = 100'		SHEET 2 OF 5	
FED. RD. DIV. NO. 6	PROJECT NO. 095		SHEET NO. 80
STATE TEXAS	DIST HOU	COUNTY HARRIS	
CONT 0111	SECT 01	JOB 095	HIGHWAY FM 521

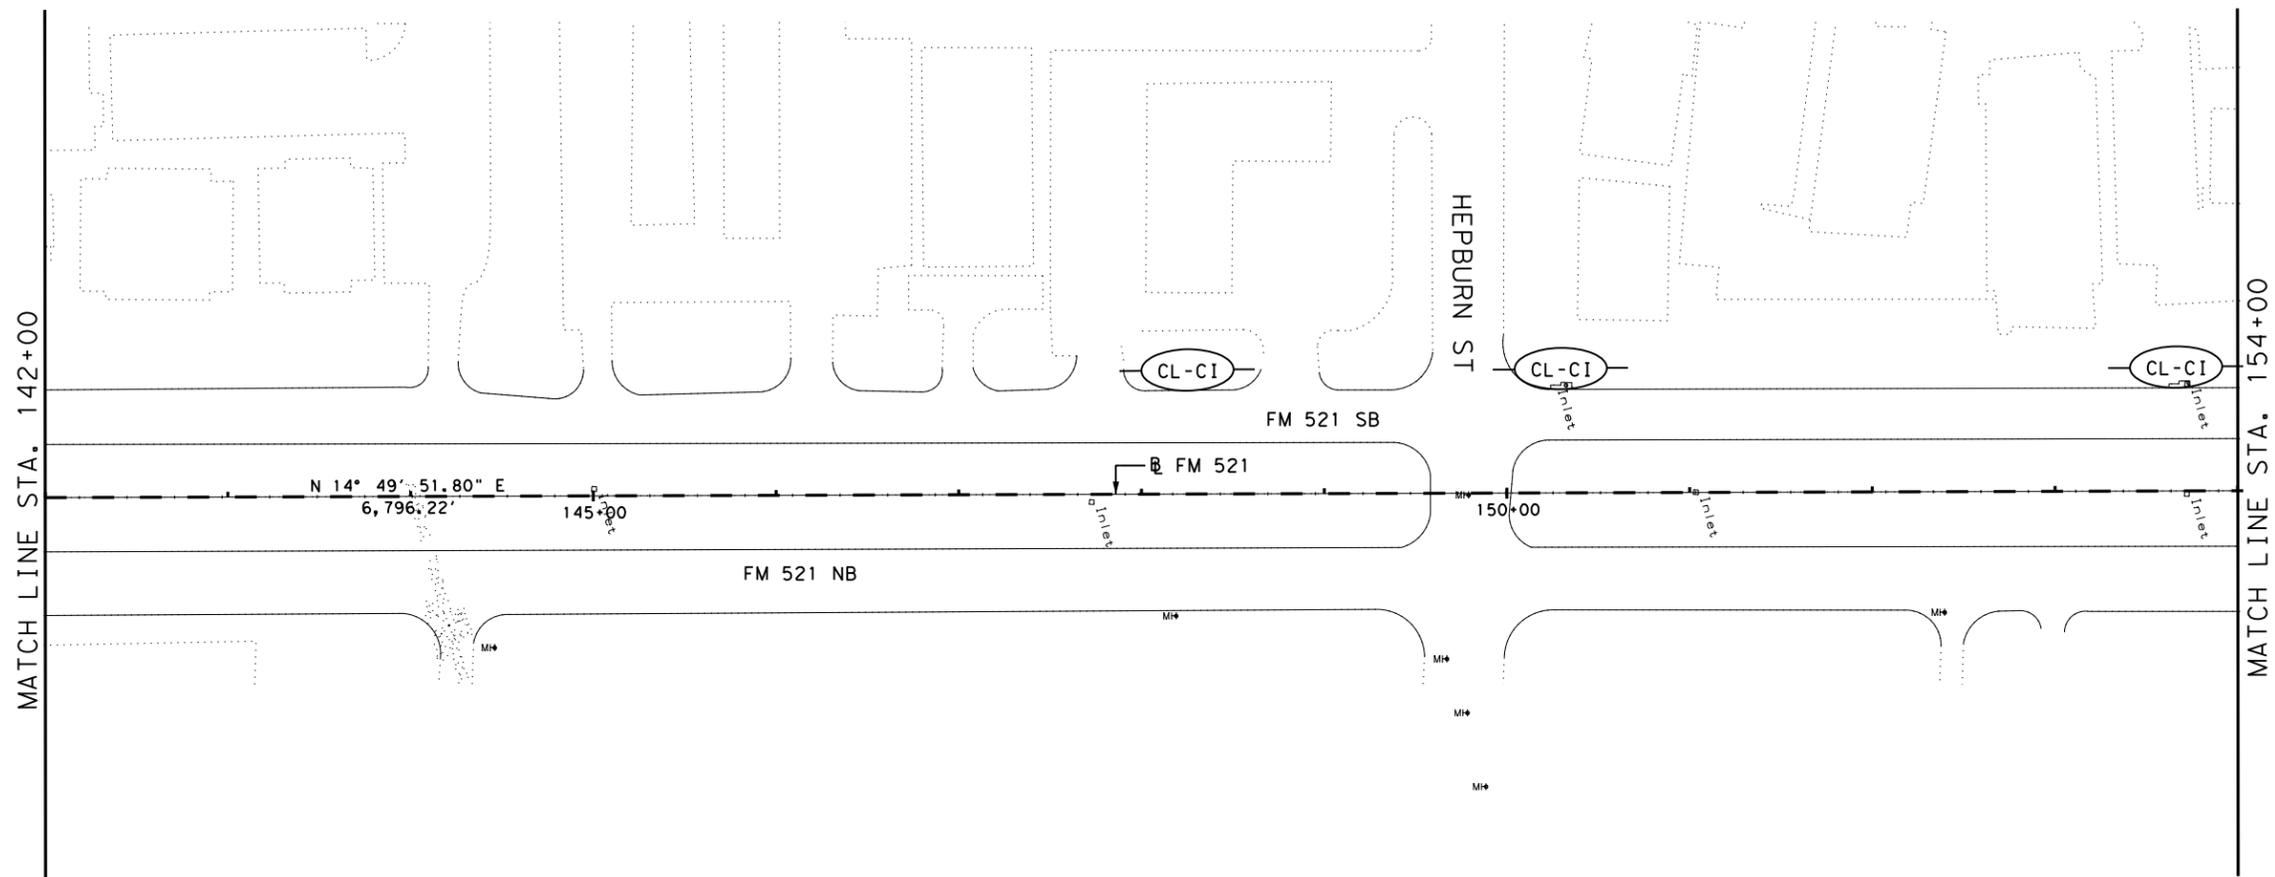


—(CL-CI)— EROSION CONTROL LOG AT CURB INLET



Sharmeen Rahman, P.E.

 
10/07/2020



FM 521
SWP3 LAYOUT

SCALE: 1" = 100'		SHEET 3 OF 5	
FED. RD. DIV. NO. 6	PROJECT NO. 095		SHEET NO. 81
STATE TEXAS	DIST HOU	COUNTY HARRIS	
CONT 0111	SECT 01	JOB 095	HIGHWAY FM 521

9/22/2020 2:28:15 PM
 T:\HUM-AO\Des\ign\Roadway\FM 521\0111-01-095.DGN\SWP3\82 SWP3 LAYOUT.dgn

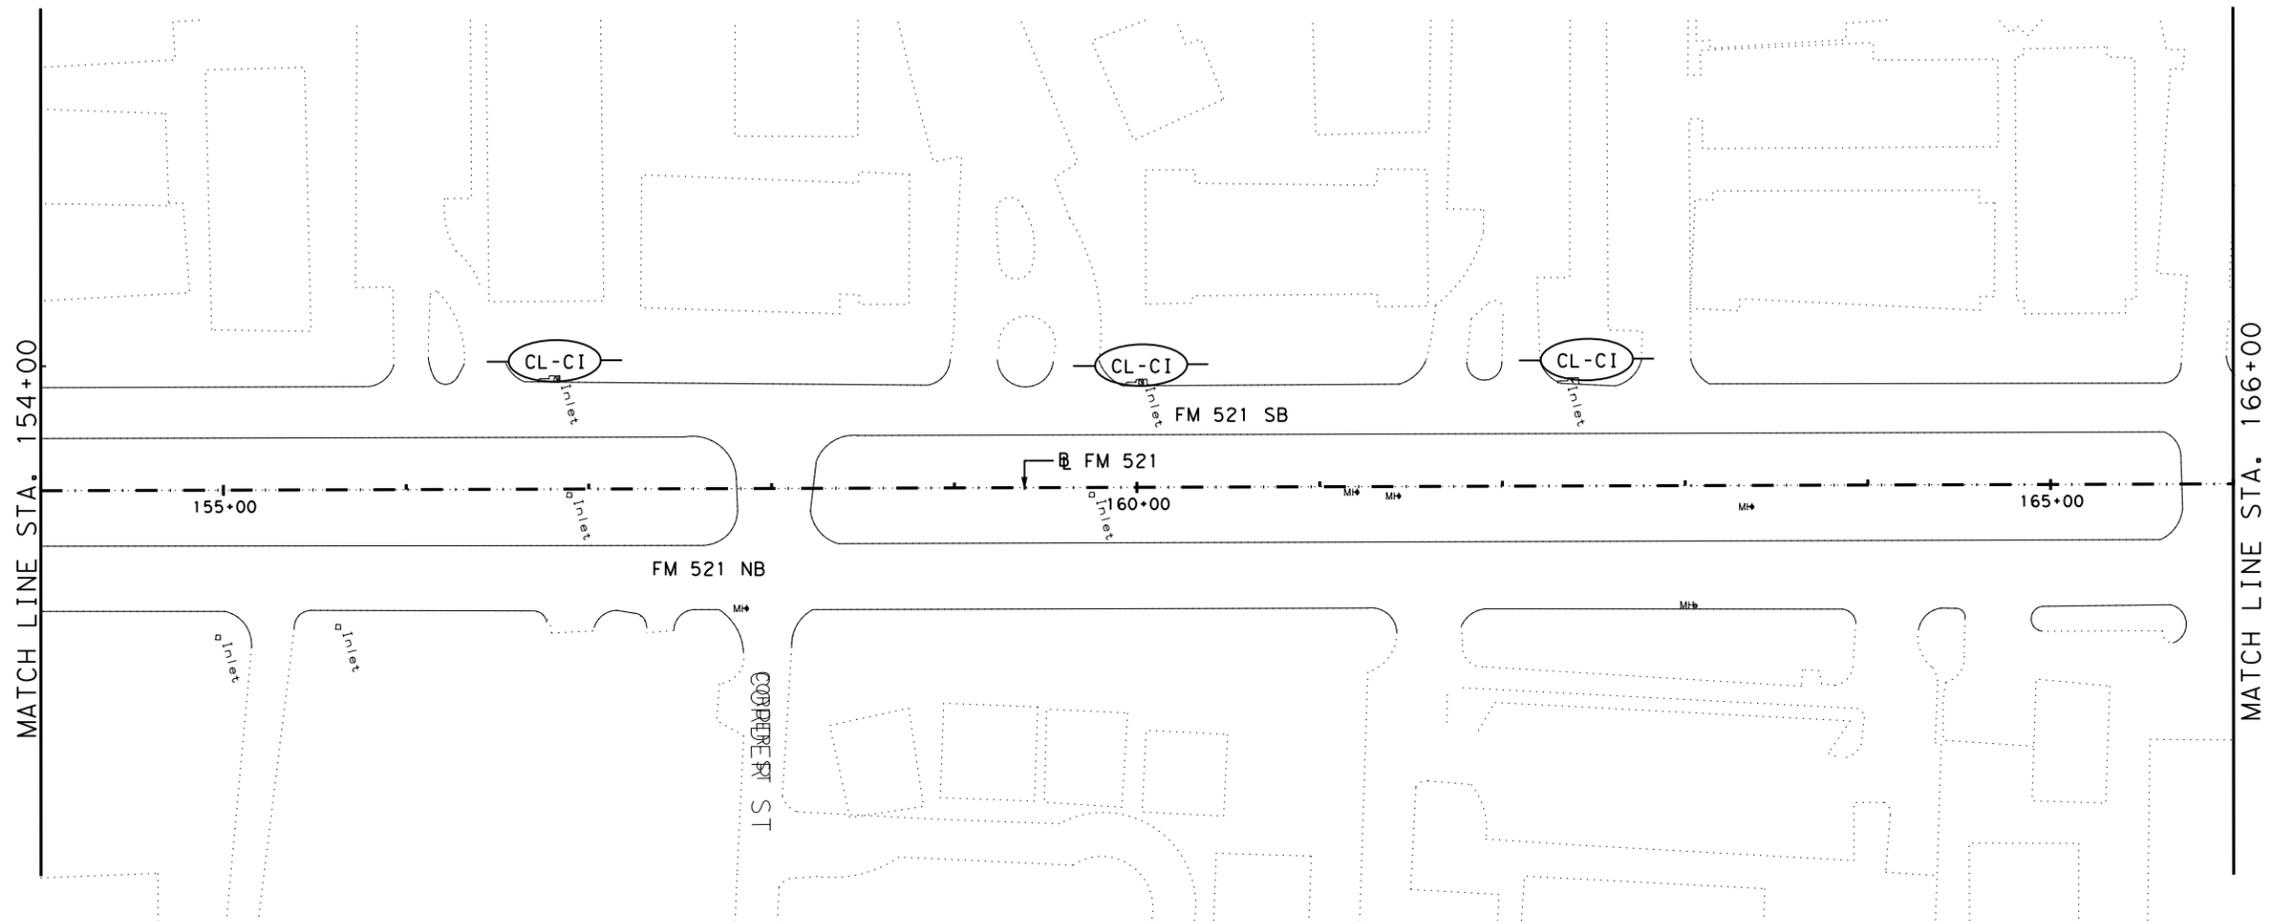


—(CL-CI)— EROSION CONTROL LOG AT CURB INLET



Sharmeen Rahman, P.E.


 
10/07/2020



FM 521
 SWP3 LAYOUT

SCALE: 1" = 100' SHEET 4 OF 5

FED. RD. DIV. NO.	PROJECT NO.		SHEET NO.
6			82
STATE	DIST	COUNTY	
TEXAS	HOU	HARRIS	
CONT	SECT	JOB	HIGHWAY
0111	01	095	FM 521

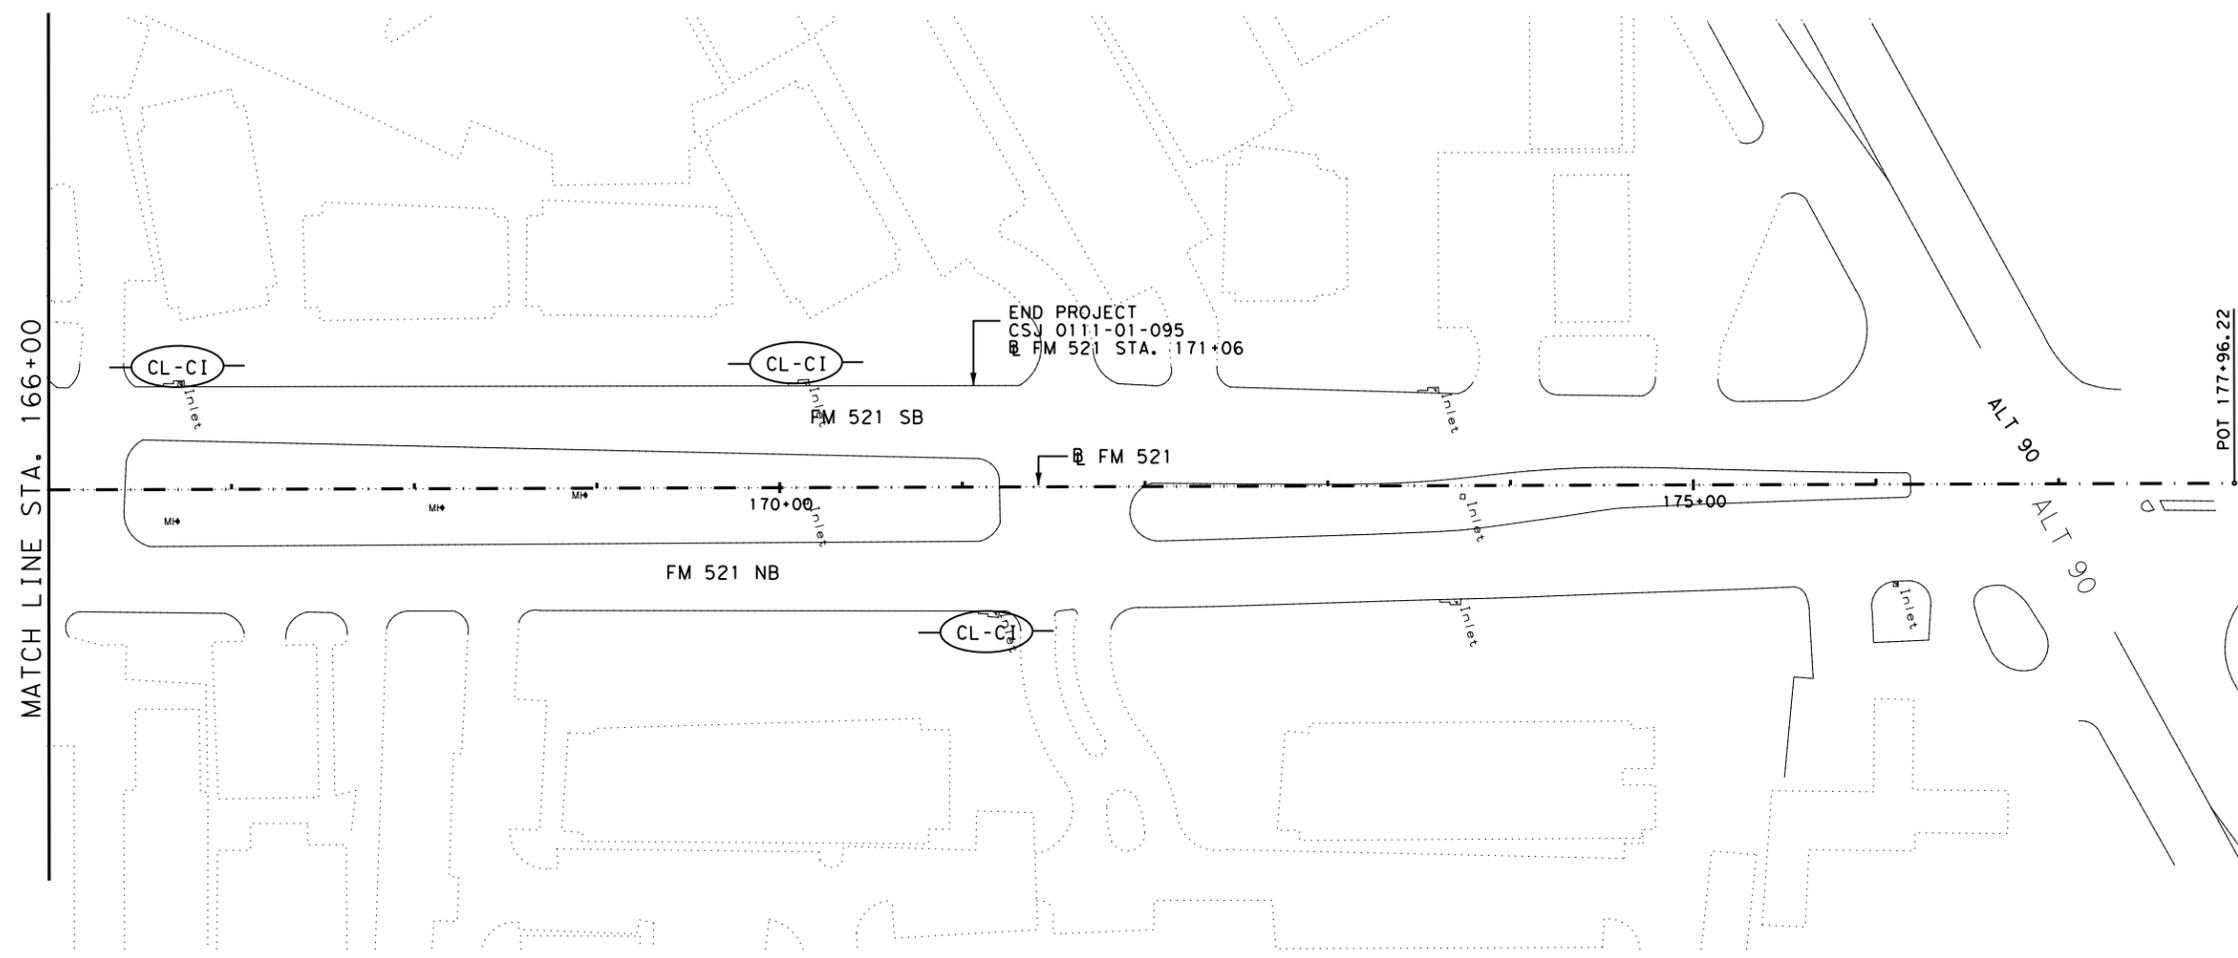 

—(CL-CI)— EROSION CONTROL LOG AT CURB INLET



Sharmeen Rahman, P.E.
10/07/2020



FM 521
SWP3 LAYOUT

SCALE: 1" = 100' SHEET 5 OF 5

FED. RD. DIV. NO.	PROJECT NO.		SHEET NO.
6	095		83
STATE	DIST	COUNTY	
TEXAS	HOU	HARRIS	
CONT	SECT	JOB	HIGHWAY
0111	01	095	FM 521

9/22/2020 2:31:12 PM T:\HUM-AO\Des\ign\Roadway\FM 521\0111-01-095\DGN\SWP3\83 SWP3 LAYOUT.dgn

SITE DESCRIPTION

PROJECT LIMITS: From 0.35 MI North of IH 610 to 0.106 MI South of ALT 90

PROJECT DESCRIPTION: Construction of Milling, 1.5" HMA Overlay with Seal Coat, Base Repair, Traffic Signal and Pavement Markings

MAJOR SOIL DISTURBING ACTIVITIES: removing concrete curb, construct dowel curb

TOTAL PROJECT AREA: 4.06

TOTAL AREA TO BE DISTURBED: Not Applicable

WEIGHTED RUNOFF COEFFICIENT: (AFTER CONSTRUCTION): 0.85

EXISTING CONDITION OF SOIL & VEGETATIVE COVER AND % OF EXISTING VEGETATIVE COVER: 6% is Bernard Clay loam, 33% Bernard-Edna, 27% Lake Charles Clay, 26% is Lake Charles-Urban Land, 6% is Bernard Urban Land and 2% is Urban Land

NAME OF RECEIVING WATERS: Braus Bayou (Segment ID# 10078)

EROSION AND SEDIMENT CONTROLS

SOIL STABILIZATION PRACTICES:

- TEMPORARY SEEDING
- PERMANENT PLANTING, SODDING, OR SEEDING
- MULCHING
- SOIL RETENTION BLANKET
- BUFFER ZONES
- PRESERVATION OF NATURAL RESOURCES

OTHER: _____

STRUCTURAL PRACTICES:

- SILT FENCES
- HAY BALES
- ROCK BERMS
- DIVERSION, INTERCEPTOR, OR PERIMETER DIKES
- DIVERSION, INTERCEPTOR, OR PERIMETER SWALES
- DIVERSION DIKE AND SWALE COMBINATIONS
- PIPE SLOPE DRAINS
- PAVED FLUMES
- ROCK BEDDING AT CONSTRUCTION EXIT
- TIMBER MATTING AT CONSTRUCTION EXIT
- CHANNEL LINERS
- SEDIMENT TRAPS
- SEDIMENT BASINS
- STORM INLET SEDIMENT TRAP
- STONE OUTLET STRUCTURES
- CURBS AND GUTTERS
- STORM SEWERS
- VELOCITY CONTROL DEVICES
- EROSION CONTROL LOGS

OTHER: _____

NARRATIVE - SEQUENCE OF CONSTRUCTION (STORM WATER MANAGEMENT) ACTIVITIES:

- INSTALL EROSION LOGS PRIOR TO COMMENCING WORK
- MAINTAIN EROSION CONTROL MEASURES THROUGHOUT PROJECT DURATION
- WHEN ALL WORK IS COMPLETE AND APPROVED BY ENGINEER, REMOVE ALL TEMPORARY EROSION CONTROL MEASURES.

STORM WATER MANAGEMENT:

ANY DEVICES REQUIRED TO MINIMIZE SEDIMENT RUNOFF IN THE EVENT OF A STORM WILL BE PLACED IN POSITION BEFORE CONSTRUCTION BEGINS. THE STORM WATER DRAINAGE WILL BE PROVIDED BY THE EXISTING SYSTEMS ALREADY IN PLACE. WATER WITHIN THE RIGHT OF WAY WILL BE CARRIED BY DITCHES TO LOWS IN THE ROAD PROFILE WHERE IT WILL OUTFALL INTO RECEIVING WATERS.

OTHER EROSION AND SEDIMENT CONTROLS:

MAINTENANCE: All erosion and sediment controls will be maintained in good working order. If a repair is necessary it will be done at the earliest date possible, but no later than 7 calendar days after the surrounding exposed ground has dried sufficiently to prevent further damage from heavy equipment. The area adjacent to creeks and drainageways shall have priority followed by devices protecting storm sewer inlets.

INSPECTION: All inspections will be performed by a TxDOT inspector per one of the options below as directed by the Area Engineer
 1. At least every 7 calendar days
 2. At least every 14 days or after 0.5 inches or more of rainfall
An inspection and maintenance report should be made for each inspection. Based on the inspection results, the controls shall be revised according to the inspection report.

WASTE MATERIALS: The dumpster used to store all waste material will meet all state and local city solid waste management regulations. All trash and construction debris will be deposited in the dumpster. The dumpster will be emptied as necessary or as required by local regulation and the trash will be hauled to a local dump. No construction waste material will be buried on site.

HAZARDOUS WASTE (INCLUDING SPILL REPORTING): In the event of a spill which may be considered hazardous, the Houston District Safety Office shall be contacted immediately at 713-802-5962.

SANITARY WASTE: All Sanitary Waste will be collected from the portable units as necessary or as required by local regulations by a licensed sanitary waste management contractor.

OFFSITE VEHICLE TRACKING:

- HAUL ROADS DAMPENED FOR DUST CONTROL
- LOADED HAUL TRUCKS TO BE COVERED WITH TARPULIN
- EXCESS DIRT ON ROAD REMOVED DAILY
- STABILIZED CONSTRUCTION ENTRANCE

OTHER: _____

REMARKS: Disposal areas, stockpiles, and haul roads shall be constructed in a manner that will minimize and control the sediment that may enter receiving waterways. Disposal areas shall not be located in any waterway, waterbody or streambed. Construction staging areas and vehicle maintenance areas shall be constructed by the Contractor in a manner which minimizes the runoff of all pollutants. All waterways shall be cleared as soon as practical of temporary embankments, temporary bridges, matting, falsework, piling, debris, and other obstructions placed during construction operations that are not part of the finished work.

SHARMEEN F. RAHMAN, P.E. DATE
10/07/2020

Texas Department of Transportation
Houston District

TxDOT STORM WATER POLLUTION PREVENTION PLAN

SWP3

FILE: STDG1.DGN	DN: TxDot	CK: TxDot	DW: TxDot	CK: TxDot
© TxDOT JANUARY 2007	DIST	FED REG	PROJECT NO.	SHEET
REVISIONS	HOU	6		84
9/2010 INSPECTION NOTE	COUNTY	CONTROL	SECT	JOB
9/2013 INSPECTION NOTE	HARRIS	0111	01	095
11/2013 SW3P TO SWP3				FM 521
03/2015 2014 SPECS				

9/21/2020 1:28:06 AM
T:\VHM\40\Des\Ign\Roadway\FM 521\0111-01-095\DCN\SWP3\SWP3.dgn

<p>I. STORMWATER POLLUTION PREVENTION</p> <p>Texas Pollutant Discharge Elimination System (TPDES) TXR 150000: Stormwater Discharge Permit or Construction General Permit is required for projects with 1 or more acres disturbed soil. Projects with any disturbed soil must protect for erosion and sedimentation in accordance with Item 506. Refer to Storm Water Pollution Prevention Plan (SWP3) Houston District standard plan.</p> <p>No Additional Comments</p>	<p>III. CULTURAL RESOURCES</p> <p>Refer to TxDOT Standard Specifications in the event historical issues or archeological artifacts are found during construction. Upon discovery of archeological artifacts (bones, burnt rock, flint, pottery, etc.) cease work in the area and contact the Engineer immediately.</p> <p>No Additional Comments</p>	<p>VI. HAZARDOUS MATERIALS OR CONTAMINATION ISSUES</p> <p>Refer to TxDOT Standard Specifications in the event potentially contaminated materials are observed, such as dead or distressed vegetation, trash disposal areas, drums, canisters, barrels, leaching or seepage of substances, unusual smells or odors, or stained soil, cease work in the area and contact the Engineer immediately.</p> <p>No Additional Comments</p>
<p>II. WORK IN OR NEAR STREAMS, WATERBODIES AND WETLANDS</p> <p>United States Army Corps of Engineers (USACE) Permit is required for filling, dredging, excavating or other work in water bodies, rivers, creeks, streams, wetlands or wet areas. The Contractor must adhere to all of the terms and general conditions associated with the following permit(s). If additional work not represented in the plans is required, contact the Engineer immediately.</p> <p><input checked="" type="checkbox"/> No United States Army Corps (USACE) Permit Required</p> <p><input type="checkbox"/> Work is authorized by the United States Army Corps of Engineers (USACE) under a Nationwide Permit (NWP) without a Pre-Construction Notification (PCN). Project specific permit was not issued by USACE, therefore is not in the plan set. The USACE general conditions are in the "General Notes."</p> <p><input type="checkbox"/> Work is authorized by the United States Army Corps of Engineers (USACE) under a Nationwide Permit (NWP) with a Pre-Construction Notification (PCN). The project specific permit issued by the United States Army Corps of Engineers (USACE) is included in the plan set. The USACE general conditions are in the "General Notes."</p> <p><input type="checkbox"/> Work is authorized by the United States Army Corps of Engineers (USACE) under a Individual Permit (IP). The project specific permit issued by the United States Army Corps of Engineers (USACE) is included in the plan set.</p> <p><input type="checkbox"/> Work would be authorized by the United States Army Corps of Engineers (USACE) permit. The project specific permit issued by the USACE will be provided to the contractor.</p> <p>United States Coast Guard (USCG) Permit is required for projects that involve the construction or modification (including changes to lighting) of a bridge or causeway across a water body determined to be navigable by the United States Coast Guard (USCG) under Section 9 of the Rivers and Harbors Act. If additional work not represented in the plans is required, contact the Engineer immediately.</p> <p><input checked="" type="checkbox"/> No United States Coast Guard (USCG) Coordination Required</p> <p><input type="checkbox"/> United States Coast Guard (USCG) Permit</p> <p><input type="checkbox"/> United States Coast Guard (USCG) Exemption</p> <p>No Additional Comments</p>	<p>IV. VEGETATION RESOURCES</p> <p>Preserve native vegetation to the extent practical. Refer to TxDOT Standard Specifications in order to comply with requirements for invasive species, beneficial landscaping and tree/brush removal.</p> <p>No Additional Comments</p> <p>V. FEDERAL LISTED, PROPOSED THREATENED, ENDANGERED SPECIES, CRITICAL HABITAT, STATE LISTED SPECIES, CANDIDATE SPECIES AND MIGRATORY BIRDS</p> <p>If any of the listed species below are observed, cease work in the area, do not disturb species or habitat and contact the Engineer immediately.</p> <p>The work may not remove active nests (from bridges, structures, or vegetation adjacent to the roadway, etc.) during nesting season (February 15 to October 1). If removal of structures or vegetation is necessary during the nesting season, the Contractor shall conduct a bird survey no more than 3 days in advance of the clearing/demolish start date. All bird surveys shall be conducted by a Field Biologist and adhere to the guidance document "Avoiding Migratory Birds and Handling Potential Violations" found in the TxDOT Environmental Compliance Toolkits at the time of the survey. (See below for Field Biologist and Ornithologist qualifications)</p> <p>No Additional Comments</p> <p>Field Biologist, Ornithologist – a field biologist is defined as an individual qualified to perform field investigations, presence/absence surveys and habitat surveys for protected avian species or species of concern. A mandatory bachelor's degree in biology or a related science is required. At a minimum, the Field Biologist, Ornithologist, shall have completed and reported a minimum of three presence/absence and habitat surveys for protected avian species in the past five years. A minimum of three projects must have been conducted in Texas. Surveys shall have been performed for documentation of species in accordance with a protocol approved by USFWS or TPWD, or following generally accepted methodologies.</p>	<p>VII. OTHER ENVIRONMENTAL ISSUES</p> <p>Comments:</p>


DATE: Aug 17, 2020
FILE:

				TxDOT Houston District	
<p>ENVIRONMENTAL PERMITS, ISSUES AND COMMITMENTS</p> <p>EPIC</p>					
FILE:	EPIC Sheet.dgn	DN:	CK:	DW:	CK:
© TxDOT: March 2017	CONT	SECT	JOB	HIGHWAY	
REVISIONS	0111	01	095	FM 521	
UPDATED section V, text and added definition (10/17)	DIST	COUNTY		SHEET NO.	
ADDED USCG and USACE notes in Section VII (04/18)	Hou	Harris		85	

Version 2.1




CURB INLETS 8" DIAMETER LOGS

ITEM 506-6040 BIODEG EROSN CONT LOGS (INSTL) (8")

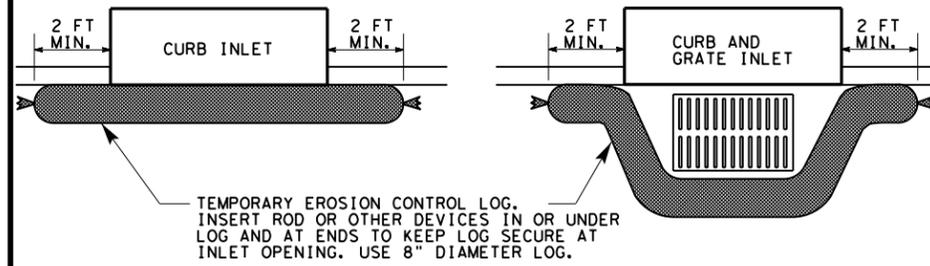

DROP INLETS AND OTHER LOCATIONS 12" DIAMETER LOGS

ITEM 506-6041 BIODEG EROSN CONT LOGS (INSTL) (12")

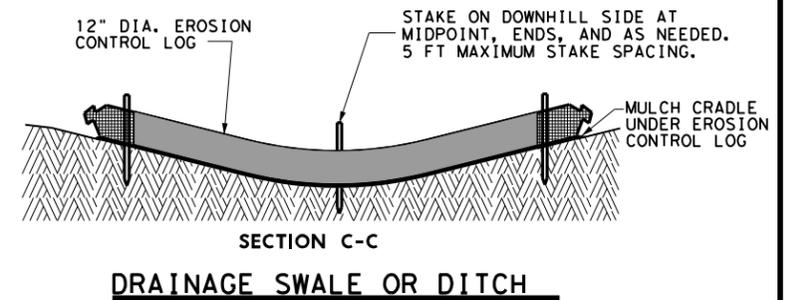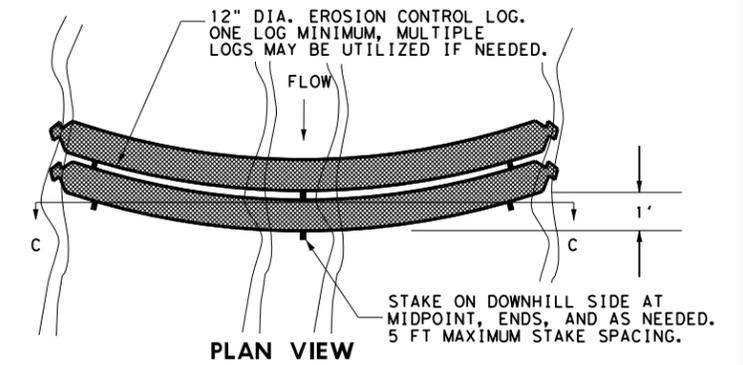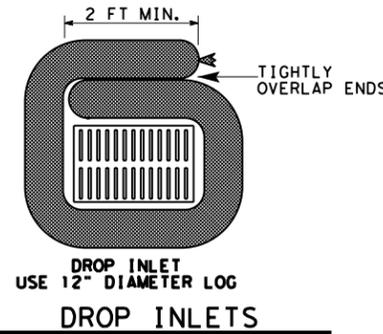

MATERIAL REQUIREMENTS

FILL:

Use 100% shredded mulch or other non-compost biodegradable material as fill for logs. No compost or fines.

DO NOT USE MATERIAL WHICH PROHIBITS WATER INFILTRATION.

LOG MESH:

Use mesh with 1/4" openings or larger. Mesh must allow water infiltration but also hold fill material in place.

SEDIMENT BASIN & TRAP USAGE GUIDELINES

A sediment trap (erosion control log) may be used to filter sediment out of runoff draining from an unstabilized area.

Traps: The drainage area for a sediment trap should not exceed 5 acres. The trap capacity should be 1800 CF/Acre (0.5" over the drainage area).



Sediment traps should be placed in the following locations:

1. Within drainage ditches spaced as needed or min. 500' on center
2. Immediately preceding ditch inlets
3. Just before the drainage enters a water course
4. Just before the drainage leaves the right of way



The trap should be cleaned when the capacity has been reduced by 1/2 or the sediment has accumulated to a depth of 1', whichever is less.

REQUIRED ITEMS:


- ITEM 506-6040 BIODEG EROSN CONT LOGS (INSTL) (8") LF
- ITEM 506-6041 BIODEG EROSN CONT LOGS (INSTL) (12") LF
- ITEM 506-6043 BIODEG EROSN CONT LOGS (REMOVE) LF

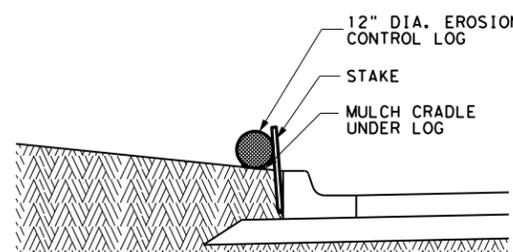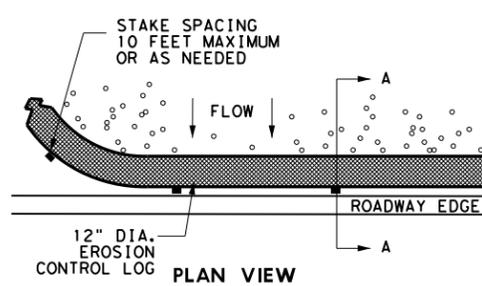


SECTION A-A
SLOPE TO ROADWAY EDGE

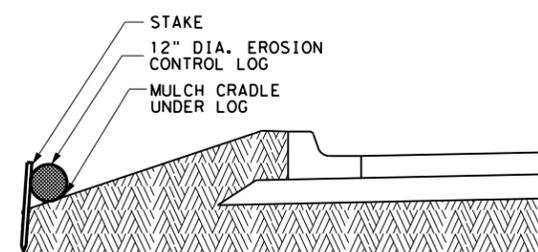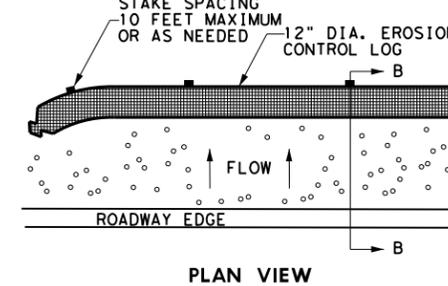

SECTION B-B
SLOPE AWAY FROM ROADWAY EDGE

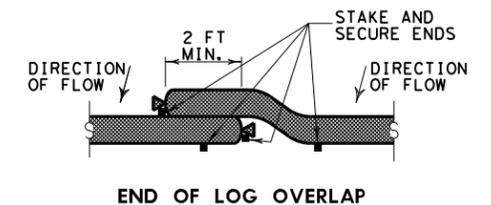

END OF LOG OVERLAP

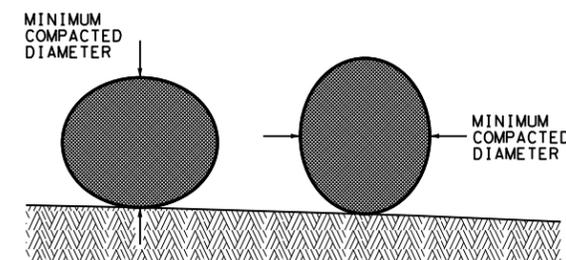

DIAMETER MEASUREMENTS OF EROSION CONTROL LOGS SPECIFIED IN PLANS

EROSION CONTROL LOG

ECL-12

FILE: STDG4a.DGN	DN: TxDot	CK: TxDot	OW: TxDot	CK: TxDot
©TXDOT 2014	DISTRICT	FED REG	PROJECT NUMBER	SHEET
REVISIONS	HOU	6		86
3/15 MINOR CORRECTIONS	COUNTY	CONTROL	SECT	JOB
	HARRIS	0111	01	095 FM 52