

FINAL PLANS

NAME OF CONTRACTOR: \_\_\_\_\_  
 DATE OF LETTING: \_\_\_\_\_  
 DATE WORK BEGAN: \_\_\_\_\_  
 DATE WORK COMPLETED: \_\_\_\_\_  
 DATE WORK ACCEPTED: \_\_\_\_\_  
 SUMMARY OF CHANGE ORDERS: \_\_\_\_\_

STATE OF TEXAS  
 DEPARTMENT OF TRANSPORTATION

PLANS OF PROPOSED  
 STATE HIGHWAY IMPROVEMENT

FEDERAL AID PROJECT  
 F 2B23(095)  
 CSJ: 0092-14-104

IH 45  
 DALLAS COUNTY

LIMITS: FROM OVERTON RD  
 TO IH 20

TOTAL LENGTH OF PROJECT =  
 ROADWAY = 21,895.84 FT. = 4.147 MI.  
 BRIDGE = 3,728.00 FT. = 0.706 MI.  
 TOTAL = 25,623.84 FT. = 4.853 MI.

FOR THE CONSTRUCTION OF SAFETY IMPROVEMENT PROJECT  
 CONSISTING OF ADD CONCRETE BARRIER


DESIGN SPEEDS = N/A

ADT = 94,088 (2023)  
 = 130,276 (2043)  
 FUNCTIONAL CLASSIFICATION = URBAN INTERSTATE

**NOTE:**

SPECIFICATIONS ADOPTED BY THE TEXAS DEPARTMENT OF TRANSPORTATION, NOVEMBER 1, 2014, AND THE CONTRACT PROVISIONS LISTED AND DATED AS FOLLOWS SHALL GOVERN ON THIS PROJECT: REQUIRED CONTRACT PROVISIONS FOR ALL FEDERAL-AID CONSTRUCTION CONTRACTS (FORM FHWA 1273, July 5, 2022)

DESIGN	FED.RD. DIV.NO.	FEDERAL AID PROJECT NO.			
SB	6	F 2B23(095)			
GRAPHICS	STATE	CONT	SECT	JOB	HIGHWAY NO.
SB	TEXAS	0092	14	104	IH 45
CHECK	CHECK	DIST	COUNTY		SHEET NO.
DN	NP	18	DALLAS		1

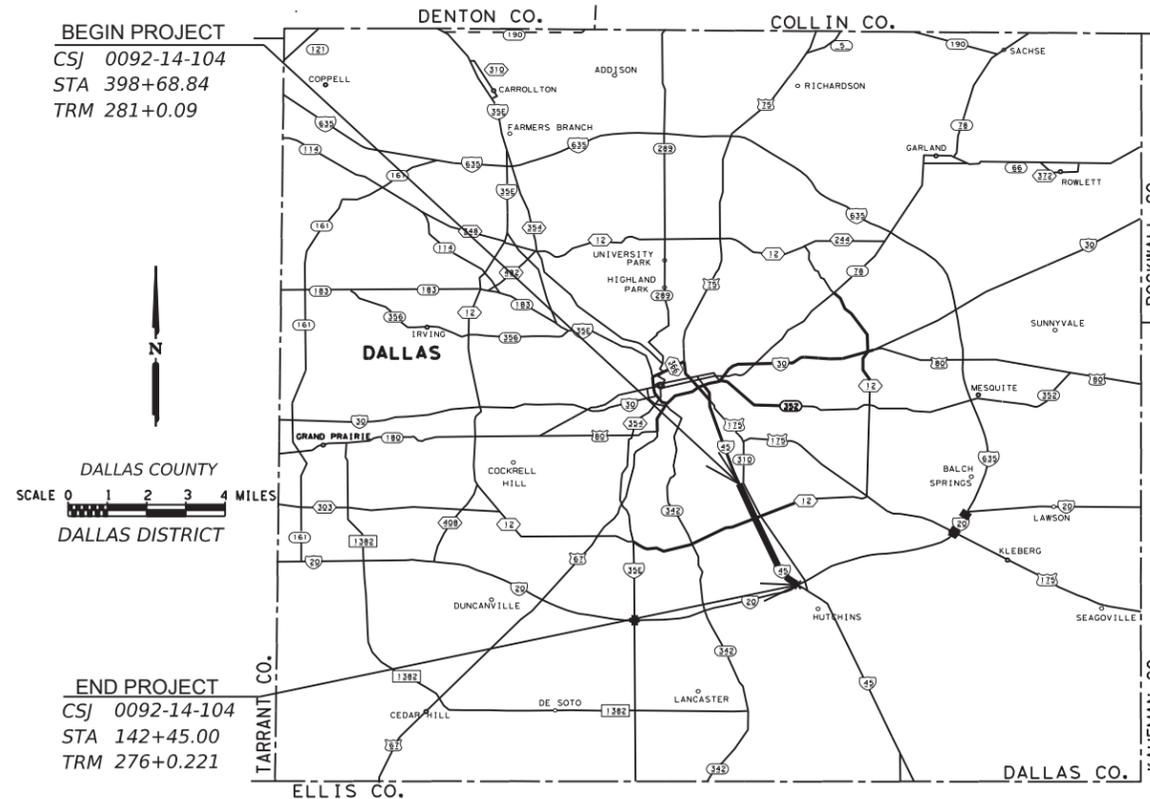

EQUATIONS: N/A  
 EXCEPTIONS: N/A  
 RAILROAD CROSSINGS: N/A

WORK WAS COMPLETED ACCORDING  
 TO THE PLANS AND CONTRACT.

\_\_\_\_\_, P.E.  
 Signature of Registrant & Date

TEXAS DEPARTMENT OF TRANSPORTATION

SUBMITTED FOR LETTING: 5/26/2023  
 Solomon Bayou, P.E.  
 DESIGN ENGINEER

RECOMMENDED DocuSigned by: 5/30/2023  
 \_\_\_\_\_, P.E.  
 91B8F2112C2C409...GINEER

RECOMMENDED DocuSigned by: 5/30/2023  
 James P. Campbell, P.E.  
 98671C109B6A4C3...RTATION PLANNING & DEVELOPMENT

APPROVED DocuSigned by: 5/30/2023  
 Casson Clemens, P.E.  
 A879E0D10CD6464...ER

# INDEX OF SHEETS

## I. GENERAL

- 1 TITLE SHEET
- 2 INDEX OF SHEETS
- 3-4 PROJECT LAYOUT
- 5 TYPICAL SECTIONS
- 6, 6A-6B GENERAL NOTES
- 7 ESTIMATE & QUANTITY SHEET
- 8 QUANTITY SUMMARY

## II. TRAFFIC CONTROL PLAN

- 9 TCP NARRATIVES
- 10 CRASH CUSHIONS SUMMARY

### TRAFFIC CONTROL PLAN STANDARDS

- \* 11-22 BC (1)-21 THRU BC (12)-21
- \* 23 TCP (5-1)-18
- \* 24 TCP (6-1)-12

## III. ROADWAY DETAILS

- 25-30 PLAN LAYOUT

### ROADWAY DETAILS STANDARDS

- \* 31 SSCB(1F)-10
- \* 32-33 CSB(1)-10
- \* 34 TAU-II-R(N)-16
- \* 35 REACT(M)-21
- \* 36 SLED-19
- \* 37 CRR

## IV. RETAINING WALL DETAILS

NONE

## V. DRAINAGE DETAILS

NONE

## VI. UTILITY

NONE

## VII. BRIDGE

NONE

## VIII. TRAFFIC ITEMS

NONE

### STANDARDS

- \* 38-39 D&OM (1)-20 THRU D&OM (2)-20

### SIGNING & PAVEMENT MARKING STANDARDS

NONE

## IX. ENVIRONMENTAL ISSUES

- 40 ENVIRONMENTAL PERMITS, ISSUES AND COMMITMENTS (EPIC) (DAL)
- 41-42 STORM POLLUTION PREVENTION PLAN (SW3P)
- 43-48 SW3P LAYOUT

### ENVIRONMENTAL ISSUES STANDARDS

- \* 49 EC (2)-16
- \* 50 EC (3)-16
- \* 51-53 EC (9)-16
- \* 54 VEGETATION ESTABLISHMENT SHEET (DAL)
- \* 55 SW3P SIGN SHEET (DAL)

## X. MISCELLANEOUS ITEMS

NONE

## XI. RAILROAD ITEMS

NONE



\* THE STANDARD SHEETS SPECIFICALLY IDENTIFIED ABOVE HAVE BEEN SELECTED BY ME OR UNDER MY RESPONSIBLE SUPERVISION AS BEING APPLICABLE TO THIS PROJECT.



*Solomon Bayou*, P.E. 5/26/2023  
Signature of Registrant & Date

IH 45			
INDEX OF SHEETS			
SHEET 1 OF 1			
CONT	SECT	JOB	HIGHWAY
0092	14	104	IH 45
DIST	COUNTY	SHEET NO.	
18	DALLAS	2	


CK: DN  
DW: SB  
CK: DN  
DW: SB



BEGIN PROJECT  
CSJ: 0092-14-104  
STA. 142+45.00

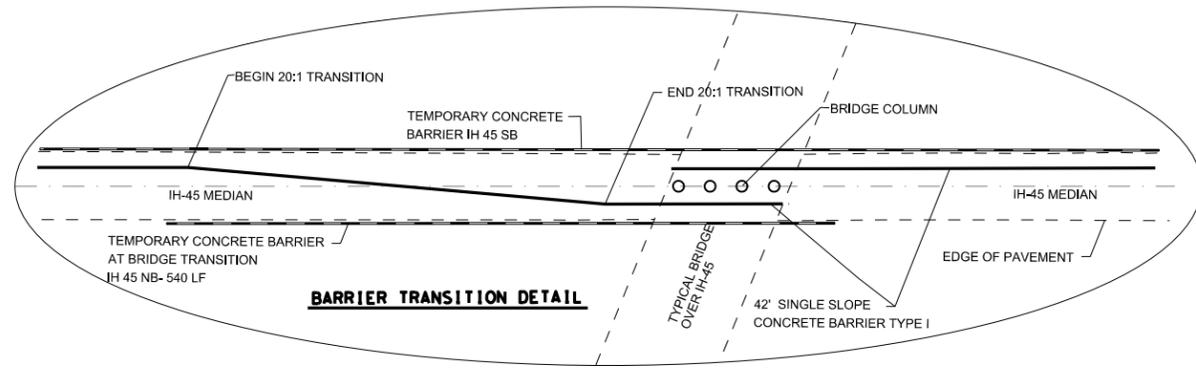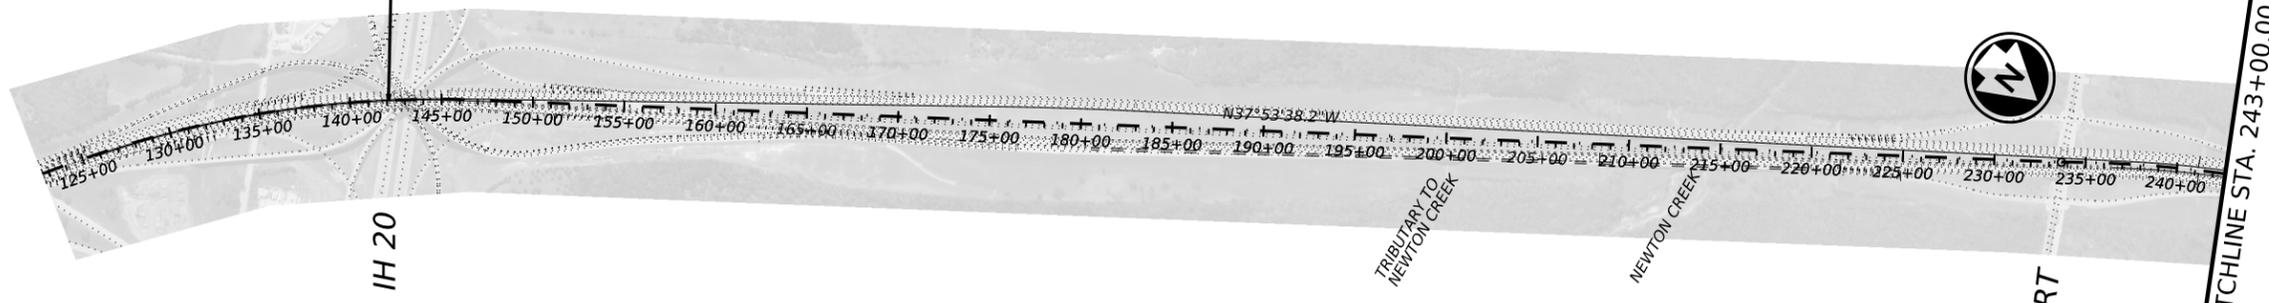

- NOTE:
1. PLACE ADVANCE WARNING SIGNS IN ACCORDANCE WITH THE BC, TCP, AND WZ STANDARD SHEETS AND TMUTCD ON IH 45 MAIN LANES AND RAMPS.
  2. REFER TO BC STANDARD SHEETS FOR LOCATION OF SIGNS.
  3. ANCHOR DRILLED SHAFT FOUNDATION TO BE USED FOR SSCB BARRIER. SEE STANDARD SSCB(1F)-10 DRILLED SHAFT ANCHOR DETAILS FOR MORE INFORMATION.

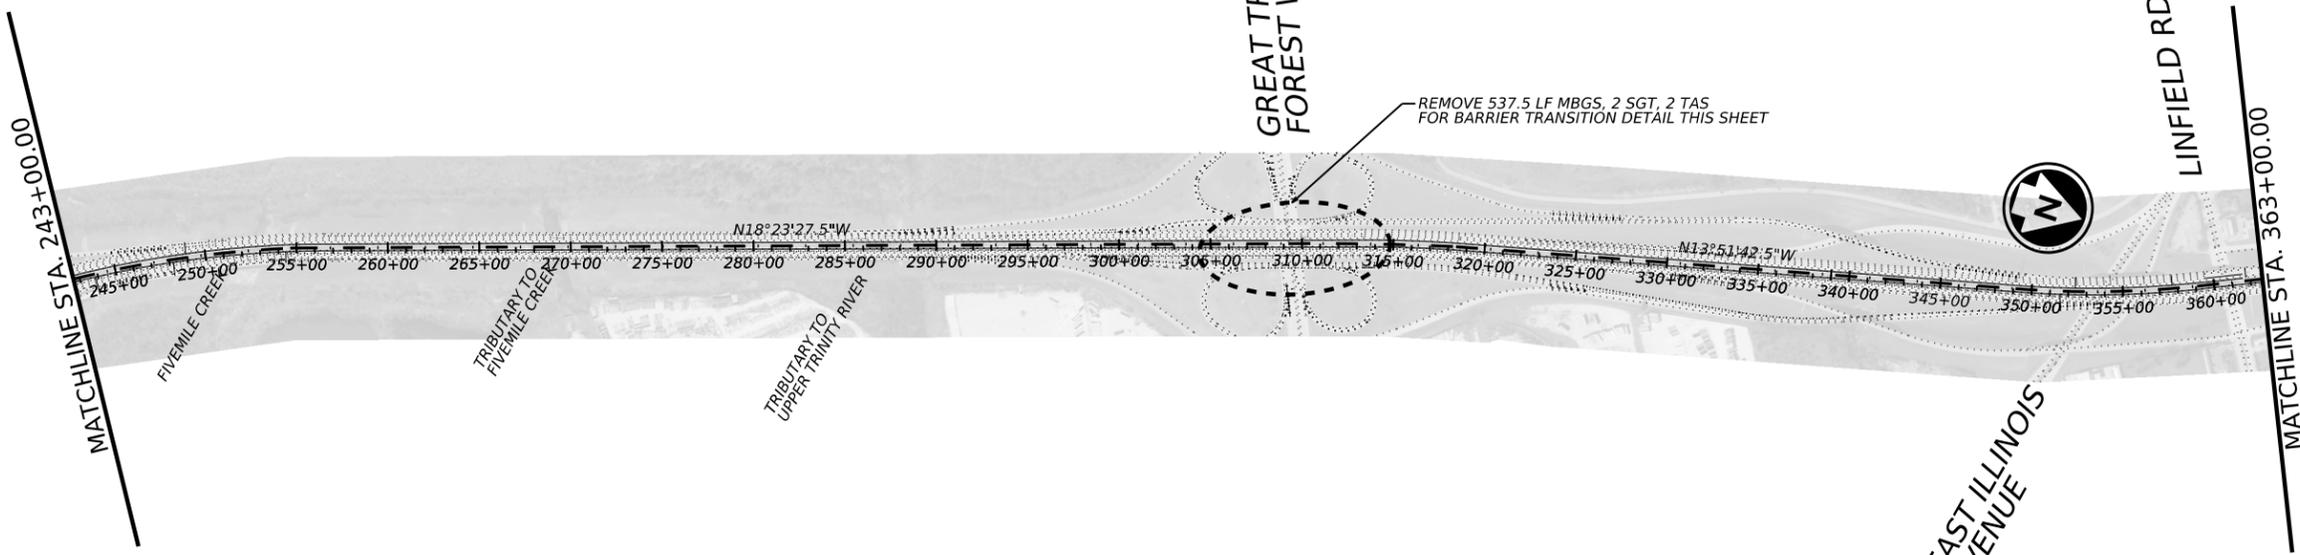

REMOVE 537.5 LF MBGS, 2 SGT, 2 TAS FOR BARRIER TRANSITION DETAIL THIS SHEET





Solomon Bayou, P.E. 5/26/2023  
Signature of Registrant & Date



IH 45			
PROJECT LAYOUT			
SCALE: 1"=1000' SHEET 1 OF 2			
CONT	SECT	JOB	HIGHWAY
0092	14	104	IH 45
DIST	COUNTY	SHEET NO.	
18	DALLAS	3	

DATE: 6/5/2023 2:14:49 PM  
FILE: c:\t\dot\pw\_on\inet\tdat5\solomon.bayou\d0841977\project layout.container file.dgn

 DW:SB CK:DN DW:SB CK:DN DW:SB CK:DN

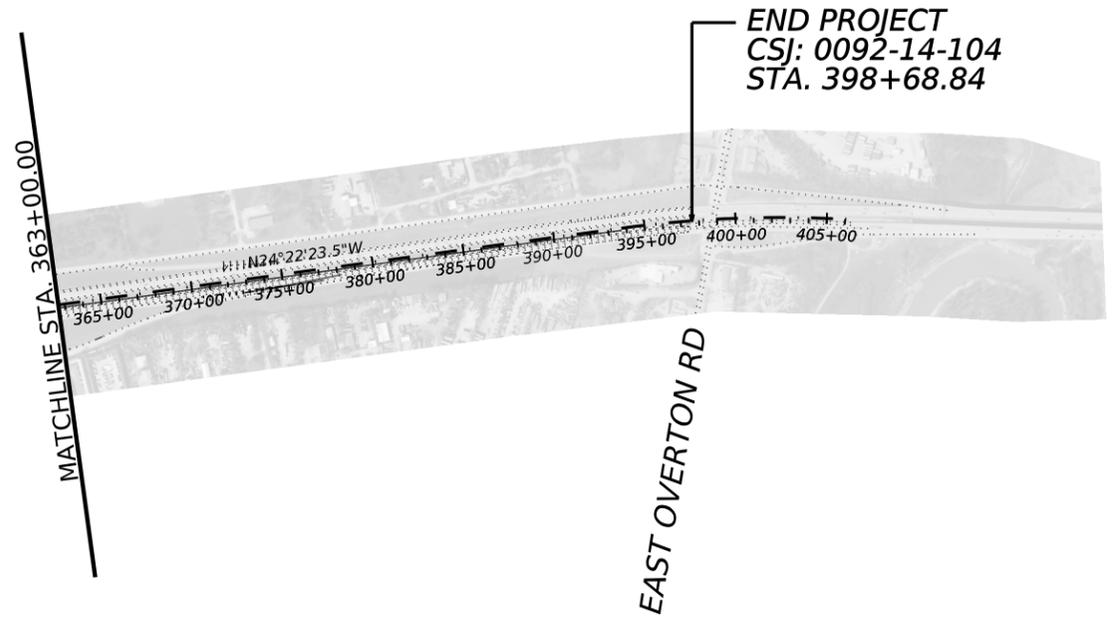

**END PROJECT**  
**CSJ: 0092-14-104**  
**STA. 398+68.84**

MATCHLINE STA. 363+00.00

EAST OVERTON RD

- NOTE:
1. PLACE ADVANCE WARNING SIGNS IN ACCORDANCE WITH THE BC, TCP, AND WZ STANDARD SHEETS AND TMUTCD ON IH 45 MAIN LANES AND RAMPS.
  2. REFER TO BC STANDARD SHEETS FOR LOCATION OF SIGNS.
  3. ANCHOR DRILLED SHAFT FOUNDATION TO BE USED FOR SSCB BARRIER. SEE STANDARD SSCB(1F)-10 DRILLED SHAFT ANCHOR DETAILS FOR MORE INFORMATION.



*Solomon Bayou* 5/16/2023  
 Signature of Registrant & Date

**Texas Department of Transportation**

**IH 45**


**PROJECT LAYOUT**

SCALE: 1"=1000' SHEET 2 OF 2



CONT	SECT	JOB	HIGHWAY
0092	14	104	IH 45
DIST		COUNTY	SHEET NO.
18		DALLAS	4

DATE: 5/12/2023 3:21:28 PM  
 FILE: c:\txdot\pw\_onlinetxdat5\solomon.bayou\d084197\project layout.container file.dgn

CK:  
DW:  
CK:  
DN:

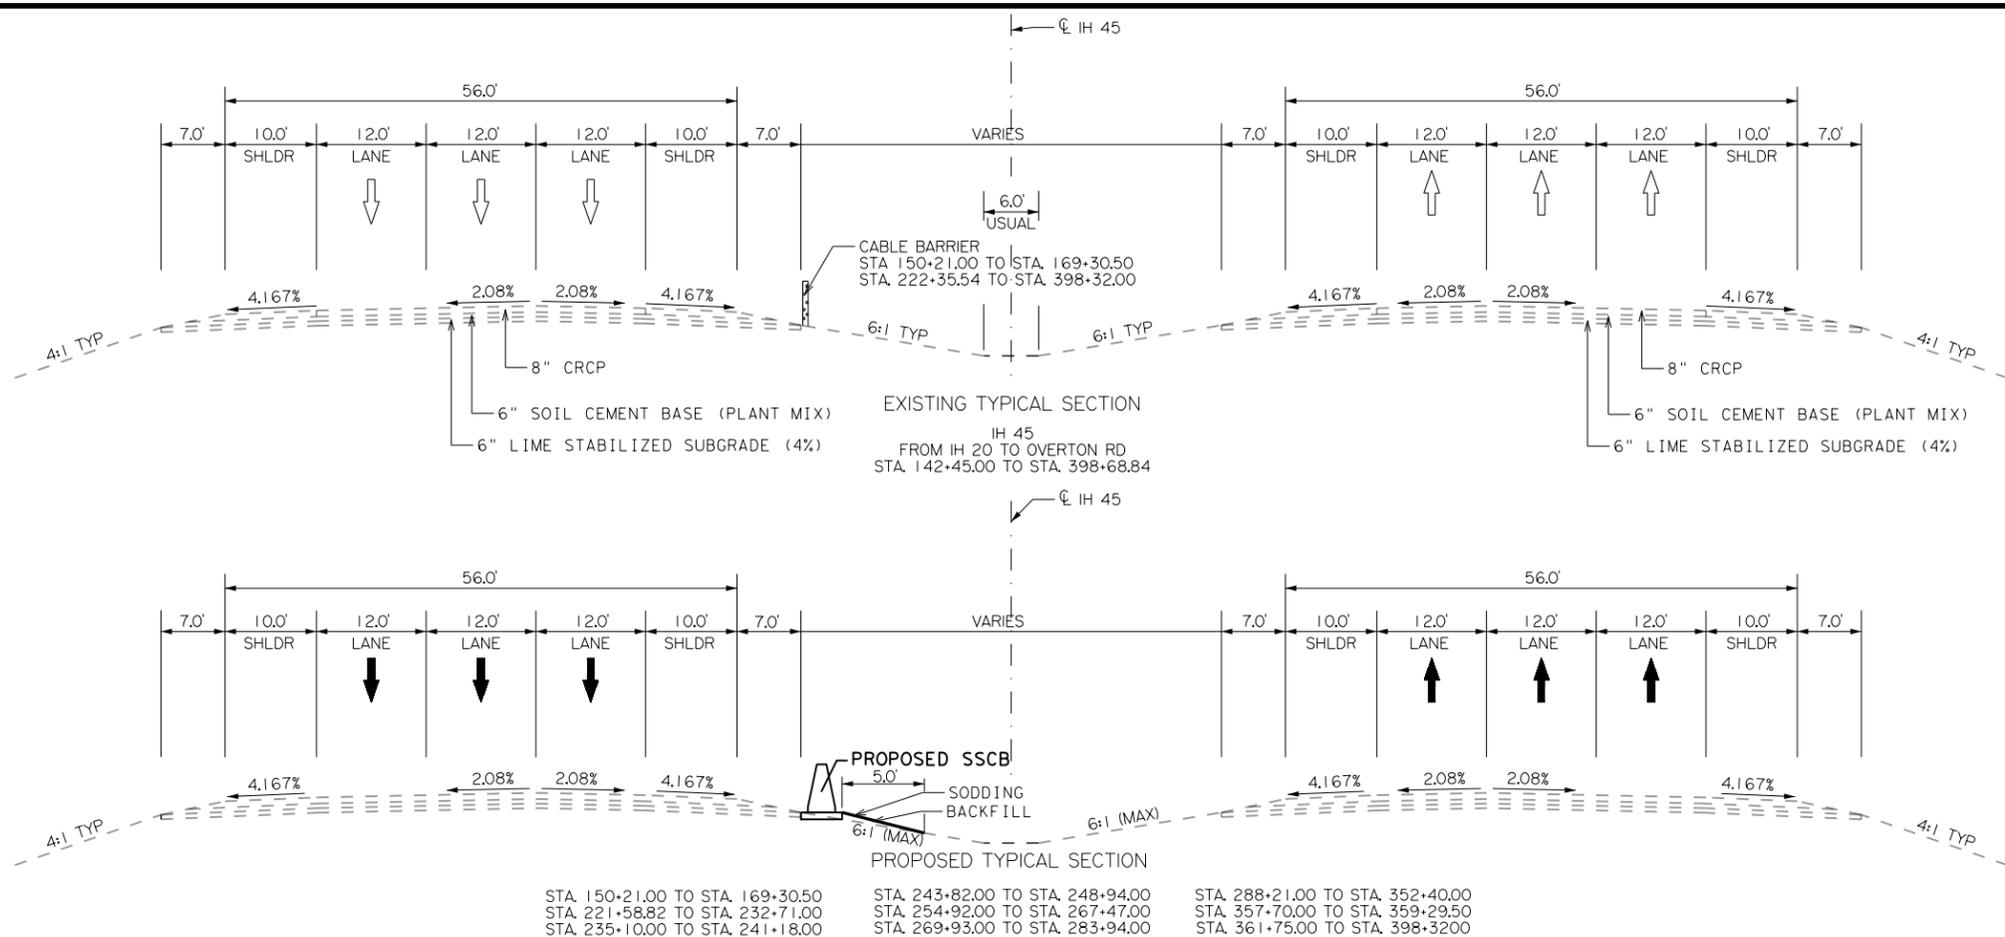

NOTES:  
 1. SEE CRR STANDARD FOR REINFORCEMENT DETAILS.

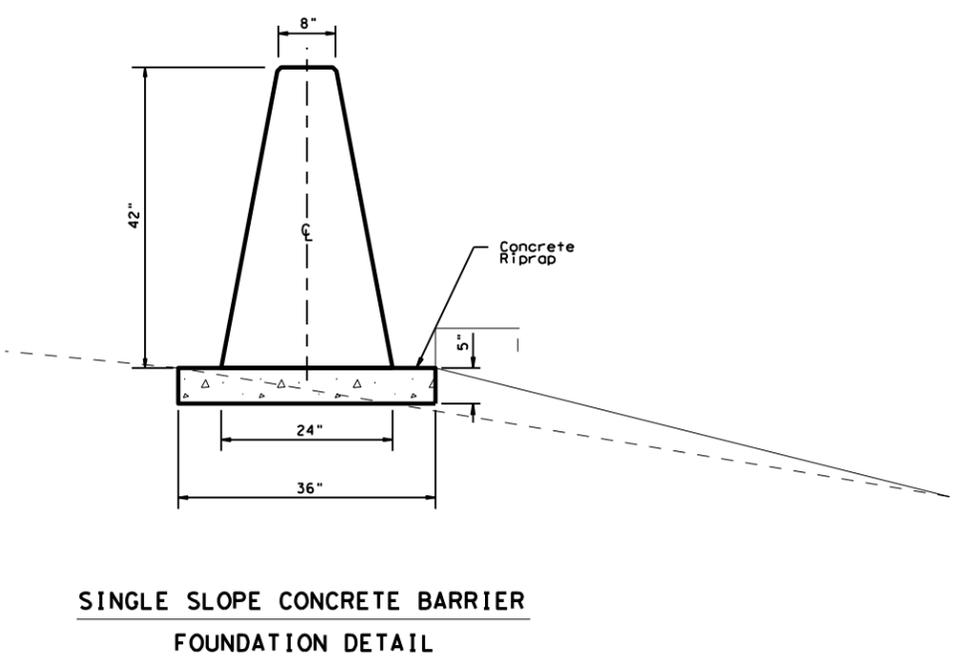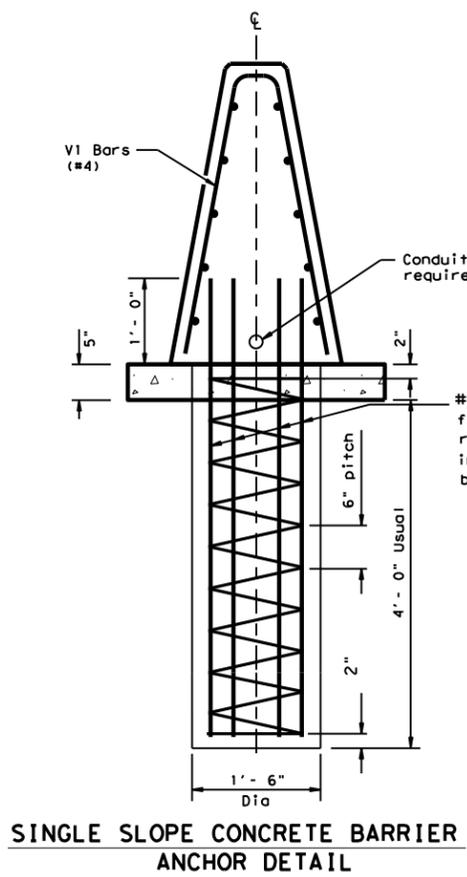

STATE OF TEXAS  
 SOLOMON BAYOU  
 127501  
 LICENSED PROFESSIONAL ENGINEER  
 Solomon Bayou, P.E. 5/26/2023  
 Signature of Registrant & Date

Texas Department of Transportation

IH 45

TYPICAL SECTIONS

N.T.S. SHEET 1 OF 1

CONT	SECT	JOB	HIGHWAY
0092	14	104	IH 45
DIST	COUNTY	SHEET NO.	
18	DALLAS	5	

DATE: 5/30/2023 7:27:05 PM  
 FILE: c:\txdot\pw\_onlinetxdat5\solomon.bayou\d0841977\TYPICAL\_SECTIONS\_104.dgn

Table 1: Basis of Estimate for Permanent Construction					
Item	Description	Thickness	Rate		Quantity
161	Compst Manuf Topsoil	4"			9,463 SY
162	Block Sod	N/A	See Specifications		9,463 SY
166 *	Fertilizer (12-6-6)	N/A	500	Lbs./Ac	0.489Ton
168	Vegetative Watering (Warm)**	N/A	12	MG/Ac/Day	1,408 MG

\*For contractor's information only  
 \*\*Use Summer rate for calculation, adjust for actual field conditions/temperatures as necessary.  
 See Vegetation Establishment Plan Sheet for estimated daily rates.

**GENERAL**

The construction, operation and maintenance of the proposed project will be consistent with the state implementation plan as prepared by the Texas Commission on Environmental Quality.

The disturbed area for this project, as shown on the plans is 3.13 acres. However, the Total Disturbed Area (TDA) will establish the required authorization for storm water discharges. The TDA of this project will be determined by the sum of the disturbed area in all project locations in the contract, and all disturbed area on all Project-Specific Locations (PSL) located in the project limits and/or within 1 mile of the project limits. The department will obtain an authorization to discharge storm water from the Texas Commission on Environmental Quality (TCEQ) for the construction site as shown on the plans, according to the TDA of the project. The contractor will obtain any required authorization from the TCEQ for the discharge of storm water from any PSL for construction support activities on or off of the project row according to the TDA of the project. When the TDA for the project exceeds 1 acre, provide a copy of the appropriate application of permit (NOI, or Construction Site Notice) to the engineer, for any PSL located in the project limits or within 1 mile of the project limits. Follow the directives and adhere to all requirements set forth in the TCEQ, Texas Pollution Discharge Elimination System, Construction General Permit (TPDES, CGP).

This project required formal consultation and permits with environmental resources agencies as outlined in the plan set's Environmental Permits Issues and commitments (EPIC) Sheet. There is a high probability that an environmentally sensitive area could be encountered on the contractor designated Project-Specific Locations (PSL) for this project (haul roads, equipment staging areas, borrow pits, disposal sites, field offices, storage areas, parking areas, etc.). Item 7.6 "Project-Specific Locations", provides a listing of regulatory agencies that may need to be contacted regarding this project.

Leave all right of way areas undisturbed until actual construction is to be performed in said areas.

Questions may be submitted via the Letting Pre-Bid Q&A web page. This webpage can be accessed from the Notice to Contractors dashboard located at the following Address:

<https://tableau.txdot.gov/views/ProjectInformationDashboard/NoticetoContractors>

or Contractor questions on this project are to be addressed to the following individual(s):

Nathan Petter [Nathan.Petter@Txdot.gov](mailto:Nathan.Petter@Txdot.gov)  
 Dung Nguyen [Dung.Nguyen@Txdot.gov](mailto:Dung.Nguyen@Txdot.gov)

Contractor questions will be accepted through email, phone, and in person by the above individuals.

All contractor questions will be reviewed by the Engineer. All questions and any corresponding responses that are generated will be posted through the same Letting Pre-Bid Q&A web page.

The Letting Pre-Bid Q&A web page for each project can be accessed by using the dashboard to navigate to the project you are interested in by scrolling or filtering the dashboard using the controls on the left. Hover over the blue hyperlink for the project you want to view the Q&A for and click on the link in the window that pops up.

**Item 5:**

Underground utilities owned by the Texas Department of Transportation may be present within the Right-Of-Way on this project. For signal, illumination, surveillance, and communications & control maintained by TxDOT, call the TxDOT Traffic Signal Office (214-320-6682) for locates a minimum of 48 hours in advance of excavation. For irrigation systems, call TxDOT Landscape Office (214-320-6205) for locates a minimum of 48 hours in advance of excavation. If city or town owned irrigation facilities are present, call the appropriate department of the local city or town a minimum of 48 hours in advance of excavation. The Contractor is liable for all damages when utilities are damaged due to Contractor's negligence including, but not limited to, repair or replacement at the Contractor's expense.

For the project to be deemed complete, permanently stabilize all unpaved disturbed areas of the project with a vegetative cover at a minimum of 70% density for the control of erosion.

Submit all shop drawings, working drawings, or other documents which require review sufficiently in advance of scheduled construction to allow no less than thirty (30) calendar days for review and response.

When a precast or cast-in-place concrete element is included in the plans, a precast concrete alternate may be submitted in accordance with "Standard Operating Procedure for Alternate Precast Proposal Submission" found online at <https://www.txdot.gov/inside-txdot/forms-publications/consultants-contractors/publications/bridge.html#design>. Acceptance or denial of an alternate is at the sole discretion of the Engineer. Impacts to the project schedule and any additional costs resulting from the use of alternates are the sole responsibility of the Contractor

**Item 6:**

To comply with the latest provisions of Build America, Buy America Act (BABA Act) of the Bipartisan Infrastructure Law, the contractor must submit a notarized original of the TxDOT Construction Material Buy America Certification Form for all items classified as construction materials. This form is not required for materials classified as a manufactured product.

County: Dallas

Highway: IH 45

Refer to the Buy America Material Classification Sheet for clarification on material categorization.

The Buy America Material Classification Sheet is located at the below link.  
<https://www.txdot.gov/business/resources/materials/buy-america-material-classification-sheet.html> for clarification on material categorization.

**Item 7:**

Repair or replace any structures and utilities that might have been damaged by negligence or a failure to have utility locates performed.

Patrol vehicles must be clearly marked to correspond with the officer's agency and equipped with appropriate lights to identify them as law enforcement. For patrol vehicles not owned by a law enforcement agency, markings will be retroreflective and legible from 100 ft. from both sides and the rear of the vehicle. Lights will be high intensity and visible from all angles.

Holiday restrictions – The Engineer may decide that no lane closures or construction operations shall be allowed during the restricted periods listed in the following holiday schedule. TxDOT has the right to lengthen, shorten, or otherwise modify these restricted periods as actual, or expected, traffic conditions may warrant. Working days will not be charged for these restricted periods. No additional compensation will be allowed for these closures (i.e., overhead, delays, stand-by, barricades or any other associated cost impacts).

- New Year's Eve and Day (5 am on December 31 thru 10:00 pm January 1)
- Easter Holiday weekend (5 am on Friday thru 10:00 pm Sunday)
- Memorial Day weekend (5 am on Friday thru 10:00pm Monday)
- Independence Day (5 am on July 3 thru 10:00 pm on July 5)
- Labor Day weekend (5 am on Friday thru 10:00 pm Monday)
- Thanksgiving Holiday (5 am on Wednesday thru 10:00 pm Sunday)
- Christmas Holiday (5 am on December 23 thru 10:00 pm December 26)

No significant traffic generator events identified

**Item 8:**

This Project will be a Standard Workweek in accordance with Article 8.3.1.4..

Nighttime work is allowed in accordance with Article 8.3.3.

Meet weekly with the engineer to notify him or her of planned work for the upcoming week.

Provide the engineer with a daily work schedule of planned work.

**Item 134:**

Start backfilling pavement edges as soon as possible after the surface course is started. Backfill and compact the pavement edges to produce a smooth surface adjacent to the pavement with no vertical edges.

County: Dallas

Highway: IH 45

Use Type "A" or "B" material to backfill pavement edges as shown in plans. Type "A" or "B" material shall consist of suitable material that when compacted will support the pavement edge. Rap is considered suitable Type "A" or "B" material.

Blade the existing vegetation into a neat wind-row prior to overlay. After placing Ty A or Ty B backfill and placing seeding, the material from the wind-row shall be replaced on the completed slopes. Emulsion shall be placed at a 50/50 solution of water to emulsion over disturbed area. Emulsion rate=0.15 Gal/SY residual. This work, materials and equipment shall be subsidiary to Item 134.

**Item 160:**

Sequence construction operations to salvage topsoil from one location and spread on areas ready to receive topsoil. Keep stockpiling of topsoil to a minimum.

**Item 161:**

Provide tickets representing quantity of compost delivered to site.

**Item 500:**

Material On Hand (MOH) will not be used in calculating partial payments for Mobilization.

**Item 502:**

The Contractor Force Account "Safety Contingency" that has been established for this project is intended to be utilized for work zone enhancements, to improve the effectiveness of the Traffic Control Plan, that could not be foreseen in the project planning and design stage. These enhancements will be mutually agreed upon by the Engineer and the Contractor's Responsible Person based on weekly or more frequent traffic management reviews on the project. The Engineer may choose to use existing bid items if it does not slow the implementation of enhancement.

Access will be provided to all business and residences at all times. Where turning radii are limited during phased construction at intersections, provide all weather surfaces such as RAP or base in turning movements to accommodate and to protect the traffic from edge drop-offs. Materials, labor, maintenance and removal for these temporary accesses and radii will not be paid for directly but will be considered subsidiary to the various bid items.

Provide written proposed lane closure information by 1:00 pm on the business day prior to the proposed closures. Do not close lanes when this requirement is not met.

When excavation is required next to a pavement lane carrying traffic and the widening is not completed by the end of the work day, backfill against the edge of the pavement with at least a 3:1 slope using an acceptable material to support vehicular traffic. Carefully remove and dispose of this material when work resumes. Backfilling pavement edges, and the materials required for the work will be subsidiary to this item.

Place barricades and signs in locations that do not obstruct the sight distance of drivers entering the highway from driveways or side streets.

County: Dallas

Highway: IH 45

Do not operate or park any equipment/machinery closer than 30 feet from the traveled roadway after sunset unless authorized by the engineer.

When moving unlicensed equipment on or across any pavement or public highways, protect the pavement from all damage using an acceptable method.

As approved by the Engineer, provide uniformed off duty police officers and squad cars during lane or ramp closures, night time work or other situations that indicate a need for additional traffic control to protect the traveling public or the construction workforce. Provide documentation such as payroll, log sheets with signatures and badge number, or invoices from the government entity providing the officers for reimbursement. Complete the weekly tracking form provided by the department and submit invoices that agree with the tracking form for payment at the end of each month approved services were provided. Reimbursement will not be made for coordination fees charged by any party.

The Lane Closure Assessment Fee is shown on the following table. The fee applies to the Contractor for closures or obstructions that overlap into restricted hour traffic for each half hour or portion thereof, per lane, regardless of length of the lane closure or obstruction.

**Table 1  
Lane Closure Assessment Fee Table**

Roadway	Amount Per Lane Per Hour
IH 45	\$1,500

Limit lane closures along IH45 to the hours between 9:00 am and 3:30 pm or nightly from 9:00 pm to 5:00 am. Work in other areas of the project is not restricted to this time frame.

Traffic Control Plans with Lane Closures causing backups of 20 minutes or greater in duration will be modified by the Engineer up to and including removal of the lane closure and adjustment of lane closure times.

Additional lanes may be closed, started earlier, or extended later with written permission of the Engineer.

**Item 506:**

Take all practicable precautions to prevent debris from being discharged into the Waters of Texas or a designated wetland. Install Best Management Practices before demolition begins and maintain them during the demolition. Remove any debris or construction material that escapes containment devices and are discharged into the restricted areas, before the next rain event or within 24 hours of the discharge.

Provide SW3P Signs. Obtain from the Engineer a copy of the project's completed TPDES Storm Water Program Construction Site Notice and Contractor Site Notice. Laminate the sheets and bond with adhesive to 36" X 36" plywood sign blanks. Ensure the sheets remain dry. Apply

County: Dallas

Highway: IH 45

Type C Blue reflective sheeting as the background and add the text "SW3P" in 5" white lettering, centered at the top. Attach the signs to approved temporary mounts and locate at each of the project limits just inside the right of way line at a readable height or as directed by the Engineer. If the sign cannot be placed outside the clear zone, it must adhere to the TMUTCD. SW3P signs, maintenance, and reposting (for replacement or as needed to ensure readability) will be subsidiary to Item 502.

Concrete Washouts are required per the CGP. The Concrete Washout Area(s) structural controls must consist of temporary berms, temporary shallow pits, and/or temporary storage tanks to prevent contaminated runoff and must be lined as to prevent contamination of underlying soil. Ensure pits properly maintained including removal of concrete as not to allow over flow. The location(s) of washout area will be approved by the Engineer. When washout pits are no longer needed, they will be removed and area will be restored to original condition. This work, materials and labor will not be measured or paid for directly but will be subsidiary to Item 506, "Temporary Erosion, Sedimentation, and Environmental Controls."

**Item 512:**

The contractor will furnish pre-cast F Shape Barriers for traffic control, and remove and retain possession of non-permanent barriers at the end of the project. Pre-cast F Shape Barriers must have drainage slots as detailed on the Concrete Safety Barrier Standards. Submit for approval the type of barrier joint connection proposed for the project.

**Item 514:**

Provide High Performance Concrete (HPC) and epoxy coated reinforcing for all Permanent Concrete Traffic Barrier located on bridge approaches or bridge slabs.

**Item 542:**

Metal beam guard fence removed from this project is to be retained and disposed of by the contractor.

**Item 6185:**

The total number of truck mounted attenuators (TMAs) or trailer attenuators (TAs) required when utilizing the traffic control standards are shown in the tables below.

TCP 5 Series	Scenario		Required TMA/TA
(5-1)-18	A	B	1

TCP 6 Series	Scenario		Required TMA/TA	
(6-1)-12	A	B	1	2

The contractor will be responsible for determining if one or more of these operations will be ongoing at the same time to determine the total number of TMAs/TAs needed for the project. Additional TMAs/TAs used that are not specified in the plans in which the contractor expects compensation will require prior approval from the Engineer.



CONTROLLING PROJECT ID 0092-14-104

DISTRICT Dallas  
HIGHWAY IH 45

# Estimate & Quantity Sheet

COUNTY Dallas

ALT	BID CODE	DESCRIPTION	UNIT	EST.	FINAL
	134-6004	BACKFILL (TY A OR B)	STA	171.000	
	161-6017	COMPOST MANUF TOPSOIL (4")	SY	9,463.000	
	162-6002	BLOCK SODDING	SY	9,463.000	
	168-6001	VEGETATIVE WATERING	MG	1,408.000	
	432-6002	RIPRAP (CONC)(5 IN)	CY	796.000	
	500-6001	MOBILIZATION	LS	1.000	
	502-6001	BARRICADES, SIGNS AND TRAFFIC HANDLING	MO	6.000	
	506-6003	ROCK FILTER DAMS (INSTALL) (TY 3)	LF	132.000	
	506-6011	ROCK FILTER DAMS (REMOVE)	LF	132.000	
	506-6020	CONSTRUCTION EXITS (INSTALL) (TY 1)	SY	770.000	
	506-6024	CONSTRUCTION EXITS (REMOVE)	SY	770.000	
	506-6041	BIODEG EROSN CONT LOGS (IN STL) (12")	LF	705.000	
	506-6043	BIODEG EROSN CONT LOGS (REMOVE)	LF	705.000	
	512-6005	PORT CTB (FUR & INST)(F-SHAPE)(TY 1)	LF	5,280.000	
	512-6029	PORT CTB (MOVE)(F-SHAPE)(TY 1)	LF	15,030.000	
	512-6053	PORT CTB (REMOVE)(F-SHAPE)(TY 1)	LF	5,280.000	
	514-6001	PERM CTB (SGL SLOPE) (TY 1) (42 )	LF	17,187.000	
	542-6001	REMOVE METAL BEAM GUARD FENCE	LF	2,289.000	
	542-6003	REMOVE DOWNSTREAM ANCHOR TERMINAL	EA	9.000	
	543-6021	REMOVE CABLE BARRIER	LF	16,957.000	
	543-6022	REMOVE CABLE BARRIER TERMINAL SECTION	EA	18.000	
	544-6003	GUARDRAIL END TREATMENT (REMOVE)	EA	9.000	
	545-6003	CRASH CUSH ATTEN (MOVE & RESET)	EA	5.000	
	545-6005	CRASH CUSH ATTEN (REMOVE)	EA	3.000	
	545-6019	CRASH CUSH ATTEN (IN STL)(S)(N)(TL3)	EA	2.000	
	658-6027	IN STL DEL ASSM (D-SY)SZ (BRF)CTB (BI)	EA	345.000	
	6001-6002	PORTABLE CHANGEABLE MESSAGE SIGN	EA	2.000	
	6185-6002	TMA (STATIONARY)	DAY	204.000	
	6185-6005	TMA (MOBILE OPERATION)	DAY	102.000	
	18	SAFETY CONTINGENCY: CONTRACTOR FORCE ACCOUNT WORK (PARTICIPATING)	LS	1.000	
		EROSION CONTROL MAINTENANCE: CONTRACTOR FORCE ACCOUNT WORK (PART)	LS	1.000	
		LAW ENFORCEMENT: CONTRACTOR FORCE ACCOUNT WORK (PARTICIPATING)	LS	1.000	



DISTRICT	COUNTY	CCSJ	SHEET
Dallas	Dallas	0092-14-104	7

CKDW  
 DW\_SB  
 CKDW  
 DW\_SB

**SUMMARY OF ROADWAY ITEMS**

IH 45	134 6004	432 6002	514 6001	542 6001	542 6003	543 6021	543 6022	544 6003	658 6027	6001 6002	6185 6002	6185 6005
	BACKFILL (TY A OR B)	RIPRAP (CONC)(5 IN)	PERM CTB (SGL SLOPE) (TY 1) (42)	REMOVE METAL BEAM GUARD FENCE	REMOVE DOWNSTRE AM ANCHOR TERMINAL	REMOVE CABLE BARRIER	REMOVE CABLE BARRIER TERMINAL SECTION	GUARDRAIL END TREATMENT (REMOVE)	INSTL DEL ASSM (D-SY) SZ (BRF) CTB (BI)	PORTABLE CHANGEABLE MESSAGE SIGN	TMA (STATIONARY)	TMA (MOBILE OPERATION)
	STA	CY	LF	LF	EA	LF	EA	EA	EA	EA	DAY	DAY
CSJ: 0092-14-104	171	796	17,187	2,289	9	16,957	18	9	345	2	204	102
<b>PROJECT TOTALS</b>	<b>171</b>	<b>796</b>	<b>17187</b>	<b>2,289</b>	<b>9</b>	<b>16,957</b>	<b>18</b>	<b>9</b>	<b>345</b>	<b>2</b>	<b>204</b>	<b>102</b>

**SUMMARY OF EROSION CONTROL ITEMS**

IH 45	161 6017	162 6002	168 6001	① 506 6003	① 506 6011	① 506 6020	① 506 6024	① 506 6041	① 506 6043
	COMPOST MANUF TOPSOIL (4")	BLOCK SODDING	VEGETATIVE WATERING	ROCK FILTER DAMS (INSTALL) (TY 3)	ROCK FILTER DAMS (REMOVE)	CONSTRUCTION EXITS (INSTALL) (TY 1)	CONSTRUCTION EXITS (REMOVE)	BIODEG EROSN CONT LOGS (INSTL) (12")	BIODEG EROSN CONT LOGS (REMOVE)
	SY	SY	MG	LF	LF	SY	SY	LF	LF
CSJ: 0092-14-104	9,463	9,463	1,408	132	132	770	770	705	705
<b>PROJECT TOTALS</b>	<b>9,463</b>	<b>9,463</b>	<b>1,408</b>	<b>132</b>	<b>132</b>	<b>770</b>	<b>770</b>	<b>705</b>	<b>705</b>

**NOTE:**  
 ① 506-SERIES PAY ITEMS INCREASED BY 10%

**SUMMARY OF WORKZONE TRAFFIC CONTROL ITEMS**

IH 45	512 6005	512 6029	512 6053	545 6003	545 6005	545 6019
	PORT CTB (FUR & INST)(F-SHAPE)(TY 1)	PORT CTB (MOVE)(F-SHAPE)(TY 1)	PORT CTB (REMOVE)(F-SHAPE)(TY 1)	CRASH CUSH ATTEN (MOVE & RESET)	CRASH CUSH ATTEN (REMOVE)	CRASH CUSH ATTEN (INSTL)(S)(N)(TL3)
	LF	LF	LF	EA	EA	EA
CSJ: 0092-14-104	5,280	15,030	5,280	5	3	2
<b>PROJECT TOTALS</b>	<b>5,280</b>	<b>15,030</b>	<b>5,280</b>	<b>5</b>	<b>3</b>	<b>2</b>



**IH 45**

**QUANTITY SUMMARY**

SHEET 1 OF 1

CONT	SECT	JOB	HIGHWAY
0092	14	104	IH 45
DIST	COUNTY	SHEET NO.	
18	DALLAS	8	

DATE: 6/6/2023 12:43:44 PM  
 FILE: c:\tdot\ipw\_onlinet\tdot5\solomon\_bayou\d0855026\SUMMARY\_104.dgn

CK:  
DW:  
CK:  
DW:

GENERAL:

1. INSTALL BARRICADES AND ADVANCED WARNING SIGNS PER BC STANDARDS, TCP STANDARDS, WORK ZONE STANDARDS AND/OR AS DIRECTED BY THE ENGINEER. THE SIGNS, BARRICADES, OR OTHER WARNING DEVICES SHOWN SHALL BE CONSIDERED MINIMUM AND ADDITIONAL SIGNS, BARRICADES, OR WARNING DEVICES DEEMED NECESSARY BY THE ENGINEER OR DICTATED BY FIELD CONDITIONS SHALL BE PROVIDED ACCORDING TO ALL APPLICABLE STANDARDS. ADDITIONAL SIGNS OR BARRICADES WILL NOT BE PAID FOR DIRECTLY BUT SHALL BE SUBSIDIARY TO BID ITEM 502 "BARRICADES, SIGNS, AND TRAFFIC HANDLING".
2. INSTALL TEMPORARY SW3P EROSION CONTROL MEASURES BEFORE (BUT NO SOONER THAN TWO WEEKS PRIOR) TO SOIL DISTURBANCE OR POTENTIAL POLLUTANT-GENERATING ACTIVITIES IN THEIR CONTROL AREA. TEMPORARY SW3P EROSION CONTROL MEASURES SHALL BE REMOVED WITHIN TWO WEEKS OF VEGETATION ESTABLISHMENT IN THEIR CONTROL AREA, OR AS APPROVED BY THE ENGINEER
3. SUBMIT A DETAILED SCHEDULE OF WORK TO THE PROJECT ENGINEER FOR APPROVAL PRIOR TO THE BEGINNING OF CONSTRUCTION WHICH GENERALLY CONFORMS TO THE SEQUENCE SHOWN ON THE TCP SEQUENCE OF WORK (SEE BELOW).
4. SUBMIT ANY REQUEST TO ALTER SEQUENCE OF OPERATION OF TRAFFIC CONTROL PLANS TO THE ENGINEER FOR WRITTEN APPROVAL PRIOR TO BEGINNING CONSTRUCTION. ADDITIONAL COST OR TIME IS AT THE EXPENSE OF THE CONTRACTOR.
5. MAINTAIN TEMPORARY SIGNS WITHIN THE PROJECT LIMITS AND COVER OR REMOVE ANY EXISTING SIGN OR PAVEMENT MARKING THAT CONFLICTS WITH TCP TO AVOID CONFUSION FOR THE TRAVELING PUBLIC. TEMPORARY SIGNING SHALL BE PLACED AS NEEDED DURING ALL PHASES. PAYMENT FOR THIS WORK SHALL BE SUBSIDIARY TO ITEM 502 BARRICADES.
6. APPLY LANE CLOSURES AS NEEDED IN ACCORDANCE WITH TCP STANDARD SHEETS AND TMUTCD AND/OR AS DIRECTED BY THE ENGINEER.
7. PLACE PORTABLE CHANGEABLE MESSAGE SIGNS TO INFORM THE TRAVELING PUBLIC OF THE INTENT TO CLOSE MAINLANES AND/OR RAMPS 7 DAYS PRIOR TO CLOSURE.
8. MAINTAIN EXISTING DRAINAGE DURING ALL CONSTRUCTION ACTIVITIES AT EXISTING INLETS AND SLOTTED DRAINS.
9. CONSTRUCTION OF PERMANENT CONCRETE BARRIER IS INTENDED TO BE DIVIDED INTO SMALL WORK AREAS WITH TEMPORARY BARRIER INSTALLED ON SB SHOULDER FOR SAFETY. CONSTRUCTION OF PERMANENT BARRIER TRANSITIONS AT BRIDGES WILL REQUIRE TEMPORARY BARRIER SET UP IN BOTH SB AND NB DIRECTION OF THE FREEWAY. ONCE PERMANENT BARRIER CONSTRUCTION IS COMPLETED IN ONE AREA, MOVE THE TEMPORARY BARRIER TO THE NEW LOCATION AND CONTINUE CONSTRUCTION OF PERMANENT BARRIER IN THE MEDIAN.

SEQUENCE OF CONSTRUCTION:

1. INSTALL ADVANCED WARNING SIGNS, WORK ZONE SIGNAGE, AND CHANNELIZING DEVICES.
2. INSTALL STORM WATER POLLUTION PREVENTION DEVICES NEEDED.
3. REMOVE & DISPOSE EXISTING CABLE BARRIER ON IH 45 AS SHOWN IN PLANS.
4. INSTALL TEMPORARY CONCRETE SAFETY BARRIER (PCTB) ON EXISTING SHOULDER AND MAINTAIN AT LEAST 6' SHOULDER WIDTH BUFFER.
5. CONSTRUCT SSCB (SINGLE SLOPE CONCRETE BARRIER) FOUNDATION.
6. INSTALL SSCB.
7. REVEGETATE DISTURBED SOIL AS SOON AS PRACTICABLE, ONCE VEGETATIVE ESTABLISHMENT AS BEEN ACHIVED, REMOVE TEMPORARY SW3P CONTROL MEASURES AS DIRECTED OR AUTHORIZED BY ENGINEER.
8. PERFORM FINAL SITE CLEAN UP AS DIRECTED BY THE ENGINEER AND REMOVE PROJECT ADVANCE WARNING SIGNS.



*Solomon Bayou* 5/26/2023  
Signature of Registrant & Date

DATE: 6/5/2023 2:34:13 PM  
FILE: c:\txdot\pw\_online\txdot5\solomon.bayou\d0841981\tcp\_narratives\_104.dgn

<b>IH 45</b>			
<b>TCP NARRATIVES</b>			
N. T. S. SHEET 1 OF 1			
CONT	SECT	JOB	HIGHWAY
0092	14	104	IH 45
DIST	COUNTY	SHEET NO.	
18	DALLAS	9	



DISCLAIMER: The use of this standard is governed by the "Texas Engineering Practice Act". No warranty of any kind is made by TxDOT for any purpose whatsoever. TxDOT assumes no responsibility for the conversion of this standard to other formats or for incorrect results or damages resulting from its use.

DATE: 2023/03/15 2:57:32 PM  
 FILE: DOCUMENT\NAME\line.txdot5\so\lomon\_bayou\d0852788\bc-21.dgn

**BARRICADE AND CONSTRUCTION (BC) STANDARD SHEETS GENERAL NOTES:**

- The Barricade and Construction Standard Sheets (BC sheets) are intended to show typical examples for placement of temporary traffic control devices, construction pavement markings, and typical work zone signs. The information contained in these sheets meet or exceed the requirements shown in the "Texas Manual on Uniform Traffic Control Devices" (TMUTCD).
- The development and design of the Traffic Control Plan (TCP) is the responsibility of the Engineer.
- The Contractor may propose changes to the TCP that are signed and sealed by a licensed professional engineer for approval. The Engineer may develop, sign and seal Contractor proposed changes.
- The Contractor is responsible for installing and maintaining the traffic control devices as shown in the plans. The Contractor may not move or change the approximate location of any device without the approval of the Engineer.
- Geometric design of lane shifts and detours should, when possible, meet the applicable design criteria contained in manuals such as the American Association of State Highway and Transportation Officials (AASHTO), "A Policy on Geometric Design of Highways and Streets," the TxDOT "Roadway Design Manual" or engineering judgment.
- When projects abut, the Engineer(s) may omit the END ROAD WORK, TRAFFIC FINES DOUBLE, and other advance warning signs if the signing would be redundant and the work areas appear continuous to the motorists. If the adjacent project is completed first, the Contractor shall erect the necessary warning signs as shown on these sheets, the TCP sheets or as directed by the Engineer. The BEGIN ROAD WORK NEXT X MILES sign shall be revised to show appropriate work zone distance.
- The Engineer may require duplicate warning signs on the median side of divided highways where median width will permit and traffic volumes justify the signing.
- All signs shall be constructed in accordance with the details found in the "Standard Highway Sign Designs for Texas," latest edition. Sign details not shown in this manual shall be shown in the plans or the Engineer shall provide a detail to the Contractor before the sign is manufactured.
- The temporary traffic control devices shown in the illustrations of the BC sheets are examples. As necessary, the Engineer will determine the most appropriate traffic control devices to be used.
- Where highway construction or maintenance work is being undertaken, other than mobile operations as defined by the Texas Manual on Uniform Traffic Control Devices, CSJ limit signs are required. CSJ limit signs are shown on BC(2). The OBEY WARNING SIGNS STATE LAW sign, STAY ALERT TALK OR TEXT LATER and the WORK ZONE TRAFFIC FINES DOUBLE sign with plaque shall be erected in advance of the CSJ limits. The BEGIN ROAD WORK NEXT X MILES, CONTRACTOR and END ROAD WORK signs shall be erected at or near the CSJ limits. For mobile operations, CSJ limit signs are not required.
- Traffic control devices should be in place only while work is actually in progress or a definite need exists.
- The Engineer has the final decision on the location of all traffic control devices.
- Inactive equipment and work vehicles, including workers' private vehicles must be parked away from travel lanes. They should be as close to the right-of-way line as possible, or located behind a barrier or guardrail, or as approved by the Engineer.

**WORKER SAFETY NOTES:**

- Workers on foot who are exposed to traffic or to construction equipment within the right-of-way shall wear high-visibility safety apparel meeting the requirements of ISEA "American National Standard for High-Visibility Apparel," or equivalent revisions, and labeled as ANSI 107-2004 standard performance for Class 2 or 3 risk exposure. Class 3 garments should be considered for high traffic volume work areas or night time work.
- Except in emergency situations, flagger stations shall be illuminated when flagging is used at night.

**COMPLIANT WORKZONE TRAFFIC CONTROL DEVICES**

- Only pre-qualified products shall be used. The "Compliant Work Zone Traffic Control Devices List" (CWZTCD) describes pre-qualified products and their sources.
- Work zone traffic control devices shall be compliant with the Manual for Assessing safety Hardware (MASH).

<b>THE DOCUMENTS BELOW CAN BE FOUND ON-LINE AT</b> <a href="http://www.txdot.gov">http://www.txdot.gov</a>
COMPLIANT WORK ZONE TRAFFIC CONTROL DEVICES LIST (CWZTCD)
DEPARTMENTAL MATERIAL SPECIFICATIONS (DMS)
MATERIAL PRODUCER LIST (MPL)
ROADWAY DESIGN MANUAL - SEE "MANUALS (ONLINE MANUALS)"
STANDARD HIGHWAY SIGN DESIGNS FOR TEXAS (SHSD)
TEXAS MANUAL ON UNIFORM TRAFFIC CONTROL DEVICES (TMUTCD)
TRAFFIC ENGINEERING STANDARD SHEETS


SHEET 1 OF 12

 Texas Department of Transportation		Traffic Safety Division Standard
<b>BARRICADE AND CONSTRUCTION          GENERAL NOTES          AND REQUIREMENTS</b>		
<b>BC (1) - 21</b>		
FILE: bc-21.dgn	DN: TxDOT	CR: TxDOT
© TxDOT November 2002	CONT	SECT
	0092	14
		104
		IH 45
REVISIONS		
4-03 7-13		
9-07 8-14		
5-10 5-21		
	DIST	COUNTY
	18	DALLAS
		SHEET NO.
		11

DISCLAIMER: The use of this standard is governed by the "Texas Engineering Practice Act". No warranty of any kind is made by TxDOT for any purpose whatsoever. TxDOT assumes no responsibility for the conversion of this standard to other formats or for incorrect results or damages resulting from its use.


DATE: 2023/03/15 2:57:34 PM  
 FILE: DOCUMENT\NAME\line\txdot\5\solomon\_bayou\d0852788\_bc-21.dgn

**TYPICAL LOCATION OF CROSSROAD SIGNS**

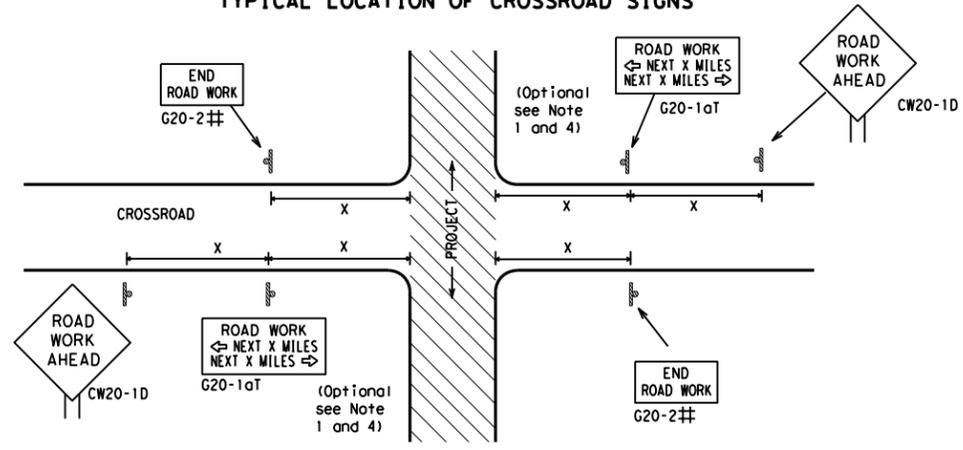

- ## May be mounted on back of "ROAD WORK AHEAD" (CW20-1D) sign with approval of Engineer. (See note 2 below)
- The typical minimum signing on a crossroad approach should be a "ROAD WORK AHEAD" (CW20-1D) sign and a (G20-2) "END ROAD WORK" sign, unless noted otherwise in plans.
  - The Engineer may use the reduced size 36" x 36" ROAD WORK AHEAD (CW20-1D) sign mounted back to back with the reduced size 36" x 18" "END ROAD WORK" (G20-2) sign on low volume crossroads (see Note 4 under "Typical Construction Warning Sign Size and Spacing"). See the "Standard Highway Sign Designs for Texas" manual for sign details. The Engineer may omit the advance warning signs on low volume crossroads. The Engineer will determine whether a road is low volume as per TMUTCD Part 5. This information shall be shown in the plans.
  - Based on existing field conditions, the Engineer/Inspector may require additional signs such as FLAGGER AHEAD, LOOSE GRAVEL, or other appropriate signs. When additional signs are required, these signs will be considered part of the minimum requirements. The Engineer/Inspector will determine the proper location and spacing of any sign not shown on the BC sheets, Traffic Control Plan sheets or the Work Zone Standard Sheets.
  - The "ROAD WORK NEXT X MILES" (G20-1aT) sign shall be required at high volume crossroads to advise motorists of the length of construction in either direction from the intersection. The Engineer will determine whether a roadway is considered high volume.
  - Additional traffic control devices may be shown elsewhere in the plans for higher volume crossroads.
  - When work occurs in the intersection area, appropriate traffic control devices, as shown elsewhere in the plans or as determined by the Engineer/Inspector, shall be in place.

**T-INTERSECTION**

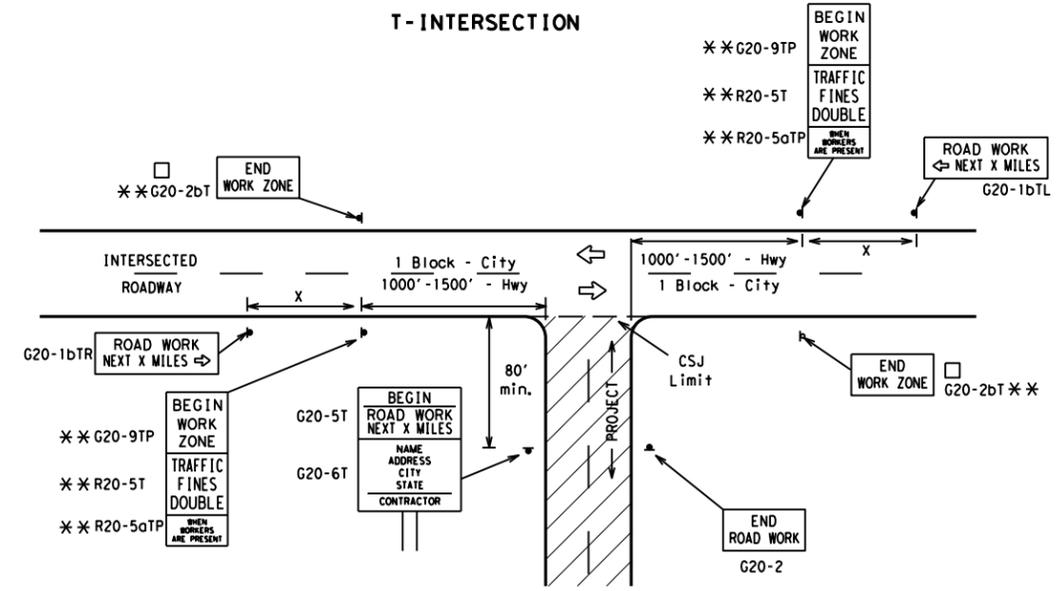

**CSJ LIMITS AT T-INTERSECTION**

- The Engineer will determine the types and location of any additional traffic control devices, such as a flagger and accompanying signs, or other signs, that should be used when work is being performed at or near an intersection.
- If construction closes the road at a T-intersection, the Contractor shall place the "CONTRACTOR NAME" (G20-6T) sign behind the Type 3 Barricades for the road closure (see BC(10) also). The "ROAD WORK NEXT X MILES" left arrow (G20-1bTL) and "ROAD WORK NEXT X MILES" right arrow (G20-1bTR) signs shall be replaced by the detour signing called for in the plans.

**TYPICAL CONSTRUCTION WARNING SIGN SIZE AND SPACING<sup>1,5,6</sup>**

Sign Number or Series	SIZE		SPACING	
	Conventional Road	Expressway/Freeway	Posted Speed MPH	Sign Δ Spacing "x" Feet (Apprx.)
CW20 <sup>4</sup>	48" x 48"	48" x 48"	30	120
CW21			35	160
CW22			40	240
CW23			45	320
CW25			50	400
CW1, CW2, CW7, CW8, CW9, CW11, CW14	36" x 36"	48" x 48"	55	500 <sup>2</sup>
CW3, CW4, CW5, CW6, CW8-3, CW10, CW12	48" x 48"	48" x 48"	60	600 <sup>2</sup>
			65	700 <sup>2</sup>
			70	800 <sup>2</sup>
			75	900 <sup>2</sup>
			80	1000 <sup>2</sup>
			*	* <sup>3</sup>


\* For typical sign spacings on divided highways, expressways and freeways, see Part 6 of the "Texas Manual on Uniform Traffic Control Devices" (TMUTCD) typical application diagrams or TCP Standard Sheets.

Δ Minimum distance from work area to first Advance Warning sign nearest the work area and/or distance between each additional sign.

**GENERAL NOTES**


- Special or larger size signs may be used as necessary.
- Distance between signs should be increased as required to have 1500 feet advance warning.
- Distance between signs should be increased as required to have 1/2 mile or more advance warning.
- 36" x 36" "ROAD WORK AHEAD" (CW20-1D) signs may be used on low volume crossroads at the discretion of the Engineer as per TMUTCD Part 5. See Note 2 under "Typical Location of Crossroad Signs".
- Only diamond shaped warning sign sizes are indicated.
- See sign size listing in "TMUTCD", Sign Appendix or the "Standard Highway Sign Designs for Texas" manual for complete list of available sign design sizes.

**WORK AREAS IN MULTIPLE LOCATIONS WITHIN CSJ LIMITS**

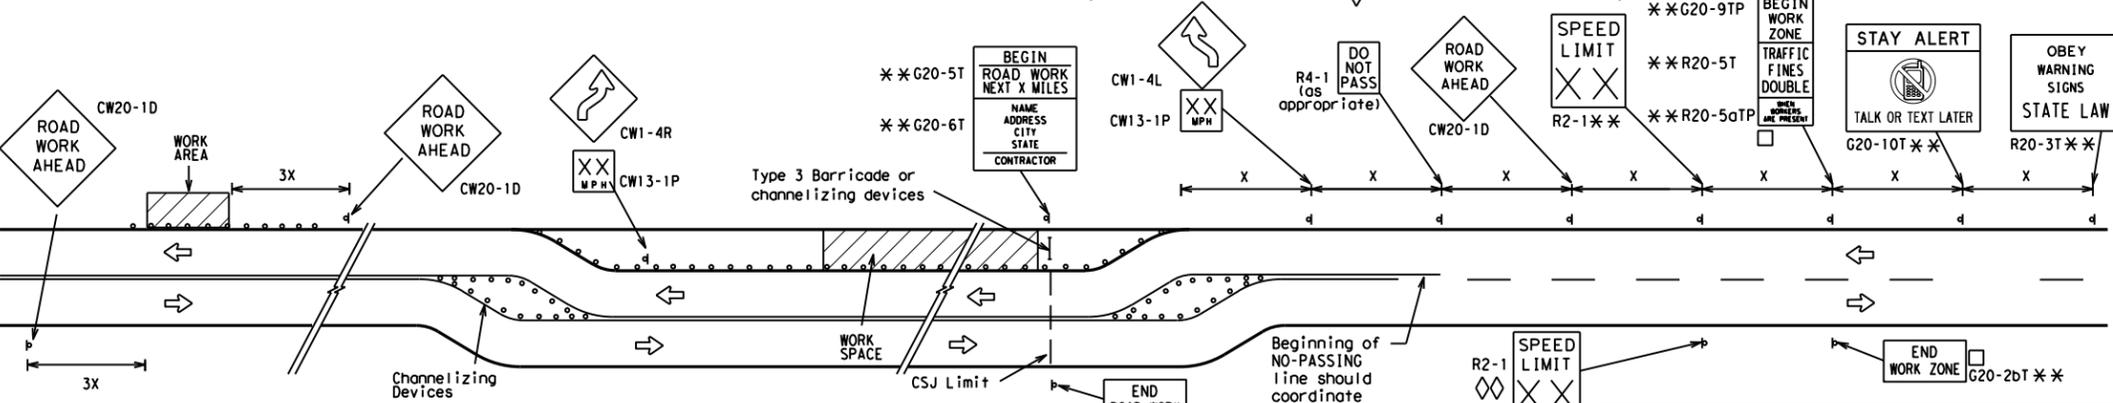


When extended distances occur between minimal work spaces, the Engineer/Inspector should ensure additional "ROAD WORK AHEAD" (CW20-1D) signs are placed in advance of these work areas to remind drivers they are still within the project limits. See the applicable TCP sheets for exact location and spacing of signs and channelizing devices.

**SAMPLE LAYOUT OF SIGNING FOR WORK BEGINNING DOWNSTREAM OF THE CSJ LIMITS**

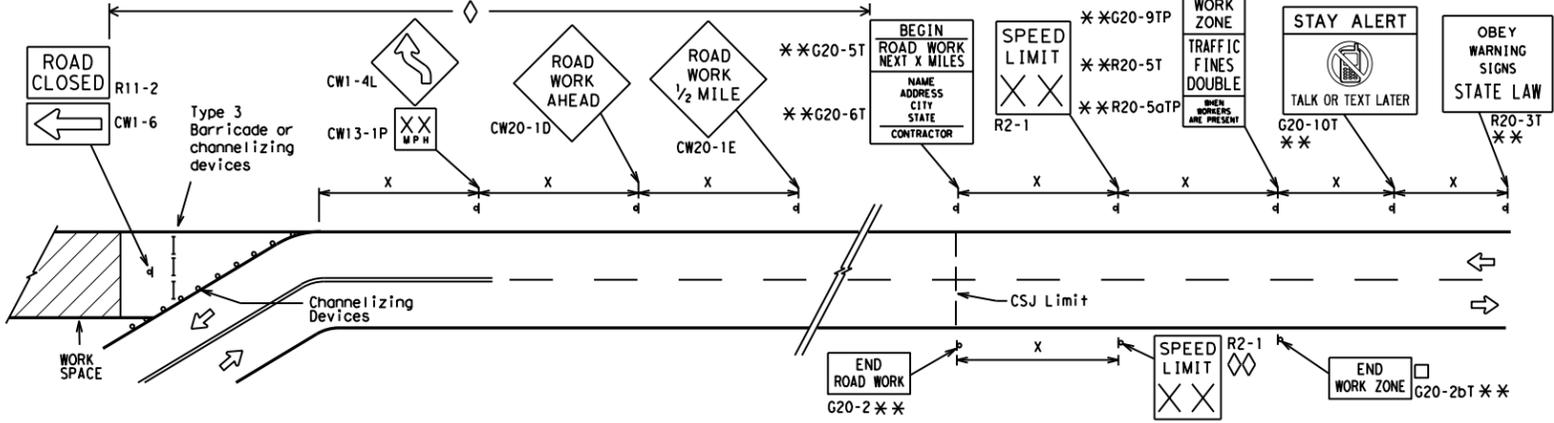

**SAMPLE LAYOUT OF SIGNING FOR WORK BEGINNING AT THE CSJ LIMITS**

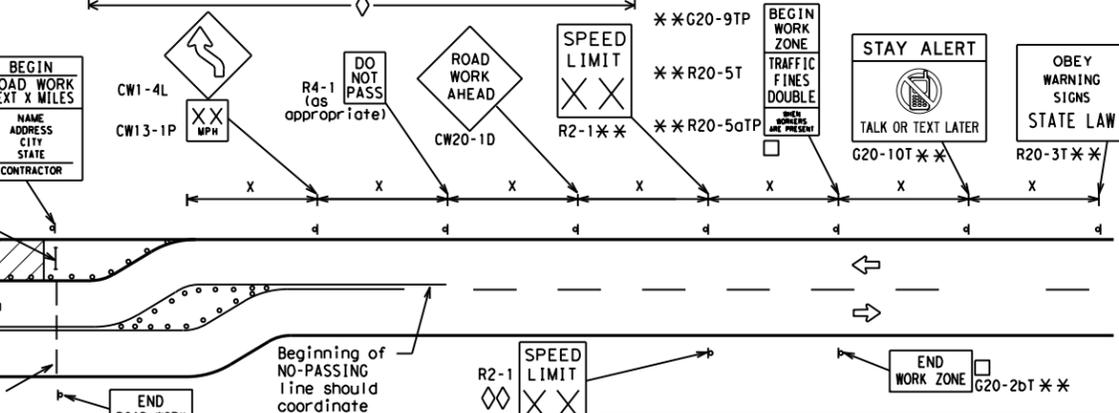

**NOTES**

- The Contractor shall determine the appropriate distance to be placed on the G20-1 series signs and "BEGIN ROAD WORK NEXT X MILES" (G20-5T) sign for each specific project. This distance shall replace the "x" and shall be rounded to the nearest whole mile with the approval of the Engineer. No decimals shall be used.
- The "BEGIN WORK ZONE" (G20-9TP) and "END WORK ZONE" (G20-2bT) shall be used as shown on the sample layout when advance signs are required outside the CSJ Limits. They inform the motorist of entering or leaving a part of the work zone lying outside the CSJ Limits where traffic fines may double if workers are present.
- CSJ limit signing is required for highway construction and maintenance work, with the exception of mobile operations.
- Area for placement of "ROAD WORK AHEAD" (CW20-1D) sign and other signs or devices as called for on the Traffic Control Plan.
- Contractor will install a regulatory speed limit sign at the end of the work zone.

**LEGEND**

—	Type 3 Barricade
○ ○ ○	Channelizing Devices
■	Sign
X	See Typical Construction Warning Sign Size and Spacing chart or the TMUTCD for sign spacing requirements.

SHEET 2 OF 12



**BARRICADE AND CONSTRUCTION PROJECT LIMIT**


**BC (2) - 21**

FILE: bc-21.dgn	DN: TxDOT	CK: TxDOT	DW: TxDOT	CK: TxDOT
© TxDOT November 2002	CONT	SECT	JOB	HIGHWAY
REVISIONS	0092	14	104	IH 45
9-07 8-14	DIST	COUNTY	SHEET NO.	
7-13 5-21	18	DALLAS	12	

# TYPICAL APPLICATION OF WORK ZONE SPEED LIMIT SIGNS

Work zone speed limits shall be regulatory, established in accordance with the "Procedures for Establishing Speed Zones," and approved by the Texas Transportation Commission, or by City Ordinance when within Incorporated City Limits.

Reduced speeds should only be posted in the vicinity of work activity and not throughout the entire project. Regulatory work zone speed signs (R2-1) shall be removed or covered during periods when they are not needed.

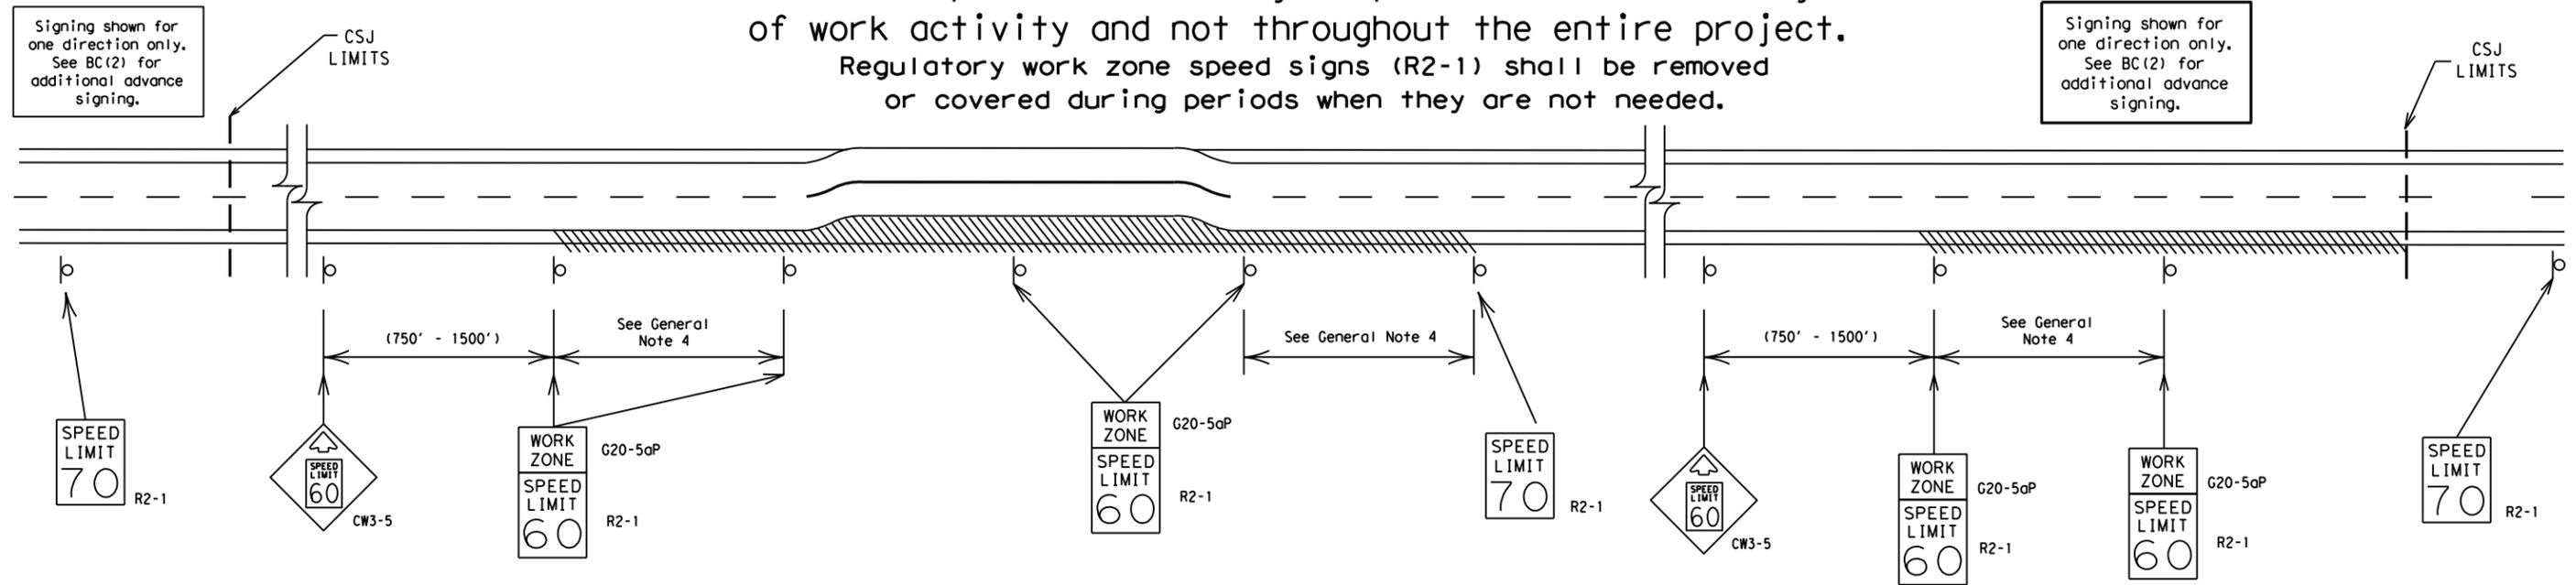

## GUIDANCE FOR USE:

### LONG/INTERMEDIATE TERM WORK ZONE SPEED LIMITS

This type of work zone speed limit should be included on the design of the traffic control plans when restricted geometrics with a lower design speed are present in the work zone and modification of the geometrics to a higher design speed is not feasible.

Long/Intermediate Term Work Zone Speed Limit signs, when approved as described above, should be posted and visible to the motorist when work activity is present. Work activity may also be defined as a change in the roadway that requires a reduced speed for motorists to safely negotiate the work area, including:

- rough road or damaged pavement surface
- substantial alteration of roadway geometrics (diversions)
- construction detours
- grade
- width
- other conditions readily apparent to the driver

As long as any of these conditions exist, the work zone speed limit signs should remain in place.

### SHORT TERM WORK ZONE SPEED LIMITS

This type of work zone speed limit may be included on the design of the traffic control plans when workers or equipment are not behind concrete barrier, when work activity is within 10 feet of the traveled way or actually in the traveled way.

Short Term Work Zone Speed Limit signs should be posted and visible to the motorists only when work activity is present. When work activity is not present, signs shall be removed or covered. (See Removing or Covering on BC(4)).

## GENERAL NOTES

- Regulatory work zone speed limits should be used only for sections of construction projects where speed control is of major importance.
- Regulatory work zone speed limit signs shall be placed on supports at a 7 foot minimum mounting height.
- Speed zone signs are illustrated for one direction of travel and are normally posted for each direction of travel.
- Frequency of work zone speed limit signs should be:
 

40 mph and greater	0.2 to 2 miles
35 mph and less	0.2 to 1 mile
- Regulatory speed limit signs shall have black legend and border on a white reflective background (See "Reflective Sheeting" on BC(4)).
- Fabrication, erection and maintenance of the "ADVANCE SPEED LIMIT" (CW3-5) sign, "WORK ZONE" (G20-5aP) plaque and the "SPEED LIMIT" (R2-1) signs shall not be paid for directly, but shall be considered subsidiary to Item 502.
- Turning signs from view, laying signs over or down will not be allowed, unless as otherwise noted under "REMOVING OR COVERING" on BC(4).
- Techniques that may help reduce traffic speeds include but are not limited to:
  - Law enforcement.
  - Flagger stationed next to sign.
  - Portable changeable message sign (PCMS).
  - Low-power (drone) radar transmitter.
  - Speed monitor trailers or signs.
- Speeds shown on details above are for illustration only. Work Zone Speed Limits should only be posted as approved for each project.
- For more specific guidance concerning the type of work, work zone conditions and factors impacting allowable regulatory construction speed zone reduction see TxDOT form #1204 in the TxDOT e-form system.

DISCLAIMER: The use of this standard is governed by the "Texas Engineering Practice Act". No warranty of any kind is made by TxDOT for any purpose whatsoever. TxDOT assumes no responsibility for the conversion of this standard to other formats or for incorrect results or damages resulting from its use.


DATE: 2023/03/15 2:57:37 PM  
FILE: DOCUMENT\NAME\line\txdot5\so\lomon\_bayou\d0852788\bc-21.dgn

SHEET 3 OF 12

		Traffic Safety Division Standard	
<h2>BARRICADE AND CONSTRUCTION WORK ZONE SPEED LIMIT</h2>			
<h3>BC (3) - 21</h3>			
FILE:	bc-21.dgn	DW: TxDOT	CK: TxDOT
© TxDOT	November 2002	CONT	SECT
REVISIONS		0092	14
9-07	8-14	104	IH 45
7-13	5-21	DIST	COUNTY
18	DALLAS	SHEET NO. 13	

DISCLAIMER: The use of this standard is governed by the "Texas Engineering Practice Act". No warranty of any kind is made by TxDOT for any purpose whatsoever. TxDOT assumes no responsibility for the conversion of this standard to other formats or for incorrect results or damages resulting from its use.


**TYPICAL MINIMUM CLEARANCES FOR LONG TERM AND INTERMEDIATE TERM SIGNS**

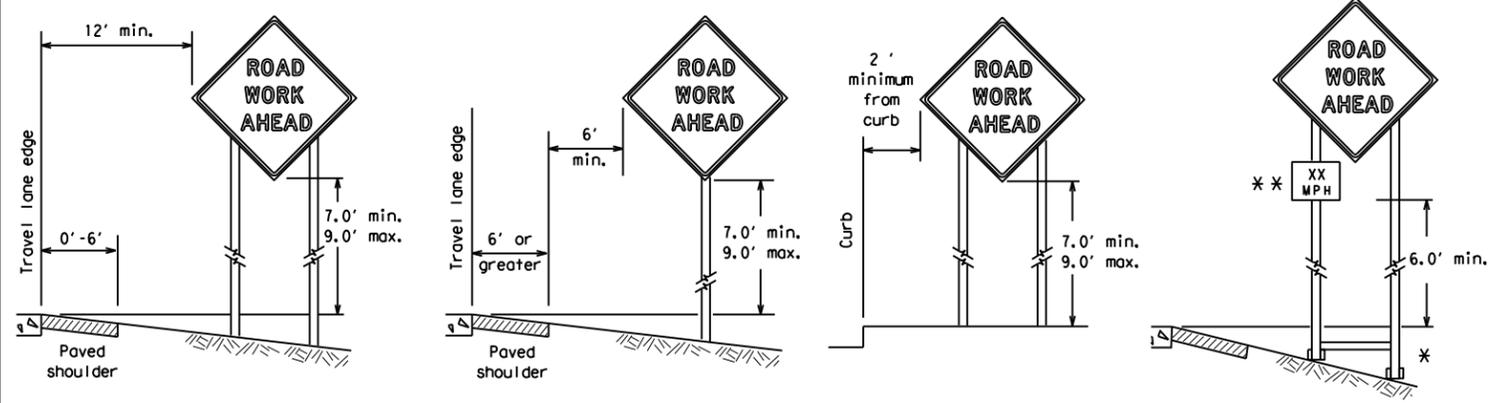

\* When placing skid supports on unlevel ground, the leg post lengths must be adjusted so the sign appears straight and plumb. Objects shall NOT be placed under skids as a means of leveling.

\*\* When plaques are placed on dual-leg supports, they should be attached to the upright nearest the travel lane. Supplemental plaques (advisory or distance) should not cover the surface of the parent sign.

**ATTACHMENT FOR SIGN SUPPORTS**

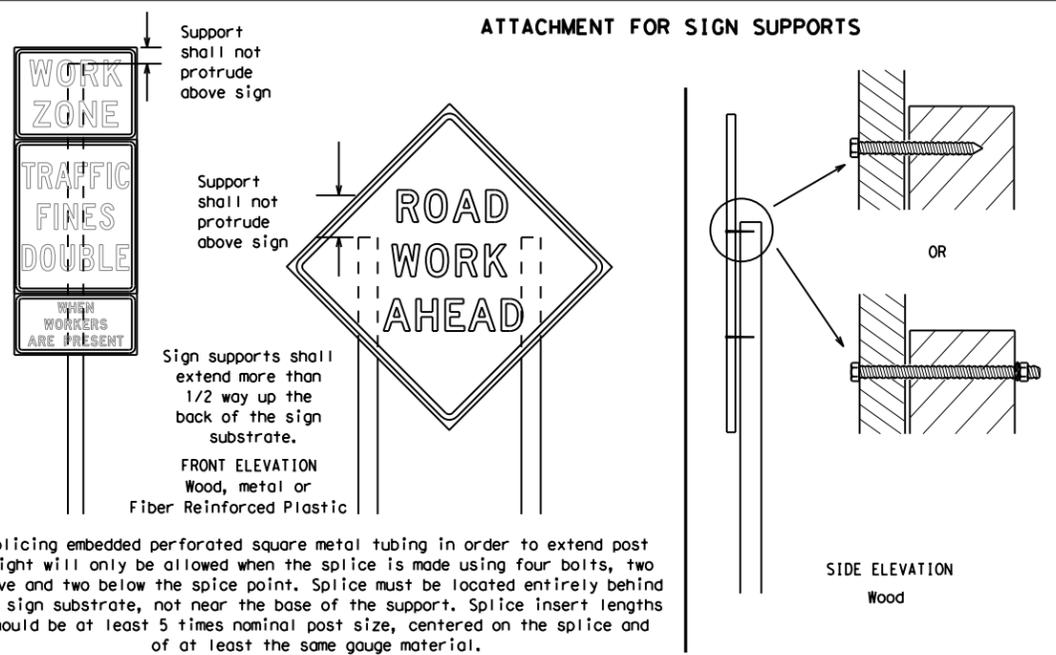

Attachment to wooden supports will be by bolts and nuts or screws. Use TxDOT's or manufacturer's recommended procedures for attaching sign substrates to other types of sign supports

**Nails shall NOT be allowed.**  
Each sign shall be attached directly to the sign support. Multiple signs shall not be joined or spliced by any means. Wood supports shall not be extended or repaired by splicing or other means.

Splicing embedded perforated square metal tubing in order to extend post height will only be allowed when the splice is made using four bolts, two above and two below the splice point. Splice must be located entirely behind the sign substrate, not near the base of the support. Splice insert lengths should be at least 5 times nominal post size, centered on the splice and of at least the same gauge material.

**GENERAL NOTES FOR WORK ZONE SIGNS**

- Contractor shall install and maintain signs in a straight and plumb condition and/or as directed by the Engineer.
- Wooden sign posts shall be painted white.
- Barricades shall NOT be used as sign supports.
- All signs shall be installed in accordance with the plans or as directed by the Engineer. Signs shall be used to regulate, warn, and guide the traveling public safely through the work zone.
- The Contractor may furnish either the sign design shown in the plans or in the "Standard Highway Sign Designs for Texas" (SHSD). The Engineer/Inspector may require the Contractor to furnish other work zone signs that are shown in the TMUTCD but may have been omitted from the plans. Any variation in the plans shall be documented by written agreement between the Engineer and the Contractor's Responsible Person. All changes must be documented in writing before being implemented. This can include documenting the changes in the Inspector's TxDOT diary and having both the Inspector and Contractor initial and date the agreed upon changes.
- The Contractor shall furnish sign supports listed in the "Compliant Work Zone Traffic Control Device List" (CWZTCD) for small roadside signs. Supports for temporary large roadside signs shall meet the requirements detailed on the Temporary Large Roadside Signs (TLRS) standard sheets. The Contractor shall install the sign support in accordance with the manufacturer's recommendations. If there is a question regarding installation procedures, the Contractor shall furnish the Engineer a copy of the manufacturer's installation recommendations so the Engineer can verify the correct procedures are being followed.
- The Contractor is responsible for installing signs on approved supports and replacing signs with damaged or cracked substrates and/or damaged or marred reflective sheeting as directed by the Engineer/Inspector.
- Identification markings may be shown only on the back of the sign substrate. The maximum height of letters and/or company logos used for identification shall be 1 inch.
- The Contractor shall replace damaged wood posts. New or damaged wood sign posts shall not be spliced.

**DURATION OF WORK (as defined by the "Texas Manual on Uniform Traffic Control Devices" Part 6)**

- The types of sign supports, sign mounting height, the size of signs, and the type of sign substrates can vary based on the type of work being performed. The Engineer is responsible for selecting the appropriate size sign for the type of work being performed. The Contractor is responsible for ensuring the sign support, sign mounting height and substrate meets manufacturer's recommendations in regard to crashworthiness and duration of work requirements.
  - Long-term stationary - work that occupies a location more than 3 days.
  - Intermediate-term stationary - work that occupies a location more than one daylight period up to 3 days, or nighttime work lasting more than one hour.
  - Short-term stationary - daytime work that occupies a location for more than 1 hour in a single daylight period.
  - Short, duration - work that occupies a location up to 1 hour.
  - Mobile - work that moves continuously or intermittently (stopping for up to approximately 15 minutes.)

**SIGN MOUNTING HEIGHT**

- The bottom of Long-term/Intermediate-term signs shall be at least 7 feet, but not more than 9 feet, above the paved surface, except as shown for supplemental plaques mounted below other signs.
- The bottom of Short-term/Short Duration signs shall be a minimum of 1 foot above the pavement surface but no more than 2 feet above the ground.
- Long-term/Intermediate-term Signs may be used in lieu of Short-term/Short Duration signing.
- Short-term/Short Duration signs shall be used only during daylight and shall be removed at the end of the workday or raised to appropriate Long-term/Intermediate sign height.
- Regulatory signs shall be mounted at least 7 feet, but not more than 9 feet, above the paved surface regardless of work duration.

**SIZE OF SIGNS**

- The Contractor shall furnish the sign sizes shown on BC (2) unless otherwise shown in the plans or as directed by the Engineer.

**SIGN SUBSTRATES**

- The Contractor shall ensure the sign substrate is installed in accordance with the manufacturer's recommendations for the type of sign support that is being used. The CWZTCD lists each substrate that can be used on the different types and models of sign supports.
- "Mesh" type materials are NOT an approved sign substrate, regardless of the tightness of the weave.
- All wooden individual sign panels fabricated from 2 or more pieces shall have one or more plywood cleat, 1/2" thick by 6" wide, fastened to the back of the sign and extending fully across the sign. The cleat shall be attached to the back of the sign using wood screws that do not penetrate the face of the sign panel. The screws shall be placed on both sides of the splice and spaced at 6" centers. The Engineer may approve other methods of splicing the sign face.

**REFLECTIVE SHEETING**

- All signs shall be retroreflective and constructed of sheeting meeting the color and retro-reflectivity requirements of DMS-8300 for rigid signs or DMS-8310 for roll-up signs. The web address for DMS specifications is shown on BC(1).
- White sheeting, meeting the requirements of DMS-8300 Type A, shall be used for signs with a white background.
- Orange sheeting, meeting the requirements of DMS-8300 Type B<sub>FL</sub> or Type C<sub>FL</sub>, shall be used for rigid signs with orange backgrounds.

**SIGN LETTERS**

- All sign letters and numbers shall be clear, and open rounded type uppercase alphabet letters as approved by the Federal Highway Administration (FHWA) and as published in the "Standard Highway Sign Design for Texas" manual. Signs, letters and numbers shall be of first class workmanship in accordance with Department Standards and Specifications.

**REMOVING OR COVERING**

- When sign messages may be confusing or do not apply, the signs shall be removed or completely covered.
- Long-term stationary or intermediate stationary signs installed on square metal tubing may be turned away from traffic 90 degrees when the sign message is not applicable. This technique may not be used for signs installed in the median of divided highways or near any intersections where the sign may be seen from approaching traffic.
- Signs installed on wooden skids shall not be turned at 90 degree angles to the roadway. These signs should be removed or completely covered when not required.
- When signs are covered, the material used shall be opaque, such as heavy mil black plastic, or other materials which will cover the entire sign face and maintain their opaque properties under automobile headlights at night, without damaging the sign sheeting.
- Burlap shall NOT be used to cover signs.
- Duct tape or other adhesive material shall NOT be affixed to a sign face.
- Signs and anchor stubs shall be removed and holes backfilled upon completion of work.

**SIGN SUPPORT WEIGHTS**


- Where sign supports require the use of weights to keep from turning over, the use of sandbags with dry, cohesionless sand should be used.
- The sandbags will be tied shut to keep the sand from spilling and to maintain a constant weight.
- Rock, concrete, iron, steel or other solid objects shall not be permitted for use as sign support weights.
- Sandbags should weigh a minimum of 35 lbs and a maximum of 50 lbs.
- Sandbags shall be made of a durable material that tears upon vehicular impact. Rubber (such as tire inner tubes) shall NOT be used.
- Rubber ballasts designed for channelizing devices should not be used for ballast on portable sign supports. Sign supports designed and manufactured with rubber bases may be used when shown on the CWZTCD list.
- Sandbags shall only be placed along or laid over the base supports of the traffic control device and shall not be suspended above ground level or hung with rope, wire, chains or other fasteners. Sandbags shall be placed along the length of the skids to weigh down the sign support.
- Sandbags shall NOT be placed under the skid and shall not be used to level sign supports placed on slopes.

**FLAGS ON SIGNS**

- Flags may be used to draw attention to warning signs. When used, the flag shall be 16 inches square or larger and shall be orange or fluorescent red-orange in color. Flags shall not be allowed to cover any portion of the sign face.

**STOP/SLOW PADDLES**

- STOP/SLOW paddles are the primary method to control traffic by flaggers. The STOP/SLOW paddle size should be 24" x 24".
- STOP/SLOW paddles shall be retroreflective when used at night.
- STOP/SLOW paddles may be attached to a staff with a minimum length of 6' to the bottom of the sign.
- Any lights incorporated into the STOP or SLOW paddle faces shall only be as specifically described in Section 6E.03 Hand Signaling Devices in the TMUTCD.

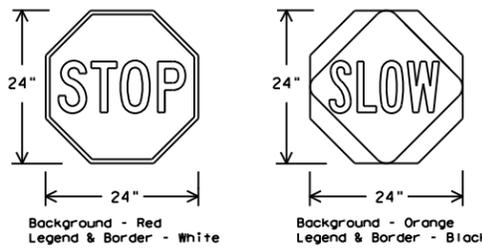

SHEETING REQUIREMENTS (WHEN USED AT NIGHT)		
USAGE	COLOR	SIGN FACE MATERIAL
BACKGROUND	RED	TYPE B OR C SHEETING
BACKGROUND	ORANGE	TYPE B <sub>FL</sub> OR C <sub>FL</sub> SHEETING
LEGEND & BORDER	WHITE	TYPE B OR C SHEETING
LEGEND & BORDER	BLACK	ACRYLIC NON-REFLECTIVE FILM

**CONTRACTOR REQUIREMENTS FOR MAINTAINING PERMANENT SIGNS WITHIN THE PROJECT LIMITS**

- Permanent signs are used to give notice of traffic laws or regulations, call attention to conditions that are potentially hazardous to traffic operations, show route designations, destinations, directions, distances, services, points of interest, and other geographical, recreational, specific service (LOGO), or cultural information. Drivers proceeding through a work zone need the same, if not better route guidance as normally installed on a roadway without construction.
- When permanent regulatory or warning signs conflict with work zone conditions, remove or cover the permanent signs until the permanent sign message matches the roadway condition. For details for covering large guide signs see the TS-CD standard.
- When existing permanent signs are moved and relocated due to construction purposes, they shall be visible to motorists at all times.
- If existing signs are to be relocated on their original supports, they shall be installed on crashworthy bases as shown on the SMD Standard sheets. The signs shall meet the required mounting heights shown on the BC Sheets or the SMD Standards. This work should be paid for under the appropriate pay item for relocating existing signs.
- If permanent signs are to be removed and relocated using temporary supports, the Contractor shall use crashworthy supports as shown on the BC standard sheets, TLRS standard sheets or the CWZTCD list. The signs shall meet the required mounting heights shown on the BC, or the SMD standard sheets during construction. This work should be paid for under the appropriate pay item for relocating existing signs.
- Any sign or traffic control device that is struck or damaged by the Contractor or his/her construction equipment shall be replaced as soon as possible by the Contractor to ensure proper guidance for the motorists. This will be subsidiary to Item 502.



**BARRICADE AND CONSTRUCTION TEMPORARY SIGN NOTES**



**BC (4) - 21**

FILE:	bc-21.dgn	DN:	TxDOT	CR:	TxDOT	OW:	TxDOT	CK:	TxDOT
© TxDOT	November 2002	CONT	SECT	JOB	HIGHWAY				
REVISIONS		0092	14	104	IH 45				
9-07	8-14	DIST	COUNTY	SHEET NO.					
7-13	5-21	DAL	DALLAS	14					

DATE: 20230321 2:57:39 PM  
FILE: DOCUMENT\NAME\line\txdot5\solomon\_bayou\d0852788\_bc-21.dgn


DISCLAIMER: The use of this standard is governed by the "Texas Engineering Practice Act". No warranty of any kind is made by TxDOT for any purpose whatsoever. TxDOT assumes no responsibility for the conversion of this standard to other formats or for incorrect results or damages resulting from its use.

DATE: 2022/10/01 9:53:22 AM  
 FILE: DOCUMENT\NAME\line.txdot\5\solomon\_bayou\d0852788\_bc-21.dgn

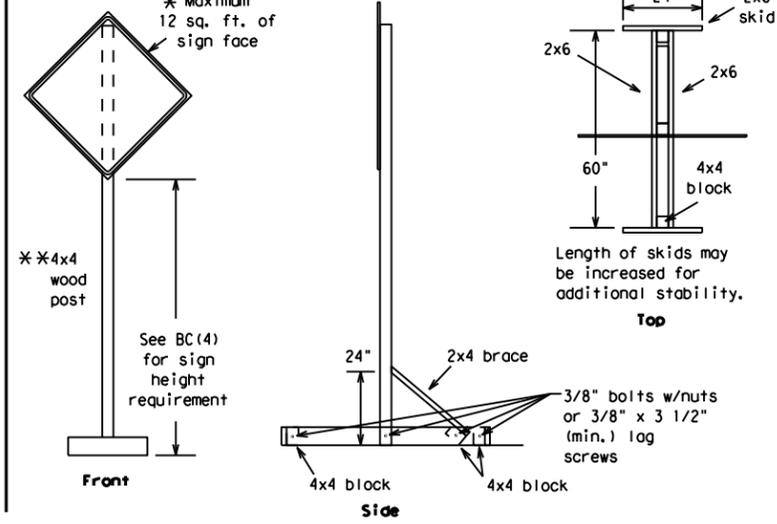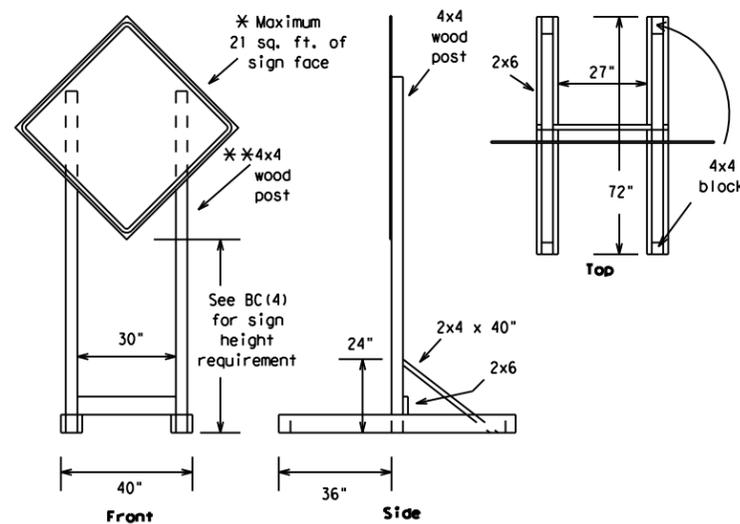



**SKID MOUNTED WOOD SIGN SUPPORTS**

\* LONG/INTERMEDIATE TERM STATIONARY - PORTABLE SKID MOUNTED SIGN SUPPORTS

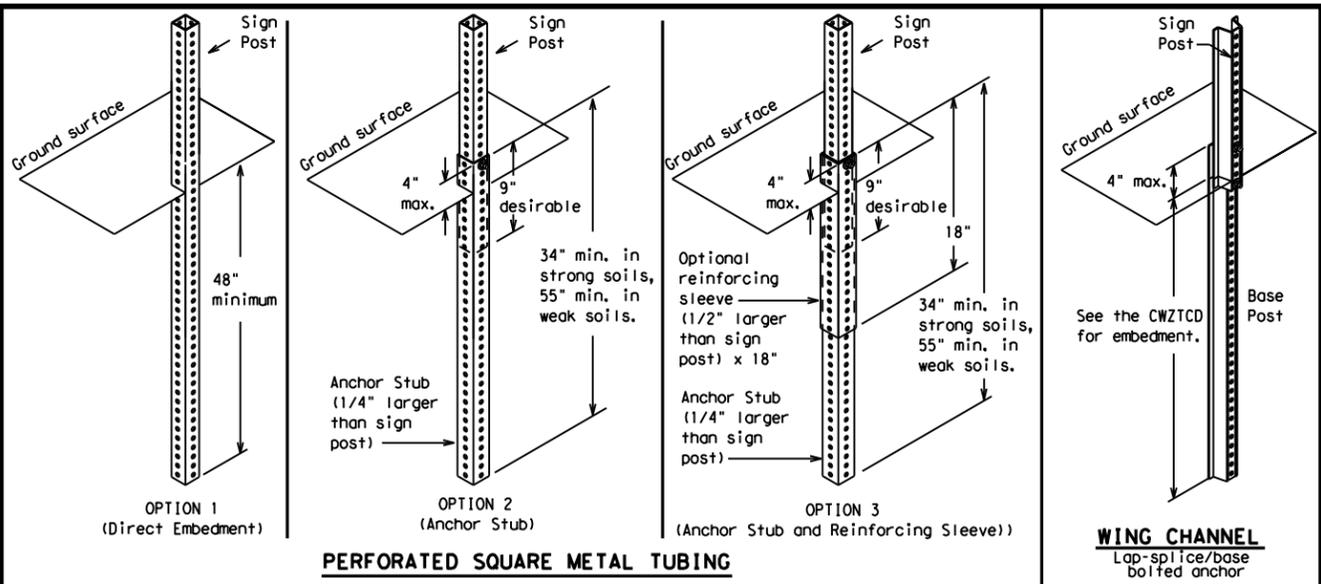

**GROUND MOUNTED SIGN SUPPORTS**

Refer to the CWZTCD and the manufacturer's installation procedure for each type sign support. The maximum sign square footage shall adhere to the manufacturer's recommendation. Two post installations can be used for larger signs.

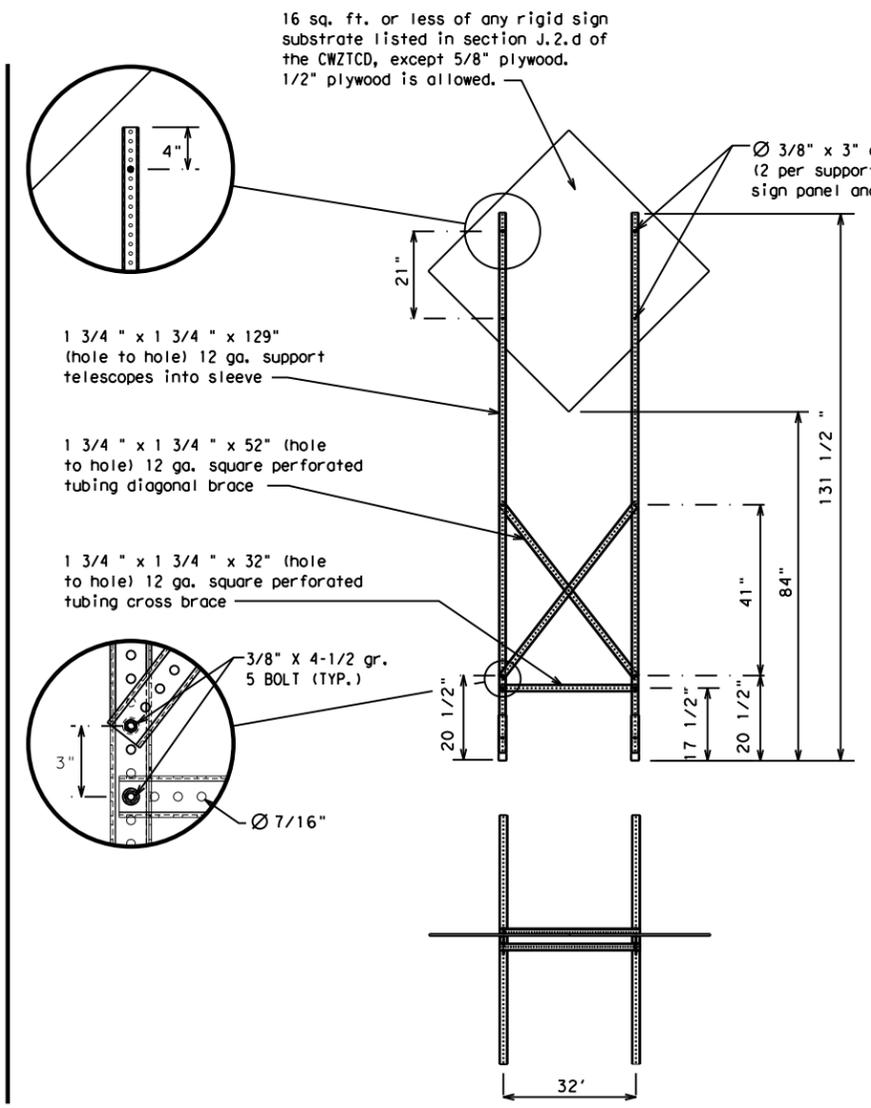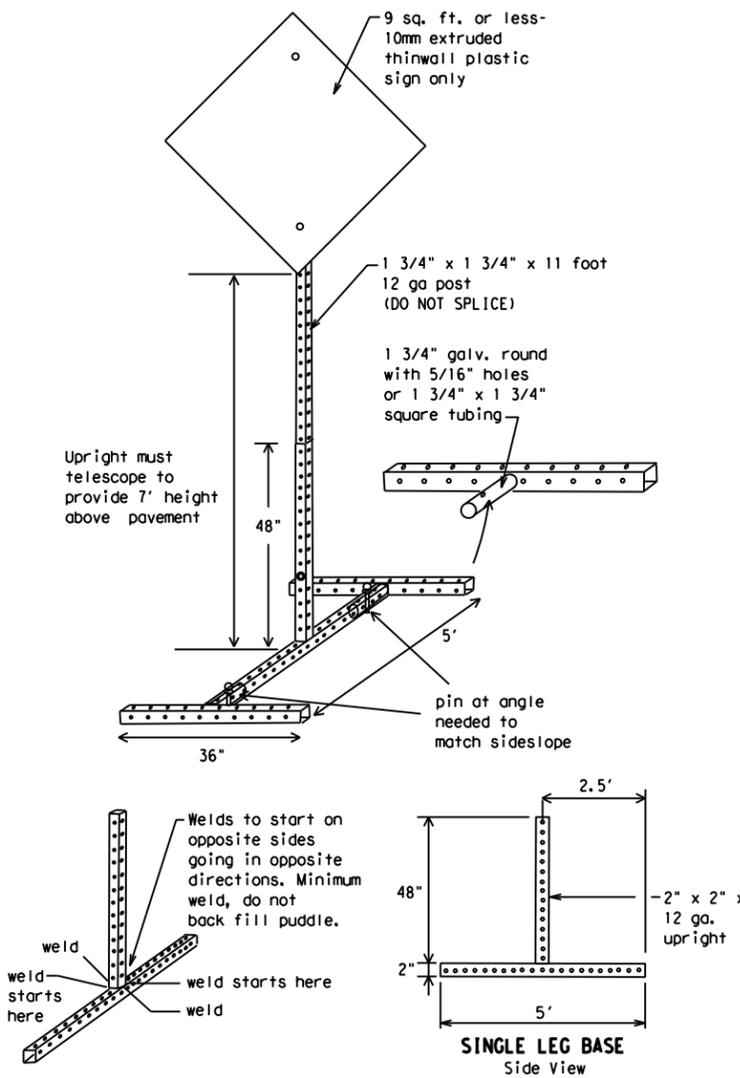

**SKID MOUNTED PERFORATED SQUARE STEEL TUBING SIGN SUPPORTS**

\* LONG/INTERMEDIATE TERM STATIONARY - PORTABLE SKID MOUNTED SIGN SUPPORTS

**WEDGE ANCHORS**  
 Both steel and plastic Wedge Anchor Systems as shown on the SMD Standard Sheets may be used as temporary sign supports for signs up to 10 square feet of sign face. They may be set in concrete or in sturdy soils if approved by the Engineer. (See web address for "Traffic Engineering Standard Sheets" on BC(1)).

**OTHER DESIGNS**  
 MORE DETAILS OF APPROVED LONG/INTERMEDIATE AND SHORT TERM SUPPORTS CAN BE FOUND ON THE CWZTCD LIST. SEE BC(1) FOR WEBSITE LOCATION.

- GENERAL NOTES**
- Nails may be used in the assembly of wooden sign supports, but 3/8" bolts with nuts or 3/8" x 3 1/2" lag screws must be used on every joint for final connection.
  - No more than 2 sign posts shall be placed within a 7 ft. circle, except for specific materials noted on the CWZTCD List.
  - When project is completed, all sign supports and foundations shall be removed from the project site. This will be considered subsidiary to Item 502.
- \* See BC(4) for definition of "Work Duration."
  - \*\* Wood sign posts MUST be one piece. Splicing will NOT be allowed. Posts shall be painted white.
  - See the CWZTCD for the type of sign substrate that can be used for each approved sign support.

SHEET 5 OF 12  
 Texas Department of Transportation  
 Traffic Safety Division Standard

**BARRICADE AND CONSTRUCTION TYPICAL SIGN SUPPORT**

**BC(5) - 21**

FILE:	bc-21.dgn	DN:	TxDOT	CK:	TxDOT	DW:	TxDOT	CR:	TxDOT
© TxDOT	November 2002	CONT	SECT	JOB	HIGHWAY				
REVISIONS	0092	14	104	IH	45				
9-07	8-14	DIST	COUNTY	SHEET NO.					
7-13	5-21	18	DALLAS	15					

WHEN NOT IN USE, REMOVE THE PCMS FROM THE RIGHT-OF-WAY OR PLACE THE PCMS BEHIND BARRIER OR GUARDRAIL WITH SIGN PANEL TURNED PARALLEL TO TRAFFIC

# RECOMMENDED PHASES AND FORMATS FOR PCMS MESSAGES DURING ROADWORK ACTIVITIES

(The Engineer may approve other messages not specifically covered here.)

## PORTABLE CHANGEABLE MESSAGE SIGNS

- The Engineer/Inspector shall approve all messages used on portable changeable message signs (PCMS).
- Messages on PCMS should contain no more than 8 words (about four to eight characters per word), not including simple words such as "TO," "FOR," "AT," etc.
- Messages should consist of a single phase, or two phases that alternate. Three-phase messages are not allowed. Each phase of the message should convey a single thought, and must be understood by itself.
- Use the word "EXIT" to refer to an exit ramp on a freeway; i.e., "EXIT CLOSED." Do not use the term "RAMP."
- Always use the route or interstate designation (IH, US, SH, FM) along with the number when referring to a roadway.
- When in use, the bottom of a stationary PCMS message panel should be a minimum 7 feet above the roadway, where possible.
- The message term "WEEKEND" should be used only if the work is to start on Saturday morning and end by Sunday evening at midnight. Actual days and hours of work should be displayed on the PCMS if work is to begin on Friday evening and/or continue into Monday morning.
- The Engineer/Inspector may select one of two options which are available for displaying a two-phase message on a PCMS. Each phase may be displayed for either four seconds each or for three seconds each.
- Do not "flash" messages or words included in a message. The message should be steady burn or continuous while displayed.
- Do not present redundant information on a two-phase message; i.e., keeping two lines of the message the same and changing the third line.
- Do not use the word "Danger" in message.
- Do not display the message "LANES SHIFT LEFT" or "LANES SHIFT RIGHT" on a PCMS. Drivers do not understand the message.
- Do not display messages that scroll horizontally or vertically across the face of the sign.
- The following table lists abbreviated words and two-word phrases that are acceptable for use on a PCMS. Both words in a phrase must be displayed together. Words or phrases not on this list should not be abbreviated, unless shown in the TMUTCD.
- PCMS character height should be at least 18 inches for trailer mounted units. They should be visible from at least 1/2 (.5) mile and the text should be legible from at least 600 feet at night and 800 feet in daylight. Truck mounted units must have a character height of 10 inches and must be legible from at least 400 feet.
- Each line of text should be centered on the message board rather than left or right justified.
- If disabled, the PCMS should default to an illegible display that will not alarm motorists and will only be used to alert workers that the PCMS has malfunctioned. A pattern such as a series of horizontal solid bars is appropriate.

## Phase 1: Condition Lists

### Road/Lane/Ramp Closure List

FREEWAY CLOSED X MILE	FRONTAGE ROAD CLOSED
ROAD CLOSED AT SH XXX	SHOULDER CLOSED XXX FT
ROAD CLSD AT FM XXXX	RIGHT LN CLOSED XXX FT
RIGHT X LANES CLOSED	RIGHT X LANES OPEN
CENTER LANE CLOSED	DAYTIME LANE CLOSURES
NIGHT LANE CLOSURES	I-XX SOUTH EXIT CLOSED
VARIOUS LANES CLOSED	EXIT XXX CLOSED X MILE
EXIT CLOSED	RIGHT LN TO BE CLOSED
MALL DRIVEWAY CLOSED	X LANES CLOSED TUE - FRI
XXXXXXXX BLVD CLOSED	

### Other Condition List

ROADWORK XXX FT	ROAD REPAIRS XXXX FT
FLAGGER XXXX FT	LANE NARROWS XXXX FT
RIGHT LN NARROWS XXXX FT	TWO-WAY TRAFFIC XX MILE
MERGING TRAFFIC XXXX FT	CONST TRAFFIC XXX FT
LOOSE GRAVEL XXXX FT	UNEVEN LANES XXXX FT
DETOUR X MILE	ROUGH ROAD XXXX FT
ROADWORK PAST SH XXXX	ROADWORK NEXT FRI-SUN
BUMP XXXX FT	US XXX EXIT X MILES
TRAFFIC SIGNAL XXXX FT	LANES SHIFT *

\* LANES SHIFT in Phase 1 must be used with STAY IN LANE in Phase 2.

## Phase 2: Possible Component Lists

### Action to Take/Effect on Travel List

MERGE RIGHT	FORM X LINES RIGHT
DETOUR NEXT X EXITS	USE XXXXX RD EXIT
USE EXIT XXX	USE EXIT I-XX NORTH
STAY ON US XXX SOUTH	USE I-XX E TO I-XX N
TRUCKS USE US XXX N	WATCH FOR TRUCKS
WATCH FOR TRUCKS	EXPECT DELAYS
EXPECT DELAYS	PREPARE TO STOP
REDUCE SPEED XXX FT	END SHOULDER USE
USE OTHER ROUTES	WATCH FOR WORKERS
STAY IN LANE *	

### Location List

AT FM XXXX
BEFORE RAILROAD CROSSING
NEXT X MILES
PAST US XXX EXIT
XXXXXXXX TO XXXXXX
US XXX TO FM XXXX

### Warning List

SPEED LIMIT XX MPH
MAXIMUM SPEED XX MPH
MINIMUM SPEED XX MPH
ADVISORY SPEED XX MPH
RIGHT LANE EXIT
USE CAUTION
DRIVE SAFELY
DRIVE WITH CARE

### \*\* Advance Notice List

TUE-FRI XX AM-X PM
APR XX-XX X PM-X AM
BEGINS MONDAY
BEGINS MAY XX
MAY X-X XX PM - XX AM
NEXT FRI-SUN
XX AM TO XX PM
NEXT TUE AUG XX
TONIGHT XX PM-XX AM

\*\* See Application Guidelines Note 6.

## APPLICATION GUIDELINES

- Only 1 or 2 phases are to be used on a PCMS.
- The 1st phase (or both) should be selected from the "Road/Lane/Ramp Closure List" and the "Other Condition List".
- A 2nd phase can be selected from the "Action to Take/Effect on Travel, Location, General Warning, or Advance Notice Phase Lists".
- A Location Phase is necessary only if a distance or location is not included in the first phase selected.
- If two PCMS are used in sequence, they must be separated by a minimum of 1000 ft. Each PCMS shall be limited to two phases, and should be understandable by themselves.
- For advance notice, when the current date is within seven days of the actual work date, calendar days should be replaced with days of the week. Advance notification should typically be for no more than one week prior to the work.

## WORDING ALTERNATIVES

- The words RIGHT, LEFT and ALL can be interchanged as appropriate.
- Roadway designations IH, US, SH, FM and LP can be interchanged as appropriate.
- EAST, WEST, NORTH and SOUTH (or abbreviations E, W, N and S) can be interchanged as appropriate.
- Highway names and numbers replaced as appropriate.
- ROAD, HIGHWAY and FREEWAY can be interchanged as needed.
- AHEAD may be used instead of distances if necessary.
- FT and MI, MILE and MILES interchanged as appropriate.
- AT, BEFORE and PAST interchanged as needed.
- Distances or AHEAD can be eliminated from the message if a location phase is used.

PCMS SIGNS WITHIN THE R.O.W. SHALL BE BEHIND GUARDRAIL OR CONCRETE BARRIER OR SHALL HAVE A MINIMUM OF FOUR (4) PLASTIC DRUMS PLACED PERPENDICULAR TO TRAFFIC ON THE UPSTREAM SIDE OF THE PCMS, WHEN EXPOSED TO ONE DIRECTION OF TRAFFIC. WHEN EXPOSED TO TWO WAY TRAFFIC, THE FOUR DRUMS SHOULD BE PLACED WITH ONE DRUM AT EACH OF THE FOUR CORNERS OF THE UNIT.

## FULL MATRIX PCMS SIGNS

- When Full Matrix PCMS signs are used, the character height and legibility/visibility requirements shall be maintained as listed in Note 15 under "PORTABLE CHANGEABLE MESSAGE SIGNS" above.
- When symbol signs, such as the "Flagger Symbol" (CW20-7) are represented graphically on the Full Matrix PCMS sign and, with the approval of the Engineer, it shall maintain the legibility/visibility requirement listed above.
- When symbol signs are represented graphically on the Full Matrix PCMS, they shall only supplement the use of the static sign represented, and shall not substitute for, or replace that sign.
- A full matrix PCMS may be used to simulate a flashing arrow board provided it meets the visibility, flash rate and dimming requirements on BC(7), for the same size arrow.

DISCLAIMER: The use of this standard is governed by the "Texas Engineering Practice Act". No warranty of any kind is made by TxDOT for any purpose whatsoever. TxDOT assumes no responsibility for the conversion of this standard to other formats or for incorrect results or damages resulting from its use.

DATE: 2022/10/20 9:54:08 AM  
FILE: \\DOCUMENT\NAME\line\txdot5\solomon\_bayou\d0852788\_bc-21.dgn

WORD OR PHRASE	ABBREVIATION	WORD OR PHRASE	ABBREVIATION
Access Road	ACCS RD	Major	MAJ
Alternate	ALT	Miles	MI
Avenue	AVE	Miles Per Hour	MPH
Best Route	BEST RTE	Minor	MNR
Boulevard	BLVD	Monday	MON
Bridge	BRDG	Normal	NORM
Canal	CANT	North	N
Center	CTR	Northbound	(route) N
Construction Ahead	CONST AHD	Parking	PKING
CROSSING	XING	Road	RD
Detour Route	DETOUR RTE	Right Lane	RT LN
Do Not	DONT	Saturday	SAT
East	E	Service Road	SERV RD
Eastbound	(route) E	Shoulder	SHLDR
Emergency	EMER	Slippery	SLIP
Emergency Vehicle	EMER VEH	South	S
Entrance, Enter	ENT	Southbound	(route) S
Express Lane	EXP LN	Speed	SPD
Expressway	EXPWY	Street	ST
XXXX Feet	XXXX FT	Sunday	SUN
Fog Ahead	FOG AHD	Telephone	PHONE
Freeway	FRWY, FWY	Temporary	TEMP
Freeway Blocked	FWY BLKD	Thursday	THURS
Friday	FRI	To Downtown	TO DWNTN
Hazardous Driving	HAZ DRIVING	Traffic	TRAF
Hazardous Material	HAZMAT	Travelers	TRVLR
High-Occupancy Vehicle	HOV	Tuesday	TUES
Hour(s)	HR, HRS	Time Minutes	TIME MIN
Information	INFO	Upper Level	UPR LEVEL
It Is	ITS	Vehicles (s)	VEH, VEHS
Junction	JCT	Warning	WARN
Left	LFT	Wednesday	WED
Left Lane	LFT LN	Weight Limit	WT LIMIT
Lane Closed	LN CLOSED	West	W
Lower Level	LWR LEVEL	Westbound	(route) W
Maintenance	MAINT	Wet Pavement	WET PVMT
		Will Not	WONT


Roadway designation # IH-number, US-number, SH-number, FM-number

<h3>BARRICADE AND CONSTRUCTION PORTABLE CHANGEABLE MESSAGE SIGN (PCMS)</h3>			
<h2>BC (6) - 21</h2>			
FILE:	bc-21.dgn	DN:	TxDOT
© TxDOT	November 2002	CK:	TxDOT
REVISIONS	0092	DW:	TxDOT
9-07	8-14	CR:	TxDOT
7-13	5-21	CON:	SECT
		JOB:	104
		HIGHWAY:	IH 45
		DIST:	18
		COUNTY:	DALLAS
		SHEET NO.:	16

DISCLAIMER: The use of this standard is governed by the "Texas Engineering Practice Act". No warranty of any kind is made by TxDOT for any purpose whatsoever. TxDOT assumes no responsibility for the conversion of this standard to other formats or for incorrect results or damages resulting from its use.


DATE: 2023/03/15 2:57:47 PM  
 FILE: DOCUMENT\NAME\line\txdot5\solomon\_bayou\d0852788\_bc-21.dgn

- Barrier Reflectors shall be pre-qualified, and conform to the color and reflectivity requirements of DMS-8600. A list of prequalified Barrier Reflectors can be found at the Material Producer List web address shown on BC(1).
- Color of Barrier Reflectors shall be as specified in the TMUTCD. The cost of the reflectors shall be considered subsidiary to Item 512.

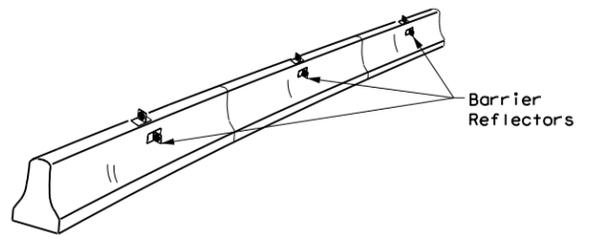


**CONCRETE TRAFFIC BARRIER (CTB)**

- Where traffic is on one side of the CTB, two (2) Barrier Reflectors shall be mounted in approximately the midsection of each section of CTB. An alternate mounting location is uniformly spaced at one end of each CTB. This will allow for attachment of a barrier grapple without damaging the reflector. The Barrier Reflector mounted on the side of the CTB shall be located directly below the reflector mounted on top of the barrier, as shown in the detail above.
- Where CTB separates two-way traffic, three barrier reflectors shall be mounted on each section of CTB. The reflector unit on top shall have two yellow reflective faces (Bi-Directional) while the reflectors on each side of the barrier shall have one yellow reflective face, as shown in the detail above.
- When CTB separates traffic traveling in the same direction, no barrier reflectors will be required on top of the CTB.
- Barrier Reflector units shall be yellow or white in color to match the edgeline being supplemented.
- Maximum spacing of Barrier Reflectors is forty (40) feet.
- Pavement markers or temporary flexible-reflective roadway marker tabs shall NOT be used as CTB delineation.
- Attachment of Barrier Reflectors to CTB shall be per manufacturer's recommendations.
- Missing or damaged Barrier Reflectors shall be replaced as directed by the Engineer.
- Single slope barriers shall be delineated as shown on the above detail.

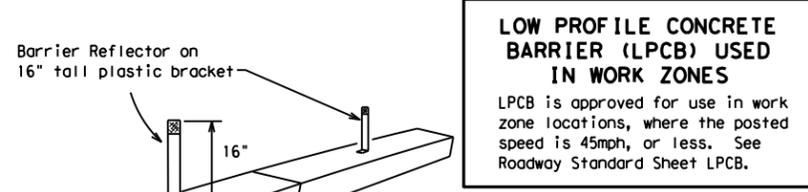

**LOW PROFILE CONCRETE BARRIER (LPCB) USED IN WORK ZONES**  
 LPCB is approved for use in work zone locations, where the posted speed is 45mph, or less. See Roadway Standard Sheet LPCB.

**LOW PROFILE CONCRETE BARRIER (LPCB)**

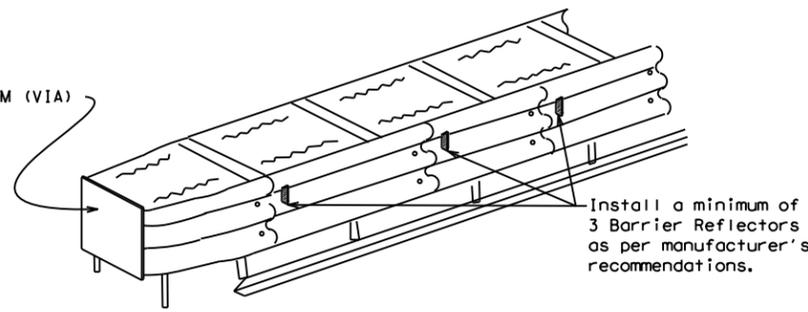

**DELINEATION OF END TREATMENTS**

**END TREATMENTS FOR CTB'S USED IN WORK ZONES**  
 End treatments used on CTB's in work zones shall meet the appropriate crashworthy standards as defined in the Manual for Assessing Safety Hardware (MASH). Refer to the CWZTCD List for approved end treatments and manufacturers.

**BARRIER REFLECTORS FOR CONCRETE TRAFFIC BARRIER AND ATTENUATORS**

**WARNING LIGHTS**


- Warning lights shall meet the requirements of the TMUTCD.
- Warning lights shall NOT be installed on barricades.
- Type A-Low Intensity Flashing Warning Lights are commonly used with drums. They are intended to warn of or mark a potentially hazardous area. Their use shall be as indicated on this sheet and/or other sheets of the plans by the designation "FL". The Type A Warning Lights shall not be used with signs manufactured with Type B<sub>PL</sub> or C<sub>FL</sub> Sheeting meeting the requirements of Departmental Material Specification DMS-8300.
- Type-C and Type D 360 degree Steady Burn Lights are intended to be used in a series for delineation to supplement other traffic control devices. Their use shall be as indicated on this sheet and/or other sheets of the plans by the designation "SB".
- The Engineer/Inspector or the plans shall specify the location and type of warning lights to be installed on the traffic control devices.
- When required by the Engineer, the Contractor shall furnish a copy of the warning lights certification. The warning light manufacturer will certify the warning lights meet the requirements of the latest ITE Purchase Specifications for Flashing and Steady-Burn Warning Lights.
- When used to delineate curves, Type-C and Type D Steady Burn Lights should only be placed on the outside of the curve, not the inside.
- The location of warning lights and warning reflectors on drums shall be as shown elsewhere in the plans.

**WARNING LIGHTS MOUNTED ON PLASTIC DRUMS**


- Type A flashing warning lights are intended to warn drivers that they are approaching or are in a potentially hazardous area.
- Type A random flashing warning lights are not intended for delineation and shall not be used in a series.
- A series of sequential flashing warning lights placed on channelizing devices to form a merging taper may be used for delineation. If used, the successive flashing of the sequential warning lights should occur from the beginning of the taper to the end of the merging taper in order to identify the desired vehicle path. The rate of flashing for each light shall be 65 flashes per minute, plus or minus 10 flashes.
- Type C and D steady-burn warning lights are intended to be used in a series to delineate the edge of the travel lane on detours, on lane changes, on lane closures, and on other similar conditions.
- Type A, Type C and Type D warning lights shall be installed at locations as detailed on other sheets in the plans.
- Warning lights shall not be installed on a drum that has a sign, chevron or vertical panel.
- The maximum spacing for warning lights on drums should be identical to the channelizing device spacing.

**WARNING REFLECTORS MOUNTED ON PLASTIC DRUMS AS A SUBSTITUTE FOR TYPE C (STEADY BURN) WARNING LIGHTS**

- A warning reflector or approved substitute may be mounted on a plastic drum as a substitute for a Type C, steady burn warning light at the discretion of the Contractor unless otherwise noted in the plans.
- The warning reflector shall be yellow in color and shall be manufactured using a sign substrate approved for use with plastic drums listed on the CWZTCD.
- The warning reflector shall have a minimum retroreflective surface area (one-side) of 30 square inches.
- Round reflectors shall be fully reflectorized, including the area where attached to the drum.
- Square substrates must have a minimum of 30 square inches of reflectorized sheeting. They do not have to be reflectorized where it attaches to the drum.
- The side of the warning reflector facing approaching traffic shall have sheeting meeting the color and retroreflectivity requirements for DMS 8300-Type B or Type C.
- When used near two-way traffic, both sides of the warning reflector shall be reflectorized.
- The warning reflector should be mounted on the side of the handle nearest approaching traffic.
- The maximum spacing for warning reflectors should be identical to the channelizing device spacing requirements.

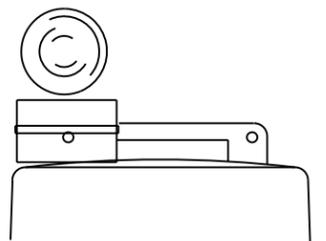


Type C Warning Light or approved substitute mounted on a drum adjacent to the travel way.

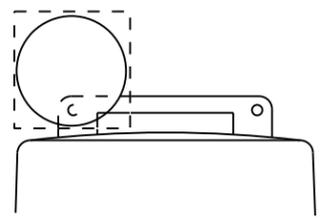

Warning reflector may be round or square. Must have a yellow reflective surface area of at least 30 square inches

Arrow Boards may be located behind channelizing devices in place for a shoulder taper or merging taper, otherwise they shall be delineated with four (4) channelizing devices placed perpendicular to traffic on the upstream side of traffic.

- The Flashing Arrow Board should be used for all lane closures on multi-lane roadways, or slow moving maintenance or construction activities on the travel lanes.
- Flashing Arrow Boards should not be used on two-lane, two-way roadways, detours, diversions or work on shoulders unless the "CAUTION" display (see detail below) is used.
- The Engineer/Inspector shall choose all appropriate signs, barricades and/or other traffic control devices that should be used in conjunction with the Flashing Arrow Board.
- The Flashing Arrow Board should be able to display the following symbols:

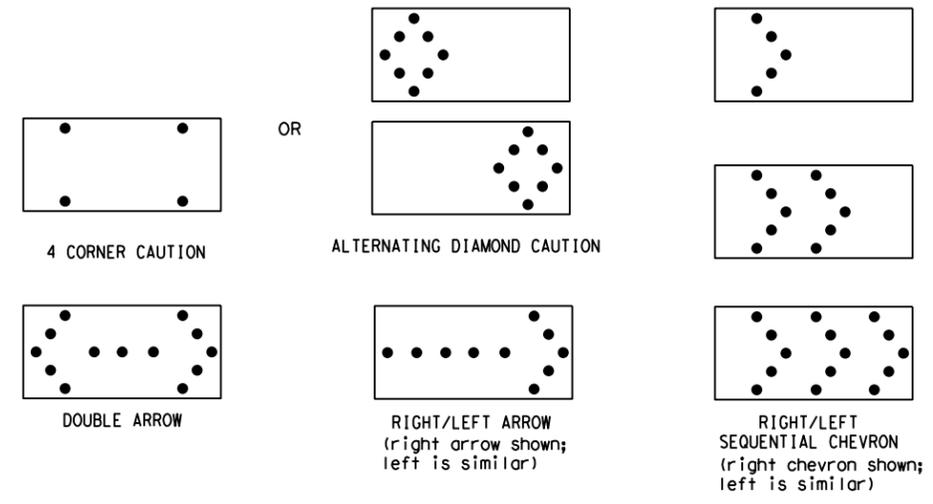

- The "CAUTION" display consists of four corner lamps flashing simultaneously, or the Alternating Diamond Caution mode as shown.
- The straight line caution display is NOT ALLOWED.
- The Flashing Arrow Board shall be capable of minimum 50 percent dimming from rated lamp voltage. The flashing rate of the lamps shall not be less than 25 nor more than 40 flashes per minute.
- Minimum lamp "on time" shall be approximately 50 percent for the flashing arrow and equal intervals of 25 percent for each sequential phase of the flashing chevron.
- The sequential arrow display is NOT ALLOWED.
- The flashing arrow display is the TxDOT standard; however, the sequential chevron display may be used during daylight operations.
- The Flashing Arrow Board shall be mounted on a vehicle, trailer or other suitable support.
- A Flashing Arrow Board SHALL NOT BE USED to laterally shift traffic.
- A full matrix PCMS may be used to simulate a Flashing Arrow Board provided it meets visibility, flash rate and dimming requirements on this sheet for the same size arrow.
- Minimum mounting height of trailer mounted Arrow Boards should be 7 feet from roadway to bottom of panel.

REQUIREMENTS			
TYPE	MINIMUM SIZE	MINIMUM NUMBER OF PANEL LAMPS	MINIMUM VISIBILITY DISTANCE
B	30 x 60	13	3/4 mile
C	48 x 96	15	1 mile

**ATTENTION**  
 Flashing Arrow Boards shall be equipped with automatic dimming devices.

WHEN NOT IN USE, REMOVE THE ARROW BOARD FROM THE RIGHT-OF-WAY OR PLACE THE ARROW BOARD BEHIND CONCRETE TRAFFIC BARRIER OR GUARDRAIL.

**FLASHING ARROW BOARDS**

SHEET 7 OF 12

**TRUCK-MOUNTED ATTENUATORS**

- Truck-mounted attenuators (TMA) used on TxDOT facilities must meet the requirements outlined in the Manual for Assessing Safety Hardware (MASH).
- Refer to the CWZTCD for the requirements of Level 2 or Level 3 TMAs.
- Refer to the CWZTCD for a list of approved TMAs.
- TMAs are required on freeways unless otherwise noted in the plans.
- A TMA should be used anytime that it can be positioned 30 to 100 feet in advance of the area of crew exposure without adversely affecting the work performance.
- The only reason a TMA should not be required is when a work area is spread down the roadway and the work crew is an extended distance from the TMA.



**BARRICADE AND CONSTRUCTION ARROW PANEL, REFLECTORS, WARNING LIGHTS & ATTENUATOR**

**BC (7) -21**

FILE:	bc-21.dgn	DN:	TxDOT	CR:	TxDOT	DW:	TxDOT	CK:	TxDOT
© TxDOT	November 2002	CONT	SECT	JOB	HIGHWAY				
REVISIONS		0092	14	104	IH 45				
9-07	8-14	DIST	COUNTY	SHEET NO.					
7-13	5-21	18	DALLAS	17					

DISCLAIMER: The use of this standard is governed by the "Texas Engineering Practice Act". No warranty of any kind is made by TxDOT for any purpose whatsoever. TxDOT assumes no responsibility for the conversion of this standard to other formats or for incorrect results or damages resulting from its use.

DATE: 2023/03/15 2:57:50 PM  
 FILE: DOCUMENT NAME\line.txdot5\so\lomon\_bayou\0852788\_bc-21.dgn

**GENERAL NOTES**

- For long term stationary work zones on freeways, drums shall be used as the primary channelizing device.
- For intermediate term stationary work zones on freeways, drums should be used as the primary channelizing device but may be replaced in tangent sections by vertical panels, or 42" two-piece cones. In tangent sections, one-piece cones may be used with the approval of the Engineer but only if personnel are present on the project at all times to maintain the cones in proper position and location.
- For short term stationary work zones on freeways, drums are the preferred channelizing device but may be replaced in tapers, transitions and tangent sections by vertical panels, two-piece cones or one-piece cones as approved by the Engineer.
- Drums and all related items shall comply with the requirements of the current version of the "Texas Manual on Uniform Traffic Control Devices" (TMUTCD) and the "Compliant Work Zone Traffic Control Devices List" (CWZTCD).
- Drums, bases, and related materials shall exhibit good workmanship and shall be free from objectionable marks or defects that would adversely affect their appearance or serviceability.
- The Contractor shall have a maximum of 24 hours to replace any plastic drums identified for replacement by the Engineer/Inspector. The replacement device must be an approved device.

**GENERAL DESIGN REQUIREMENTS**

Pre-qualified plastic drums shall meet the following requirements:



- Plastic drums shall be a two-piece design; the "body" of the drum shall be the top portion and the "base" shall be the bottom.
- The body and base shall lock together in such a manner that the body separates from the base when impacted by a vehicle traveling at a speed of 20 MPH or greater but prevents accidental separation due to normal handling and/or air turbulence created by passing vehicles.
- Plastic drums shall be constructed of lightweight flexible, and deformable materials. The Contractor shall NOT use metal drums or single piece plastic drums as channelization devices or sign supports.
- Drums shall present a profile that is a minimum of 18 inches in width at the 36 inch height when viewed from any direction. The height of drum unit (body installed on base) shall be a minimum of 36 inches and a maximum of 42 inches.
- The top of the drum shall have a built-in handle for easy pickup and shall be designed to drain water and not collect debris. The handle shall have a minimum of two widely spaced 9/16 inch diameter holes to allow attachment of a warning light, warning reflector unit or approved compliant sign.
- The exterior of the drum body shall have a minimum of four alternating orange and white retroreflective circumferential stripes not less than 4 inches nor greater than 8 inches in width. Any non-reflectorized space between any two adjacent stripes shall not exceed 2 inches in width.
- Bases shall have a maximum width of 36 inches, a maximum height of 4 inches, and a minimum of two footholds of sufficient size to allow base to be held down while separating the drum body from the base.
- Plastic drums shall be constructed of ultra-violet stabilized, orange, high-density polyethylene (HDPE) or other approved material.
- Drum body shall have a maximum unballasted weight of 11 lbs.
- Drum and base shall be marked with manufacturer's name and model number.

**RETROREFLECTIVE SHEETING**

- The stripes used on drums shall be constructed of sheeting meeting the color and retroreflectivity requirements of Departmental Materials Specification DMS-8300, "Sign Face Materials." Type A or Type B reflective sheeting shall be supplied unless otherwise specified in the plans.
- The sheeting shall be suitable for use on and shall adhere to the drum surface such that, upon vehicular impact, the sheeting shall remain adhered in-place and exhibit no delaminating, cracking, or loss of retroreflectivity other than that loss due to abrasion of the sheeting surface.



**BALLAST**

- Unballasted bases shall be large enough to hold up to 50 lbs. of sand. This base, when filled with the ballast material, should weigh between 35 lbs (minimum) and 50 lbs (maximum). The ballast may be sand in one to three sandbags separate from the base, sand in a sand-filled plastic base, or other ballasting devices as approved by the Engineer. Stacking of sandbags will be allowed, however height of sandbags above pavement surface may not exceed 12 inches.
- Bases with built-in ballast shall weigh between 40 lbs. and 50 lbs. Built-in ballast can be constructed of an integral crumb rubber base or a solid rubber base.
- Recycled truck tire sidewalls may be used for ballast on drums approved for this type of ballast on the CWZTCD list.
- The ballast shall not be heavy objects, water, or any material that would become hazardous to motorists, pedestrians, or workers when the drum is struck by a vehicle.
- When used in regions susceptible to freezing, drums shall have drainage holes in the bottoms so that water will not collect and freeze becoming a hazard when struck by a vehicle.
- Ballast shall not be placed on top of drums.
- Adhesives may be used to secure base of drums to pavement.

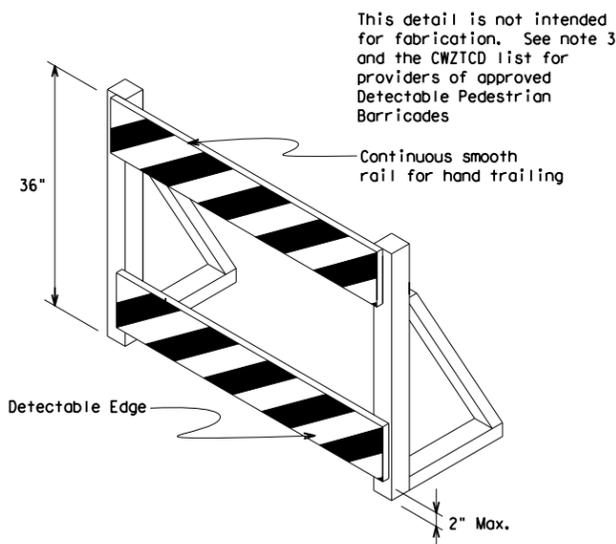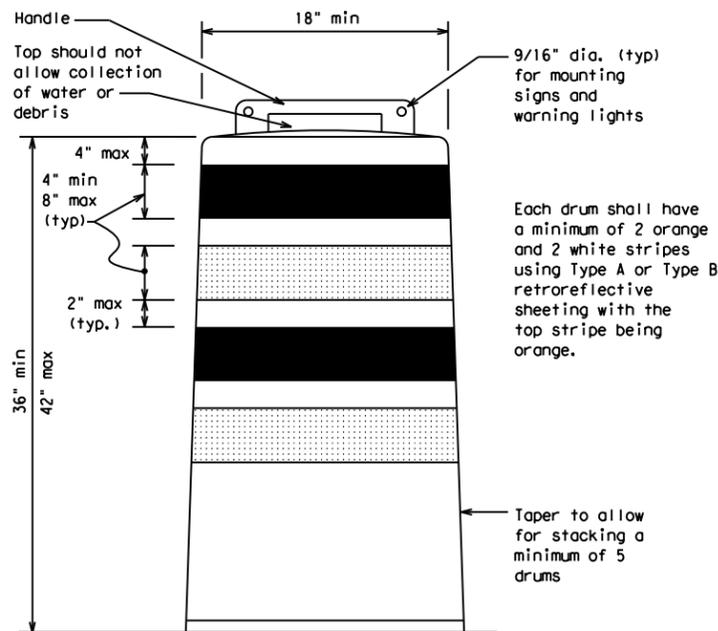


**DETECTABLE PEDESTRIAN BARRICADES**

- When existing pedestrian facilities are disrupted, closed, or relocated in a TTC zone, the temporary facilities shall be detectable and include accessibility features consistent with the features present in the existing pedestrian facility. Refer to WZ(BTS-2) for Pedestrian Control requirements for Sidewalk Diversions, Sidewalk Detours and Crosswalk Closures.
- Where pedestrians with visual disabilities normally use the closed sidewalk, a Detectable Pedestrian Barricade shall be placed across the full width of the closed sidewalk instead of a Type 3 Barricade.
- Detectable pedestrian barricades similar to the one pictured above, longitudinal channelizing devices, some concrete barriers, and wood or chain link fencing with a continuous detectable edging can satisfactorily delineate a pedestrian path.
- Tape, rope, or plastic chain strung between devices are not detectable, do not comply with the design standards in the "Americans with Disabilities Act Accessibility Guidelines (ADAAG)" and should not be used as a control for pedestrian movements.
- Warning lights shall not be attached to detectable pedestrian barricades.
- Detectable pedestrian barricades should use 8" nominal barricade rails as shown on BC(10) provided that the top rail provides a smooth continuous rail suitable for hand trailing with no splinters, burrs, or sharp edges.

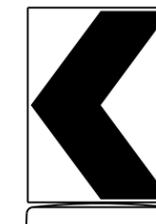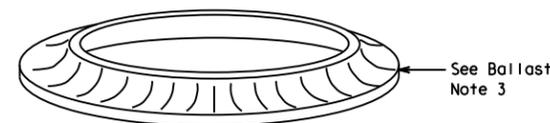

18" x 24" Sign  
(Maximum Sign Dimension)  
Chevron CW1-8, Opposing Traffic Lane  
Divider, Driveway sign D70a, Keep Right  
R4 series or other signs as approved  
by Engineer

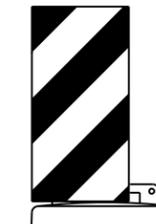

12" x 24"  
Vertical Panel  
mount with diagonals  
sloping down towards  
travel way

Plywood, Aluminum or Metal sign  
substrates shall NOT be used on  
plastic drums

**SIGNS, CHEVRONS, AND VERTICAL PANELS MOUNTED ON PLASTIC DRUMS**

- Signs used on plastic drums shall be manufactured using substrates listed on the CWZTCD.
- Chevrons and other work zone signs with an orange background shall be manufactured with Type B<sub>FL</sub> or Type C<sub>FL</sub> Orange sheeting meeting the color and retroreflectivity requirements of DMS-8300, "Sign Face Material," unless otherwise specified in the plans.
- Vertical Panels shall be manufactured with orange and white sheeting meeting the requirements of DMS-8300 Type A or Type B. Diagonal stripes on Vertical Panels shall slope down toward the intended traveled lane.
- Other sign messages (text or symbolic) may be used as approved by the Engineer. Sign dimensions shall not exceed 18 inches in width or 24 inches in height, except for the R9 series signs discussed in note 8 below.
- Signs shall be installed using a 1/2 inch bolt (nominal) and nut, two washers, and one locking washer for each connection.
- Mounting bolts and nuts shall be fully engaged and adequately torqued. Bolts should not extend more than 1/2 inch beyond nuts.
- Chevrons may be placed on drums on the outside of curves, on merging tapers or on shifting tapers. When used in these locations, they may be placed on every drum or spaced not more than on every third drum. A minimum of three (3) should be used at each location called for in the plans.
- R9-9, R9-10, R9-11 and R9-11a Sidewalk Closed signs which are 24 inches wide may be mounted on plastic drums, with approval of the Engineer.

SHEET 8 OF 12




**BARRICADE AND CONSTRUCTION CHANNELIZING DEVICES**

**BC (8) - 21**

FILE:	bc-21.dgn	DN:	TxDOT	CK:	TxDOT	DW:	TxDOT	CR:	TxDOT
© TxDOT	November 2002	CONT	SECT	JOB	HIGHWAY				
REVISIONS		0092	14	104	IH 45				
4-03	8-14	DIST	COUNTY	SHEET NO.					
9-07	5-21	18	DALLAS	18					
7-13									


DISCLAIMER: The use of this standard is governed by the "Texas Engineering Practice Act". No warranty of any kind is made by TxDOT for any purpose whatsoever. TxDOT assumes no responsibility for the conversion of this standard to other formats or for incorrect results or damages resulting from its use.

DATE: 2023/03/15 2:57:53 PM  
 FILE: DOCUMENT\NAME\line\txdot5\solomon\_bayou\d0852788\bc-21.dgn

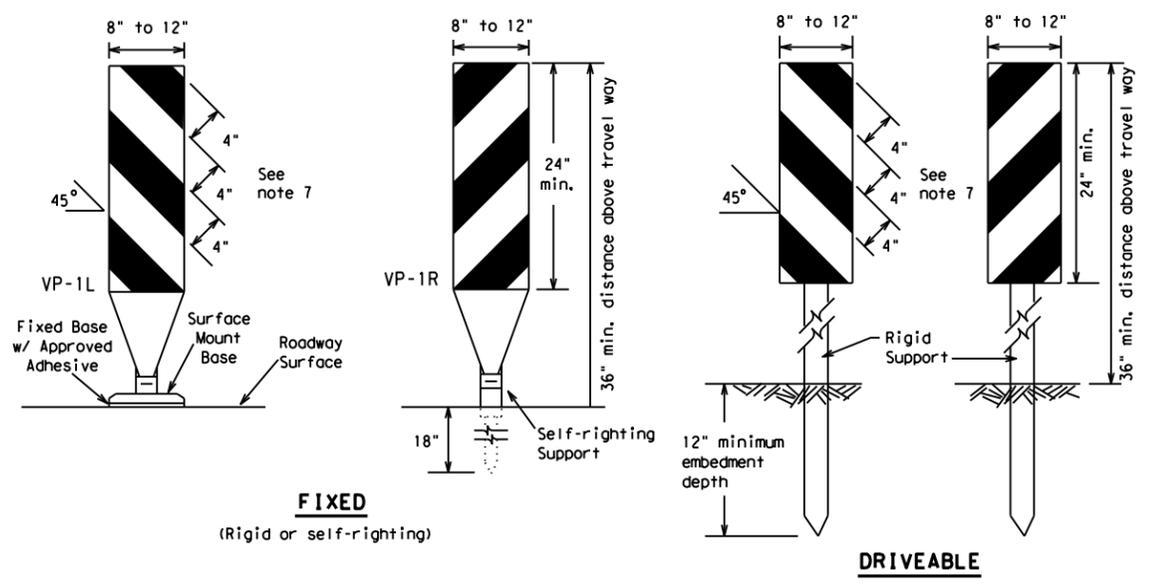

**FIXED**  
(Rigid or self-righting)


**DRIVEABLE**

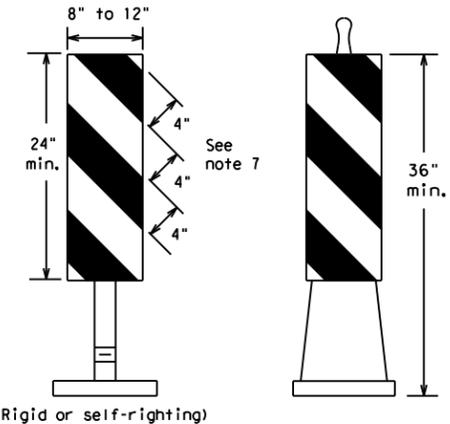

**PORTABLE**


**VERTICAL PANELS (VPs)**

- Vertical Panels (VP's) are normally used to channelize traffic or divide opposing lanes of traffic.
- VP's may be used in daytime or nighttime situations. They may be used at the edge of shoulder drop-offs and other areas such as lane transitions where positive daytime and nighttime delineation is required. The Engineer/Inspector shall refer to the Roadway Design Manual for additional requirements on the use VP's for drop-offs.
- VP's should be mounted back to back if used at the edge of cuts adjacent to two-way two lane roadways. Stripes are to be reflective orange and reflective white and should always slope downward toward the travel lane.
- VP's used on expressways and freeways or other high speed roadways, may have more than 270 square inches of retroreflective area facing traffic.
- Self-righting supports are available with portable base. See "Compliant Work Zone Traffic Control Devices List" (CWZTCD).
- Sheeting for the VP's shall be retroreflective Type A or Type B conforming to Departmental Material Specification DMS-8300, unless noted otherwise.
- Where the height of reflective material on the vertical panel is 36 inches or greater, a panel stripe of 6 inches shall be used.

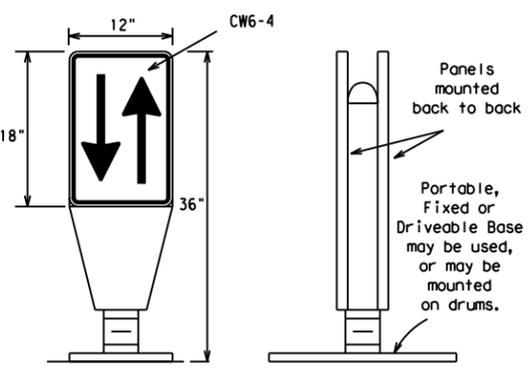

**OPPOSING TRAFFIC LANE DIVIDERS (OTLD)**


- Opposing Traffic Lane Dividers (OTLD) are delineation devices designed to convert a normal one-way roadway section to two-way operation. OTLD's are used on temporary centerlines. The upward and downward arrows on the sign's face indicate the direction of traffic on either side of the divider. The base is secured to the pavement with an adhesive or rubber weight to minimize movement caused by a vehicle impact or wind gust.
- The OTLD may be used in combination with 42" cones or VPs.
- Spacing between the OTLD shall not exceed 500 feet. 42" cones or VPs placed between the OTLD's should not exceed 100 foot spacing.
- The OTLD shall be orange with a black non-reflective legend. Sheeting for the OTLD shall be retroreflective Type B<sub>FL</sub> or Type C<sub>FL</sub> conforming to Departmental Material Specification DMS-8300, unless noted otherwise. The legend shall meet the requirements of DMS-8300.

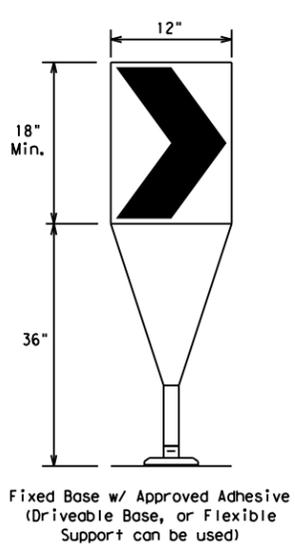

Fixed Base w/ Approved Adhesive (Driveable Base, or Flexible Support can be used)

- The chevron shall be a vertical rectangle with a minimum size of 12 by 18 inches.
- Chevrons are intended to give notice of a sharp change of alignment with the direction of travel and provide additional emphasis and guidance for vehicle operators with regard to changes in horizontal alignment of the roadway.
- Chevrons, when used, shall be erected on the outside of a sharp curve or turn, or on the far side of an intersection. They shall be in line with and at right angles to approaching traffic. Spacing should be such that the motorist always has three in view, until the change in alignment eliminates its need.
- To be effective, the chevron should be visible for at least 500 feet.
- Chevrons shall be orange with a black nonreflective legend. Sheeting for the chevron shall be retroreflective Type B<sub>FL</sub> or Type C<sub>FL</sub> conforming to Departmental Material Specification DMS-8300, unless noted otherwise. The legend shall meet the requirements of DMS-8300.
- For Long Term Stationary use on tapers or transitions on freeways and divided highways, self-righting chevrons may be used to supplement plastic drums but not to replace plastic drums.

**CHEVRONS**

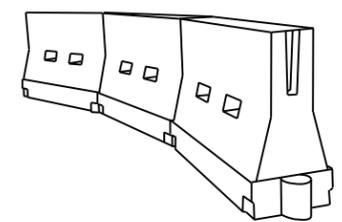

**LONGITUDINAL CHANNELIZING DEVICES (LCD)**

- LCDs are crashworthy, lightweight, deformable devices that are highly visible, have good target value and can be connected together. They are not designed to contain or redirect a vehicle on impact.
- LCDs may be used instead of a line of cones or drums.
- LCDs shall be placed in accordance to application and installation requirements specific to the device, and used only when shown on the CWZTCD list.
- LCDs should not be used to provide positive protection for obstacles, pedestrians or workers.
- LCDs shall be supplemented with retroreflective delineation as required for temporary barriers on BC(7) when placed roughly parallel to the travel lanes.
- LCDs used as barricades placed perpendicular to traffic should have at least one row of reflective sheeting meeting the requirements for barricade rails as shown on BC(10). Place reflective sheeting near the top of the LCD along the full length of the device.

**WATER BALLASTED SYSTEMS USED AS BARRIERS**

- Water ballasted systems used as barriers shall not be used solely to channelize road users, but also to protect the work space per the appropriate Manual for Assessing Safety Hardware (MASH) crashworthiness requirements based on roadway speed and barrier application.
- Water ballasted systems used to channelize vehicular traffic shall be supplemented with retroreflective delineation or channelizing devices to improve daytime/nighttime visibility. They may also be supplemented with pavement markings.
- Water ballasted systems used as barriers shall be placed in accordance to application and installation requirements specific to the device, and used only when shown on the CWZTCD list.
- Water ballasted systems used as barriers should not be used for a merging taper except in low speed (less than 45 MPH) urban areas. When used on a taper in a low speed urban area, the taper shall be delineated and the taper length should be designed to optimize road user operations considering the available geometric conditions.
- When water ballasted systems used as barriers have blunt ends exposed to traffic, they should be attenuated as per manufacturer recommendations or flared to a point outside the clear zone.

If used to channelize pedestrians, longitudinal channelizing devices or water ballasted systems must have a continuous detectable bottom for users of long canes and the top of the unit shall not be less than 32 inches in height.

**HOLLOW OR WATER BALLASTED SYSTEMS USED AS LONGITUDINAL CHANNELIZING DEVICES OR BARRIERS**

**GENERAL NOTES**

- Work Zone channelizing devices illustrated on this sheet may be installed in close proximity to traffic and are suitable for use on high or low speed roadways. The Engineer/Inspector shall ensure that spacing and placement is uniform and in accordance with the "Texas Manual on Uniform Traffic Control Devices" (TMUTCD).
- Channelizing devices shown on this sheet may have a driveable, fixed or portable base. The requirement for self-righting channelizing devices must be specified in the General Notes or other plan sheets.
- Channelizing devices on self-righting supports should be used in work zone areas where channelizing devices are frequently impacted by errant vehicles or vehicle related wind gusts making alignment of the channelizing devices difficult to maintain. Locations of these devices shall be detailed elsewhere in the plans. These devices shall conform to the TMUTCD and the "Compliant Work Zone Traffic Control Devices List" (CWZTCD).
- The Contractor shall maintain devices in a clean condition and replace damaged, nonreflective, faded, or broken devices and bases as required by the Engineer/Inspector. The Contractor shall be required to maintain proper device spacing and alignment.
- Portable bases shall be fabricated from virgin and/or recycled rubber. The portable bases shall weigh a minimum of 30 lbs.
- Pavement surfaces shall be prepared in a manner that ensures proper bonding between the adhesives, the fixed mount bases and the pavement surface. Adhesives shall be prepared and applied according to the manufacturer's recommendations.
- The installation and removal of channelizing devices shall not cause detrimental effects to the final pavement surfaces, including pavement surface discoloration or surface integrity. Driveable bases shall not be permitted on final pavement surfaces. The Engineer/Inspector shall approve all application and removal procedures of fixed bases.

Posted Speed	Formula	Minimum Desirable Taper Lengths * *			Suggested Maximum Spacing of Channelizing Devices	
		10' Offset	11' Offset	12' Offset	On a Taper	On a Tangent
30	L = WS <sup>2</sup> / 60	150'	165'	180'	30'	60'
35		205'	225'	245'	35'	70'
40		265'	295'	320'	40'	80'
45	L = WS	450'	495'	540'	45'	90'
50		500'	550'	600'	50'	100'
55		550'	605'	660'	55'	110'
60		600'	660'	720'	60'	120'
65		650'	715'	780'	65'	130'
70		700'	770'	840'	70'	140'
75		750'	825'	900'	75'	150'
80		800'	880'	960'	80'	160'

\* \* \* Taper lengths have been rounded off.  
 L=Length of Taper (FT.) W=Width of Offset (FT.)  
 S=Posted Speed (MPH)

**SUGGESTED MAXIMUM SPACING OF CHANNELIZING DEVICES AND MINIMUM DESIRABLE TAPER LENGTHS**

SHEET 9 OF 12



**BARRICADE AND CONSTRUCTION CHANNELIZING DEVICES**

**BC (9) - 21**

FILE: bc-21.dgn	DN: TxDOT	CK: TxDOT	DW: TxDOT	CR: TxDOT
© TxDOT November 2002	CONT	SECT	JOB	HIGHWAY
REVISIONS	0092	14	104	IH 45
9-07 8-14	DIST	COUNTY	SHEET NO.	
7-13 5-21	18	DALLAS	19	



## WORK ZONE PAVEMENT MARKINGS

### GENERAL

- The Contractor shall be responsible for maintaining work zone and existing pavement markings, in accordance with the standard specifications and special provisions, on all roadways open to traffic within the CSJ limits unless otherwise stated in the plans.
- Color, patterns and dimensions shall be in conformance with the "Texas Manual on Uniform Traffic Control Devices" (TMUTCD).
- Additional supplemental pavement marking details may be found in the plans or specifications.
- Pavement markings shall be installed in accordance with the TMUTCD and as shown on the plans.
- When short term markings are required on the plans, short term markings shall conform with the TMUTCD, the plans and details as shown on the Standard Plan Sheet WZ(STPM).
- When standard pavement markings are not in place and the roadway is opened to traffic, DO NOT PASS signs shall be erected to mark the beginning of the sections where passing is prohibited and PASS WITH CARE signs at the beginning of sections where passing is permitted.
- All work zone pavement markings shall be installed in accordance with Item 662, "Work Zone Pavement Markings."

### RAISED PAVEMENT MARKERS

- Raised pavement markers are to be placed according to the patterns on BC(12).
- All raised pavement markers used for work zone markings shall meet the requirements of Item 672, "RAISED PAVEMENT MARKERS" and Departmental Material Specification DMS-4200 or DMS-4300.

### PREFABRICATED PAVEMENT MARKINGS

- Removable prefabricated pavement markings shall meet the requirements of DMS-8241.
- Non-removable prefabricated pavement markings (foil back) shall meet the requirements of DMS-8240.


### MAINTAINING WORK ZONE PAVEMENT MARKINGS

- The Contractor will be responsible for maintaining work zone pavement markings within the work limits.
- Work zone pavement markings shall be inspected in accordance with the frequency and reporting requirements of work zone traffic control device inspections as required by Form 599.
- The markings should provide a visible reference for a minimum distance of 300 feet during normal daylight hours and 160 feet when illuminated by automobile low-beam headlights at night, unless sight distance is restricted by roadway geometrics.
- Markings failing to meet this criteria within the first 30 days after placement shall be replaced at the expense of the Contractor as per Specification Item 662.

### REMOVAL OF PAVEMENT MARKINGS

- Pavement markings that are no longer applicable, could create confusion or direct a motorist toward or into the closed portion of the roadway shall be removed or obliterated before the roadway is opened to traffic.
- The above shall not apply to detours in place for less than three days, where flaggers and/or sufficient channelizing devices are used in lieu of markings to outline the detour route.
- Pavement markings shall be removed to the fullest extent possible, so as not to leave a discernable marking. This shall be by any method approved by TxDOT Specification Item 677 for "Eliminating Existing Pavement Markings and Markers".
- The removal of pavement markings may require resurfacing or seal coating portions of the roadway as described in Item 677.
- Subject to the approval of the Engineer, any method that proves to be successful on a particular type pavement may be used.
- Blast cleaning may be used but will not be required unless specifically shown in the plans.
- Over-painting of the markings SHALL NOT BE permitted.
- Removal of raised pavement markers shall be as directed by the Engineer.
- Removal of existing pavement markings and markers will be paid for directly in accordance with Item 677, "ELIMINATING EXISTING PAVEMENT MARKINGS AND MARKERS," unless otherwise stated in the plans.
- Black-out marking tape may be used to cover conflicting existing markings for periods less than two weeks when approved by the Engineer.

## Temporary Flexible-Reflective Roadway Marker Tabs

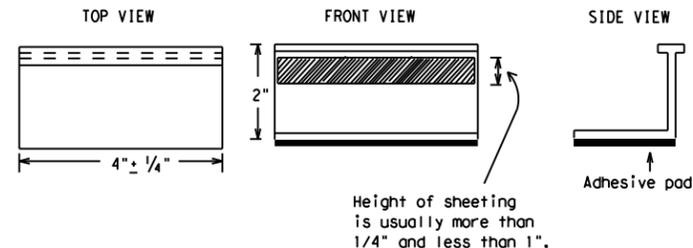

**STAPLES OR NAILS SHALL NOT BE USED TO SECURE  
TEMPORARY FLEXIBLE-REFLECTIVE ROADWAY MARKER  
TABS TO THE PAVEMENT SURFACE**

- Temporary flexible-reflective roadway marker tabs used as guidemarks shall meet the requirements of DMS-8242.
- Tabs detailed on this sheet are to be inspected and accepted by the Engineer or designated representative. Sampling and testing is not normally required, however at the option of the Engineer, either "A" or "B" below may be imposed to assure quality before placement on the roadway.
  - Select five (5) or more tabs at random from each lot or shipment and submit to the Construction Division, Materials and Pavement Section to determine specification compliance.
  - Select five (5) tabs and perform the following test. Affix five (5) tabs at 24 inch intervals on an asphaltic pavement in a straight line. Using a medium size passenger vehicle or pickup, run over the markers with the front and rear tires at a speed of 35 to 40 miles per hour, four (4) times in each direction. No more than one (1) out of the five (5) reflective surfaces shall be lost or displaced as a result of this test.
- Small design variances may be noted between tab manufacturers.
- See Standard Sheet WZ(STPM) for tab placement on new pavements. See Standard Sheet TCP(7-1) for tab placement on seal coat work.

### RAISED PAVEMENT MARKERS USED AS GUIDEMARKS

- Raised pavement markers used as guidemarks shall be from the approved product list, and meet the requirements of DMS-4200.
- All temporary construction raised pavement markers provided on a project shall be of the same manufacturer.
- Adhesive for guidemarks shall be bituminous material hot applied or butyl rubber pad for all surfaces, or thermoplastic for concrete surfaces.

Guidemarks shall be designated as:  
 YELLOW - (two amber reflective surfaces with yellow body).  
 WHITE - (one silver reflective surface with white body).

DEPARTMENTAL MATERIAL SPECIFICATIONS	
PAVEMENT MARKERS (REFLECTORIZED)	DMS-4200
TRAFFIC BUTTONS	DMS-4300
EPOXY AND ADHESIVES	DMS-6100
BITUMINOUS ADHESIVE FOR PAVEMENT MARKERS	DMS-6130
PERMANENT PREFABRICATED PAVEMENT MARKINGS	DMS-8240
TEMPORARY REMOVABLE, PREFABRICATED PAVEMENT MARKINGS	DMS-8241
TEMPORARY FLEXIBLE, REFLECTIVE ROADWAY MARKER TABS	DMS-8242

A list of prequalified reflective raised pavement markers, non-reflective traffic buttons, roadway marker tabs and other pavement markings can be found at the Material Producer List web address shown on BC(1).

SHEET 11 OF 12



## BARRICADE AND CONSTRUCTION PAVEMENT MARKINGS

 
**BC(11)-21**

FILE: bc-21.dgn	DN: TxDOT	CK: TxDOT	DW: TxDOT	CR: TxDOT
© TxDOT February 1998	CONT	SECT	JOB	HIGHWAY
REVISIONS	0092	14	104	IH 45
2-98 9-07 5-21	DIST	COUNTY	SHEET NO.	
1-02 7-13	18	DALLAS	21	
11-02 8-14				


DISCLAIMER: The use of this standard is governed by the "Texas Engineering Practice Act". No warranty of any kind is made by TxDOT for any purpose whatsoever. TxDOT assumes no responsibility for the conversion of this standard to other formats or for incorrect results or damages resulting from its use.

DATE: 2023/03/15 2:57:58 PM  
FILE: DOCUMENT\NAME\line\txdot5\solomon\_bayou\d0852788\_bc-21.dgn

## PAVEMENT MARKING PATTERNS




 REFLECTORIZED PAVEMENT MARKINGS - PATTERN A




REFLECTORIZED PAVEMENT MARKINGS - PATTERN B

 Pattern A is the TXDOT Standard, however Pattern B may be used if approved by the Engineer. Prefabricated markings may be substituted for reflectORIZED pavement markings.




RAISED PAVEMENT MARKERS - PATTERN A

 


RAISED PAVEMENT MARKERS - PATTERN B

## CENTER LINE & NO-PASSING ZONE BARRIER LINES FOR TWO-LANE, TWO-WAY HIGHWAYS

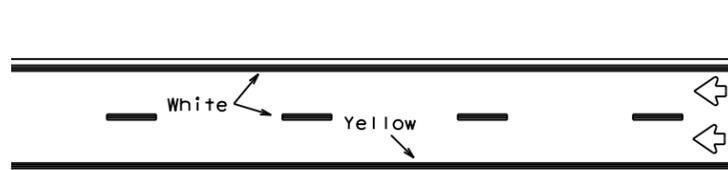

REFLECTORIZED PAVEMENT MARKINGS

Prefabricated markings may be substituted for reflectORIZED pavement markings.

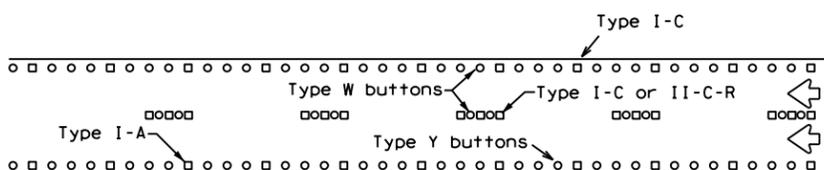


RAISED PAVEMENT MARKERS

## EDGE & LANE LINES FOR DIVIDED HIGHWAY




REFLECTORIZED PAVEMENT MARKINGS

Prefabricated markings may be substituted for reflectORIZED pavement markings.

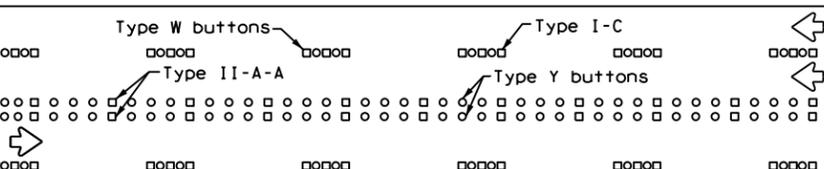


RAISED PAVEMENT MARKERS

## LANE & CENTER LINES FOR MULTILANE UNDIVIDED HIGHWAYS

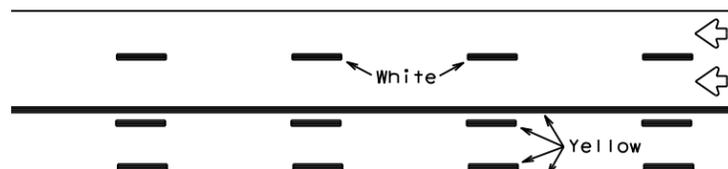

REFLECTORIZED PAVEMENT MARKINGS


Prefabricated markings may be substituted for reflectORIZED pavement markings.

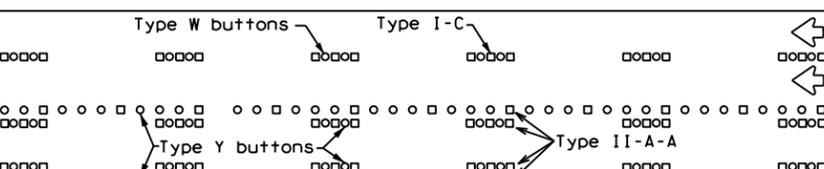



RAISED PAVEMENT MARKERS

## TWO-WAY LEFT TURN LANE


## STANDARD WORK ZONE PAVEMENT MARKINGS DETAILS

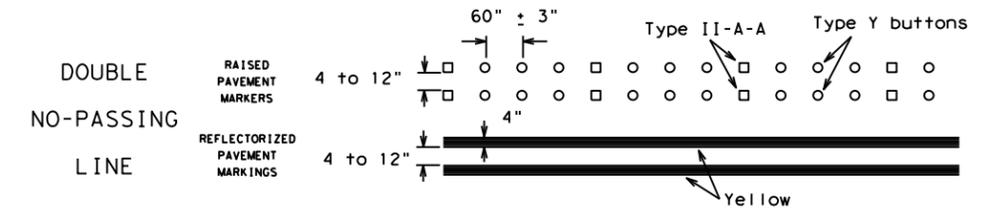


### SOLID LINES

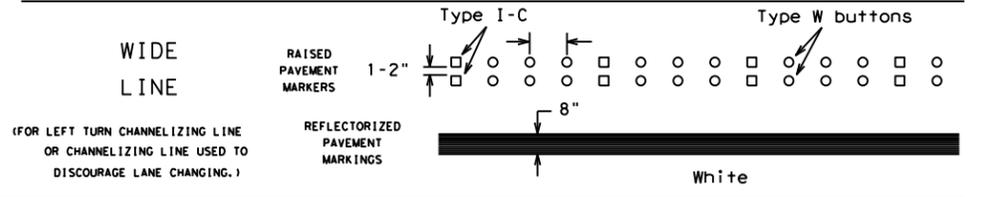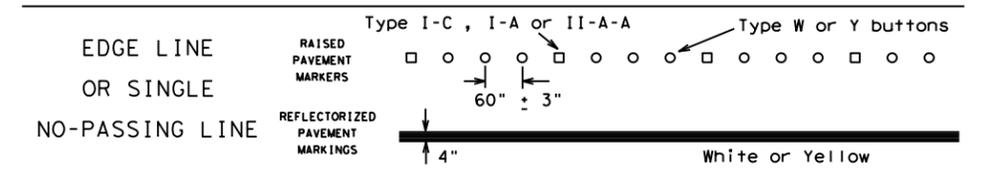

(FOR LEFT TURN CHANNELIZING LINE OR CHANNELIZING LINE USED TO DISCOURAGE LANE CHANGING.)

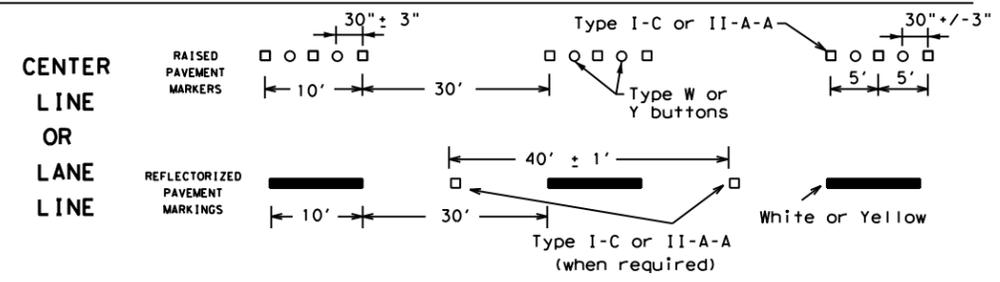


### BROKEN LINES

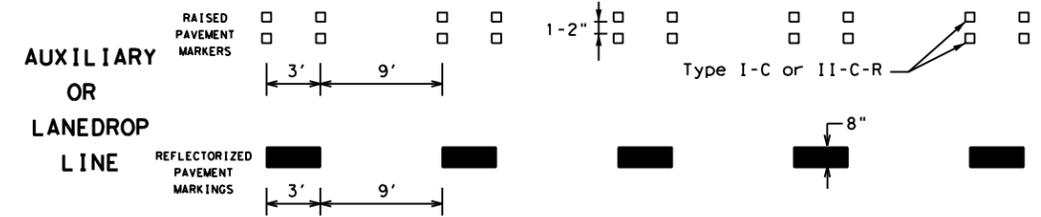

### REMOVABLE MARKINGS WITH RAISED PAVEMENT MARKERS

If raised pavement markers are used to supplement REMOVABLE markings, the markers shall be applied to the top of the tape at the approximate mid length of tape used for broken lines or at 20 foot spacing for solid lines. This allows an easier removal of raised pavement markers and tape.

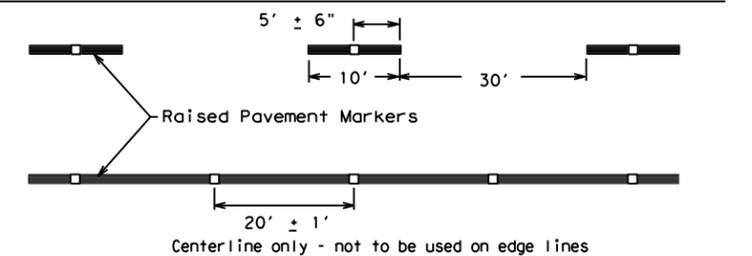

SHEET 12 OF 12



## BARRICADE AND CONSTRUCTION PAVEMENT MARKING PATTERNS

BC(12)-21

FILE: bc-21.dgn	DN: TxDOT	CK: TxDOT	OW: TxDOT	CR: TxDOT
©TxDOT February 1998	CONT	SECT	JOB	HIGHWAY
REVISIONS	0092	14	104	IH 45
1-97 9-07 5-21	DIST	COUNTY	SHEET NO.	
2-98 7-13	18	DALLAS	22	
11-02 8-14				


Raised pavement markers used as standard pavement markings shall be from the approved products list and meet the requirements of Item 672 "RAISED PAVEMENT MARKERS."

DISCLAIMER: The use of this standard is governed by the "Texas Engineering Practice Act". No warranty of any kind is made by TxDOT for any purpose whatsoever. TxDOT assumes no responsibility for the conversion of this standard to other formats or for incorrect results or damages resulting from its use.


DATE: 2023/03/15 2:58:01 PM  
FILE: DOCUMENT NAME\line\txdot5\solomon\_bayou\d0852788\_bc-21.dgn

DISCLAIMER: The use of this standard is governed by the "Texas Engineering Practice Act". No warranty of any kind is made by TxDOT for any purpose whatsoever. TxDOT assumes no responsibility for the conversion of this standard to other formats or for incorrect results or damages resulting from its use.

DATE: 5/17/2023 9:32:23 AM  
 FILE: c:\txdot\pw\_online\txdot5\solomon\_bayou\d0852788\tcp5-1-18.dgn

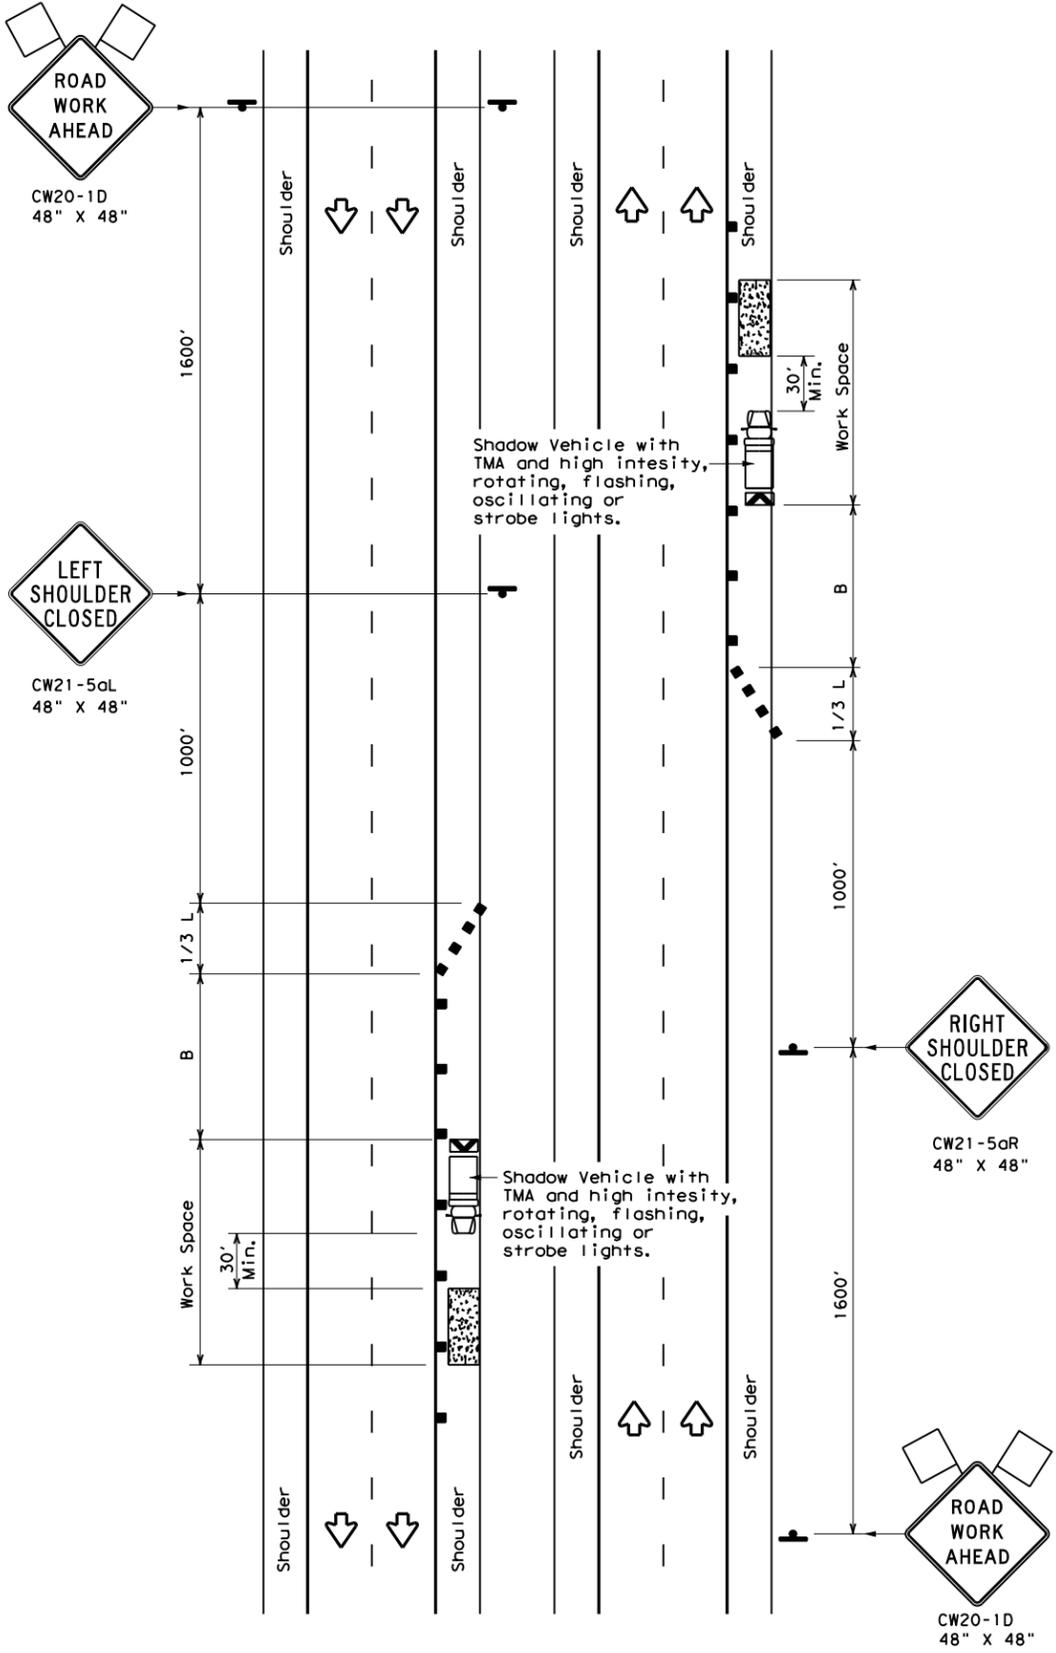

TCP (5-1a)  
**WORK AREA ON SHOULDER**

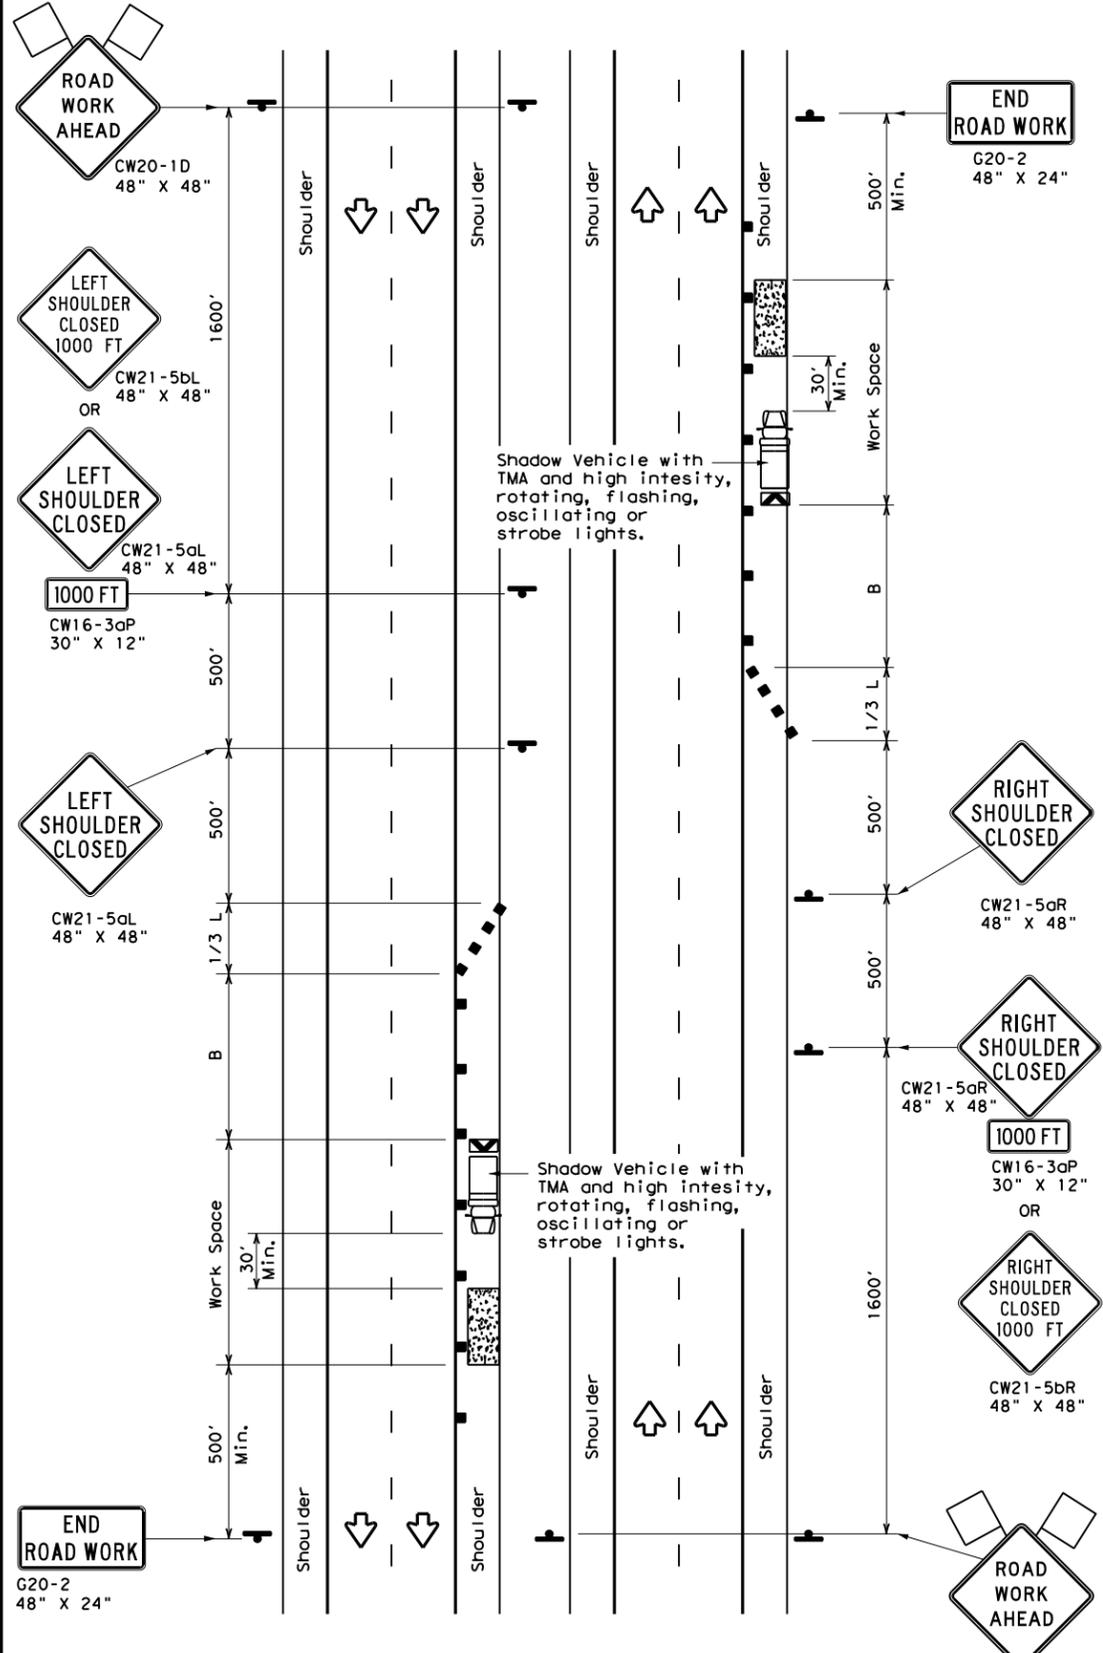

TCP (5-1b)  
**WORK AREA ON SHOULDER**

LEGEND			
	Type 3 Barricade		Channelizing Devices
	Heavy Work Vehicle		Truck Mounted Attenuator (TMA)
	Trailer Mounted Flashing Arrow Board		Portable Changeable Message Sign (PCMS)
	Sign		Traffic Flow
	Flag		Flagger

Posted Speed *	Formula	Minimum Desirable Taper Lengths **			Suggested Maximum Spacing of Channelizing Devices		Suggested Longitudinal Buffer Space "B"
		10' Offset	11' Offset	12' Offset	On a Taper	On a Tangent	
30	L = WS <sup>2</sup> / 60	150'	165'	180'	30'	60'	90'
35		205'	225'	245'	35'	70'	120'
40		265'	295'	320'	40'	80'	155'
45	L = WS	450'	495'	540'	45'	90'	195'
50		500'	550'	600'	50'	100'	240'
55		550'	605'	660'	55'	110'	295'
60		600'	660'	720'	60'	120'	350'
65		650'	715'	780'	65'	130'	410'
70		700'	770'	840'	70'	140'	475'
75		750'	825'	900'	75'	150'	540'
80		800'	880'	960'	80'	160'	615'

\* Conventional Roads Only  
 \*\* Taper lengths have been rounded off.  
 L=Length of Taper (FT) W=Width of Offset (FT) S=Posted Speed (MPH)

TYPICAL USAGE				
MOBILE	SHORT DURATION	SHORT TERM STATIONARY	INTERMEDIATE TERM STATIONARY	LONG TERM STATIONARY
	TCP (5-1a)	TCP (5-1b)	TCP (5-1b)	

- GENERAL NOTES**
1. A Shadow Vehicle with a TMA should be used anytime it can be positioned 30' to 100' in advance of the area of crew exposure without adversely affecting the performance or quality of the work. Type 3 barricades or drums may be substituted when workers on foot are no longer present when approved by the Engineer.
  2. 28" tall or taller one-piece cones will be allowed only for Short Duration or Short Term stationary operations when workers are present to maintain the devices upright and in proper location. Intermediate Term stationary work areas should use Drums, Vertical Panels or 42" tall two-piece cones.




**TRAFFIC CONTROL PLAN  
 SHOULDER WORK FOR  
 FREEWAYS / EXPRESSWAYS**

**TCP (5-1) - 18**


FILE: tcp5-1-18.dgn	DN:	CK:	DW:	CK:
© TxDOT February 2012	CONT	SECT	JOB	HIGHWAY
REVISIONS	0092	14	104	IH 45
2-18	DIST	COUNTY	SHEET NO.	
	18	DALLAS	23	

DISCLAIMER: The use of this standard is governed by the "Texas Engineering Practice Act". No warranty of any kind is made by TxDOT for any purpose whatsoever. TxDOT assumes no responsibility for the conversion of this standard to other formats or for incorrect results or damages resulting from its use.

DATE: 5/8/2023 2:58:56 PM  
 FILE: c:\txdot\pw\_online\txdot5\solomon\_bayou\d0647166\tcp6-1.dgn

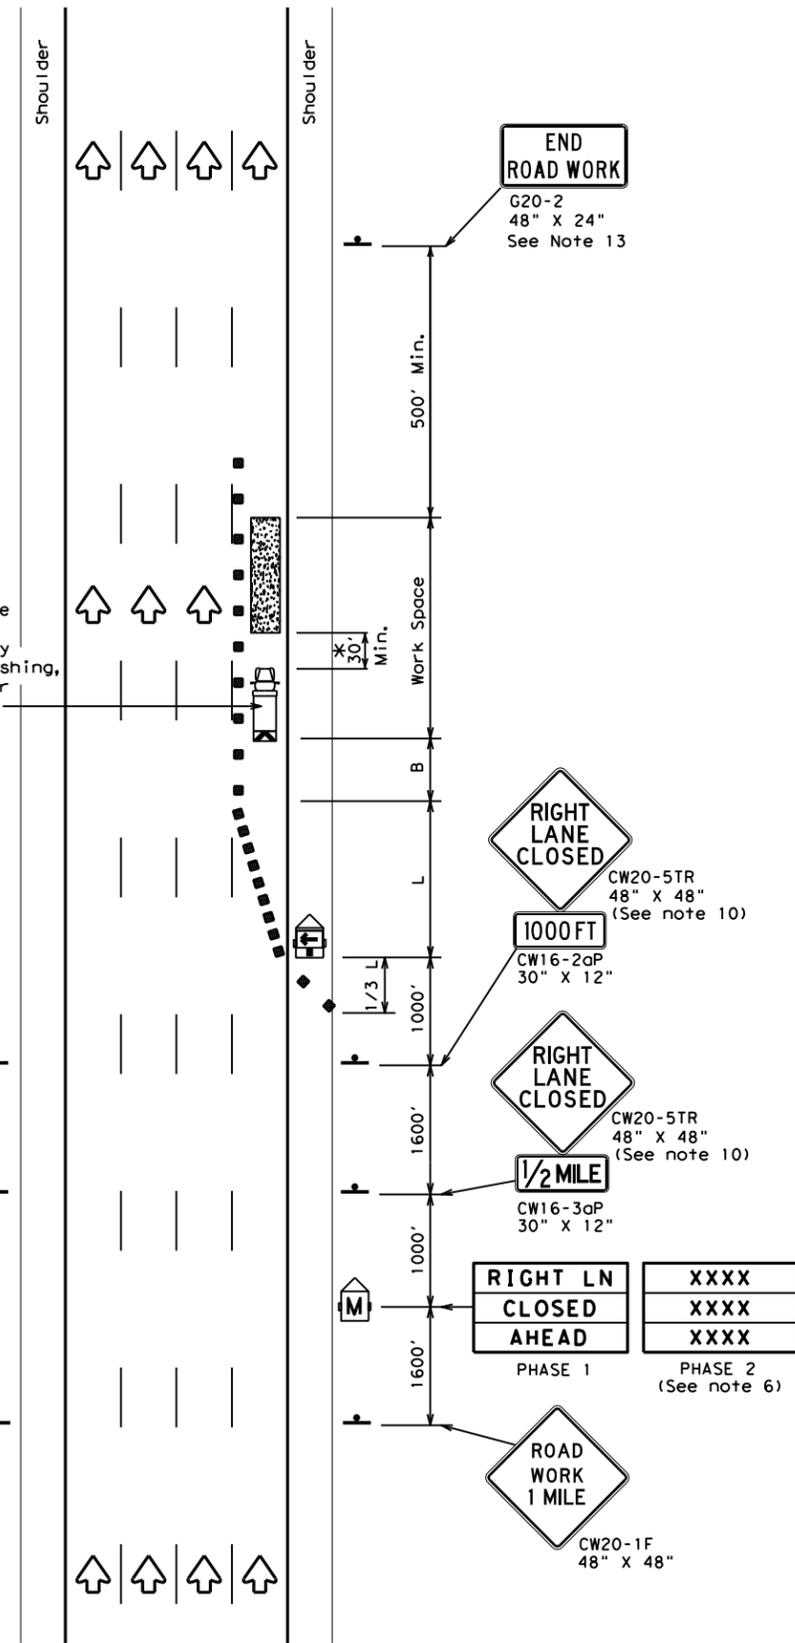

TCP (6-1a)  
**TYPICAL FREEWAY  
 ONE LANE CLOSURE**

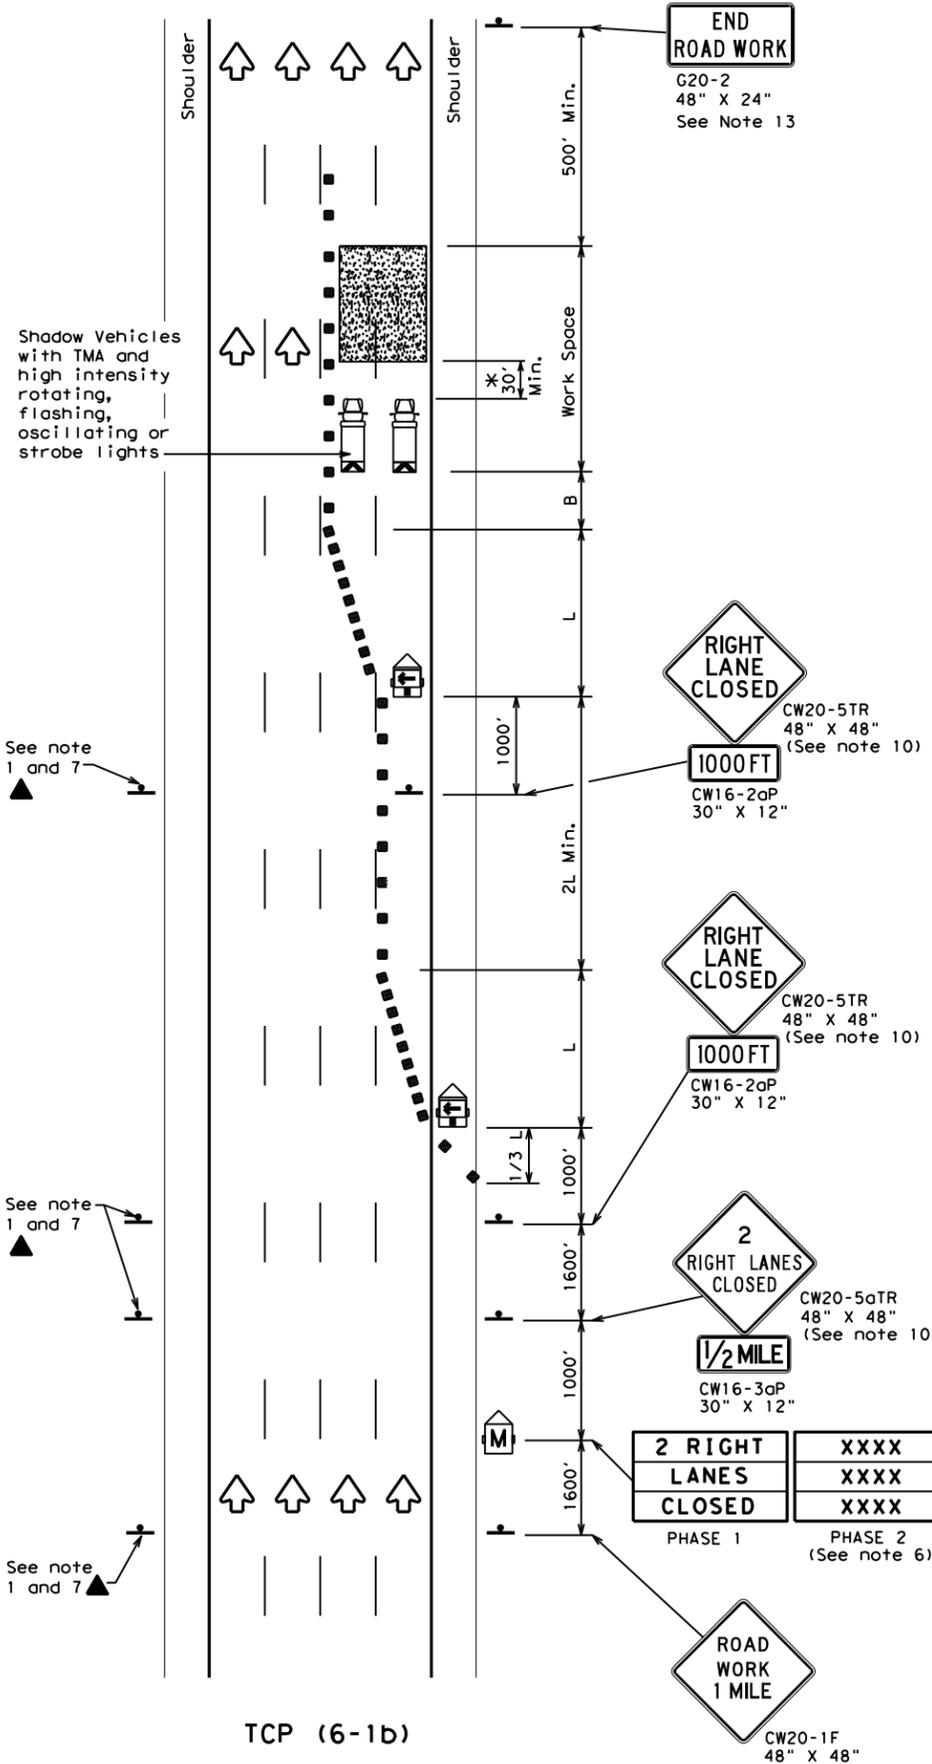

TCP (6-1b)  
**TYPICAL FREEWAY  
 TWO LANE CLOSURE**

LEGEND			
	Type 3 Barricade		Channelizing Devices
	Heavy Work Vehicle		Truck Mounted Attenuator (TMA)
	Trailer Mounted Flashing Arrow Board		Portable Changeable Message Sign (PCMS)
	Sign		Traffic Flow
	Flag		Flagger

Posted Speed	Formula	Minimum Desirable Taper Lengths "L"			Suggested Maximum Spacing of Channelizing Devices		Suggested Longitudinal Buffer Space "B"
		10' Offset	11' Offset	12' Offset	On a Taper	On a Tangent	
45	L = WS	450'	495'	540'	45'	90'	195'
50		500'	550'	600'	50'	100'	240'
55		550'	605'	660'	55'	110'	295'
60		600'	660'	720'	60'	120'	350'
65		650'	715'	780'	65'	130'	410'
70		700'	770'	840'	70'	140'	475'
75		750'	825'	900'	75'	150'	540'
80	800'	880'	960'	80'	160'	615'	

\*\* Taper lengths have been rounded off.  
 L=Length of Taper (FT) W=Width of Offset (FT) S=Posted Speed (MPH)

TYPICAL USAGE				
MOBILE	SHORT DURATION	SHORT TERM STATIONARY	INTERMEDIATE TERM STATIONARY	LONG TERM STATIONARY
	✓	✓	✓	

**GENERAL NOTES**

- All traffic control devices illustrated are REQUIRED. Devices denoted with the triangle symbol may be omitted when stated elsewhere in the plans.
- Drums or 42" cones are the typical channelizing devices. For Intermediate Term Stationary work, drums shall be used on tapers with drums or 42" cones used on tangent sections. Other channelizing devices may be used as directed by the Engineer.
- All construction signs and barricades placed during any phase of work shall remain in place until removal is approved by the Engineer.
- The Engineer may direct the Contractor to furnish additional signs and barricades as required to maintain traffic flow, detours and motorist safety during construction.
- Static message boards or changeable message signs stating the date and duration of ramp or freeway lane closures shall be placed a minimum of seven (7) calendar days in advance of the actual closure.
- Phase 2 of the PCMS message should include appropriate information formatted as shown on BC(6), such as "MERGE LEFT," recommended advisory speed, delay information, or other specific warnings.
- Duplicate construction warning signs should be erected on the medians side of freeways where median width will permit and traffic volume justifies the signing.
- The number of closed lanes may be increased provided the spacing of traffic control devices, taper lengths and tangent lengths meet the requirements of the TMUTCD.
- Warning signs for intermediate term stationary work should be mounted at 7' to the bottom of the sign.
- Warning signs shown shall be appropriately altered for left lane closures. When signs are mounted at 1' height for short term stationary or short duration work, sign versions shown in the SHSD for Texas with distances on the sign face rather than mounted on a plaque below the sign may be used.
- When possible, PCMS units should be located in advance of the last available exit ramp prior to the lane closure to allow motorists an alternate route. They may also be relocated to improve advance warning in case of unanticipated queuing or congestion.
- For Intermediate Term Stationary work at night, floodlights should be used to illuminate the work area and equipment crossings. Floodlights shall not produce a disabling glare condition for road users or workers.
- The END ROAD WORK (G20-2) sign may be omitted when it conflicts with G20-2 signs already in place on the project.

\* A shadow vehicle equipped with a Truck Mounted Attenuator is typically required. A shadow vehicle equipped with a TMA shall be used if it can be positioned 30' to 100' in advance of the area of crew exposure without adversely affecting the work performance.


Texas Department of Transportation  
 Traffic Operations Division Standard

**TRAFFIC CONTROL PLAN  
 FREEWAY LANE CLOSURES**

**TCP (6-1) - 12**

FILE:	tcp6-1.dgn	DN:	TxDOT	CK:	TxDOT	DW:	TxDOT	CK:	TxDOT
©TxDOT	February 1998	CONT	SECT	JOB	HIGHWAY				
8-12	REVISIONS	0092	14	104	IH 45				
	DIST	COUNTY	SHEET NO.						
	18	DALLAS	24						


DW: SB  
 CK: DN  
 DW: SB  
 CK: DN

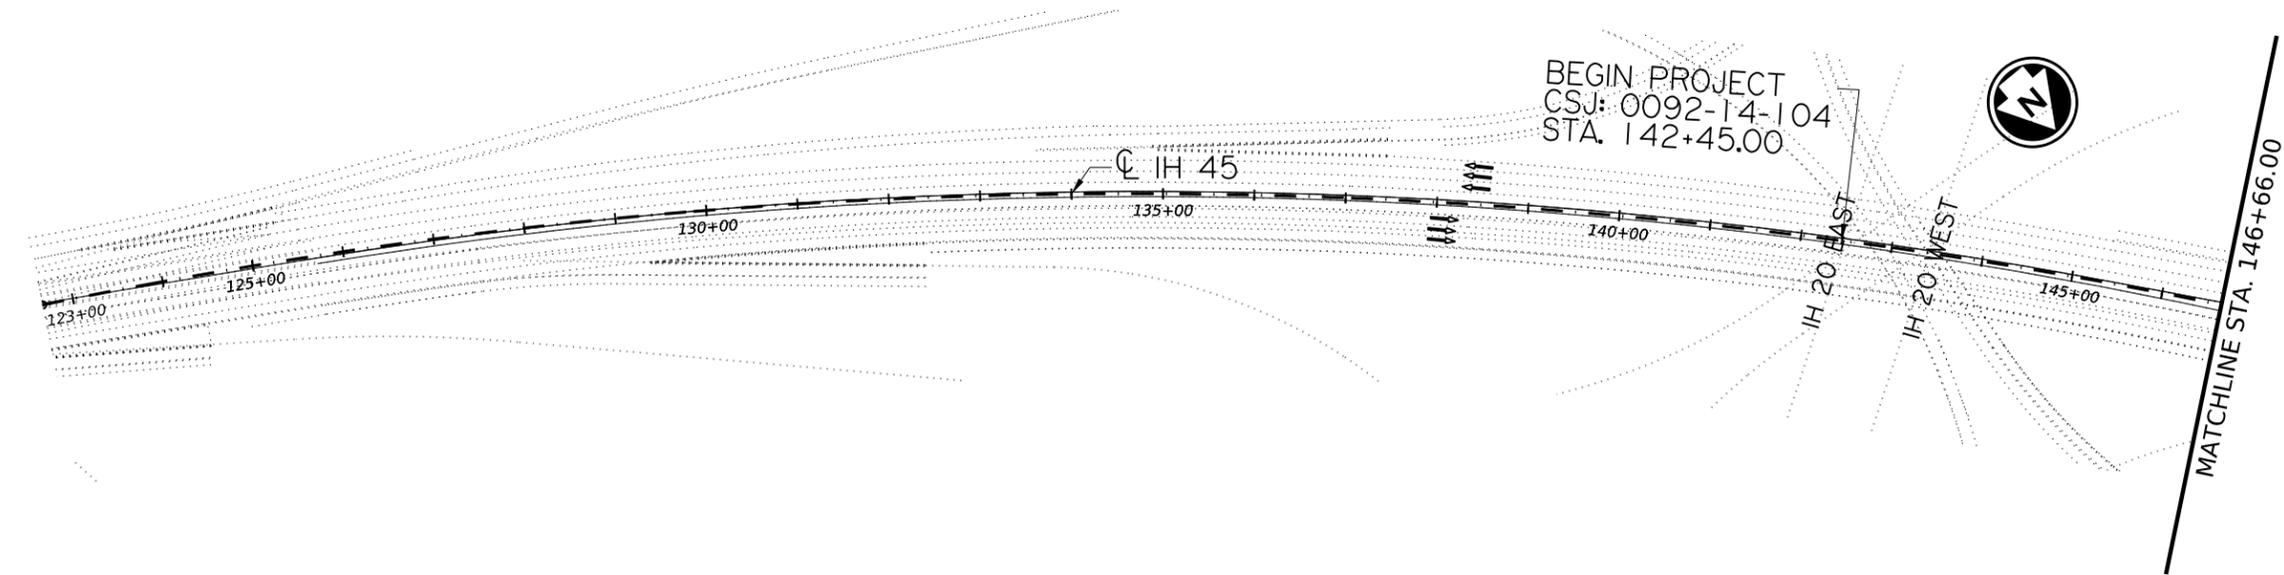

**LEGEND**

CONCRETE BARRIER  
 DIRECTION OF TRAFFIC

- NOTE:
- SEE TCP, WZ, BC STANDARDS, AND MUTCD FOR ADDITIONAL INFORMATION, DEVICES AND DEVICE PLACEMENT.
  - CONTRACTOR TO DETERMINE LOCATION OF UTILITIES TO AVOID IMPACTING.
  - ANCHOR DRILLED SHAFT FOUNDATION TO BE USED FOR SSCB BARRIER. SEE STANDARD SSCB(1F)-10 DRILLED SHAFT ANCHOR DETAILS FOR MORE INFORMATION.

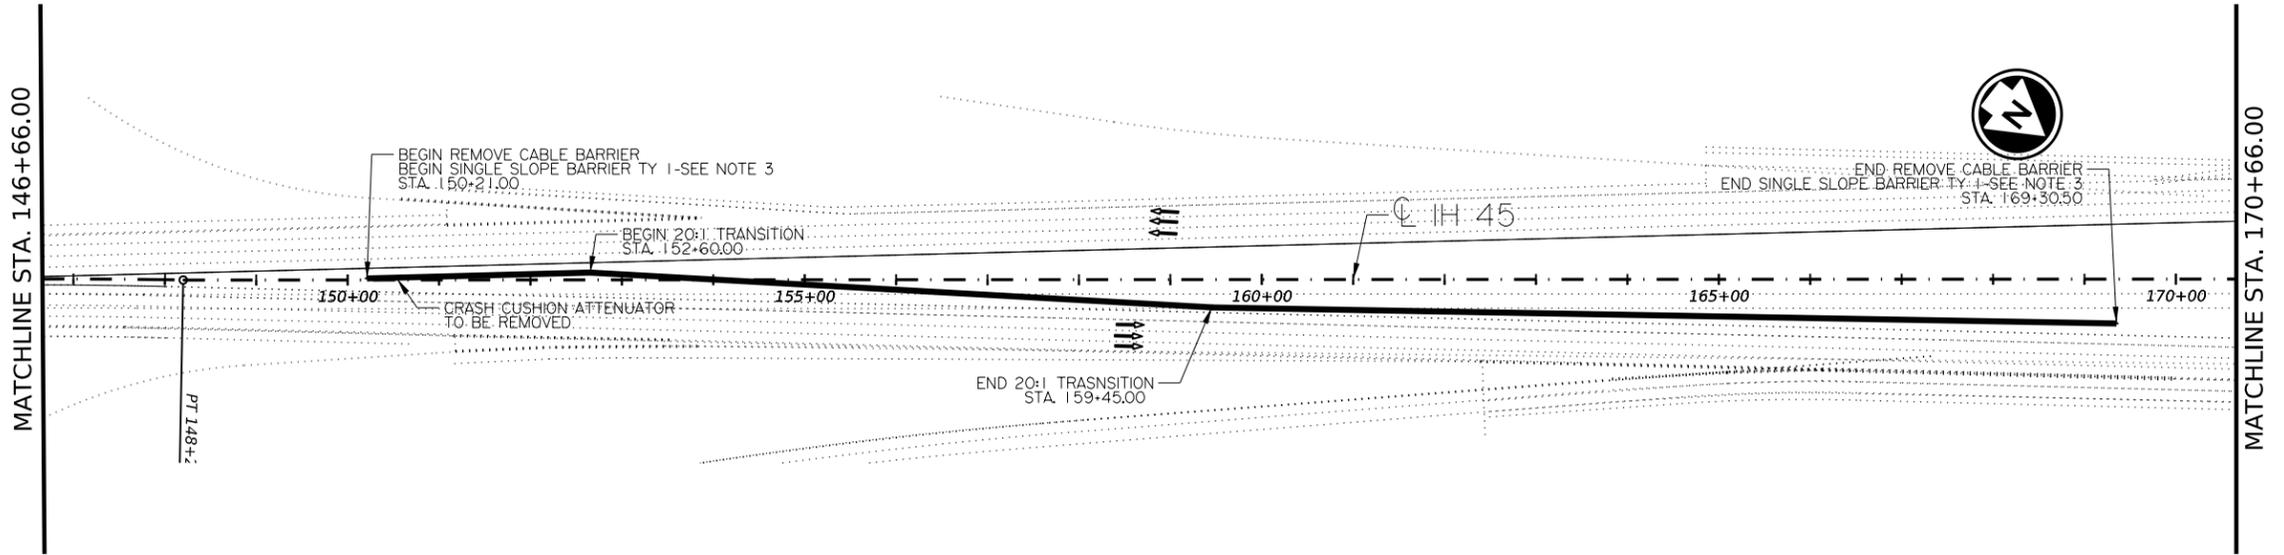

Solomon Bayou 5/26/2023  
 Signature of Registrant P.E. Date


**IH 45**  
 CTB  
 PLAN LAYOUT

SCALE: 1"=200' SHEET 1 OF 6

CONT	SECT	JOB	HIGHWAY
0092	14	104	IH 45
DIST	COUNTY	SHEET NO.	
18	DALLAS	25	

DATE: 6/6/2023 7:38:19 AM  
 FILE: c:\txdot\pw\_online\txdot\5\solomon.bayou\d0841982\SSCB PLAN LAYOUT CONTAINER FILE.dgn

DW:SB CK:DN DW:SB CK:DN

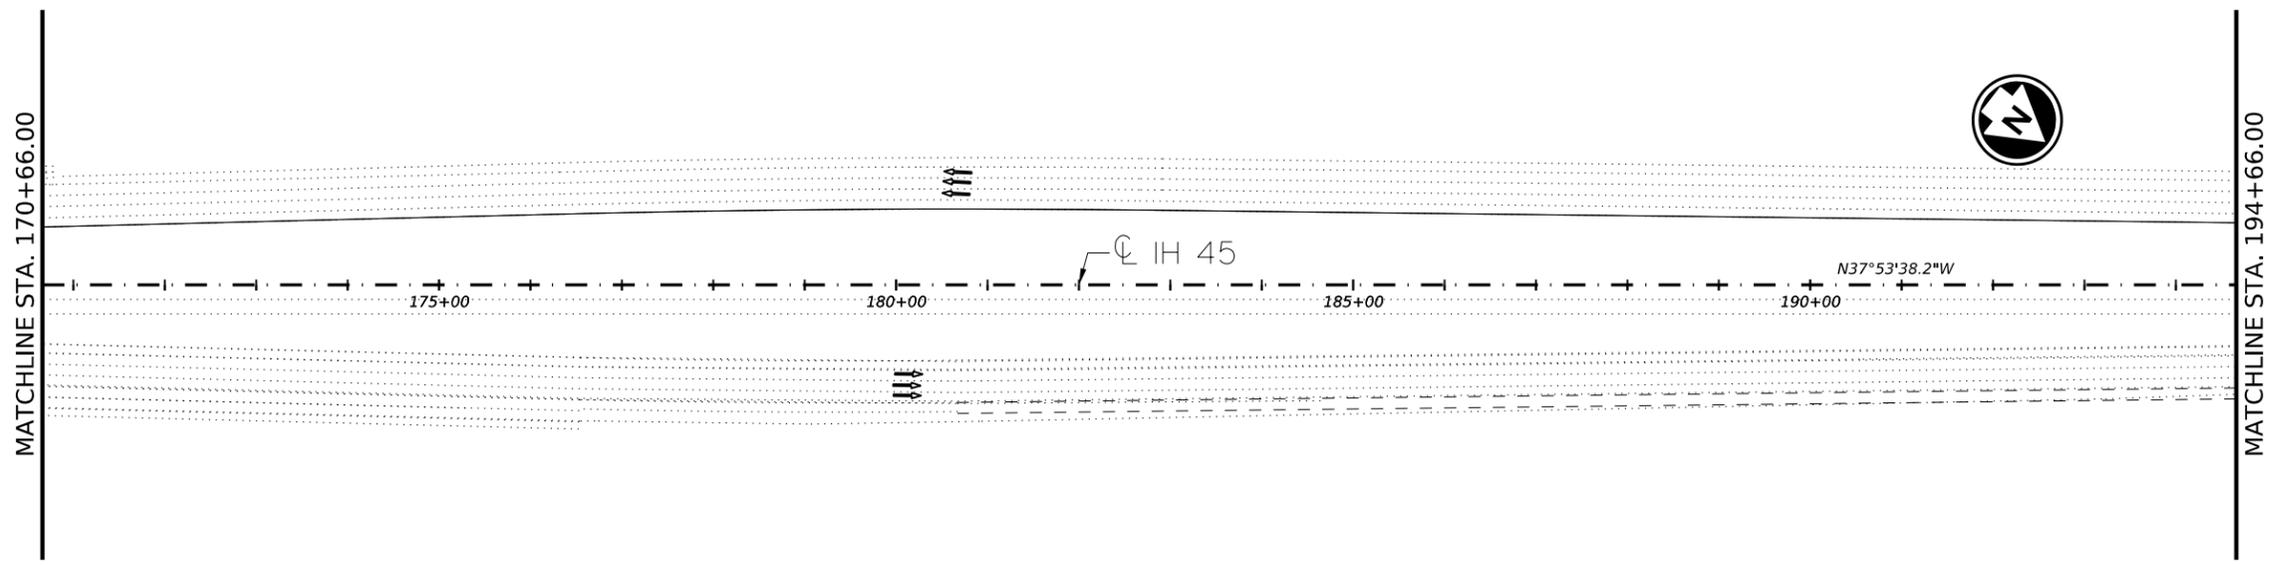


**LEGEND**

CONCRETE BARRIER

DIRECTION OF TRAFFIC

- NOTE:**
1. SEE TCP, WZ, BC STANDARDS, AND MUTCD FOR ADDITIONAL INFORMATION, DEVICES AND DEVICE PLACEMENT.
  2. CONTRACTOR TO DETERMINE LOCATION OF UTILITIES TO AVOID IMPACTING.
  3. ANCHOR DRILLED SHAFT FOUNDATION TO BE USED FOR SSCB BARRIER. SEE STANDARD SSCB (1F)-10 DRILLED SHAFT ANCHOR DETAILS FOR MORE INFORMATION.

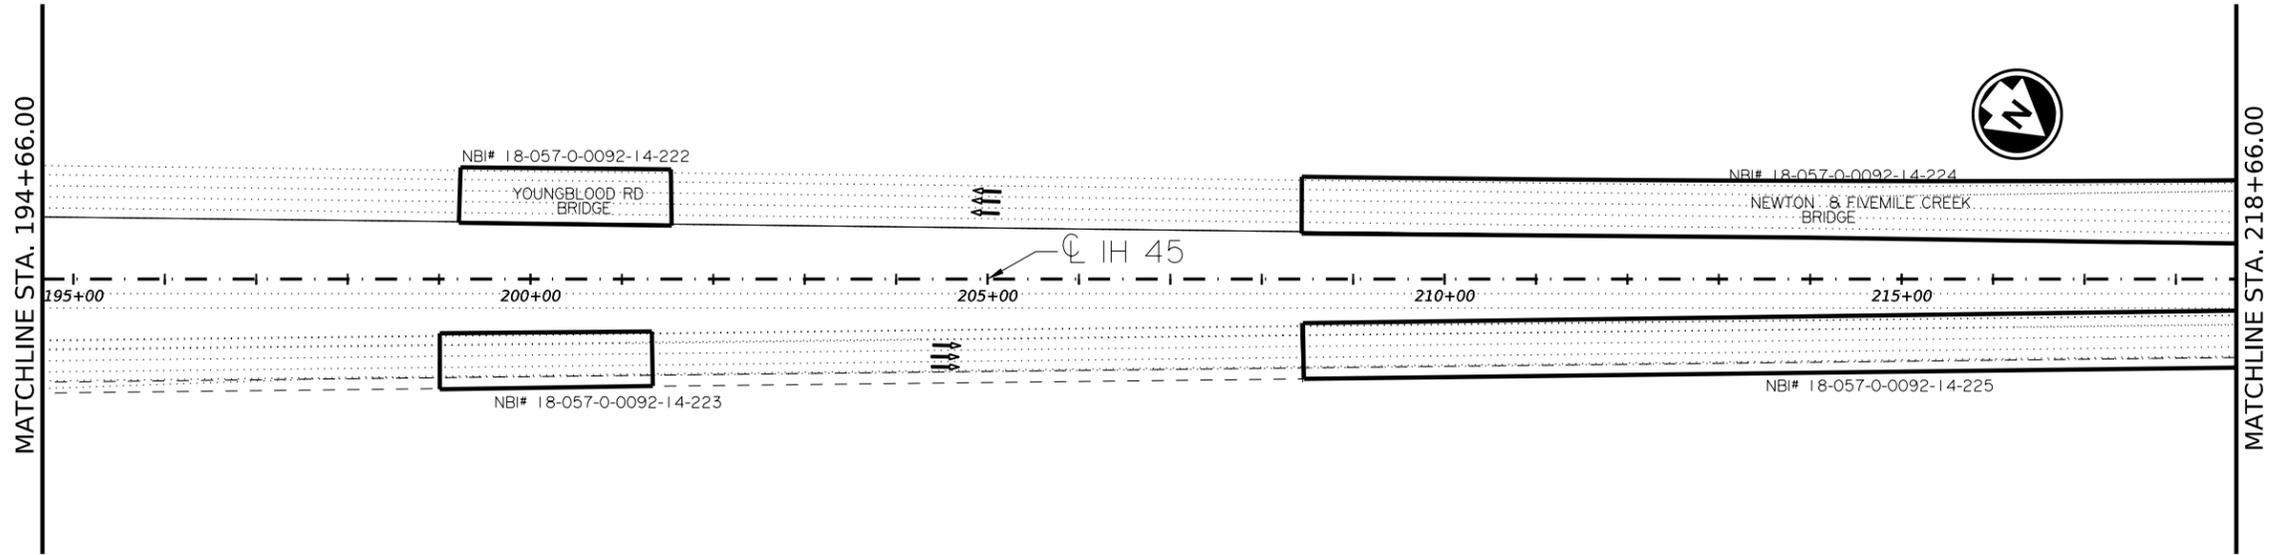

*Solomon Bayou* P.E. 5/16/2023  
Signature of Requestor & Date



**IH 45**

**CTB**



 
**PLAN LAYOUT**

SCALE: 1" = 200' SHEET 2 OF 6


CONT	SECT	JOB	HIGHWAY
0092	14	104	IH 45
DIST	COUNTY	SHEET NO.	
18	DALLAS	26	

DATE: 5/17/2023 10:47:52 AM  
FILE: c:\txdot\pw\_onlinetxdat5\solomon.bayou\d0841982\SSCB PLAN LAYOUT CONTAINER FILE.dgn

DW: SB  
 CK: DN  
 DW: SB  
 CK: DN  
 DW: SB  
 CK: DN

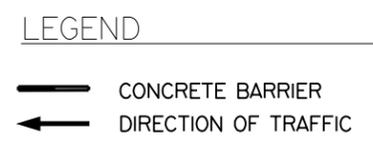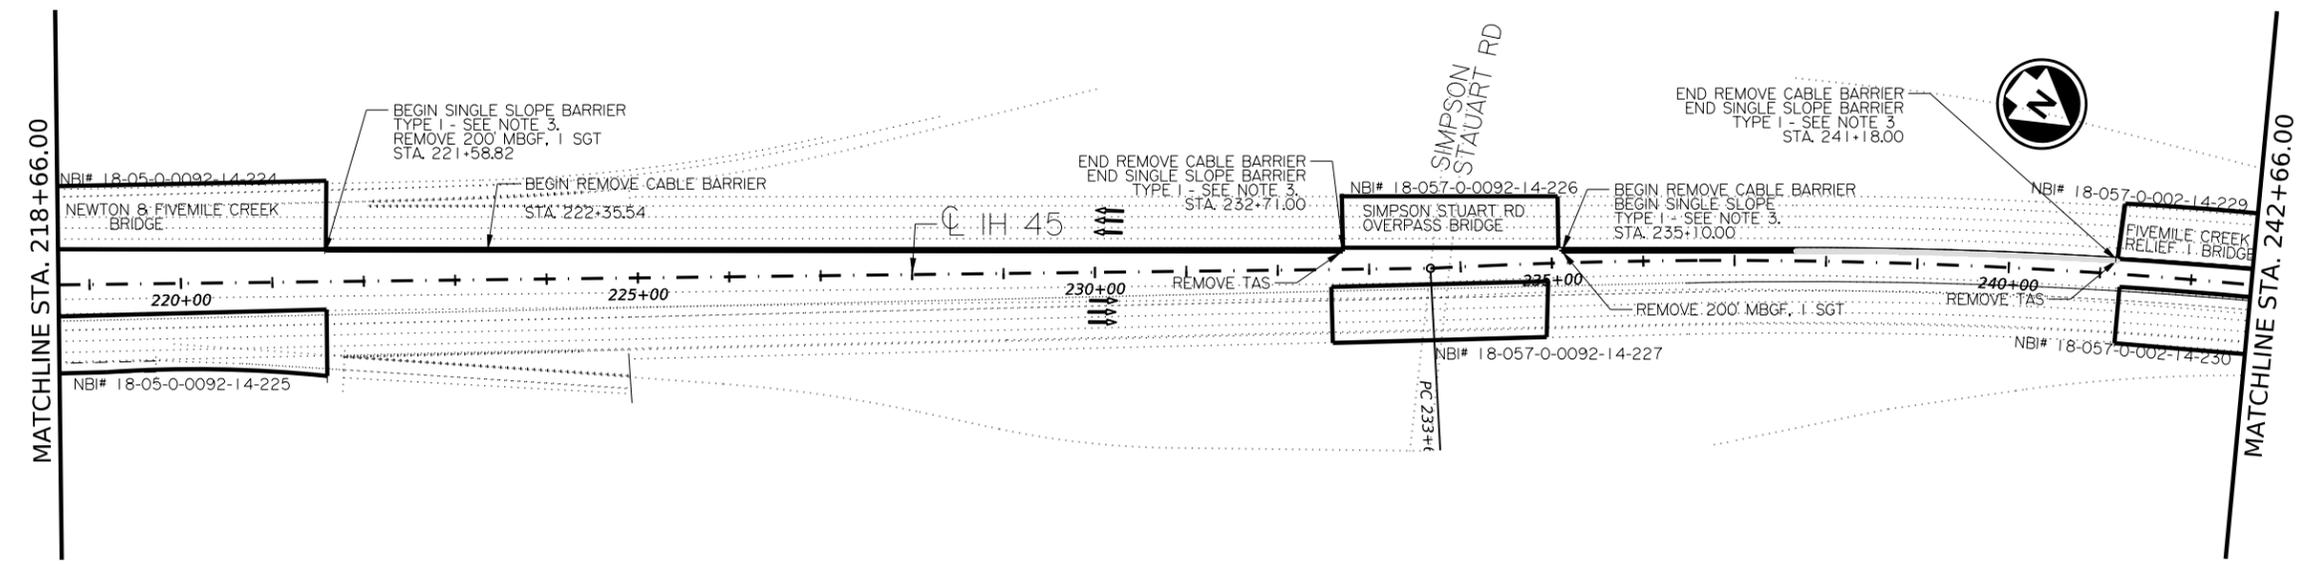

- NOTE:
- SEE TCP, WZ, BC STANDARDS, AND MUTCD FOR ADDITIONAL INFORMATION, DEVICES AND DEVICE PLACEMENT.
  - CONTRACTOR TO DETERMINE LOCATION OF UTILITIES TO AVOID IMPACTING.
  - ANCHOR DRILLED SHAFT FOUNDATION TO BE USED FOR SSCB BARRIER. SEE STANDARD SSCB(1F)-10 DRILLED SHAFT ANCHOR DETAILS FOR MORE INFORMATION.

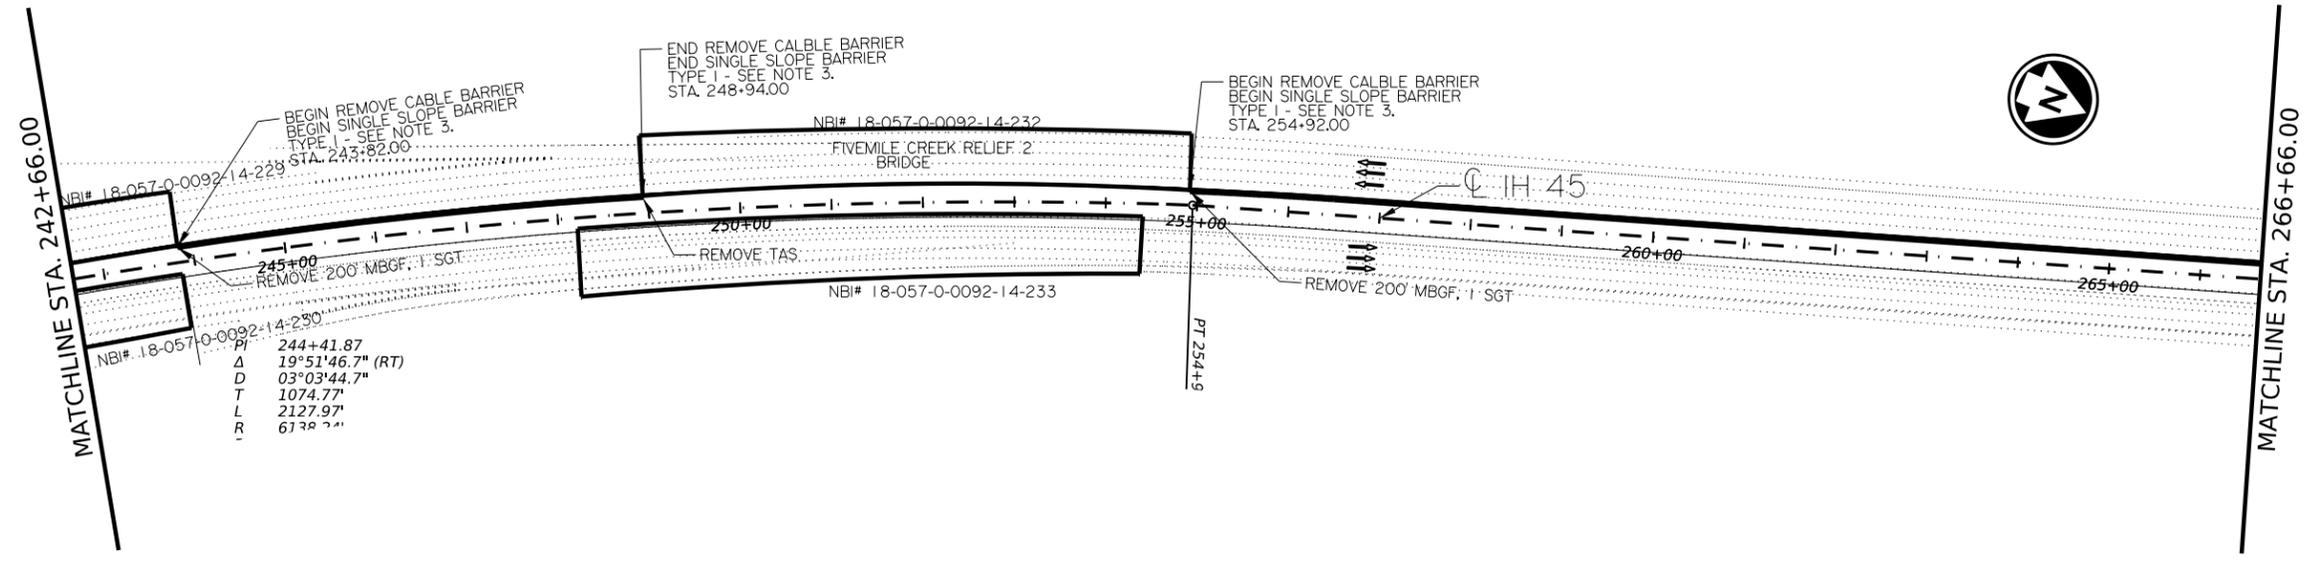

STATE OF TEXAS  
 SOLOMON BAYOUR  
 127501  
 LICENSED  
 PROFESSIONAL ENGINEER




*Solomon Bayour* 5/16/2023  
 Signature of Registrant Date




<b>IH 45</b>			
<b>CTB</b>			
<b>PLAN LAYOUT</b>			
SCALE: 1"=200'		SHEET 3 OF 6	
CONT	SECT	JOB	HIGHWAY
0092	14	104	IH 45
DIST	COUNTY	SHEET NO.	
18	DALLAS	27	

DATE: 5/8/2023 2:59:53 PM  
 FILE: c:\ttdot\pw\_onlinetxdat5\solomon.bayour\d0841982\SSCB PLAN LAYOUT CONTAINER FILE.dgn

 CK: DN  
DW: SB  
CK: DN  
DW: SB

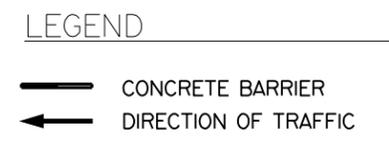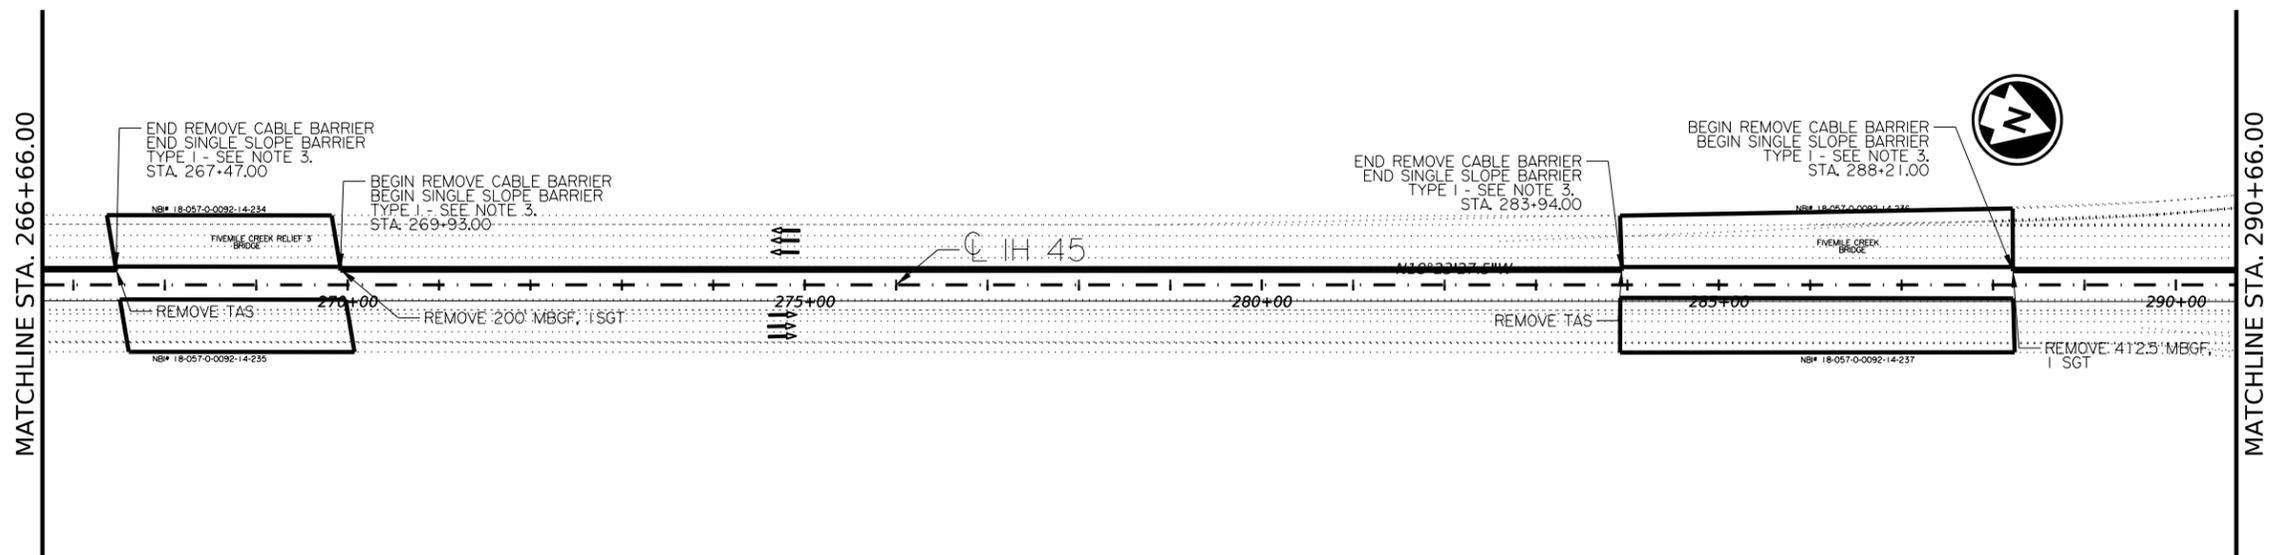

- NOTE:
1. SEE TCP, WZ, BC STANDARDS, AND MUTCD FOR ADDITIONAL INFORMATION, DEVICES AND DEVICE PLACEMENT.
  2. CONTRACTOR TO DETERMINE LOCATION OF UTILITIES TO AVOID IMPACTING.
  3. ANCHOR DRILLED SHAFT FOUNDATION TO BE USED FOR SSCB BARRIER. SEE STANDARD SSCB (1F)-10 DRILLED SHAFT ANCHOR DETAILS FOR MORE INFORMATION.

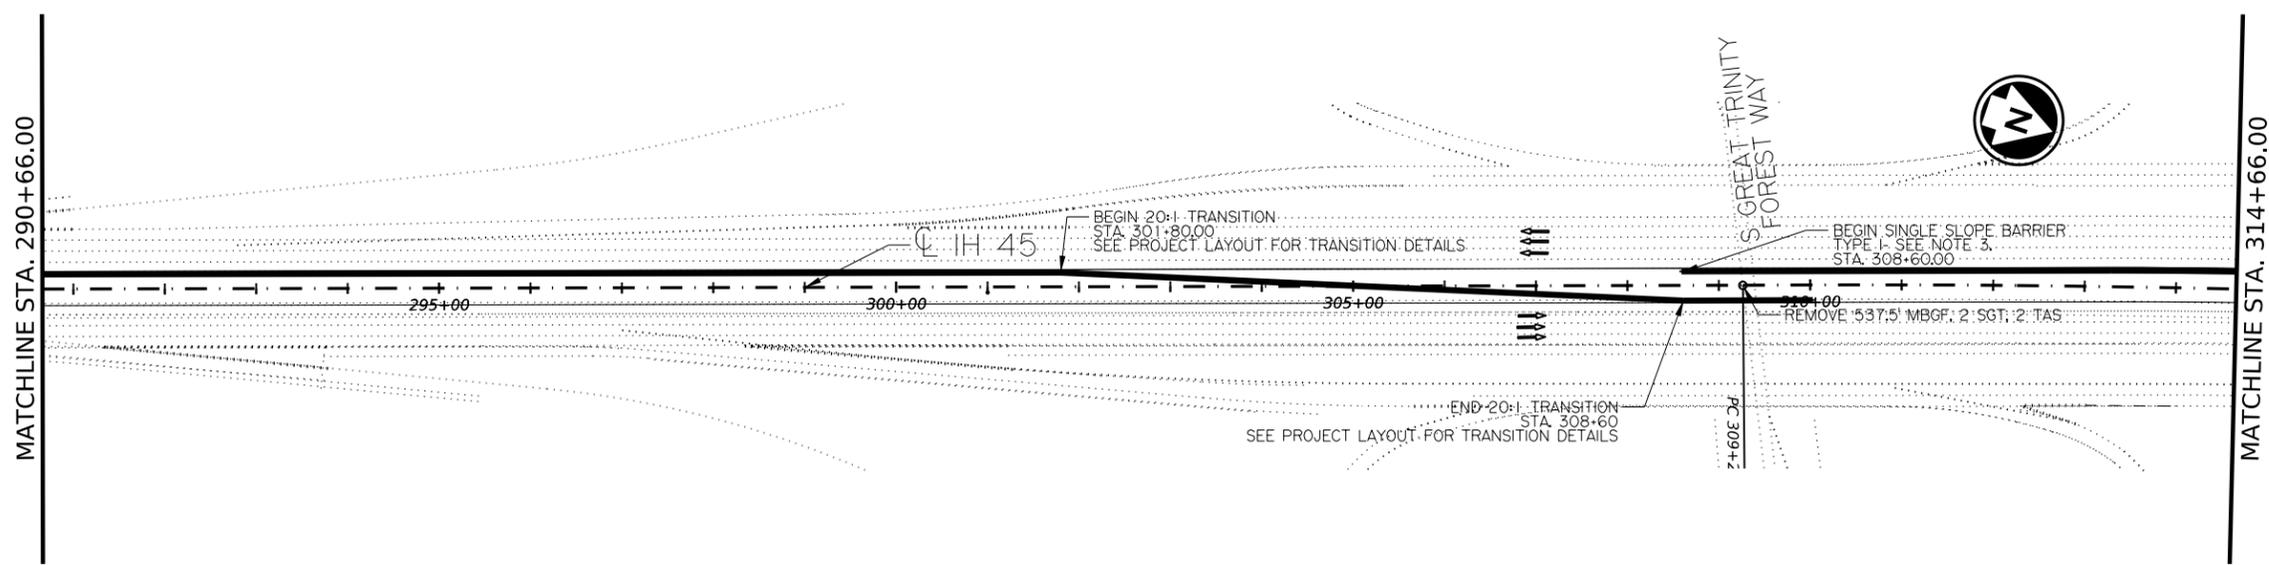

STATE OF TEXAS  
SOLOMON BAYOU  
127501  
LICENSED PROFESSIONAL ENGINEER

*Solomon Bayou, P.E.* 5/26/2023  
Signature of Registrant & Date

Texas Department of Transportation



IH 45  
CTB  
PLAN LAYOUT

SCALE: 1" = 200' SHEET 4 OF 6

CONT	SECT	JOB	HIGHWAY
0092	14	104	IH 45
DIST	COUNTY	SHEET NO.	
18	DALLAS	28	

DATE: 6/6/2023 8:44:40 AM  
FILE: c:\txdot\pw\_onlinetxdot\5\solomon.bayou\d0841982\SSCB PLAN LAYOUT CONTAINER FILE.dgn

 DW: SB    CC: DN    DW: SB    CC: DN

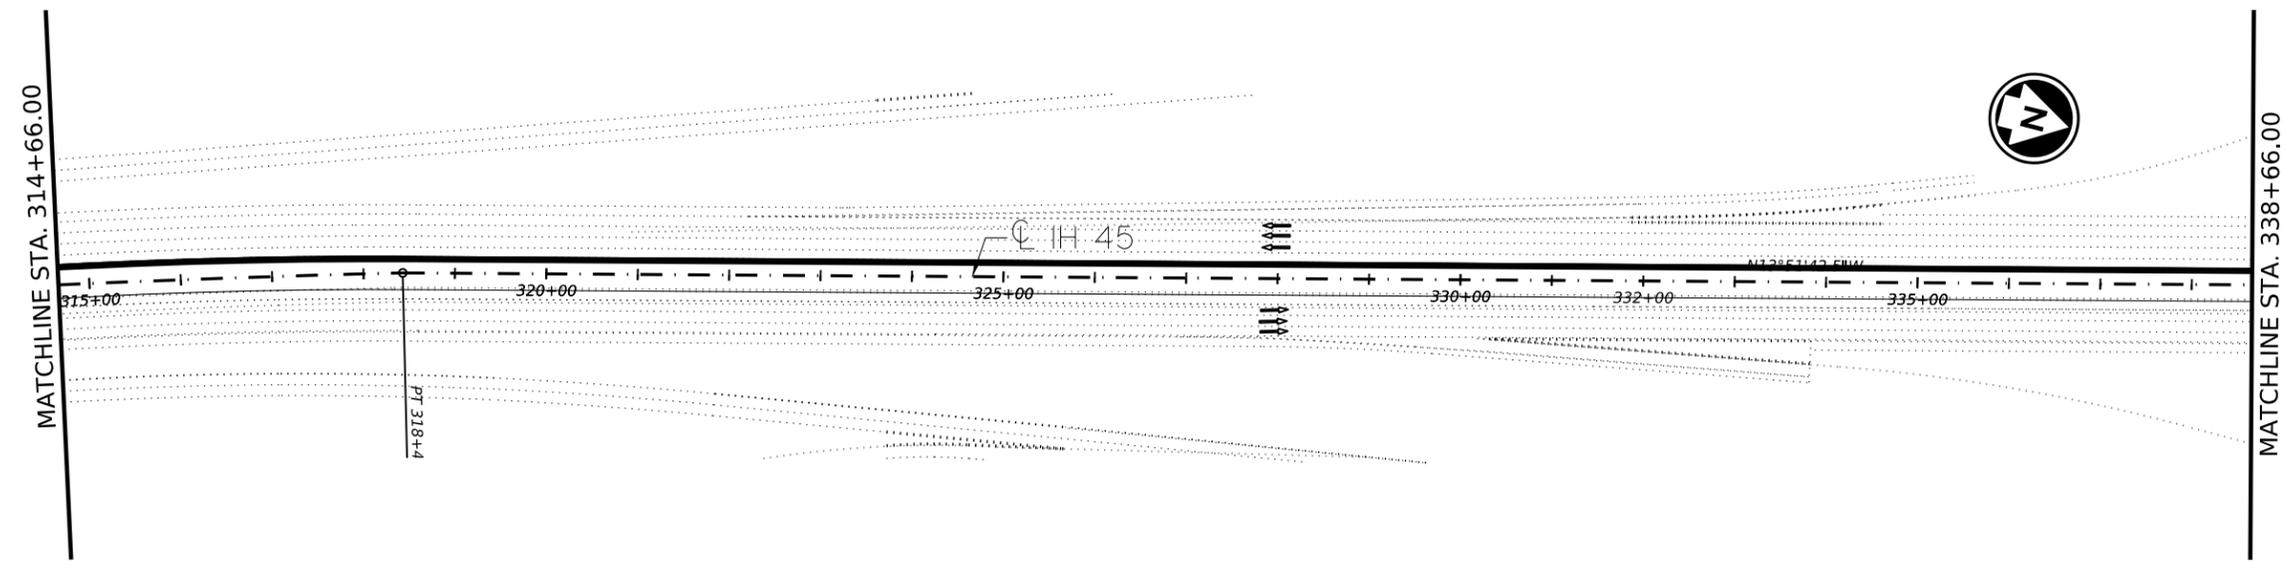


**LEGEND**

— CONCRETE BARRIER

← DIRECTION OF TRAFFIC

- NOTE:**
- SEE TCP, WZ, BC STANDARDS, AND MUTCD FOR ADDITIONAL INFORMATION, DEVICES AND DEVICE PLACEMENT.
  - CONTRACTOR TO DETERMINE LOCATION OF UTILITIES TO AVOID IMPACTING.
  - ANCHOR DRILLED SHAFT FOUNDATION TO BE USED FOR SSCB BARRIER. SEE STANDARD SSCB(1F)-10 DRILLED SHAFT ANCHOR DETAILS FOR MORE INFORMATION.

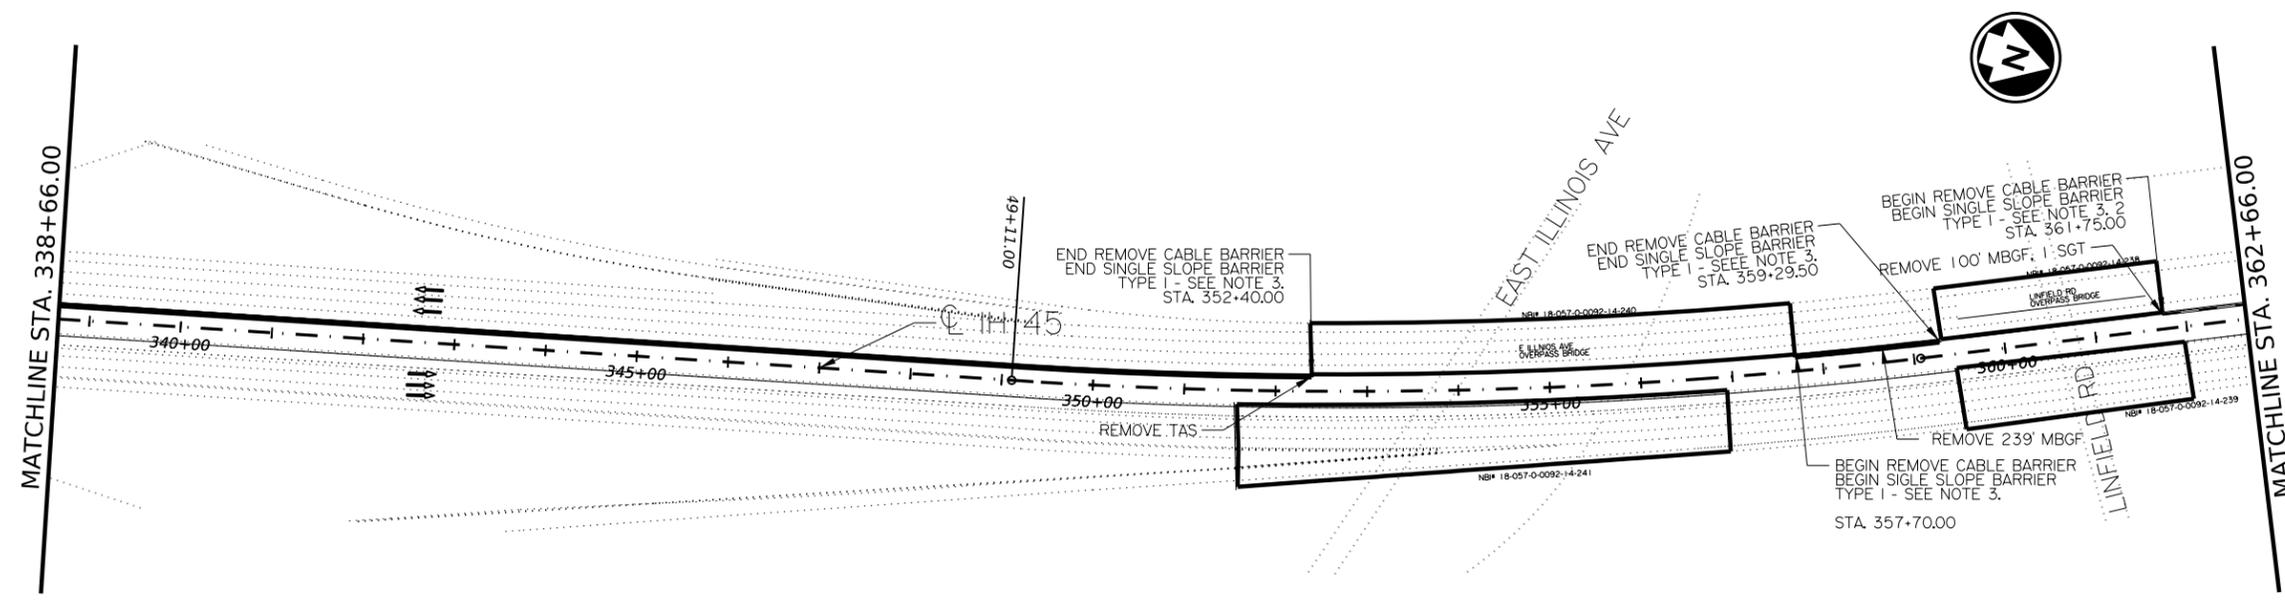

Solomon Bayou, P.E. 5/16/2023  
Signature of Requestant    Date



**IH 45**

**CTB**


**PLAN LAYOUT**

SCALE: 1" = 200'    SHEET 5 OF 6

CONT	SECT	JOB	HIGHWAY
0092	14	104	IH 45
DIST	COUNTY	SHEET NO.	
18	DALLAS	29	


DATE: 5/8/2023 2:59:59 PM  
FILE: c:\txdot\pw\_onlinetxdat5\solomon.bayou\d0841982\SSCB PLAN LAYOUT CONTAINER FILE.dgn

DW: SB    CC: DN    DW: SB    CC: DN    CC: DN

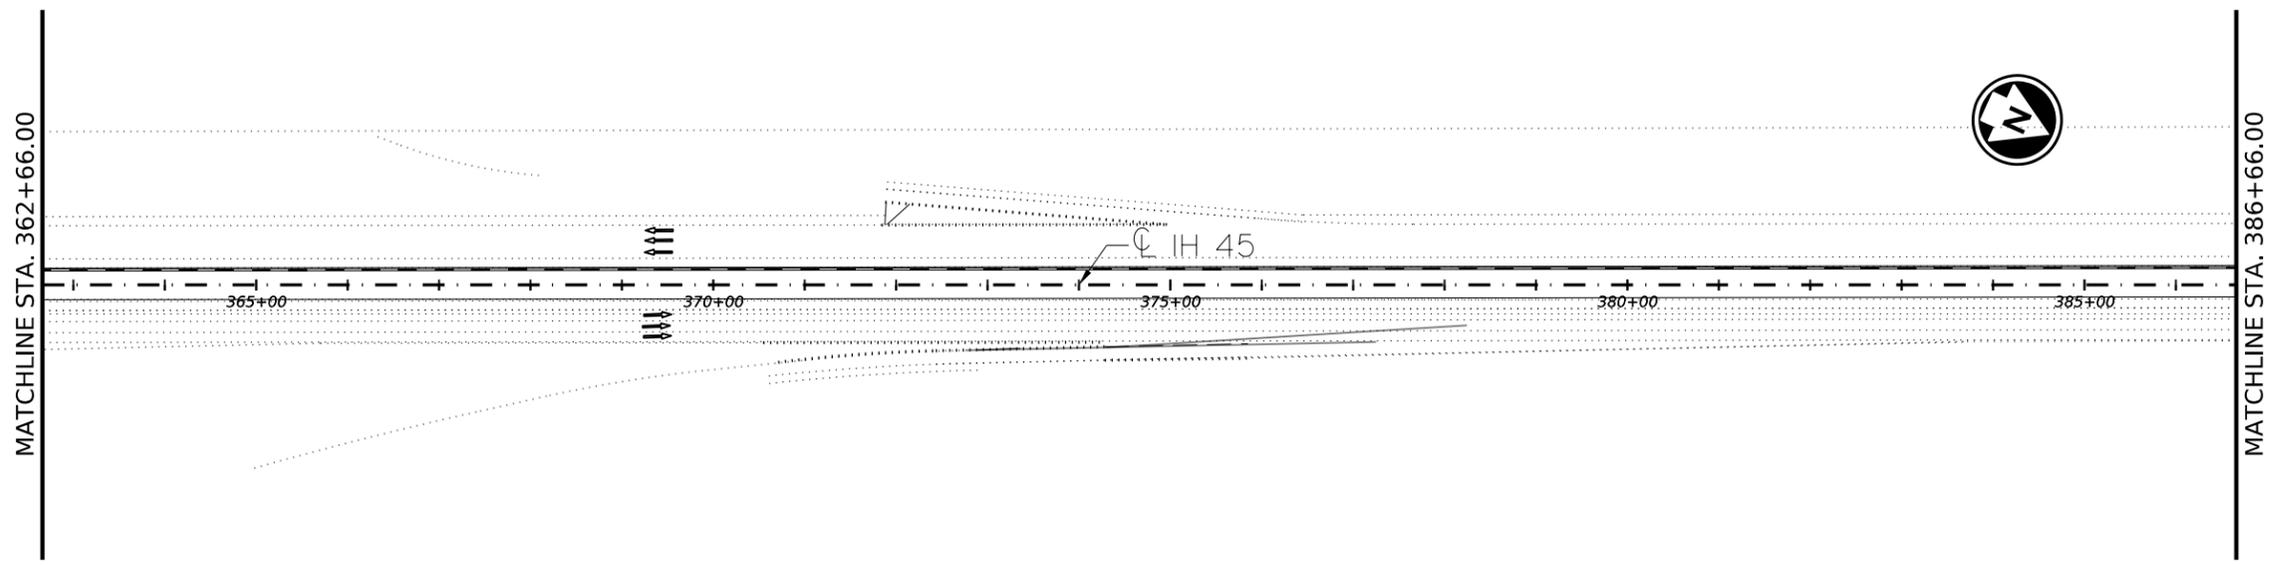

**LEGEND**

CONCRETE BARRIER  
 DIRECTION OF TRAFFIC

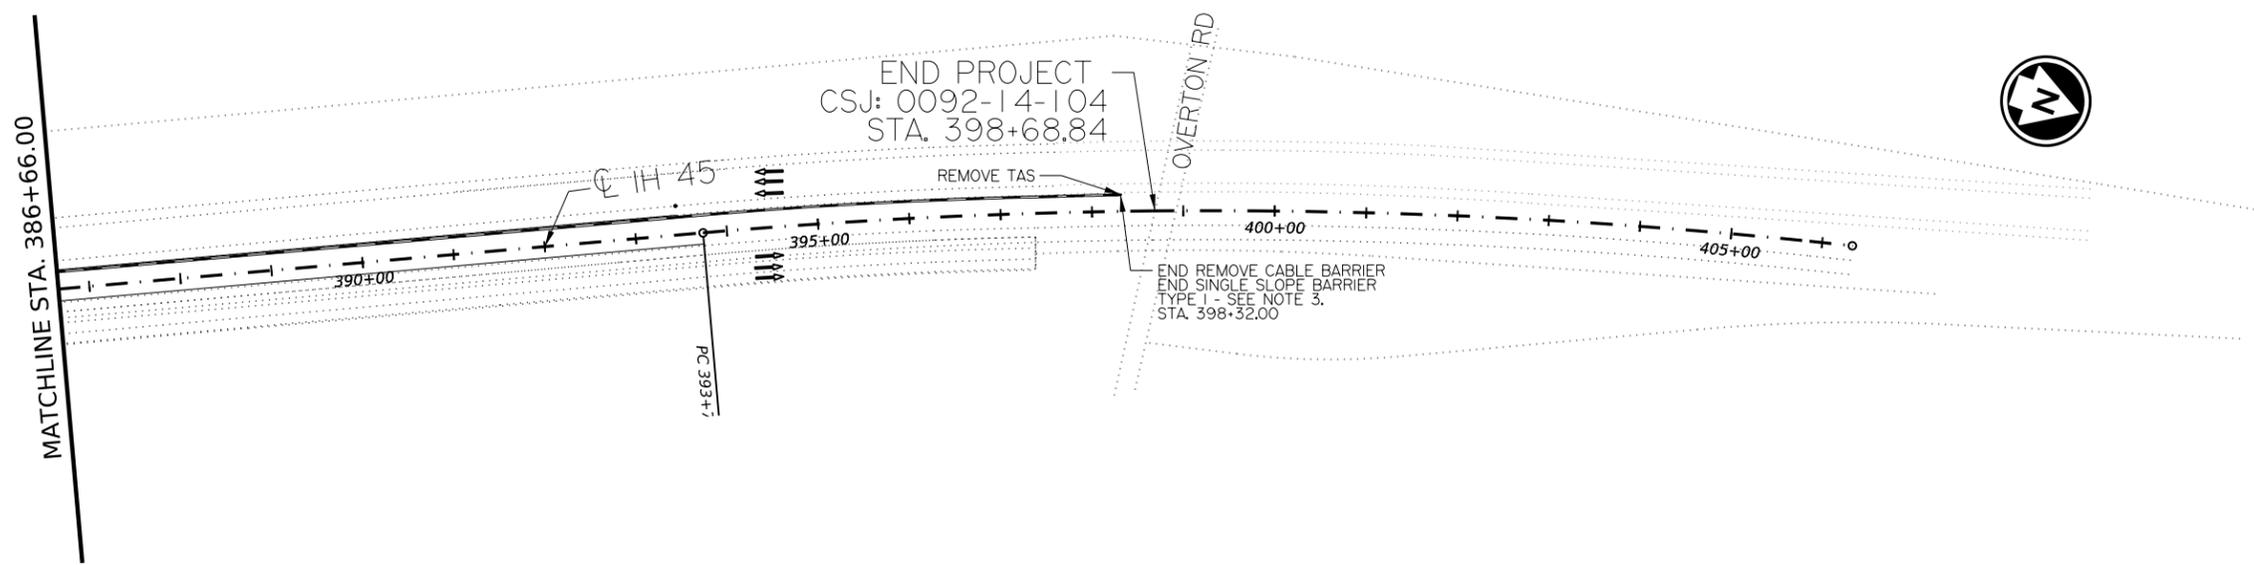

- NOTE:**
- SEE TCP, WZ, BC STANDARDS, AND MUTCD FOR ADDITIONAL INFORMATION, DEVICES AND DEVICE PLACEMENT.
  - CONTRACTOR TO DETERMINE LOCATION OF UTILITIES TO AVOID IMPACTING.
  - ANCHOR DRILLED SHAFT FOUNDATION TO BE USED FOR SSCB BARRIER. SEE STANDARD SSCB(1F)-10 DRILLED SHAFT ANCHOR DETAILS FOR MORE INFORMATION.



*Solomon Bayou* P.E. 5/16/2023  
 Signature of Registrant    Date




**IH 45**  
  
**CTB**  
**PLAN LAYOUT**

SCALE: 1" = 200'      SHEET 6 OF 6


CONT	SECT	JOB	HIGHWAY
0092	14	104	IH 45
DIST	COUNTY	SHEET NO.	
18	DALLAS	30	

DATE: 5/8/2023 3:00:01 PM  
 FILE: c:\txdot\pw\_online\txdot\5\solomon.bayou\d0841982\SSCB PLAN LAYOUT CONTAINER FILE.dgn

DATE: 2023203214  
 FILE: DOCUMENT NAME\online\txdot5\solomon\_bayou\d0852788\sscb1f10.dgn  
 DISCLAIMER: The use of this standard is governed by the "Texas Engineering Practice Act". No warranty of any kind is made by TxDOT for any purpose whatsoever. TxDOT assumes no responsibility for the conversion of this standard to other formats or for incorrect results or damages resulting from its use.

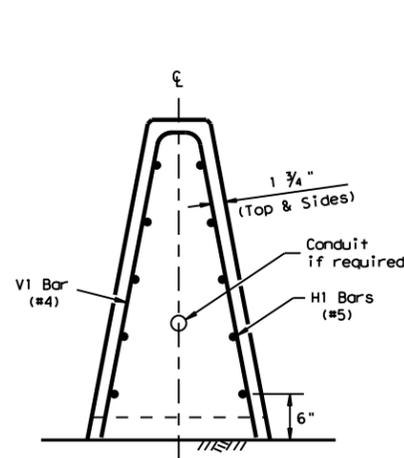


**END VIEW**  
**CAST-IN-PLACE (CIP) BARRIER**  
 Barrier is Symmetrical About the Center Line

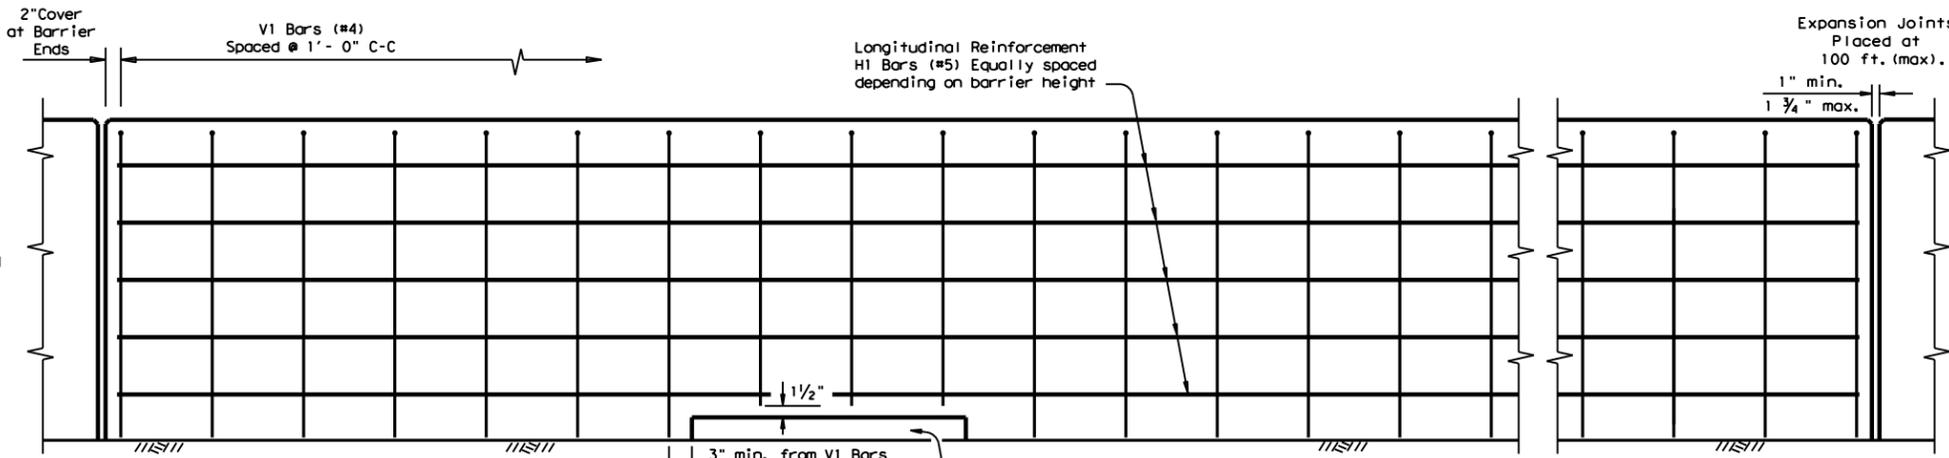


**ELEVATION VIEW**  
**Cast-in-Place (SSCB) (Type 2) on Roadway**

Note:  
 Bottom of reinforcement cage may rest on top of the finished grade.  
 Reinforcement around the drainage slots may be cut or bent to accommodate the edge and top clearances.

- GENERAL NOTES**
- Concrete shall be Class C. Unless otherwise specified in the plans.
  - Where used, rebar reinforcement shall be Grade 60 and conform to ASTM A615.
  - These details cover barrier per Item 514, "Permanent Concrete Traffic Barrier".
  - The Anchorage shown is considered subsidiary to the bid item.
  - Top edges of CIP barrier shall have a 3/4" chamfer or tooled radius.
  - Drainage slot locations (12'-0", C-C Min. Spacing) are shown elsewhere, or as directed by the Engineer. Drainage slot heights on the SSCB may be increased to a maximum of 5 inches, without geometric changes to the barrier face.
  - Cast-in-place barrier may be slip formed. Bracing may be tied or tack welded to the reinforcement cage to provide cage stability. Do not weld to anchorage.
  - For locations where lighting is required, see the SSCB(4) sheet for the proper reinforcement and anchorage.

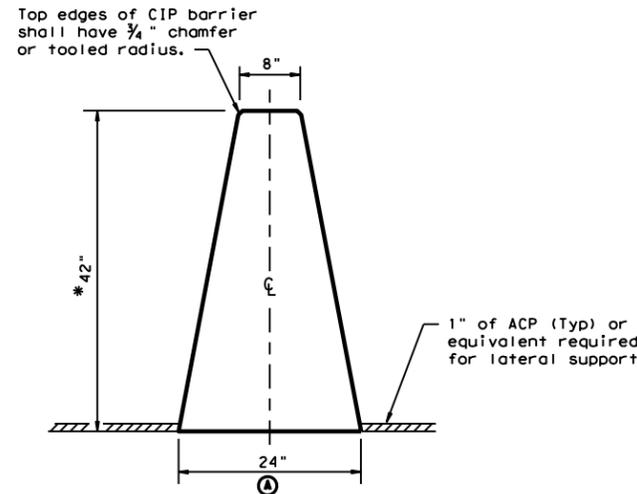

**SINGLE SLOPE CONCRETE BARRIER**  
**(SSCB) (42")**

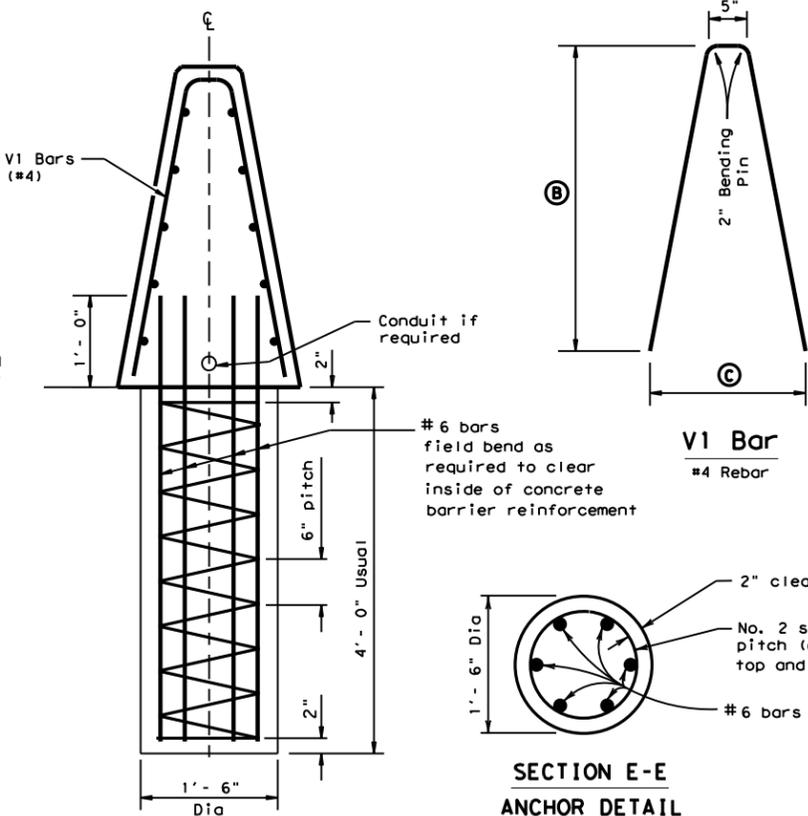


BARRIER HEIGHT (IN.)	* DIMENSIONS (IN.)		
	A	B	C
42	24	40 1/4	20 1/2
48	26 1/4	46 1/4	22 3/4
54	28 1/2	52 1/4	25 1/8

\*(SSCB) (42") Barrier height may be increased to 48" or 54". This would increase the barrier and reinforcement dimensions accordingly.


**Cast-In-Place (CIP) or Slip-Formed (SSCB)**

Cast-in-Place barrier may be connected to precast SSCB. Joint connection "Types" may be used in Cast-in-Place barrier, to match the precast barrier connection. (See required connection "Type" elsewhere in the plans)

The weight of Cast-in-Place (SSCB) 42" is approx. 717 lbs per ft.

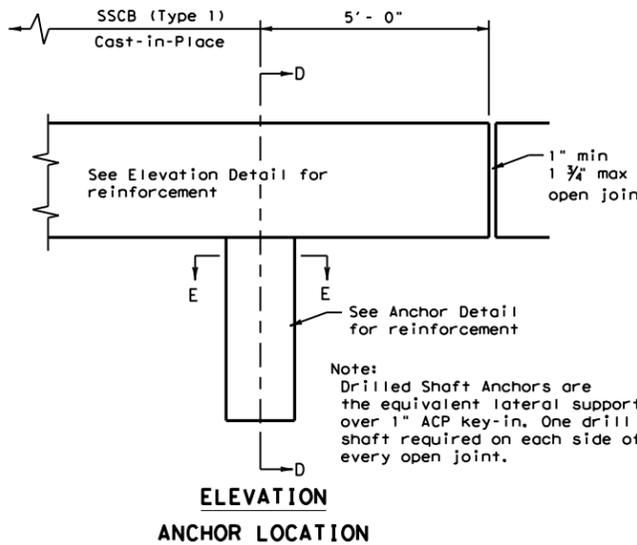


**ELEVATION ANCHOR LOCATION**

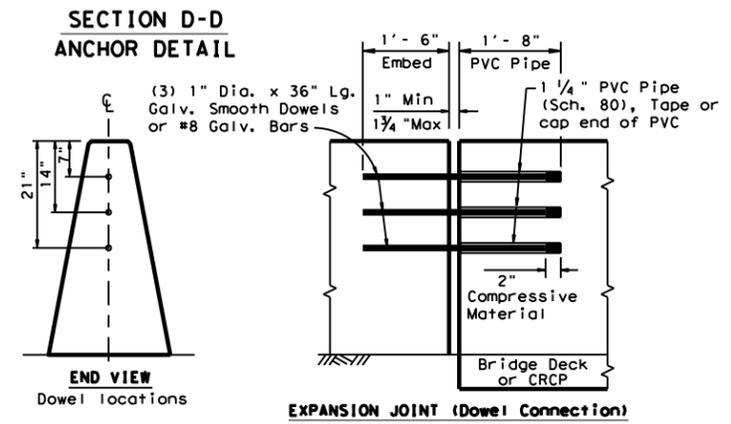

**EXPANSION JOINT (Dowel Connection)**

Dowels may be used, as directed by the Engineer, in locations where the barrier could be laterally displaced.

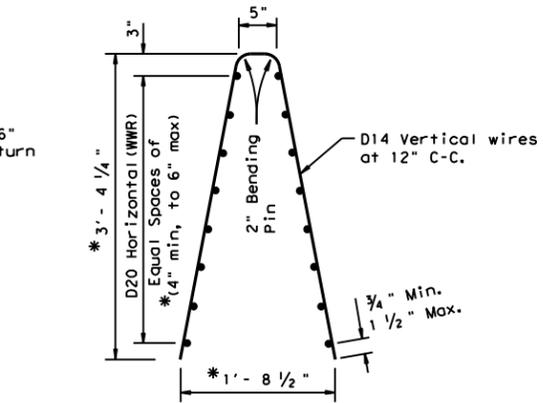

**Welded Wire Reinforcement (WWR) Option for Bars V1 and H1**  
**(WWR) General Notes**

- Deformed Welded Wire Reinforcement (WWR) shall conform to ASTM A497.
- Welded wire cage may be cut and bent to accommodate the drainage slots, as directed by the Engineer.
- Welded wire splice locations shall have a "minimum" splice lap length of 12".
- Combinations of reinforcing steel and WWR will be permitted, as directed by the Engineer. The dimension from the end of the barrier section to the first wire shall not exceed 3".


Design Division Standard

**SINGLE SLOPE CONCRETE BARRIER**  
**CAST-IN-PLACE (TYPE 1)**  
**(FLEXIBLE PAVEMENT)**  
**SSCB(1F) - 10**


FILE: sscb1f10.dgn	DN: TxDOT	CK: AM	DW: BD	CK:
© TxDOT December 2010	CONT	SECT	JOB	HIGHWAY
REVISIONS	0092	14	104	IH 45
	DIST	COUNTY	SHEET NO.	
	18	DALLAS	31	

DISCLAIMER: The use of this standard is governed by the "Texas Engineering Practice Act". No warranty of any kind is made by TxDOT for any purpose whatsoever. TxDOT assumes no responsibility for the conversion of this standard to other formats or for incorrect results or damages resulting from its use.


DATE: 2025/0823 3:24:11 PM  
 FILE: DOCUMENT\NAME\line\txdot5\solomon\_bayou\d0852788\_csb110.dgn

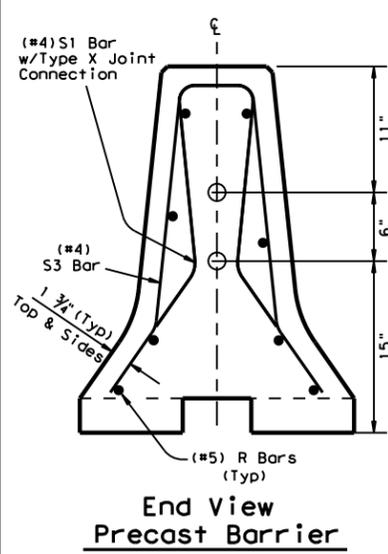


**End View Precast Barrier**  
 See sheet 2 of 3 for Joint connection Type X

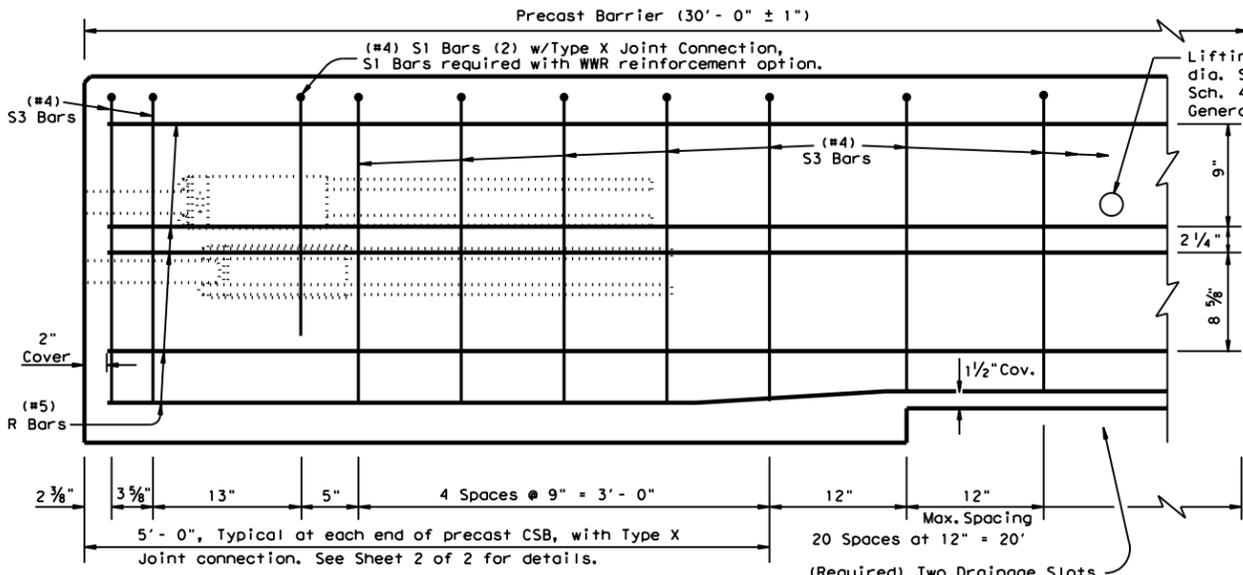


**Reinforcement for Precast (CSB) Concrete Safety Barrier (Type 1)**  
 Showing reinforcement for Joint Type X

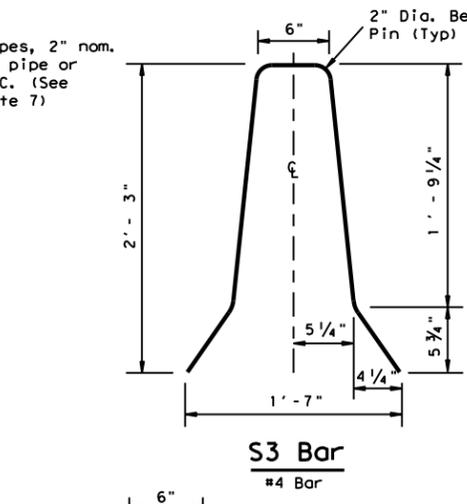

**S3 Bar**  
 #4 Bar

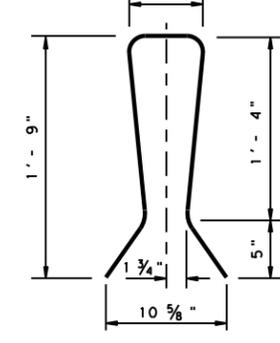

**S1 Bar**  
 #4 Bar (2)  
 (Joint Type X)

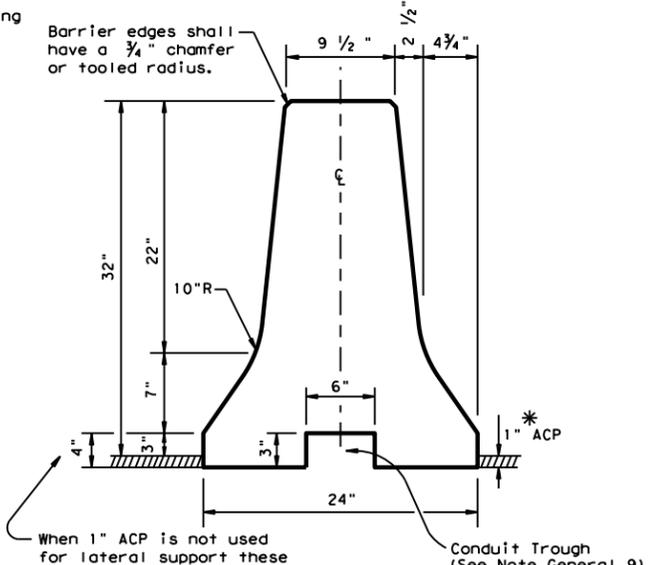


**Concrete Safety Barrier**


\* When 1" ACP is "not" used as lateral support for permanent barrier placement. A permissible method of attaining the equivalent lateral support may be used, See CSB(6) sheet.

**GENERAL NOTES**


- Concrete shall be Class H with a minimum compressive strength of 3,600 psi.
- Where used, rebar reinforcement shall be Grade 60 and conform to ASTM A615.
- Precast barrier length shall be 30 ft. unless otherwise specified on the plans.
- All precast barrier edges shall have a 3/4 inch chamfer or toolled radius.
- All concrete, reinforcement, joint connection systems, grout etc. as shown, are considered as part of the barrier payment.
- All steel assemblies for joint shall be galvanized after fabrication in accordance with Item 445, "Galvanizing."
- Regardless of the method of handling, barrier lifting points shall be approx. 7.5 feet from the ends of the barrier. Lifting devices and attachments to barrier sections shall be approved by the Engineer.
- Surface finishing and grouting (where required) shall be two parts sand one part cement with enough water to make the mixture plastic. Grouting shall be done in a manner that will assure a smooth surface. Surface finishing shall be considered subsidiary to the various bid items involved.
- Conduit trough when required shall be shown elsewhere on the plans, or as directed by the Engineer.

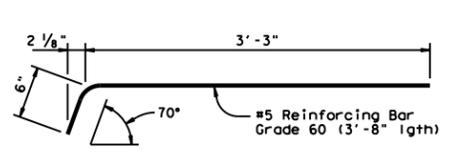


**DEFORMED BAR ANCHOR DETAILS**  
 Two (2) Bars required per assembly. Eight (8) required per joint.

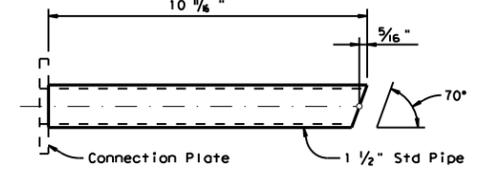


**UPPER CONNECTION PIPE DETAILS**  
 One (1) Steel Pipe required per Upper Assembly. Two (2) required per joint.

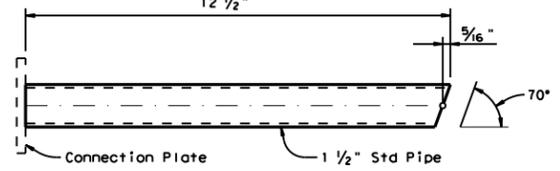


**LOWER CONNECTION PIPE DETAILS**  
 One (1) Steel Pipe required per Lower Assembly. Two (2) required per joint.

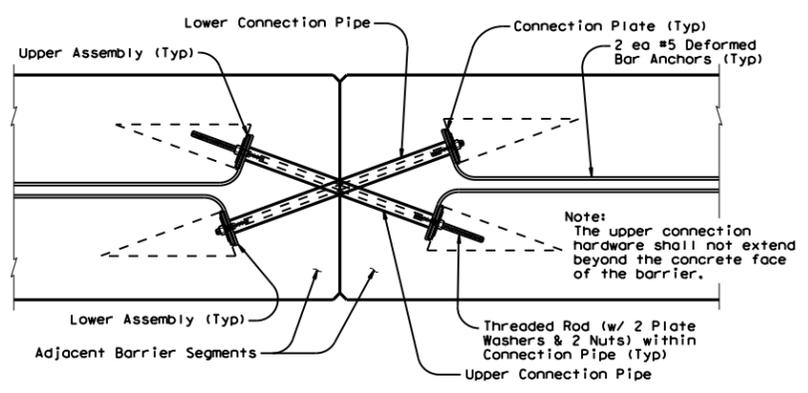


**TYPE X JOINT INSTALLATION DETAIL**  
 Barrier reinforcing and Type X Joint Leave-Out dimensions not shown for clarity.

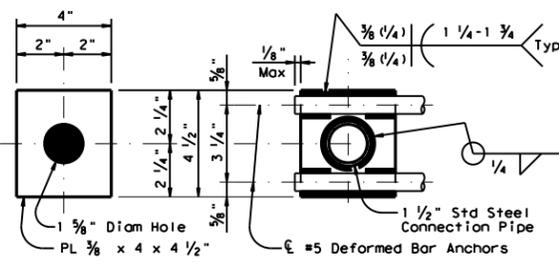

**CONNECTION PLATE DETAILS**  
 One (1) Plate required per assembly. Four (4) required per joint. All steel fittings for joint Type X shall be galvanized after fabrication in accordance with Item 445.

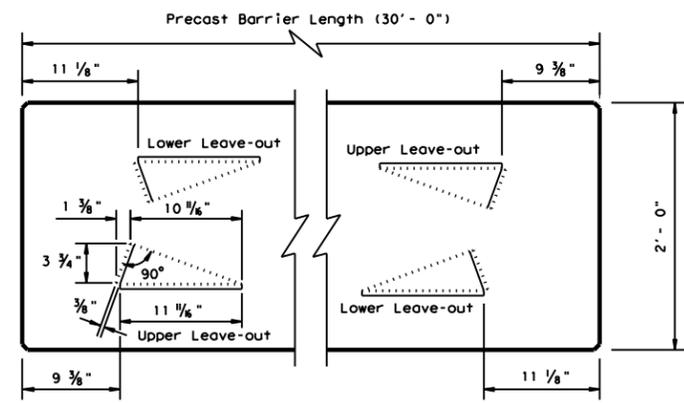


**BARRIER PLAN AT END JOINTS**

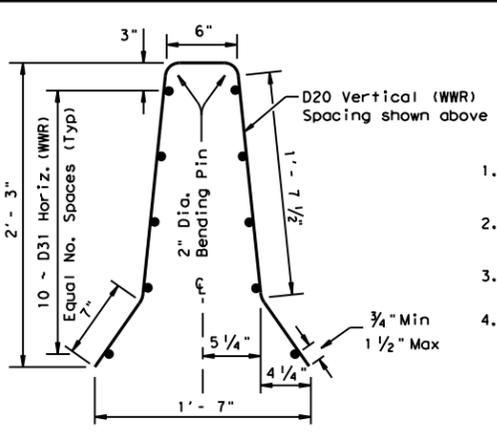


**Welded Wire Reinforcement (WWR) Option for Bars R and S3**  
 (WWR) General Notes

- Deformed Welded Wire Reinforcement (WWR) shall conform to ASTM A497.
- Welded wire cage may be cut or bent to accommodate the Type X joint connection and drainage slots, as directed by the Engineer.
- All reinforcement shall comply with Item 440, "Reinforcing Steel."
- Combinations of reinforcing steel and WWR will be permitted, as directed by the Engineer. The dimension from the end of the barrier section to the first wire shall not exceed 3".

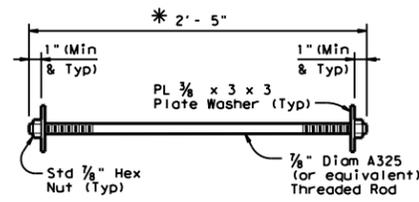

**CONNECTION BOLT OR THREADED ROD DETAIL**  
 Two (2) Threaded Rods (or Equivalent Hex Hd. Bolts) (w/ Two (2) PL 3/8 x 3 x 3 Plate Washers & Two (2) Std Hex Nuts) required per joint.

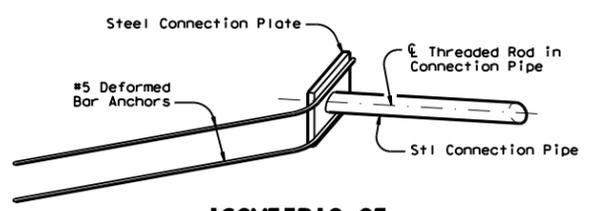


**ISOMETRIC OF TYPICAL WELDED ASSEMBLY**  
 Four (4) [2 Upper & 2 Lower] Assemblies required per joint.

Weight of one Precast 30 ft. (CSB) segment = Approx. 6.5 Tons or 440 lbs per ft.


		Design Division Standard	
<b>CONCRETE SAFETY BARRIER (F-SHAPE)</b> PRECAST BARRIER (TYPE 1) <b>CSB(1)-10</b>			
FILE: csb110.dgn	DN: TxDOT	CK: AM	DW: BD
© TxDOT December 2010	CONT: 0092	SECT: 14	JOB: 104
REVISIONS			HIGHWAY: IH 45
	DIST: 18	COUNTY: DALLAS	SHEET NO.: 32

DISCLAIMER: The use of this standard is governed by the "Texas Engineering Practice Act". No warranty of any kind is made by TxDOT for any purpose whatsoever. TxDOT assumes no responsibility for the conversion of this standard to other formats or for incorrect results or damages resulting from its use.


DATE: 2023/08/25 3:31:33 PM  
 FILE: \\DOCUMENT\NAME\line\txdot5\solomon\_bayou\d0852788\csb110.dgn

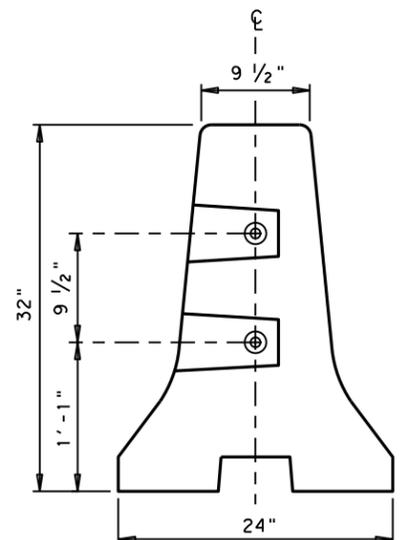

**END VIEW (CSB) QUICK-BOLT**  
 QUICK-BOLT POCKET LOCATIONS

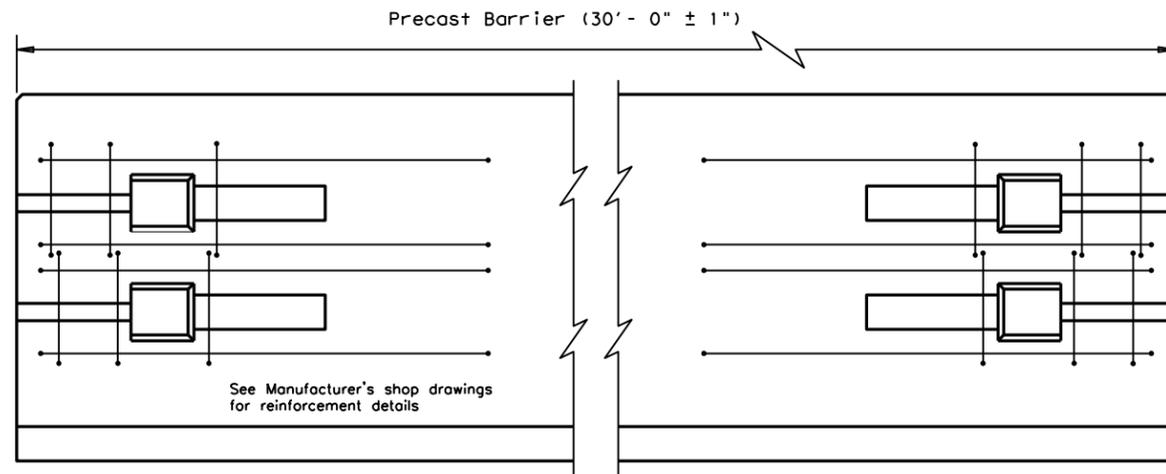


**ELEVATION (CSB) QUICK-BOLT**  
 See Manufacturer's shop drawing for additional details

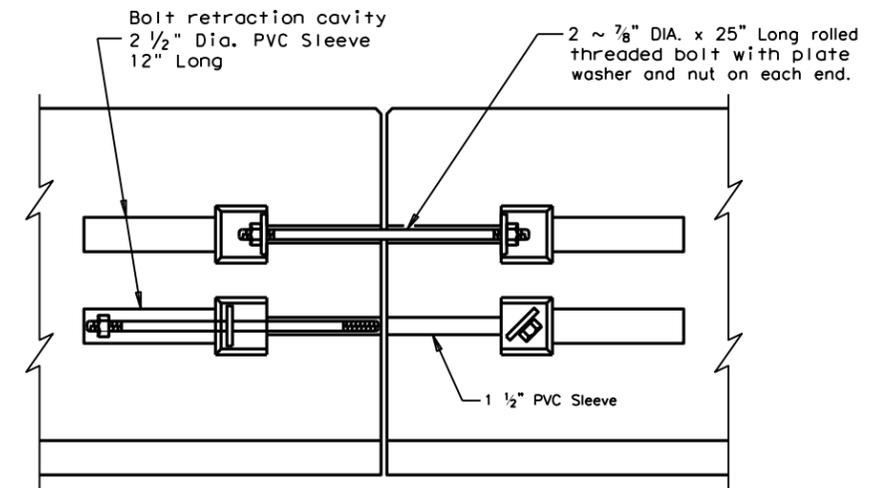


**ELEVATION VIEW SHOWING JOINT CONNECTION**  
**"QUICK-BOLT"**

**Joint Connection (Type Q)**

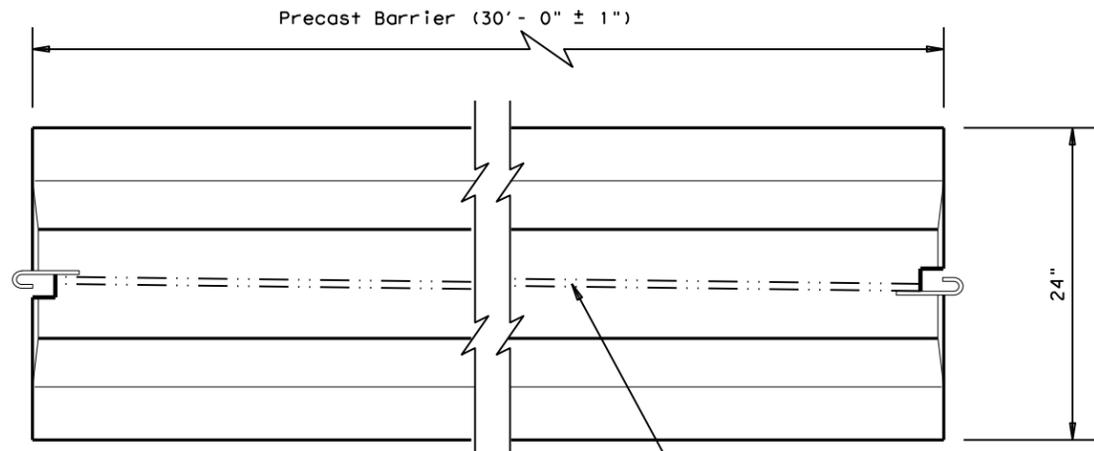


**TOP VIEW**  
**PRECAST (CSB) WITH J-J HOOKS**  
 See Manufacturer's shop drawing for additional details

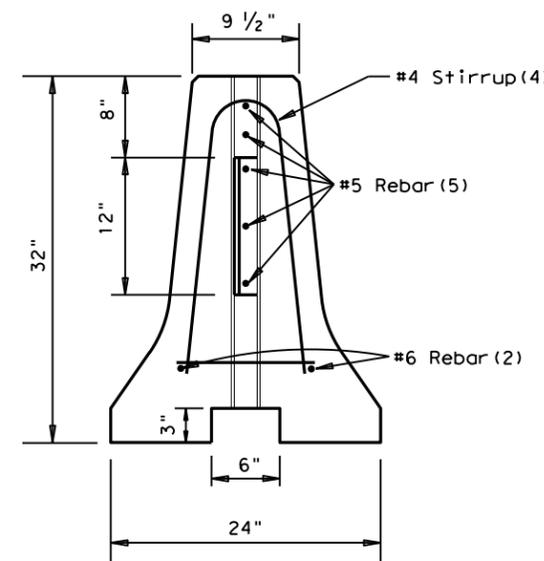

**END VIEW**  
**J-J HOOK CONNECTION**

**Joint Connection (Type J)**

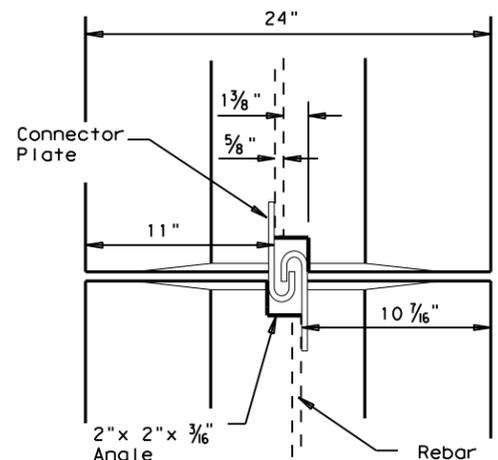

**VIEW FROM ABOVE**  
**J-J HOOK CONNECTION**

**Proprietary Joint Connections (CSB)**

Two proprietary joint connections are acceptable as alternates to the (Type X) connection shown, here on. These joint connections types are:

J-J Hooks by Easi-Set Industries, (800)547-4045  
 Quick-Bolt by Bexar Concrete, (210)497-3773


If one of these connection systems are exclusively specified in the plans, prior approval for sole source use must be obtained. Details of the connection components and barrier reinforcement for these systems, will be shown on the manufacturer's shop drawing(s) furnished to the Engineer.

SHEET 2 OF 2


		Design Division Standard	
<b>CONCRETE SAFETY BARRIER (F-SHAPE)</b> <b>PRECAST BARRIER (TYPE 1)</b> <b>CSB(1)-10</b>			
FILE: csb110.dgn	DN: TxDOT	CK: AM	DW: BD
© TxDOT December 2010	CONT: 0092	SECT: 14	JOB: 104
REVISIONS			HIGHWAY: IH 45
	DIST: 18	COUNTY: DALLAS	SHEET NO.: 33

DISCLAIMER: The use of this standard is governed by the "Texas Engineering Practice Act". No warranty of any kind is made by TxDOT for any purpose whatsoever. TxDOT assumes no responsibility for the conversion of this standard to other formats or for incorrect results or damages resulting from its use.

DATE: 5/8/2023  
 FILE: c:\txdot\pw\_online\txdot5\solomon\_bayou\d0852788\tauu1rn16.dgn

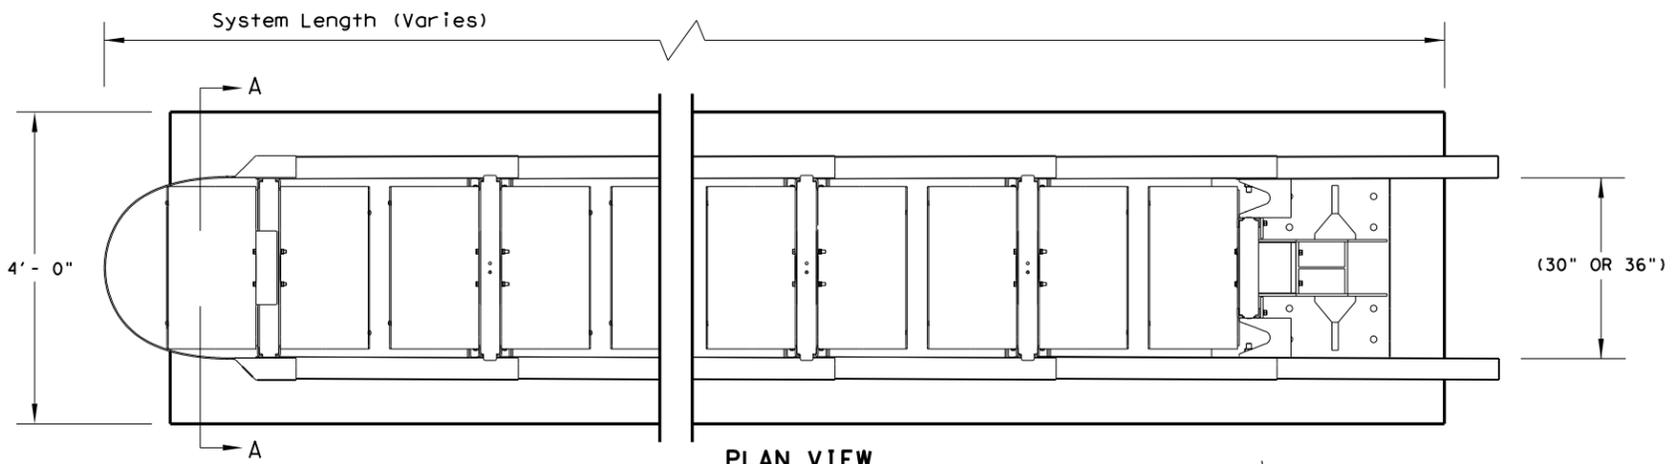


**PLAN VIEW**

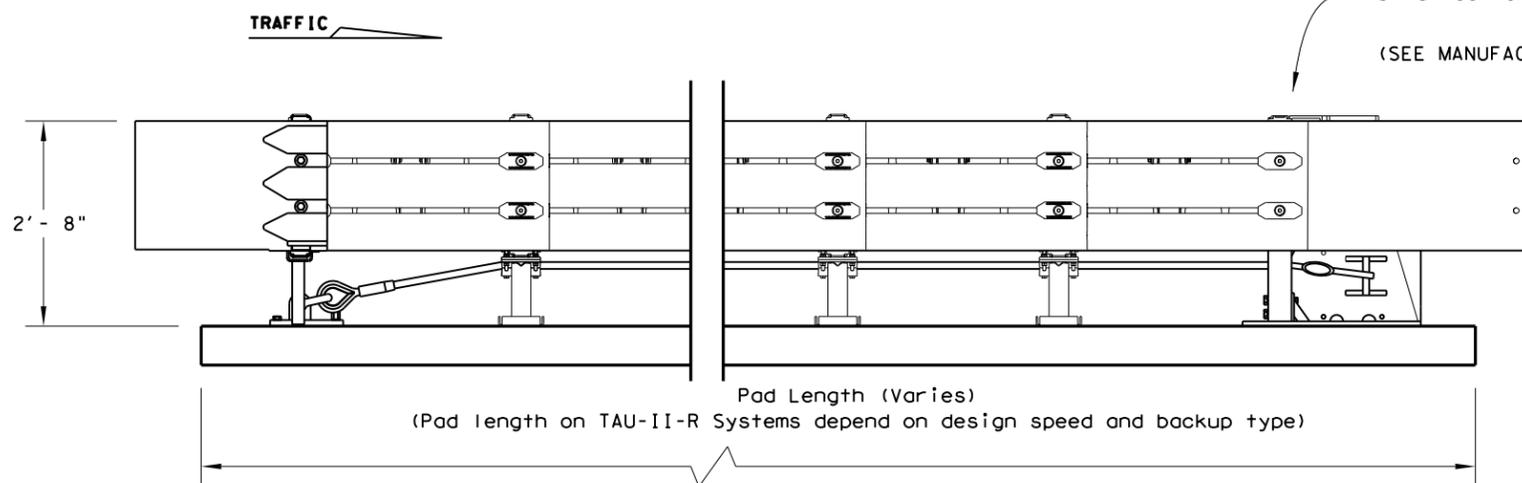

**ELEVATION VIEW**

Attachments and transitions to various barrier shapes, barrier railings and bi-directional traffic flows are available.  
 (SEE MANUFACTURER'S PRODUCT MANUAL)

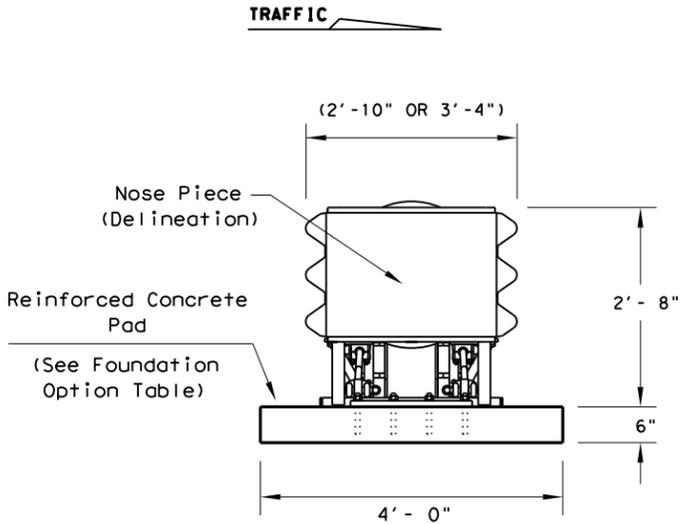

**SECTION A-A**


Nose Piece delineation orientation, is shown elsewhere on the plans.

TRANSITION OPTIONS	
Vertical Wall	
Concrete Traffic Barriers	
W-Beam Guardrail	
Thrie Beam Guardrail	

For bi-directional transition panel and end shoe details. (See manufacturer's product manual.)

FOUNDATION OPTIONS	
6" Reinforced Concrete	
8" Unreinforced Concrete	
Asphalt over Concrete with Minimum 6" Embedment in Concrete	
6" Asphalt over 6" Compact Subbase	
8" Minimum Asphalt	

For steel placement in concrete foundations. (See manufacturer's product manual)

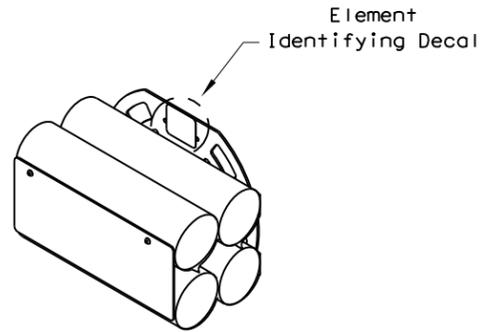

**ENERGY ABSORBING ELEMENTS (EAE)**

BACKUP SUPPORT OPTIONS	
Compact (Stand Alone)	
Flush Mount	
PCB (Concrete Barrier)	

TAU-II-R (NARROW) SYSTEM LENGTHS			
BACKSTOP	TL-2	TL-3	70 mph
PCB	13'-7"	27'-10"	30'-7"
Flush Mount	14'-0"	28'-3"	31'-0"
Compact	15'-3"	29'-6"	32'-3"

Backup and Transition types are shown elsewhere on the plans, (i.e. Attenuator location details or in the general notes).

Note: System lengths are ± 2"

**GENERAL NOTES**

- For specific information regarding installation and technical guidance of the system, contact: Lindsay Transportation Solutions - Barrier Systems, Inc. at (707) 374-6800. 180 River Road, Rio Vista, CA 94571
- For bi-directional traffic, appropriate transition panels will be required.
- Additional details for the backup support option, transition options and foundation option will be shown on the manufacturer's shop drawings furnished to the Engineer.
- Concrete shall be class "S" with a minimum compressive strength of 4,000 psi.
- Maximum permissible cross-slope is 8%.
- The installation area should be free from curbs, elevated objects, or depressions.
- The TAU-II-R system should be approximately parallel with the barrier or center of merging barriers.
- Refer to Universal TAU-II-R configuration chart for specific systems configuration number and location of each type of energy absorbing element.
- 30-inch (30") model shown, also available in 36-inch (36") configuration.

**BILL OF MATERIAL**

PRODUCT CODE	QTY	DESCRIPTION
B030704	1	Front Support
B030703	TBD	Mid Support
TBD	1	Backstop Assembly (See Table)
TBD	1	Front Cable Anchor
TBD	1	Nose Assembly
B010202	TBD	Sliding Panel
B010659	2	End Panel
K001003	1	Slider Assembly Kit
BSI-1202006-KT	TBD	TAU-II-R Slider Kit
BSI-1107131-KT	TBD	TAU-II-R EAE Mounting Hw Kit
BSI-1012069-00	TBD	Energy Absorbing Element, Type 1
BSI-1012070-00	TBD	Energy Absorbing Element, Type 2
BSI-1012071-00	TBD	Energy Absorbing Element, Type 3
BSI-1110009-00	TBD	Energy Absorbing Element, Type 3N
TBD	TBD	Cable Assembly
K001004	TBD	Cable Guide Kit
K001005	2	Front Support Leg Kit
B010651	4	Pipe Panel Mount
TBD	1	Anchoring Package

(TBD) = To Be Determined, depending on Backup Type and System Length.

(See manufacturer's product manual for details)



**LTS-BARRIER SYSTEMS  
CRASH CUSHION  
(R-NARROW)**







**TAU-II-R(N)-16**

**LOW MAINTENANCE**

FILE: tau1rn16.dgn	DN: TxDOT	CK: KM	DW: VP	CK: CGL
©TxDOT: January 2013	CONT	SECT	JOB	HIGHWAY
REVISIONS	0092	14	104	IH 45
REVISED 06, 2013 (VP)	DIST	COUNTY	SHEET NO.	
REVISED 03, 2016 (VP)	18	DALLAS	34	

DISCLAIMER: The use of this standard is governed by the "Texas Engineering Practice Act". No warranty of any kind is made by TxDOT for any purpose whatsoever. TxDOT assumes no responsibility for the conversion of this standard to other formats or for incorrect results or damages resulting from its use.

DATE: 5/8/2023  
FILE: \$FILEL\$.s

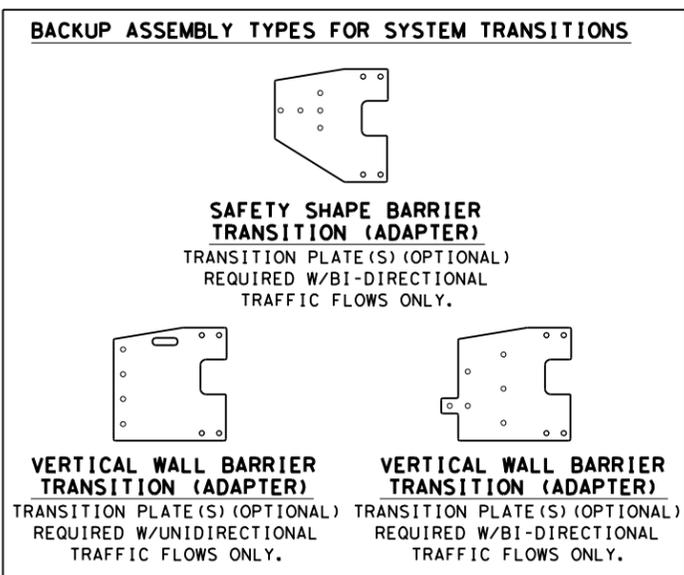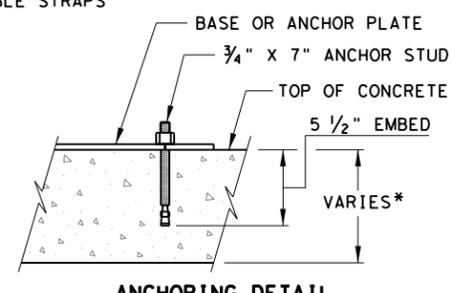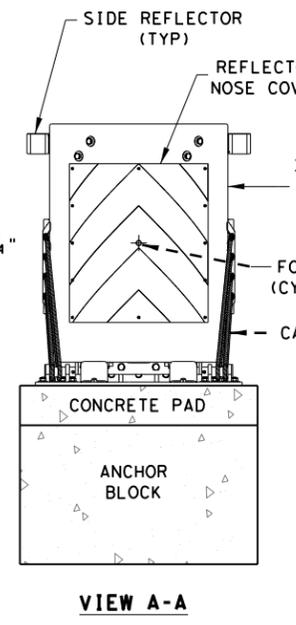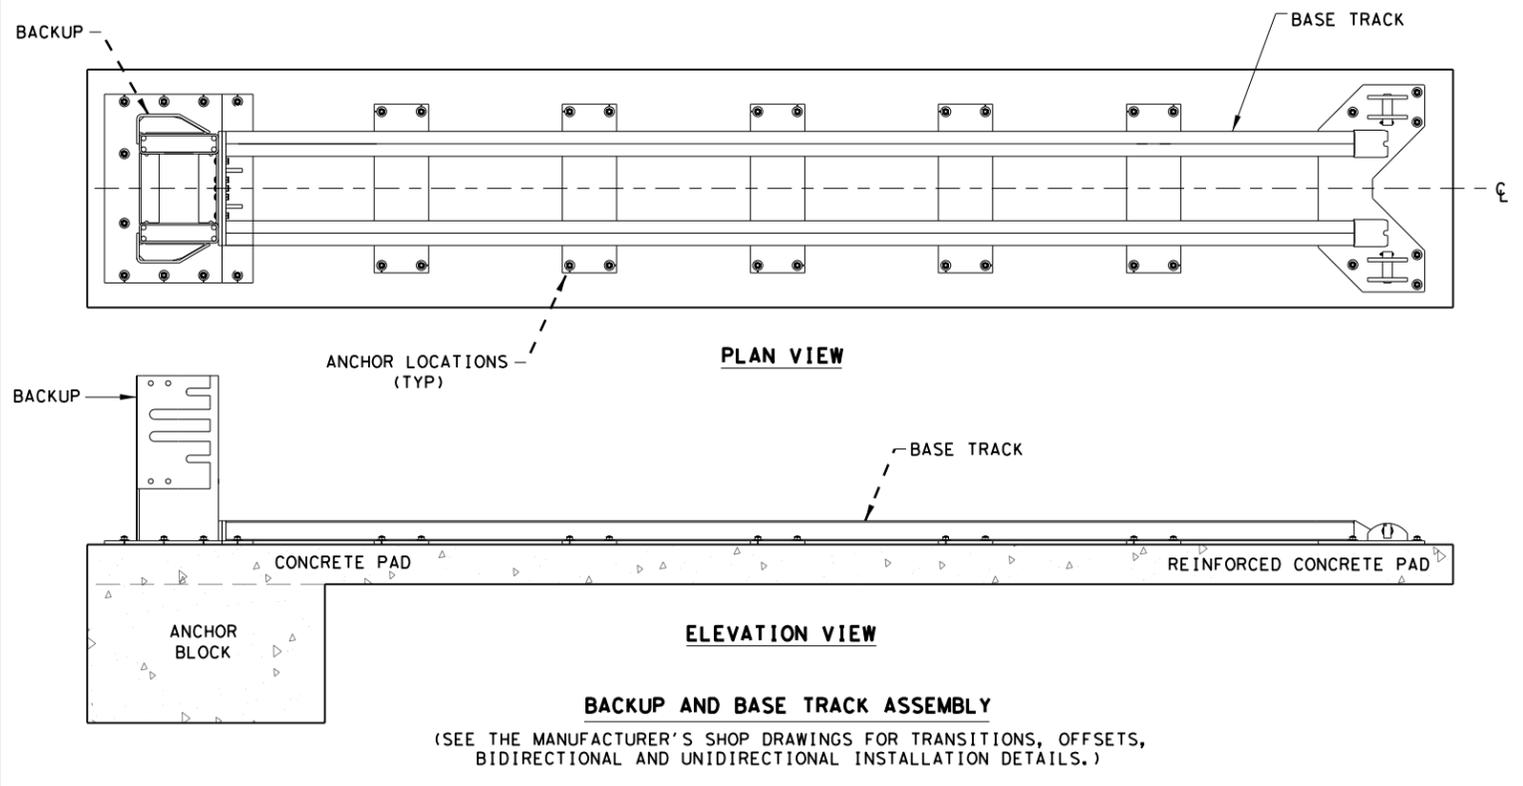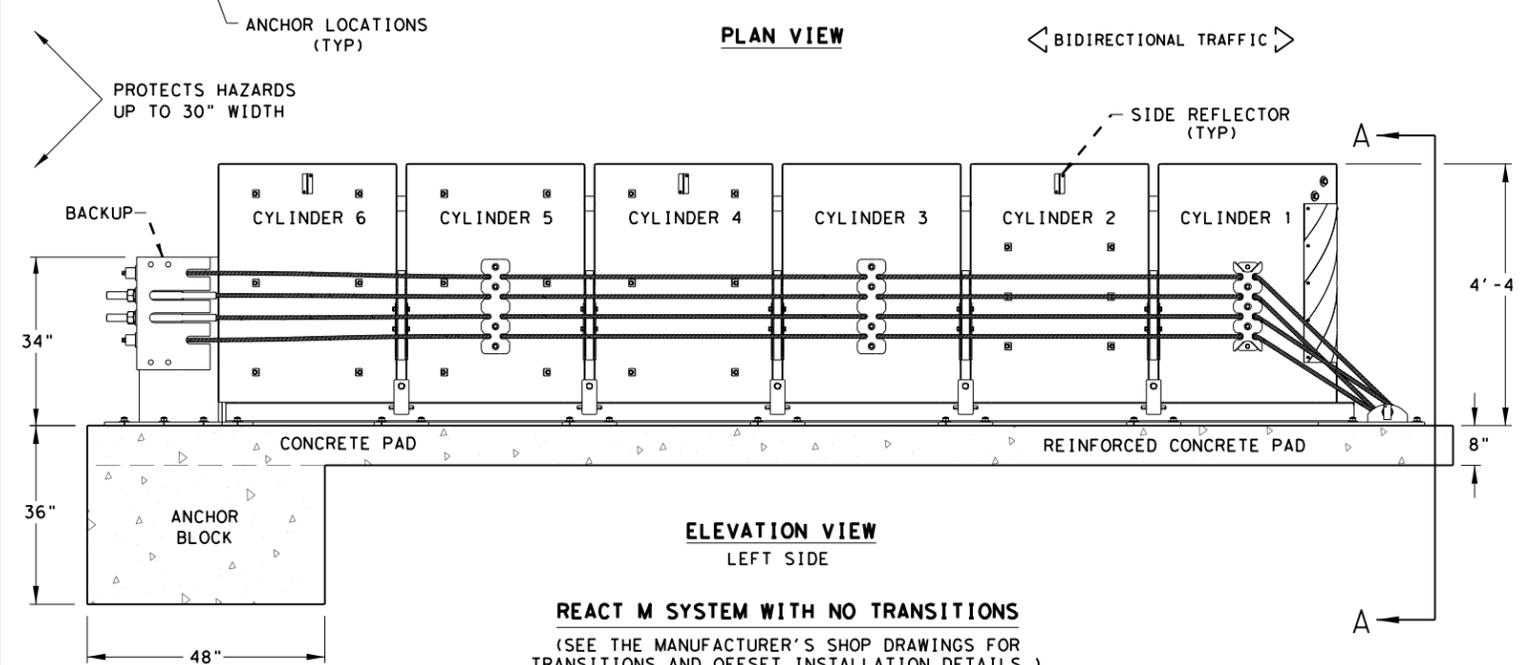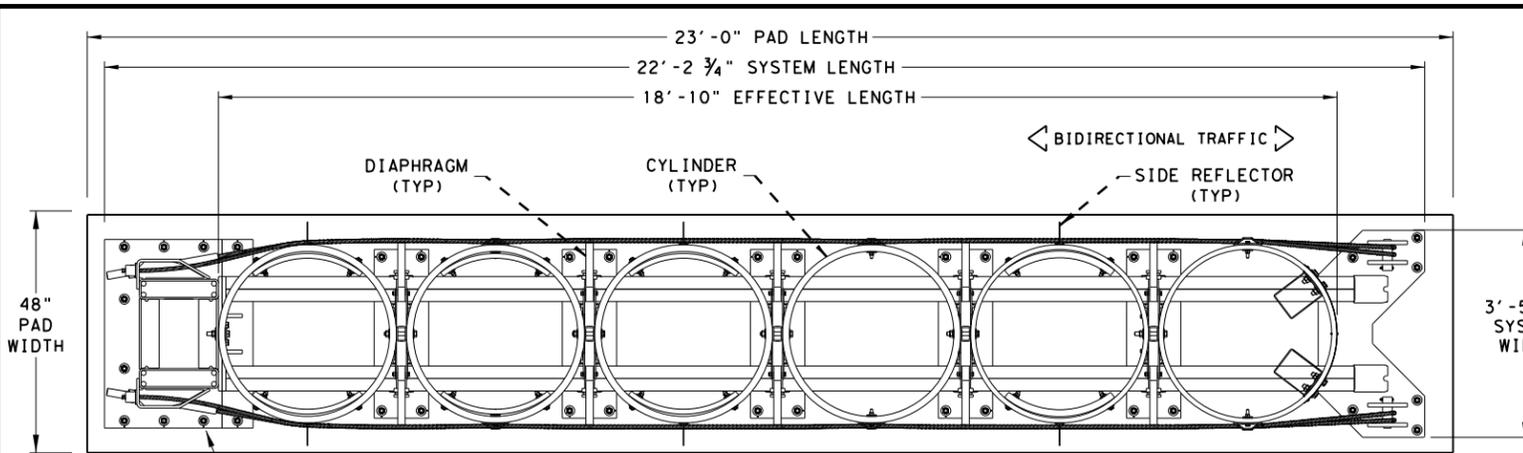

NOTES:  
CONTACT THE MANUFACTURER WITH SITE SPECIFIC DATA (SSD) FOR THE CORRECT BACKUP ASSEMBLY AND TRANSITION PANELS OR SIDE PANELS USED FOR STANDARD AND BI-DIRECTIONAL INSTALLATIONS: AT DIVIDED-HIGHWAY MEDIANS OR UNDIVIDED ROADWAYS WHERE THE SYSTEM IS EXPOSED TO IMPACTS FROM ONE OR TWO DIFFERENT DIRECTIONS OF TRAFFIC FLOW.

- GENERAL NOTES**
- FOR SPECIFIC INFORMATION REGARDING INSTALLATION AND TECHNICAL GUIDANCE OF THE SYSTEM, CONTACT: TRINITY HIGHWAY - ENERGY ABSORPTION AT 1(888)323-6374 OR WEBSITE: [www.trinityhighway.com](http://www.trinityhighway.com).
  - THE NOSE OF THE REACT M SHALL BE CLAD WITH A PLASTIC WRAP WITH STANDARD DELINEATION ADHERED TO THE WRAP AND SHALL HAVE A SERIES OF SIDE MARKER REFLECTORS ON BOTH SIDES OF THE UNIT. SEE SITE PLAN VIEWS FOR MARKER AND PLASTIC WRAP COLOR ORIENTATION.
  - FOR BI-DIRECTIONAL TRAFFIC, APPROPRIATE TRANSITION DETAILS WILL BE AS SHOWN ON THE MANUFACTURER'S SHOP DRAWINGS.
  - DETAILS OF COMPONENTS FOR THE REACT M, BACKUPS AND REINFORCING DETAILS WILL BE SHOWN ON THE MANUFACTURER'S SHOP DRAWINGS FURNISHED TO THE ENGINEER.
  - IF THE CROSS-SLOPE VARIES MORE THAN 2% OVER THE LENGTH OF THE SYSTEM, THE CONCRETE PAD WILL REQUIRE LEVELING. MAXIMUM PERMISSIBLE CROSS-SLOPE IS 8%.
  - THE INSTALLATION AREA SHOULD BE FREE FROM CURBS, ELEVATED OBJECTS, OR DEPRESSIONS.
  - THE REACT M SYSTEM SHOULD BE APPROXIMATELY PARALLEL WITH THE BARRIER OR CENTERLINE OF MERGING BARRIERS.
  - ALL STEEL COMPONENTS TO BE HOT DIPPED GALVANIZED EXCEPT STAKES, DRIVE SPIKES, THREADED BOLTS IN BACKUP UNIT, AND WEDGE FITTINGS ON CABLES.
  - THIS DRAWING REPRESENTS THE REACT M TL-3 SYSTEM, RE-DIRECTIVE, NON-GATING CRASH CUSHION THAT CAN PROTECT HAZARDS UP TO 30-INCHES IN WIDTH.

**DESIGN DATA TABLE FOR REACT M**

TEST NUMBER	TEST LEVEL	OVERALL LENGTH	TRANSITION LENGTH	SYSTEM WIDTH
3-30 to 3-36	TL-3	22'-2 3/4"	-	3'-5 3/4"
3-37A	TL-3	22'-2 3/4"	9'-10 3/4"	3'-5 3/4"
3-38	TL-3	22'-2 3/4"	-	3'-5 3/4"

**ANCHOR SYSTEM TYPE**

APPROVED ADHESIVE, 7" STUDS, 5.5" EMBEDMENT

**FOUNDATION TYPES**

MINIMUM 8" REINFORCED PORTLAND CEMENT CONCRETE PAD (REQUIRED REINFORCING STEEL FOR CONCRETE PAD SHALL BE SHOWN ON THE MANUFACTURER'S SHOP DRAWINGS.)

MINIMUM 8" NON-REINFORCED PORTLAND CEMENT CONCRETE ROADWAY MEASURING AT LEAST 12' WIDE BY 50' LONG)

MINIMUM 7" CONCRETE DECK STRUCTURE, OR MINIMUM 6" REINFORCED CONCRETE ROADWAY

NOTE:  
THIS STANDARD IS A BASIC REPRESENTATION OF THE REACT M SYSTEM AND IS NOT INTENDED TO REPLACE THE PRODUCT DESCRIPTION ASSEMBLY MANUAL.

Texas Department of Transportation  
Design Division Standard


**TRINITY HIGHWAY ENERGY ABSORPTION CRASH CUSHION REACT M (NARROW) (MASH TL-3) REACT (M) -21**

FILE: reactm21.dgn	DN: TxDOT	CK: KM	DW: SS	CK: CL
©TxDOT: JULY 2021	CONT	SECT	JOB	HIGHWAY
REVISIONS	0092	14	104	IH 45
	DIST	COUNTY	SHEET NO.	
	18	DALLAS	35	


**LOW MAINTENANCE**

DISCLAIMER: This standard is governed by the "Texas Engineering Practice Act". No warranty of any kind is made by TxDOT for any purpose whatsoever. TxDOT assumes no responsibility for the conversion of this standard to other formats or for incorrect results or damages resulting from its use.

DATE: 5/8/2023  
 FILE: c:\txdot\pw\_online\txdot5\solomon\_bayou\d0852788\sled19.dgn

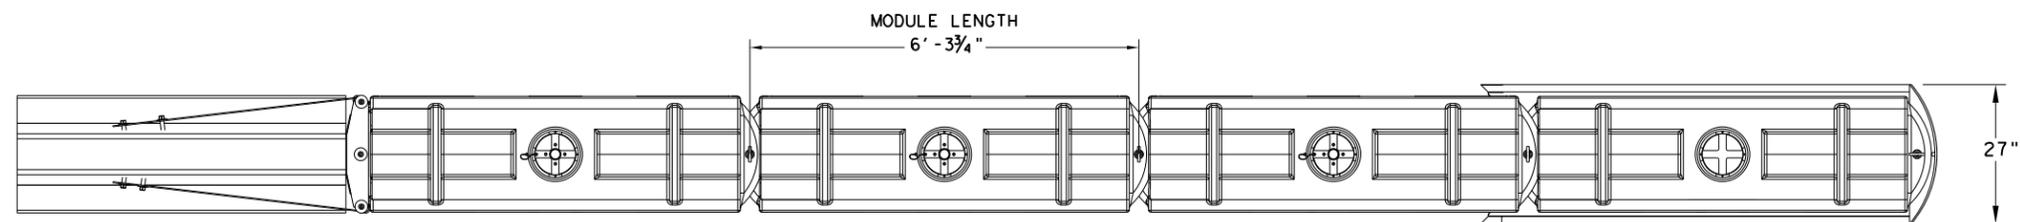


**PLAN VIEW**

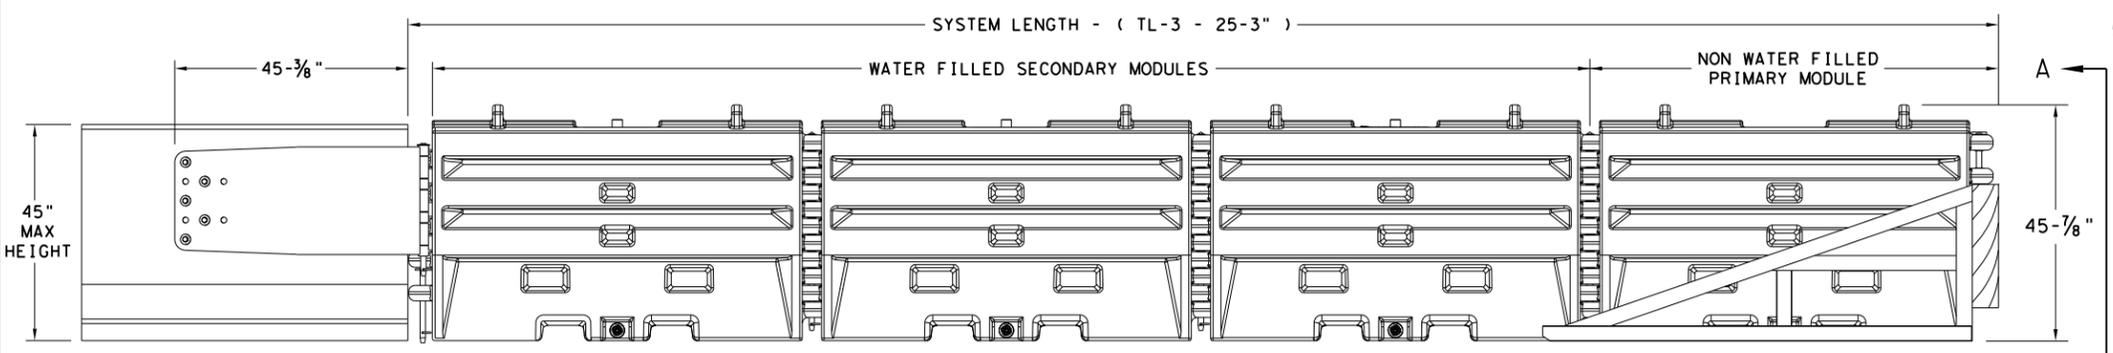


**ELEVATION VIEW**

**GENERAL NOTES**

1. REFER TO THE INSTALLATION MANUAL FOR SPECIFIC SYSTEM ASSEMBLY AND MODULE ORIENTATION. FOR ADDITIONAL INFORMATION, CONTACT TRAFFIX, INC. AT (949) 361-5663.
2. THE SLED SYSTEM IS A MASH APPROVED TEST LEVEL 3 (TL-3) CRASH CUSHION APPROVED FOR USE IN TEMPORARY WORK ZONES. THE SLED SYSTEM IS A NON-REDIRECTIVE, GATING CRASH CUSHION THAT DOES NOT NEED TO BE ATTACHED TO THE GROUND AND CAN BE INSTALLED ON CONCRETE, ASPHALT, GRAVEL OR COMPACTED SOIL.
3. MAXIMUM PERMISSIBLE CROSS SLOPE IS 8° (DEGREES) (14%).
4. THE INSTALLATION AREA SHOULD BE FREE FROM CURBS, ELEVATED OBJECTS, OR DEPRESSIONS.
5. THE SLED SYSTEM CAN BE ATTACHED TO:
  - CONCRETE BARRIER, TEMPORARY OR PERMANENT, 45" MAXIMUM HEIGHT
  - STEEL BARRIER
  - PLASTIC BARRIER
  - CONCRETE BRIDGE ABUTMENTS
  - W-BEAM GUARD RAIL
  - THRIE BEAM GUARD RAIL

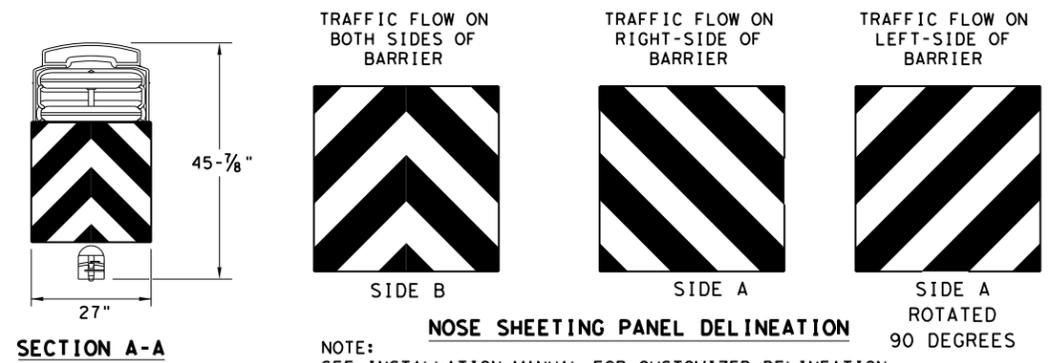

**SECTION A-A**

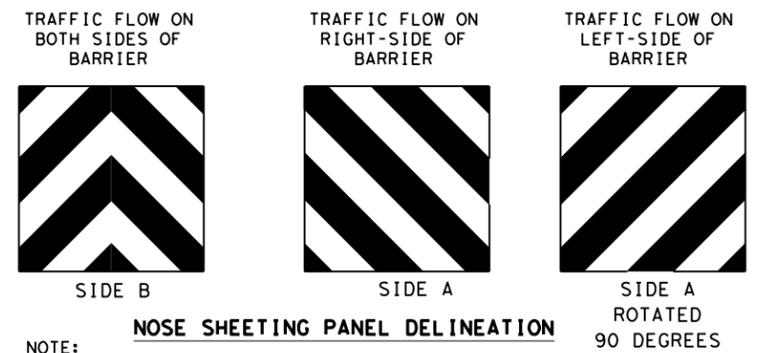


**NOSE SHEETING PANEL DELINEATION**

NOTE:  
SEE INSTALLATION MANUAL FOR CUSTOMIZED DELINEATION NOSE SHEETING FOR DECAL PLACEMENT.

TEST LEVEL	NUMBER OF SECONDARY MODULES	SYSTEM LENGTH
TL-3	3	25' 3"

BILL OF MATERIAL		
PART NUMBER	DESCRIPTION	QTY: TL-3
45131	TRANSITION FRAME, GALVANIZED	1
45150	TRANSITION PANEL, GALVANIZED	2
45147-CP	TRANSITION SHORT DROP PIN W/ KEEPER PIN, GALVANIZED	2
45148-CP	TRANSITION LONG DROP PIN W/ KEEPER PIN, GALVANIZED	1
45050	ANCHOR BOLTS	9
12060	WASHER, 3/4" ID X 2" OD	9
45044-Y	SLED YELLOW WATER FILLED MODULE	3
45044-YH	SLED YELLOW "NO FILL" MODULE	1
45044-S	CIS (CONTAINMENT IMPACT SLED), GALVANIZED	1
45043-CP	T-PIN W/ KEEPER PIN	4
18009-B-I	FILL CAP W/ "DRIVE BY" FLOAT INDICATOR	3
45033-RC-B	DRAIN PLUG	3
45032-DPT	DRAIN PLUG REMOVAL TOOL	1

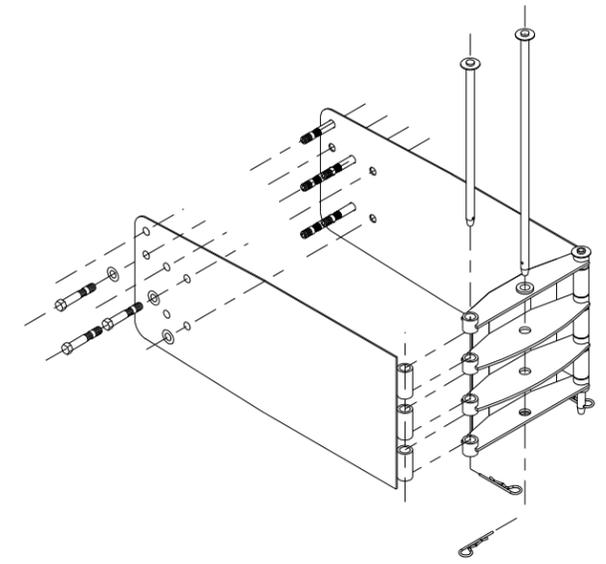

**SLED TRANSITION COMPONENTS FOR ATTACHMENT TO CMB**

NOTE:  
SEE MANUFACTURER'S INSTALLATION MANUAL FOR FURTHER DETAILS.

TRANSITION OPTIONS
SLED TRANSITION TO CONCRETE TRAFFIC BARRIER (TEMPORARY OR PERMANENT)
SLED TRANSITION TO STEEL TRAFFIC BARRIER (CONTACT MFGR FOR PROPER TRANSITION)
SLED TRANSITION TO PLASTIC TRAFFIC BARRIER (CONTACT MFGR FOR PROPER TRANSITION)
SLED TRANSITION TO W-BEAM OR THRIE BEAM GUARD RAIL (CONTACT MFGR FOR PROPER TRANSITION)
SLED TRANSITION TO CONCRETE BRIDGE ABUTMENT

NOTE:  
THIS STANDARD IS A BASIC REPRESENTATION OF THE SLED, IT IS NOT INTENDED TO REPLACE THE INSTALLATION INSTRUCTIONS MANUAL.

**SACRIFICIAL**





Design Division Standard

SLED  
 CRASH CUSHION  
 TL-3 MASH COMPLIANT  
 (TEMPORARY, WORK ZONE)  
 SLED-19




FILE: sled19.dgn	DN: TxDOT	CK: KM	DW: VP	CK:
© TxDOT: DECEMBER 2019	CONT	SECT	JOB	HIGHWAY
REVISIONS	0092	14	104	IH 45
	DIST	COUNTY	SHEET NO.	
	18	DALLAS	36	

DISCLAIMER: The use of this standard is governed by the "Texas Engineering Practice Act". No warranty of any kind is made by TxDOT for any purpose whatsoever. TxDOT assumes no responsibility for the conversion of this standard to other formats or for incorrect results or damages resulting from its use.

DATE: 5/8/2023 3:52:35 PM  
 FILE: c:\t\dot\p\_w\online\t\dot\5\solomon\_bayou\d0852788\crrstdel-19.dgn

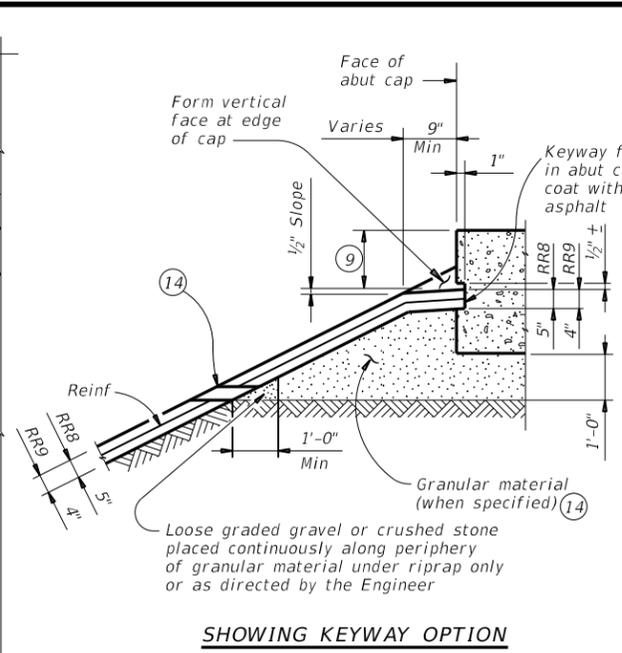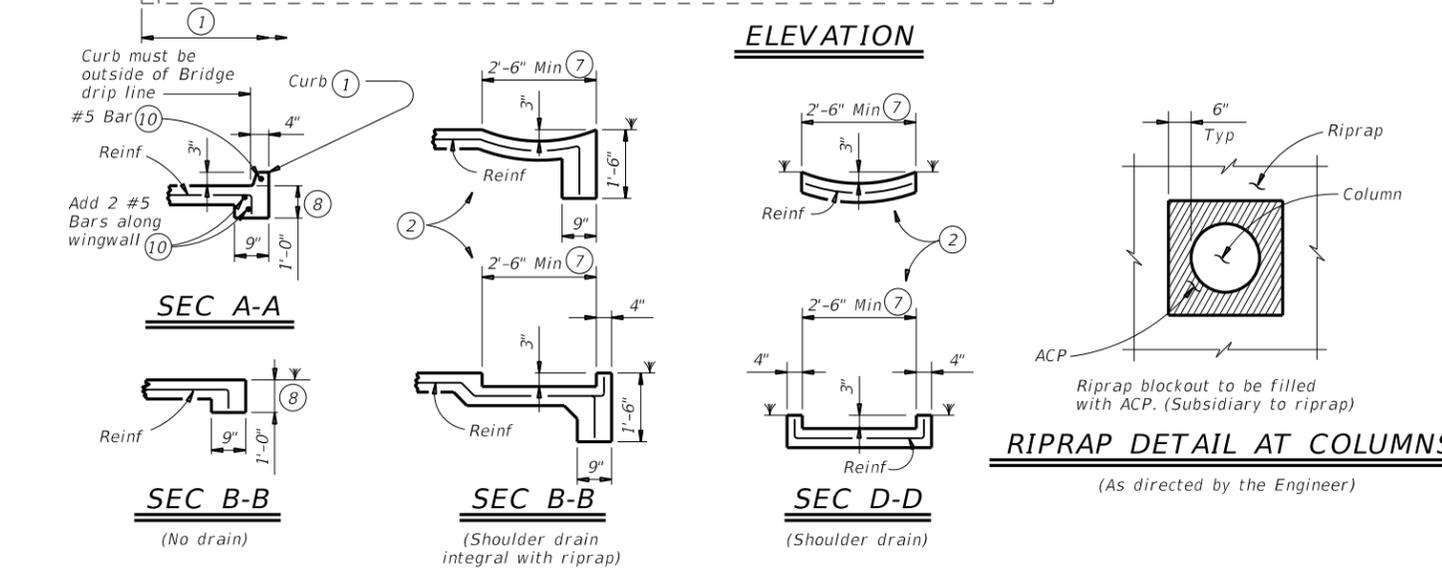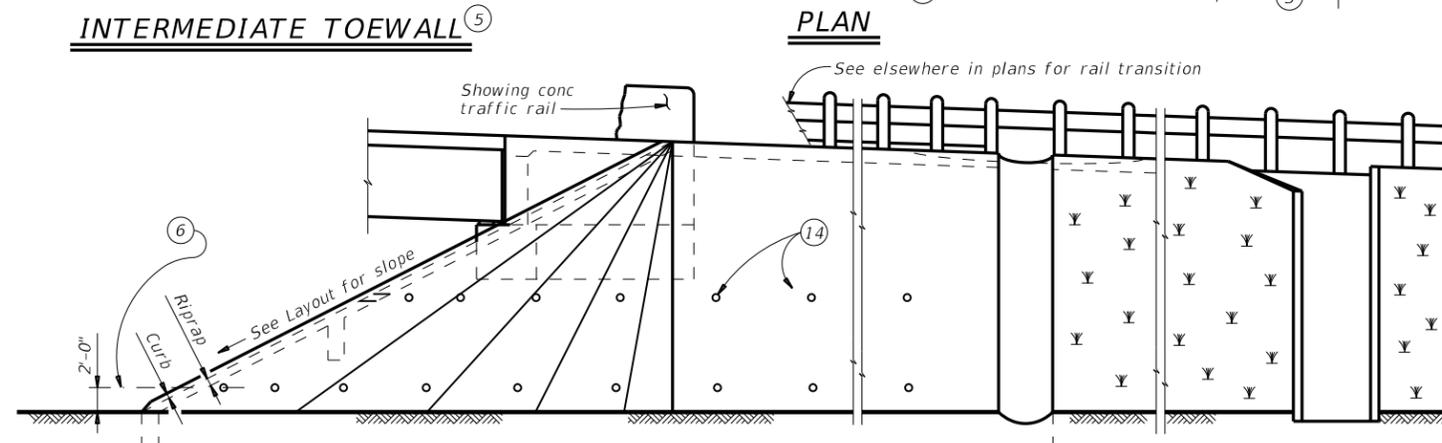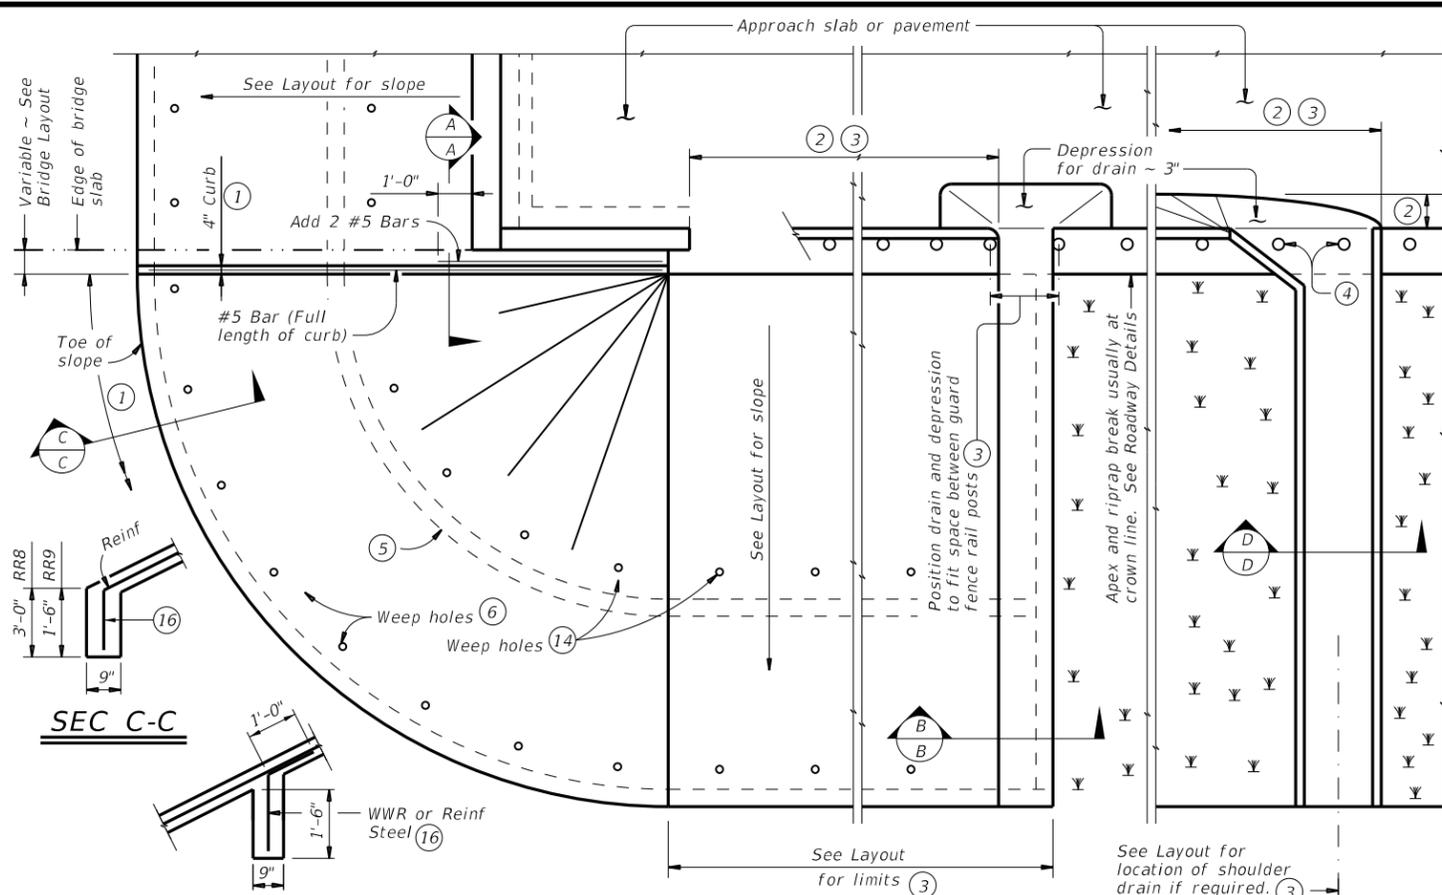

- SHOWING KEYWAY OPTION**
- When riprap is shown extended around header on layout, extend slab and toewall as shown and eliminate 4" curb.
  - Limits and configuration of drains and depressions are as shown elsewhere in plans or as directed by the Engineer.
  - Location of shoulder drain must consider limitations imposed by rail transition. Do not locate shoulder drains at expansion joints between approach slab and concrete pavement.
  - See details elsewhere in plans for installation of guard fence posts through concrete riprap.
  - Provide intermediate toewall only when designated elsewhere in the plans or included in the specifications.
  - Provide lower level of 2" Dia weep holes at 10' c-c backed by 1 CF packet of gravel and galvanized hardware cloth at all locations unless directed by the Engineer to eliminate.
  - Use wider or other drain configurations if shown elsewhere in plans or if directed by the Engineer.
  - Wall extension may be reduced or modified if approved by the Engineer. Increase wall extension to 1'-6" whenever the optional intermediate toewall is called for in the plans.
  - Top of cap to top of riprap dimension varies as directed by the Engineer. Should be 9" Min for beam/slab type bridges and 1'-6" for slab span, box beam, or slab beam bridges.
  - #5 bars shown are required even when synthetic fiber reinforcing option is selected.
  - Provide sealing option for joint between the face of cap and riprap as designated by the Engineer or as shown elsewhere on plans.
  - Flashing (shown in Cap Option A) may be used at wingwall in addition to Exp Jt Mat'l if shown on plans or directed by the Engineer.
  - Provide #3 reinforcing bars at 18" Spa c-c. Provide Welded Wire Reinforcement (WWR) as 6x6-D2.9xD2.9 or D3xD3. Combinations of WWR and reinforcing bars may be used if both are permitted. Use lap splices of a minimum 6 inches, measured from the transverse wire of WWR, and the ends of reinforcing bars.
  - If granular material is specified, provide upper level of 2" Dia weep holes at 10' c-c backed by galvanized hardware cloth.
  - 8" x 18 Gage Galv Sheet Metal
  - Provide WWR or #3 bars, with 1'-0" extension into slope.
  - WWR or reinforcing steel is continuous through riprap construction joints. Provide WWR or reinforcing steel that extends 1'-1" minimum into adjacent riprap on each side of construction joint even if synthetic reinforcing fiber is utilized.

 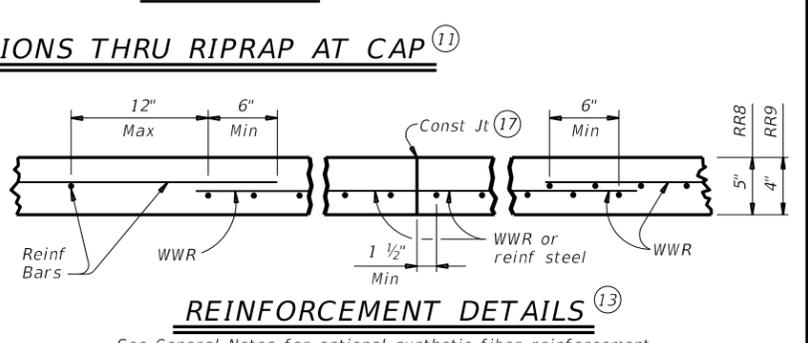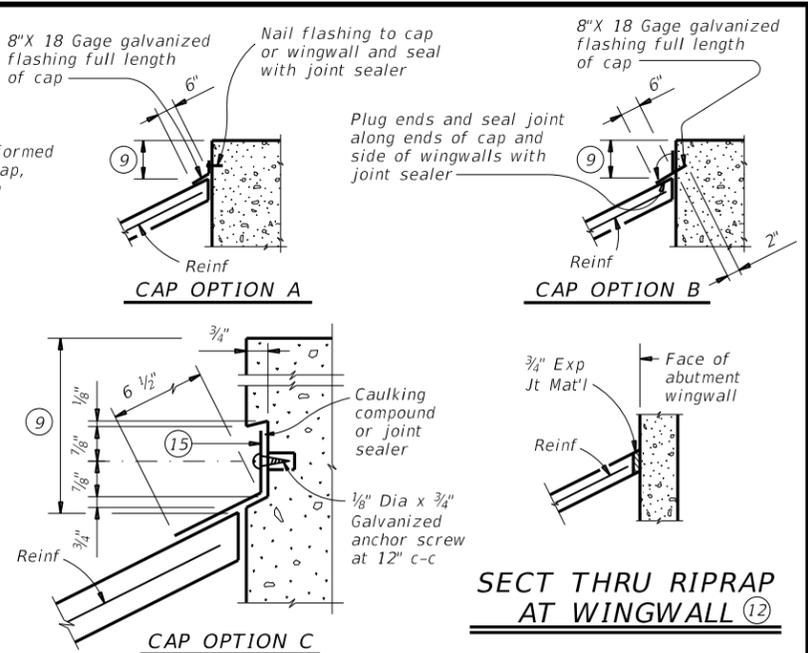

**REINFORCEMENT DETAILS**

See General Notes for optional synthetic fiber reinforcement.

**GENERAL NOTES:**  
 Provide Class "B" concrete (f'c = 2,000 psi) unless noted elsewhere in plans.  
 Provide Grade 60 reinforcing steel.  
 Provide deformed welded wire reinforcement (WWR) meeting ASTM A1064, unless otherwise shown.  
 Provide reinforcing bars, deformed WWR, or any suitable combination of both types for riprap reinforcing, unless specified elsewhere in the plans.  
 Optionally synthetic fibers may be used if approved by the Engineer. Provide synthetic fibers listed on the "Fibers for Concrete" Material Producer List (MPL) in lieu of steel reinforcing in riprap concrete.  
 Install construction joints or grooved joints extending the full slant slope height at intervals of approximately 20 feet unless otherwise directed by the Engineer.  
 Hardware cloth, loose grade stone behind weep holes, flashing, or other sealing material are subsidiary to the bid item "Riprap".  
 See Layout for limits of riprap.  
 RR8 is to be used on stream crossings.  
 RR9 is to be used on other embankments.

**RIPRAP DETAIL AT COLUMNS**  
 (As directed by the Engineer)

Riprap blockout to be filled with ACP. (Subsidiary to riprap)

**FOR CONTRACTOR'S INFORMATION ONLY:**  
 5" of RR8 = 0.015 CY/SF  
 4" of RR9 = 0.012 CY/SF  
 #3 Reinf at 18" c-c = 0.501 Lbs/SF  
 6x6-D3xD3 = 0.408 Lbs/SF

		<b>Bridge Division Standard</b>	
<b>CONCRETE RIPRAP AND SHOULDER DRAINS EMBANKMENTS AT BRIDGE ENDS (TYPES RR8 &amp; RR9)</b>			
<b>CRR</b>			
FILE: crrstdel-19.dgn	DN: TxDOT	CK: TxDOT	DW: TxDOT
©TxDOT April 2019	CONTRACT NO. 0092 14	SECTION NO. 104	HIGHWAY NO. IH 45
REVISIONS	DIST. NO. 18	COUNTY NO. DALLAS	SHEET NO. 37

DISCLAIMER: The use of this standard is governed by the "Texas Engineering Practice Act". No warranty of any kind is made by TxDOT for any purpose whatsoever. TxDOT assumes no responsibility for the conversion of this standard to other formats or for incorrect results or damages resulting from its use.

DATE: 5/8/2023 3:58:24 PM  
 FILE: c:\txdot\pw\_online\txdot5\solomon\_bayou\d0852788.dgn

REFLECTOR UNIT SIZES FOR DELINEATORS AND OBJECT MARKERS				DELINEATORS				D & OM DESCRIPTIVE CODES		
DEVICE	SIZE 1	SIZE 2	SIZE 3	SIZE 4	SINGLE		DOUBLE		INSTL DEL ASSM (D-XX)SZ X (XXXX)XXX(XX) NUMBER OF REFLECTORS S = Single D = Double COLOR OF REFLECTORS W = White Y = Yellow R = Red REFLECTOR UNIT SIZE 1 or 2 TYPE OF POST OR DELINEATOR WC = Wing Channel Post YFLX = Yellow Flexible Post WFLX = White Flexible Post BRF = Barrier Reflector TYPE OF MOUNT GND = Embedded (drivable or set in concrete) CTB = Concrete Barrier Mount GF1 or GF2 = Guard Fence Attachment SRF = Surface Mount DIRECTION If Required BI = Bi-Directional BR = Bi-Directional with red on back	
SHEETING	Yellow, White or Red Type B or C reflective sheeting				Yellow, White or Red Type B or C Reflective Sheeting					
NOTE	1. Size 1 and 4 - Direct applied reflective sheeting for use on flexible post (fix). 2. Size 2 and 3 - For use on wing channel (wc) post only. Use approved metal, plastic or fiberglass backplate with 17/64" mounting holes.				POST TYPE	WC	YFLX, WFLX	WC	YFLX, WFLX	INSTL OM ASSM (OM-XX) (XXXX)XXX(XX) TYPE OF OBJECT MARKER 1, 2, 3, or 4 NUMBER OF REFLECTORS OR DIRECTION X = 3-Size 2 reflector unit (Type 2 only) Y = 1-Size 3 reflector unit (Type 2 only) Z = 3-Size 1 or 1-Size 4 reflector unit(s) (Type 2 only) L = Left Side (Type 3 Object Marker only) R = Right Side (Type 3 Object Marker only) C = Center (Type 3 Object Marker only) TYPE OF POST WC = Wing Channel Post WFLX = White Flexible Post TWT = Thin Walled Tubing TYPE OF MOUNT GND = Embedded (drivable) SRF = Surface Mount WAS = Wedge Anchor Steel WAP = Wedge Anchor Plastic DIRECTION If Required BI = Bi-Directional
					MOUNT TYPE	GND	GND, SRF	GND	GND, SRF	

OBJECT MARKERS										
DEVICE	Type 1 (OM-1)		Type 2 (OM-2)			Type 3 (OM-3)			Type 4 (OM-4)	
	OM-1	OM-2X	OM-2Y	OM-2Z	OM-3L	OM-3R	OM-3C	OM-4		
	Yellow-Type B <sub>FL</sub> or C <sub>FL</sub> Sheeting		Yellow - Type B or C Sheeting			Alternating acrylic black and retroreflective yellow - Type B <sub>FL</sub> or C <sub>FL</sub> Sheeting			Red -Type B <sub>FL</sub> or C <sub>FL</sub> Sheeting	
SHEETING	TWT		WC	WC	WFLX	TWT			TWT	
POST TYPE	WAS, WAP		GND	GND	GND, SRF	WAS, WAP			WAS, WAP	
MOUNT TYPE										

DEPARTMENTAL MATERIAL SPECIFICATIONS	
FLEXIBLE DELINEATOR & OBJECT MARKER POSTS (EMBEDDED & SURFACE MOUNT TYPES)	DMS-4400
SIGN FACE MATERIALS	DMS-8300
DELINEATORS, OBJECT MARKERS AND BARRIER REFLECTORS	DMS-8600

BARRIER REFLECTORS (BRF)			CHEVRONS				ONE DIRECTION LARGE ARROW		NOTE: Delineator and object marker substrates and sign substrates shall be 0.080" Aluminum sign blank to conform to ASTM B-209 Alloy 6061-T6 or approved alternative.	
DEVICE	GF1	GF2	CTB	W1-8				W1-6		
	1. Barrier reflectors shall meet the requirements of DMS 8600. 2. Approved Barrier Reflectors are listed on the "Barrier Reflectors" Material Producer List at: www.txdot.gov.				1. CHEVRON (W1-8) signs and ONE DIRECTION LARGE ARROW (W1-6) Signs shall be installed per Sign Mounting Details (SMD) Standard Sheets and paid under Item 644 (Small Roadside Sign Assemblies). 2. When there is a need to increase conspicuity, the Texas version of the ONE DIRECTION LARGE ARROW sign (W1-9T) may be used instead of the ONE DIRECTION LARGE ARROW (W1-6).					
SHEETING	Yellow, White, Red									
NOTE	1. Reflective sheeting shall have a minimum dimension of 3 inches and minimum surface area of 9 square inches.									
SIZE (W x L)	18" x 24" (Conventional)		24" x 30" (Conventional Oversize)		30" x 36" (Expressway)		36" x 48" (Freeway)		48" x 24" (Conventional)	60" x 30" (Expressway & Freeway)
MOUNTING HEIGHT	4'-0" or 7'-0"			7'-0" Only		7'-0"				














### DELINEATOR & OBJECT MARKER MATERIAL DESCRIPTION

#### D & OM(1)-20

FILE: dom1-20.dgn	DN: TXDOT	CK: TXDOT	DW: TXDOT	CR: TXDOT
© TXDOT August 2004	CONT	SECT	JOB	HIGHWAY
REVISIONS	0092	14	104	IH 45
10-09 3-15	DIST	COUNTY	SHEET NO.	
4-10 7-20	18	DALLAS	38	

DISCLAIMER: The use of this standard is governed by the "Texas Engineering Practice Act". No warranty of any kind is made by TxDOT for any purpose whatsoever. TxDOT assumes no responsibility for the conversion of this standard to other formats or for incorrect results or damages resulting from its use.

DATE: 5/8/2023 3:58:41 PM  
 FILE: c:\txdot\pw\_online\txdot5\solomon\_bayou\d0852788\_dom2-20.dgn

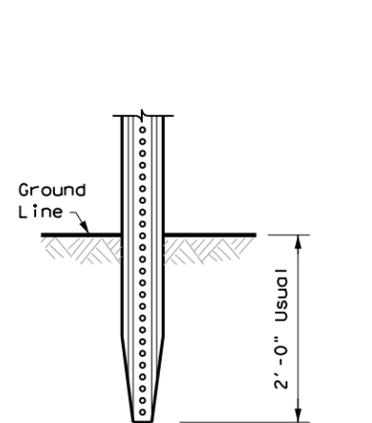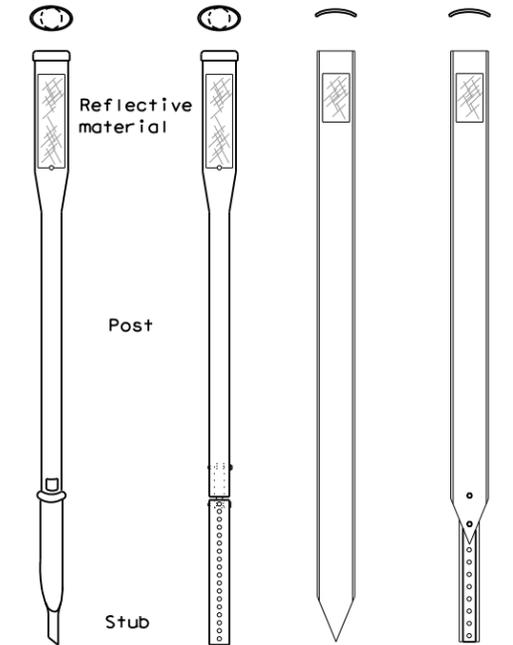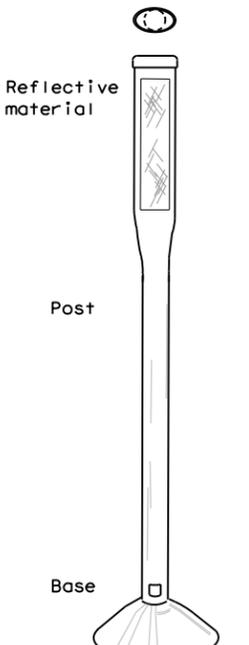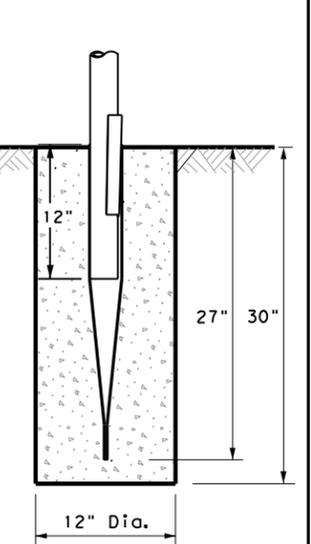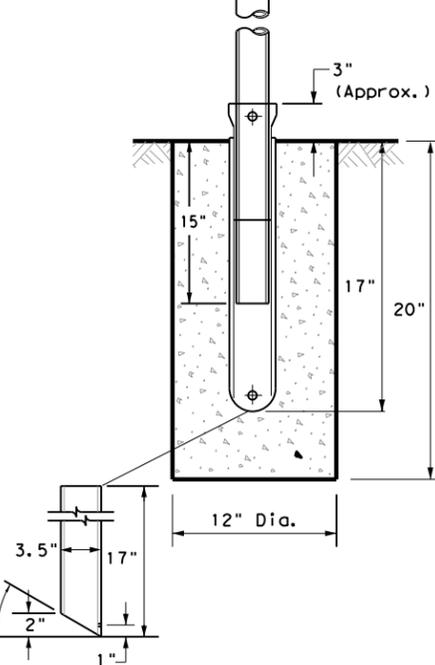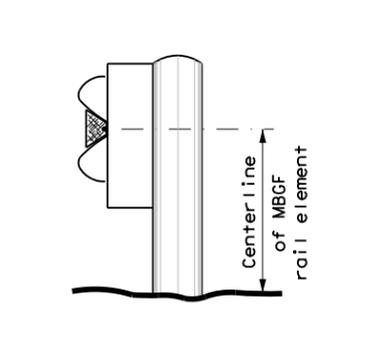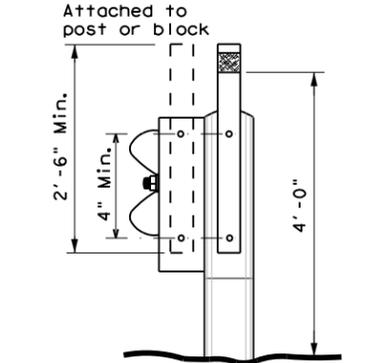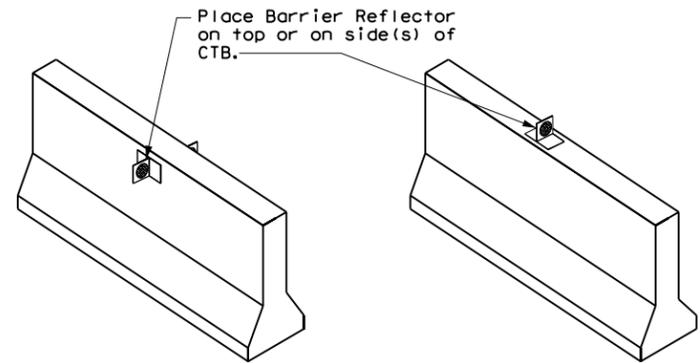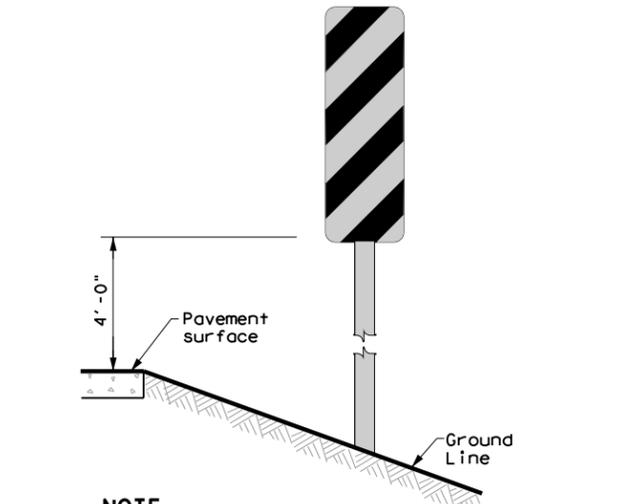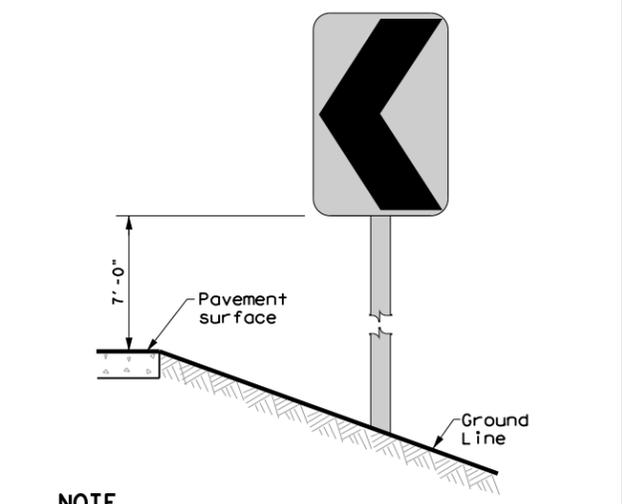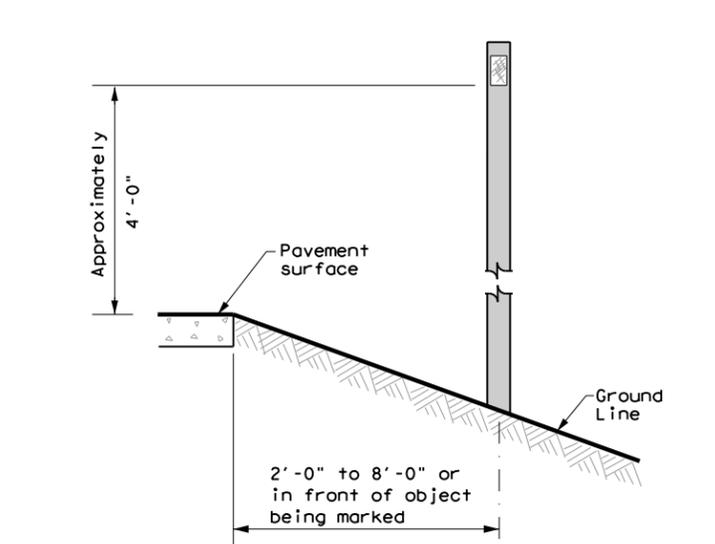POST TYPE AND SUPPORT FOUNDATION DETAILS				TYPE OF BARRIER MOUNTS		
WING CHANNEL (WC)	FLEXIBLE POSTS (YFLX, WFLX)		WEDGE ANCHOR SYSTEMS		GUARD FENCE ATTACHMENT	
GND	GND	SRF	WAS	WAP	GF 1	
 <p style="text-align: center;">2'-0" Usual</p>	 <p style="text-align: center;">Reflective material</p> <p style="text-align: center;">Post</p> <p style="text-align: center;">Stub</p>	 <p style="text-align: center;">Reflective material</p> <p style="text-align: center;">Post</p> <p style="text-align: center;">Base</p>	 <p style="text-align: center;">12" Dia.</p> <p style="text-align: center;">27" 30"</p>	 <p style="text-align: center;">3" (Approx.)</p> <p style="text-align: center;">15" 17" 20"</p> <p style="text-align: center;">12" Dia.</p> <p style="text-align: center;">3.5" 17" 30° 2" 1"</p>	 <p style="text-align: center;">Centerline of MBCF rail element</p>	 <p style="text-align: center;">Attached to post or block</p> <p style="text-align: center;">2'-6" Min.</p> <p style="text-align: center;">4" Min.</p> <p style="text-align: center;">4'-0"</p>
	EMBEDDED	SURFACE MOUNT	STEEL	PLASTIC	CONCRETE TRAFFIC BARRIER (CTB)	
<p><b>NOTES</b></p> <ol style="list-style-type: none"> <li>1. Embedded Wing Channel (WC) post option may be used for Type 2 Object Markers and Delineators only.</li> <li>2. 1.12 lbs/ft steel per ASTM A 1011 SS Gr. 50, or ASTM A499.</li> </ol>			<p><b>NOTE</b></p> <ol style="list-style-type: none"> <li>1. Install per manufacturer's recommendations.</li> </ol>		 <p style="text-align: center;">Place Barrier Reflector on top or on side(s) of CTB.</p>	
<p><b>NOTES</b></p> <ol style="list-style-type: none"> <li>1. See "Flexible Delineator and Object Marker Posts" Material Producer List for approved devices.</li> <li>2. Install per manufacturer's recommendations.</li> <li>3. Post length may vary to meet field conditions.</li> <li>4. When using yellow delineators with flexible posts to separate opposing direction of travel, such as centerline or median use, the flexible posts shall be yellow.</li> </ol>			<p><b>GENERAL NOTES</b></p> <ol style="list-style-type: none"> <li>1. Place delineators on a section of roadway at a consistent distance from the edge of pavement.</li> <li>2. Where a restriction prevents consistent placement from the pavement edge, place the affected object markers in line with the innermost edge of the obstruction.</li> <li>3. When Type 2 object markers and delineators are more than 8'-0" from the edge of the pavement, it may not be possible to maintain a height of approximately 4'-0". If this is the case, place the object marker or delineator as close to the desired height as possible.</li> <li>4. Install all delineators, object markers and barrier reflectors in accordance with the manufacturer's recommendation.</li> <li>5. Barrier reflectors should be installed a minimum of 18 inches above the edge of the pavement surface.</li> <li>6. Diagonal stripes on Type 3 object markers shall slope down toward the intended travel lane.</li> </ol>			
TYPES 1,3, AND 4 OBJECT MARKERS AND CHEVRONS		CHEVRONS AND ONE DIRECTION LARGE ARROW SIGN		DELINEATORS AND TYPE 2 OBJECT MARKERS		
 <p style="text-align: center;">4'-0"</p> <p style="text-align: center;">Pavement surface</p> <p style="text-align: center;">Ground Line</p>		 <p style="text-align: center;">7'-0"</p> <p style="text-align: center;">Pavement surface</p> <p style="text-align: center;">Ground Line</p>		 <p style="text-align: center;">Approximately 4'-0"</p> <p style="text-align: center;">Pavement surface</p> <p style="text-align: center;">Ground Line</p> <p style="text-align: center;">2'-0" to 8'-0" or in front of object being marked</p>		
<p><b>NOTE</b></p> <p>Mounting at 4 feet to the bottom of the chevron is permitted for chevrons that will not exceed a height of 6'-6" to the top of the chevron (sizes 24" x 30" and smaller)</p>		<p><b>NOTE</b></p> <p>Chevrons 30" x 36" and larger shall be mounted at a height of 7' to the bottom of the chevron. Chevron sign and ONE DIRECTION LARGE ARROW sign (W1-9T) shall be installed per SMD standard sheets and paid under item 644.</p>		<p>See general notes 1, 2 and 3.</p>		



Traffic Safety Division Standard

## DELINEATOR & OBJECT MARKER INSTALLATION

### D & OM(2)-20

FILE: dom2-20.dgn	DN: TXDOT	CK: TXDOT	DW: TXDOT	CK: TXDOT
© TXDOT August 2004	CONT	SECT	JOB	HIGHWAY
REVISIONS	0092	14	104	IH 45
10-09 3-15	DIST	COUNTY	SHEET NO.	
4-10 7-20	18	DALLAS	39	

**DISCLAIMER:**  
 The use of this standard is governed by the "Texas Engineering Practice Act".  
 No warranty of any kind is made by TxDOT for any purpose whatsoever.  
 TxDOT assumes no responsibility for the conversion of this standard to other  
 formats or for incorrect results or damage resulting from its use.

**Notes To Designer:**  
 1. Do not alter Sheet Design or Font style, size or weight - match text attributes.  
 2. If additional space is needed for a numbered section, fence and adjust sections up or down  
 as needed for proportioning and readability but do not relocate from its relative position.  
 3. All areas should be addressed thoroughly and verify the necessary pay items are set up to  
 support actions needed.  
 Filled Out: XX/XX/XXXX  
 Prepared By: Name/Section

**I. STORMWATER POLLUTION PREVENTION PLAN-CLEAN WATER ACT SECTION 402**

TPDES TXR 150000: Stormwater Discharge Permit or Construction General Permit required for projects with 1 or more acres disturbed soil. Projects with any disturbed soil must protect for erosion and sedimentation in accordance with Item 506.  
 List adjacent MS 4 Operator(s) that receive discharges from this project. They need to be notified prior to construction activities.  
 (Note: Leave blank only if no adjacent MS 4 Operator(s) are affected.)

1. City of Dallas Phase II MS4 - Contact Kevin Hurley
- 2.

No Action Required       Required Action

Action Number:

1. Prevent stormwater pollution by controlling erosion and sedimentation in accordance with TPDES Permit TXR 150000.
2. Comply with the SW3P and revise when necessary to control pollution or required by the Engineer.
3. Post Construction Site Notice (CSN) with SW3P information on or near the site, accessible to the public and TCEQ, EPA or other inspectors.
4. When Contractor project specific locations (PSL's) increase disturbed soil area to 5 acres or more, submit NOI to TCEQ and the Engineer.

**II. WORK IN OR NEAR STREAMS, WATERBODIES AND WETLANDS CLEAN WATER ACT SECTIONS 401 AND 404**

USACE Permit required for filling, dredging, excavating or other work in any water bodies, rivers, creeks, streams, wetlands or wet areas. No equipment is allowed in any stream channel below the ordinary High Water Mark except on approved temporary stream crossings or drill pads.

The Contractor must adhere to all of the terms and conditions associated with the following permit(s):

- No Permit Required
- Nationwide Permit 14 - PCN not Required (less than 1/10th acre waters or wetlands affected)
- Nationwide Permit 14 - PCN Required (1/10 to <1/2 acre, 1/3 in tidal waters)
- Individual 404 Permit Required
- Other Nationwide Permit Required: NWP# 3(a)

Required Actions: List Waters of the US Permit applies to, location in project and check Best Management Practices planned to control erosion, sedimentation and post-project TSS.

- 1.
- 2.
- 3.

The elevation of the ordinary high water marks of any areas requiring work to be performed in the waters of the US requiring the use of a nationwide permit can be found on the Bridge Layouts.

Best Management Practices for applicable 401 General Conditions:  
 (Note: If CORP Permit not required, do not check boxes.)

Erosion	Sedimentation	Post-Construction TSS
<input type="checkbox"/> Temporary Vegetation	<input type="checkbox"/> Silt Fence	<input type="checkbox"/> Vegetative Filter Strips
<input type="checkbox"/> Blankets/Matting	<input type="checkbox"/> Rock Berm	<input type="checkbox"/> Retention/Irrigation Systems
<input type="checkbox"/> Mulch	<input type="checkbox"/> Triangular Filter Dike	<input type="checkbox"/> Extended Detention Basin
<input type="checkbox"/> Sodding	<input type="checkbox"/> Sand Bag Berm	<input type="checkbox"/> Constructed Wetlands
<input type="checkbox"/> Interceptor Swale	<input type="checkbox"/> Straw Bale Dike	<input type="checkbox"/> Wet Basin
<input type="checkbox"/> Diversion Dike	<input type="checkbox"/> Brush Berms	<input type="checkbox"/> Erosion Control Compost
<input type="checkbox"/> Erosion Control Compost	<input type="checkbox"/> Erosion Control Compost	<input type="checkbox"/> Mulch Filter Berm and Socks
<input type="checkbox"/> Mulch Filter Berm and Socks	<input type="checkbox"/> Mulch Filter Berm and Socks	<input type="checkbox"/> Compost Filter Berm and Socks
<input type="checkbox"/> Compost Filter Berm and Socks	<input type="checkbox"/> Compost Filter Berm and Socks	<input type="checkbox"/> Vegetation Lined Ditches
	<input type="checkbox"/> Stone Outlet Sediment Traps	<input type="checkbox"/> Sand Filter Systems
	<input type="checkbox"/> Sediment Basins	<input type="checkbox"/> Grassy Swales

**III. CULTURAL RESOURCES**

Refer to TxDOT Standard Specifications in the event historical issues or archeological artifacts are found during construction. Upon discovery of archeological artifacts (bones, burnt rock, flint, pottery, etc.) cease work in the immediate area and contact the Engineer immediately.

No Action Required       Required Action

Action Number:

- 1.

**IV. VEGETATION RESOURCES**

Preserve native vegetation to the extent practical. Contractor must adhere to Construction Specification Requirements Specs 162, 164, 192, 193, 506, 730, 751 & 752 in order to comply with requirements for invasive species, beneficial landscaping and tree/brush removal commitments.

No Action Required       Required Action

Action Number:

- 1.

**V. FEDERAL LISTED, PROPOSED THREATENED, ENDANGERED SPECIES, CRITICAL HABITAT, STATE LISTED SPECIES, CANDIDATE SPECIES AND MIGRATORY BIRDS TREATY ACT.**

No Action Required       Required Action

Action Number:

1. The following species could occur in the project area: Monarch butterfly, Woodhouse's toad, American bumblebee, slender glass lizard, and Texas garter snake. Follow the special note on the EPIC sheet and the BMPs listed below to protect these species.

2. Contractor to implement the following BMPs from "Beneficial Management Practices: Avoiding, Minimizing, and Mitigating Impacts of Transportation Projects on State Natural Resources" available at <https://ftp.txdot.gov/pub/txdot-info/env/toolkit/300-01-bmp.pdf>.
  - a. Section 2.6.1 Aquatic Amphibian and Reptile BMP (barrier fencing not required)
  - b. Section 2.6.2 Terrestrial Amphibian and Reptile BMP
  - c. Section 2.4.4 Insect Pollinator BMP
  - d. Section 1.4 Water Quality BMP
  - e. Section 1.2 Vegetation BMP

**Special Notes:**

1. Avoid harming all wildlife species if encountered and allow them to safely leave the project site. Due diligence should be used to avoid killing or harming any wildlife species in the implementation of transportation projects.
2. If any of the listed species are observed, cease work in the immediate area, do not disturb species or habitat and contact the Engineer immediately. The work may not remove active nests from bridges and other structures during nesting season of the birds associated with the nests. If caves or sinkholes are discovered, cease work in the immediated area, and contact the Engineer immediately.
3. The Migratory Bird Act of 1918 states that it is unlawful to kill, capture, collect, possess, buy, sell, trade or transport any migratory bird, nest, young, feather or egg in part or in whole, without a federal permit issued in accordance within the Act's policies and regulations. The contractor would remove all old migratory bird nests from any structure or trees where work would be done from October 1 to February 15. In addition, the contractor would be prepared to prevent migratory birds from building nest(s) between February 15 to October 1. In the event that migratory birds are encountered on-site during project construction, efforts to avoid adverse impacts on protected birds, active nests, eggs and/or young would be observed.

**LIST OF ABBREVIATIONS**

BMP: Best Management Practice	SPCC: Spill Prevention Control and Countermeasure
CGP: Construction General Permit	SW3P: Storm Water Pollution Prevention Plan
DSHS: Texas Department of State Health Services	PCN: Pre-Construction Notification
FHWA: Federal Highway Administration	PSL: Project Specific Location
MOA: Memorandum of Agreement	TCEQ: Texas Commission on Environmental Quality
MOU: Memorandum of Understanding	TPDES: Texas Pollutant Discharge Elimination System
MS4: Municipal Separate Stormwater Sewer System	TPWD: Texas Parks and Wildlife Department
MBTA: Migratory Bird Treaty Act	TxDOT: Texas Department of Transportation
NOT: Notice of Termination	T&E: Threatened and Endangered Species
NWP: Nationwide Permit	USACE: U.S. Army Corp of Engineers
NOI: Notice of Intent	USFWS: U.S. Fish and Wildlife Service

**VI. HAZARDOUS MATERIALS OR CONTAMINATION ISSUES**

General (applies to all projects):  
 Comply with the Hazard Communication Act (the Act) for personnel who will be working with hazardous materials by conducting safety meetings prior to beginning construction and making workers aware of potential hazards in the workplace. Ensure that all workers are provided with personal protective equipment appropriate for any hazardous materials used. Obtain and keep on-site Safety Data Sheets (SDS) for all hazardous products used on the project, which may include, but are not limited to the following categories: Paints, acids, solvents, asphalt products, chemical additives, fuels and concrete curing compounds or additives. Provide protected storage, off bare ground and covered, for products which may be hazardous. Maintain product labelling as required by the Act. Maintain an adequate supply of on-site spill response materials, as indicated in the SDS. In the event of a spill, take actions to mitigate the spill as indicated in the SDS, in accordance with safe work practices, and contact the District Spill Coordinator immediately. The Contractor shall be responsible for the proper containment and cleanup of all product spills.

Contact the Engineer if any of the following are detected:

- \* Dead or distressed vegetation (not identified as normal)
- \* Trash piles, drums, canisters, barrels, etc.
- \* Undesirable smells or odors
- \* Evidence of leaching or seepage of substances

Does the project involve any bridge class structure rehabilitation(s) or replacement(s) (bridge class structures not including box culverts)?

Yes       No

If "No", then no further action is required.  
 If "Yes", then TxDOT is responsible for completing asbestos assessment/inspection.

Are the results of the asbestos inspection positive (is asbestos present)?

Yes       No

If "Yes", then TxDOT must retain a DSHS licensed asbestos consultant to assist with the notification, develop abatement/mitigation procedures, and perform management activities as necessary. The notification form to DSHS must be postmarked at least 15 working days prior to scheduled demolition.

If "No", then TxDOT is still required to notify DSHS 15 working days prior to any scheduled demolition.

In either case, the Contractor is responsible for providing the date(s) for abatement activities and/or demolition with careful coordination between the Engineer and asbestos consultant in order to minimize construction delays and subsequent claims.

Any other evidence indicating possible hazardous materials or contamination discovered on site. Hazardous Materials or Contamination Issues Specific to this Project:

No Action Required       Required Action

Action Number:

- 1.
- 2.
- 3.

**VII. OTHER ENVIRONMENTAL ISSUES**

(includes regional issues such as Edwards Aquifer District, etc.)

No Action Required       Required Action

Action Number:

- 1.



**ENVIRONMENTAL PERMITS, ISSUES AND COMMITMENTS (EPIC)**

FED. RD. DIV. NO.	PROJECT NO.		HIGHWAY NO.
6	SEE TITLE SHEET		IH 45
STATE	DISTRICT	COUNTY	
TEXAS	DALLAS	DALLAS	SHEET NO.
CONTROL	SECTION	JOB	
0092	14	104	40

**GENERAL NOTE:**

Any change orders and/or deviations from the final design must be reported to the Engineer prior to commencement of construction activities, as additional environmental clearance may be required.

**STORMWATER POLLUTION PREVENTION PLAN (SWP3):**

This SWP3 has been developed in accordance with the TPDES Construction General Permit TXR150000 (CGP). The Texas Department of Transportation (TxDOT) ensures that project specifications include adequate best management practices (BMPs) for this project.

For all projects with any soil disturbing activities, TxDOT will maintain a SWP3 with all pertinent records, correspondence, environmental documents, etc. at the project field office. If no field office is available, then this SWP3 shall be kept in the appropriate TxDOT Area Office.

This SWP3 is consistent with requirements specified in applicable stormwater plans and the projects environmental permits, issues, and commitments (EPICs). A copy of the CGP is included in Attachment 2.12 of the SWP3 binder.

**1.0 SITE/PROJECT DESCRIPTION**

**1.1 PROJECT CONTROL SECTION JOB (CSJ):**

CSJ: 0092-14-104, IH 45

**1.2 PROJECT LIMITS:**

IH 45, From OVERTON RD to IH 20

**1.3 PROJECT COORDINATES:**

BEGIN: (Lat) 32.6617419,(Long) -96.7265418

END: (Lat)32.7243295,(Long) -96.7621314

**1.4 TOTAL PROJECT AREA (Acres): 82.4**

**1.5 TOTAL AREA TO BE DISTURBED (Acres): 3.13**

**1.6 NATURE OF CONSTRUCTION ACTIVITY:**

ADD COCNRETE BARRIER

**1.7 MAJOR SOIL TYPES:**

Soil Type	Description
Austin silty clay, 1% to 3% slopes	100% silty clay, well drained high rate of runoff
Frio silty clay, 0% to 1% slopes	100% silty clay, well drained Medium rate of runoff
Houston Black-Urban land complex, 0% to 4% slopes	100% clay Moderately well drained very high rate of runoff
Eddy clay loam, 3% to 8% slopes	100% clay loam, well drained Medium rate of runoff

**1.8 PROJECT SPECIFIC LOCATIONS (PSLs):**

PSLs must be depicted on the Environmental Layout Sheets in Attachment 1.2 of this SWP3. PSLs may be identified during preconstruction meetings or during the construction process. Please choose from the options below:

- PSLs determined during preconstruction meeting
- PSLs determined during construction
- No PSLs planned for construction

Type	Sheet #s

All off-ROW PSLs required by the Contractor are the Contractor's responsibility. The Contractor shall secure all permits required by local, state, federal laws for off-ROW PSLs. The contractor shall provide diagrams, areas of disturbance, acreage, and BMPs for all off-ROW PSLs within one mile of the project.

**1.9 CONSTRUCTION ACTIVITIES:**

(Use the following list as a starting point when developing the Construction Activity Schedule and Ceasing Record in Attachment 2.5.)

- Mobilization
- Install sediment and erosion controls
  - Blade existing topsoil into windrows, prep ROW, clear and grub
  - Remove existing pavement
  - Grading operations, excavation, and embankment
  - Excavate and prepare subgrade for proposed pavement widening
  - Remove existing culverts, safety end treatments (SETs)
- Remove existing metal beam guard fence (MBGF), bridge rail
  - Install proposed pavement per plans
  - Install culverts, culvert extensions, SETs
- Install mow strip, MBGF, bridge rail
  - Place flex base
  - Rework slopes, grade ditches
  - Blade windrowed material back across slopes
  - Revegetation of unpaved areas
- Achieve site stabilization and remove sediment and erosion control measures
  - Other: \_\_\_\_\_
  - Other: \_\_\_\_\_
  - Other: \_\_\_\_\_

**1.10 POTENTIAL POLLUTANTS AND SOURCES:**

- Sediment laden stormwater from stormwater conveyance over disturbed area
- Fuels, oils, and lubricants from construction vehicles, equipment, and storage
- Solvents, paints, adhesives, etc. from various construction activities
  - Transported soils from offsite vehicle tracking
- Construction debris and waste from various construction activities
  - Contaminated water from excavation or dewatering pump-out water
- Sanitary waste from onsite restroom facilities
- Trash from various construction activities/receptacles
  - Long-term stockpiles of material and waste
- Other: CONCRETE: TRUCK LOAD, PUMING, CONCRETE WASH OUT
  - Other: \_\_\_\_\_
  - Other: \_\_\_\_\_

**1.11 RECEIVING WATERS:**

Receiving waters must be depicted on the Environmental Layout Sheets in Attachment 1.2 of this SWP3. Include Segment # for receiving waters.

Tributaries	Classified Waterbody
Tributaries To Upper Trinity River (Honey Springs Branch)	0805 Upper Trinity River Dioxin and PCBs n edible tissue
Tributaries To Five mile creek (Newton creek, whites branch, and floyed branch)	0805 Upper Trinity River Dioxin and PCBs n edible tissue
[*Segements 0805, 0819 and 08411 are impaired by Bacteria in water (Recreation use) Segment 0805 is also impaired by Dioxin and PCBs in edible tissue.] See also TNRCC TMDL report and Implementation plan:Nine Total Maximum Daily Loads for Legacy Pollutants in Streams and a Reservoir in Dallas abd Tarrant Counties for Segments 0805, 0841, and 0841A; and Implementation Plan for Dallas and Tarrant County Legacy Pollutant TMDLs for Segements 0805, 0841, and 0841A.	

\* Add (\*) for impaired waterbodies with pollutant in ( ).

**1.12 ROLES AND RESPONSIBILITIES: TxDOT**

- Development of plans and specifications
  - Submit Notice of Intent (NOI) to TCEQ (≥5 acres)
- Post Construction Site Notice
- Submit NOI/CSN to local MS4
- Perform SWP3 inspections
- Maintain SWP3 records and update to reflect daily operations
- Complete and submit Notice of Termination to TCEQ
- Maintain SWP3 records for 3 years
  - Other: \_\_\_\_\_
  - Other: \_\_\_\_\_
  - Other: \_\_\_\_\_

**1.13 ROLES AND RESPONSIBILITIES: CONTRACTOR**

- Day To Day Operational Control
  - Submit Notice of Intent (NOI) to TCEQ (≥5 acres)
- Post Construction Site Notice
- Submit NOI/CSN to local MS4
- Maintain schedule of major construction activities
- Install, maintain and modify BMPs
- Complete and submit Notice of Termination to TCEQ
- Maintain SWP3 records for 3 years
  - Other: \_\_\_\_\_
  - Other: \_\_\_\_\_
  - Other: \_\_\_\_\_

**1.14 LOCAL MUNICIPAL SEPARATE STORM SEWER SYSTEM (MS4) OPERATOR COORDINATION:**

MS4 Entity
City of Dallas Phase I MS4 contact Kevin Hurley



Solomon Bayou, P.E. 5/26/2023  
Signature of Registrant Date

**STORMWATER POLLUTION PREVENTION PLAN (SWP3)**



FED. RD. DIV. NO.	PROJECT NO.			SHEET NO.
6	SEE TITLE SHEET			41
STATE	STATE DIST.	COUNTY		
TEXAS	18	DALLAS		
CONT.	SECT.	JOB	HIGHWAY NO.	
0092	14	104	IH 45	

**STORMWATER POLLUTION PREVENTION PLAN (SWP3):**

**2.0 BEST MANAGEMENT PRACTICES (BMPs) AND CONTROLS, INSPECTION, AND MAINTENANCE**

The Contractor shall be the responsible party for implementing the BMPs described herein and for complying with the SWP3 for control of erosion and sedimentation during day-to-day operations. The Contractor shall implement changes to this SWP3 approved by TxDOT within the times specified in this SWP3 or the CGP.

**2.1 EROSION CONTROL AND SOIL STABILIZATION BMPs:**

**T / P**

- Protection of Existing Vegetation
- Vegetated Buffer Zones
- Soil Retention Blankets
- Geotextiles
- Mulching/ Hydromulching
- Soil Surface Treatments
- Temporary Seeding
- Permanent Planting, Sodding or Seeding
- Biodegradable Erosion Control Logs
- Rock Filter Dams/ Rock Check Dams
- Vertical Tracking
- Interceptor Swale
- Riprap
- Diversion Dike
- Temporary Pipe Slope Drain
- Embankment for Erosion Control
- Paved Flumes
- Other: \_\_\_\_\_
- Other: \_\_\_\_\_
- Other: \_\_\_\_\_
- Other: \_\_\_\_\_

**2.2 SEDIMENT CONTROL BMPs:**

**T / P**

- Biodegradable Erosion Control Logs
- Dewatering Controls
- Inlet Protection
- Rock Filter Dams/ Rock Check Dams
- Sandbag Berms
- Sediment Control Fence
- Stabilized Construction Exit
- Floating Turbidity Barrier
- Vegetated Buffer Zones
- Vegetated Filter Strips
- Other: \_\_\_\_\_
- Other: \_\_\_\_\_
- Other: \_\_\_\_\_
- Other: \_\_\_\_\_

Refer to the Environmental Layout Sheets/ SWP3 Layout Sheets located in Attachment 1.2 of this SWP3

Sediment control BMPs requiring design capacity calculations (See SWP3 Attachment 1.3.):

**T / P**

- Sediment Trap
  - Calculated volume runoff from 2-year, 24-hour storm for each acre of disturbed area
  - 3,600 cubic feet of storage per acre drained
- Sedimentation Basin
  - Not required (<10 acres disturbed)
  - Required (>10 acres) and implemented.
    - Calculated volume runoff from 2-year, 24-hour storm for each acre of disturbed area
    - 3,600 cubic feet of storage per acre drained
  - Required (>10 acres), but not feasible due to:
    - Available area/Site geometry
    - Site slope/Drainage patterns
    - Site soils/Geotechnical factors
    - Public safety
    - Other: \_\_\_\_\_

**2.3 PERMANENT CONTROLS:**

(Coordinate post-construction BMPs with appropriate TxDOT maintenance sections.)

BMPs To Be Left In Place Post Construction:

Type	Stationing	
	From	To
Block Sodding	150+46.00	398+68.84

Refer to the Environmental Layout Sheets/ SWP3 Layout Sheets located in Attachment 1.2 of this SWP3

**2.4 OFFSITE VEHICLE TRACKING CONTROLS:**

- Excess dirt/mud on road removed daily
- Haul roads dampened for dust control
- Loaded haul trucks to be covered with tarpaulin
- Stabilized construction exit
- Other: \_\_\_\_\_
- Other: \_\_\_\_\_
- Other: \_\_\_\_\_
- Other: \_\_\_\_\_

**2.5 POLLUTION PREVENTION MEASURES:**

- Chemical Management
- Concrete and Materials Waste Management
- Debris and Trash Management
- Dust Control
- Sanitary Facilities
- Other: **Avoid storing portable sanitary units, concrete washouts or chemicals within 50 feet upgradient of a receiving water or drainage conveyance without adequate pollution controls. \*Capture saw-cutting debris and slurry for proper disposal. \*Maintain paved surfaces and adjacent properties free of project sedimentation and loose materials.**
- Other: \_\_\_\_\_
- Other: \_\_\_\_\_

**2.6 VEGETATED BUFFER ZONES:**

Natural vegetated buffers shall be maintained as feasible to protect adjacent surface waters. If vegetated natural buffer zones are not feasible due to site geometry, the appropriate additional sediment control measures have been incorporated into this SWP3.

Type	Stationing	
	From	To

Refer to the Environmental Layout Sheets/ SWP3 Layout Sheets located in Attachment 1.2 of this SWP3

**2.7 ALLOWABLE NON-STORMWATER DISCHARGES:**

- Fire hydrant flushings
- Irrigation drainage
- Pavement washwater (where spills or leaks have not occurred, and detergents are not used)
- Potable water sources
- Springs
- Uncontaminated groundwater
- Water used to wash vehicles or control dust
- Other allowable non-stormwater discharges as allowed by TPDES GP TXR150000.

**2.8 INSPECTIONS:**

All disturbed areas and erosion and sediment control devices shall be inspected at least once every seven (7) days. Inspections shall be performed by TxDOT as indicated on the Field Inspection and Maintenance Report Form 2118 and retained in Attachment 2.5 of this SWP3 .

**2.9 MAINTENANCE:**

Control measures shall be properly installed according to specifications. If it is determined that a BMP or control measure is not operating effectively, maintenance must be accomplished as soon as possible and before the next anticipated rain event, but in no case later than 7 calendar days after being able to access the site. Maintenance shall be performed by the Contractor as indicated on the Field Inspection and Maintenance Report Form 2118 and retained in Attachment 2.5 of this SWP3.



Solomon Bayou, P.E. 5/26/2023  
Signature of Registrant Date


 
**STORMWATER POLLUTION PREVENTION PLAN (SWP3)**

© 2023 Texas Department of Transportation  
Sheet 2 of 2

FED. RD. DIV. NO.	PROJECT NO.		SHEET NO.
6	SEE TITLE SHEET		42
STATE	STATE DIST.	COUNTY	
TEXAS	18	DALLAS	
CONT.	SECT.	JOB	HIGHWAY NO.
0092	14	104	IH 45

DW: SB  
 CK: DN  
 DW: SB  
 CK: DN

DATE DISTURBED: - - - - -  
 DATE STABILIZED: - - - - -

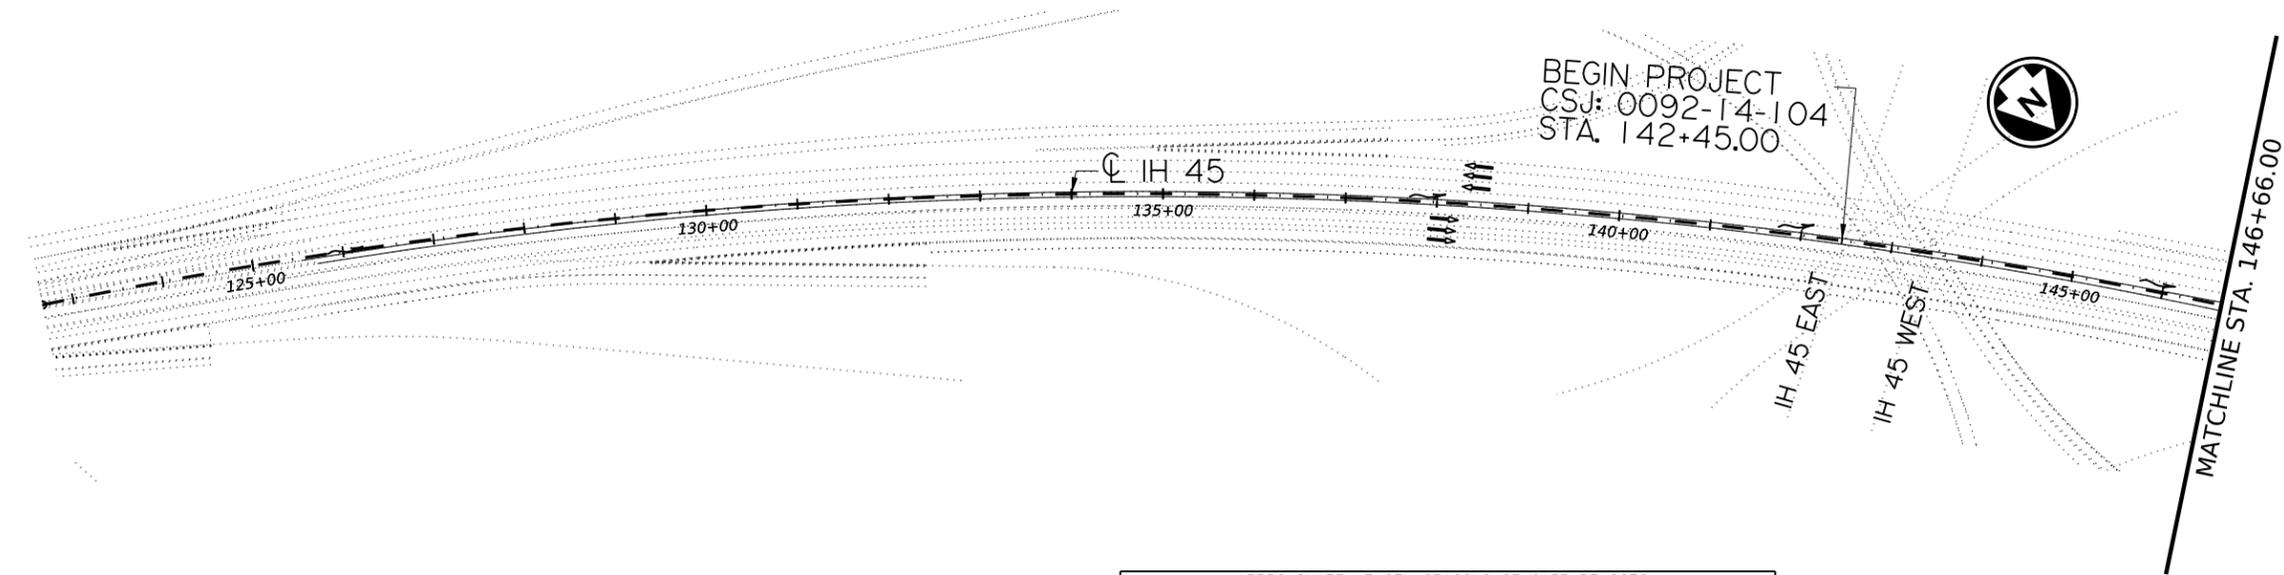

**LEGEND**


	EROSION CONTROL LOG
	ROCK FILTER DAM
	WATER FLOW DIRECTION

BMP ID	DATE INSTALLED	DATE REMOVED
BMP 1-1		
BMP 1-2		
BMP 1-3		
BMP 1-4		
BMP 1-5		

APPROXIMATE LENGTH/SPACING OF SW3P DEVICES		
TYPE OF DEVICE	APPROX. LENGTH	SPACING
ECL	10 LF/SIDE OF ROAD	EVERY 400' OF DITCH

PERMANENT SODDING (PER TYPICAL SECTION)	
DATE PLACED	

- NOTE:**
- 10 LF OF EROSION CONTROL LOG TO BE PLACED IN THE MEDIAN DITCH EVERY 400'.
  - ACTUAL LOCATION OF THE EROSION CONTROL LOG TO BE DETERMINED BY THE ENGINEER.
  - CONSTRUCTION EXIT LOCATION TO BE DETERMINED BY THE CONTRACTOR WITH THE APPROVAL OF THE ENGINEER.
  - BMP'S SHALL NOT BE INSTALLED IN THEIR CONTROL AREAS ANY SOONER THAN 2 WEEKS PRIOR TO SOIL DISTURBANCE OF THAT AREA.
  - SEE TYPICAL SECTIONS FOR THE DISTURBANCE AND SODDING LIMITS.

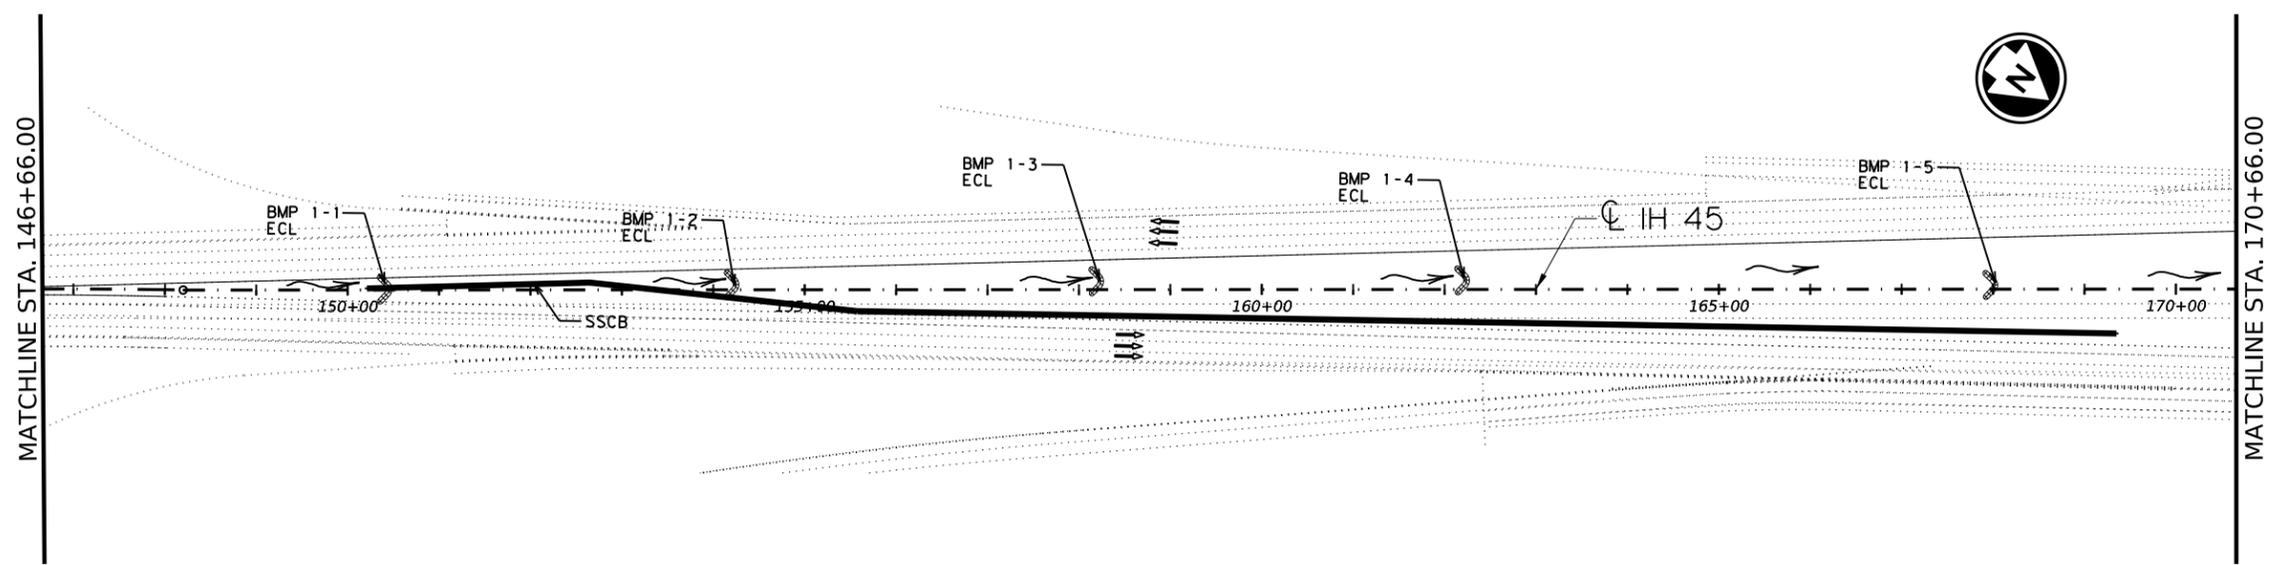

Solomon Bayou 5/26/2023  
 Signature of Registrant Date



**IH 45**  
**SW3P LAYOUT**

SCALE: 1"=200' SHEET 1 OF 6


CONT	SECT	JOB	HIGHWAY
0092	14	104	IH 45
DIST	COUNTY	SHEET NO.	
18	DALLAS	43	

DATE: 5/29/2023 8:30:52 PM  
 FILE: c:\txdot\pw\_online\txdot\5\solomon.bayou\d0841988\SW3P PLAN LAYOUT CONTAINER FILE.dgn

DW: SB  
 CK: DN  
 DW: SB  
 CK: DN  
 DW: SB  
 CK: DN



DATE DISTURBED: -----  
 DATE STABILIZED: -----

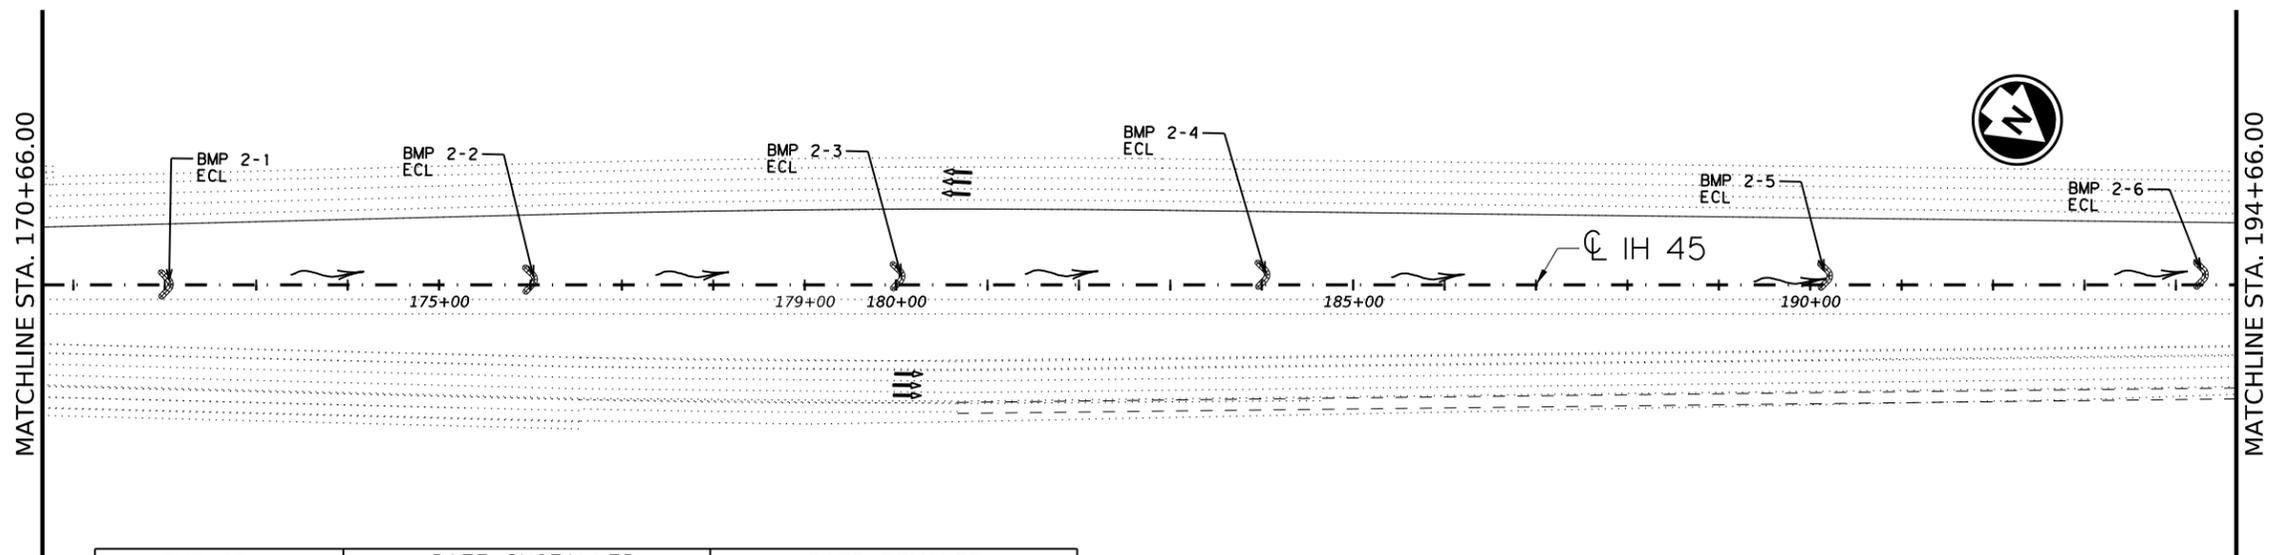

**LEGEND**


- EROSION CONTROL LOG
- ROCK FILTER DAM
- WATER FLOW DIRECTION

BMP ID	DATE INSTALLED	DATE REMOVED
BMP 2-1		
BMP 2-2		
BMP 2-3		
BMP 2-4		
BMP 2-5		
BMP 2-6		
BMP 2-7		
BMP 2-8		
BMP 2-9		
BMP 2-10		
BMP 2-11		
BMP 2-12		

APPROXIMATE LENGTH/SPACING OF SW3P DEVICES		
TYPE OF DEVICE	APPROX. LENGTH	SPACING
ECL	10 LF/SIDE OF ROAD	EVERY 400' OF DITCH

PERMANENT SODDING (PER TYPICAL SECTION)	
DATE PLACED	

- NOTE:**
- 10 LF OF EROSION CONTROL LOG TO BE PLACED IN THE MEDIAN DITCH EVERY 400'.
  - ACTUAL LOCATION OF THE EROSION CONTROL LOG TO BE DETERMINED BY THE ENGINEER.
  - CONSTRUCTION EXIT LOCATION TO BE DETERMINED BY THE CONTRACTOR WITH THE APPROVAL OF THE ENGINEER.
  - BMP'S SHALL NOT BE INSTALLED IN THEIR CONTROL AREAS ANY SOONER THAN 2 WEEKS PRIOR TO SOIL DISTURBANCE OF THAT AREA.
  - SEE TYPICAL SECTIONS FOR THE DISTURBANCE AND SODDING LIMITS.

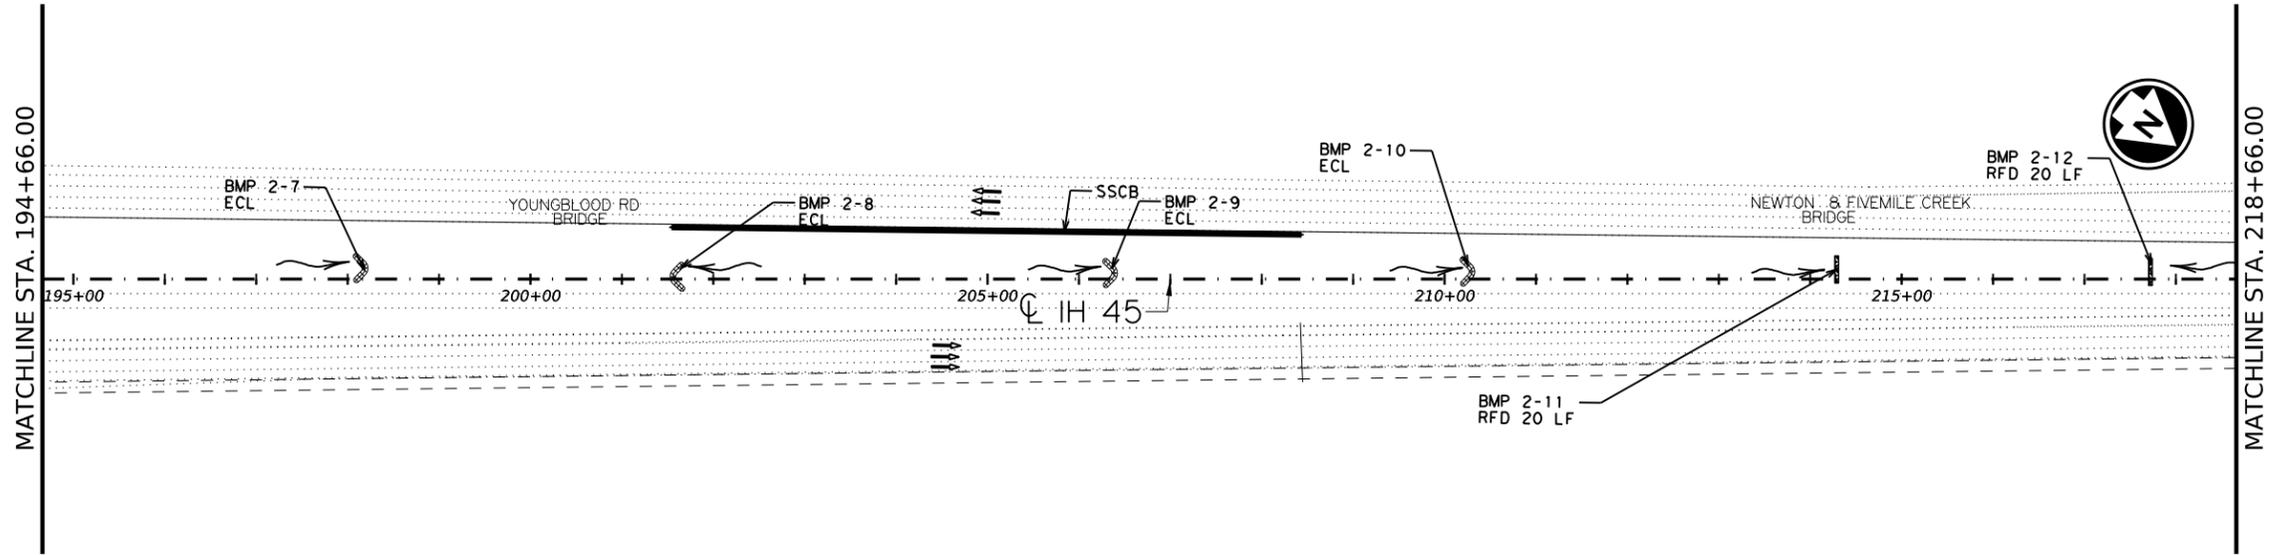

Solomon Bayou  
 Signature of Registrant  
 5/26/2023  
 Date



**IH 45**

**SW3P LAYOUT**


 
SCALE: 1" = 200' SHEET 2 OF 6

CONT	SECT	JOB	HIGHWAY
0092	14	104	IH 45
DIST	COUNTY	SHEET NO.	
18	DALLAS	44	

DATE: 5/29/2023 8:30:58 PM  
 FILE: c:\txdot\pw\_onlinetxdat5\solomon.bayoutd0841988\sw3p PLAN LAYOUT CONTAINER FILE.dgn

CK DN  
DW SB  
CK DN  
DW SB

DATE DISTURBED: -----  
DATE STABILIZED: -----

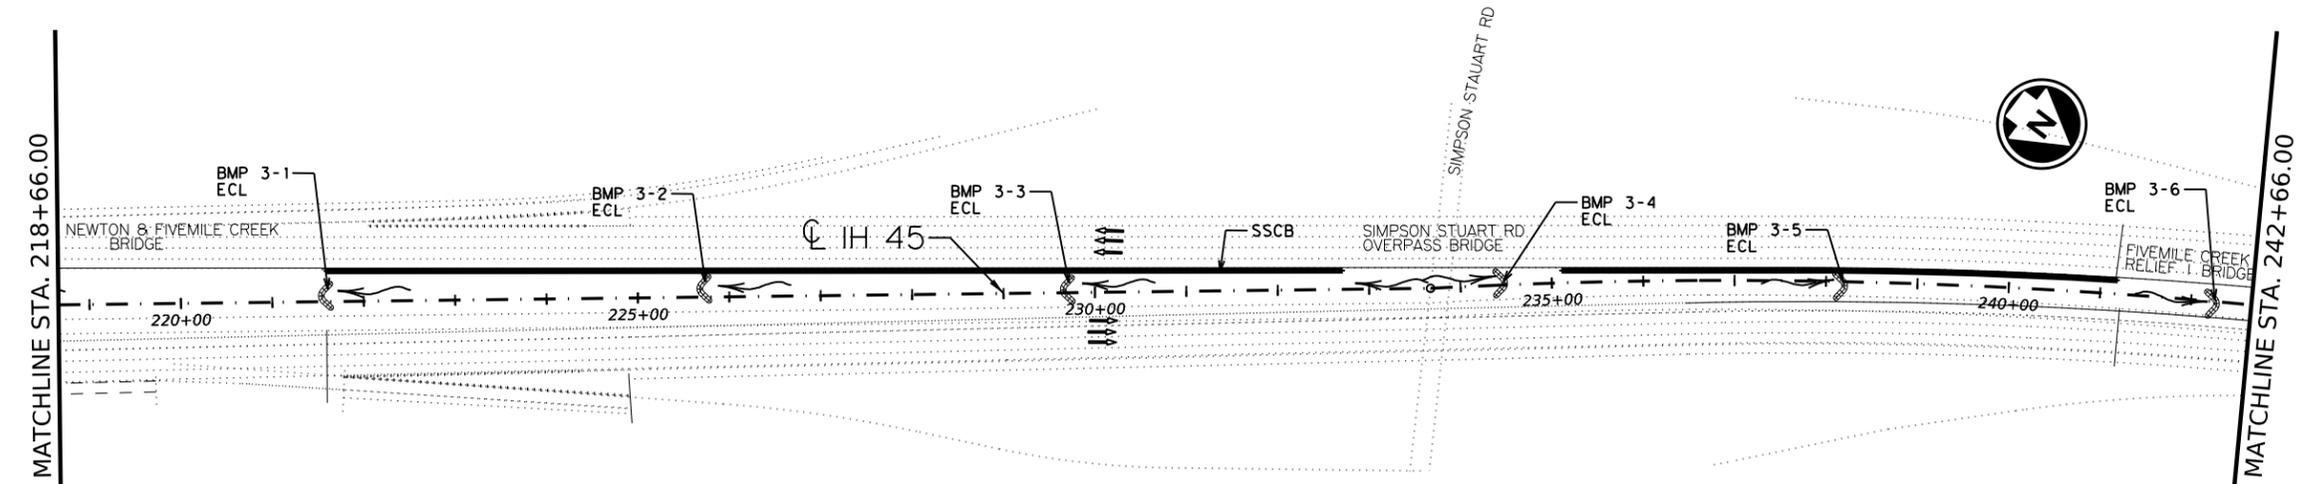

**LEGEND**


- EROSION CONTROL LOG
- ROCK FILTER DAM
- WATER FLOW DIRECTION

BMP ID	DATE INSTALLED	DATE REMOVED
BMP 3-1		
BMP 3-2		
BMP 3-3		
BMP 3-4		
BMP 3-5		
BMP 3-6		
BMP 3-7		
BMP 3-8		
BMP 3-9		
BMP 3-10		
BMP 3-11		
BMP 3-12		
BMP 3-13		

APPROXIMATE LENGTH/SPACING OF SW3P DEVICES		
TYPE OF DEVICE	APPROX. LENGTH	SPACING
ECL	10 LF/SIDE OF ROAD	EVERY 400' OF DITCH

PERMANENT SODDING (PER TYPICAL SECTION)	
DATE PLACED	

- NOTE:
- 10 LF OF EROSION CONTROL LOG TO BE PLACED IN THE MEDIAN DITCH EVERY 400'.
  - ACTUAL LOCATION OF THE EROSION CONTROL LOG TO BE DETERMINED BY THE ENGINEER.
  - CONSTRUCTION EXIT LOCATION TO BE DETERMINED BY THE CONTRACTOR WITH THE APPROVAL OF THE ENGINEER.
  - BMP'S SHALL NOT BE INSTALLED IN THEIR CONTROL AREAS ANY SOONER THAN 2 WEEKS PRIOR TO SOIL DISTURBANCE OF THAT AREA.
  - SEE TYPICAL SECTIONS FOR THE DISTURBANCE AND SODDING LIMITS.

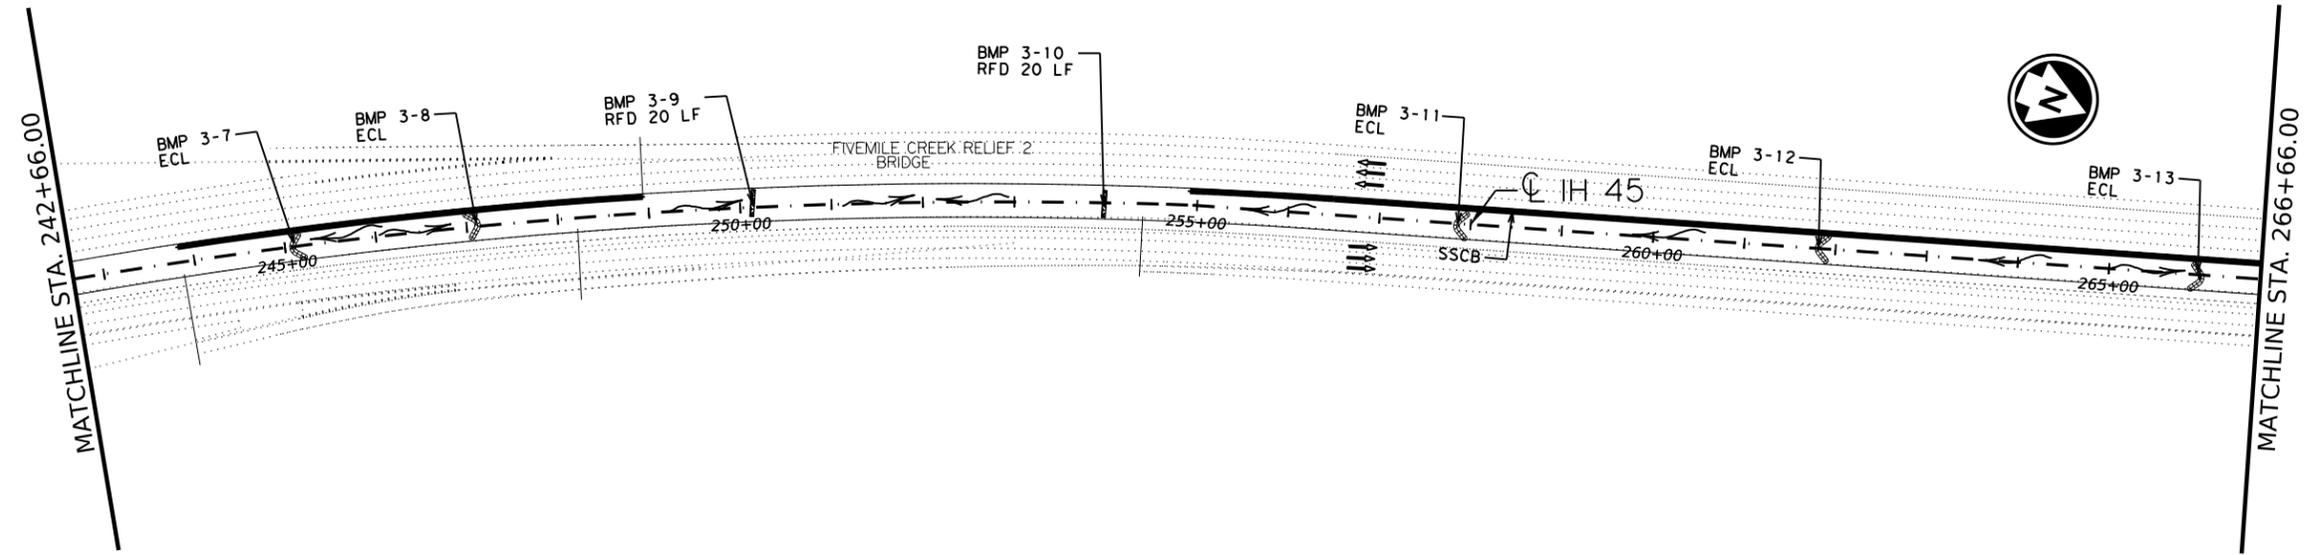

Solomon Bayou, P.E. 5/26/2023  
Signature of Registrant & Date



**IH 45**

**SW3P LAYOUT**

 
SCALE: 1"=200' SHEET 3 OF 6

CONT	SECT	JOB	HIGHWAY
0092	14	104	IH 45
DIST	COUNTY	SHEET NO.	
18	DALLAS	45	

DATE: 5/29/2023 8:31:02 PM  
FILE: c:\txdot\pw\_onlinetxdat5\solomon.bayoutd0841988\sw3p PLAN LAYOUT CONTAINER FILE.dgn


DATE DISTURBED: - - - - -

DATE STABILIZED: - - - - -



LEGEND

- EROSION CONTROL LOG
- ROCK FILTER DAM
- WATER FLOW DIRECTION

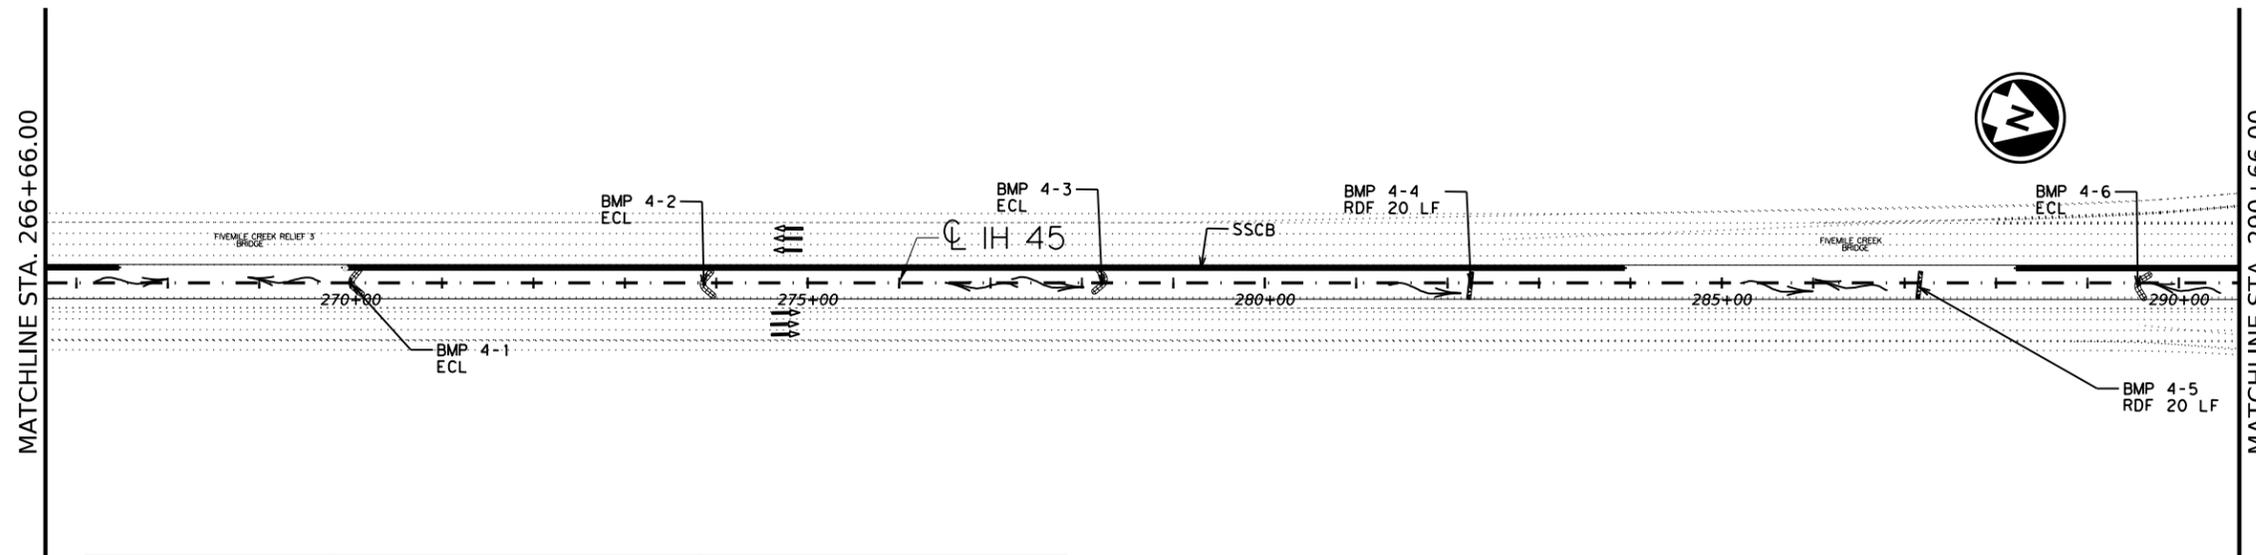


BMP ID	DATE INSTALLED	DATE REMOVED
BMP 4-1		
BMP 4-2		
BMP 4-3		
BMP 4-4		
BMP 4-5		
BMP 4-6		
BMP 4-7		
BMP 4-8		
BMP 4-9		
BMP 4-10		
BMP 4-11		
BMP 4-12		

APPROXIMATE LENGTH/SPACING OF SW3P DEVICES		
TYPE OF DEVICE	APPROX. LENGTH	SPACING
ECL	10 LF/SIDE OF ROAD	EVERY 400' OF DITCH

PERMANENT SODDING (PER TYPICAL SECTION)	
DATE PLACED	

- NOTE:
- 10 LF OF EROSION CONTROL LOG TO BE PLACED IN THE MEDIAN DITCH EVERY 400'.
  - ACTUAL LOCATION OF THE EROSION CONTROL LOG TO BE DETERMINED BY THE ENGINEER.
  - CONSTRUCTION EXIT LOCATION TO BE DETERMINED BY THE CONTRACTOR WITH THE APPROVAL OF THE ENGINEER.
  - BMP'S SHALL NOT BE INSTALLED IN THEIR CONTROL AREAS ANY SOONER THAN 2 WEEKS PRIOR TO SOIL DISTURBANCE OF THAT AREA.
  - SEE TYPICAL SECTIONS FOR THE DISTURBANCE AND SODDING LIMITS.

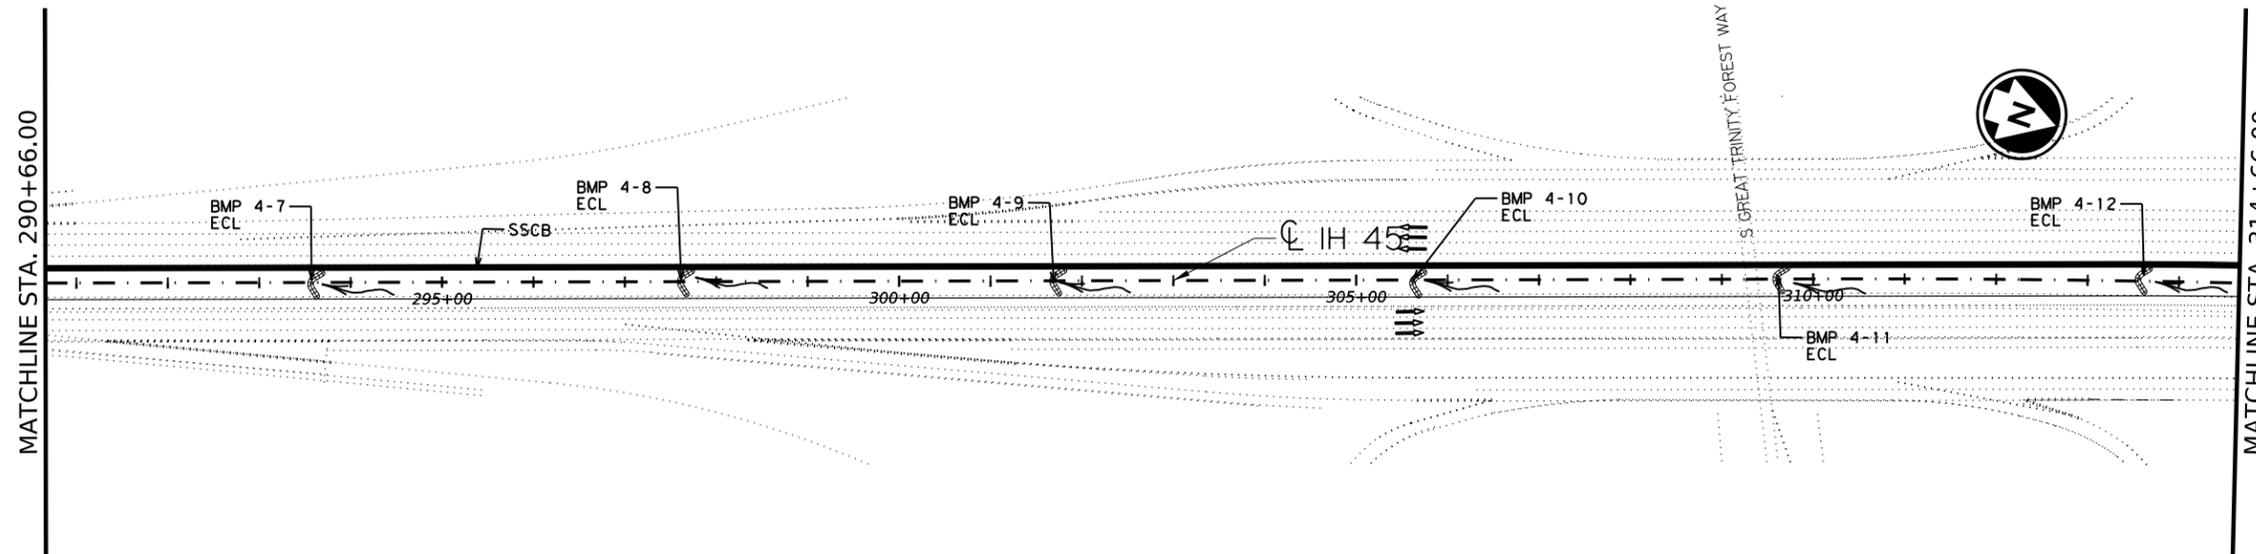

Solomon Bayou, P.E. 5/26/2023  
Signature of Registrant & Date



IH 45  
SW3P LAYOUT


SCALE: 1" = 200' SHEET 4 OF 6

CONT	SECT	JOB	HIGHWAY
0092	14	104	IH 45
DIST	COUNTY	SHEET NO.	
18	DALLAS	46	


DATE: 5/29/2023 8:31:06 PM  
FILE: c:\txdot\pw\_onlinetxdat5\solomon.bayou\d0841988\SW3P PLAN LAYOUT CONTAINER FILE.dgn

DW: SB  
CK: DN  
DW: SB  
CK: DN

 DW:SB  
CK:DN  
DW:SB  
CK:DN



DATE DISTURBED: -----  
DATE STABILIZED: -----

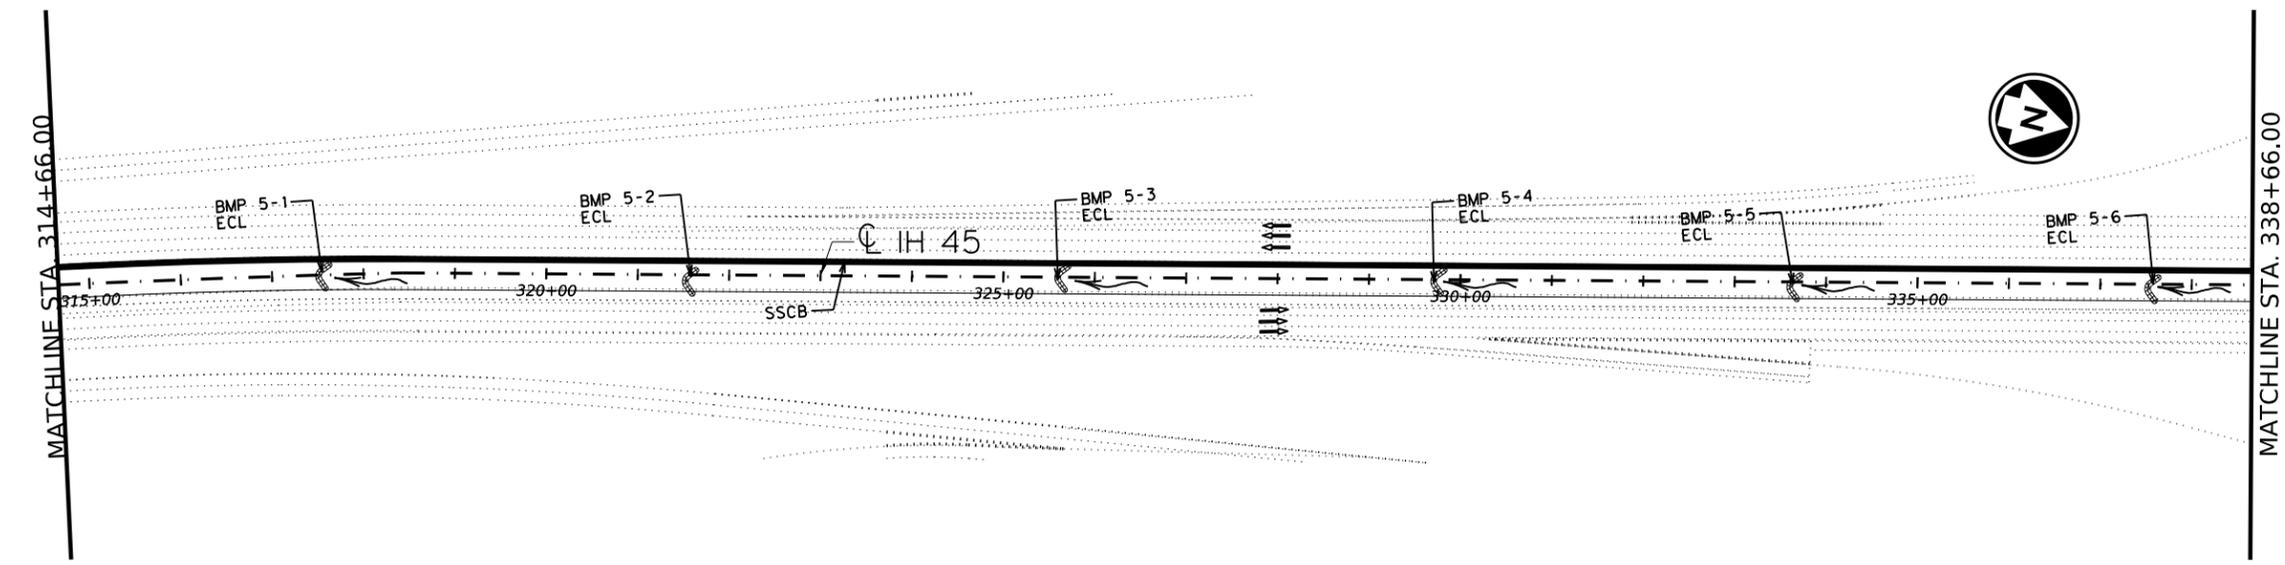

**LEGEND**


- EROSION CONTROL LOG
- ROCK FILTER DAM
- WATER FLOW DIRECTION

BMP ID	DATE INSTALLED	DATE REMOVED
BMP 5-1		
BMP 5-2		
BMP 5-3		
BMP 5-4		
BMP 5-5		
BMP 5-6		
BMP 5-7		
BMP 5-8		
BMP 5-9		
BMP 5-10		
BMP 5-11		
BMP 5-12		

APPROXIMATE LENGTH/SPACING OF SW3P DEVICES		
TYPE OF DEVICE	APPROX. LENGTH	SPACING
ECL	10 LF/SIDE OF ROAD	EVERY 400' OF DITCH

PERMANENT SODDING (PER TYPICAL SECTION)	
DATE PLACED	

- NOTE:
1. 10 LF OF EROSION CONTROL LOG TO BE PLACED IN THE MEDIAN DITCH EVERY 400'.
  2. ACTUAL LOCATION OF THE EROSION CONTROL LOG TO BE DETERMINED BY THE ENGINEER.
  3. CONSTRUCTION EXIT LOCATION TO BE DETERMINED BY THE CONTRACTOR WITH THE APPROVAL OF THE ENGINEER.
  4. BMP'S SHALL NOT BE INSTALLED IN THEIR CONTROL AREAS ANY SOONER THAN 2 WEEKS PRIOR TO SOIL DISTURBANCE OF THAT AREA.
  5. SEE TYPICAL SECTIONS FOR THE DISTURBANCE AND SODDING LIMITS.

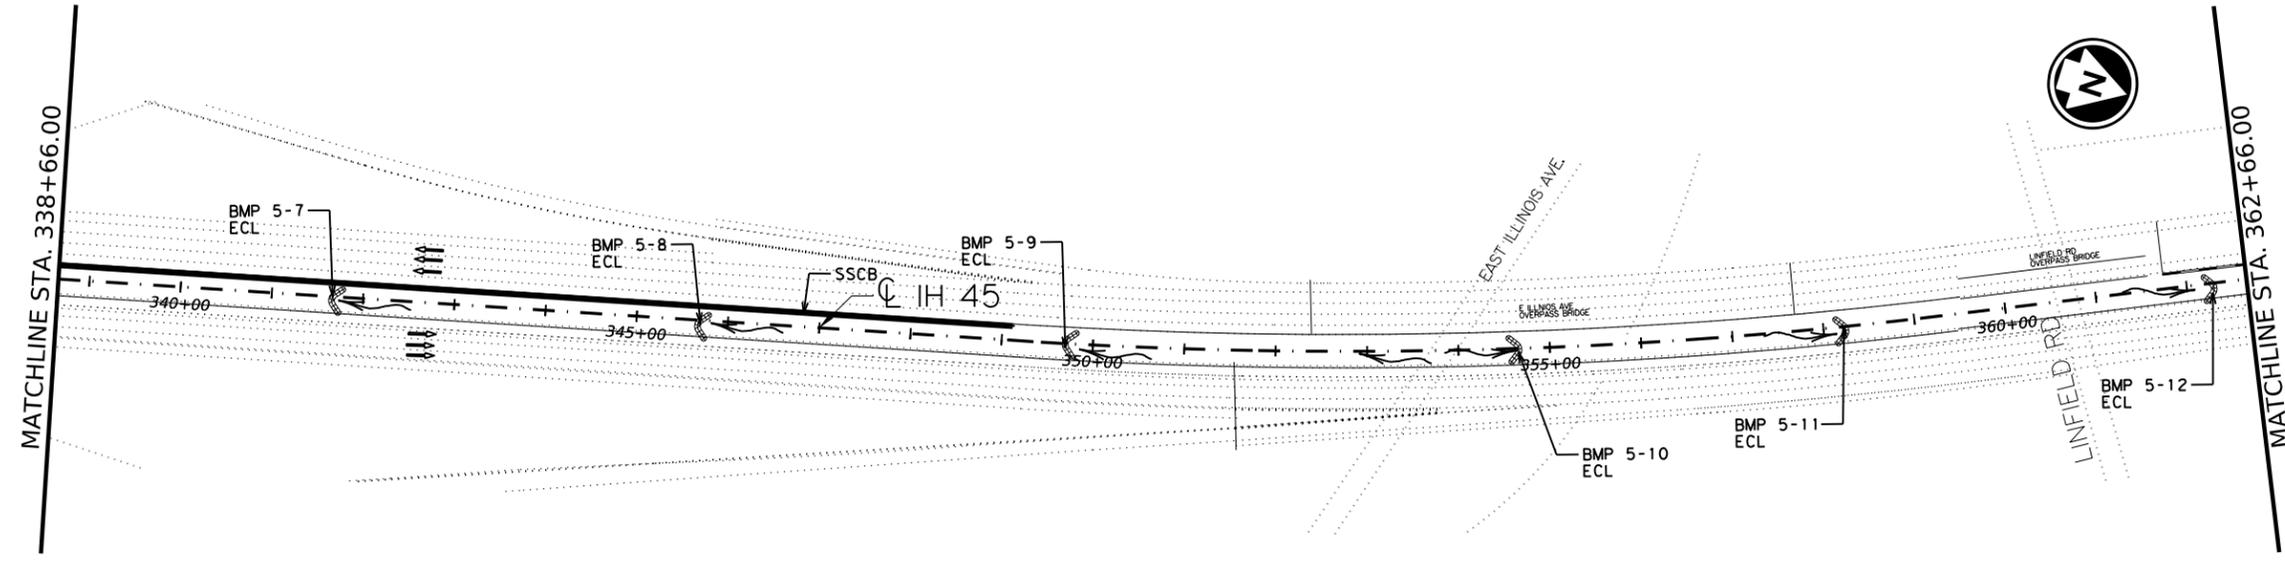

*Solomon Bayou*, P.E. 5/26/2023  
Signature of Registrant & Date



**IH 45**  
**SW3P LAYOUT**

SCALE: 1"=200' SHEET 5 OF 6

CONT	SECT	JOB	HIGHWAY
0092	14	104	IH 45
DIST	COUNTY	SHEET NO.	
18	DALLAS	47	

DATE: 5/29/2023 8:31:11 PM  
FILE: c:\txdot\pw\_onlinetxdat5\solomon\_bayou\0841988\SW3P\_PLAN\_LAYOUT\_CONTAINER\_FILE.dgn


DATE DISTURBED: -----

DATE STABILIZED: -----



LEGEND

- EROSION CONTROL LOG
- ROCK FILTER DAM
- WATER FLOW DIRECTION

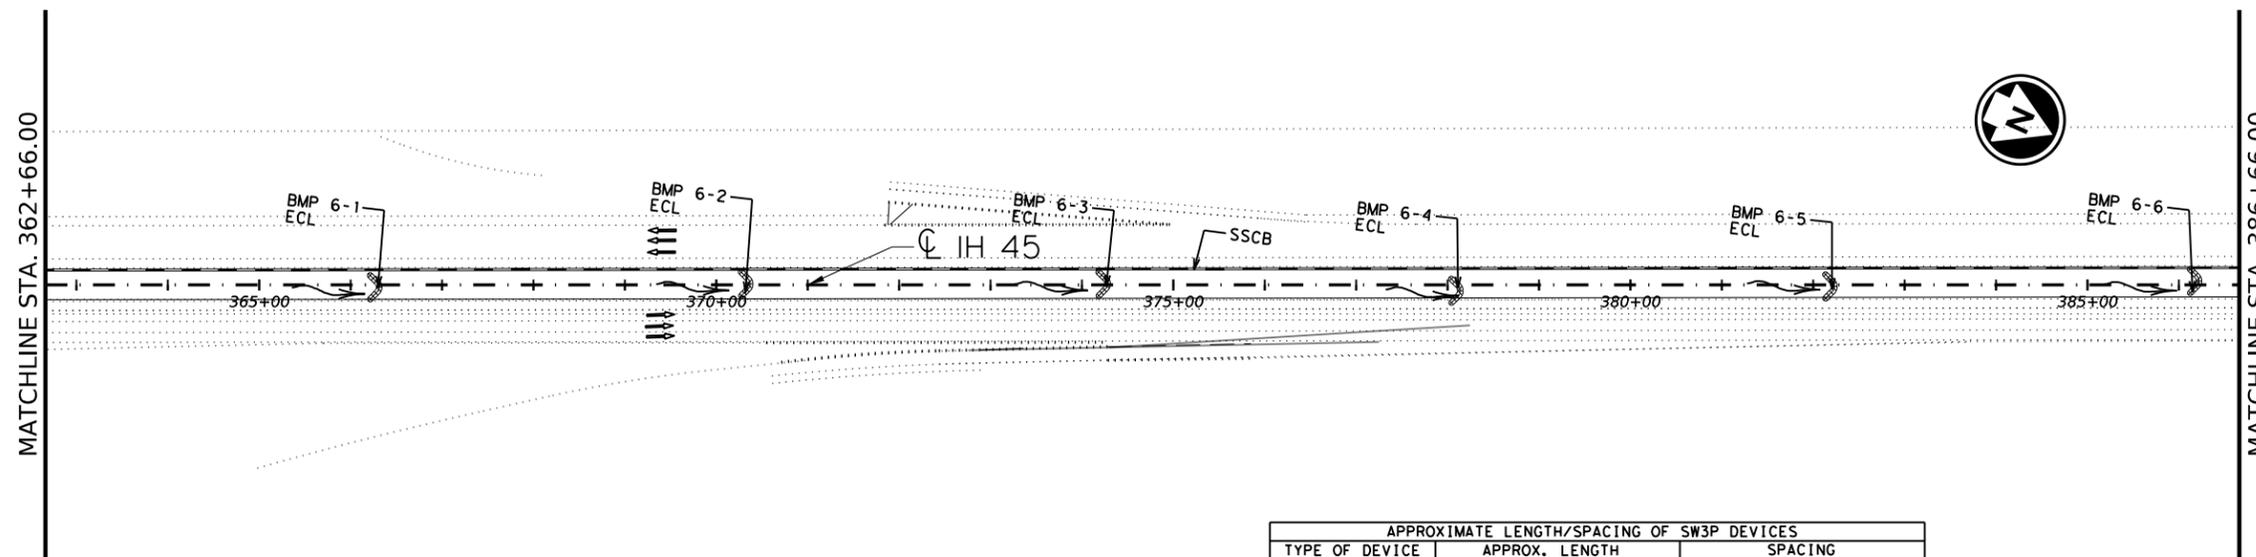


BMP ID	DATE INSTALLED	DATE REMOVED
BMP 6-1		
BMP 6-2		
BMP 6-3		
BMP 6-4		
BMP 6-5		
BMP 6-6		
BMP 6-7		
BMP 6-8		
BMP 6-9		
BMP 6-10		

APPROXIMATE LENGTH/SPACING OF SW3P DEVICES		
TYPE OF DEVICE	APPROX. LENGTH	SPACING
ECL	10 LF/SIDE OF ROAD	EVERY 400' OF DITCH

PERMANENT SODDING (PER TYPICAL SECTION)	
DATE PLACED	

- NOTE:
- 10 LF OF EROSION CONTROL LOG TO BE PLACED IN THE MEDIAN DITCH EVERY 400'.
  - ACTUAL LOCATION OF THE EROSION CONTROL LOG TO BE DETERMINED BY THE ENGINEER.
  - CONSTRUCTION EXIT LOCATION TO BE DETERMINED BY THE CONTRACTOR WITH THE APPROVAL OF THE ENGINEER.
  - BMP'S SHALL NOT BE INSTALLED IN THEIR CONTROL AREAS ANY SOONER THAN 2 WEEKS PRIOR TO SOIL DISTURBANCE OF THAT AREA.
  - SEE TYPICAL SECTIONS FOR THE DISTURBANCE AND SODDING LIMITS.

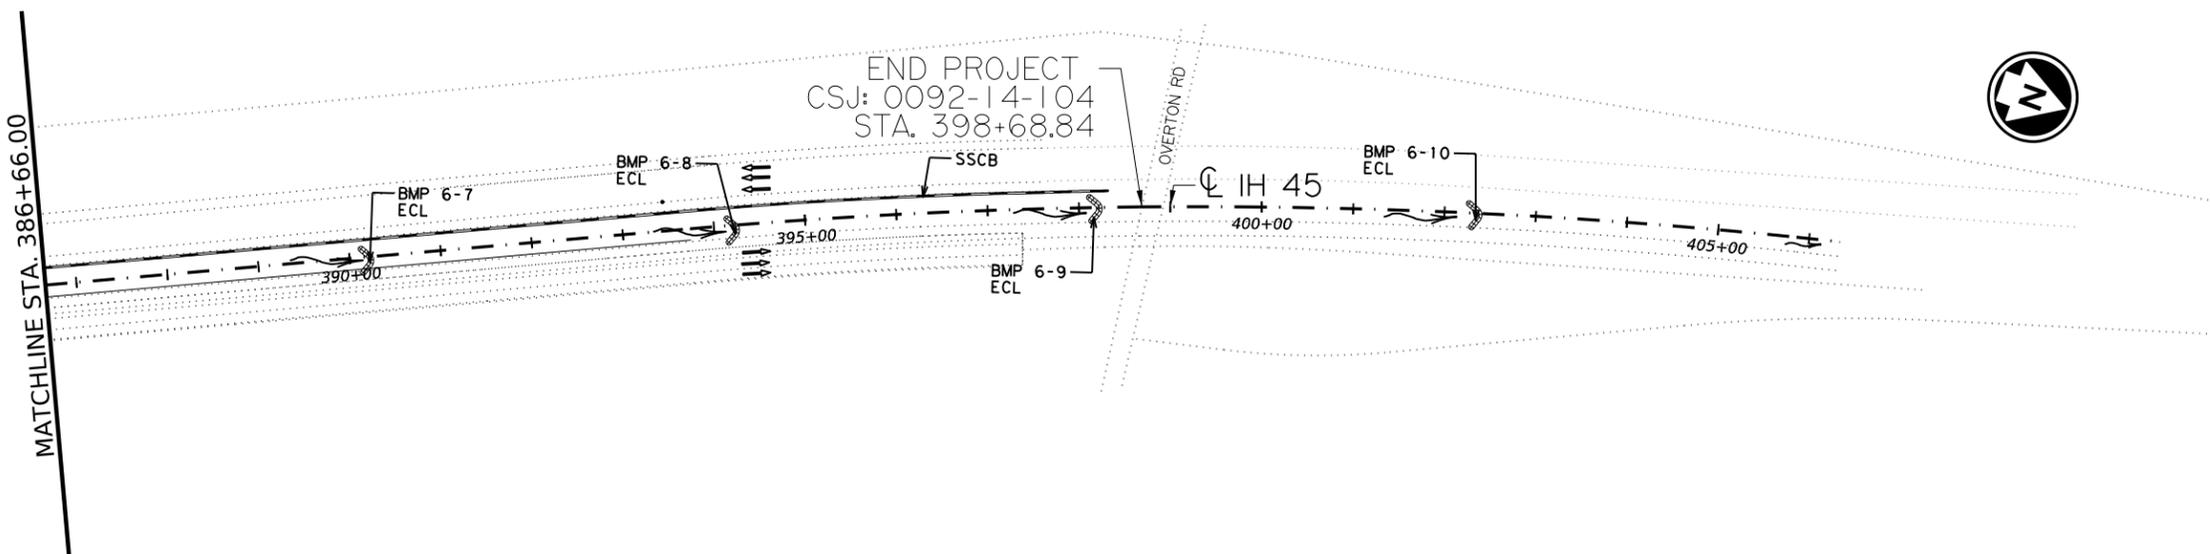

Solomon Bayou, P.E. 5/26/2023  
Signature of Registrant & Date



IH 45


SW3P LAYOUT

SCALE: 1" = 200' SHEET 6 OF 6

CONT	SECT	JOB	HIGHWAY
0092	14	104	IH 45
DIST	COUNTY	SHEET NO.	
18	DALLAS	48	


DISCLAIMER: The use of this standard is governed by the "Texas Engineering Practice Act". No warranty of any kind is made by TxDOT for any purpose whatsoever. TxDOT assumes no responsibility for the conversion of this standard to other formats or for incorrect results or damages resulting from its use.

DATE: 5/8/2023  
 FILE: c:\txdot\pw\_online\txdot5\solomon\_bayou\0852788\ec216.dgn

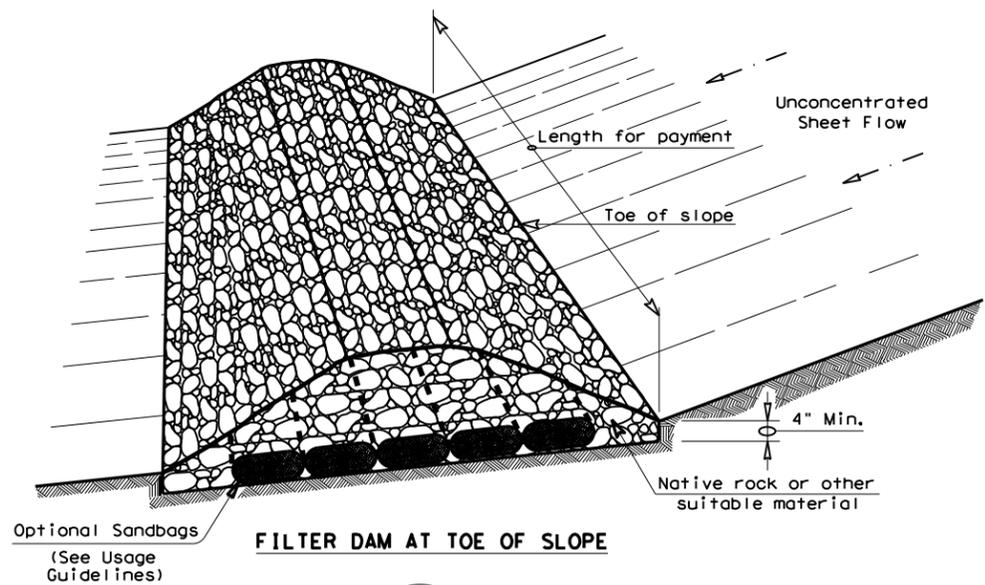


**FILTER DAM AT TOE OF SLOPE**

(RFD1)

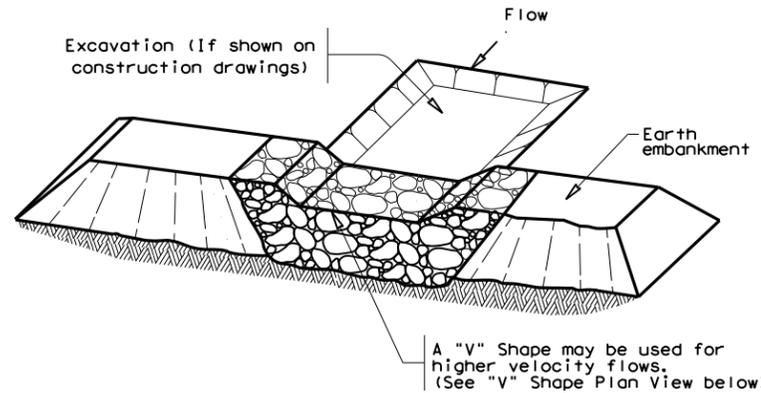


**FILTER DAM AT SEDIMENT TRAP**

(RFD1) OR (RFD2)

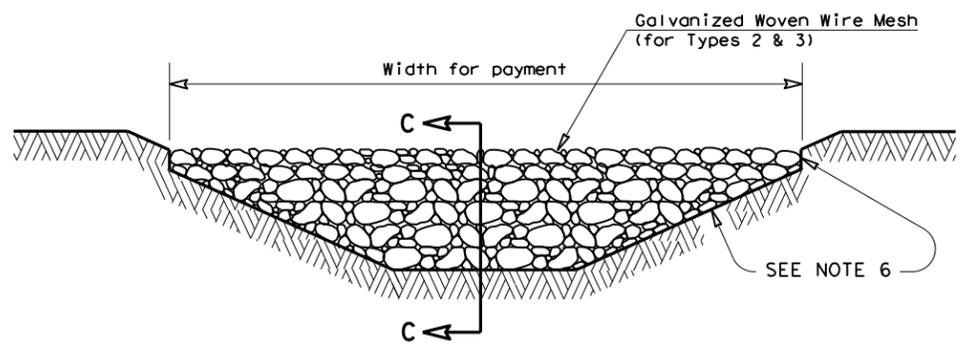


**FILTER DAM AT CHANNEL SECTIONS**


(RFD1) OR (RFD2) OR (RFD3)

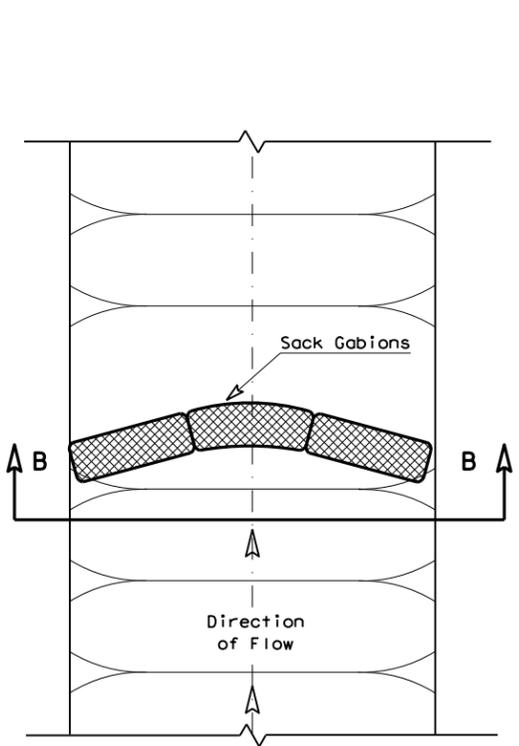


**PLAN VIEW**

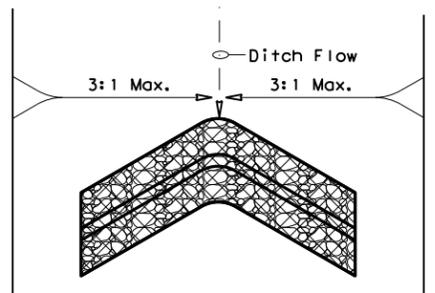


**"V" SHAPE PLAN VIEW**

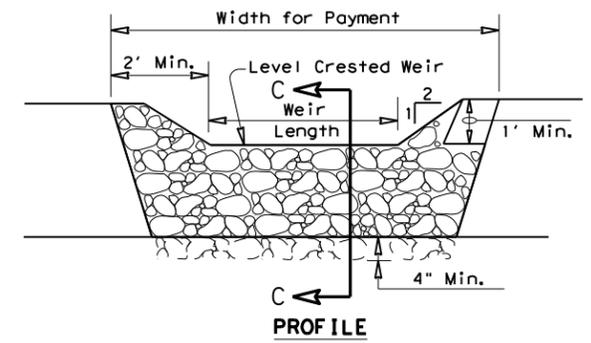


**PROFILE**

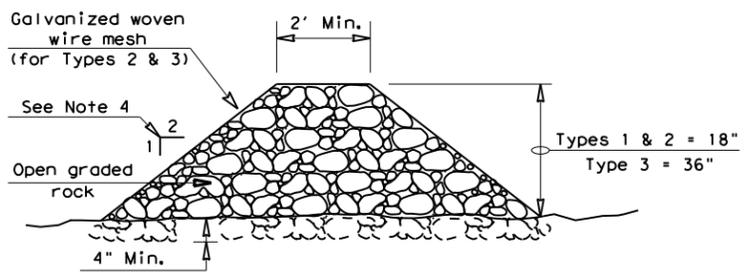

**SECTION C-C**

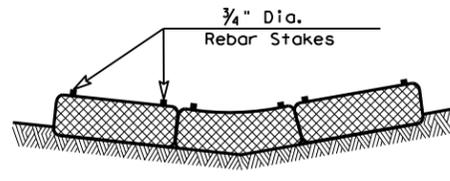


**SECTION B-B**

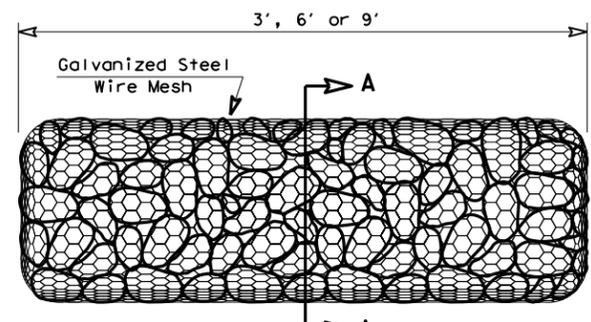

**TYPE 4 (SACK GABIONS)**

(RFD4)

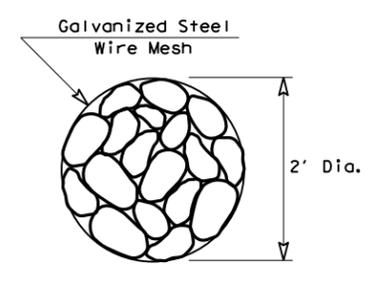

**SECTION A-A**

**ROCK FILTER DAM USAGE GUIDELINES**

Rock Filter Dams should be constructed downstream from disturbed areas to intercept sediment from overland runoff and/or concentrated flow. The dams should be sized to filter a maximum flow through rate of 60 GPM/FT<sup>2</sup> of cross sectional area. A 2 year storm frequency may be used to calculate the flow rate.

**Type 1** (18" high with no wire mesh) (3" to 6" aggregate): Type 1 may be used at the toe of slopes, around inlets, in small ditches, and at dike or swale outlets. This type of dam is recommended to control erosion from a drainage area of 5 acres or less. Type 1 may not be used in concentrated high velocity flows (approximately 8 Ft/Sec or more) in which aggregate wash out may occur. Sandbags may be used at the embedded foundation (4" deep min.) for better filtering efficiency of low flows if called for on the plans or directed by the Engineer.

**Type 2** (18" high with wire mesh) (3" to 6" aggregate): Type 2 may be used in ditches and at dike or swale outlets.

**Type 3** (36" high with wire mesh) (4" to 8" aggregate): Type 3 may be used in stream flow and should be secured to the stream bed.

**Type 4** (Sack gabions) (3" to 6" aggregate): Type 4 May be used in ditches and smaller channels to form an erosion control dam.

**Type 5:** Provide rock filter dams as shown on plans.

**GENERAL NOTES**

1. If shown on the plans or directed by the Engineer, filter dams should be placed near the toe of slopes where erosion is anticipated, upstream and/or downstream at drainage structures, and in roadway ditches and channels to collect sediment.
2. Materials (aggregate, wire mesh, sandbags, etc.) shall be as indicated by the specification for "Rock Filter Dams for Erosion and Sedimentation Control".
3. The rock filter dam dimensions shall be as indicated on the SW3P plans.
4. Side slopes should be 2:1 or flatter. Dams within the safety zone shall have sideslopes of 6:1 or flatter.
5. Maintain a minimum of 1' between top of rock filter dam weir and top of embankment for filter dams at sediment traps.
6. Filter dams should be embedded a minimum of 4" into existing ground.
7. The sediment trap for ponding of sediment laden runoff shall be of the dimensions shown on the plans.
8. Rock filter dam types 2 & 3 shall be secured with 20 gauge galvanized woven wire mesh with 1" diameter hexagonal openings. The aggregate shall be placed on the mesh to the height & slopes specified. The mesh shall be folded at the upstream side over the aggregate and tightly secured to itself on the downstream side using wire ties or hog rings. For in stream use, the mesh should be secured or staked to the stream bed prior to aggregate placement.
9. Sack Gabions should be staked down with 3/4" dia. rebar stakes, and have a double-twisted hexagonal weave with a nominal mesh opening of 2 1/2" x 3 1/4".
10. Flow outlet should be onto a stabilized area (vegetation, rock, etc.).
11. The guidelines shown hereon are suggestions only and may be modified by the Engineer.


**PLAN SHEET LEGEND**

- Type 1 Rock Filter Dam (RFD1)
- Type 2 Rock Filter Dam (RFD2)
- Type 3 Rock Filter Dam (RFD3)
- Type 4 Rock Filter Dam (RFD4)


		<b>Design Division Standard</b>	
<b>TEMPORARY EROSION, SEDIMENT AND WATER POLLUTION CONTROL MEASURES</b>			
<b>ROCK FILTER DAMS</b>			
<b>EC(2) - 16</b>			
FILE: ec216	DN: TxDOT	CK: KM	DW: VP
© TxDOT: JULY 2016	CONT: 0092	SECT: 14	JOB: 104
REVISIONS			HIGHWAY: IH 45
	DIST: 18	COUNTY: DALLAS	SHEET NO.: 49

DISCLAIMER:  
 The use of this standard is governed by the "Texas Engineering Practice Act". No warranty of any kind is made by TxDOT for any purpose whatsoever. TxDOT assumes no responsibility for the conversion of this standard to other formats or for incorrect results or damages resulting from its use.

DATE: 5/8/2023  
 FILE: c:\txdot\pw\_online\txdot5\solomon\_bayou\d0852788\ec316.dgn

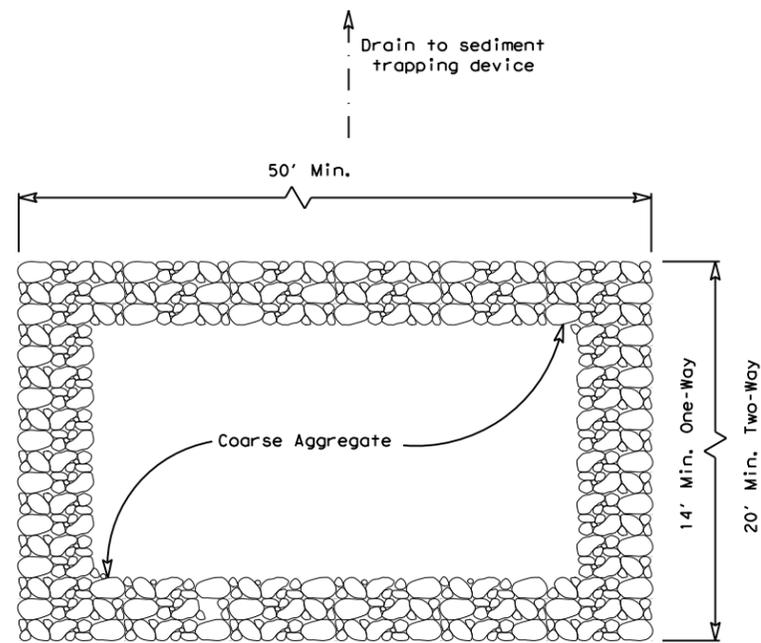

PLAN VIEW

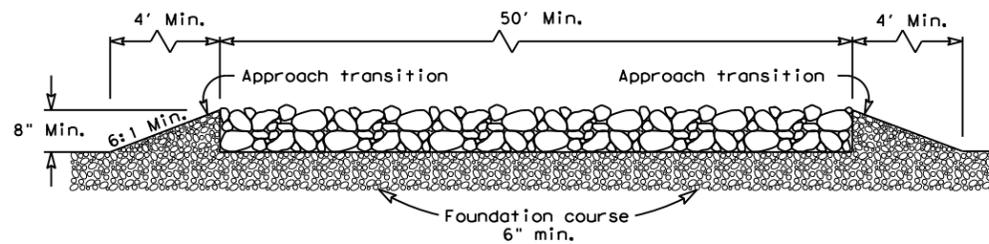


ELEVATION VIEW


CONSTRUCTION EXIT (TYPE 1)  
 ROCK CONSTRUCTION (LONG TERM)

GENERAL NOTES (TYPE 1)

- The length of the type 1 construction exit shall be as indicated on the plans, but not less than 50'.
- The coarse aggregate should be open graded with a size of 4" to 8".
- The approach transitions should be no steeper than 6:1 and constructed as directed by the Engineer.
- The construction exit foundation course shall be flexible base, bituminous concrete, portland cement concrete or other materials approved by the Engineer.
- The construction exit shall be graded to allow drainage to a sediment trapping device.
- The guidelines shown hereon are suggestions only and may be modified by the Engineer.
- Construct exits with a width of at least 14 ft. for one-way and 20 ft. for two-way traffic for the full width of the exit, or as directed by the engineer.

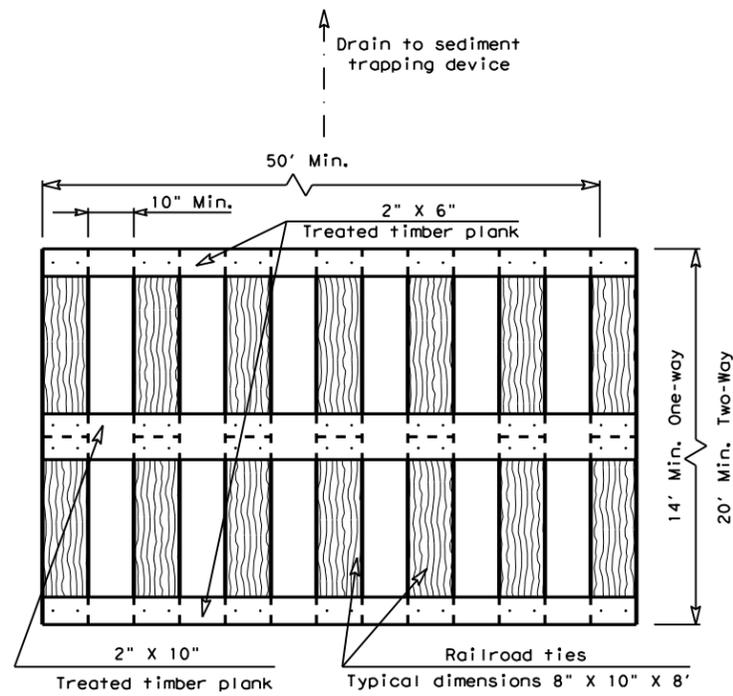

PLAN VIEW

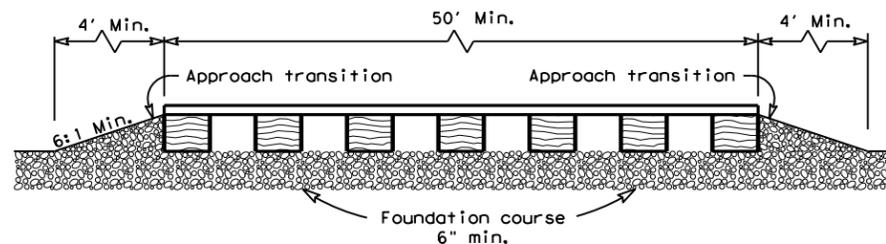


ELEVATION VIEW


CONSTRUCTION EXIT (TYPE 2)  
 TIMBER CONSTRUCTION (LONG TERM)

GENERAL NOTES (TYPE 2)

- The length of the type 2 construction exit shall be as indicated on the plans, but not less than 50'.
- The treated timber planks shall be attached to the railroad ties with 1/2" x 6" min. lag bolts. Other fasteners may be used as approved by the Engineer.
- The treated timber planks shall be #2 grade min., and should be free from large and loose knots.
- The approach transitions shall be no steeper than 6:1 and constructed as directed by the Engineer.
- The construction exit foundation course shall be flexible base, bituminous concrete, portland cement concrete or other material as approved by the Engineer.
- The construction exit should be graded to allow drainage to a sediment trapping device.
- The guidelines shown hereon are suggestions only and may be modified by the Engineer.
- Construct exits with a width of at least 14 ft. for one-way and 20 ft. for two-way traffic for the full width of the exit, or as directed by the engineer.

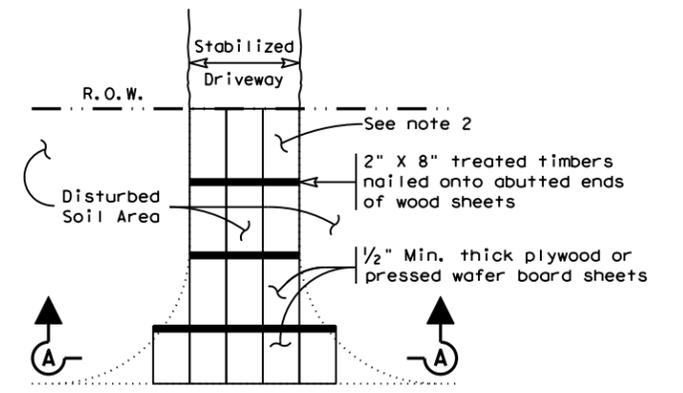

PLAN VIEW

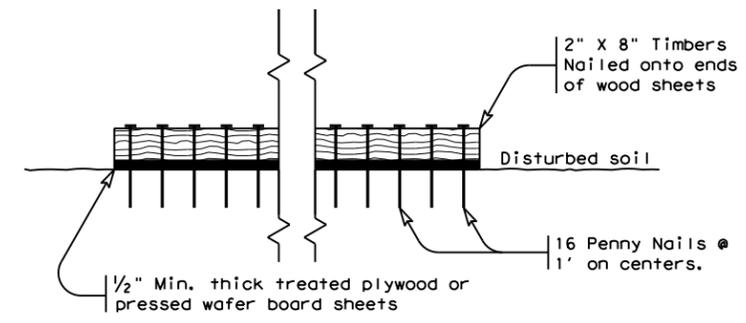

SECTION A-A  
 CONSTRUCTION EXIT (TYPE 3)  
 SHORT TERM


GENERAL NOTES (TYPE 3)

- The length of the type 3 construction exit shall be as shown on the plans, or as directed by the Engineer.
- The type 3 construction exit may be constructed from open graded crushed stone with a size of two to four inches spread a min. of 4" thick to the limits shown on the plans.
- The treated timber planks shall be #2 grade min., and should be free from large and loose knots.
- The guidelines shown hereon are suggestions only and may be modified by the Engineer.


		Design Division Standard	
<b>TEMPORARY EROSION, SEDIMENT AND WATER POLLUTION CONTROL MEASURES CONSTRUCTION EXITS EC(3)-16</b>			
FILE: ec316	DN: TxDOT	CK: KM	DW: VP
© TxDOT: JULY 2016	CONT	SECT	JOB
REVISIONS	0092	14	104
	DIST	COUNTY	SHEET NO.
	18	DALLAS	50

DISCLAIMER: The use of this standard is governed by the "Texas Engineering Practice Act". No warranty of any kind is made by TxDOT for any purpose whatsoever. TxDOT assumes no responsibility for the conversion of this standard to other formats or for incorrect results or damages resulting from its use.

DATE: 5/8/2023  
 FILE: c:\t\dot\p\online\t\dot5\solomon\_bayou\d0852788\ec916.dgn

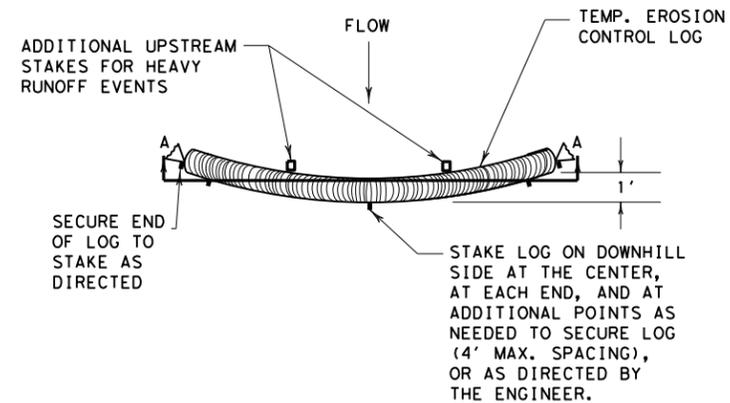


PLAN VIEW

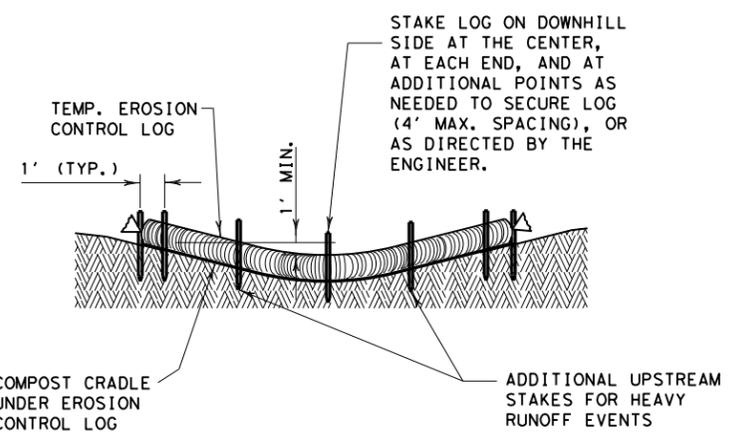


SECTION A-A  
EROSION CONTROL LOG DAM

CL-D

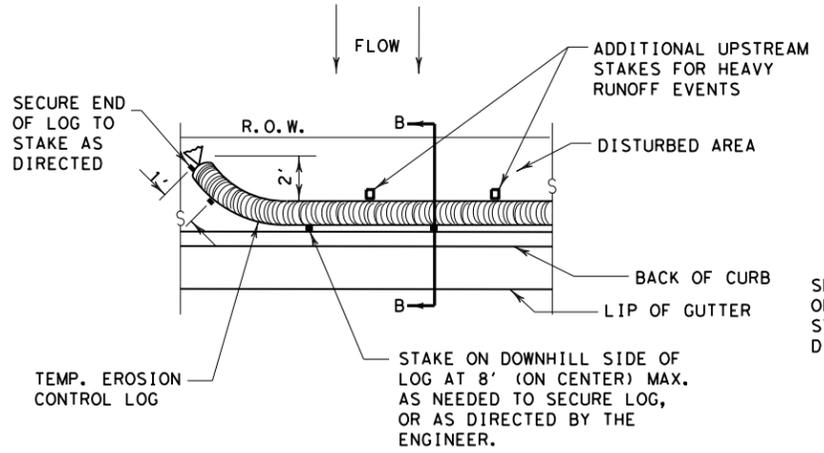


PLAN VIEW

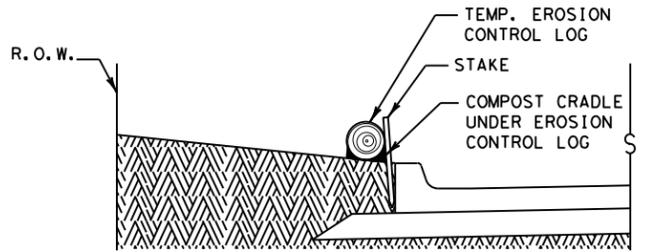


SECTION B-B  
EROSION CONTROL LOG AT BACK OF CURB

CL-BOC

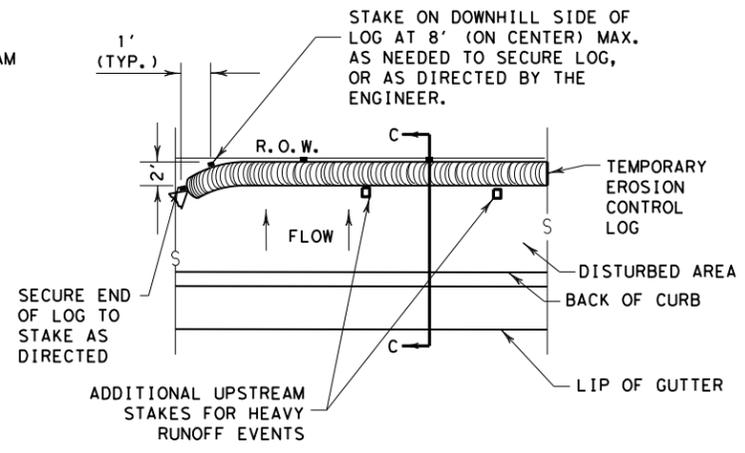


PLAN VIEW

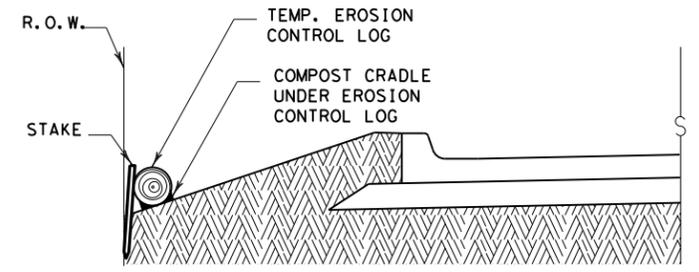

SECTION C-C


EROSION CONTROL LOG AT EDGE OF RIGHT-OF-WAY

CL-ROW

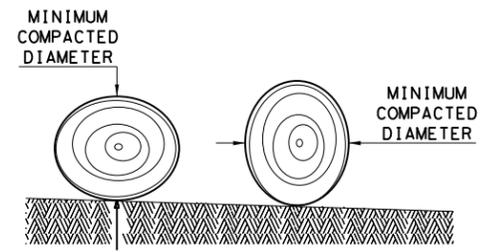

DIAMETER MEASUREMENTS OF EROSION CONTROL LOGS SPECIFIED IN PLANS

- LEGEND**
- CL-D EROSION CONTROL LOG DAM
  - CL-BOC EROSION CONTROL LOG AT BACK OF CURB
  - CL-ROW EROSION CONTROL LOG AT EDGE OF RIGHT-OF-WAY
  - CL-SST EROSION CONTROL LOGS ON SLOPES STAKE AND TRENCHING ANCHORING
  - CL-SSL EROSION CONTROL LOGS ON SLOPES STAKE AND LASHING ANCHORING
  - CL-DI EROSION CONTROL LOG AT DROP INLET
  - CL-CI EROSION CONTROL LOG AT CURB INLET
  - CL-GI EROSION CONTROL LOG AT CURB & GRATE INLET

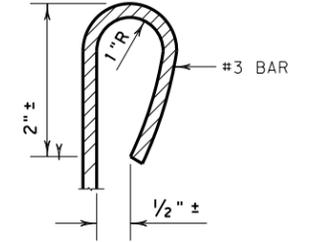

REBAR STAKE DETAIL

**SEDIMENT BASIN & TRAP USAGE GUIDELINES**

An erosion control log sediment trap may be used to filter sediment out of runoff draining from an unstabilized area.

**Log Traps:** The drainage area for a sediment trap should not exceed 5 acres. The trap capacity should be 1800 CF/Acre (0.5" over the drainage area).

Control logs should be placed in the following locations:

1. Within drainage ditches spaced as needed or min. 500' on center
2. Immediately preceding ditch inlets or drain inlets
3. Just before the drainage enters a water course
4. Just before the drainage leaves the right of way
5. Just before the drainage leaves the construction limits where drainage flows away from the project.

The logs should be cleaned when the sediment has accumulated to a depth of 1/2 the log diameter.

Cleaning and removal of accumulated sediment deposits is incidental and will not be paid for separately.

**GENERAL NOTES:**


1. EROSION CONTROL LOGS SHALL BE INSTALLED IN ACCORDANCE WITH MANUFACTURER'S RECOMMENDATIONS, OR AS DIRECTED BY THE ENGINEER.
2. LENGTHS OF EROSION CONTROL LOGS SHALL BE IN ACCORDANCE WITH MANUFACTURER'S RECOMMENDATIONS AND AS REQUIRED FOR THE PURPOSE INTENDED.
3. UNLESS OTHERWISE DIRECTED, USE BIODEGRADABLE OR PHOTODEGRADABLE CONTAINMENT MESH ONLY WHERE LOG WILL REMAIN IN PLACE AS PART OF A VEGETATIVE SYSTEM. FOR TEMPORARY INSTALLATIONS, USE RECYCLABLE CONTAINMENT MESH.
4. FILL LOGS WITH SUFFICIENT FILTER MATERIAL TO ACHIEVE THE MINIMUM COMPACTED DIAMETER SPECIFIED IN THE PLANS WITHOUT EXCESSIVE DEFORMATION.
5. STAKES SHALL BE 2" X 2" WOOD OR #3 REBAR, 2'-4' LONG, EMBEDDED SUCH THAT 2" PROTRUDES ABOVE LOG, OR AS DIRECTED BY THE ENGINEER.
6. DO NOT PLACE STAKES THROUGH CONTAINMENT MESH.
7. COMPOST CRADLE MATERIAL IS INCIDENTAL & WILL NOT BE PAID FOR SEPARATELY.
8. SANDBAGS USED AS ANCHORS SHALL BE PLACED ON TOP OF LOGS & SHALL BE OF SUFFICIENT SIZE TO HOLD LOGS IN PLACE.
9. TURN THE ENDS OF EACH ROW OF LOGS UPSLOPE TO PREVENT RUNOFF FROM FLOWING AROUND THE LOG.
10. FOR HEAVY RUNOFF EVENTS, ADDITIONAL UPSTREAM STAKES MAY BE NECESSARY TO KEEP LOG FROM FOLDING IN ON ITSELF.

SHEET 1 OF 3

		Design Division Standard	
<b>TEMPORARY EROSION, SEDIMENT AND WATER POLLUTION CONTROL MEASURES</b> <b>EROSION CONTROL LOG</b> <b>EC (9) - 16</b>			
FILE: ec916	DN: TxDOT	CK: KM	DW: LS/PT
© TxDOT: JULY 2016	CONT	SECT	JOB
REVISIONS	0092	14	104
	DIST	COUNTY	SHEET NO.
	18	DALLAS	51


DISCLAIMER: The use of this standard is governed by the "Texas Engineering Practice Act". No warranty of any kind is made by TxDOT for any purpose whatsoever. TxDOT assumes no responsibility for the conversion of this standard to other formats or for incorrect results or damages resulting from its use.

DATE: 5/8/2023  
 FILE: c:\txdot\pw\_online\txdot5\olomon\_bayou\d0852788\ec916.dgn

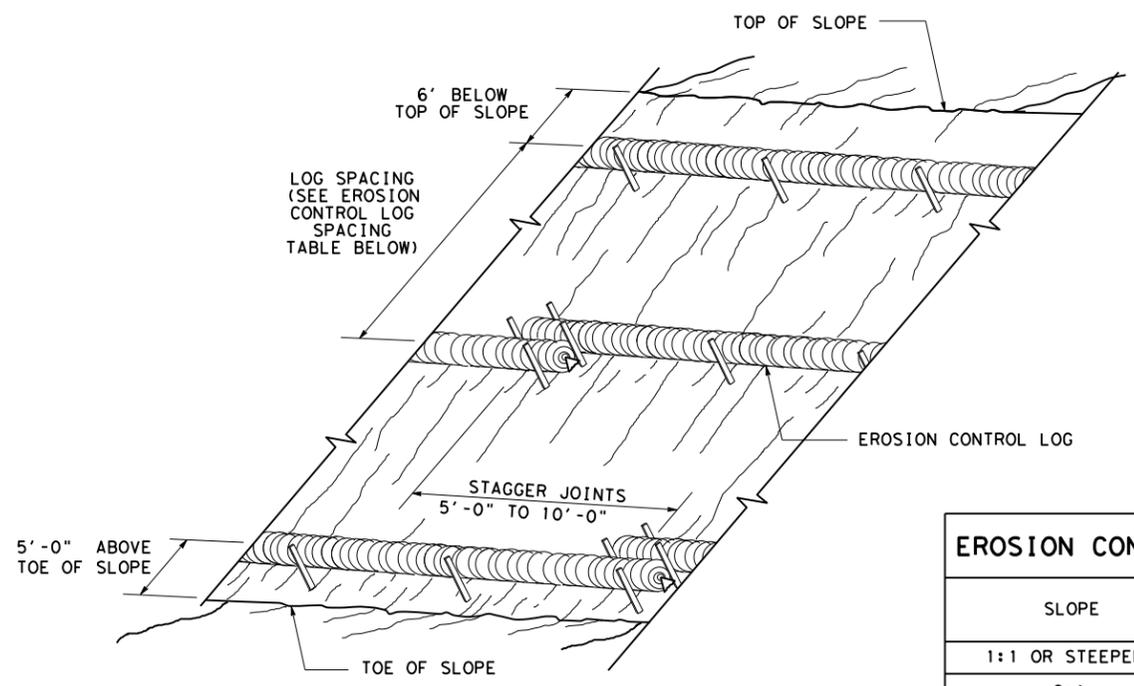

**EROSION CONTROL LOGS ON SLOPES  
STAKE AND TRENCHING ANCHORING**


CL-SST

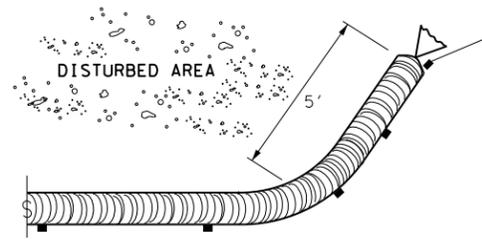

**END SECTION RAP DETAIL**


SLOPE	LOG DIAMETER			
	6"	8"	12"	18"
1:1 OR STEEPER	5'	10'	15'	20'
2:1	10'	20'	30'	40'
3:1	15'	30'	45'	60'
4:1 OR FLATTER	20'	40'	60'	80'

\* ADJUSTMENTS CAN BE MADE FOR SOIL TYPE:  
 SOFT, LOAMY SOILS-ADJUST ROWS CLOSER TOGETHER;  
 HARD, ROCKY SOILS- ADJUST ROWS FARTHER APART

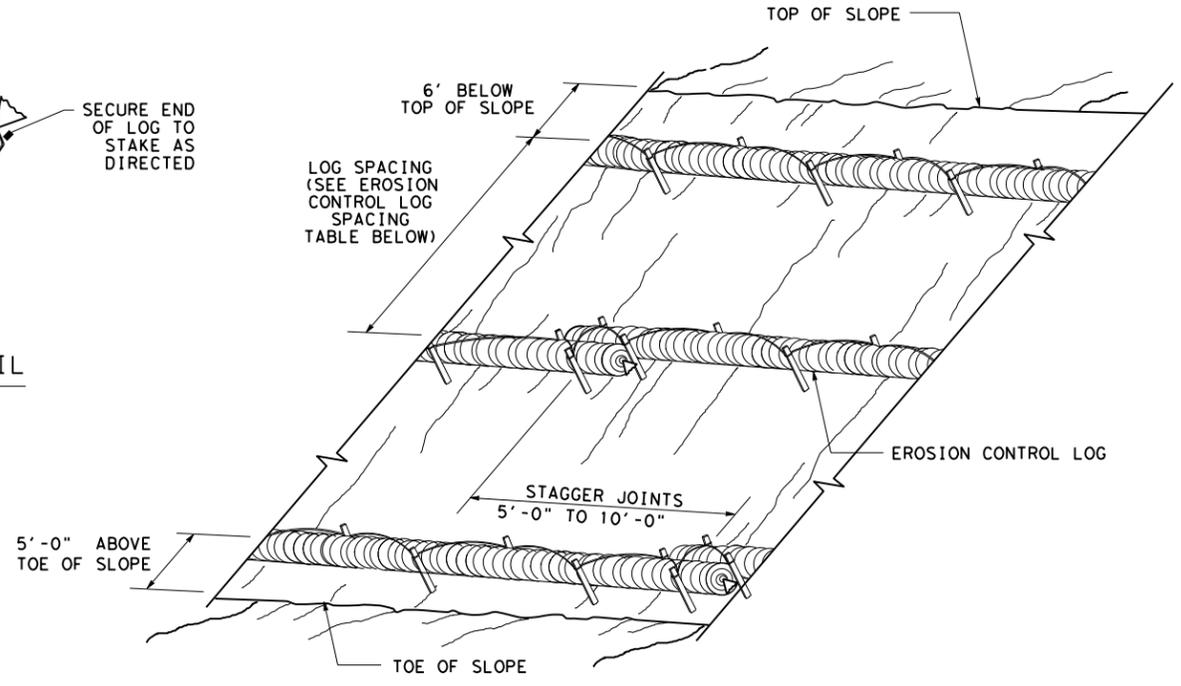


**EROSION CONTROL LOGS ON SLOPES  
STAKE AND LASHING ANCHORING**

CL-SSL

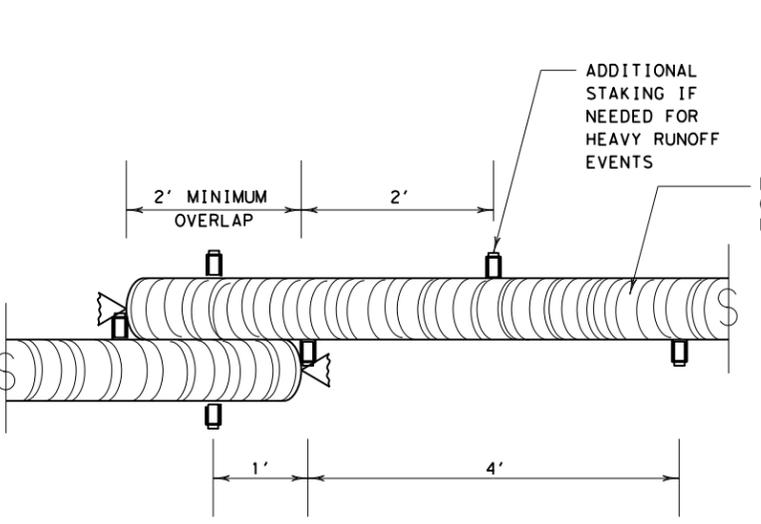

**STAKE AND TRENCHING ANCHORING DETAIL**


CL-SST

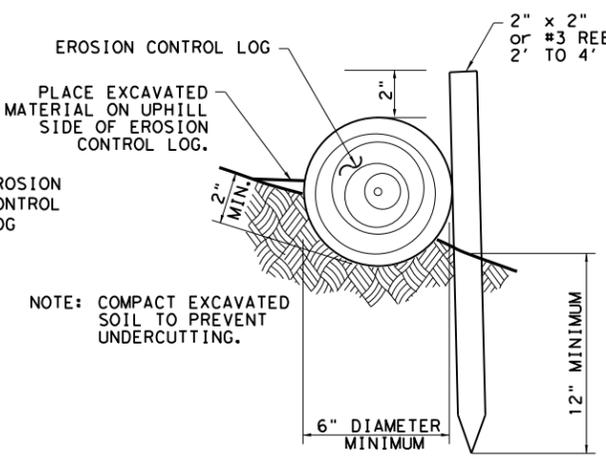


**STAKE AND LASHING ANCHORING DETAIL**

CL-SSL

LOG DIAMETER	DEPTH
6"	2"
8"	3"
12"	4"
18"	5"

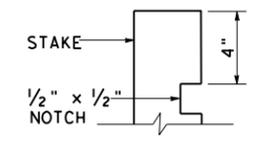

**STAKE NOTCH DETAIL**

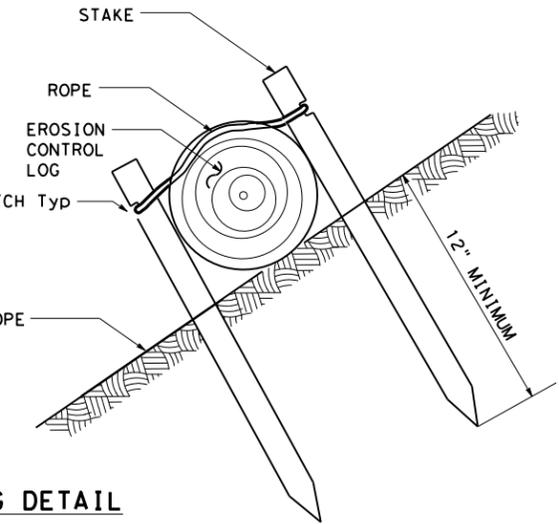


SHEET 2 OF 3

		Design Division Standard	
<b>TEMPORARY EROSION,          SEDIMENT AND WATER          POLLUTION CONTROL MEASURES          EROSION CONTROL LOG          EC (9) - 16</b>			
FILE: ec116	DN: TxDOT	CK: KM	DW: LS/PT
© TxDOT: JULY 2016	CONT SECT	JOB	HIGHWAY
REVISIONS	0092 14	104	IH 45
DIST	COUNTY	SHEET NO.	
18	DALLAS	52	


DISCLAIMER: The use of this standard is governed by the "Texas Engineering Practice Act". No warranty of any kind is made by TxDOT for any purpose whatsoever. TxDOT assumes no responsibility for the conversion of this standard to other formats or for incorrect results or damages resulting from its use.

DATE: 5/8/2023  
 FILE: c:\txdot\pw\_online\txdot5\solomon\_bayou\d0852788\ec916.dgn

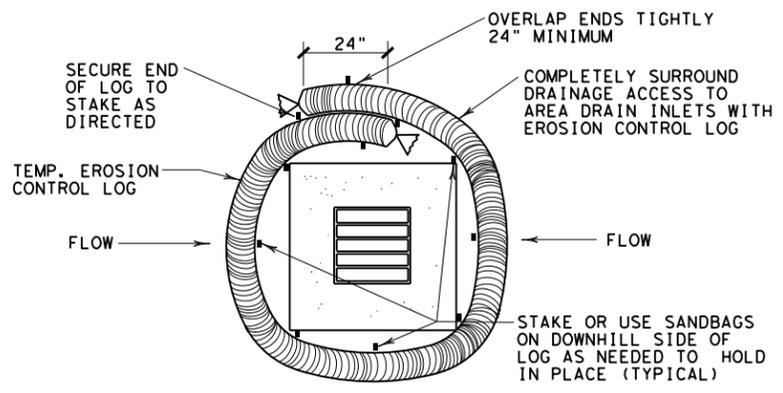


**EROSION CONTROL LOG AT DROP INLET**

CL-DI

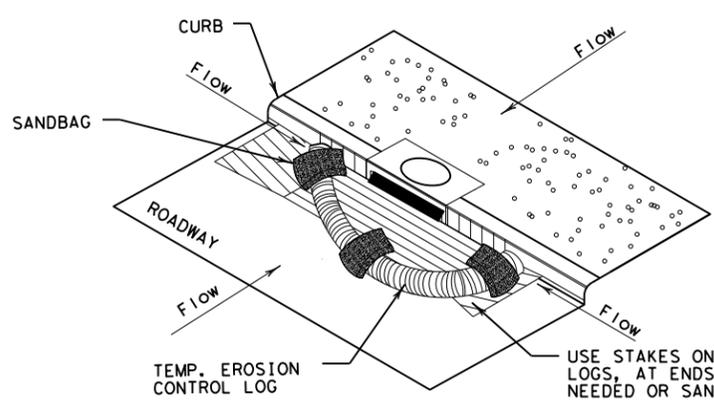

**EROSION CONTROL LOG AT CURB INLET**


CL-CI

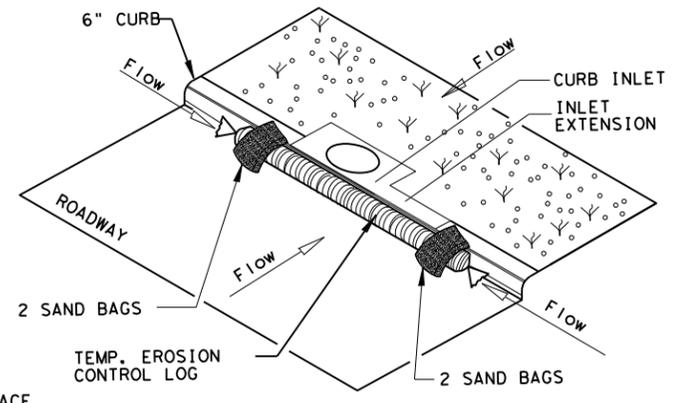

**EROSION CONTROL LOG AT CURB INLET**


CL-CI

NOTE:  
 EROSION CONTROL LOGS USED AT CURB INLETS SHOULD ONLY BE USED IF THEY WILL NOT IMPEDE TRAFFIC OR FLOOD THE ROADWAY OR WHEN THE STORM SEWER SYSTEM IS NOT FULLY FUNCTIONAL.

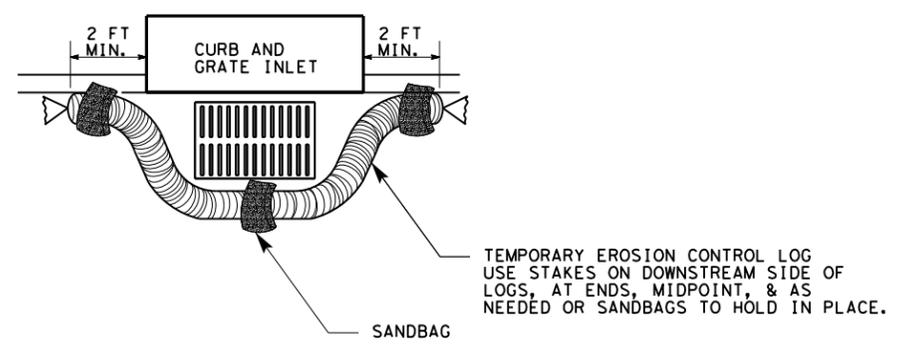

**EROSION CONTROL LOG AT CURB & GRADE INLET**

CL-GI

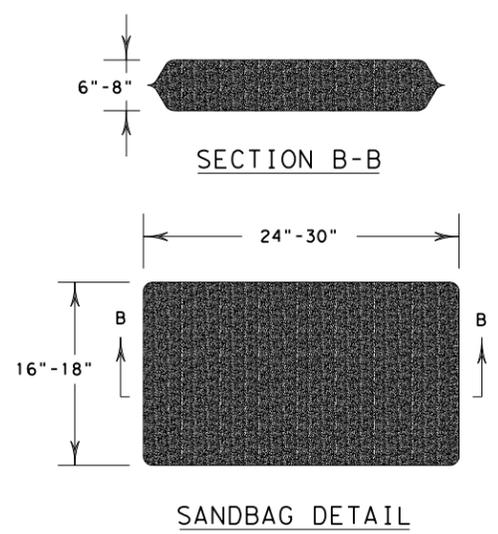

SHEET 3 OF 3

		<i>Design Division Standard</i>	
<b>TEMPORARY EROSION, SEDIMENT AND WATER POLLUTION CONTROL MEASURES</b> <b>EROSION CONTROL LOG</b> <b>EC (9) - 16</b>			
FILE: ec916	DN: TxDOT	CK: KM	DW: LS/PT
© TxDOT: JULY 2016	CONT	SECT	JOB
REVISIONS	0092	14	104
	DIST	COUNTY	SHEET NO.
	18	DALLAS	53

USER ID

**SURFACE PREPARATION** ITEM 160\* TOPSOIL SY / ITEM 161\* COMPOST MANUF. TOPSOIL (BOS) (4") SY

**SURFACE PREPARATION**

Prepare planting area surface BEFORE placing Topsoil, Compost, Fertilizer, Seed and/or Sod. Once project area has been completed to final lines, grade and compaction, remove objectionable materials from planting area surface and cultivate existing surface to a depth of 4 inches, unless otherwise specified or directed.

Refer to Items 160 and 161 of TxDOT 2014 Standard Specifications\* for specifications, dimensions, volumes, and measurements that have been modified or not shown in plans. Materials and construction shall meet all specifications.

**TOPSOIL NOTES:**

- When Topsoil is specified under Item 160, use suitable material salvaged from the project ROW in accordance with Item 160 specifications, and/or secure additional good material from approved sources.
- Topsoil shall include only the top 6 inches of its native surface, and be easily cultivated, fertile, erosion-resistant and free of objectionable materials.
- Topsoil obtained from sites outside of the ROW must come from approved sources and have a pH between 5.5 and 8.5 su.
- Place Topsoil on pre-cultivated surface, spread to a uniform loose cover at thickness specified, and shape per plans. Water and roll the finished surface with a light roller or other suitable equipment per Item 160.3; do not over-compact.

**COMPOST NOTES:**

- When Compost Manufactured Topsoil (4") is specified under Item 161, use compost meeting all requirements of Item 161.2 and Table 1. Provide quality control (QC) documentation and obtain Engineer approval prior to compost delivery.
- Contractor shall provide tickets/invoices that document material type, quantity and placement for all compost delivered.
- Additional topsoil may be required to be imported to achieve the compost/topsoil mix ratio. Topsoil must meet Item 160 specifications.

**APPLICATION OF COMPOST MANUFACTURED TOPSOIL (4")**

AFTER Surface Preparation, uniformly spread a 1-inch layer of compost on-grade with 3 inches topsoil over pre-cultivated planting area. (25% compost and 75% topsoil = 1" compost and 3" topsoil.) Then mix compost and topsoil together by cultivating the compost into the topsoil (by till or disk) to a 4-inch (4") depth. Roll the finished surface with a light corrugated drum; do not over-compact.

**FERTILIZER** ITEM 166\* FERTILIZER AC

**SOIL ANALYSIS FOR FERTILIZER APPLICATION RATE**

Unless otherwise stated in the plans, Contractor shall perform at least one soil analysis on each project before fertilization, and submit results to Engineer with recommended fertilizer rates based on soil analysis. Engineer may direct sample location(s). Soil analysis may be waived if both compost and sod are used on entire project.

**FERTILIZER NOTES:**

- Refer to Item 166 of TxDOT 2014 Standard Specifications\* for specifications, dimensions, volumes, and measurements that have been modified or not shown in plans. Materials and construction shall meet all specifications.
- Apply fertilizer BEFORE seeding, or AFTER placing sod.
- Use fertilizer containing nitrogen (N), phosphoric acid (P) and potash (K) nutrients, unless otherwise specified. At least 50% of the Nitrogen component shall be a slow-release sulfur-coated urea as described in Item 166.3. Do not apply more than 60 lbs Nitrogen per acre without Engineer concurrence.
- Deliver fertilizer in bags, clearly labeled to show contents, unless otherwise specified or approved prior to delivery. When non-bagged, loose fertilizer is approved, provide documentation for each load of material delivered, to validate authenticity of the material.
- Apply fertilizer uniformly, as a dry, granular material, essentially dust-free, and do not mix with water for application as a slurry.
- When both temporary and permanent seeding are specified for the same area, apply half of the required fertilizer before the temporary seeding operation and the other half before the permanent seeding operation.

**SEEDING FOR EROSION CONTROL** ITEM 164\* DRILL SEEDING AC

RECOMMENDED PLANTING SEASON	PERMANENT RURAL SEED MIX ITEM 164 - DRILL SEEDING (PERM) (RURAL) (CLAY)	PERMANENT URBAN SEED MIX ITEM 164 - DRILL SEEDING (PERM) (URBAN) (CLAY)	TEMPORARY DRILL SEED MIX ITEM 164 - DRILL SEEDING (TEMP) (WARM OR COOL)
<b>WARM SEASON</b> Mar. 15th, April, May, June, July, August, Sept. 15th	Green Sprangletop (Van Horn) - 1.0 lbs/AC Sideoats Grama (Haskell) - 1.0 lbs/AC Texas Grama (Atascosa) - 1.0 lbs/AC Hairy Grama (Chaparral) - 0.4 lbs/AC Shortspike Windmillgrass (Welder) - 0.2 lbs/AC Little Bluestem (OK Select) - 0.8 lbs/AC Purple Prairie Clover (Cuero) - 0.6 lbs/AC Engelmann Daisy (Eldorado) - 0.75 lbs/AC Illinois Bundlesflower - 1.3 lbs/AC Awnless Bushsunflower (Plateau) - 0.2 lbs/AC	Green Sprangletop (Leptochloa dubia) - 0.3 lbs/AC Sideoats Grama (El Reno) (Bouteloua curtipendula) - 3.6 lbs/AC Buffalograss (Texoka) (Buchloe dactyloides) - 1.6 lbs/AC Bermudagrass (Cynodon dactylon) - 2.4 lbs/AC	Foxtail Millet (Setaria italica) - 34 lbs/AC
<b>COOL SEASON</b> Sept 16th, Oct, Nov, Dec, Jan, Feb, Mar 14th			Pure Live Seed Rate** Tall Fescue (Festuca arundinaceae) - 4.5 lbs/AC Western Wheatgrass (Agropyron smithii) - 5.6 lbs/AC Red Winter Wheat (Triticum aestivum) - 34 lbs/AC Cereal Rye - 34 lbs/AC

**SEEDING NOTES:**

- When seeding is specified under Item 164, refer to TxDOT 2014 Standard Specifications\* for specifications, dimensions, volumes, and measurements that have been modified or not shown. Materials and construction shall meet specifications.
- Conduct seeding upon completion of each applicable construction stage (dependent upon planting season requirements), without compensation for additional move-ins.
- Place seed AFTER preparing planting area surface. Refer to Surface Preparation detail in this sheet, as well as Topsoil Item 160 and Compost Manufactured Topsoil Item 161 when specified. Apply fertilizer per Item 166 BEFORE seeding, per specifications and this sheet, to help drill the fertilizer into the soil.
- When temporary grasses are well-established and more than 2 inches tall, mow planting area before seeding permanent grasses; mowing for this purpose will be subsidiary. When vegetation is not already well-established, cultivate planting area to a depth as described in Item 164.3, before temporary seeding and before permanent seeding.
- Seed material must be appropriate to the location, soil type and season. Use the seed mix species and pure live seed rates designated in Tables 1-4 of the TxDOT 2014 Standard Specifications\* for Item 164, unless otherwise specified.
- All seed shall meet labeling, delivery, analysis, and testing requirements described in Item 164.2.1. Deliver seed in labeled, unopened bags or containers to Engineer prior to planting.
- Uniformly plant seed over the designated planting area, along the contour of slopes, and drill seed to a depth as described in Item 164.3.4.
- Hydroseeding may be allowed, when specified or Engineer concurs.
- Implement and continue Vegetative Watering per the schedule, rate and volume specified under Item 168.

**TXDOT REFERENCE MATERIALS:**

- "STANDARD SPECIFICATIONS FOR CONSTRUCTION AND MAINTENANCE OF HIGHWAYS, STREETS, AND BRIDGES" 2014
- "A GUIDANCE TO ROADSIDE VEGETATION ESTABLISHMENT" 2004
- ONLINE TRAINING COURSE: MNT415 REVEGETATION DURING CONSTRUCTION
- DALLAS DISTRICT "VEGETATION ESTABLISHMENT GUIDELINES"

**SODDING FOR EROSION CONTROL** ITEM 162\* BLOCK SOD (BERMUDA) SY

BLOCK OR ROLL SOD	COMMON NAME	BOTANICAL NAME
	Common Bermuda Grass	Cynodon dactylon

**SODDING NOTES:**

- Refer to Item 162 of TxDOT 2014 Standard Specifications\* for specifications, dimensions, volumes, and measurements that have been modified or not shown in plans. Materials and construction shall meet all specifications.
- Place sod between the average date of the last freeze in the Spring and 6 weeks before the average date of the first freeze in the Fall, per the Texas Almanac for the project area.
- Place sod only AFTER soil surface preparation is complete as detailed in this sheet. Dry soil may require pre-watering.
- Place all sod (blocks or rolls) within 24 hours of delivery to the site, and keep moist from the time it is dug up until it is planted. Sod with dried roots will not be accepted.
- Place sod with joints alternating on each row to prevent all joints from lining up, and place blocks firmly against adjacent blocks. Roll, tamp and trim sod per Item 162.3.
- Place fertilizer promptly AFTER sodding operation is complete in each area.
- Water sod immediately following placement, and continue Vegetative Watering per Item 168.

**VEGETATIVE WATERING FOR ESTABLISHING SEED AND SOD** ITEM 168\* VEGETATIVE WATERING MG

SEASON (Usual Months)	RATE	TIME SCHEDULE	TOTAL WATER ESTIMATE
SPRING & FALL (March, April, May, October)	7,000 gallons/acre per working day	Vegetative watering for seed shall begin on the day after rainfall described below and continue for 60 consecutive working days; vegetative watering for sod shall begin on the day the sod is placed and continue for a minimum of 15 consecutive working days.	420,000 gallons/acre (60 working days)
SUMMER (June, July, August, September)	12,000 gallons/acre per working day		720,000 gallons/acre (60 working days)
WINTER (November through February)	1,000 gallons/acre per working day	Vegetative watering for seed and/or sod shall begin on the day after placement for 15 consecutive working days	15,000 gallons/acre (15 working days)

Notes: Rate and frequency may be adjusted, with the approval of the Engineer, to meet site conditions (especially with sod). For informational purposes only: 1,000 gallons equals 1 MG

**VEGETATIVE WATERING NOTES:**

- Refer to Item 168 of TxDOT 2014 Standard Specifications\* for specifications, dimensions, volumes, and measurements that have been modified or not shown in plans. Materials and construction shall meet all specifications.
- Use clean water free of industrial waste and other substances harmful to vegetation growth, per Item 168.2.
- Use Vegetative Watering to keep the seed bed moist during germination; not to provide initial watering. After drill seeding, postpone watering operations until site receives at least 1/2-inch of natural rainfall in a single day. Delay watering operations for warm season grasses until soil temperature exceeds 70 degrees F.
- For sod, water immediately.
- All water distribution equipment shall be furnished and operated to provide water at a uniform and controllable rate. Use a metering device on all watering equipment.
- Evenly distribute water over entire area designated for seeding and/or sodding, using even spray patterns that do not disturb seed bed and/or dislodge seed from seed bed.
- Do not water between the hours of 12:00 p.m. and 6:00 p.m. when daytime temperatures exceed 95 degrees F.
- After initial establishment period, continue intermittent watering of newly established seed or sod at a rate of approximately 1-inch water/week, during summer months until end of contract.
- If 1/4-inch or more of rainfall occurs on site on any given working day, no vegetative watering will be needed on that working day. (Note: 1/4-inch rain equals 7,000 gallons of water per acre.)
- Should the Contractor fail to apply the specified amount of water within the time allowed, any seed or sod in poor condition shall be replaced, fertilized, and watered at Contractor's expense.

**ROADSIDE MOWING** ITEM 730\* PROJECT MAINTENANCE AC

**MOWING NOTES:**

- During project construction, once seed is established, use mowing to promote permanent grasses by mowing any remaining temporary grasses.
- Also mow established turf and ROW grasses in designated areas of project limits as specified or directed by Engineer.
- Remove litter and debris prior to mowing.
- Do not mow on wet ground when soil rutting can occur.
- Hand-trim around obstructions and stormwater control devices as needed.
- Maintain paved surfaces free of tracked soils and clipped vegetation.

**SEQUENCE OF WORK:**

- CULTIVATE SURFACE SOIL.
- PREPARE / PLACE TOPSOIL, OR
- PREPARE / PLACE COMPOST MANUFACTURED TOPSOIL.
- APPLY FERTILIZER AND THEN PLACE SEEDING, OR
- PLACE SOD AND THEN APPLY FERTILIZER.
- CONDUCT VEGETATIVE WATERING.
- CONDUCT ROADSIDE MOWING, AS DIRECTED.



**VEGETATION ESTABLISHMENT SHEET**  
(DALLAS DISTRICT)

TEMPLATE REVISION DATE: 02/21/19

DESIGN CPB	FED. RD. DIV. NO. 6	PROJECT NO. (See Title Sheet)		HIGHWAY NO. IH 45
GRAPHICS XXX	STATE	DISTRICT	COUNTY	SHEET NO.
CHECK XXX	TEXAS	DALLAS	DALLAS	54
CHECK XXX	CONTROL	SECTION	JOB	
	0092	14	104	

DATE

